


--

 **mace**

*Mace Group
Newminster House
27-29 Baldwin Street
Bristol
BS1 1LT*

Telephone 01179 549 870
www.macegroup.com

PROJECT <i>Dairy Condensing Unit London Road Campus, University of Reading</i>		
DRAWING TITLE <i>Ground Floor Plan - As existing</i>		
STAGE	Feasibility	
DRAWN BY	CW	DATE 20.07.2023
CHECKED	TD	SCALE 1:200@A3
PROJECT No.	SEQ. No.	REV.
2000007259	001	-

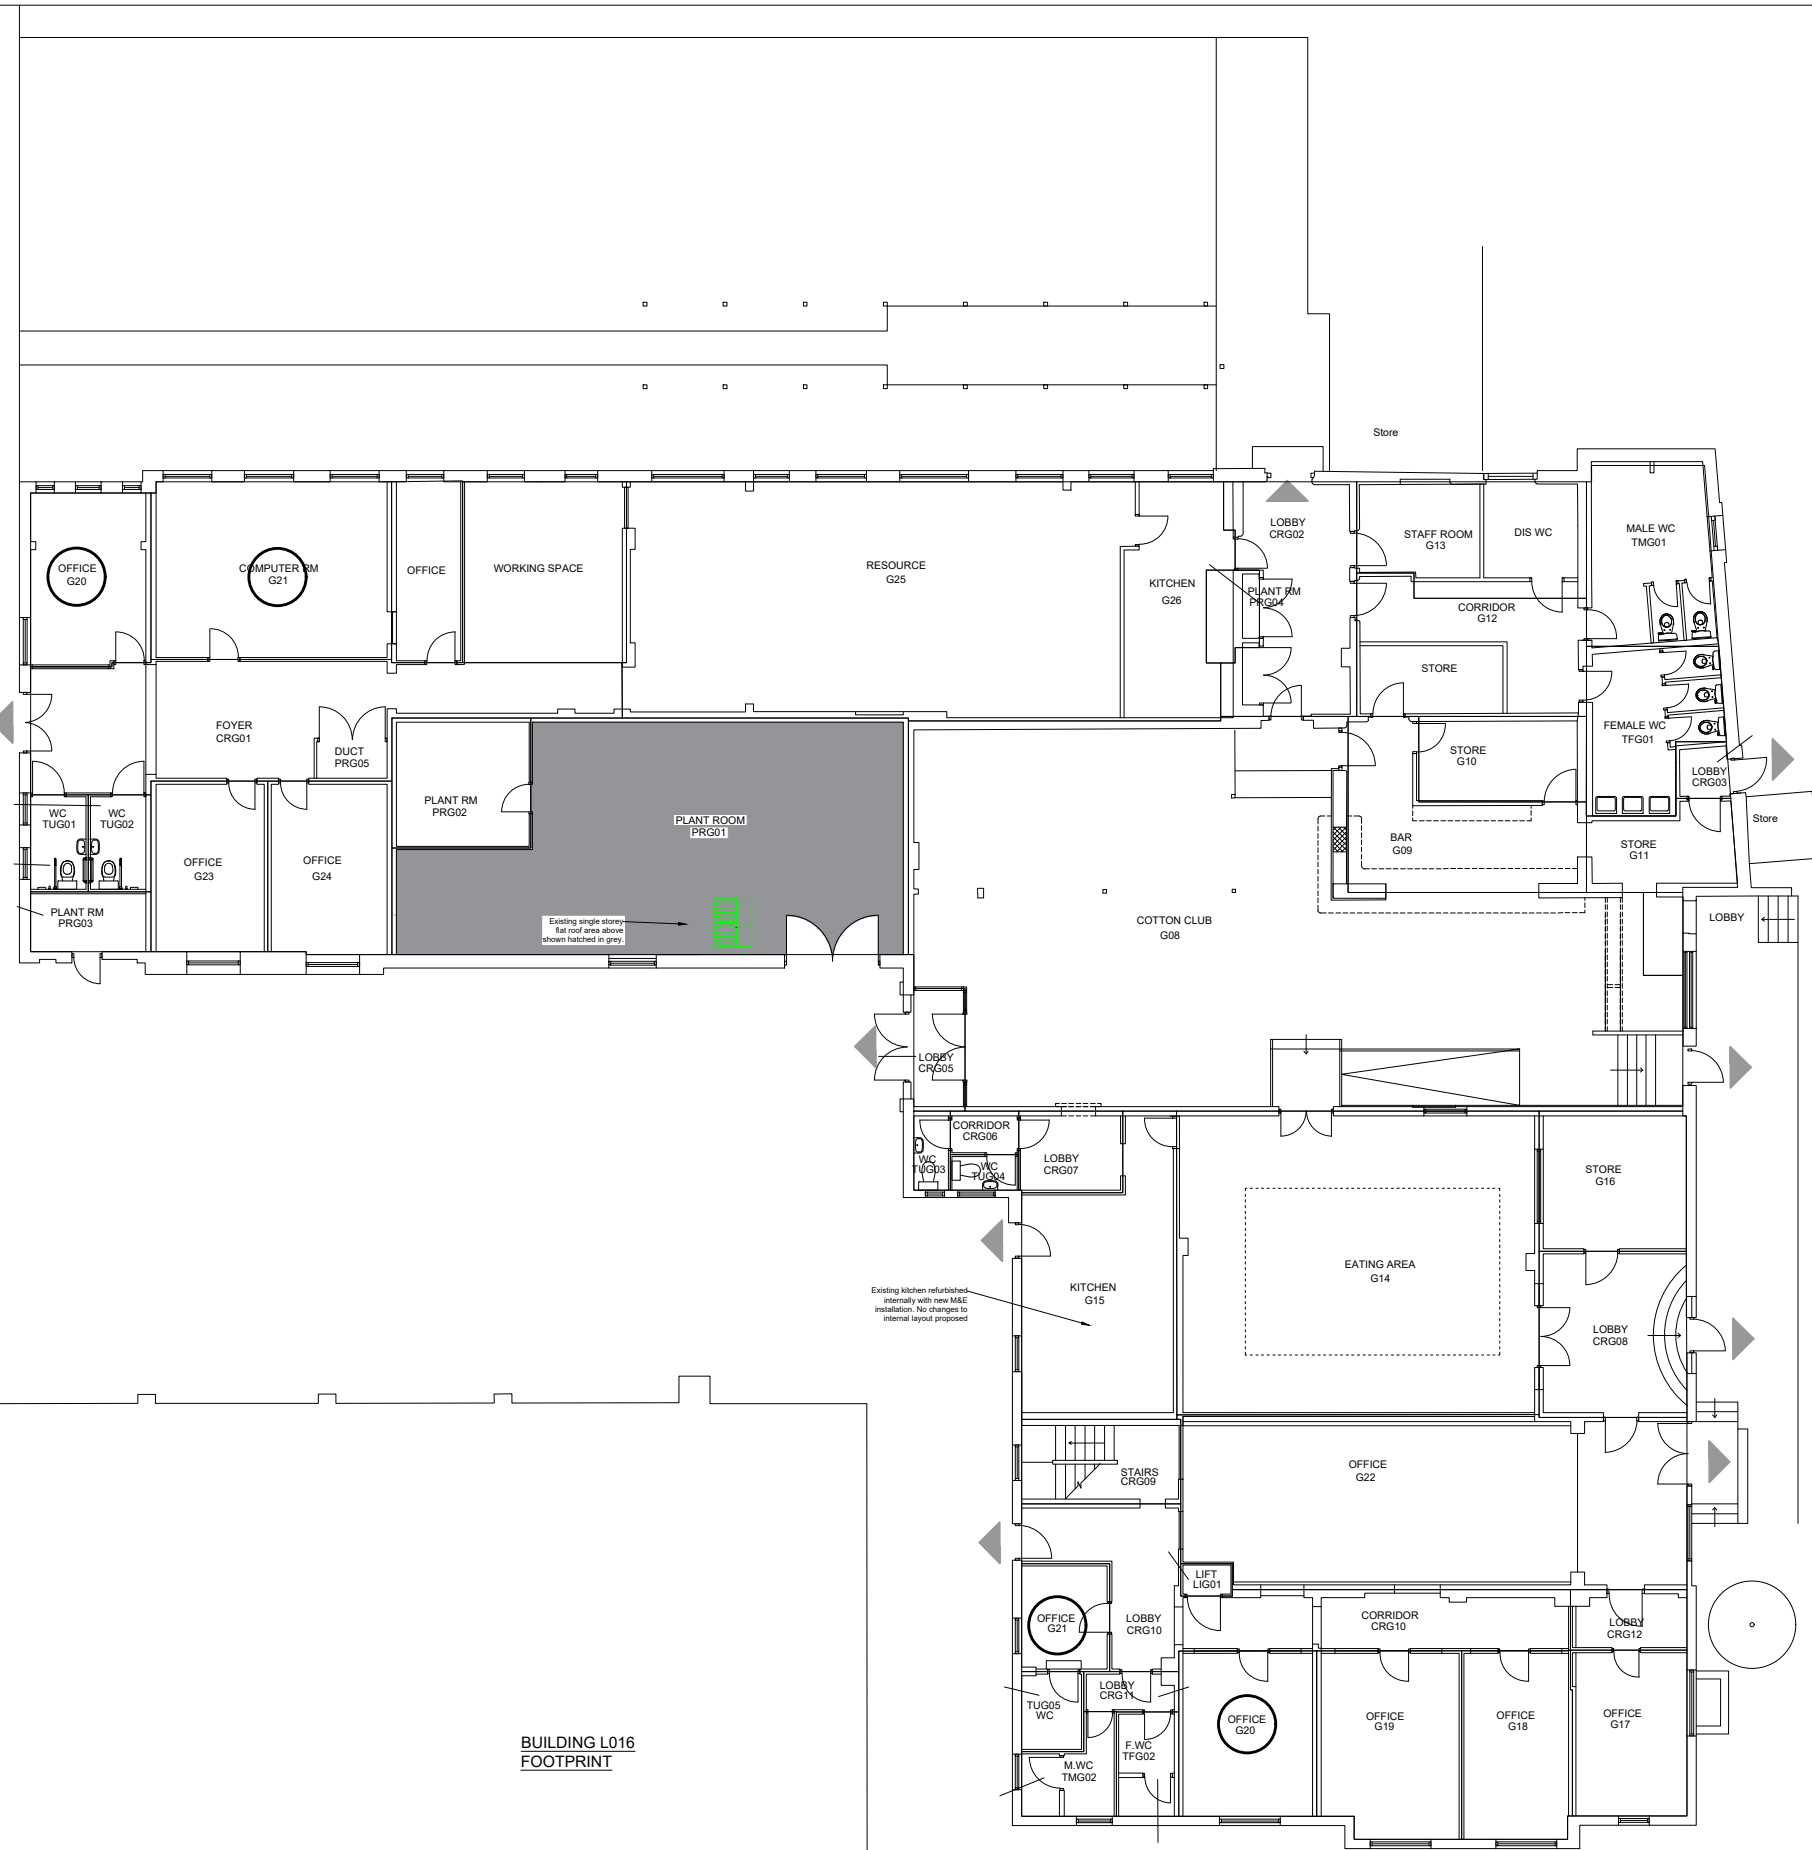

Existing Ground Floor Plan

Scale 1:200 @ A3

