




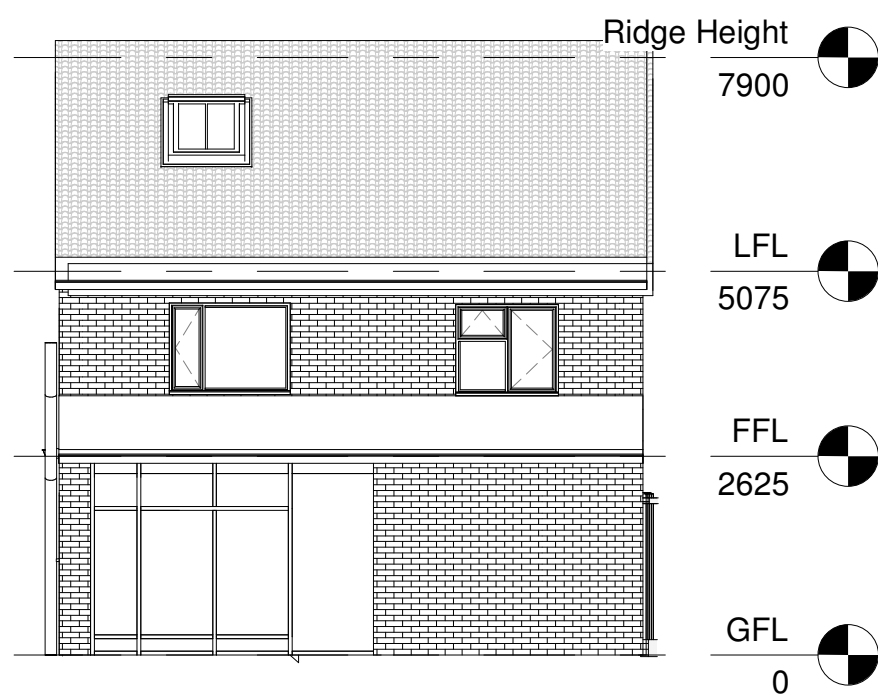

Front Elevation (1:100)

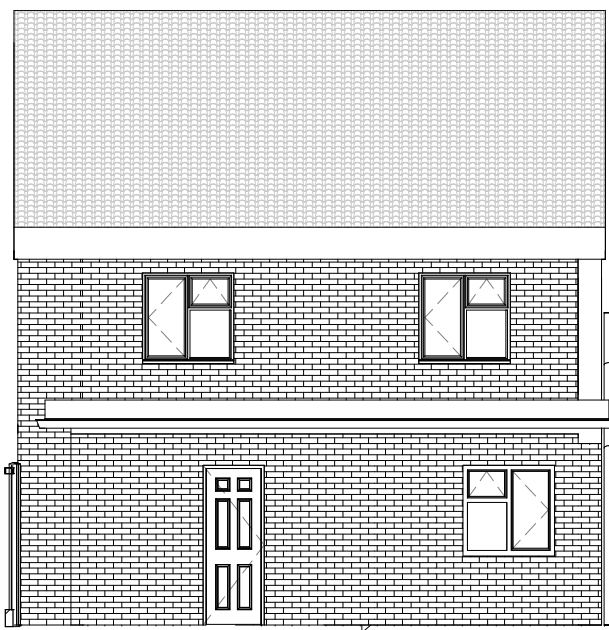


Rear Elevation (1:100)

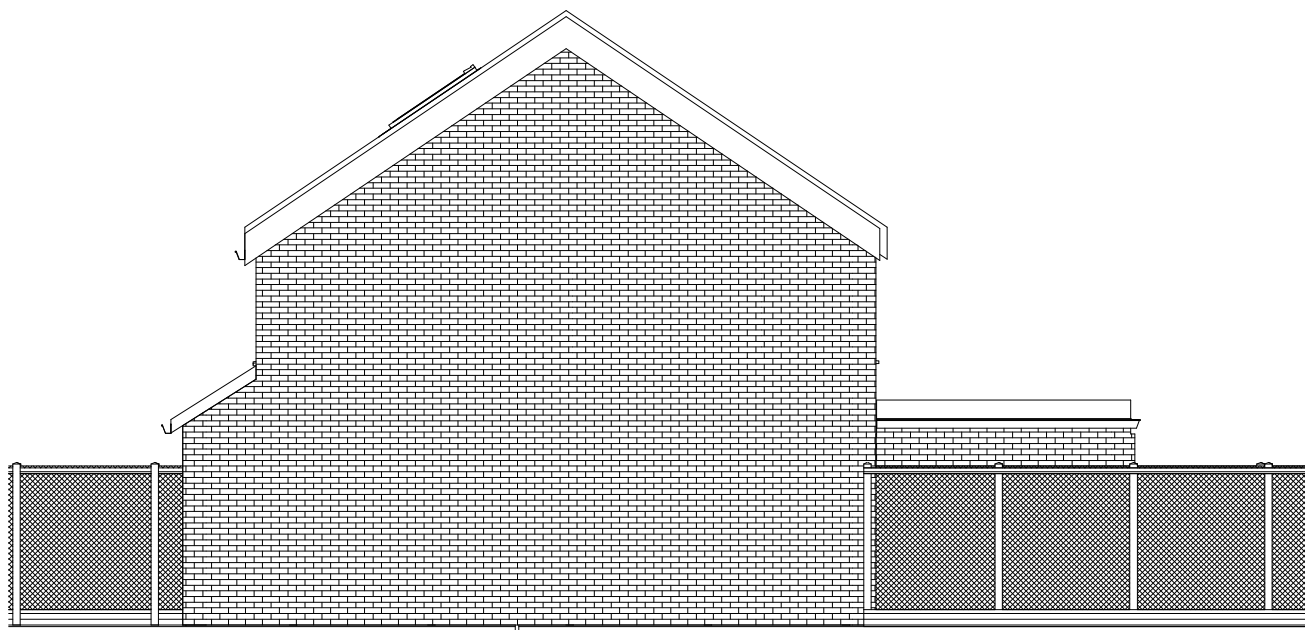



Side Elevation (1:100)




Side Elevation (1:100)

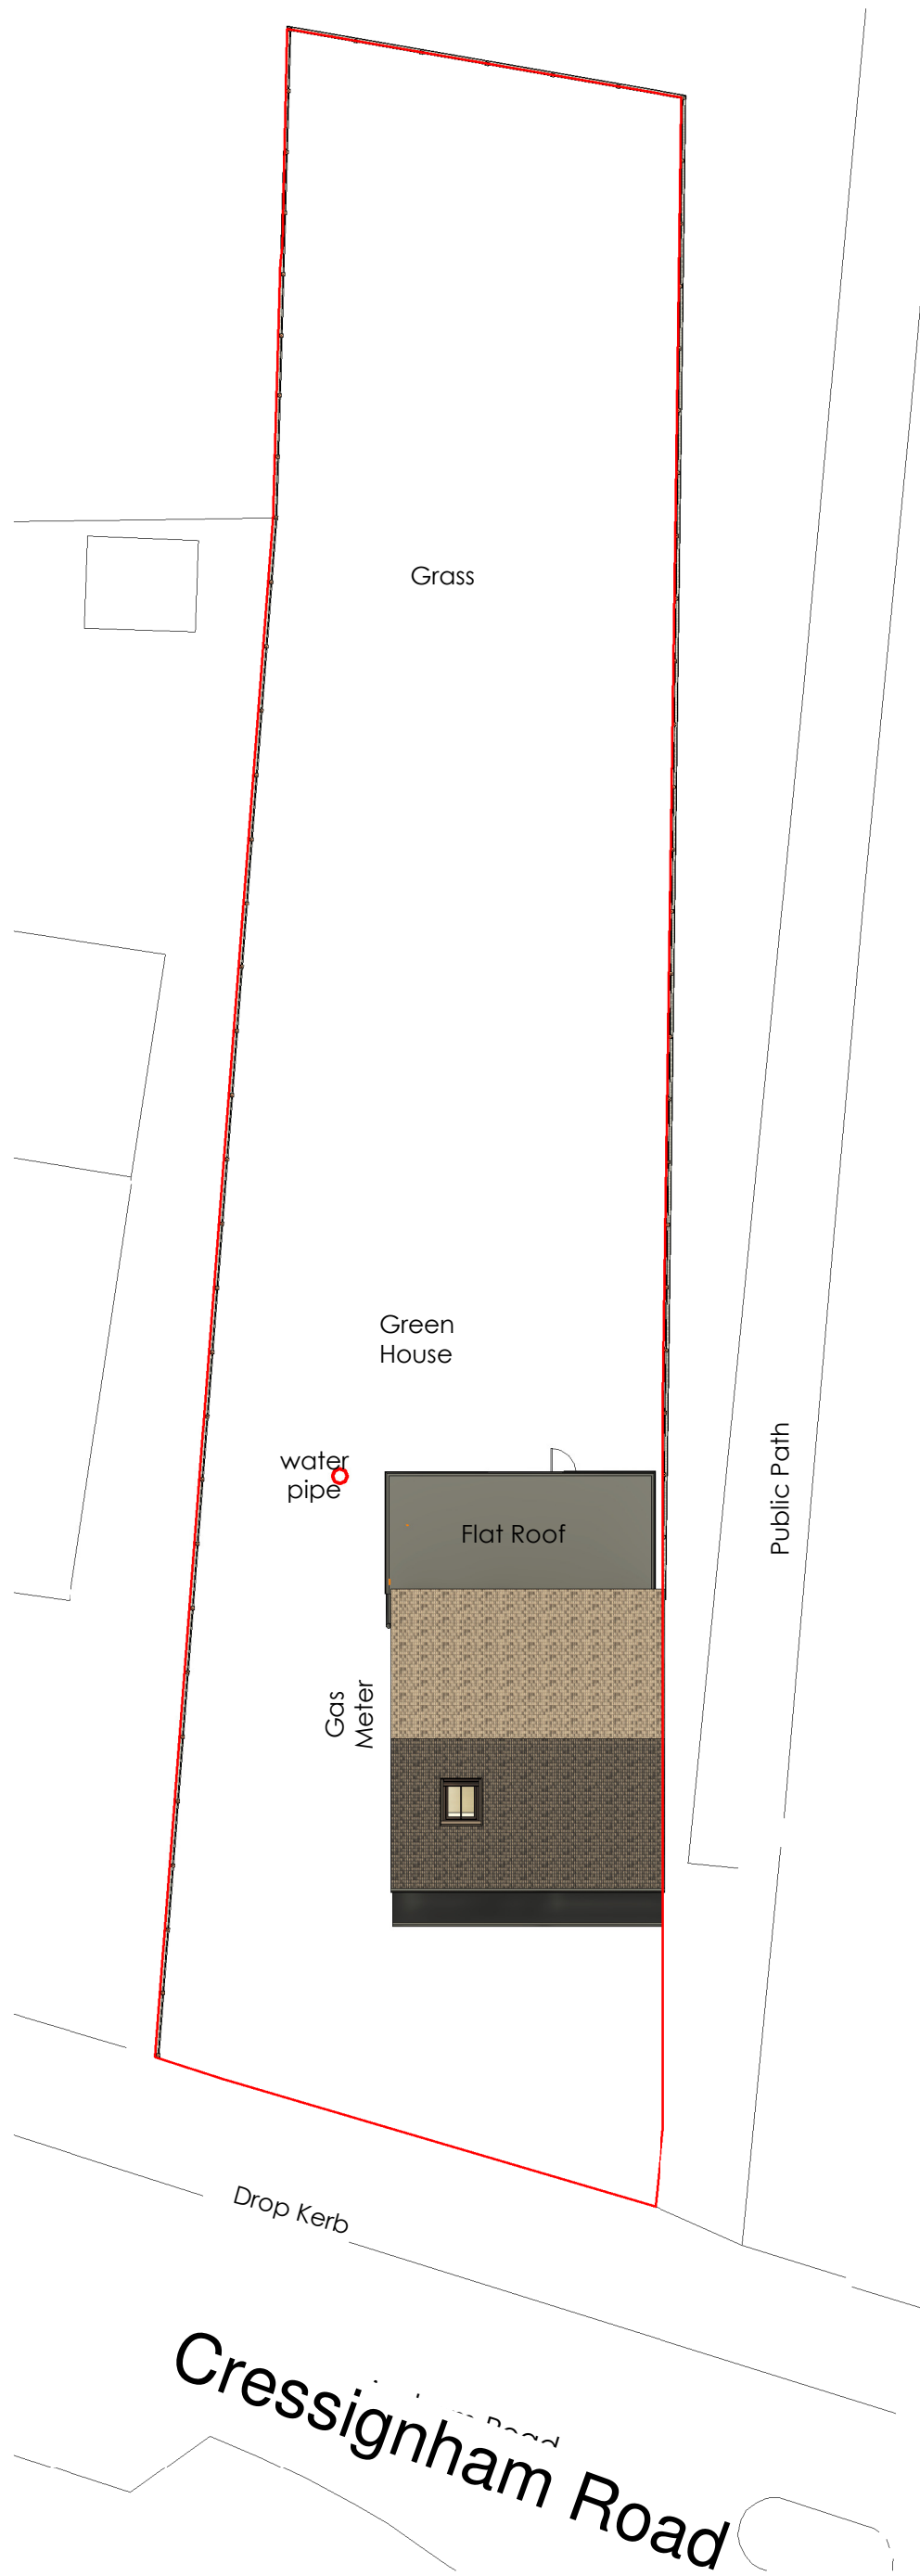


Existing Block Plan (1:200)

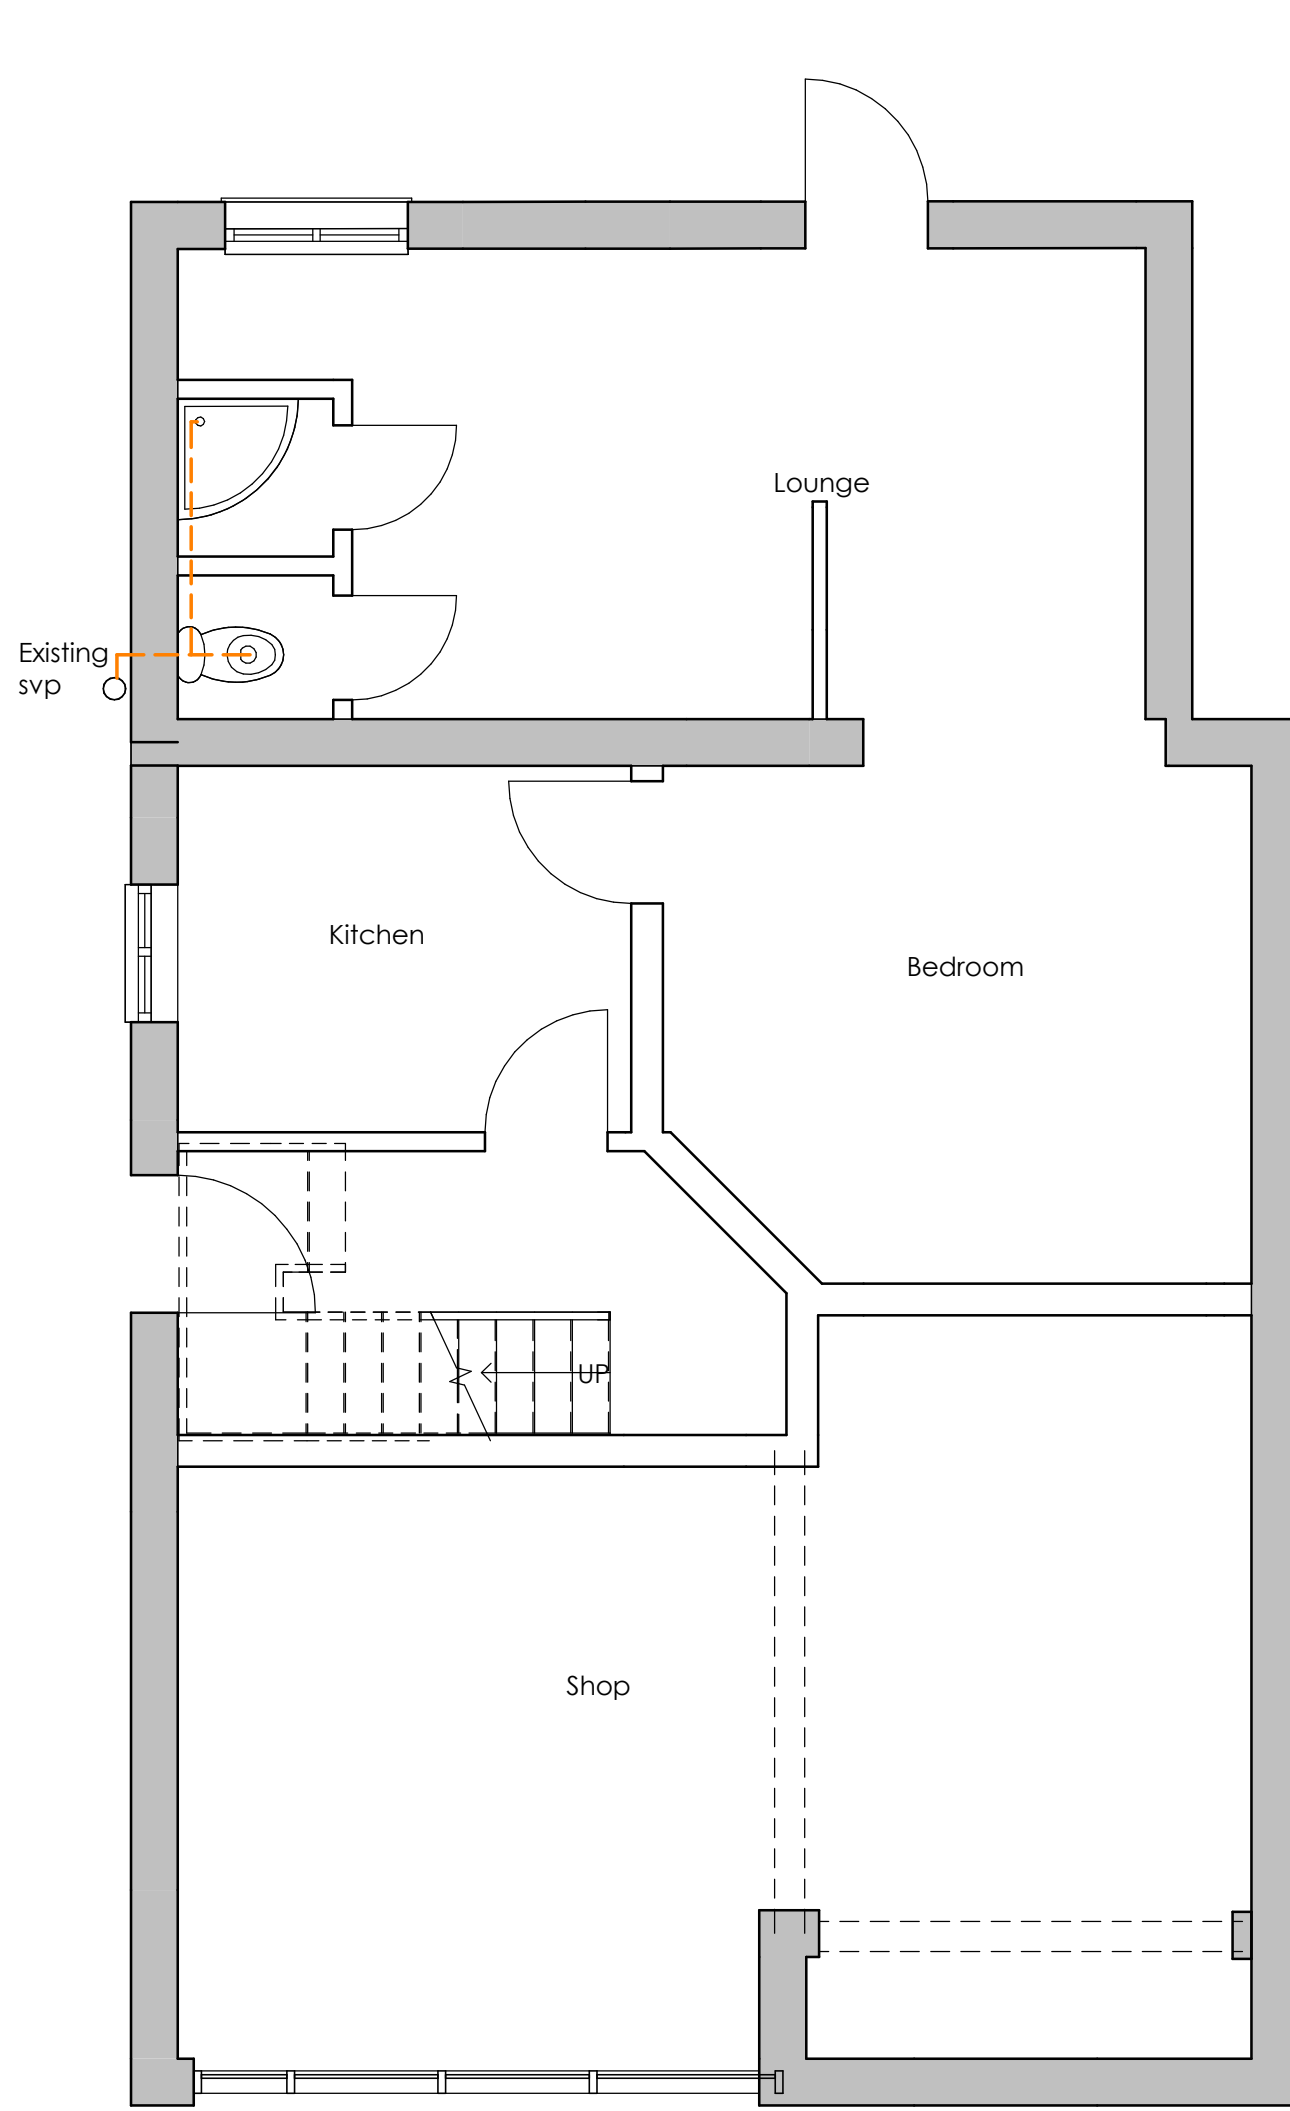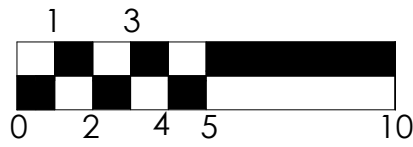


Existing Ground Floor (1:50)

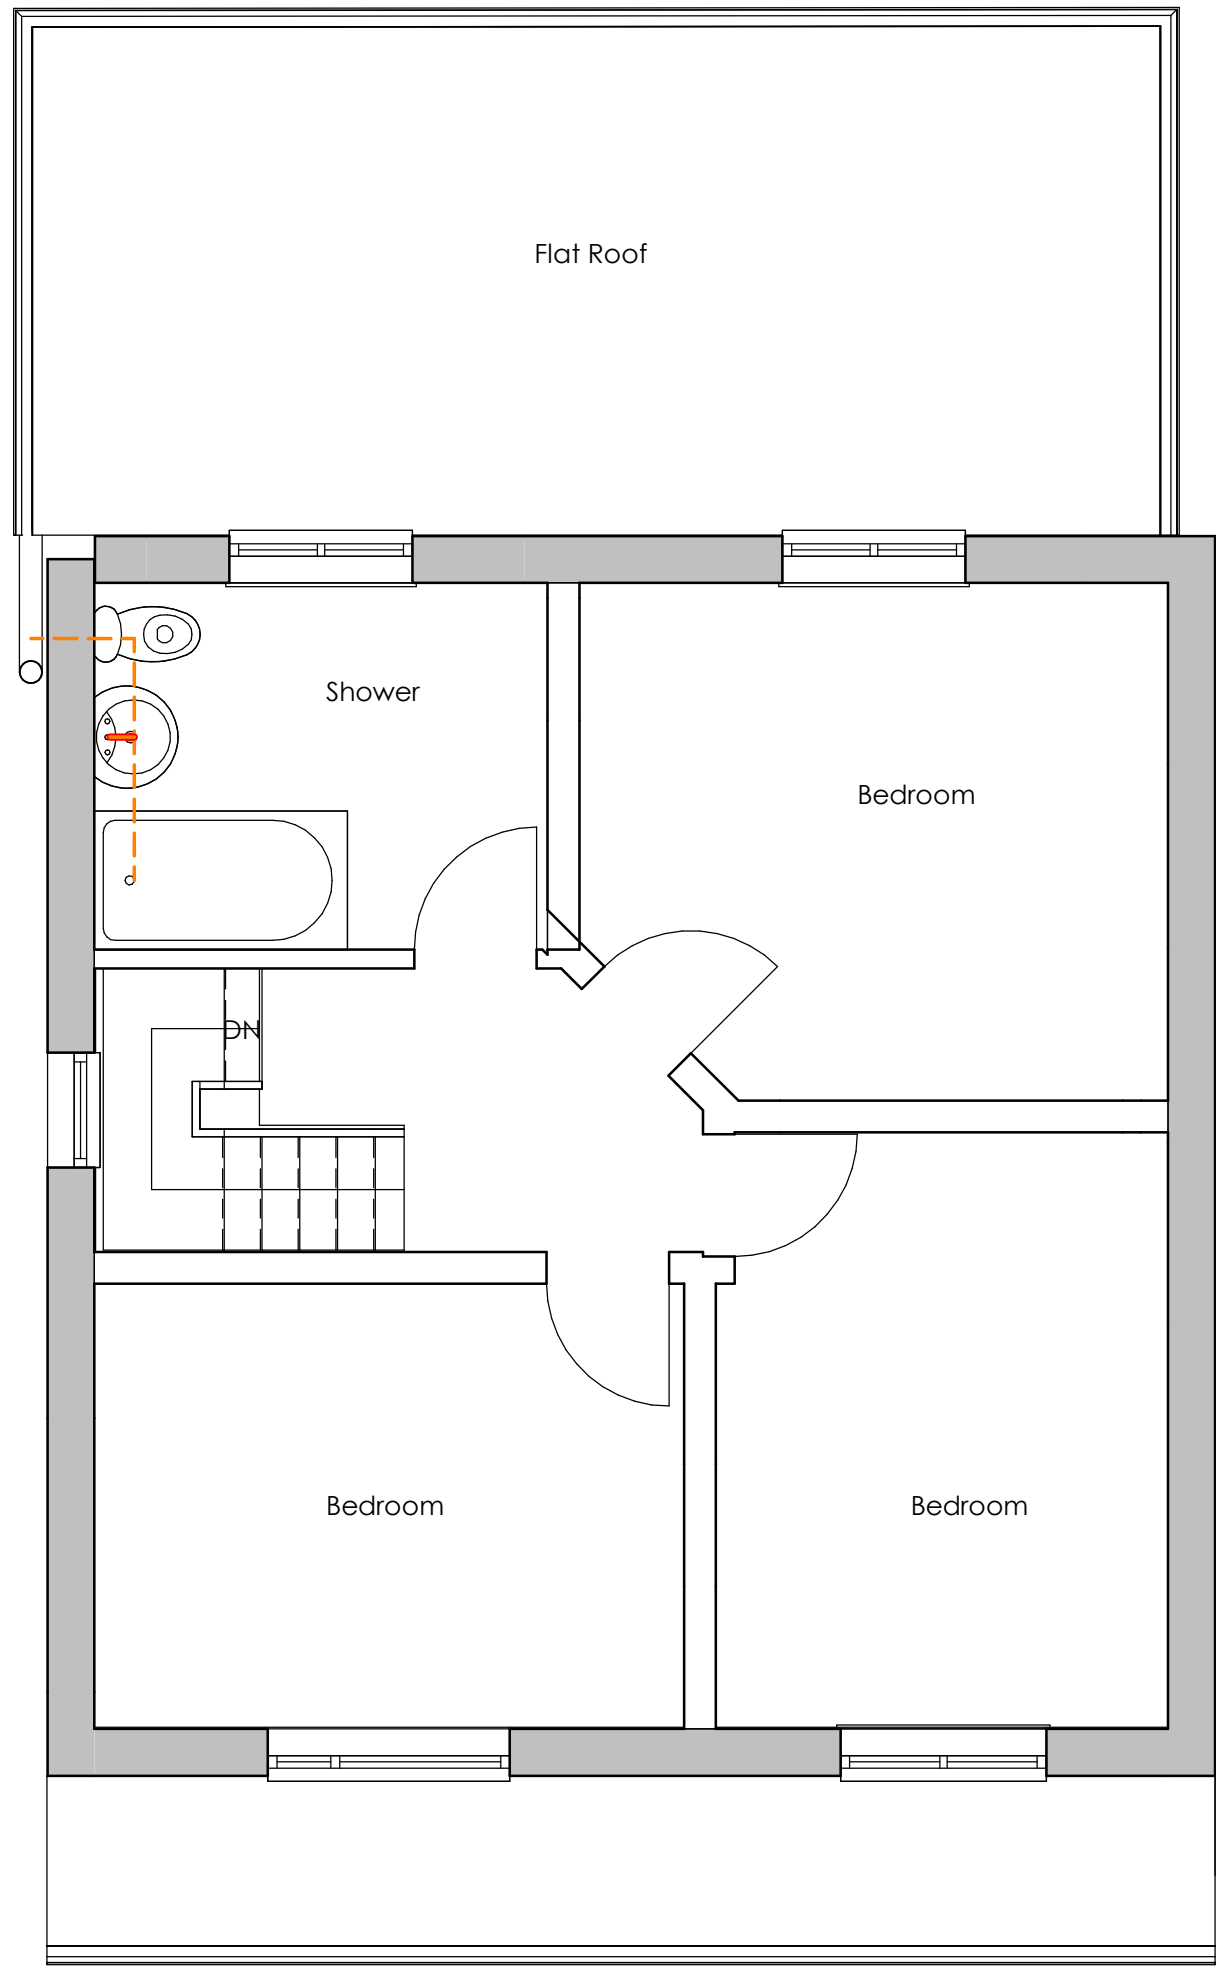

Existing First Floor (1:50)

 

Scale
1 : 50

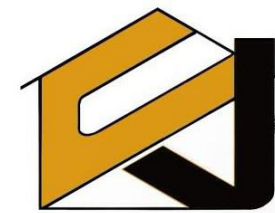

PLAN | DESIGN | BUILD
JCENG SOLUTIONS
tel:0118 348 6230 mob:07411070270
email:info@jcengsolutions.com
web:www.jcengsolutions.com

NOTES:
THE CONTRACTORS ARE TO CHECK ALL DIMENSIONS, DRAIN RUNS AND GENERAL CONDITIONS ON THE SITE BEFORE WORKS COMMENCE, AND INFORM JCENG SOLUTIONS IMMEDIATELY UPON DISCOVERY OF ANY ERRORS, OMISSIONS OR DISCREPANCIES. ALL WORKS ARE TO BE CARRIED OUT IN ACCORDANCE WITH CURRENT BUILDING REGULATIONS, BRITISH STANDARDS, CODE OF PRACTICE AND LOCAL AUTHORITY REQUIREMENTS. DO NOT SCALE FROM THIS DRAWING WITHOUT FIRST OBTAINING WRITTEN AUTHORISATION FROM JCENG SOLUTIONS.
THIS DRAWING IS THE PROPERTY OF JCENG SOLUTIONS AND IS ISSUED ON THE CONDITION THAT IT IS NOT REPRODUCED, DISCLOSED OR COPIED TO ANY UNAUTHORISED PERSON IN WHOLE OR PART WITHOUT PRIOR WRITTEN CONSENT

- RE Rodding Eye
- MH Man Hole
- SD Smoke detector
- MFO Mechanical fan outlet
- HT Heat detector
- SVVP Soil vent pipe
- RWP Rain water pipe
- FWD Foul water drain
- RWD Rain water drain
- SB Site boundary
- BL Beam /Lintels
- Demolition
- FD30s 1/2hour fire door
- FE Fire door
- Towel rail size 300mm L x 800mm H
- Radiator size 1200mm L x 600mm H

REV	DATE	DESCRIPTION
-----	------	-------------

CLIENT ADDRESS
**85 Cressingham Rd,
Reading RG2 7RX**

TITLE
**Existing Floor Plan &
Elevations**

CLIENT
Mr. Kularia

DRAWN BY JC	CHECKED BY RB	DATE 04/05/23
SCALE (@ A1) As indicated	PROJECT NUMBER 85-CR-01	

DRAWING NUMBER A101	REV
-------------------------------	-----