


 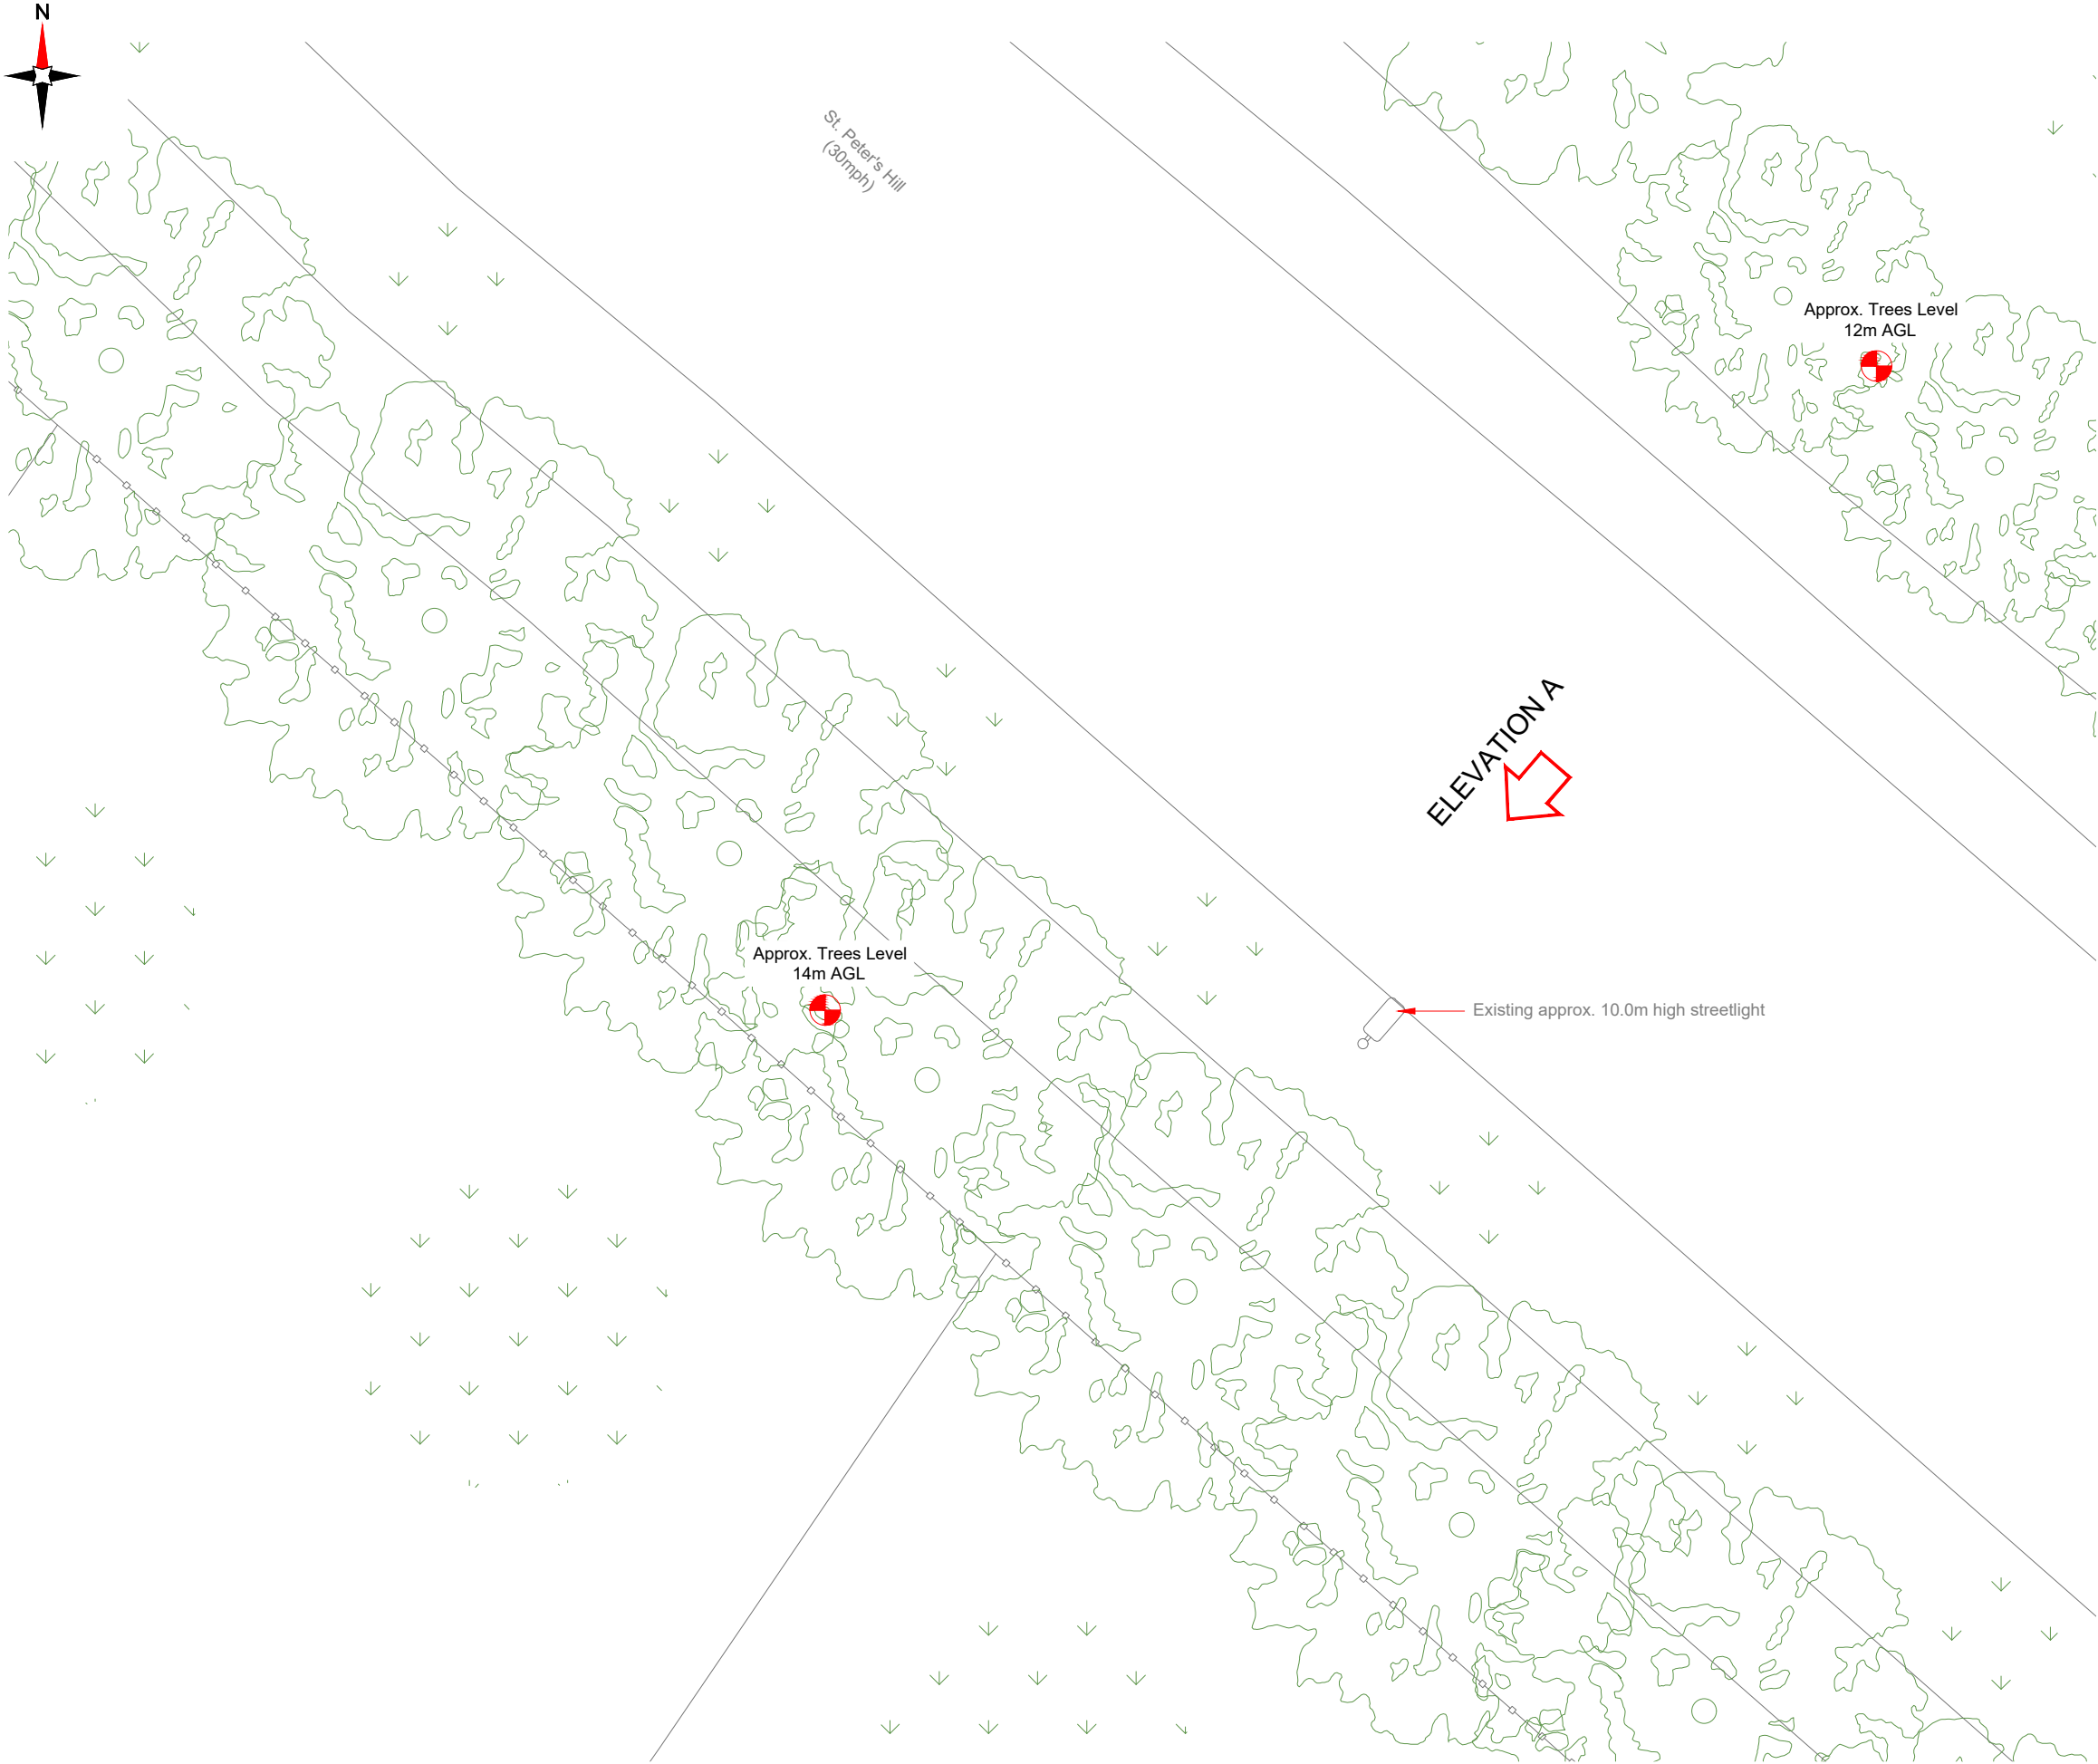


100mm

150mm

10mm

EXISTING SITE PLAN



- NOTES:
- ALL DIMENSIONS IN MM UNLESS OTHERWISE NOTED.

Master:	MBNL / EE:	Project:	Purpose of Issue:	Issue:
M002	MBNL	3UK DNSW	Planning	B
Date:	13/03/2023	Revision / Upgrade Description:		
Drawn:	CDN	Pole type changed to Phase 9		
Checked:	DH			
Approved:	SD			
Master:	MBNL / EE:	Project:	Purpose of Issue:	Issue:
M001	MBNL	3UK DNSW	Planning	A
Date:	01/06/2021	Revision / Upgrade Description:		
Drawn:	CDN	First Issue - Site nomination dated: TBC		
Checked:	DH			
Approved:	SD			

CK Hutchison
Networks (UK)
Limited

Green Park
450 Longwater Avenue
Reading
RG30 3UR

Design Consultant & Principal Contractor:



WHP Telecoms
Unit 1 Maple Park,
Low Fields Avenue, Leeds
LS12 6HH

Tel: 01133023550
e-mail: info@whptelecoms.com

Site Name:
ST. PETER'S HILL STREETWORKS

Site ID:
RDG18136

Address:
ST. PETER'S HILL, CAVERSHAM HEIGHTS,
READING, ENGLAND,
RG4 7DN

Title:
100 EXISTING SITE PLAN

Project:
3UK DNSW

Purpose of Issue:
PLANNING

EE Cell ID: 84071	MBNL Cell ID: RDG167	Cell ID: RG6764
----------------------	-------------------------	--------------------

Master Drawing No: RDG18136_M002	Issue: B
-------------------------------------	-------------