


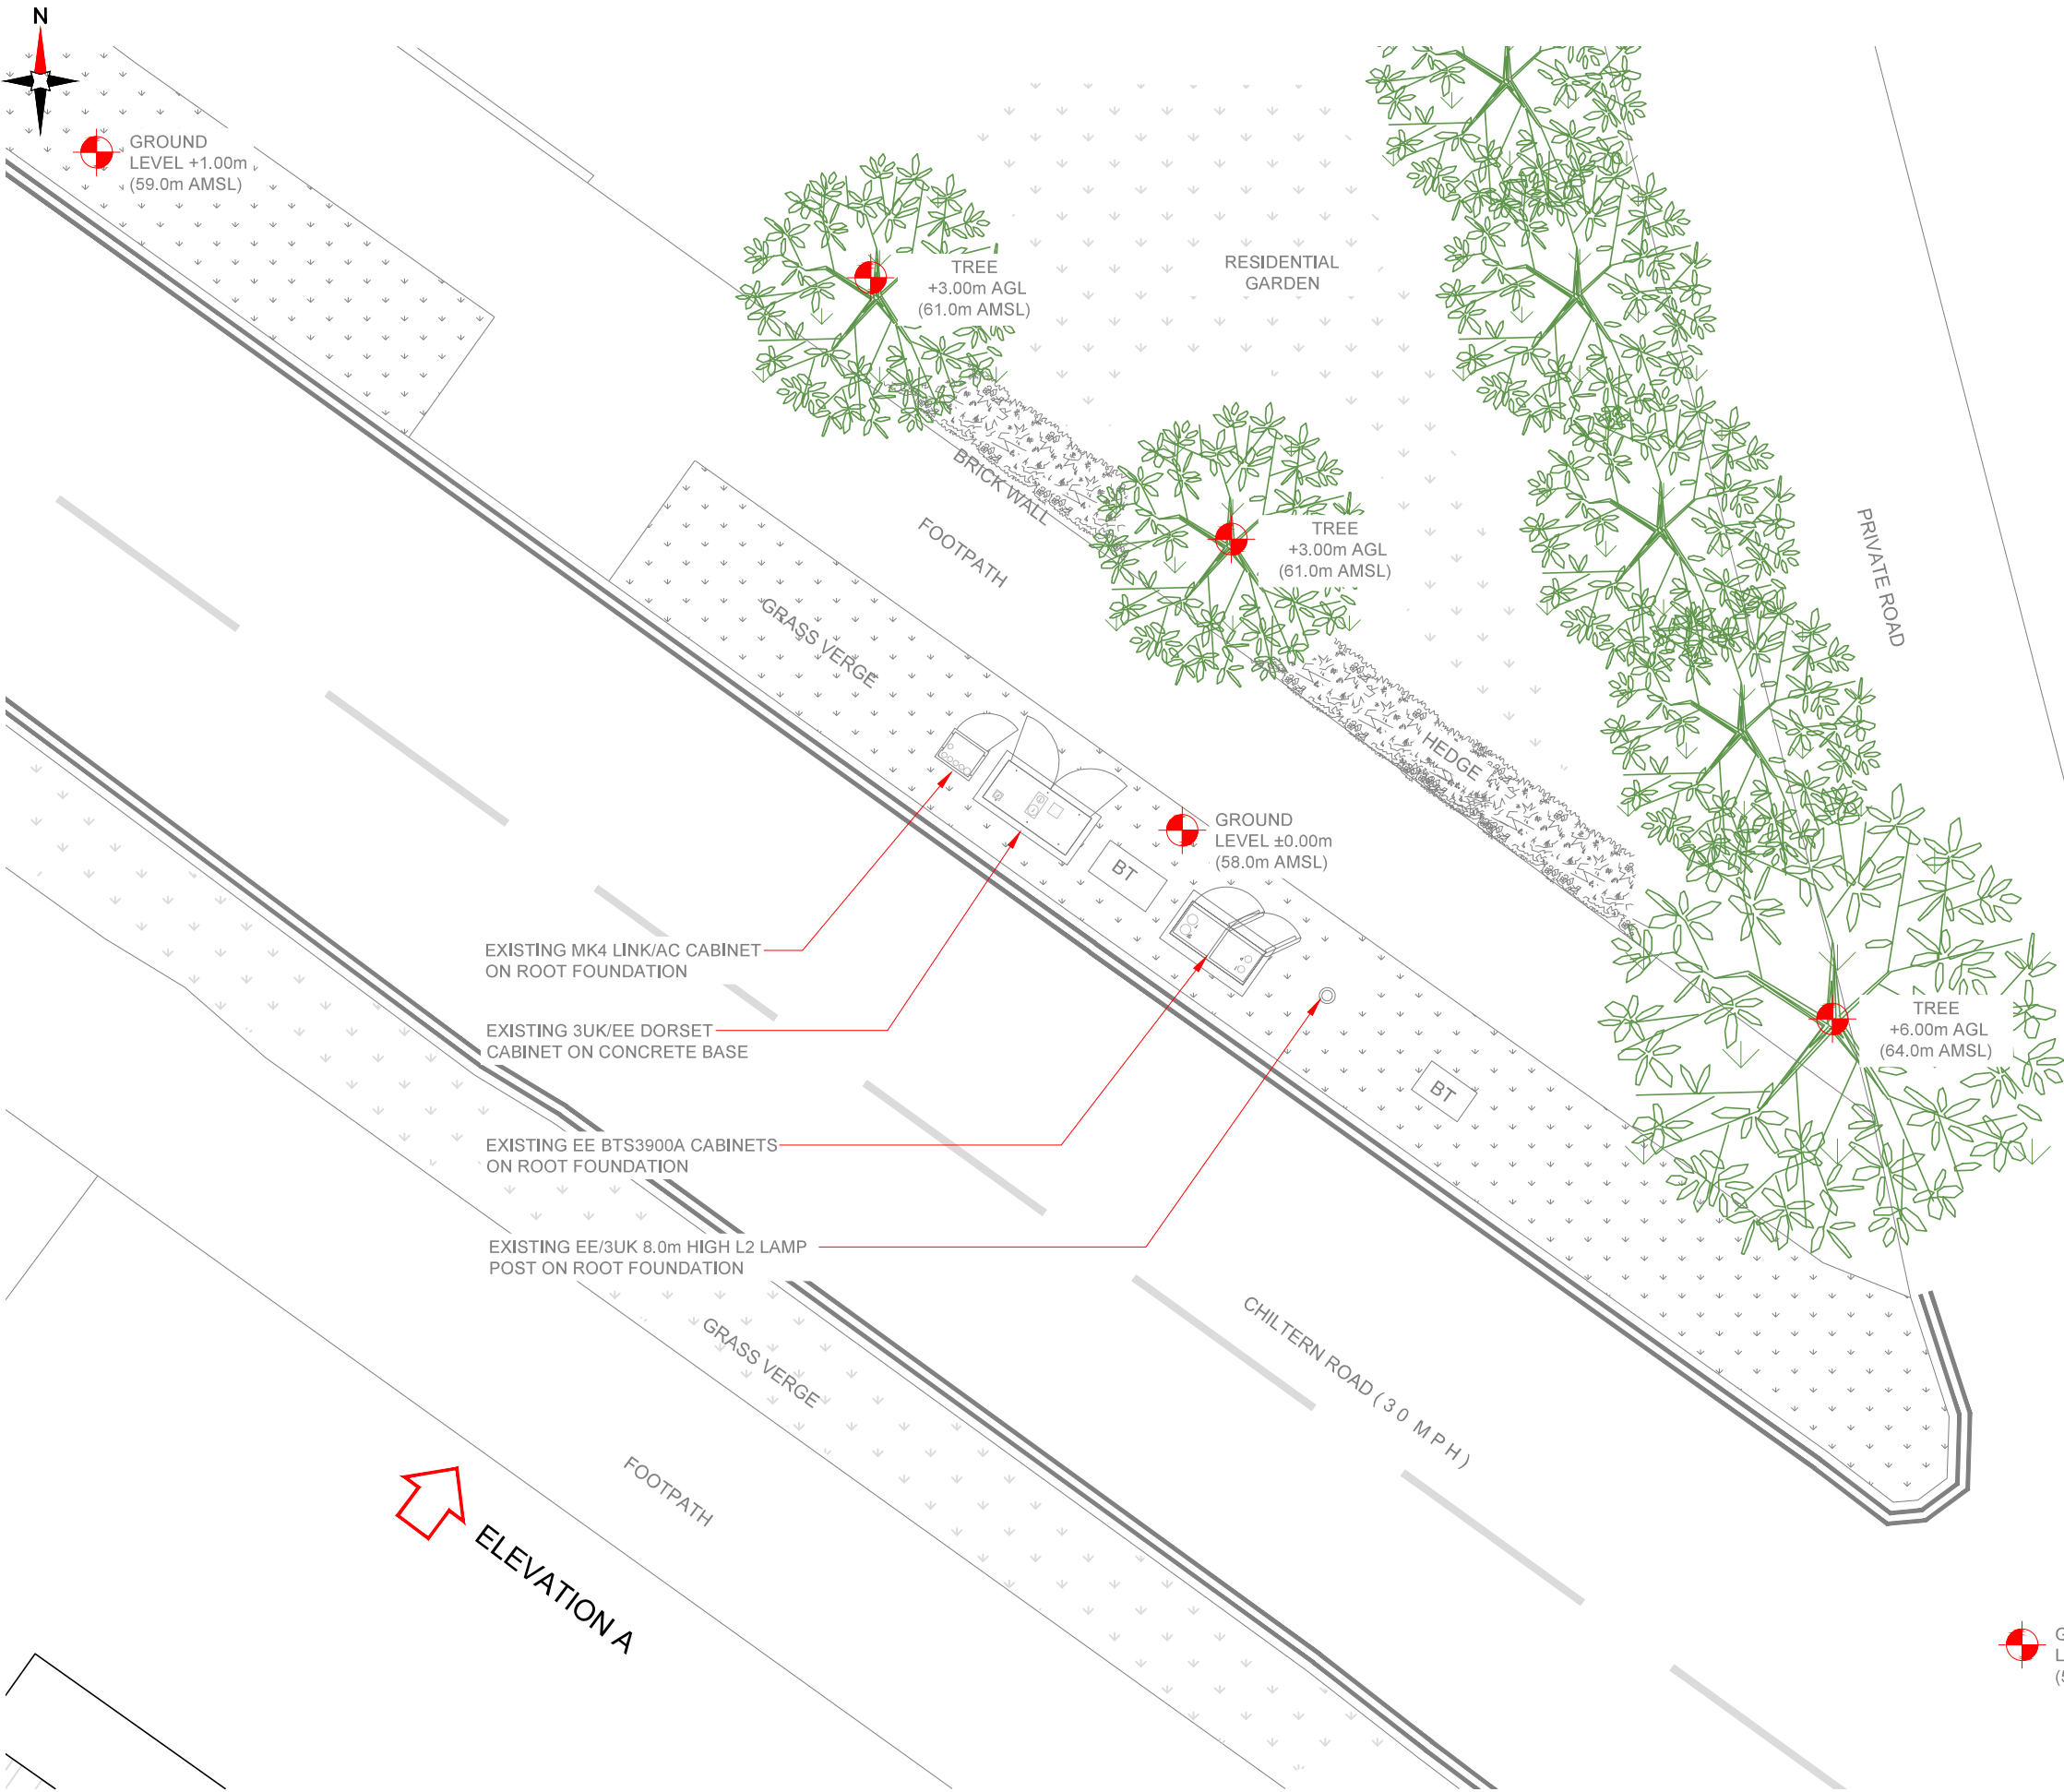

3G / 4G Antenna ID	Existing 3G Bearing
EA1	0°
EB1	120°
EC1	240°

NOTES:

1. ALL DIMENSIONS IN MM UNLESS OTHERWISE NOTED.

Master:	MBNL / EE / 3UK:	Project:	Purpose of Issue:	Issue:
M002	MBNL	MBNL 3UK BUY-IN	Planning	B
Date:	12.08.2022	Revision / Upgrade Description:		
Drawn:	A.M.Ward	Change to Phase 7 Monopole Configuration		
Checked:	A.Dobson			
Approved:	A.Dobson			
Master:	MBNL / EE / 3UK:	Project:	Purpose of Issue:	Issue:
M001	MBNL	MBNL 3UK BUY-IN	Planning	A
Date:	03.08.2022	Revision / Upgrade Description:		
Drawn:	M.Williams	First Issue - For comments		
Checked:	A.Dobson			
Approved:	A.Dobson			



Hutchison 3G UK Limited
Green Park, 450 Longwater Avenue
Reading, RG30 3UR
Tel: 01628 765 000
Fax: 01628 765 001



Hatfield Business Park
Hatfield
Hertfordshire
AL10 9BW
Tel: 01707 315000
Fax: 01707 319001



Mobile Broadband Network Limited
Sixth Floor, Thames Tower, Station Road, Reading, RG1 1LX

Design Consultant & Principal Contractor:

**CLARKE
telecom**

Unit E, Madison Place, Northampton Road,
Manchester, M40 5AG
Tel: 0161 785 4500 Fax: 0161 785 4501
Web: www.clarke-telecom.com

Site Name:

94 CHILTERN ROAD

Site ID:

1185859

Address:

**EASTERN GRASS VERGE
OUTSIDE 94 CHILTERN ROAD,
CAVERSHAM, READING,
BERKSHIRE
RG4 5JD**

Title:

100 EXISTING SITE PLAN

Project:

MBNL - 3UK BUY-IN

Purpose of Issue:

PLANNING

EE Cell ID:	MBNL Cell ID:	3UK Cell ID:
10900	RDG079	RG4655

Master Drawing No:	Issue:
1185859_RDG079_10900_RG4655_M002	B

100mm

50mm

10mm

EXISTING SITE PLAN

