


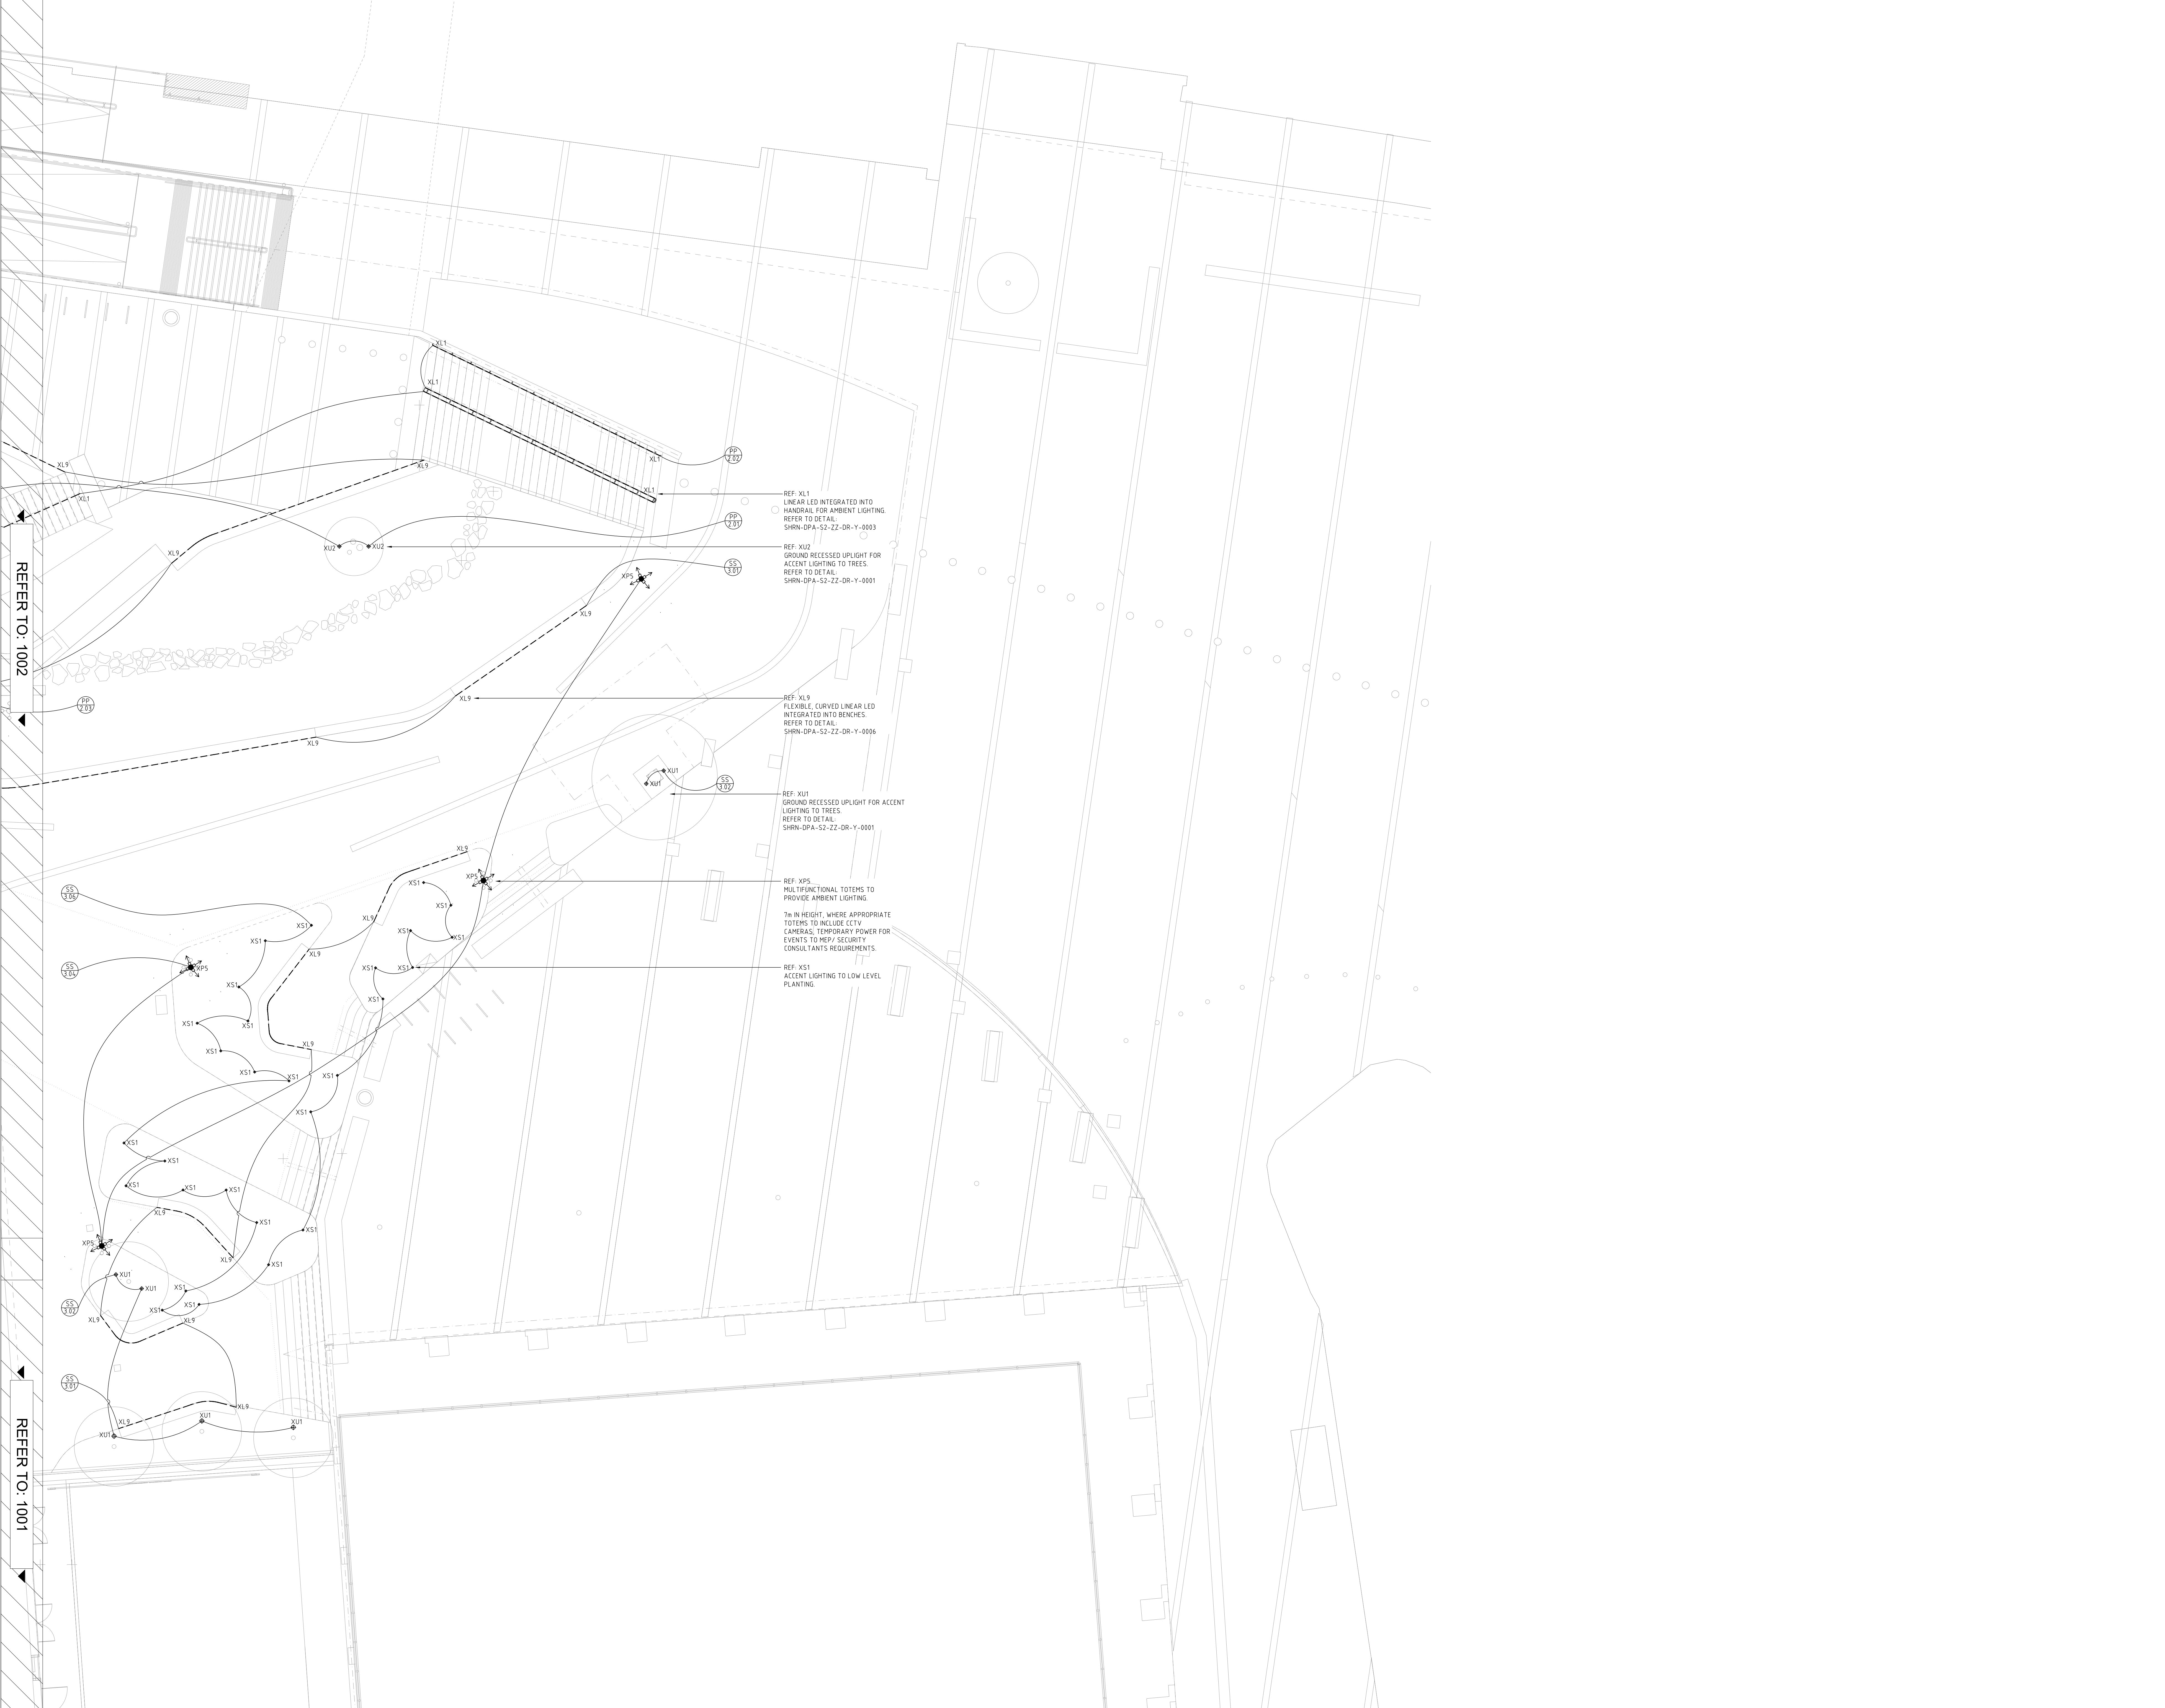

REFER TO: 1002

REFER TO: 1001

- LIGHTING NOTES:
- R
01

Indicates lighting control area
Indicates lighting control channel
 - D1Indicates luminaire type
 - 1. Refer to appropriate dpa luminaire and lighting control schedules for further details.
 - 2. Scaled dimensions should not be taken from this drawing. All dimensions to be checked on-site.
 - 3. Where appropriate refer to associated lighting detail drawings for the exact location of luminaires.
 - 4. All equipment supplied by the installing contractor shall comply with the relevant EN, BS, CE & IEC regulations, and be capable of installation in accordance with the current edition of the IEE wiring regulations. All equipment shall comply with all other statutory and local authority requirements.
 - 5. Installing Contractor to ensure that all transformers and control gear are compatible with the lighting control system dimmers.
 - 6. Final locations of lighting control plates, manual sliders and dimmer racks to be co-ordinated with Architect and M&E consultant. Exact locations to be agreed on-site and approved by client.
 - 7. Emergency lighting system and signage by others.

T01	Tender Issue	IC	25.11.2020
O4	Stage 4a Issue	HR	05.05.2020
O3	Stage 4 Issue	HR	15.05.2020
O2	Stage 4a - Draft Issue	HR	13.05.2020
O1	Stage 3 - Developed Design	HR	27.11.2019
First Issue:	Stage 3 - Preliminary	HR	15.11.2019
Revision:	Description:	By:	Date:

dpa lighting consultants London
1 Aylmford Street Telephone +44 (0) 20 3142 6300
London, SW1V 3RY, UK Email london@dpalighting.com

Project:
STH STATION HILL, READING

Drawing Title:
**PHASE 2 - NORTH SITE - LEVEL 00
LANDSCAPE LIGHTING LAYOUT 3**

Scale:	Drawn By:	Date:	Drawing No:	Revision:
1:100@A0	HR	15.11.2019	SHRN-DPA-S2-ZZ-CR-Y-1003	T01

Copyright reserved by dpa lighting consultants London. To be used for client's use only. All other dimensions must be used. Any detail or dimensional conflicts should be referred to dpa lighting consultants London for clarification.