



GENERAL NOTE  
This drawing is to be read in conjunction with all other relevant drawings, schedules and specifications issued.  
All interior dimensions including ceiling heights are taken to and from finished surfaces unless otherwise stated. All levels and dimensions must be checked on site.  
Any discrepancies with the information depicted in this drawing must be reported in writing. Responsibility cannot be accepted for alterations made to this drawing without prior permission.  
This drawing must not be photocopied, scaled or reproduced otherwise scale accuracy cannot be guaranteed.  
This drawing should not be used in any circumstances for any structural calculation or building construction / demolition work.


| SYMBOL | DESCRIPTION                                  |
|--------|----------------------------------------------|
|        | 13 AMP. SWITCHED SOCKET OUTLET               |
|        | 13 AMP. SWITCHED SOCKET OUTLET ABOVE WORKTOP |
|        | ONE WAY SWITCH                               |
|        | TWO WAY SWITCH                               |
|        | TELEPHONE POINT                              |
|        | TELEVISION POINT                             |
|        | INTERCOM                                     |
|        | COCKER SWITCH (1100MM ABOVE FFL)             |
|        | CONSUMER SERVICE UNIT                        |
|        | SHAVER POINT                                 |
|        | CEILING LIGHTING POINT - PENDANT TYPE        |
|        | CEILING LIGHTING POINT - DOWN LIGHTERS TYPE  |
|        | WALL MOUNTED LIGHTING POINT                  |
|        | CENTRAL HEATING PROGRAMMER & TIMER           |
|        | PROGRAMMER TEMPERATURE SENSOR                |
|        | PROGRAMMABLE ROOM THERMOSTAT                 |
|        | EXTRACT FAN                                  |
|        | COCKER HOOD                                  |
|        | SWITCH FOR EXTRACT FAN                       |
|        | RADIATOR                                     |
|        | SMOKE DETECTOR                               |
|        | HEAT DETECTOR                                |
|        | CO ALARM                                     |
|        | CALL POINT                                   |
|        | EMERGENCY LIGHTING                           |

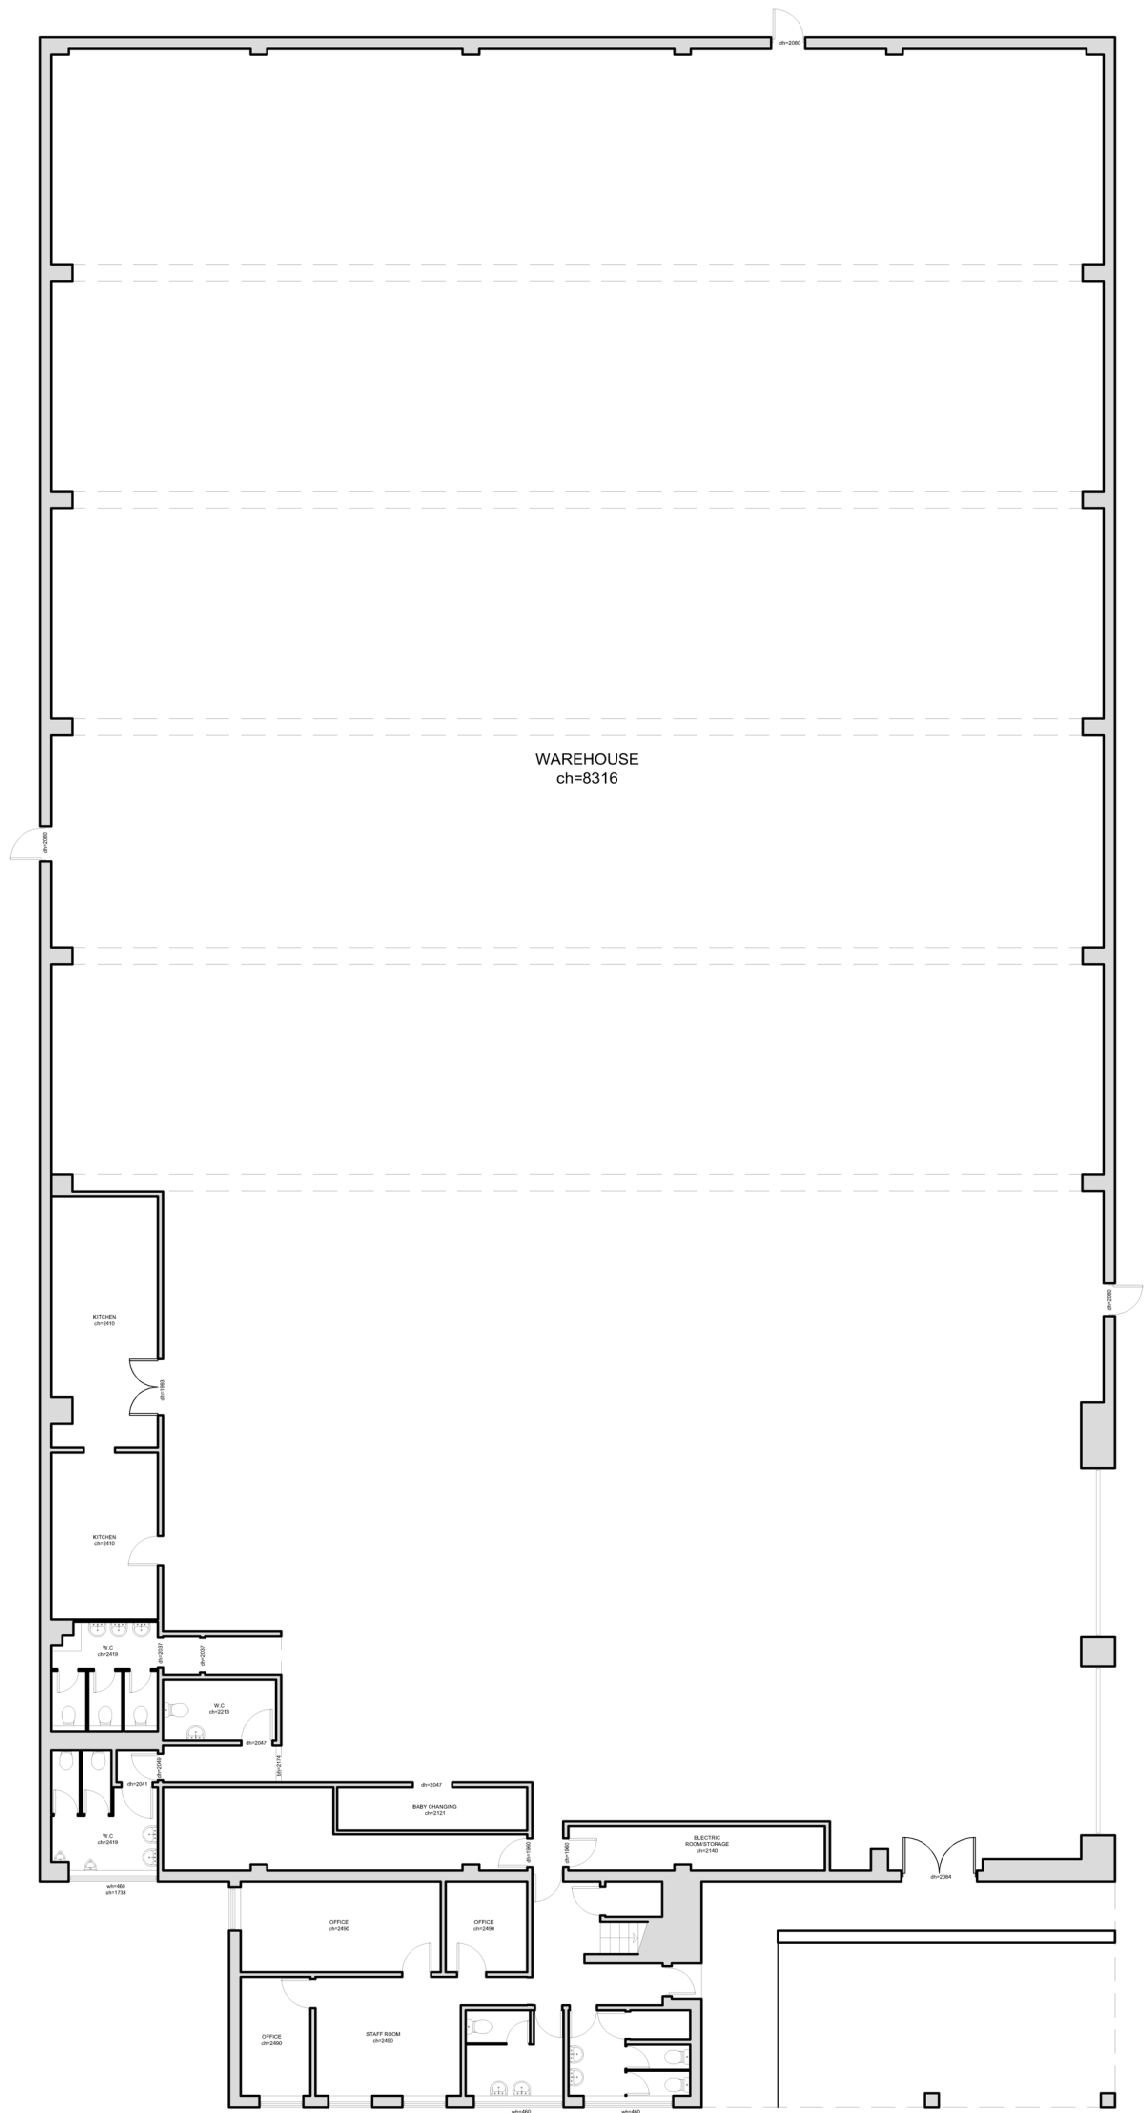

GROUND FLOOR PLAN

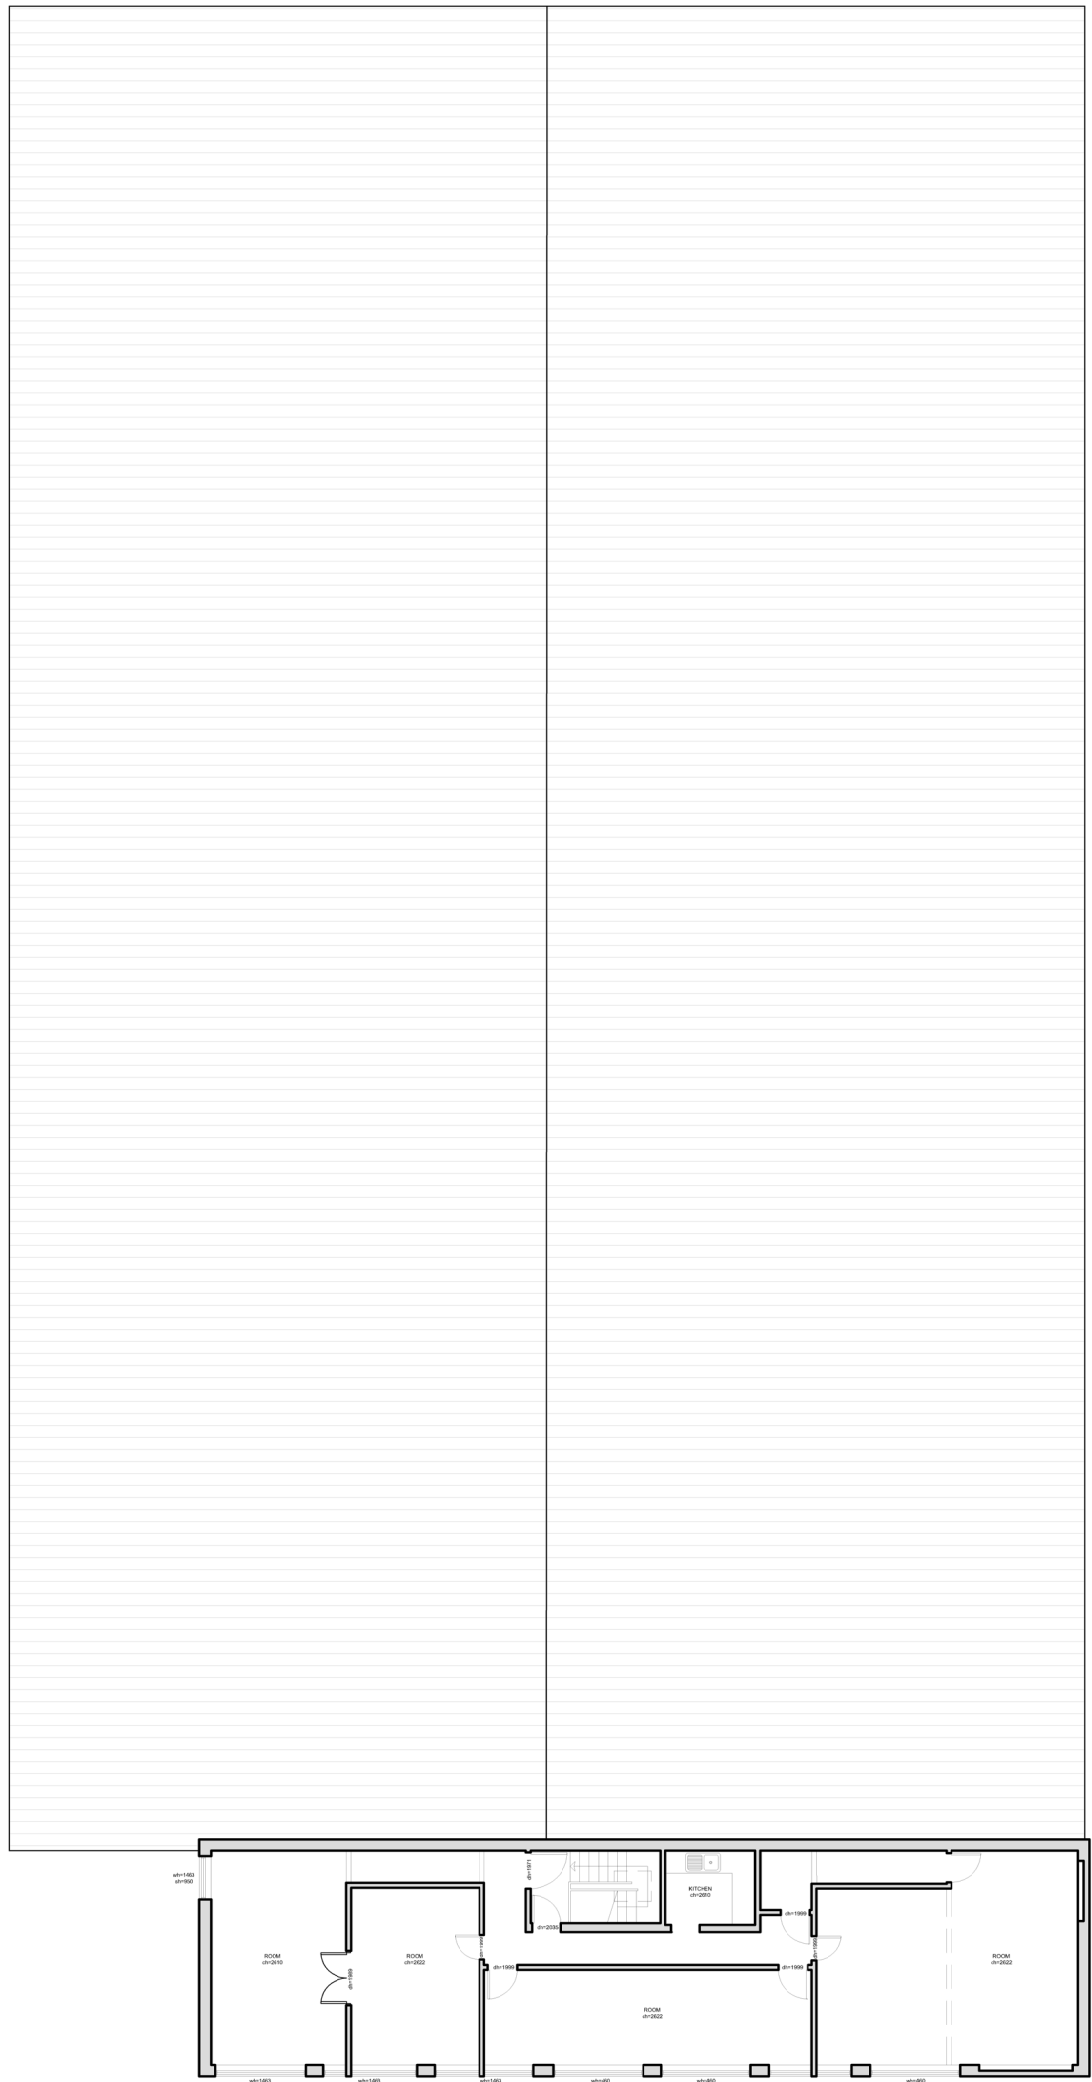

 FIRST FLOOR PLAN



PROJECT TITLE  
UNIT 7 NORCOTT INDUSTRIAL ESTATE  
1-7 STERLING WAY  
TILEHURST  
READING  
RG30 6HW  
DRAWING TITLE

| FLOOR PLANS |         |            |
|-------------|---------|------------|
| SCALE       | SIZE    | DRAWING    |
| 1:200       | A2      | 269554     |
| DRAWN       | CHECKED | DATE       |
| AYH         |         | 02/12/2020 |

FOURWALLS™

SUITE 1.14, BUILDING THREE  
WATCHMOR PARK, CAMBERLEY, GU15 3YL  
WWW.FOURWALLS-GROUP.COM

