


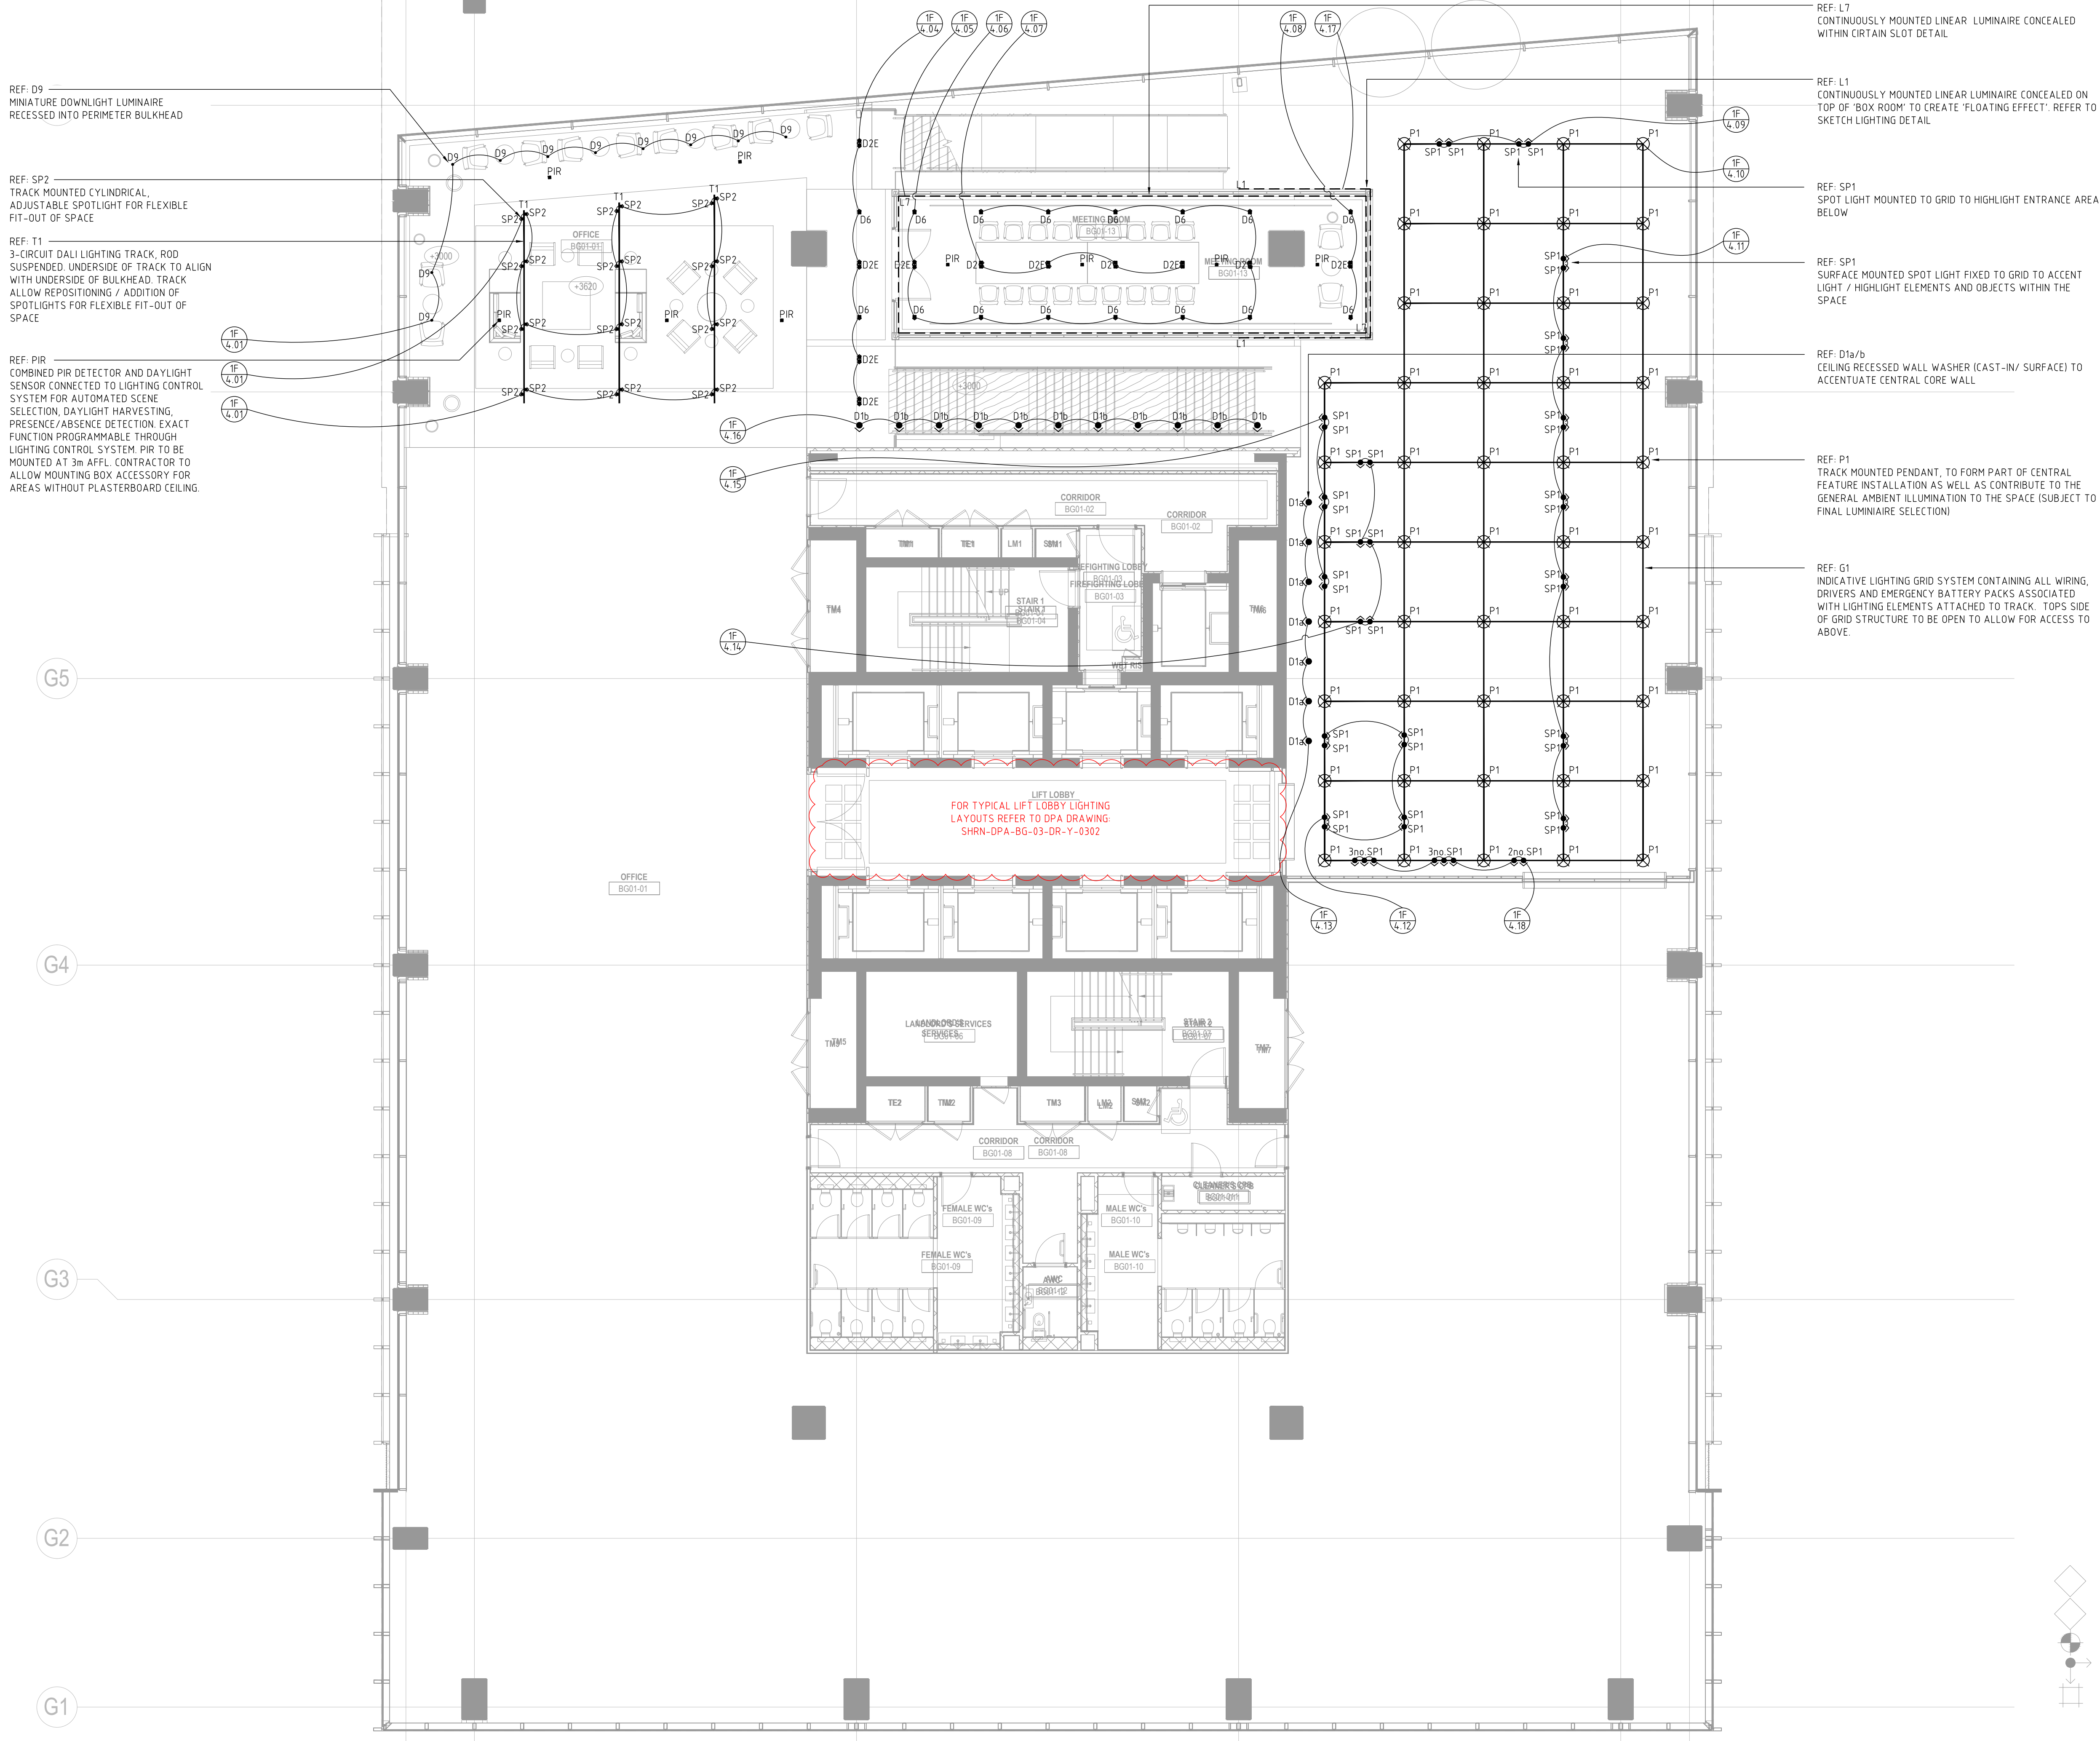

- LIGHTING NOTES:
- R**
01

Indicates lighting control area
Indicates lighting control channel
 - D1**

Indicates luminaire type
 - 1.

Refer to appropriate dpa luminaire and lighting control schedules for further details.
 - 2.

Scaled dimensions should not be taken from this drawing. All dimensions to be checked on-site.
 - 3.

Where appropriate refer to associated lighting detail drawings for the exact location of luminaires.
 - 4.

All equipment supplied by the installing contractor shall comply with the relevant EN, BS, CE & IEC regulations, and be capable of installation in accordance with the current edition of the IEE wiring regulations. All equipment shall comply with all other statutory and local authority requirements.
 - 5.

Installing Contractor to ensure that all transformers and control gear are compatible with the lighting control system dimmers.
 - 6.

Final locations of lighting control plates, manual sliders and dimmer racks to be co-ordinated with Architect and M&E consultant. Exact locations to be agreed on-site and approved by client.
 - 7.

Emergency lighting system and signage by others.

T03	Stage 4 Design - Level 1 Co-Working Space Added	IC	24.09.2020
T02	Reception Update	HR	26.06.2020
T01	Stage 4 Design - FINAL ISSUE	CHL	05.06.2020
O3	Stage 4 Design - Update	HR	15.05.2020
O2	Stage 4 Design	HR	14.05.2020
O1	Stage 3 - Developed Design	HR	28.11.2019
First Issue	For Information/ Comment	HR	22.11.2019
Revision:	Description:	By:	Date:

dpa

lighting consultants London

1 Aylesford Street
London, SW1V 3RY, UK

Telephone +44 (0) 20 3142 6300
Email london@dpalighting.com

Project:

SHRN STATION HILL, READING

Drawing Title:

PHASE 2 - ONE STATION HILL
ATRIUM - LEVEL 01
REFLECTED CEILING PLAN LIGHTING LAYOUT

Scale:	Drawn By:	Date:	Drawing No:	Revision:
1:100@A1	HR	24/09/2020	SHRN-DPA-BG-01-DR-Y-0102	T03

© Copyright dpa lighting consultants London. Do not scale drawing. Figured dimensions must be used.
Any detail or dimensional conflicts should be referred to dpa lighting consultants London for clarification.