


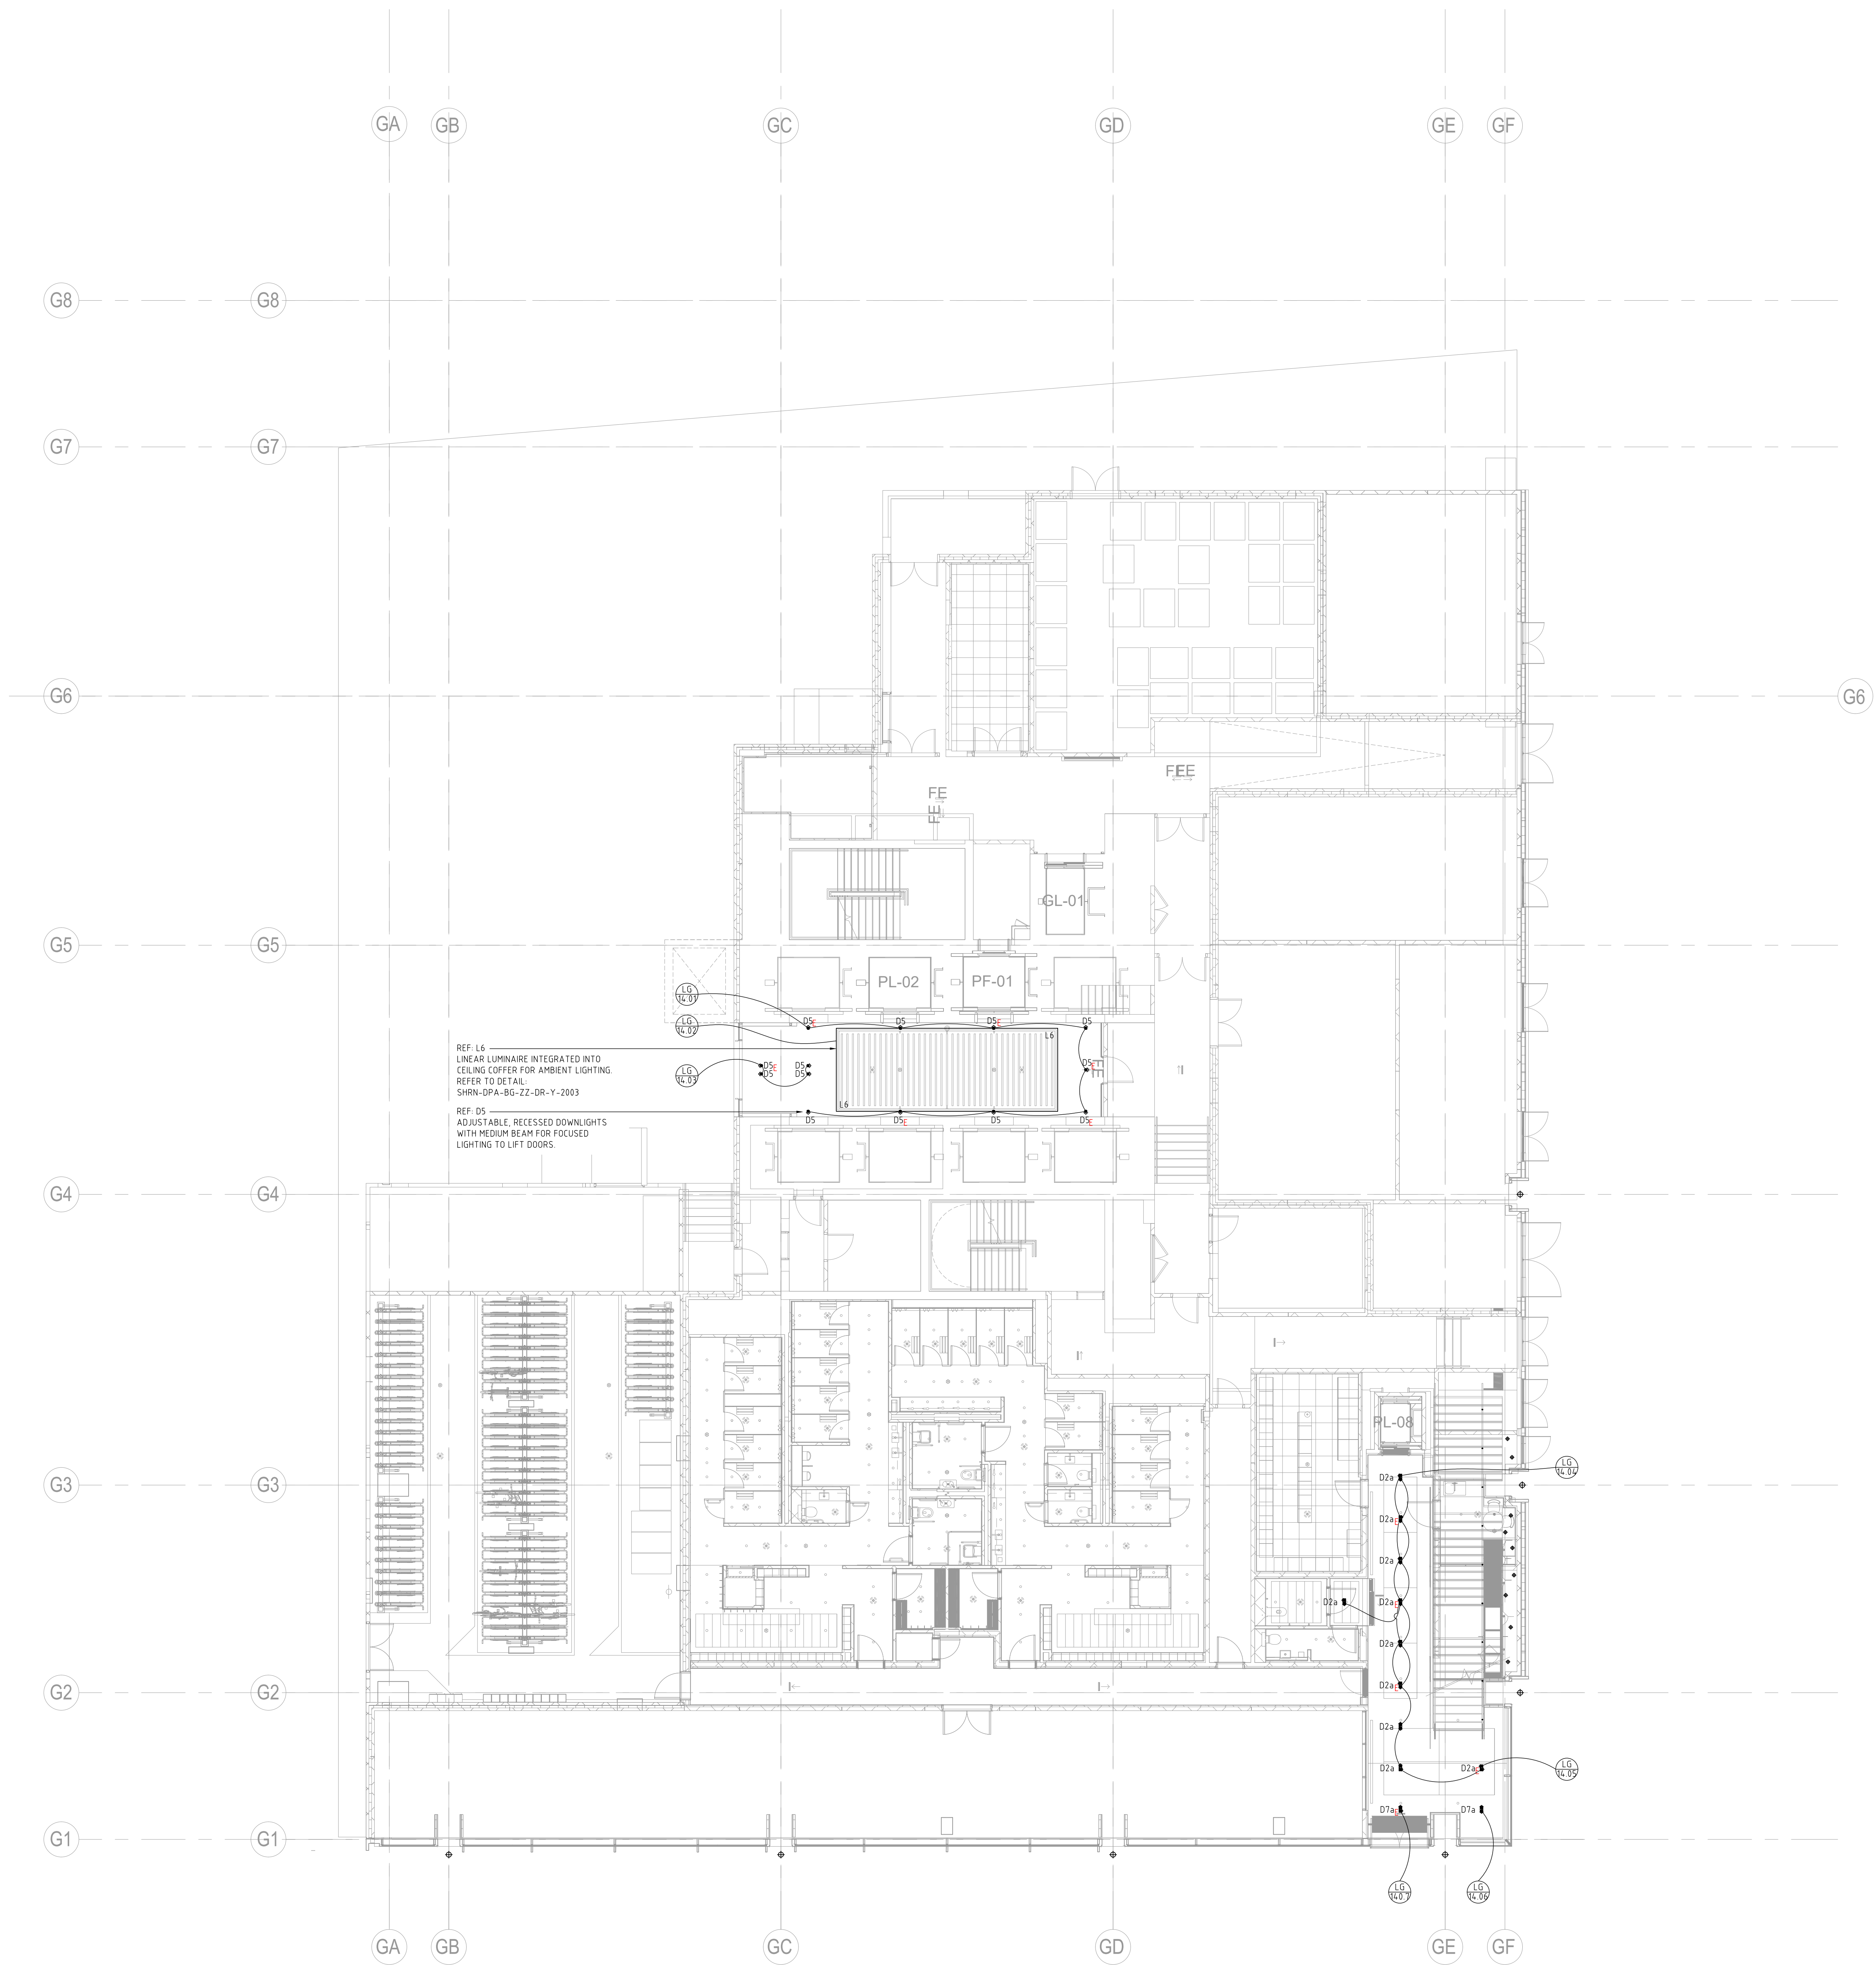

- LIGHTING NOTES:
- R 01 Indicates lighting control area
 - 01 Indicates lighting control channel
 - D1 Indicates luminaire type
 - 1. Refer to appropriate dpa luminaire and lighting control schedules for further details.
 - 2. Scaled dimensions should not be taken from this drawing. All dimensions to be checked on-site.
 - 3. Where appropriate refer to associated lighting detail drawings for the exact location of luminaires.
 - 4. All equipment supplied by the installing contractor shall comply with the relevant EN, BS, CE & IEC regulations, and be capable of installation in accordance with the current edition of the IEE wiring regulations. All equipment shall comply with all other statutory and local authority requirements.
 - 5. Installing Contractor to ensure that all transformers and control gear are compatible with the lighting control system dimmers.
 - 6. Final locations of lighting control plates, manual sliders and dimmer racks to be co-ordinated with Architect and M&E consultant. Exact locations to be agreed on-site and approved by client.
 - 7. Emergency lighting system and signage by others.

First Issue	Stage 4 - Final Issue	HR	26.06.2020
Revision:	Descriptions:	By:	Date:

dpa lighting consultants London
1, Aylesford Street
London, SW1V 3BY, UK
Telephone +44 (0) 20 3142 6300
Email london@dpalighting.com

Project:
STHN STATION HILL, READING

Drawing Title:
**PHASE 2 - ONE STATION HILL
LOWER GROUND
RCP LIGHTING LAYOUT**

Scale:	Drawn By:	Date:	Drawing No:	Revision:
1:100@A0	HR	26.06.2020	09HR-DPA-BG-LG-GR-V-020	T02

Copyright © 2020 dpa lighting consultants London. All rights reserved. No part of this drawing may be reproduced or transmitted in any form or by any means electronic or mechanical, including photocopying, recording, or by any information storage and retrieval system, without permission in writing from dpa lighting consultants London.