


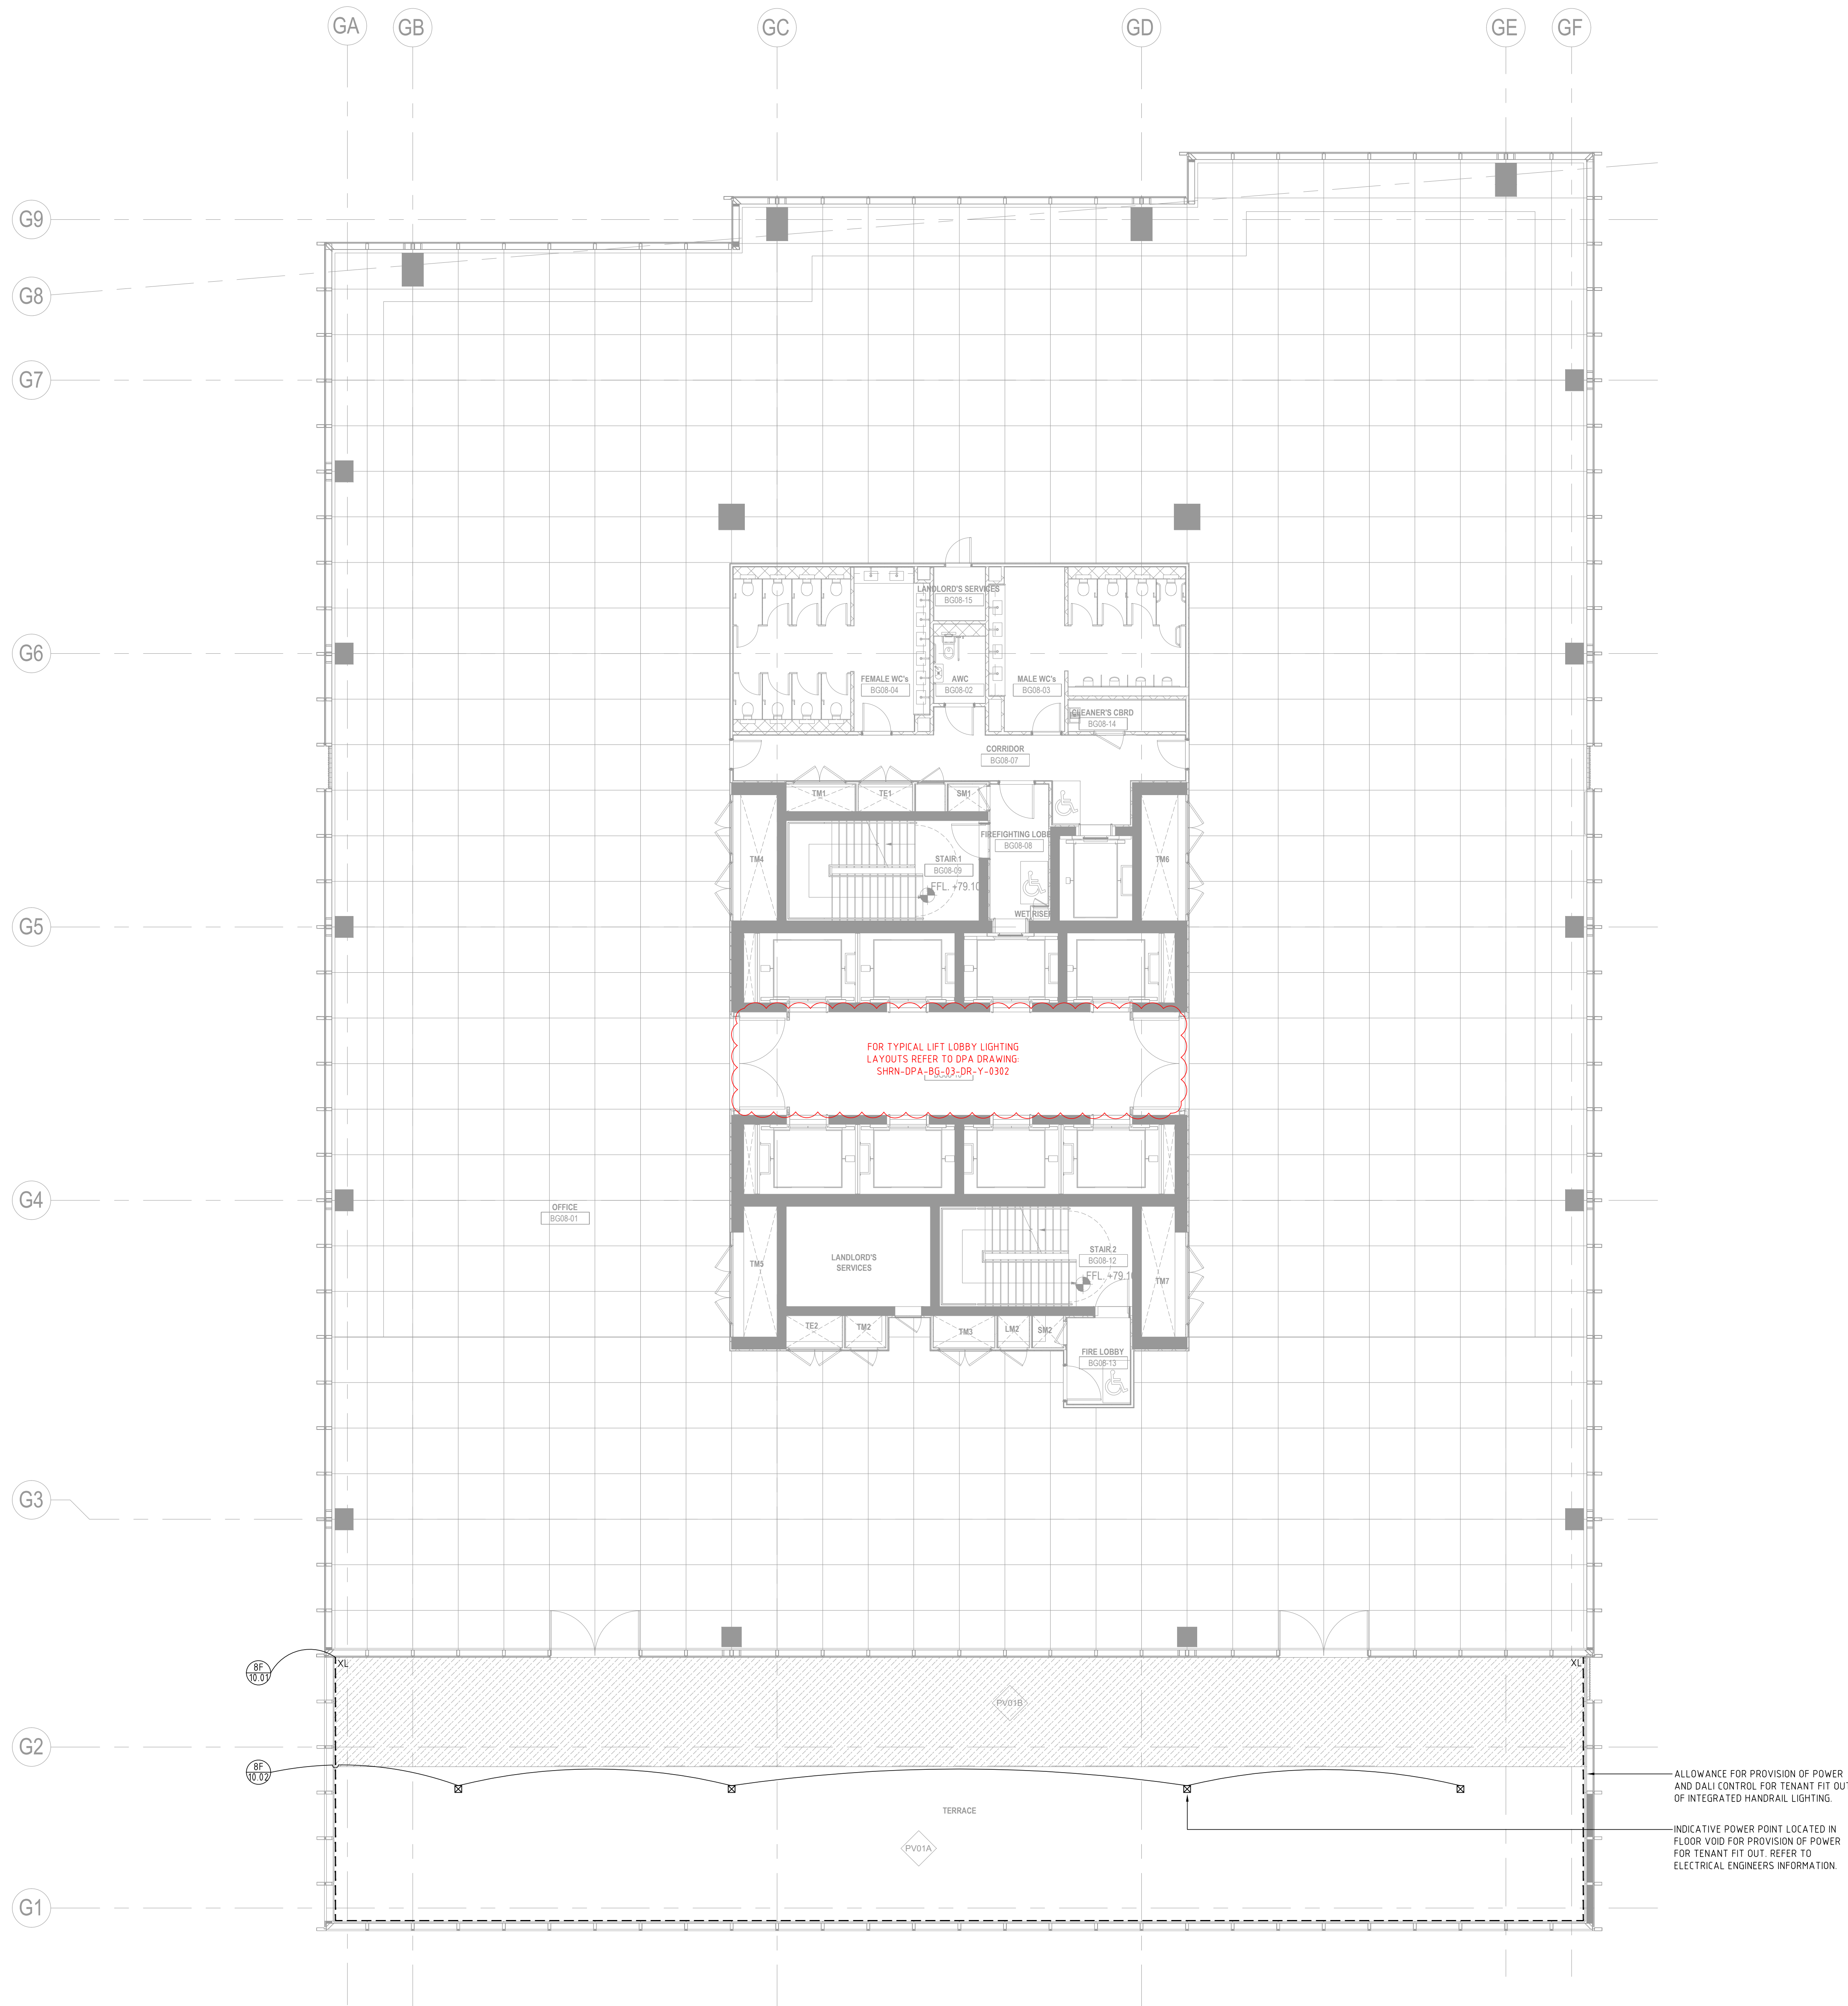

- LIGHTING NOTES:
- R
D1

Indicates lighting control area
Indicates lighting control channel
 - D1

Indicates luminaire type
 - 1.

Refer to appropriate dps luminaire and lighting control schedules for further details.
 - 2.

Scaled dimensions should not be taken from this drawing. All dimensions to be checked on-site.
 - 3.

Where appropriate refer to associated lighting detail drawings for the exact location of luminaires.
 - 4.

All equipment supplied by the installing contractor shall comply with the relevant EN, BS, CE & IEC regulations, and be capable of installation in accordance with the current edition of the IEE wiring regulations. All equipment shall comply with all other statutory and local authority requirements.
 - 5.

Installing Contractor to ensure that all transformers and control gear are compatible with the lighting control system dimmers.
 - 6.

Final locations of lighting control plates, manual sliders and dimmer racks to be co-ordinated with Architect and M&E consultant. Exact locations to be agreed on-site and approved by client.
 - 7.

Emergency lighting system and signage by others.

T01	Stage 4 Design - Final Issue	CHL	05.06.2020
First Issue	Stage 4 Design	HR	15.05.2020
Revision:	Description:	By:	Date:

dpa lighting consultants London
1 Aylshurst Street Telephone: +44 (0) 20 3142 6500
London, SW1V 3RY, UK Email: london@dpa-lighting.com

Project:
STHN STATION HILL, READING

Drawing Title:
**PHASE 2 - ONE STATION HILL
TERRACE - LEVEL 08
LOW LEVEL LIGHTING LAYOUT**

Scale:	Drawn By:	Date:	Drawing No:	Revision:
1:100@A0	CHL	05.06.2020	SHRN-DPA-BG-08-DR-Y-0001	T01

© Copyright the lighting consultants. All rights reserved. Do not scale drawings. Scaled dimensions must be used. Any detail or dimensional conflicts should be referred to the lighting consultants London for clarification.