

DO NOT SCALE FROM THIS DRAWING - CHECK ALL DIMENSIONS ON SITE
THIS DRAWING IS INDICATIVE ONLY. THEREFORE, INSTALLING CONTRACTORS MUST CHECK ALL INFORMATION SHOWN FOR ACCURACY, PRIOR TO USING THIS DRAWING FOR ANY INSTALLATION WORK.
ANY INACCURACIES WITH THIS DRAWING MUST BE REPORTED TO ION CONSULTING ENGINEERS AT THE EARLIEST OPPORTUNITY



BACKGROUND INFORMATION

ION XREF DRG No.	X20-026 SITE PROP (2021-01-19)		
RECEIVED FROM	DRAWING NUMBER	REV	DATE REC'D
Saunders	8/29 / 1200	P3	2021.01.18

NOTES

- THIS DRAWING SHALL BE READ IN CONJUNCTION WITH THE ION CONSULTING ENGINEERS SPECIFICATION FOR THE ELECTRICAL SERVICES INSTALLATION.

THIS DRAWING IS INDICATIVE ONLY &
DOES NOT REPRESENT A DESIGN SOLUTION -
IT IS PROVIDED TO ASSIST THE CONTRACTOR.

T1 | 05.02.2021 | TENDER ISSUE | DG | JH

REV	DATE	DESCRIPTION	DRN	CHK
-----	------	-------------	-----	-----

CLIENT:  **Reading**
Borough Council
Working better with you

PROJECT: ARTHUR HILL
POOL REGENERATION

TITLE: EXTERNAL SERVICES
LV DISTRIBUTION & TELECOMS LAYOUT

STATUS: TENDER | SCALE: 1:200



**Building Services
Consulting Engineers**

ION Consulting Engineers Ltd
Hill Barn, Grosvenor Court, Ampfield Hill,
Ampfield, Romsey, Hampshire, SO51 9BD
T: 01794 368693
F: 01794 368484
E: admin@ion-consulting.co.uk



©  THIS DRAWING IS COPYRIGHT
IT MAY NOT BE REPRODUCED, OR USED IN ANY FORM WITHOUT
WRITTEN PERMISSION OF ION CONSULTING ENGINEERS

DWG No: 20-026 E301 | REV: T1

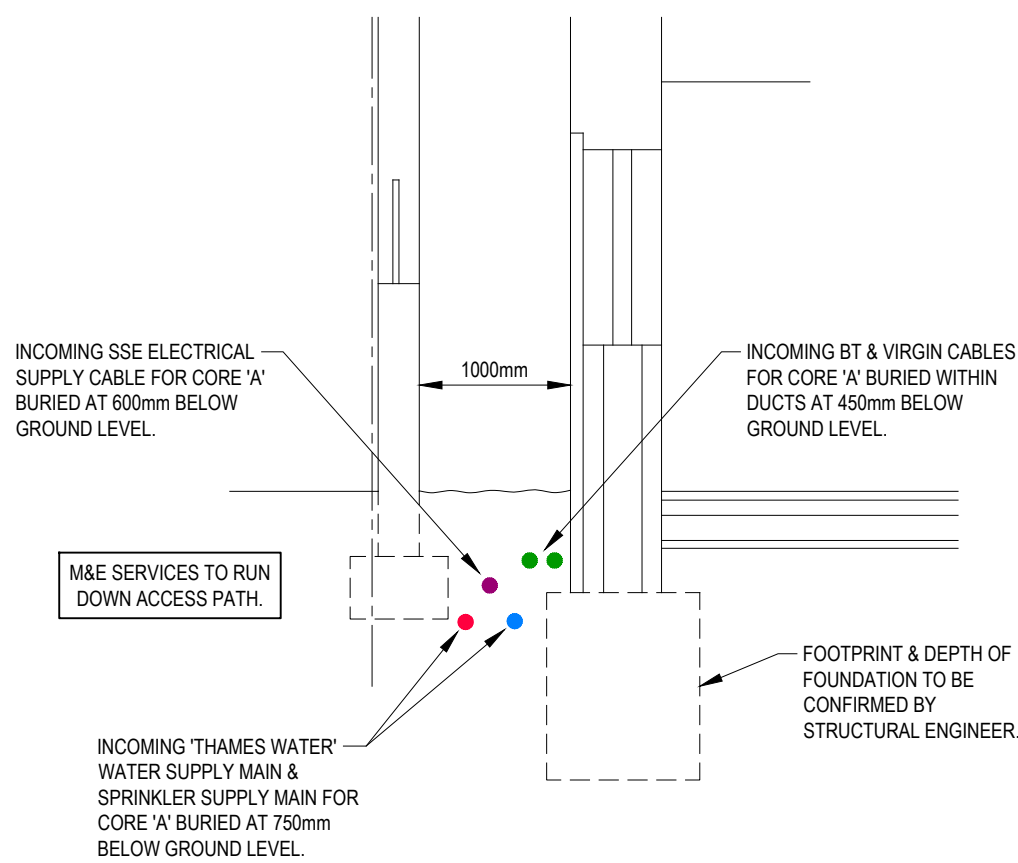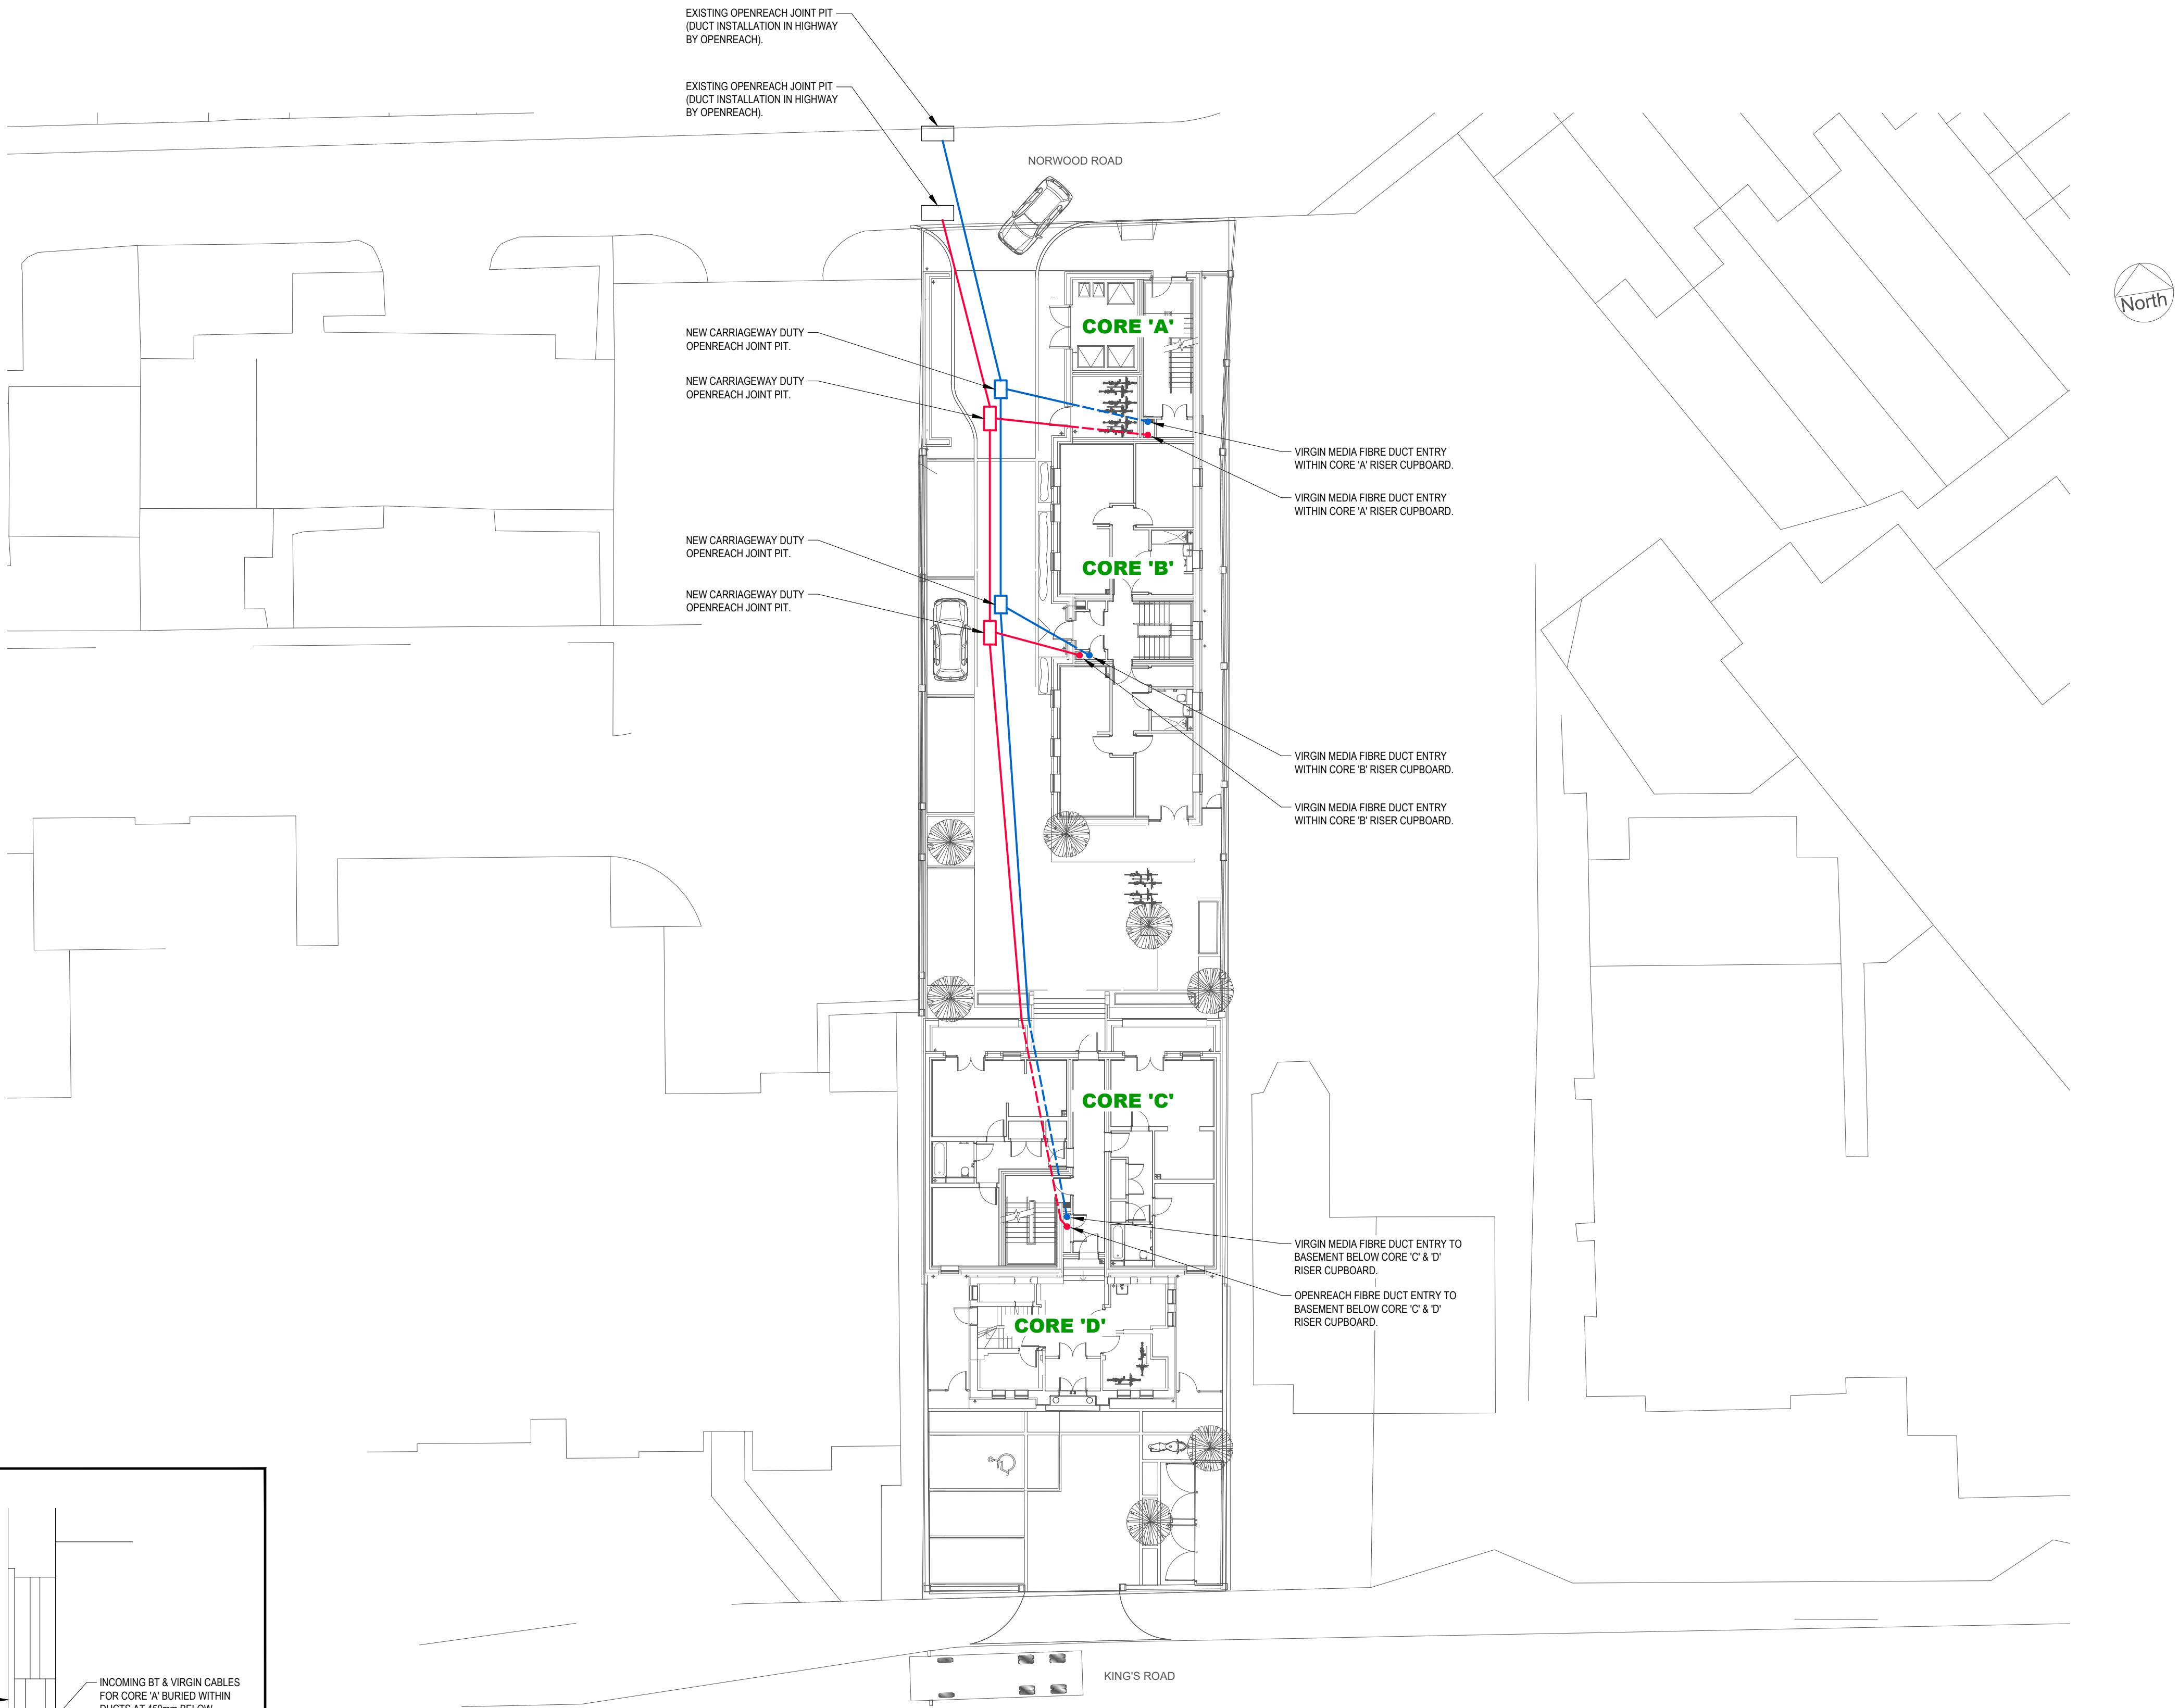

SECTION A-A
SCALE: NTS