

All dimensions and levels are to be checked on site by the contractor prior to preparation of shop drawings and commencement of works on site.


Do not scale from this drawing.

This drawing and the copyrights and patents therein are the property of ig9 and may not be used or reproduced without prior written consent.

This drawing is to be read in conjunction with all relevant consultant's and/or specialist's drawings/documents and any discrepancies or variations are to be notified to ig9 Limited before the affected work commences.

ELECTRICAL LEGEND

- SINGLE SWITCHED SOCKET OUTLET
- DOUBLE SWITCHED SOCKET OUTLET
- CONSUMER UNIT
- DOOR BELL SOUNDER
- DOOR BELL PUSH
- SMOKE DETECTOR
- HEAT DETECTOR
- CO DETECTOR
- PENDANT
- WALL LIGHT
- SECURITY LIGHTS
- LIGHT SWITCH
- PULL CORD
- ASSISTED LIVING PULL CORD
- SKY / BT OUTLET
- TV RETURN
- MECHANICAL EXTRACT FAN
- FLOURESCENT LIGHT
- DOOR ENTRYPHONE

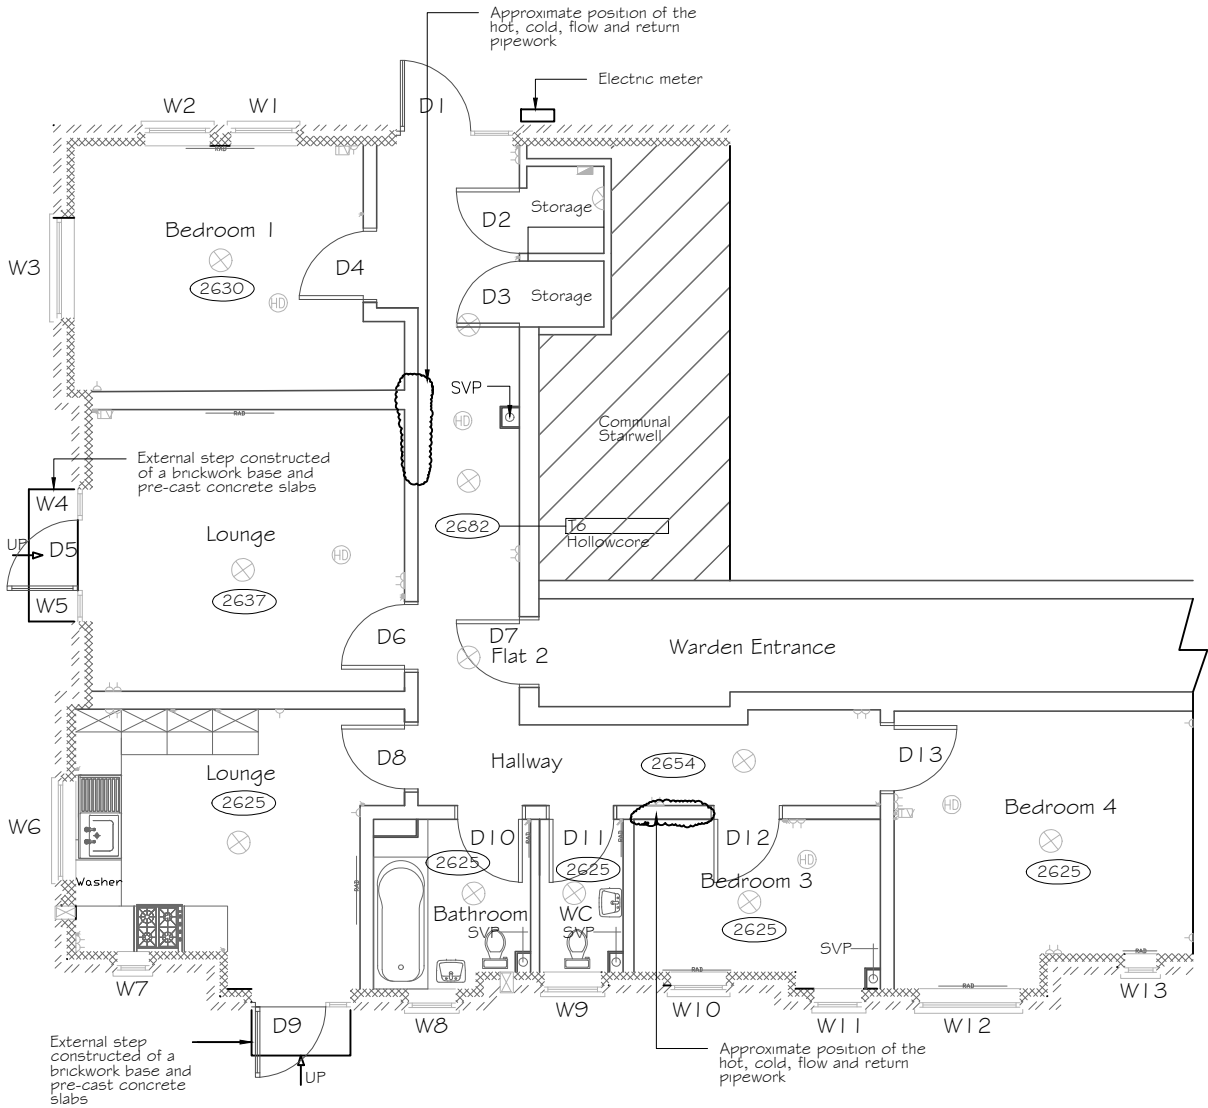

PI	Nov 20	Planning Application
Rev	Date	Description
ig9 ig9 11 Riverside Building Trinity Buoy Wharf 64 Orchard Place London E14 0PF t. 0207 538 4646 e. info@ig9.co.uk w. www.ig9.co.uk		
Building Surveying Project Management Cost Consultants Consulting Engineers Principal Designer		
Client Catalyst Housing Limited		
Project Subdivision of Wardens Flat 2 Asantewa House Fobney Street Reading RG1 6BZ		
Title Existing Ground Floor Plan		
Scale 1:100@A3	Drawn By GW	
Date November 2020	Checked By JB	
Drawing No. 2021-101956-003	Revision PI	