


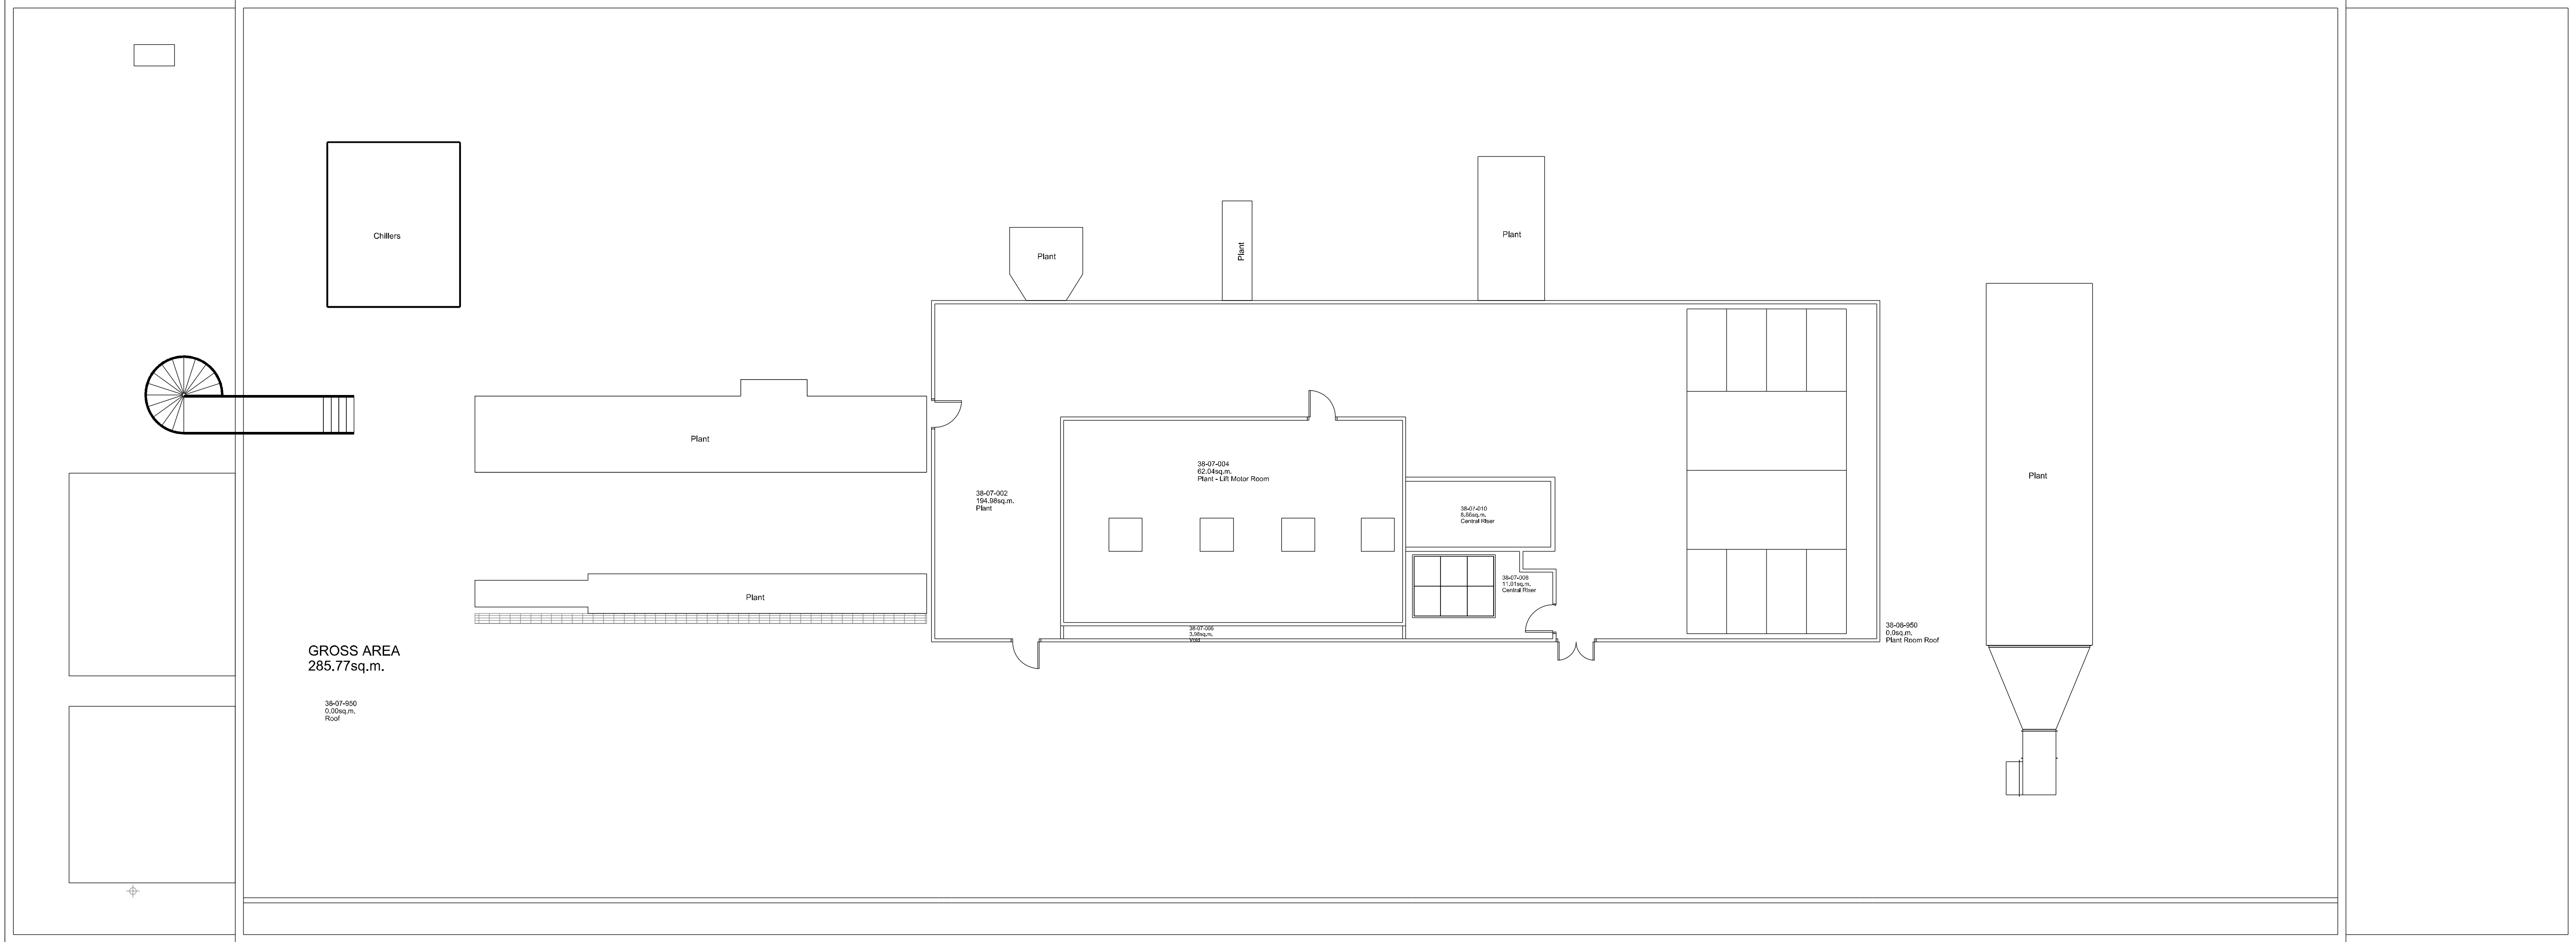

Maternity - Level 7

02	22/12/2020	TS	Updated for planning request
01	28/10/2020	TS	Title bar updated
00	26/10/2020	TS	Drawing number updated and alterations in discussion with M&E

REV	DATE	BY	DESCRIPTION	CHK	APP
-----	------	----	-------------	-----	-----

DRAWING STATUS:
EMPLOYER'S REQUIREMENTS

GBS health 
wsp
<http://www.wsp.com>

CLIENT:
**ROYAL BERKSHIRE HOSPITAL
NHS FOUNDATION TRUST**

PROJECT:
Maternity AHU

TITLE:
Existing Plan Maternity Level 7 Roof Plan

SCALE @ A1: 1:100@A1, 1:50@A3	CHECKED:	APPROVED:
PROJECT NUMBER:	DESIGNED: TS	DATE: 21.10.2020
DRAWING No: 6975/FY21-007/DWG/102	REV: 02	

