


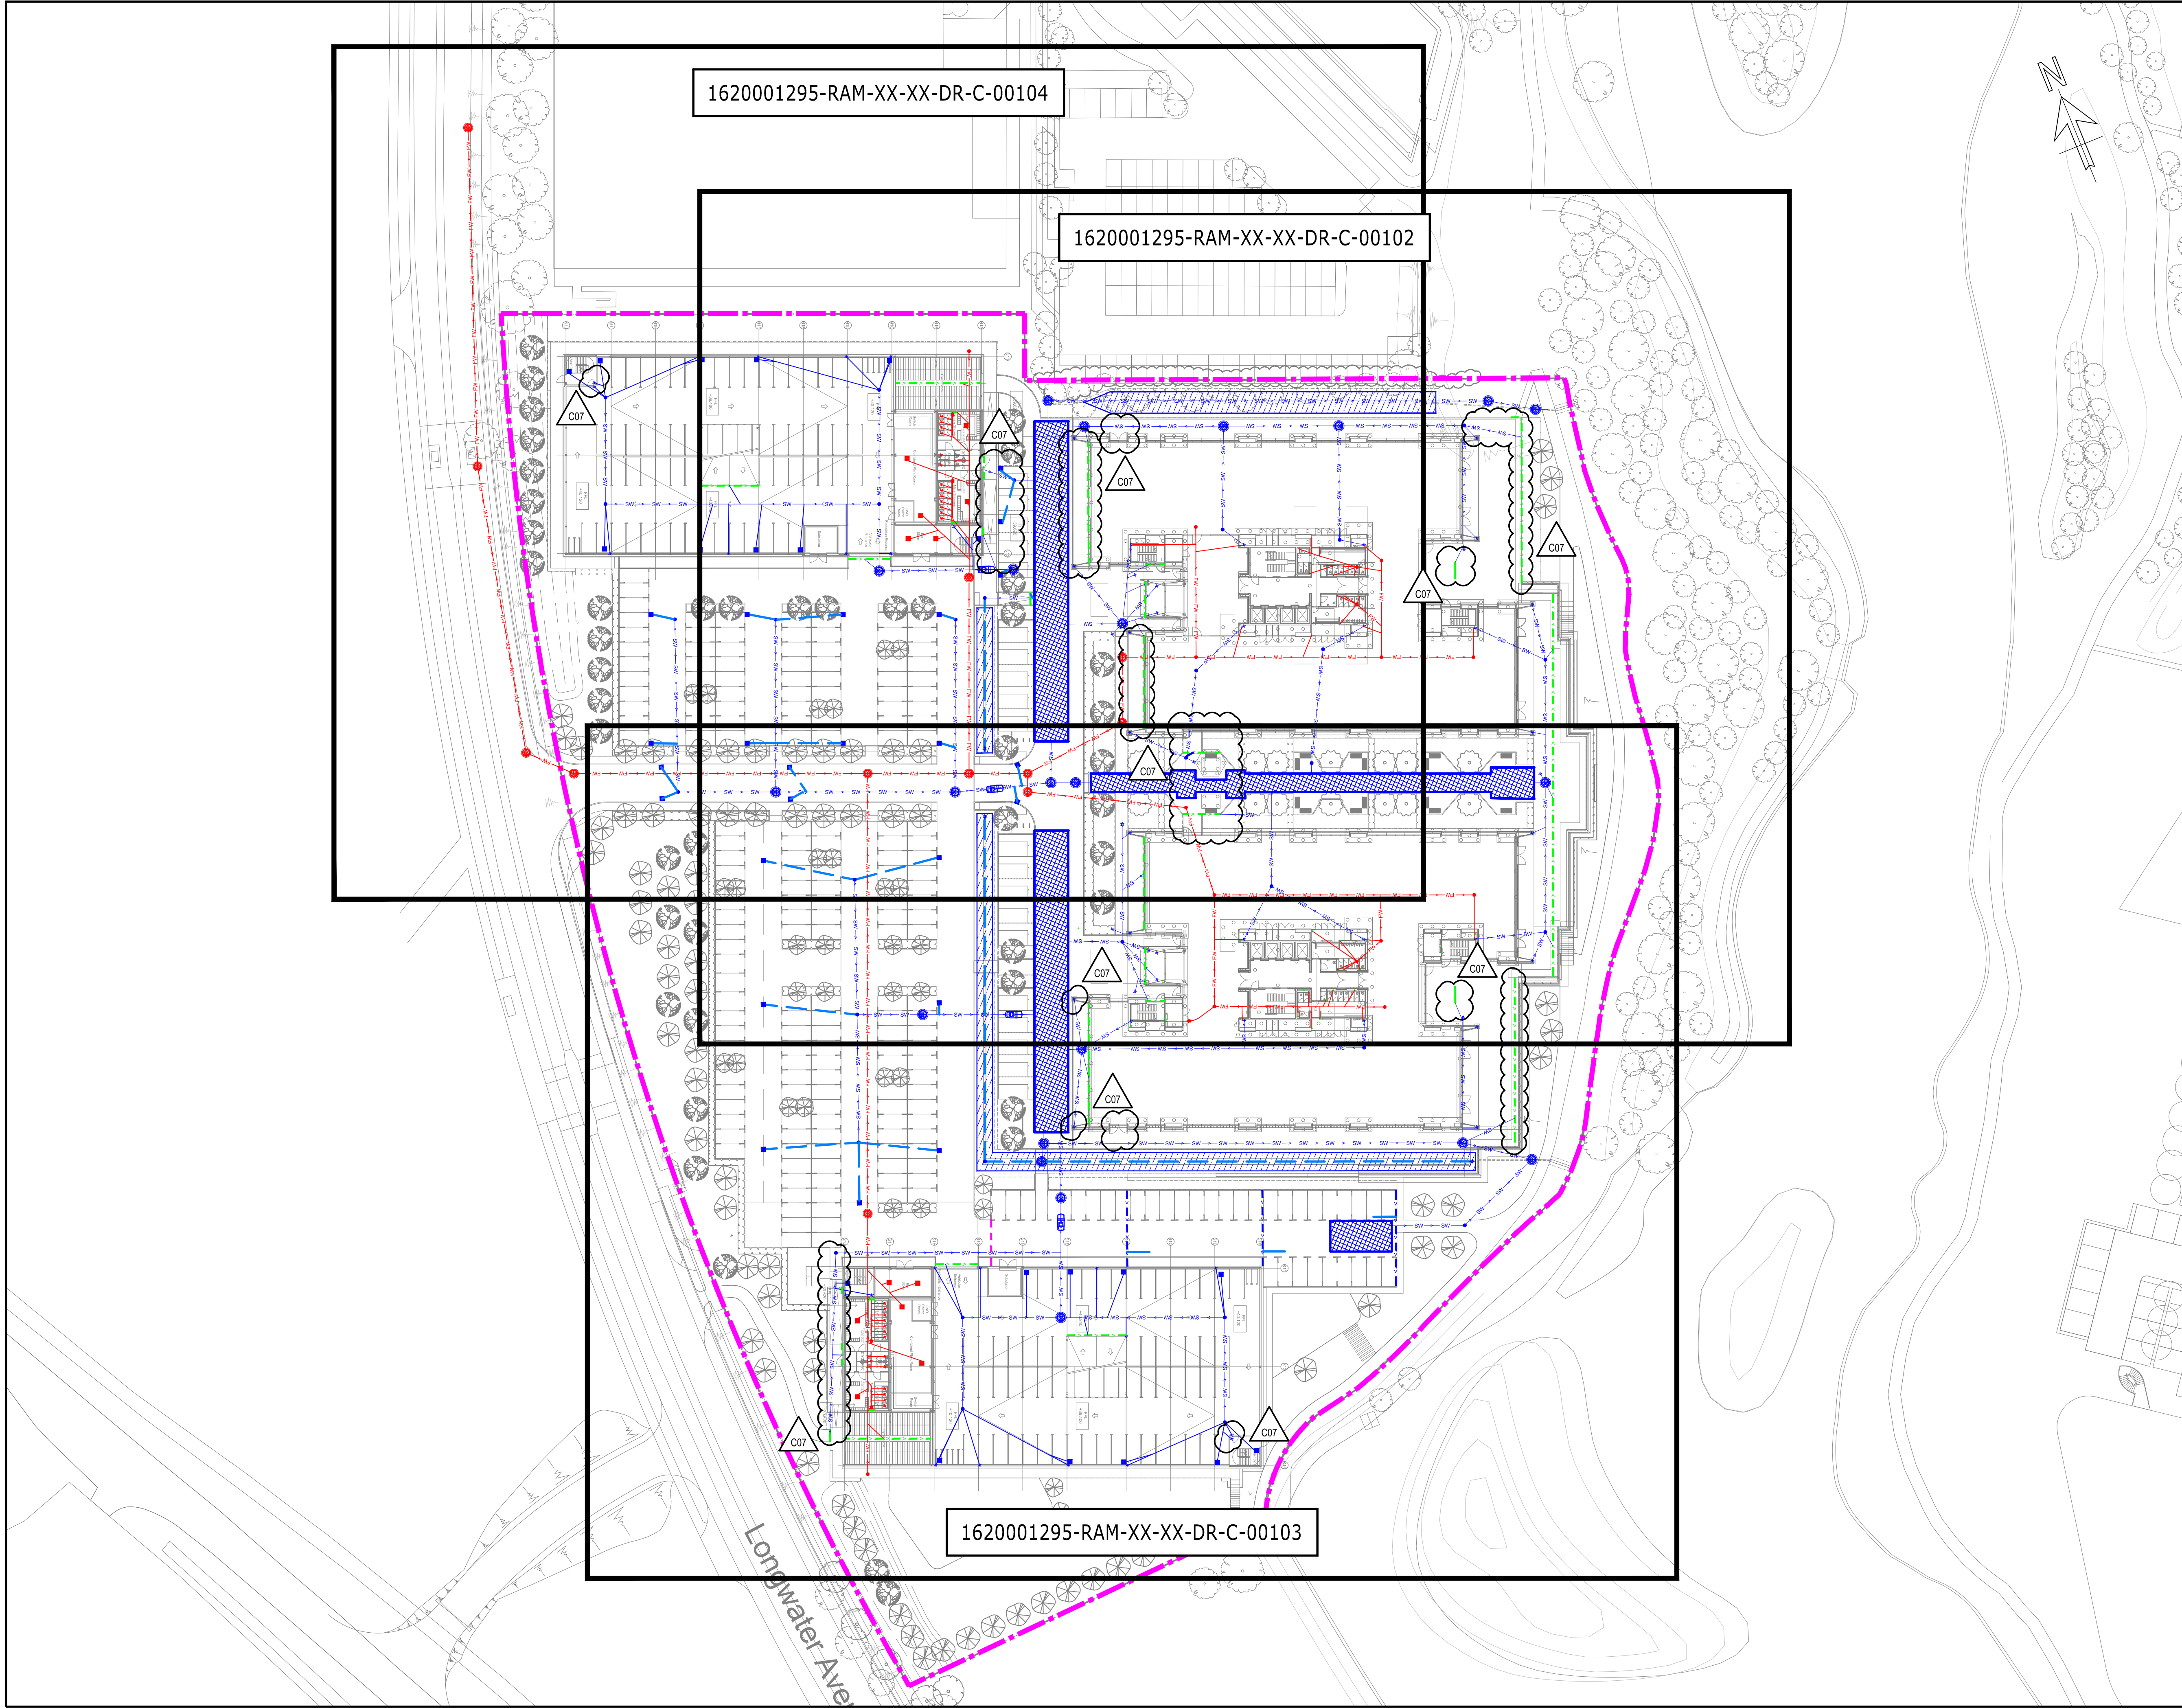

COPYRIGHT RAMBOLL UK LIMITED. ALL RIGHTS RESERVED. THIS DOCUMENT IS ISSUED FOR THE PARTY WHO COMMISSIONED IT AND FOR THE SPECIFIC PURPOSES CONNECTED WITH THE PROJECT ONLY. IT SHOULD NOT BE RELIED UPON BY ANY OTHER PARTY OR USED FOR ANY OTHER PURPOSE. RAMBOLL ACCEPTS NO RESPONSIBILITY OR LIABILITY WHICH MAY ARISE FROM RELIANCE OR USE OF THIS DOCUMENT OR THE DATA CONTAINED HEREIN BY ANY OTHER PARTY OR FOR ANY OTHER PURPOSE.

Notes

- THIS DRAWING IS NOT TO BE SCALED.
- THIS DRAWING IS TO BE READ IN CONJUNCTION WITH ALL RELEVANT ARCHITECTURAL, STRUCTURAL AND M&E DRAWINGS.
- THIS IS NOT AN INSTALLATION DRAWING NOR A CO-ORDINATION DRAWING.
- THIS DRAWING IS BASED ON,
 - 5224-PDP-SW-XX-DR-L-0001_WIP GA PLAN RECEIVED 20.09.2018 FROM PLACE LANDSCAPE ARCHITECTS.
 - RAMBOLL STRUCTURES DRAWING 'STRUCTURAL PLAN-FND LEVEL' ISSUED ON SEPTEMBER 2019.
 - HOARE LEA M&E DRAWINGS '0511850-HL-XX-GF-GA-P-520-0232' AND '0511850-HL-XX-GF-GA-P-520-0233' REVISION P1, DATED SEPTEMBER 2019.
- REFER TO RAMBOLL DRAWINGS 1620001295-RAM-XX-XX-DR-C-00400 TO 00410 FOR DRAINAGE DETAILS.
- PETROL INTERCEPTORS TO BE FITTED WITH HIGH LEVEL ALARM WITH EXTERNAL POWER SUPPLY AND AIR VENT.

KEY:

- SITE BOUNDARY
- SW SURFACE WATER DRAIN
- FW FOUL WATER DRAIN
- ACO CHANNEL DRAIN
- FILCOTEN GREEN CHANNEL DRAIN
- PERFORATED DRAINAGE PIPE
- SURFACE WATER MANHOLE
- FOUL WATER MANHOLE
- SURFACE WATER GULLY
- FOUL WATER GULLY
- IMPERMEABLE MEMBRANE
- ATTENUATION TANK
- SWALE
- RAIN WATER POINT
- SOIL VENT PIPE
- RODDING EYE

C07	CONSTRUCTION ISSUE	29.05 2020	NK JW	PC
C06	CONSTRUCTION ISSUE	06.03 2020	NK JW	PC
C05	CONSTRUCTION ISSUE	18.12 2019	NK JW	PC
C04	CONSTRUCTION ISSUE	26.09 2019	MES JW	PC
C03	CONSTRUCTION ISSUE	15.08 2019	MES JW	PC
C02	CONSTRUCTION ISSUE	15.04 2019	MES JW	PC
C01	CONSTRUCTION ISSUE	22.03 2019	MES JW	PC
Rev	Description	Date	By Chk	App

CONSTRUCTION

400 LONGWATER AVENUE
PLOT 3.2

tel 020 7631 5291 london@ramboll.co.uk
www.ramboll.co.uk

FOUL & SURFACE WATER
DRAINAGE LAYOUT
KEY PLAN

Project No: 1620001295	Scale (@A1): 1:500	Drawn: MES	Date: AUG 2018
Drawing No: RAM-XX-XX-DR-C-00101	Rev: C07		

29/05/2020 12:27:00