


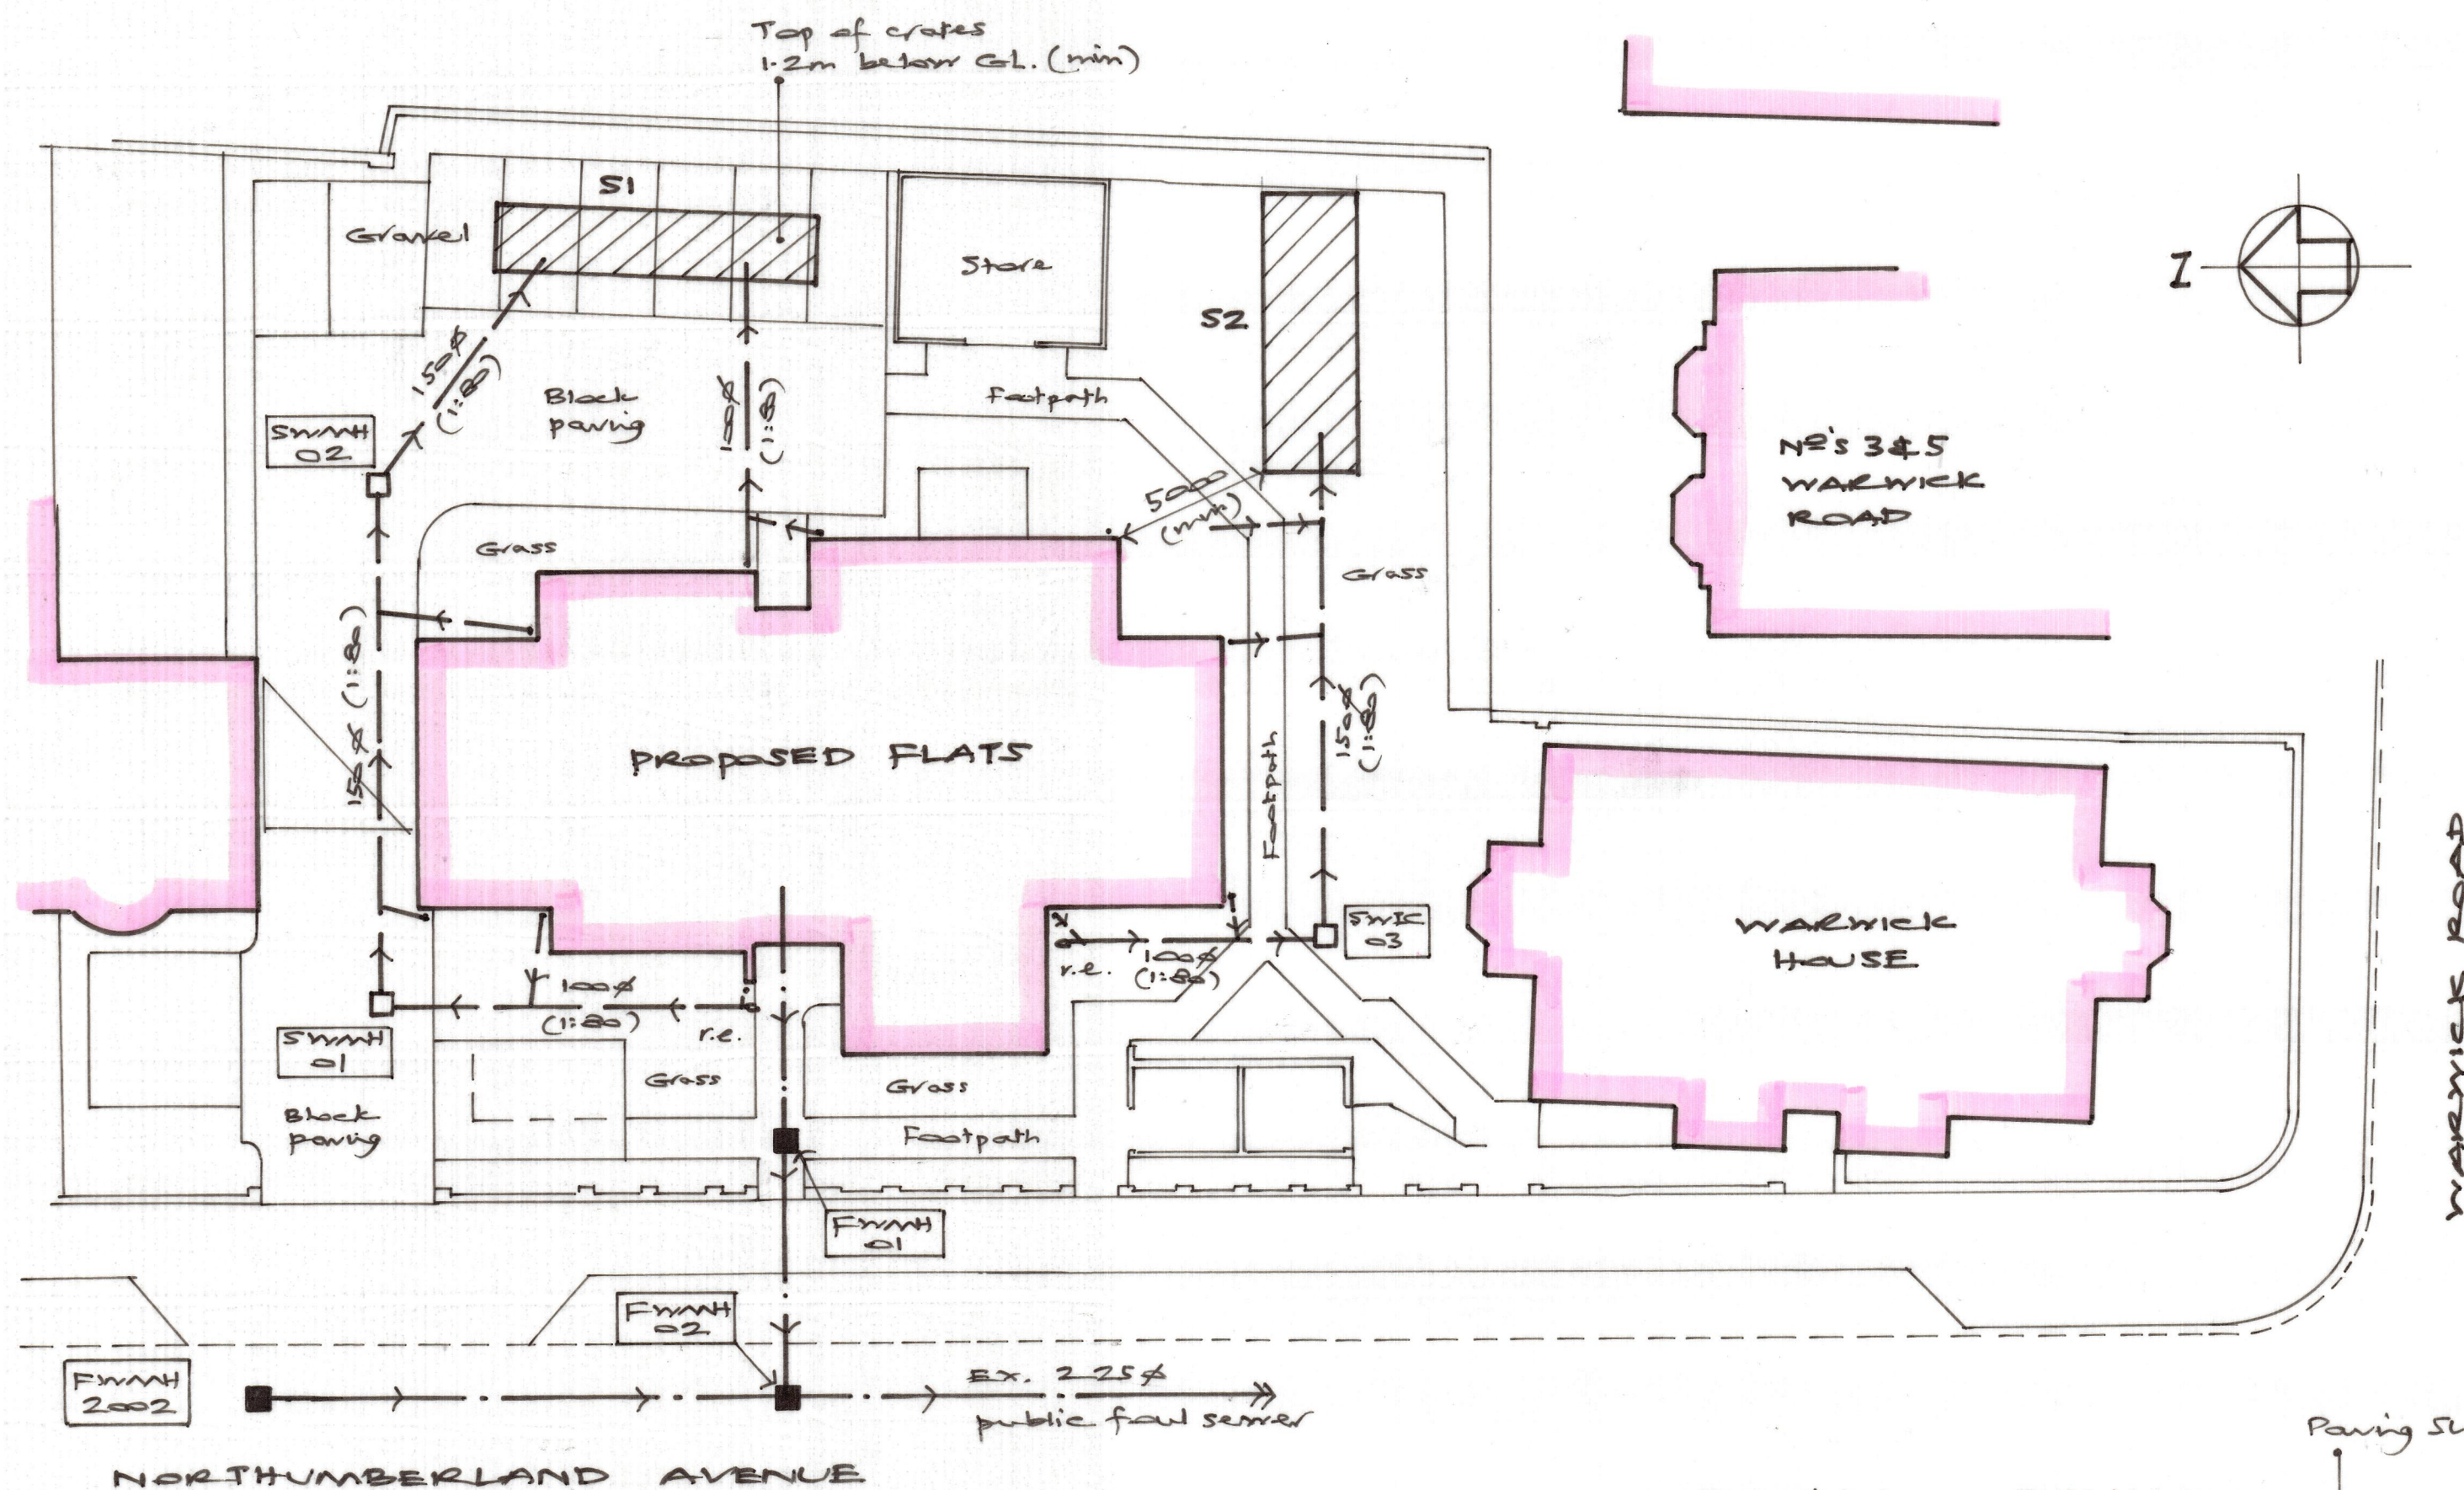

Note:
All dimensions must be checked on site
and not scaled from this drawing.

Key:-

- Storm water drain
- Foul water drain
- Storm water manhole
- Foul water manhole
- Rodding eye
- r.e. Rodding eye
- ▨ Soakaway

- S1 - 10m x 2m x 0.8m deep below lowest incoming drain. Warin Aquacell Plus Crates
- S2 - 9m x 3m x 0.8m deep below lowest incoming drain. Warin Aquacell Prime Crates

A		
	Date	Revision

© copyright

stephen penfold associates
civil and structural engineers
unit 8, northam business centre, princes street, northam
southampton, hants, so14 5rp
tel: (023) 8023 2346 email: stephen@spa-engineers.co.uk
fax: (023) 8033 0393 email: james@spa-engineers.co.uk

Client

CREATIVE SUPPORT

Job Title

**PROPOSED DEVELOPMENT
WARWICK ROAD/
NORTHUMBERLAND AVE
READING
BERKS**


Drawing Title

**PROPOSED SUDS
STORM WATER
DRAINAGE LAYOUT**


Scale 1:200 @ A2

Date Nov '20 Drawn by SP.


Drg. No. 20170/100 Rev.

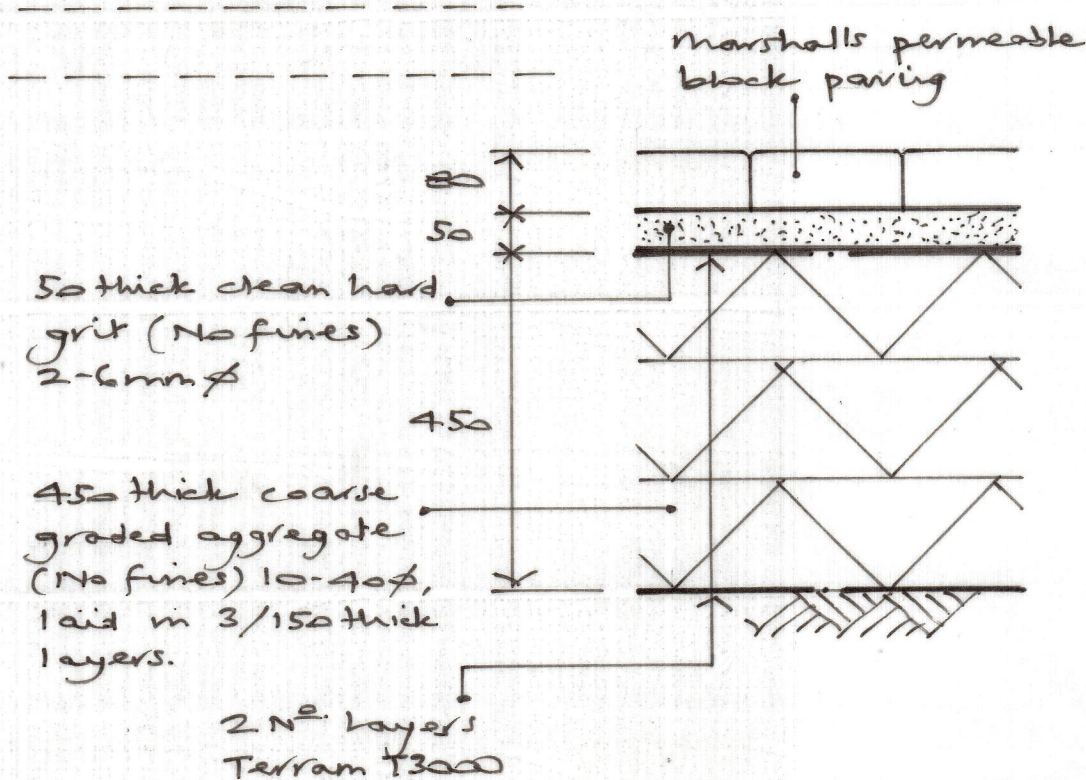

**PERMEABLE BLOCK
PAVING CONSTRUCTION DETAIL**
(1:10)

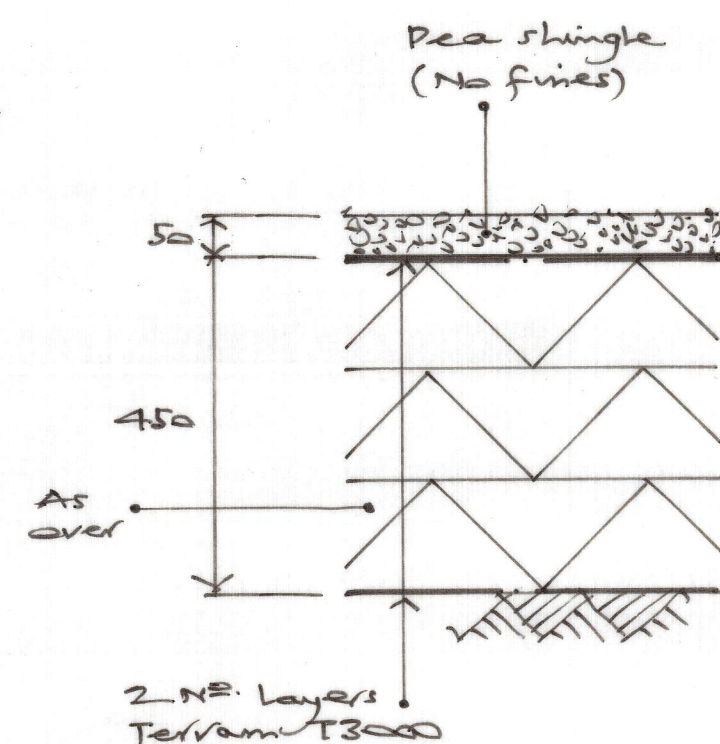

**GRAVEL PARKING
CONSTRUCTION DETAIL**
(1:10)

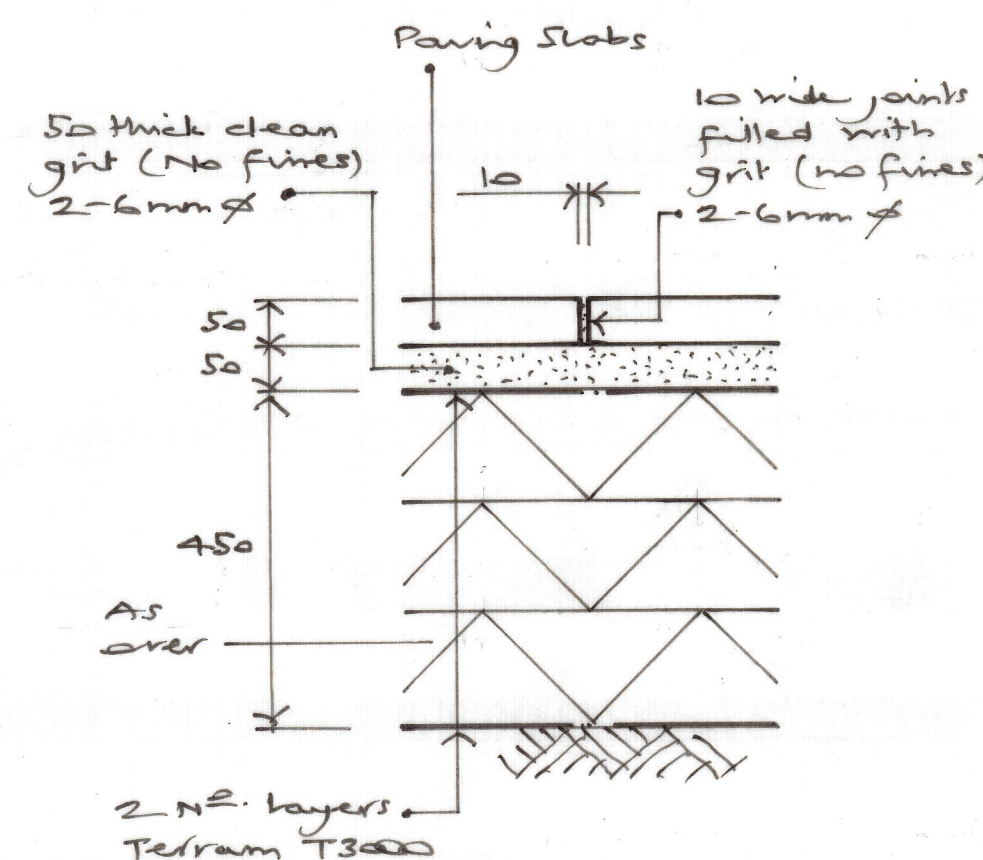

**FOOTPATH
CONSTRUCTION DETAIL**
(1:10)