
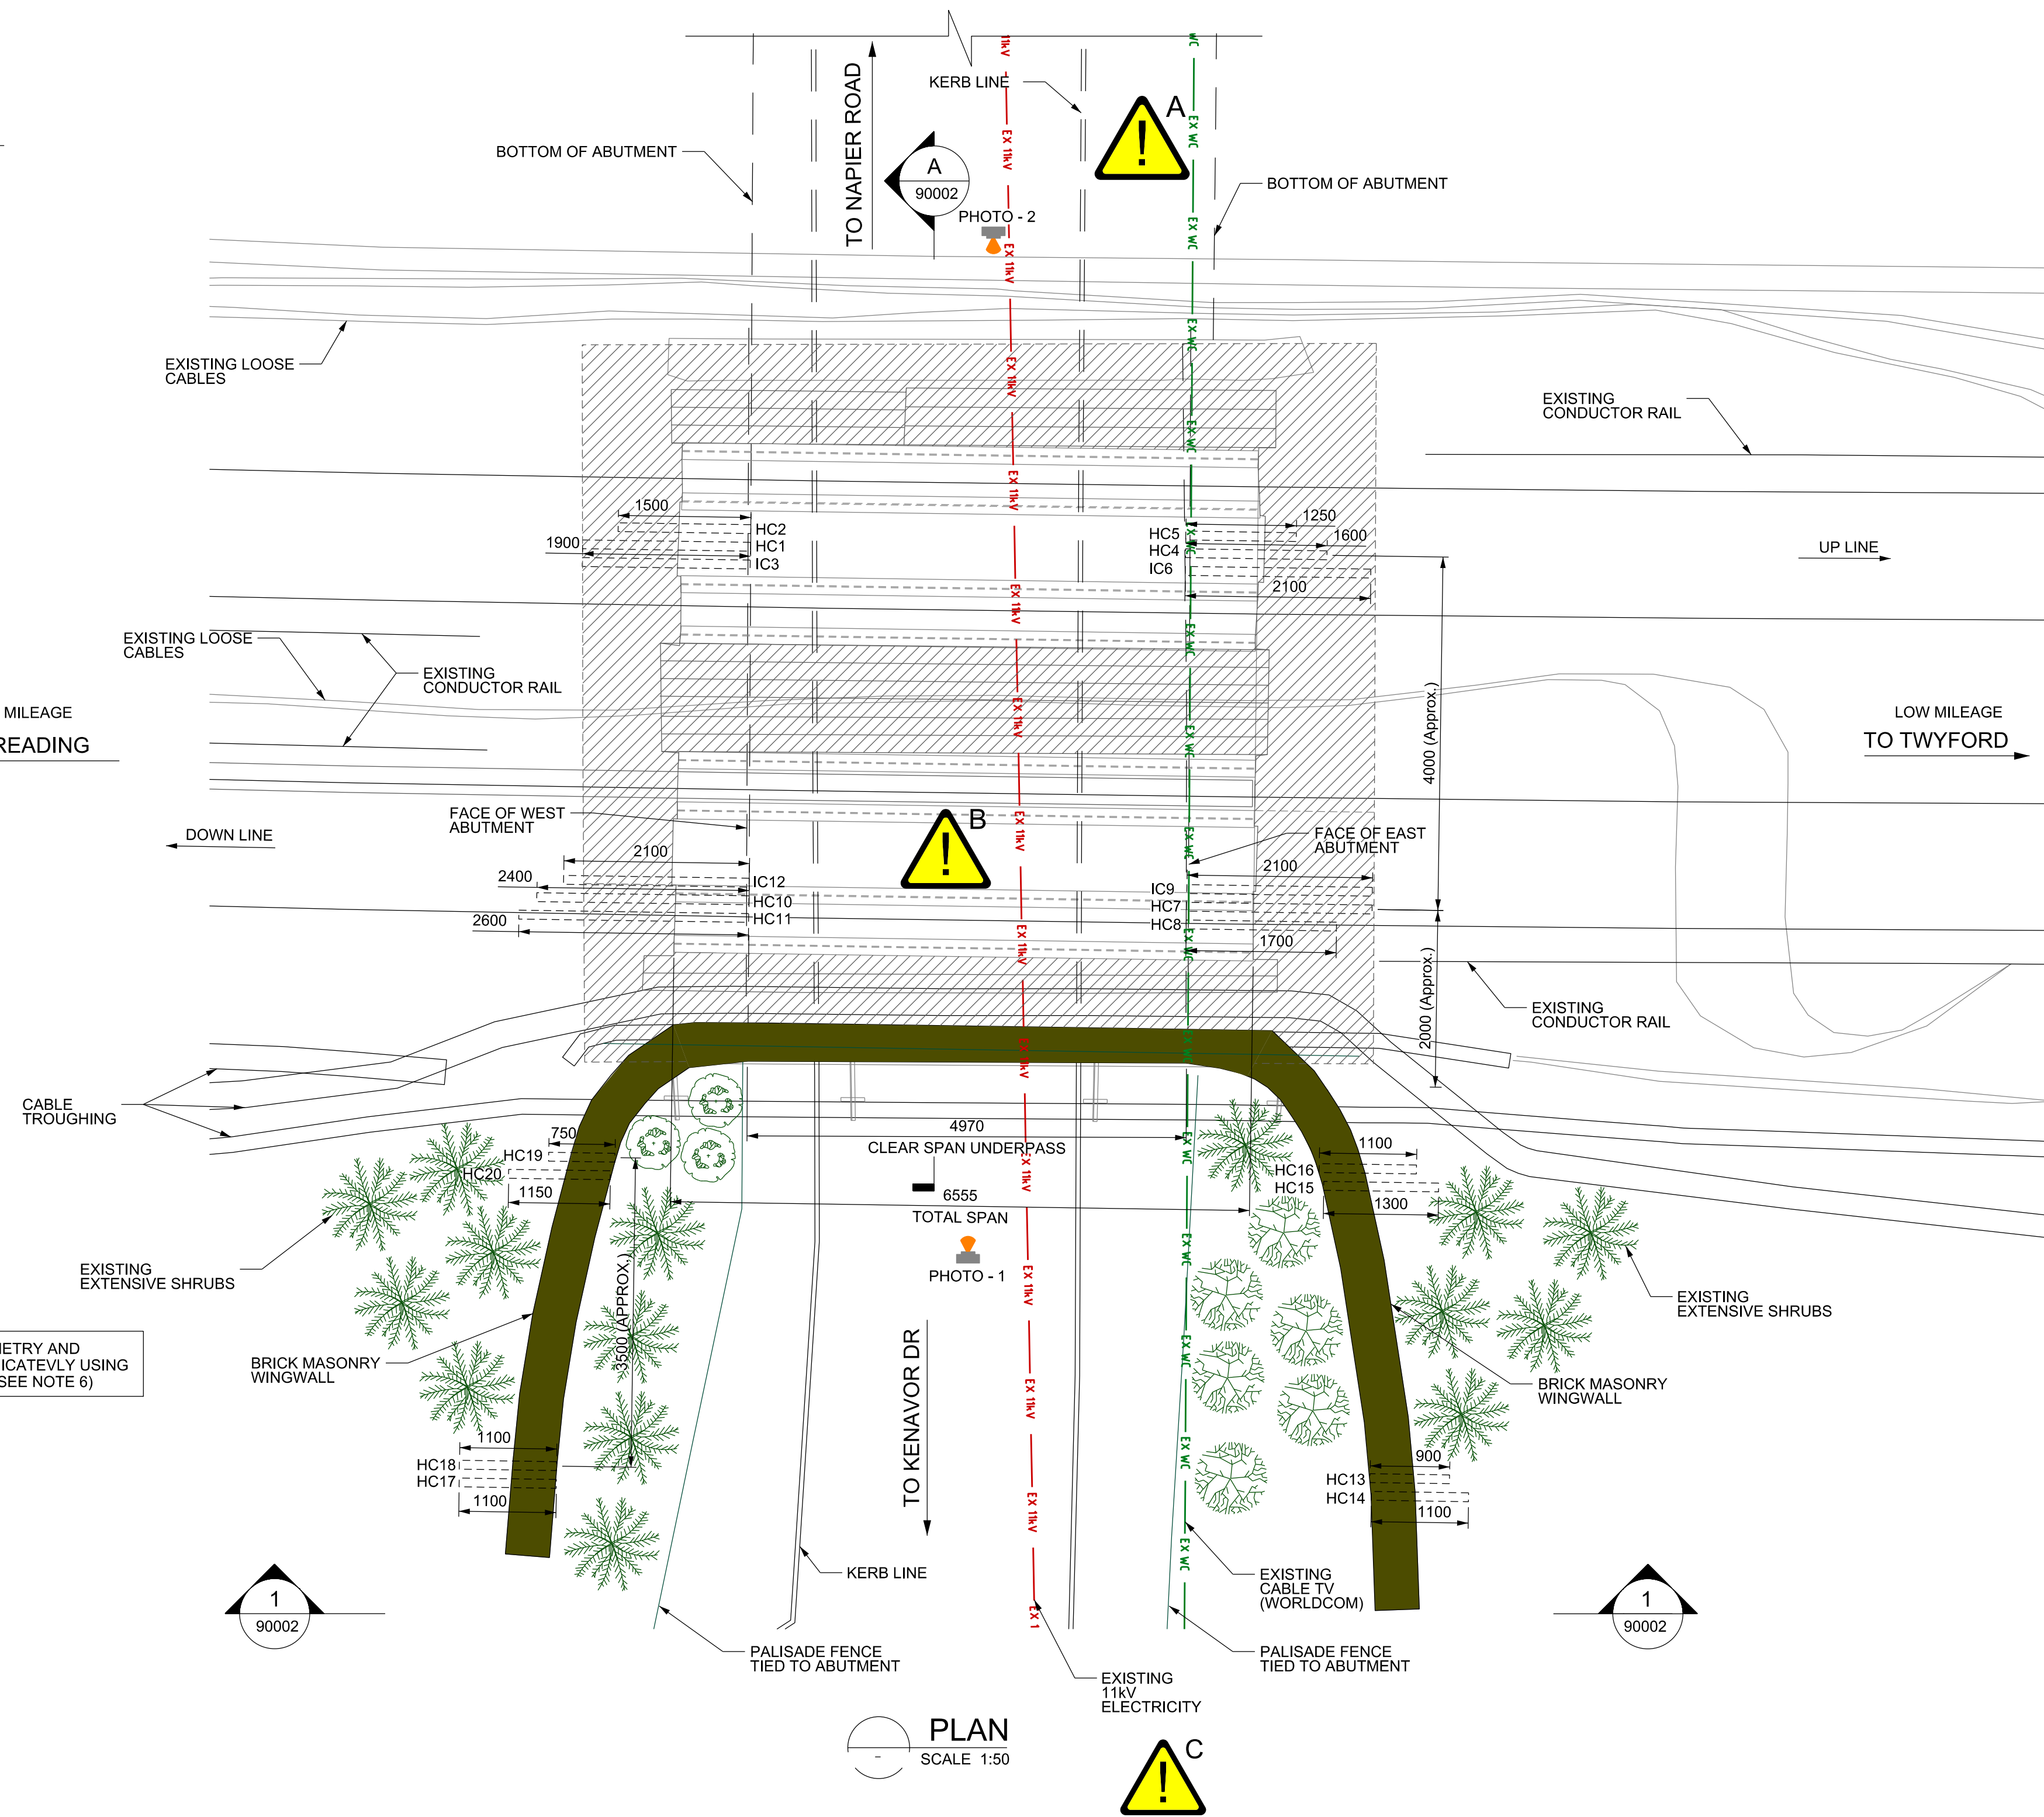


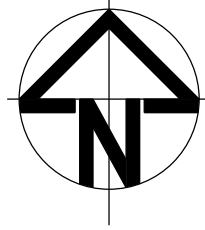

ABUTMENT / WINGWALL GEOMETRY AND FOUNDING DEPTH SHOWN INDICATEVLY USING CORING DATA INFORMATION (SEE NOTE 6)

PLAN
SCALE 1:50

HAZARD SUMMARY TABLE		
	SIGNIFICANT DESIGNER'S IDENTIFIED HAZARDS	LIFE SAVING RULES
	'EVERYDAY' LOW RISK HAZARDS AND THOSE HAZARDS WHICH SHOULD BE OBVIOUS TO A COMPETENT CONTRACTOR HAVE NOT BEEN INDICATED ON THIS DRAWING. SHOULD ANY ADDITIONAL HAZARDS BE IDENTIFIED DURING THE COURSE OF THE WORKS, THE CONTRACTOR SHALL NOTIFY ALL RELEVANT MEMBERS OF THE PROJECT TEAM	
	DRUGS / ALCOHOL TRAINING & COMPETENCY NO MOBILE PHONES CORRECT EQUIPMENT OBEY DRIVING RULES	
	EARTHING EXCLUSION ZONE PLANS AND PERMITS SAFETY HARNESS AT HEIGHT ISOLATION	
A	CAPACITY INFORMATION OF ADJACENT MASONRY ARCH BRIDGE UNKNOWN.	
B	RISK OF BRITTLE FRACTURE OF CAST IRON	
C	WORKING ADJACENT TO BURIED SERVICES. PROTECTION/ISOLATION OF SERVICES TO BE COMPLETED PRIOR TO WORKS.	
• FOR MORE DETAILED INFORMATION PLEASE REFER TO THE DESIGNERS H&S RISK ASSESSMENT REF.: 10010855-ARC-HNP-UB-RA-C-RP1001.		

- NOTES:**
- ALL DIMENSIONS ARE IN MILLIMETRES AND LEVELS ARE IN METRES AOD UNLESS NOTED OTHERWISE.
 - DO NOT SCALE FROM DRAWING, USE FIGURED DIMENSIONS ONLY.
 - DRAWING PRODUCED BASED ON TOPOGRAPHICAL SURVEY CONDUCTED BY PLOWMAN CRAVEN ON BEHALF OF OSBORNE ON SEPTEMBER 2019. (DWG No. 43321T-01-1)
 - SERVICE INFORMATION PRODUCED BY PREMIER ENERGY (AUGUST 2019).
 - THIS DRAWING TO BE READ IN CONJUNCTION WITH THE FORM 001 DOCUMENT, THE DESIGNERS HAZARD RECORD AND ALL FORM 001 DRAWINGS.
 - CORING TRIAL PIT DETAILS OBTAINED FROM TEST CORE RESULTS SUBMITTED BY MOHAN BUILDING SERVICES LTD DATED 15 SEPTEMBER 2019 ON BEHALF OF OSBORNE.
 - ANY DISCREPANCIES BETWEEN THE INFORMATION GIVEN ARE TO BE BROUGHT TO THE ATTENTION OF THE ENGINEER AS SOON AS POSSIBLE.

KEY:

HC - HORIZONTAL CORE
IC - INCLINED CORE
EX 11kV - EXISTING 11kV ELECTRICITY
EX WC - EXISTING CABLE TV (WORLDCOM)



PHOTO - 1 SOUTH ELEVATION
SCALE: NTS



PHOTO - 2 NORTH ELEVATION
SCALE: NTS



LOCATION MAP
SCALE: NTS
(OS GRID REFERENCE: SU 7246773748)

Rev	Date	Description	Drawn	Check	Approv
A01	24.01.20	FORM 001 FOR APPROVAL	NA	KC	JM

NetworkRail



PROJECT:
WESSEX MULTI-FUNCTIONAL FRAMEWORK

ARCADIS Design & Consultancy for natural and built assets
Registered office: Arcadis House, 34 York Way, London N1 9AB
Registered office: Arcadis House, 34 York Way, London N1 9AB
Tel: +44 (0)20 7812 2000
www.arcadis.com

TITLE:
HUNTLEY AND PALMERS UNDERBRIDGE EXISTING GENERAL ARRANGEMENT PLAN

Designed	MB.PRASHANTH	Signed		Date	24.01.2020
Drawn	A.NITHIN	Signed		Date	24.01.2020
Checked	C.KARTHIK	Signed		Date	24.01.2020
Approved	J.MARTIN	Signed		Date	24.01.2020
Scale:	As shown @ A1	Datum:	AOD		
Original Size:	A1	Grid:	SU 7246774		
ELR:	RDG2	Mileage:	68 miles 489 yards		
Suitability Code:	S4	Project Number:	10035850		

Suitability Description:

FORM 001 FOR APPROVAL

Drawing Number:	041126-ARC-DRG-ECV-90001	Revision:	A01
-----------------	--------------------------	-----------	-----