
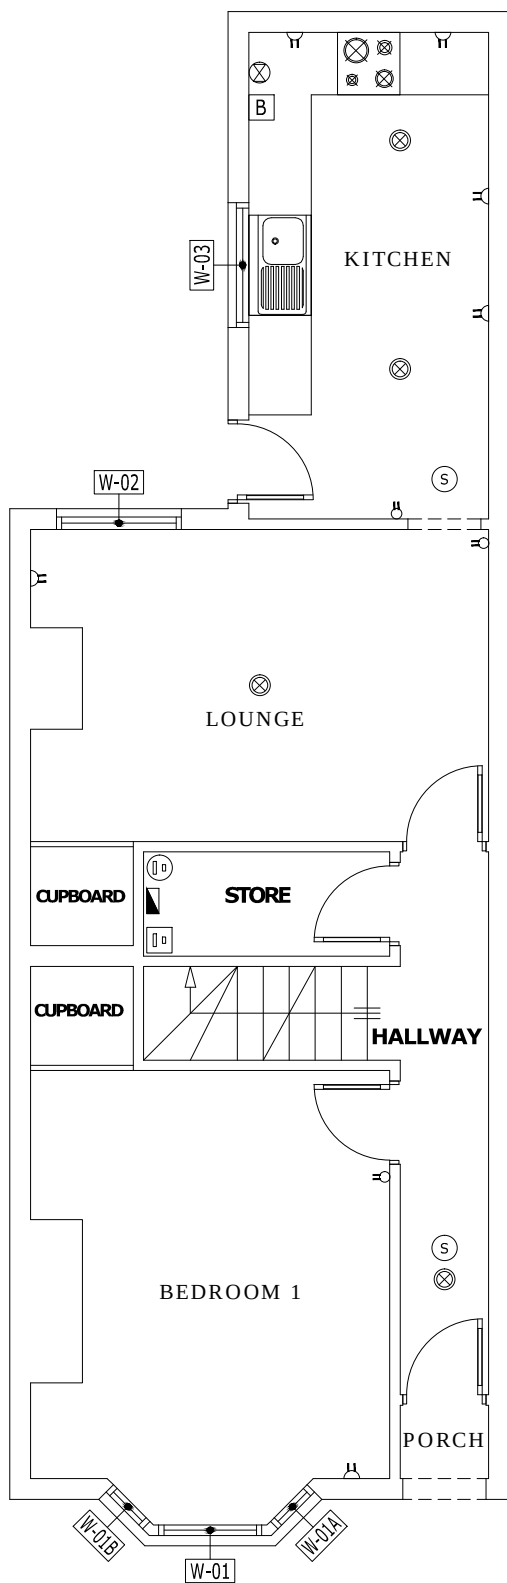


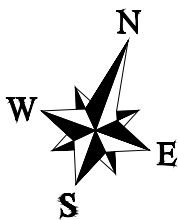

LEGEND:-

	Water Stop Cock
	Electric Board
	Electric Meter
	Gas Meter
	Boiler Location
	Smoke Alarm
	Single Light Switch
	Double Light Switch
	Single Plug Socket
	Double Plug Socket
	Ceiling Light

W. TYPE	WIDTH	HEIGHT	SILL
W-01	---	---	---
W-01A	---	---	---
W-01B	---	---	---
W-02	990	1670	760
W-03	1120	1130	1160



279 London Road
Reading RG1 3NZ, UK

RDG279

Drawing Title:

Ground Floor Plan

Scale:	REV. NO:	Drawn:
1:50	01	M.S.

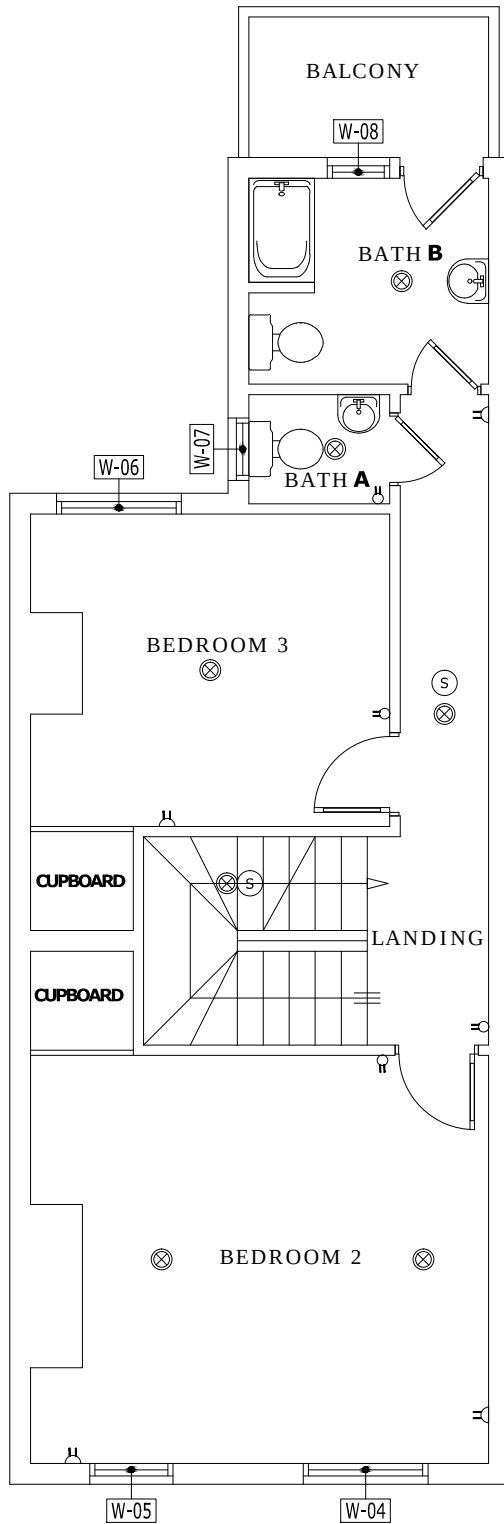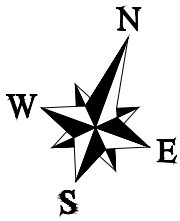

LEGEND:-

	Water Stop Cock
	Electric Board
	Electric Meter
	Gas Meter
	Boiler Location
	Smoke Alarm
	Single Light Switch
	Double Light Switch
	Single Plug Socket
	Double Plug Socket
	Ceiling Light

W. TYPE	WIDTH	HEIGHT	SILL
W-04	830	1750	750
W-05	830	1750	750
W-06	1040	1690	660
W-07	400	840	1370
W-08	560	990	1000


279 London Road
Reading RG1 3NZ, UK

RDG279

Drawing Title:

First Floor Plan

Scale:	REV. NO:	Drawn:
1:50	01	M.S.

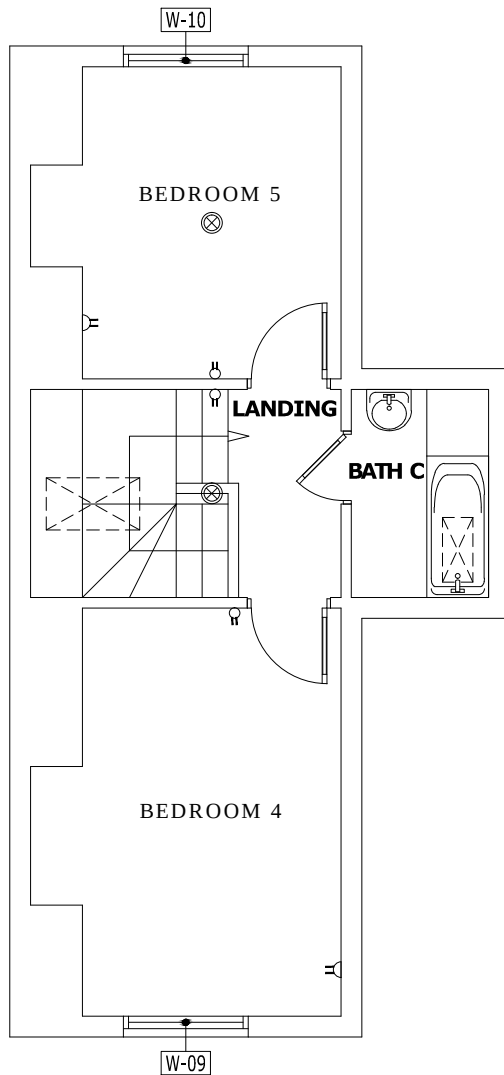

	Water Stop Cock
	Electric Board
	Electric Meter
	Gas Meter
	Boiler Location
	Smoke Alarm
	Single Light Switch
	Double Light Switch
	Single Plug Socket
	Double Plug Socket
	Ceiling Light

279 London Road Reading RG1 3NZ, UK		
RDG279		
Drawing Title:		
Second Floor Plan		
Scale:	REV. NO:	Drawn:
1:50	01	M.S.