
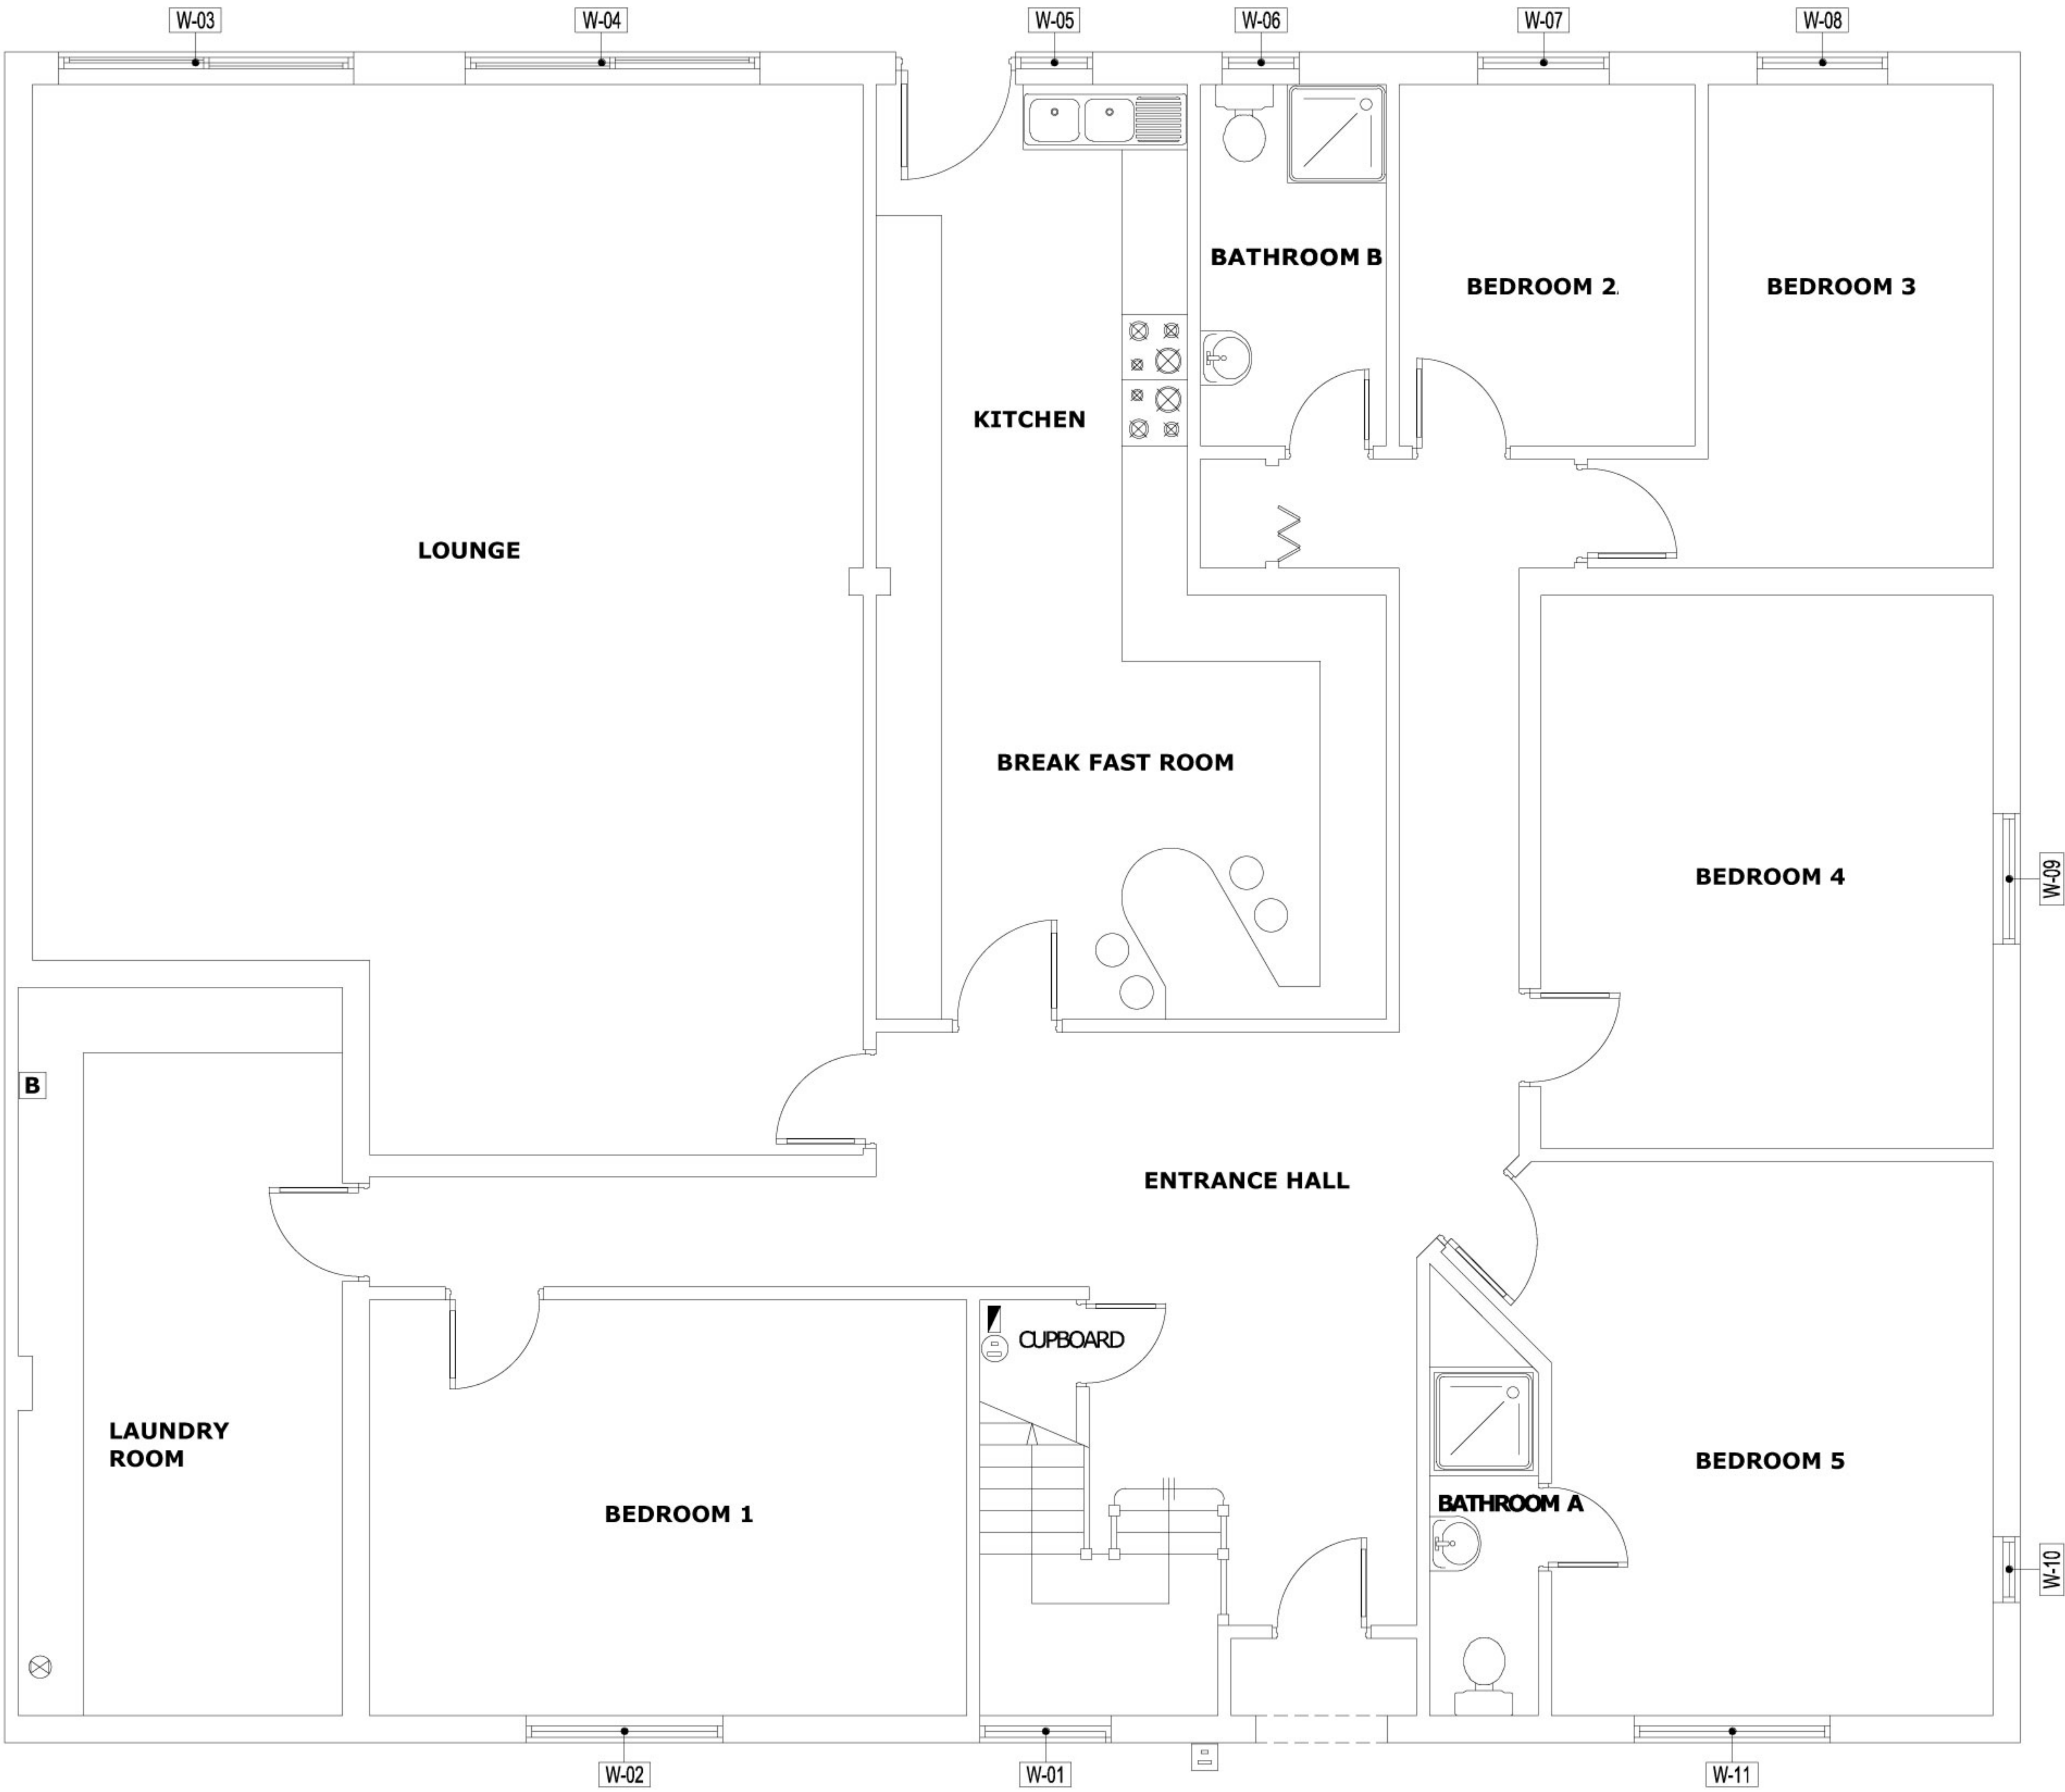


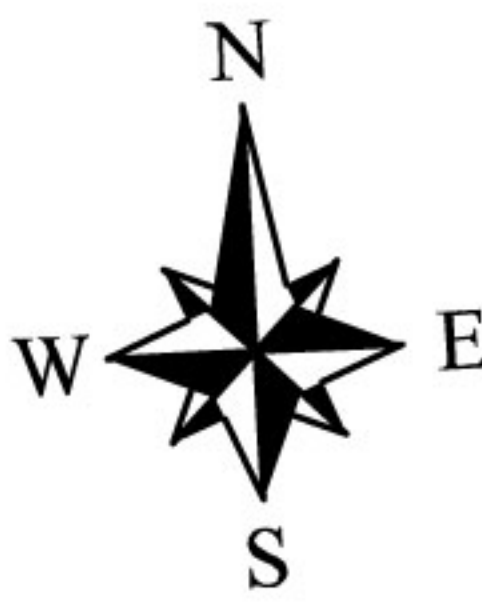

LEGEND:-	
	Water Stop Cock
	Electric Board
	Electric Meter
	Gas Meter
	Boiler Location
	Smoke Alarm
	Single Light Switch
	Double Light Switch
	Single Plug Socket
	Double Plug Socket
	Ceiling Light


W. TYPE	WIDTH	HEIGHT	SILL
W-01	102	167	---
W-02	152	158	---
W-03	113	213	---
W-04	115	213	---
W-05	---	---	---
W-06	55	106	---
W-07	107	152	---
W-08	105	152	---
W-09	101	159	---
W-10	53	159	---
W-11	150	159	---

50 Cressingham Road
Reading, RG2 7JR, UK

RDG050

Drawing Title:
Ground Floor Plan

Scale: 1:50	REV. NO: 01	Drawn: M.S.
----------------	----------------	----------------

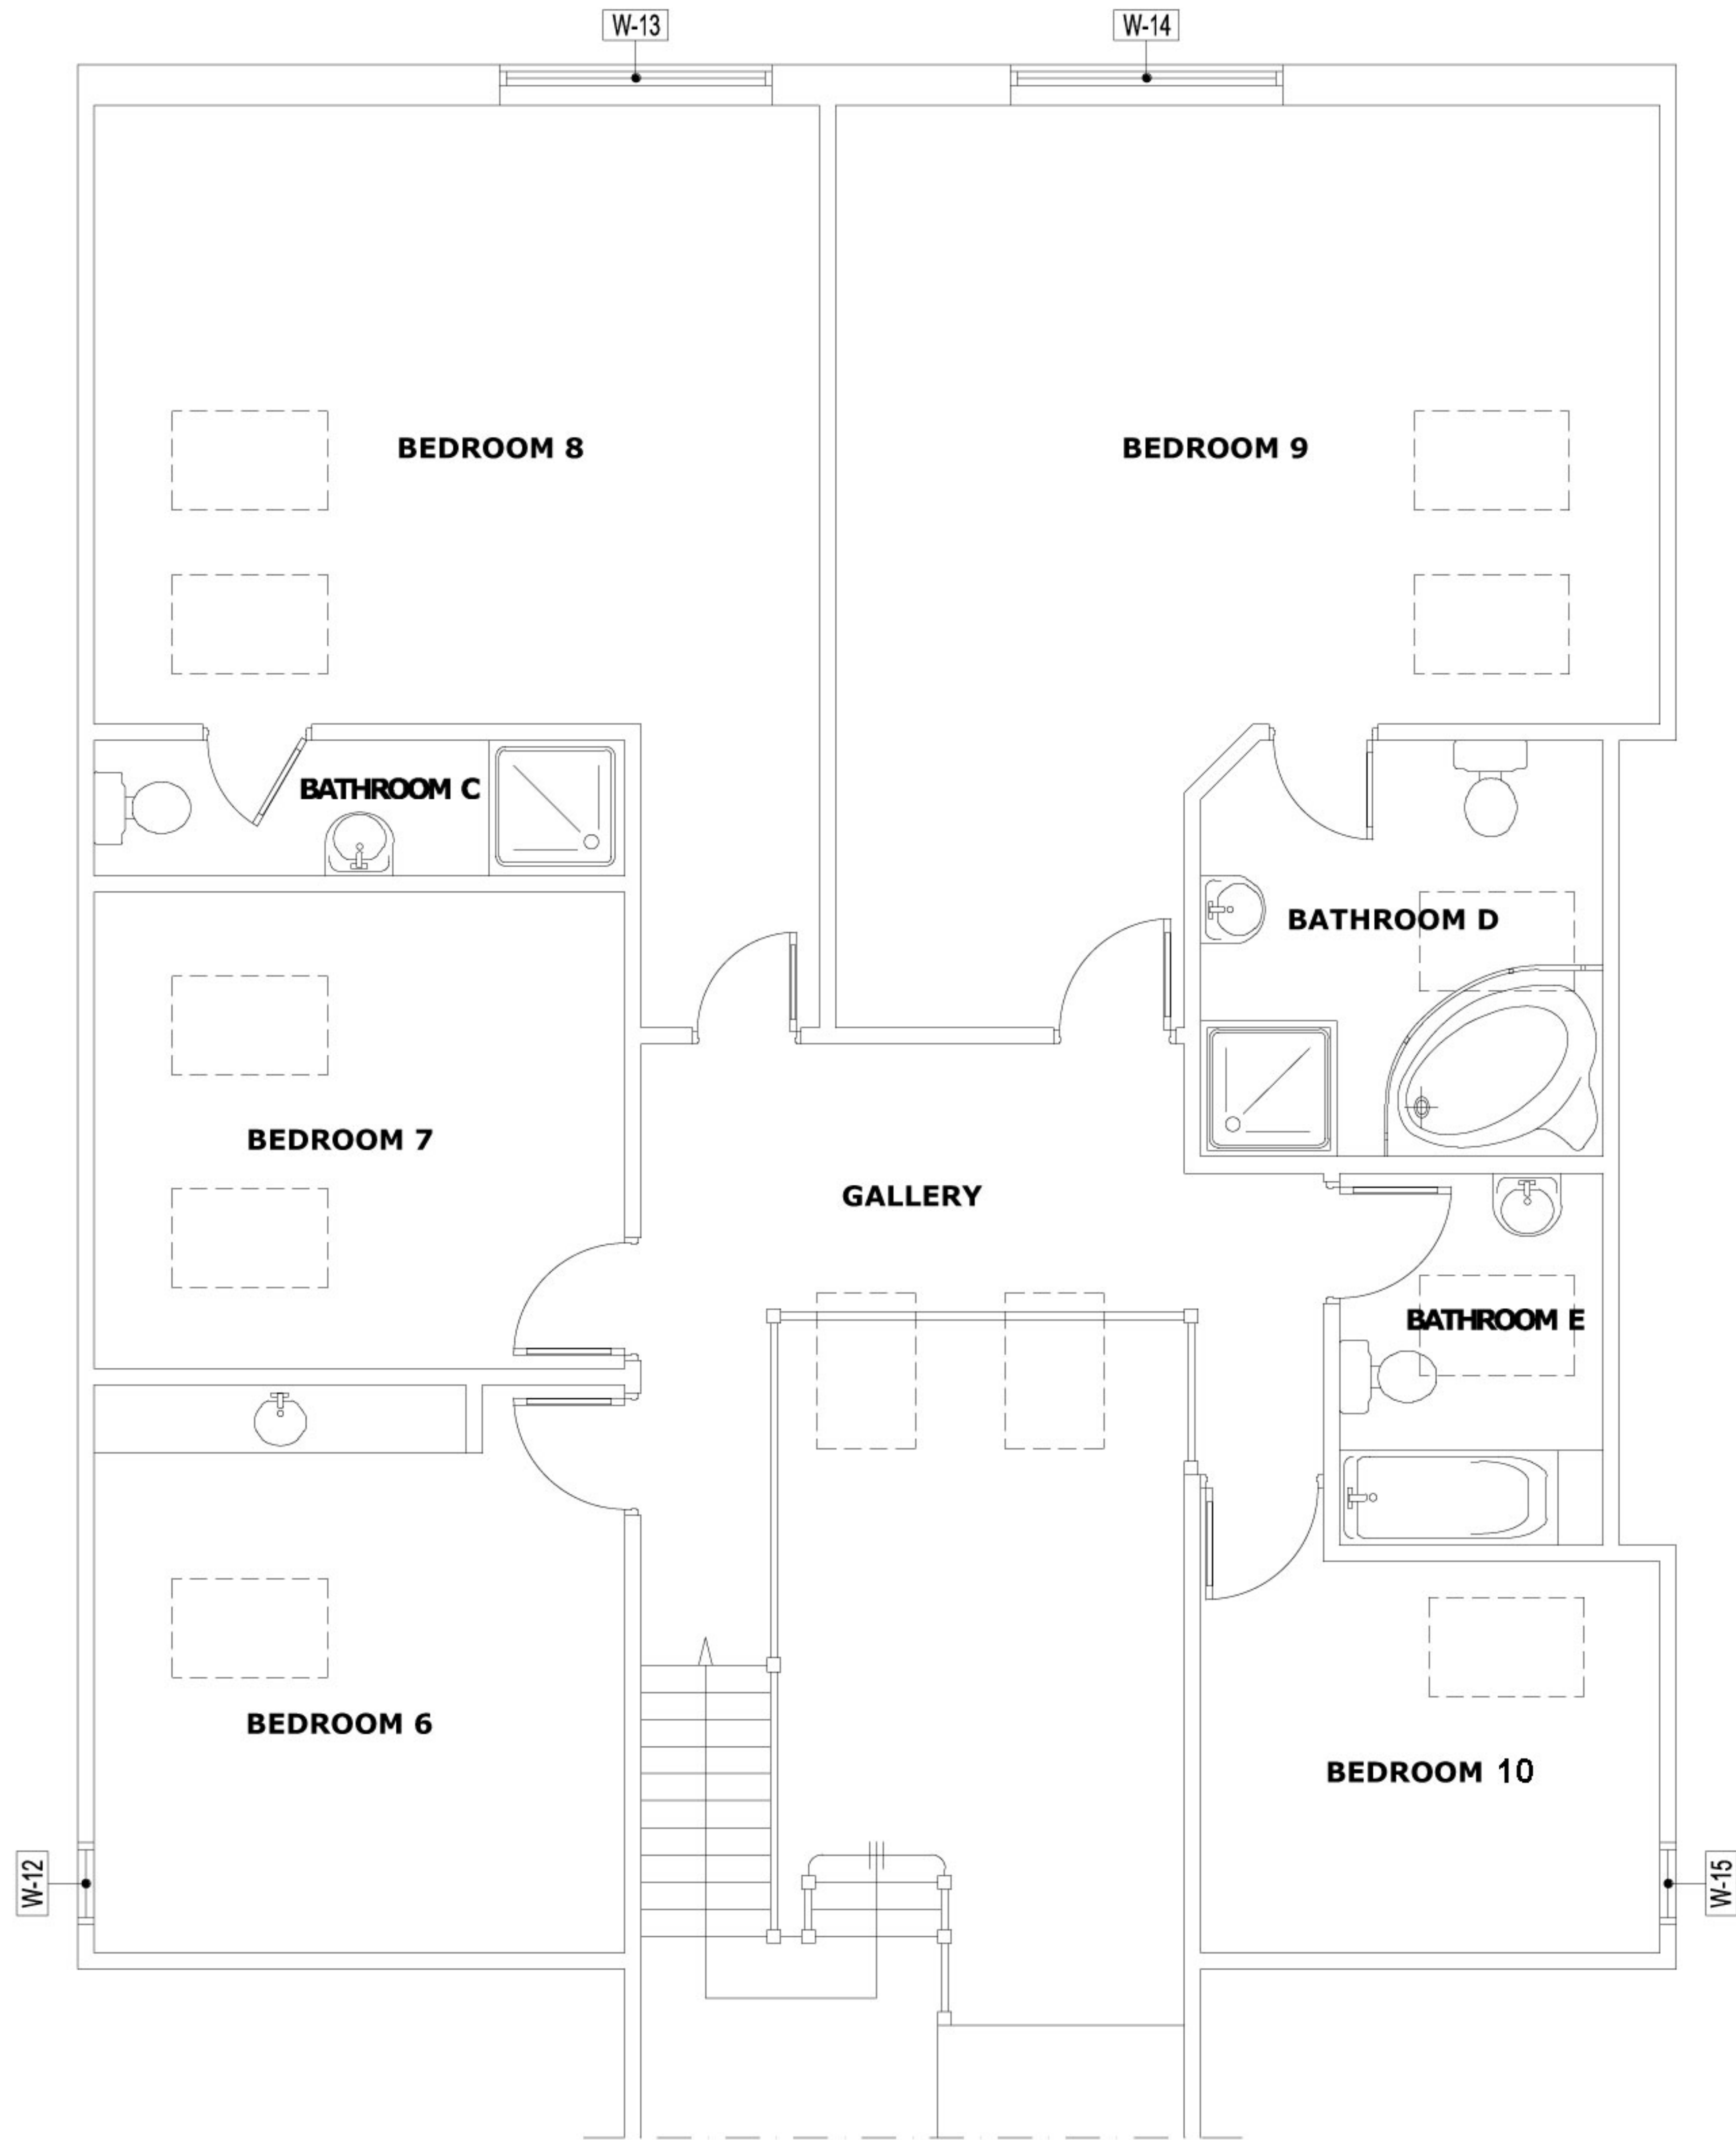

LEGEND:-	
	Water Stop Cock
	Electric Board
	Electric Meter
	Gas Meter
	Boiler Location
	Smoke Alarm
	Single Light Switch
	Double Light Switch
	Single Plug Socket
	Double Plug Socket
	Ceiling Light

W. TYPE	WIDTH	HEIGHT	SILL
W-12	70	90	---
W-13	180	120	---
W-14	177	121	---
W-15	70	90	---

--

50 Cressingham Road
Reading, RG2 7JR, UK

RDG050

Drawing Title:

First Floor Plan

Scale:	REV. NO:	Drawn:
1:50	01	M.S.