


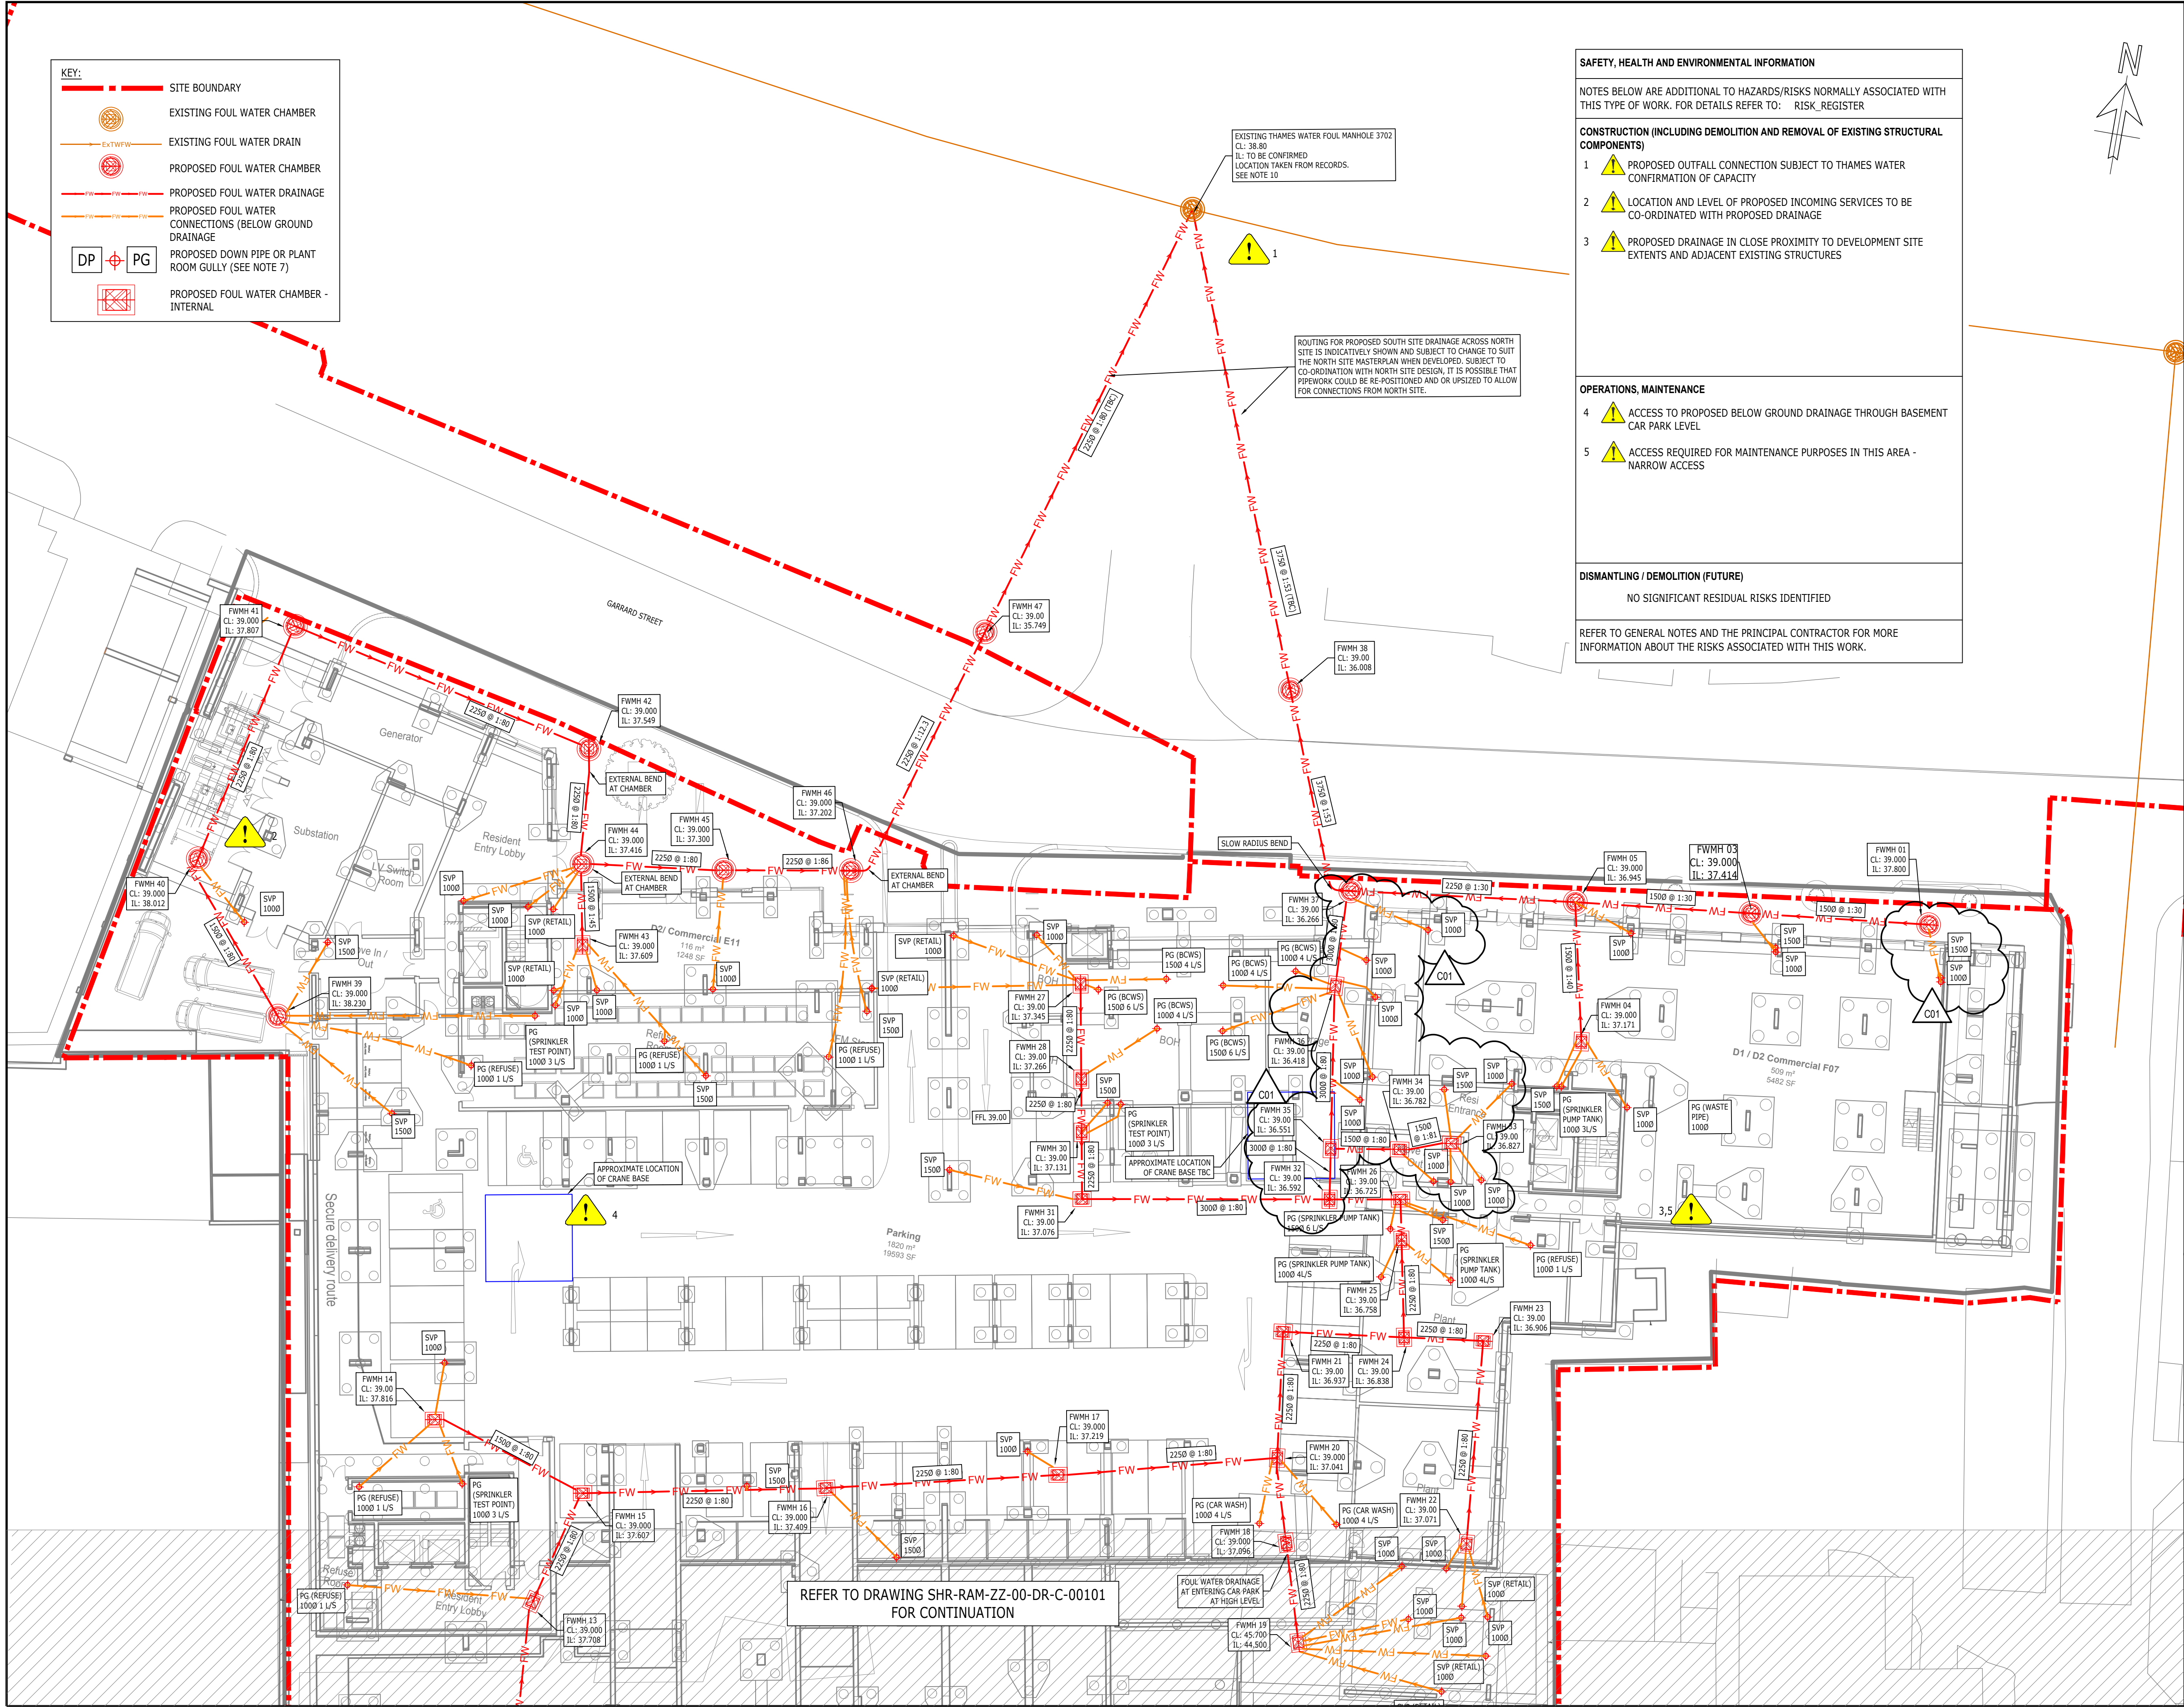

COPYRIGHT RAMBOLL UK LIMITED. ALL RIGHTS RESERVED. THIS DOCUMENT IS ISSUED FOR THE PARTY WHO COMMISSIONED IT AND FOR THE SPECIFIC PURPOSES CONNECTED WITH THE PROJECT ONLY. IT SHOULD NOT BE RELIED UPON BY ANY OTHER PARTY OR USED FOR ANY OTHER PURPOSE. RAMBOLL ACCEPTS NO RESPONSIBILITY OR LIABILITY WHICH MAY ARISE FROM RELIANCE OR USE OF THIS DOCUMENT OR THE DATA CONTAINED HEREIN BY ANY OTHER PARTY OR FOR ANY OTHER PURPOSE.			
Notes			
1. THIS DRAWING IS NOT TO BE SCALED.			
2. THIS DRAWING IS TO BE READ IN CONJUNCTION WITH ALL RELEVANT ARCHITECTURAL, STRUCTURAL AND M&E DRAWINGS.			
3. THIS IS NOT AN INSTALLATION DRAWING NOR A CO-ORDINATION DRAWING.			
4. THIS DRAWING IS BASED ON, • PLOWMAN CRAVEN UNDERGROUND SERVICES SURVEY '40652-01T-01', REVISION A, DATED 13.11.2018. • ARCHITECTURAL LAYOUT SHR-CRL-BE-GF-A-113-103, SHR-CRL-BE-LG-A-113-101, SHR-CRL-BE-MZ-A-113-102, SHR-CRL-BF-GF-A-150-003, SHR-CRL-BF-MZ-A-133-002, SHR-CRL-BF-LG-A-133-001, RECEIVED 22.08.19			
5. WHERE PROPOSED DRAINAGE IS SHOWN EXITING THE BUILDING, THE PIPE INVERT LEVEL AND GRADIENTS AT THESE LOCATIONS HAVE BEEN DESIGNED BASED ON THE AVAILABLE INFORMATION.			
6. THE UNDERCOVER CAR PARK AREAS ARE NOT PROVIDED WITH POSITIVE DRAINAGE, EXCEPT FOR THE PROPOSED CAR WASHING BAY. REFER TO FOUL WATER DRAINAGE LAYOUTS.			
7. THE PROPOSED BELOW GROUND DRAINAGE DESIGN IS SUBJECT TO ONGOING DISCUSSIONS WITH THAMES WATER TO AGREE THE PROPOSED OUTFALL LOCATIONS, AND THAMES WATER APPROVAL.			
8. PRE-DEVELOPMENT ENQUIRY HAS BEEN SUBMITTED TO THAMES WATER TO CONFIRM THE CAPACITY OF EXISTING SEWER.			
9. PRESENCE AND SIZE OF EXISTING DOWNPIPES SERVING ADJOINING SITE TO BE CONFIRMED. DEDICATED DRAINAGE TO BE INSTALLED AS REQUIRED. TYPICAL ARRANGEMENT SHOWN.			
10. REFER TO RAMBOLL DRAWINGS SHR-RAM-XX-XX-DR-C-000401, SHR-RAM-XX-XX-DR-C-000402, SHR-RAM-XX-XX-DR-C-000403 AND SHR-RAM-XX-XX-DR-C-000404 FOR DRAINAGE DETAILS			
11. PROPOSED ATTENUATION TANK IS LOCATED BELOW PODIUM LEVEL. SUBJECT TO DESIGN BY OTHERS, CONNECTIONS MAY BE PROVIDED THROUGH RETAIL SPACES			
KEY PLAN			
SHEET 1			
SHEET 2			
C01 ISSUED FOR CONTRACT			
T02 STAGE 4A SUPERSTRUCTURE ISSUE			
T01 STAGE 4A ISSUE			
Rev	Description	Date	By App
CONTRACT			
STATION HILL READING			
RAMBOLL			
tel 020 7631 5291 london@ramboll.co.uk www.ramboll.co.uk			
PHASE 1 (BLOCK E & F) PROPOSED FOUL WATER DRAINAGE LAYOUT SHEET 2 OF 2			
Project No:	Scale (0A1):	Drawn:	Date:
1620004716	1:200	CS	DEC 2018
Drawing No:	Rev:		
SHR-RAM-ZZ-00-DR-C-00102	C01		