


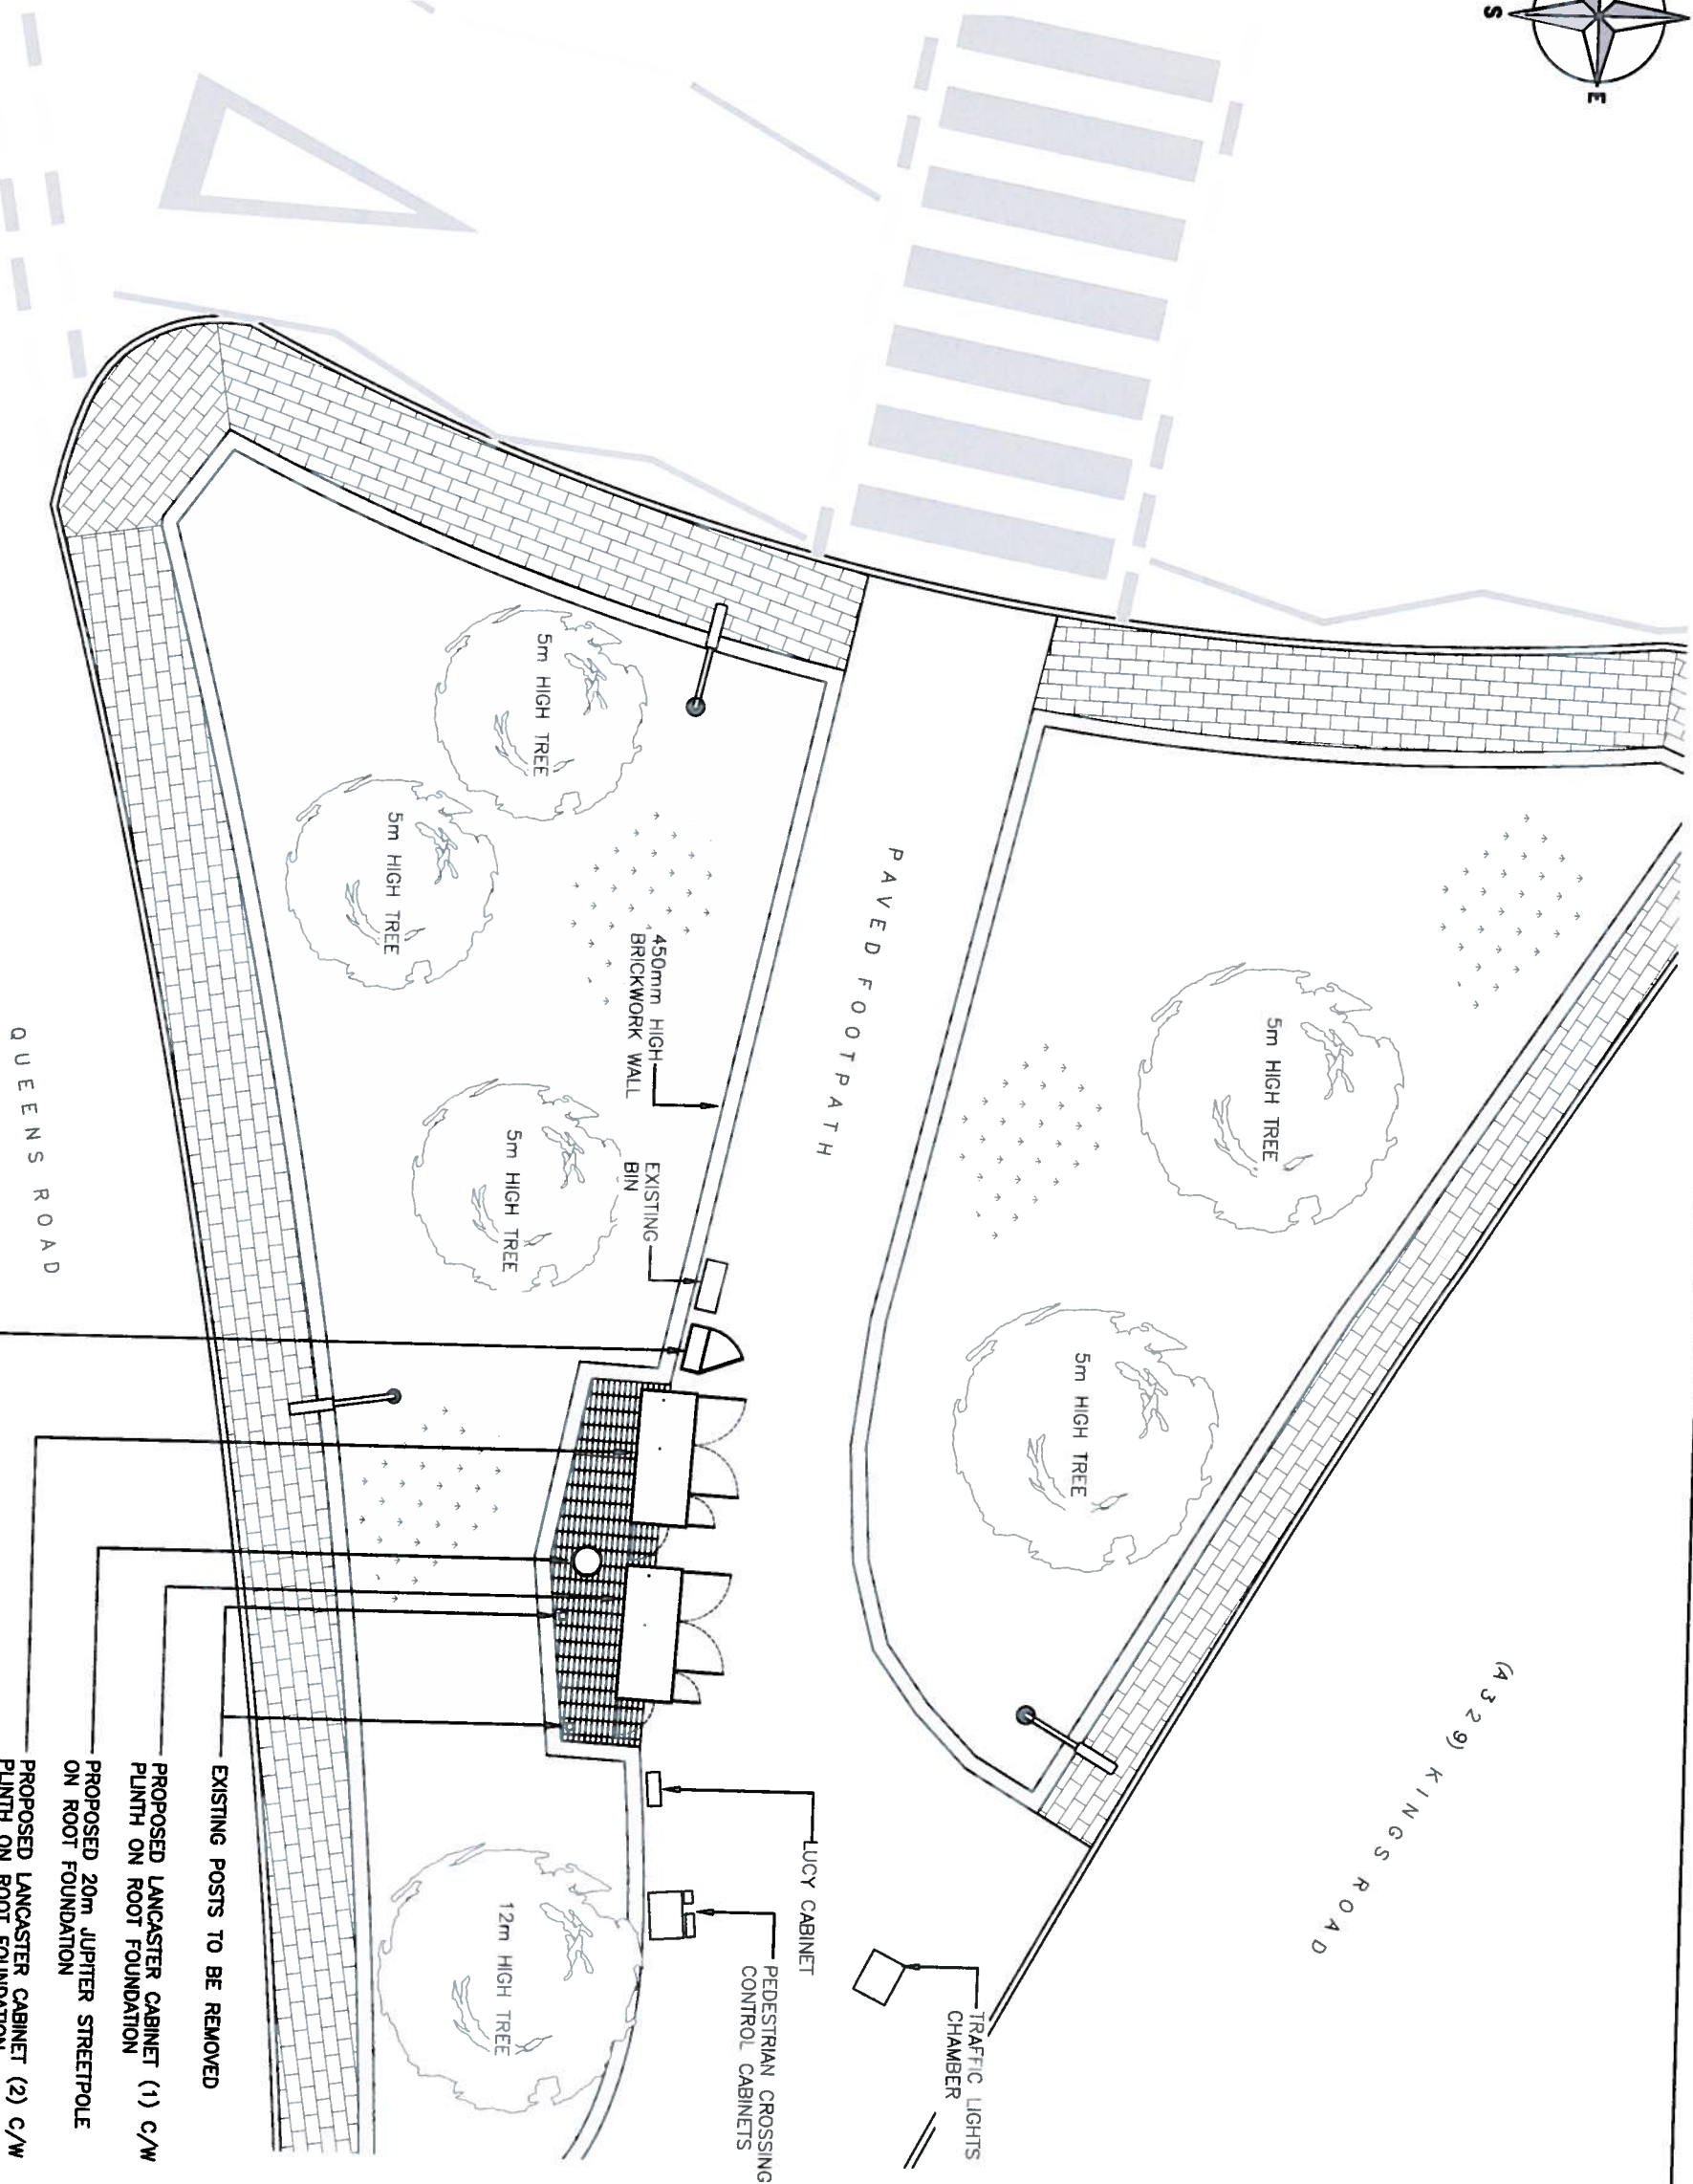

PROPOSED SITE PLAN

(1:100)

The drawings comply with TEF & Vodafone Standard ICNIRP guidelines.
Designed in accordance with CTL document: SDN0008

ALL DIMENSIONS ARE IN mm UNLESS NOTED OTHERWISE			
N.G.R	E: 472371	N: 173295	
NOTES:			

REV	DESCRIPTION	BY	CH	DATE
A	Issued for Approval	GL	SB	06.02.19
REV	MODIFICATION	BY	CH	DATE

CLARKE
telecom

Unit 5, Madison Place, Northampton Road,
Manchester, M40 3AG
Tel: 0161 785 4500
Fax: 0161 785 4501
Web: www.clarke-telecom.com

Cell Name		Opt.
SW ON KINGS ROAD		-
Cell ID No		
CTL	TEF	VF

245471	N/A	17467
Site Address / Contact Details		
KINGS ROAD READING RG1 3GS		

Drawing Title:	
PROPOSED SITE PLAN	
Purpose of Issue:	
PLANNING	
Drawing Number:	
201	
Surveyed By:	
SB	
Original Sheet Size:	
A3	
Drawn:	
GL	
Date:	
06.02.19	
Checked:	
SB	
Date:	
06.02.19	
Issue:	
A	