


SCALE 250:1 @ A4

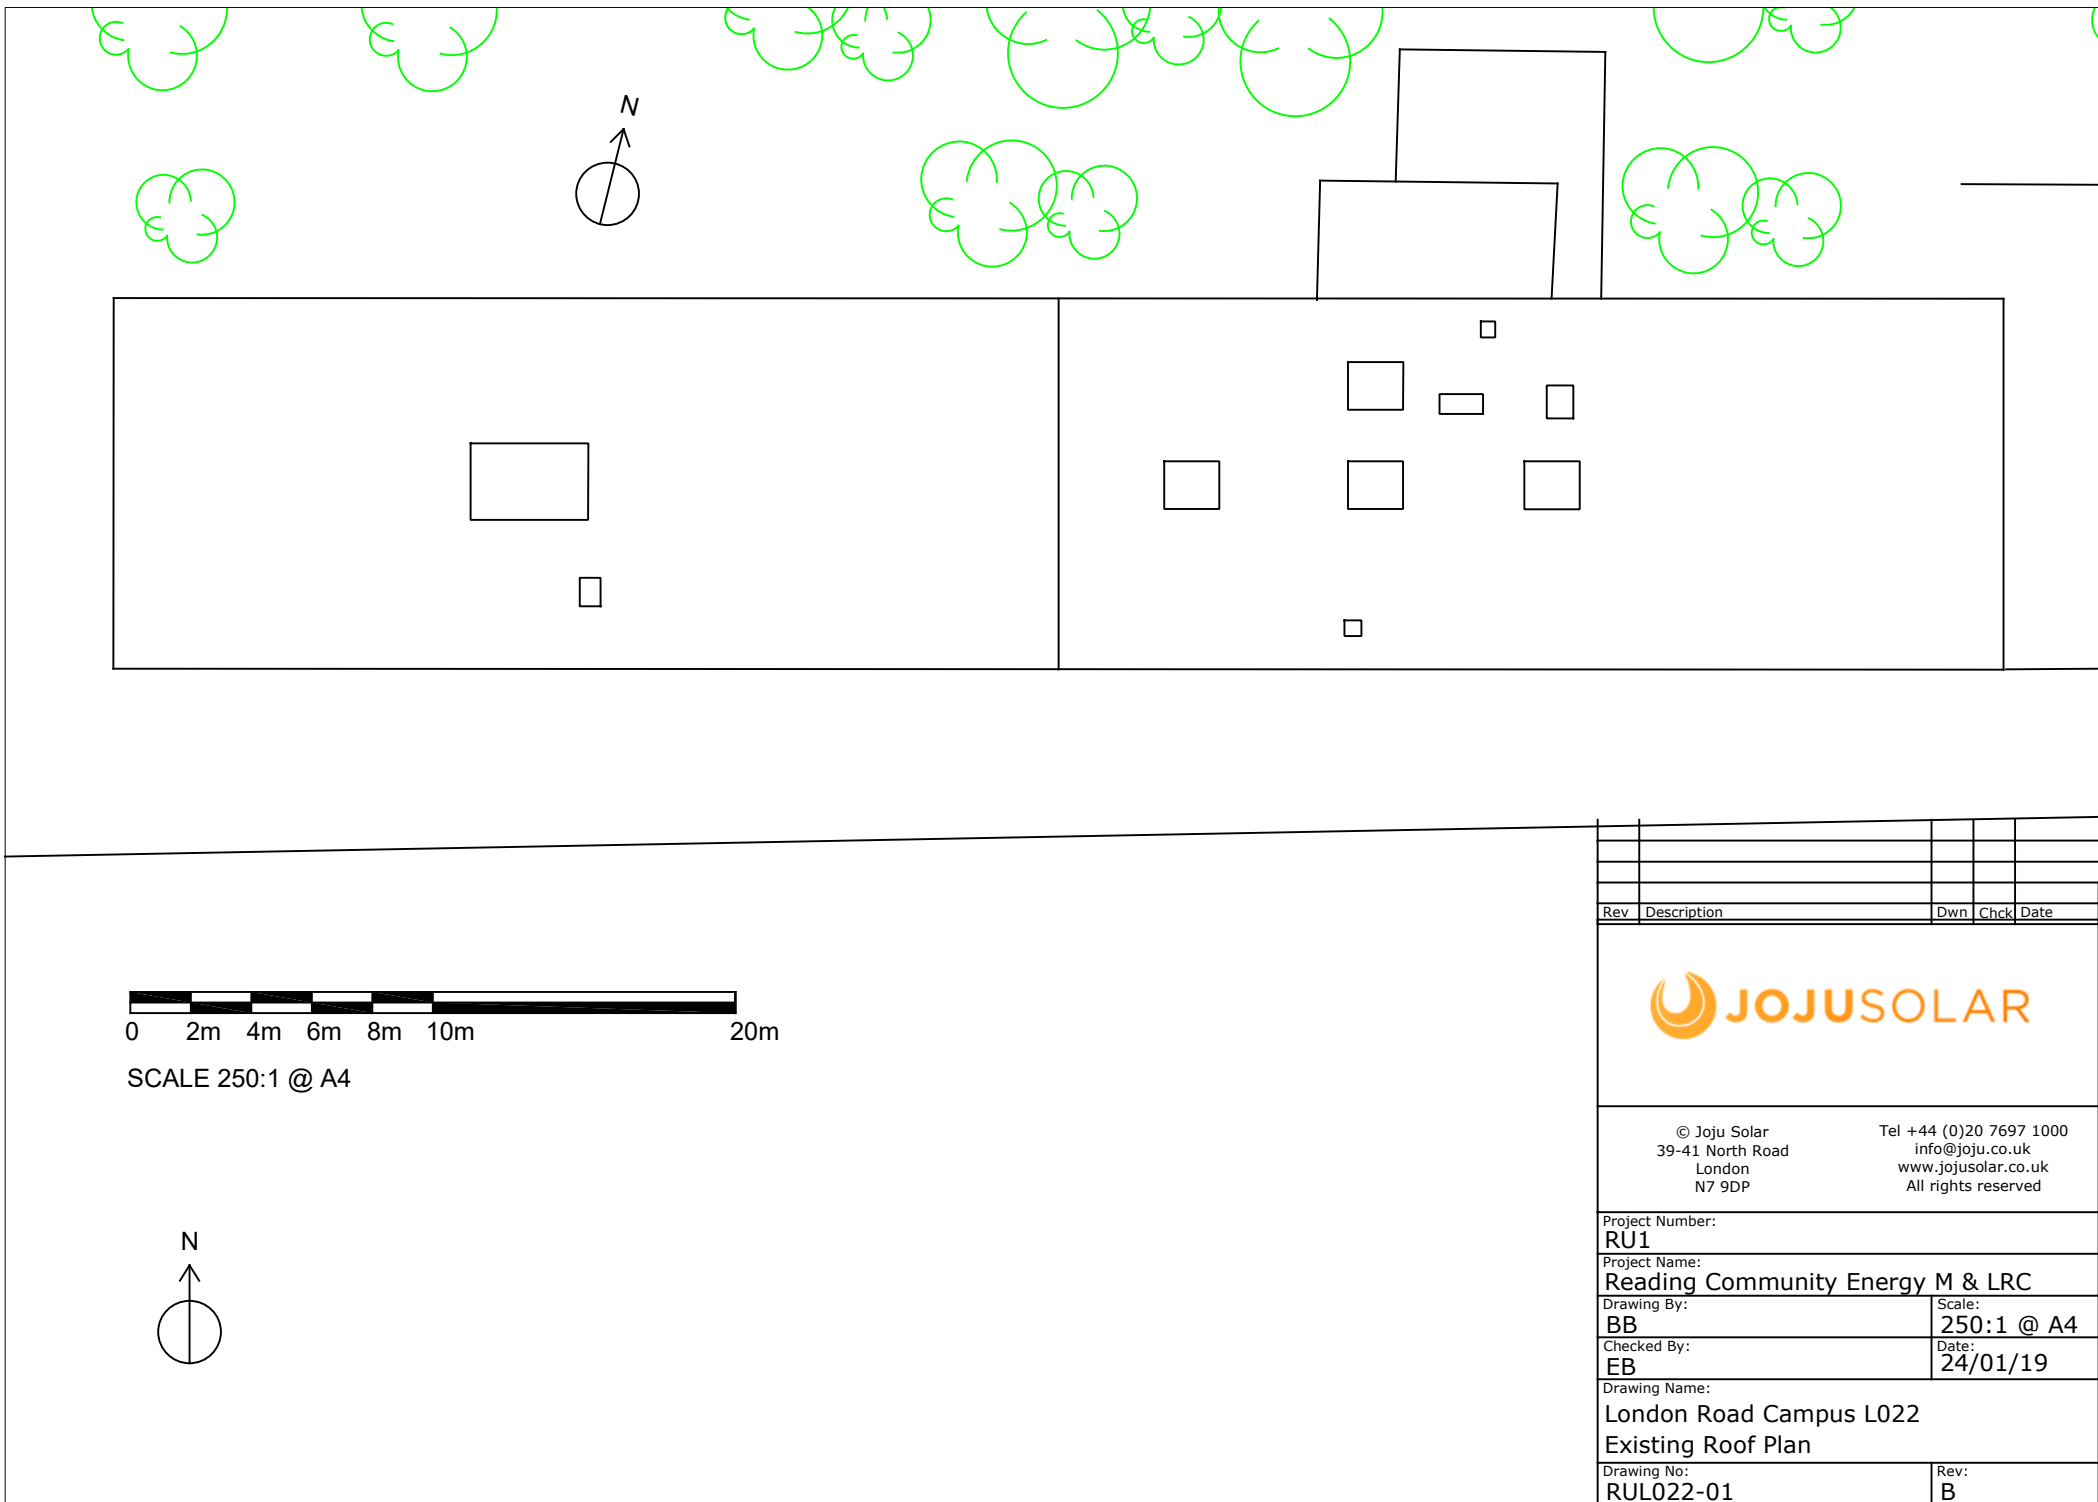

Rev	Description	Dwn	Chck	Date
				
© Joju Solar 39-41 North Road London N7 9DP		Tel +44 (0)20 7697 1000 info@joju.co.uk www.jojusolar.co.uk All rights reserved		
Project Number: RU1				
Project Name: Reading Community Energy M & LRC				
Drawing By: BB		Scale: 250:1 @ A4		
Checked By: EB		Date: 24/01/19		
Drawing Name: London Road Campus L022 Existing Roof Plan				
Drawing No: RUL022-01		Rev: B		