


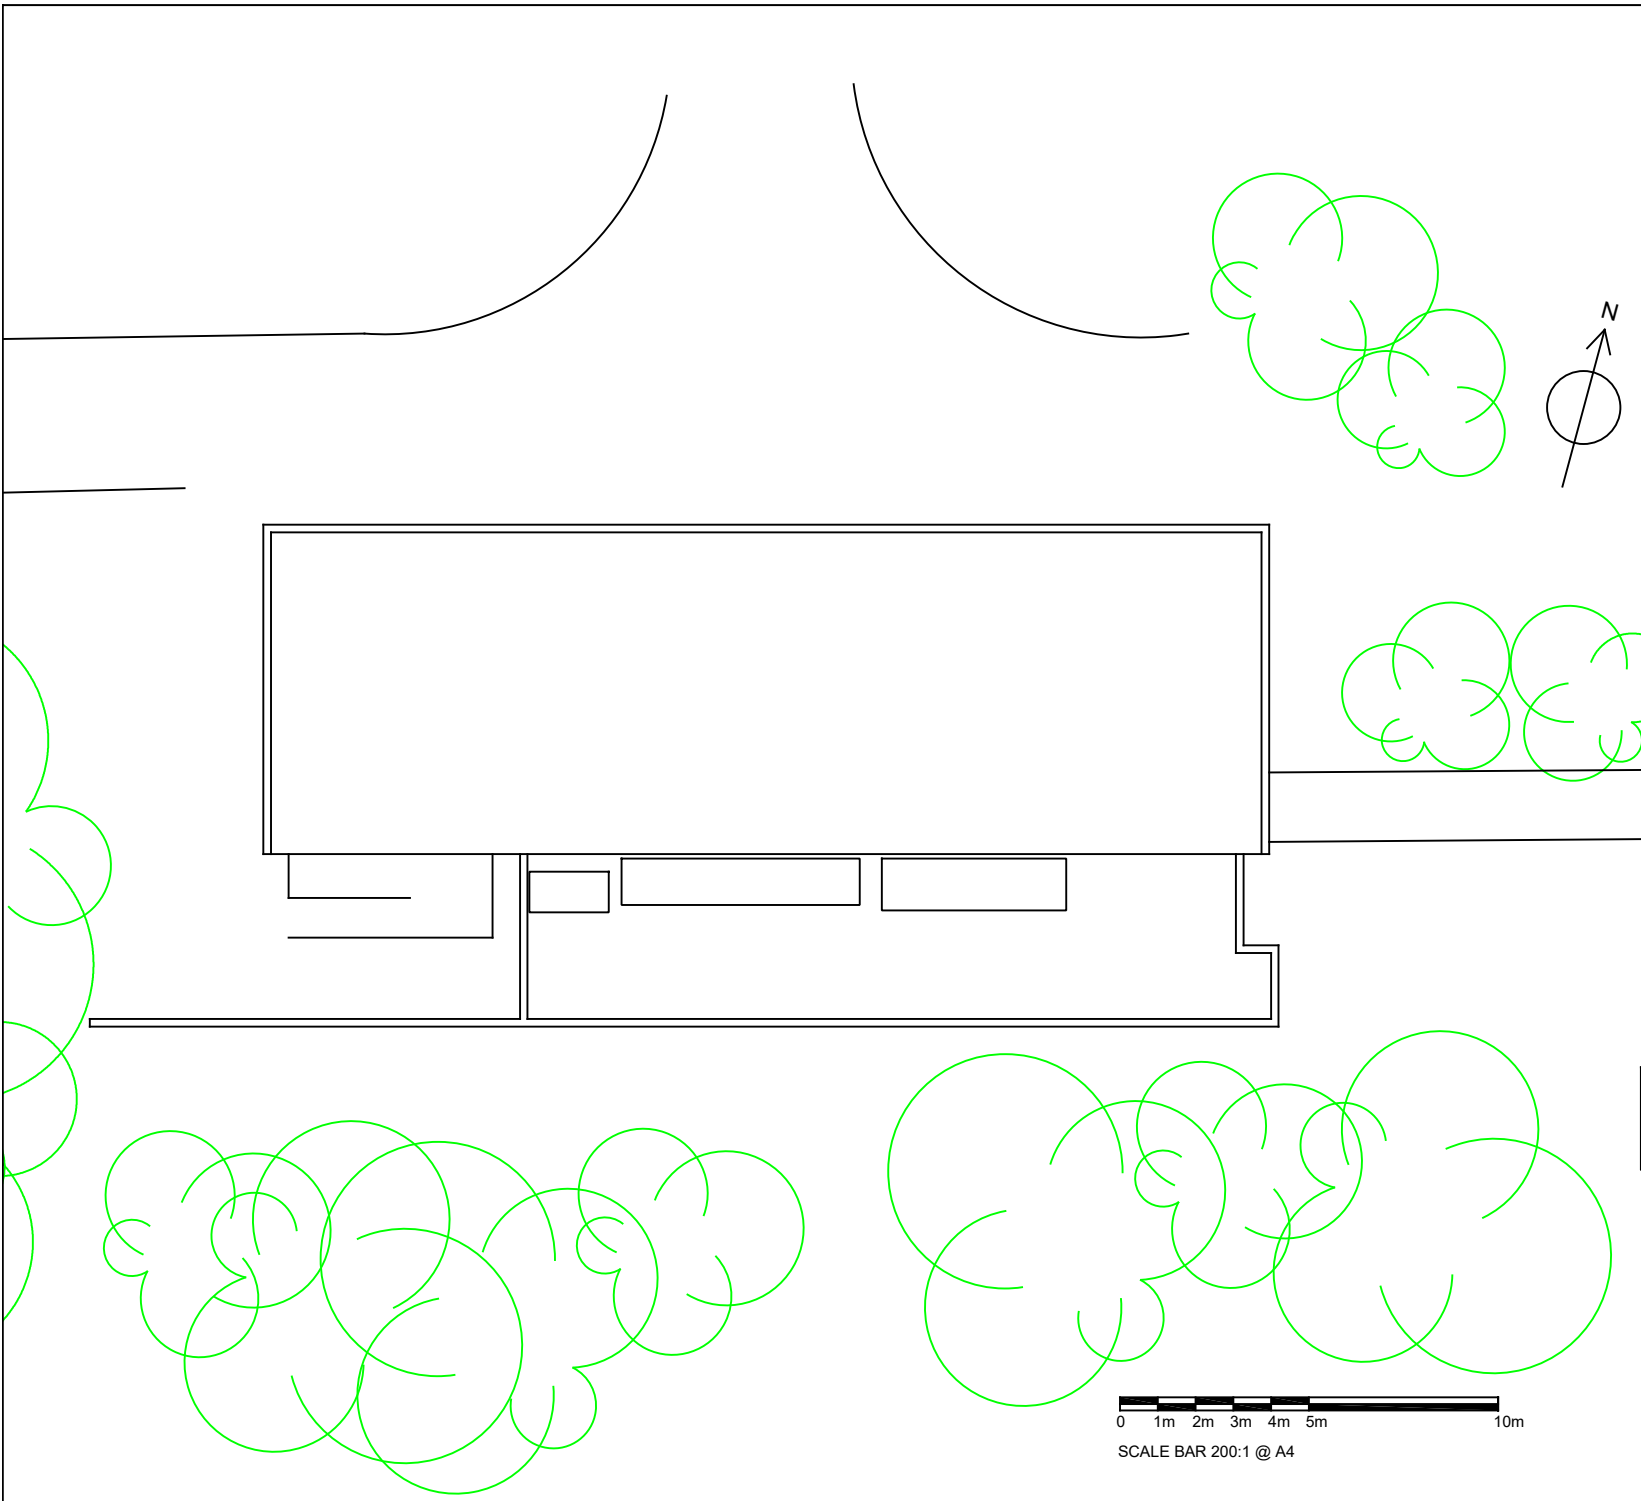

A	INIT. DRAFT	BB	EB	22/1/19
Rev	Description	Dwn	Chck	Date



© Joju Solar
39-41 North Road
London
N7 9DP

Tel +44 (0)20 7697 1000
info@joju.co.uk
www.joju.co.uk
All rights reserved

Project Number: RU1	
Project Name: Reading Community Energy M & LRC	
Drawing By: BB	Scale: 200:1 @ A4
Checked By: EB	Date: 22/01/19
Drawing Name: MERL Archive Existing Roof Plan	
Drawing No: RUARC01	Rev: B