


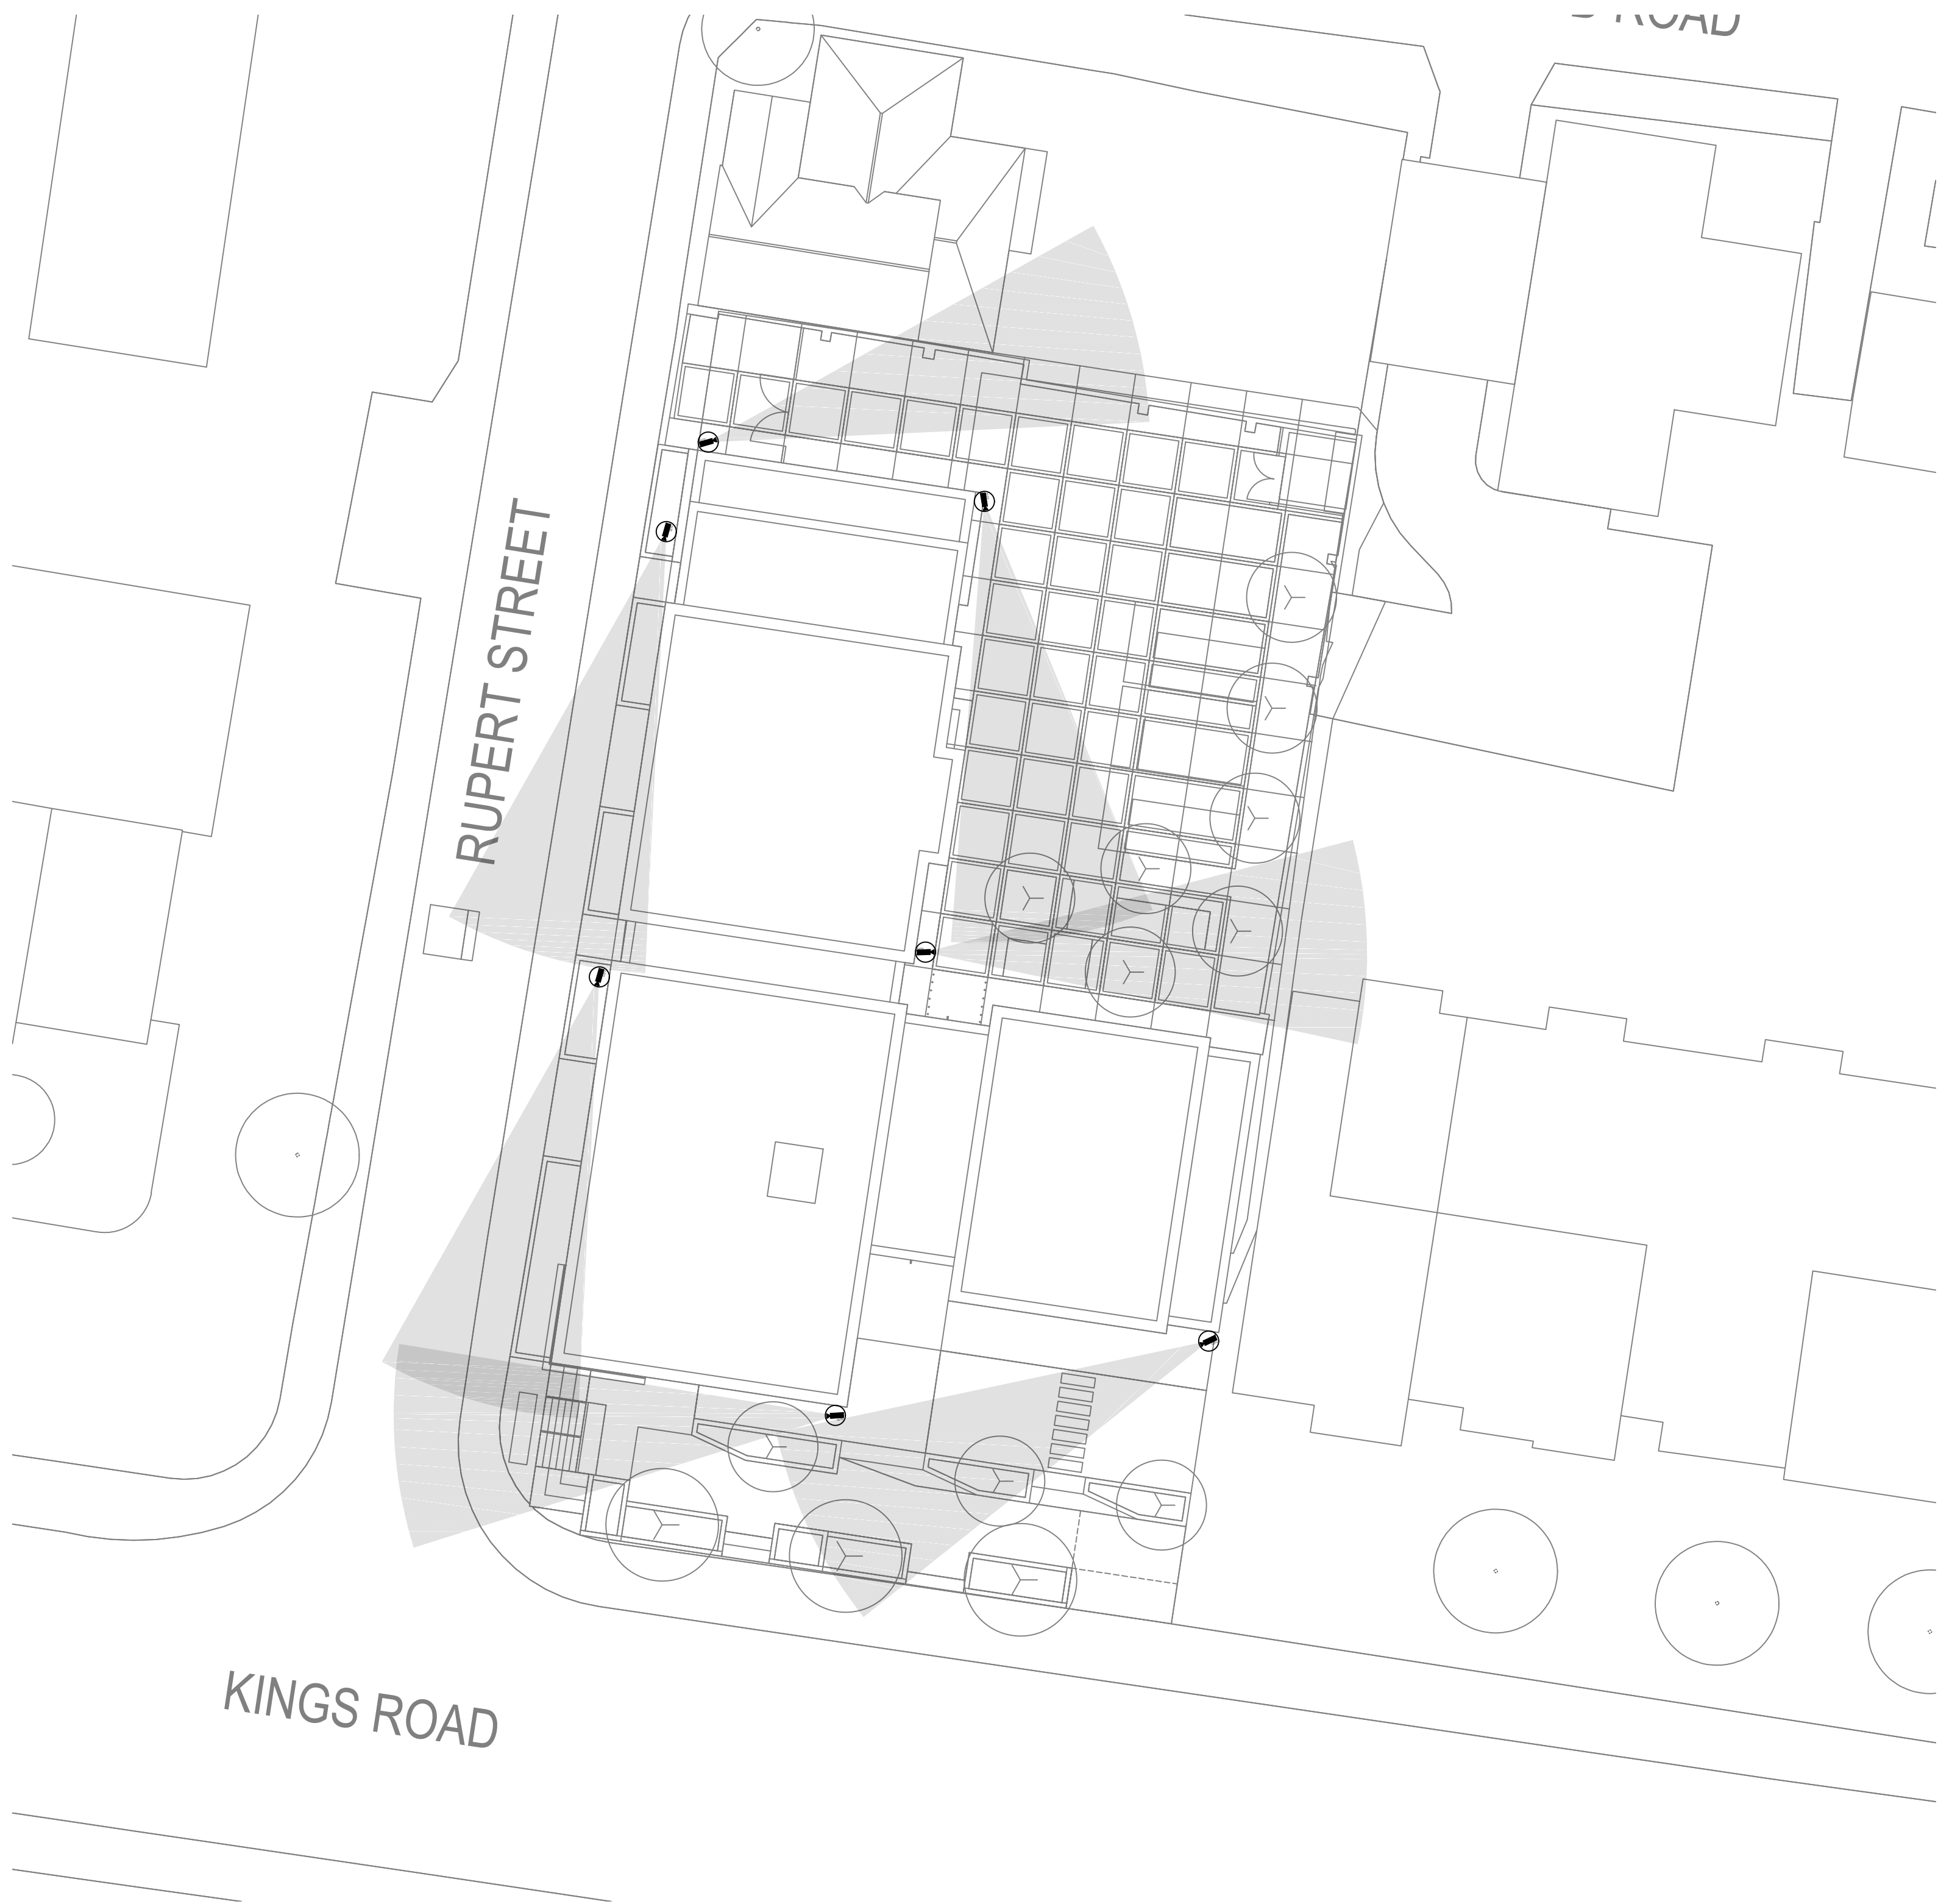

NOTES
THIS IS A DESIGN DRAWING NOT AN INSTALLATION DRAWING.
DIMENSIONS SHOULD NOT BE SCALED.
SITE DIMENSIONS TO BE CHECKED BEFORE PRODUCTION OF
CRITICAL MANUFACTURING DRAWINGS.
THE DRAWING IS COPYRIGHT AND NO PART MAY BE
REPRODUCED WITHOUT WRITTEN CONSENT.

- NOTES
- DO NOT SCALE FROM THIS DRAWING.
 - THE CONTRACTOR MUST VERIFY ALL DIMENSIONS
TOLERANCES AND REFERENCES BEFORE PROCEEDING
WITH WORKS.
 - ANY DISCREPANCY FOUND BETWEEN THIS DRAWING AND
ANY OTHER DOCUMENTS MUST BE REPORTED
IMMEDIATELY TO THE CONTRACT ADMINISTRATOR.
 - ALL CONTROL DEVICES AND EQUIPMENT IS TO BE LOCATED
IN ACCESSIBLE AREAS.
 - THE CONTRACTOR IS TO ALLOW FOR COORDINATION OF
THE SERVICES AND STRUCTURAL BEAMS/OPENINGS
DURING THE DESIGN/PRODUCTION OF THE WORKING
DRAWINGS.
 - COVERAGE WITHIN THIS DRAWING IS INDICATIVE AND IS
TO BE CONFIRMED BY SPECIALIST.
 - FINAL LOCATIONS AND SPECIFICATIONS OF CCTV CAMERAS
TO BE CONFIRMED BY SPECIALIST.

LEGEND
 FIXED DOME IP RATED CAMERA

DESIGN INTENT

P2	14/01/19	CAMERA LAYOUT UPDATED AND INDICATIVE COVERAGE ADDED	OR	PL
P1	08/01/19	ISSUED FOR PLANNING	OR	PL
REV	DATE	DESCRIPTION	BY	VE

WGC
WILSON GRAY CONSULTING

North East
0191 691 6770
Yorkshire
0113 390 0185

Drawing Status
PLANNING

Project
ALEXANDER HOUSE

Drawing Title
ELECTRICAL ENGINEERING SERVICES
EXTERNAL CCTV LAYOUT

Client
jansons
property investors and developers

Scale
1:200@A1

Engineer
DB

Date
JAN 19

Drawing Number
4512-EX-00-DR-E-500

Rev
P2

Architects Revision
33443-L-90-100 (003)