


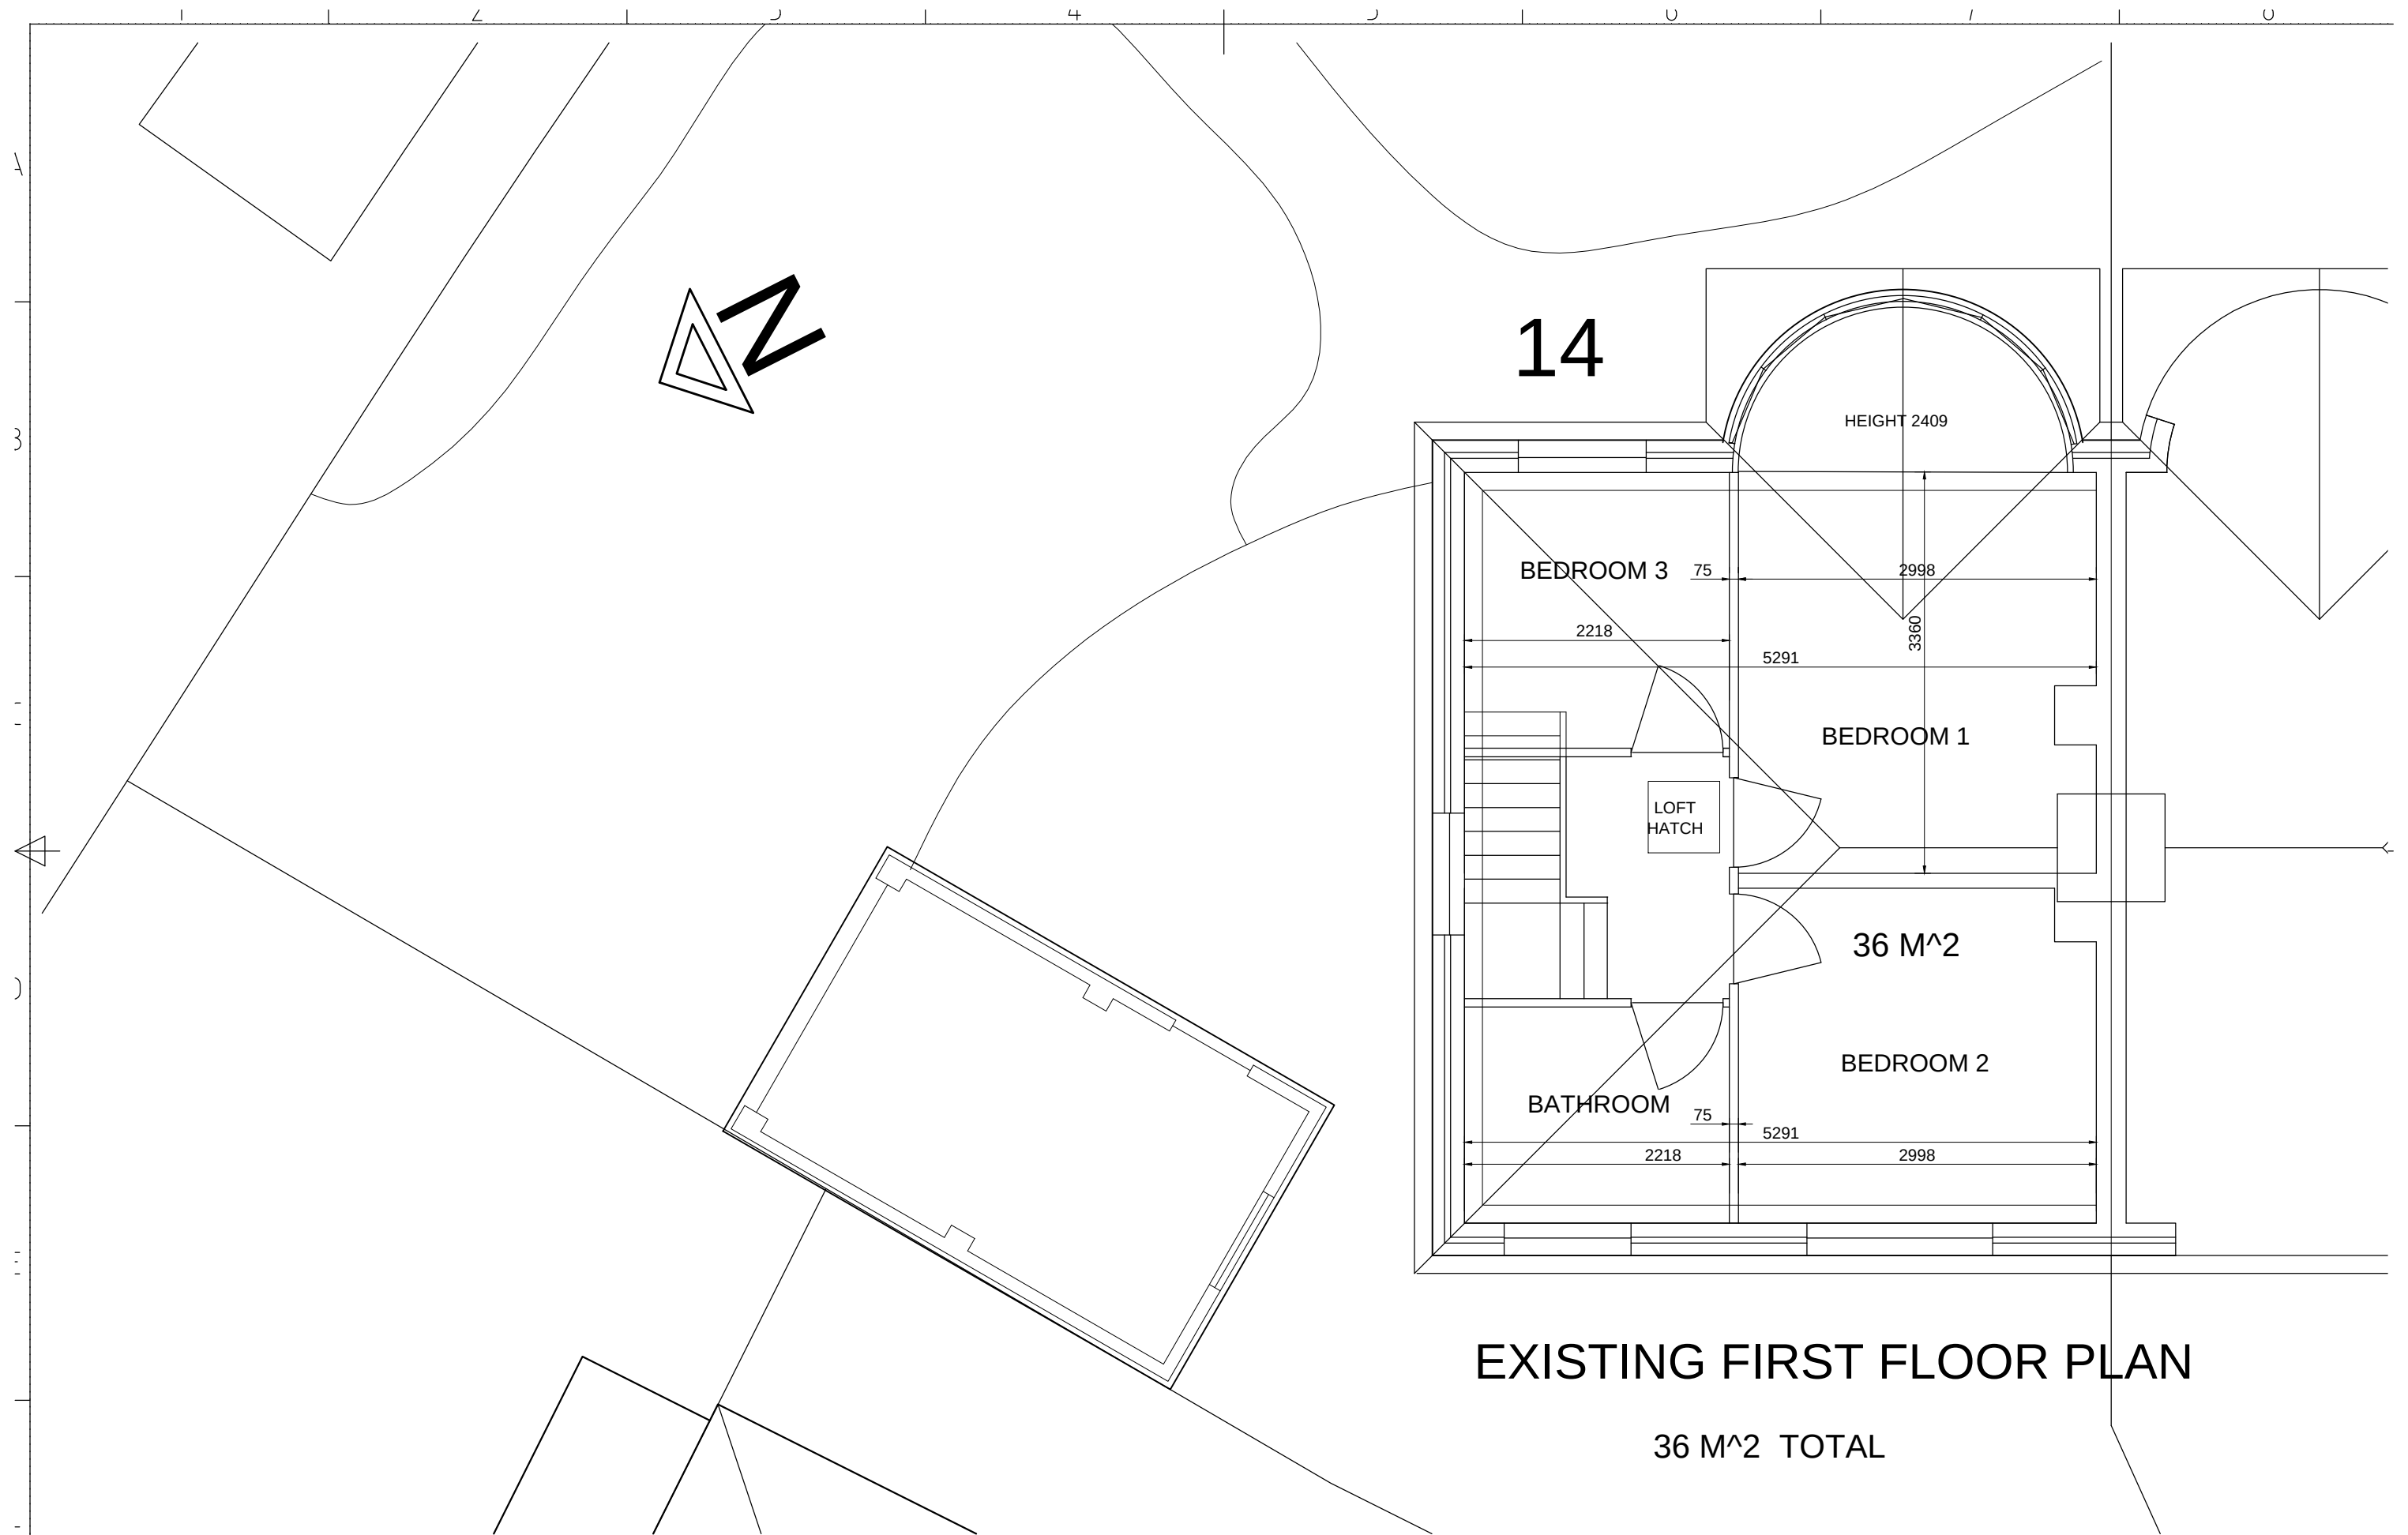

14

BEDROOM 3

BEDROOM 1


BEDROOM 2

BATHROOM

LOFT HATCH

EXISTING FIRST FLOOR PLAN

36 M² TOTAL

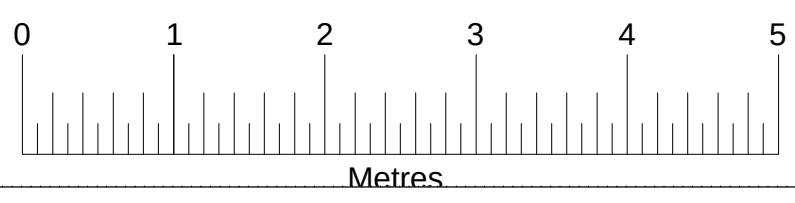

7					Client	F.M. Pool	Trilane Limited Chartered Structural Engineers Whitecot Sevenoaks Way Orpington Kent BR5 3JE tel. 01689 815 927 fax. 0208 302 2760	Scale	1 : 50 @ A3	1 : 71 @ A4
					Project	14 Barnsdale Road Reading FIRST FLOOR PLAN 1		Date	Nov 16	Engineer JAW Engineer
								Dwg No.	14 BR ~ FF1	
										Rev
	Rev.	Date	Description	Eng						