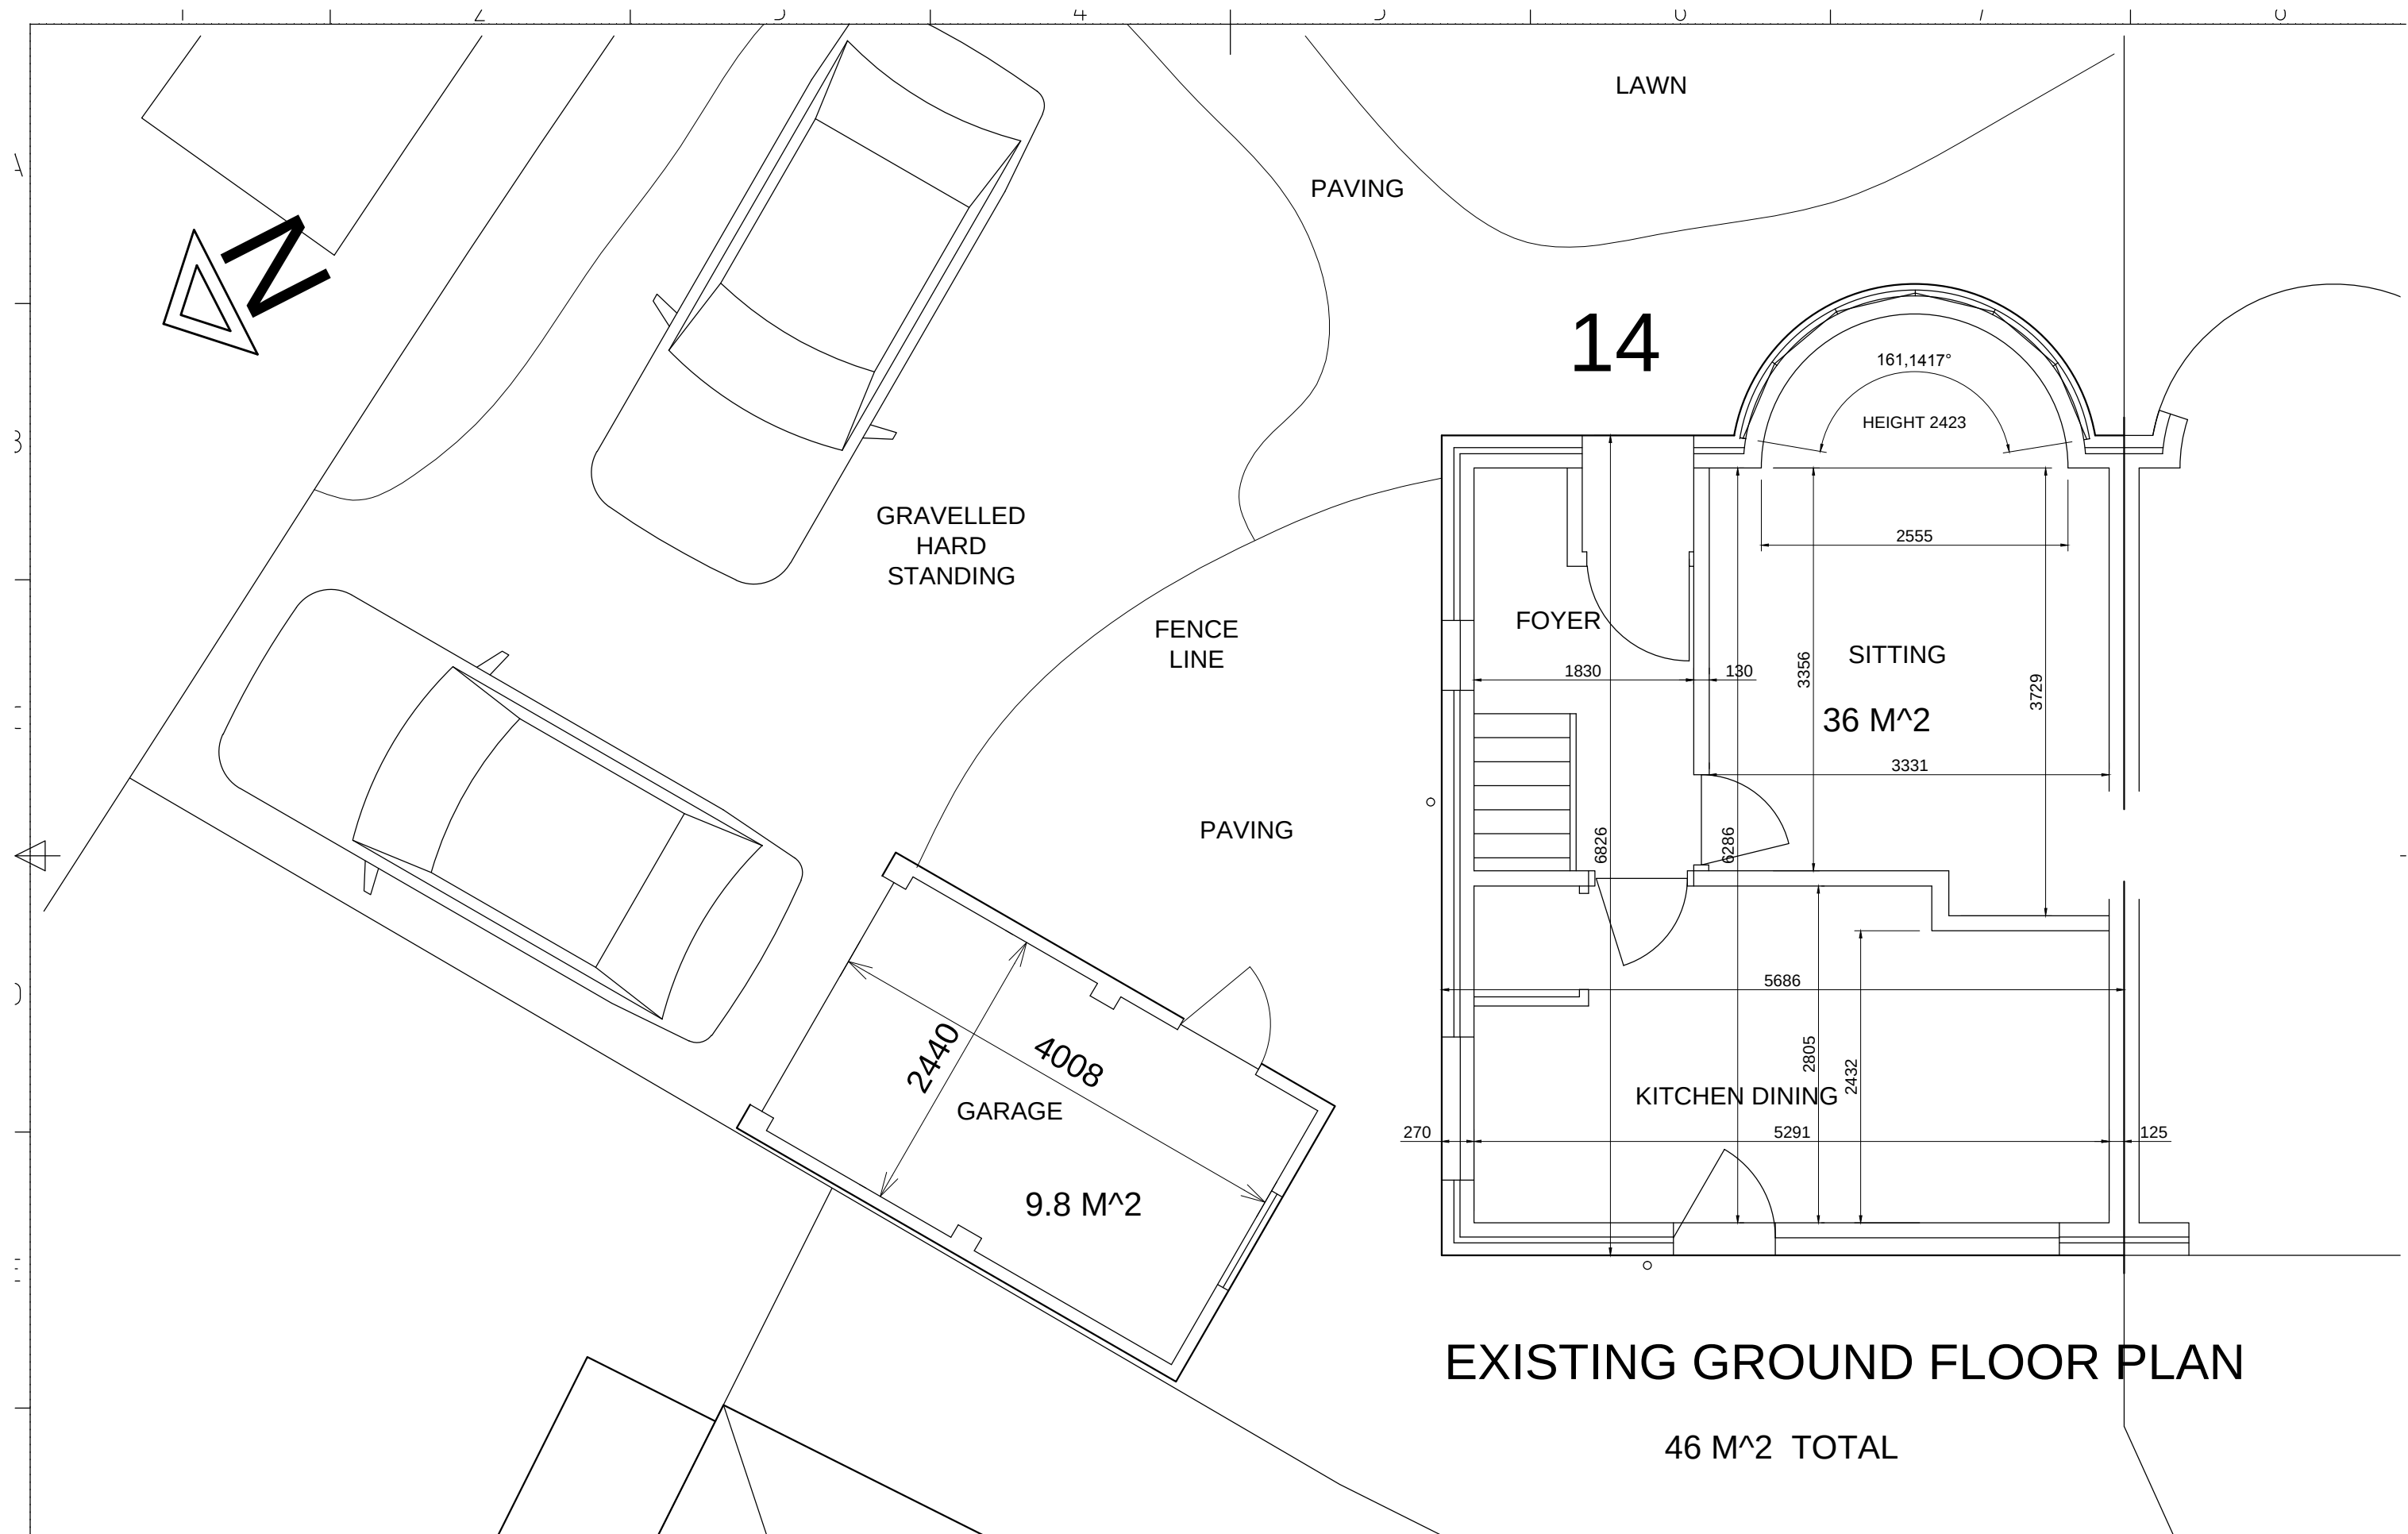


		Client F.M. Pool		Trilane Limited Chartered Structural Engineers		Scale 1 : 50 @ A3 1 : 71 @ A4
		Project 14 Barnsdale Road Reading		Whitecot Sevenoaks Way Orpington Kent BR5 3JE		Date Nov 16
		GROUND FLOOR PLAN 1		tel. 01689 815 927 fax. 0208 302 2760		Engineer JAW
						Engineer
Rev.	Date	Description	Eng	Dwg No. 14 BR ~ GF1		Rev