


SURFACE WATER DRAINAGE
CONNECTION TO PHASE 1
DRAINAGE SYSTEM, AS
PREVIOUSLY GRANTED.

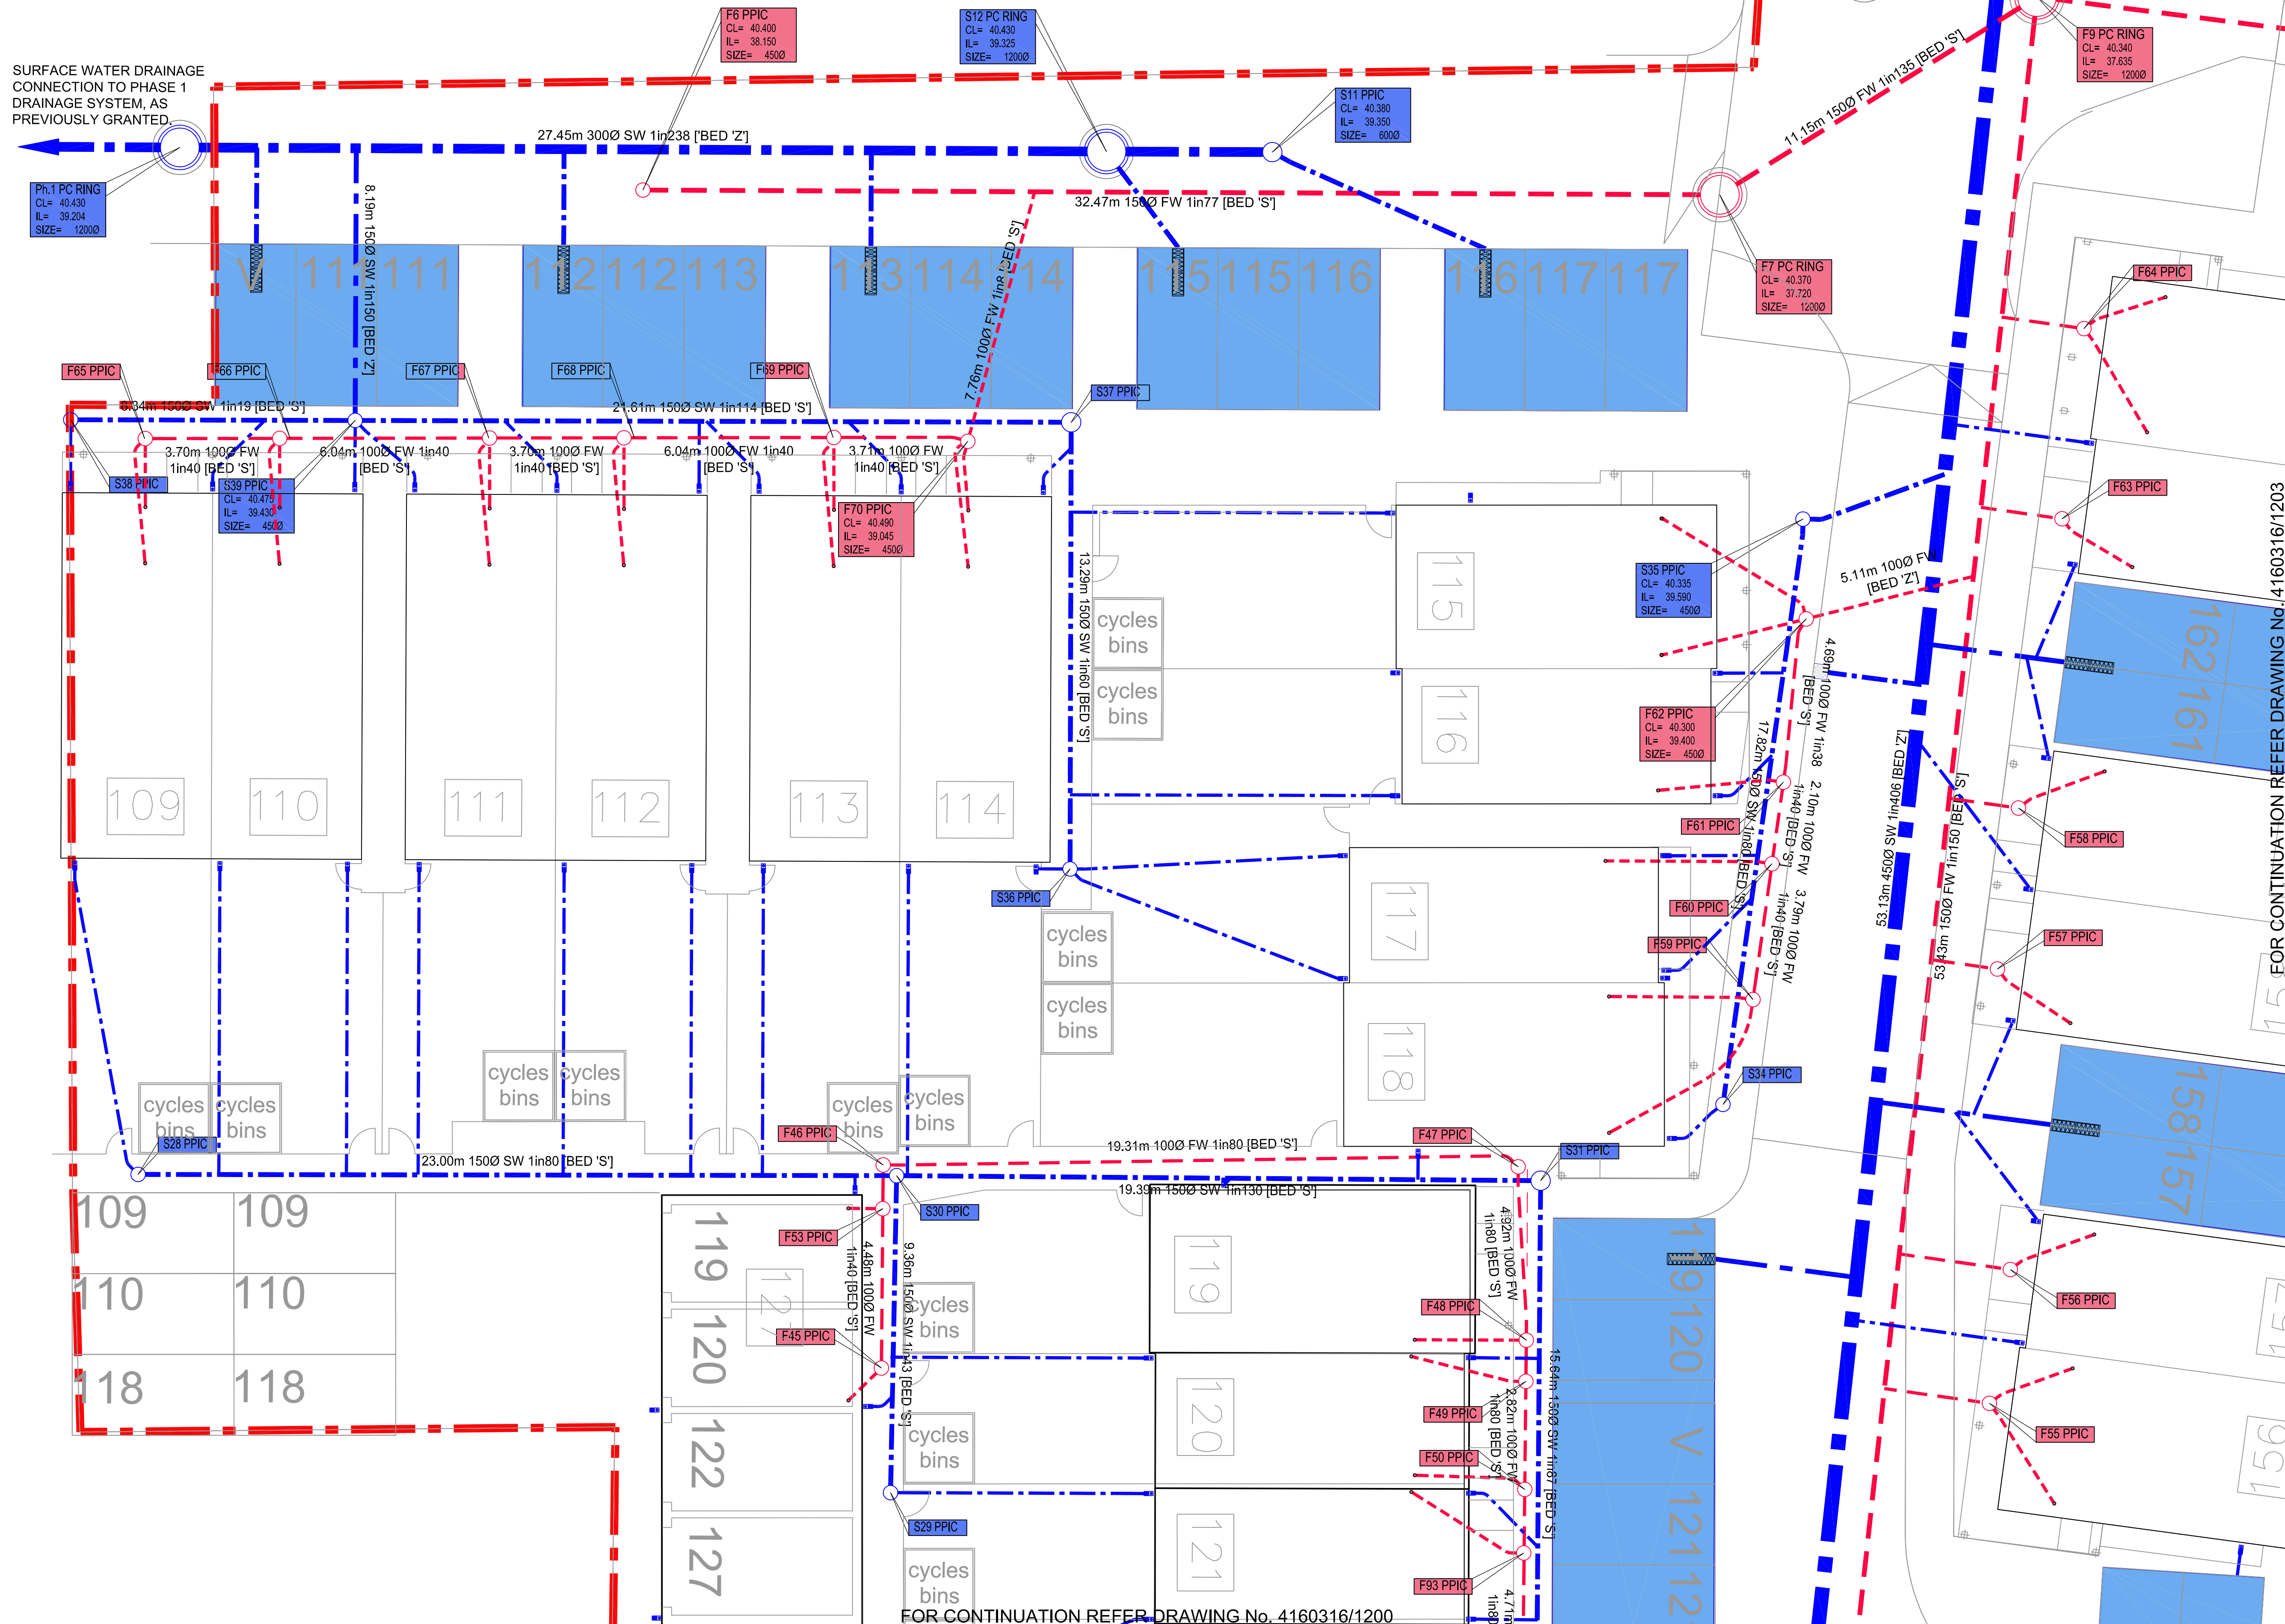


GENERAL NOTES

1. THIS DRAWING MUST NOT BE SCALED OFF.
WORK TO FIGURED DIMENSIONS ONLY.
2. THIS DRAWING IS TO BE READ IN CONJUNCTION
WITH ALL RELEVANT DRAWINGS, DOCUMENTS &
SPECIFICATIONS.
3. REFER TO DRAWING No. 4160316-1204 FOR
DRAINAGE NOTES.

KEY

- Phase 3A Boundary
- Flat Boundary Excluded from Phase 3A
- Lined permeable parking space with
100mmØ connection to SW network
- Proposed FW Sewer
- Proposed FW Manhole
- Proposed FW Polyprop Inspection Chamber
- Proposed SW Sewer
- Proposed SW Manhole
- Existing Manhole Details
- Proposed FW Manhole Details
- Proposed SW Manhole Details
- Indicative SW drainage line serving
individual properties
- Indicative FW drainage line serving
individual properties
- Diffuser unit to permeable sub-base.
2No. Permavoid 150 units or equal.

ALL SVP AND RWP LOCATIONS TO
BE CONFIRMED BY THE
ARCHITECT AND ARE INDICATED
FOR INFORMATION ONLY.

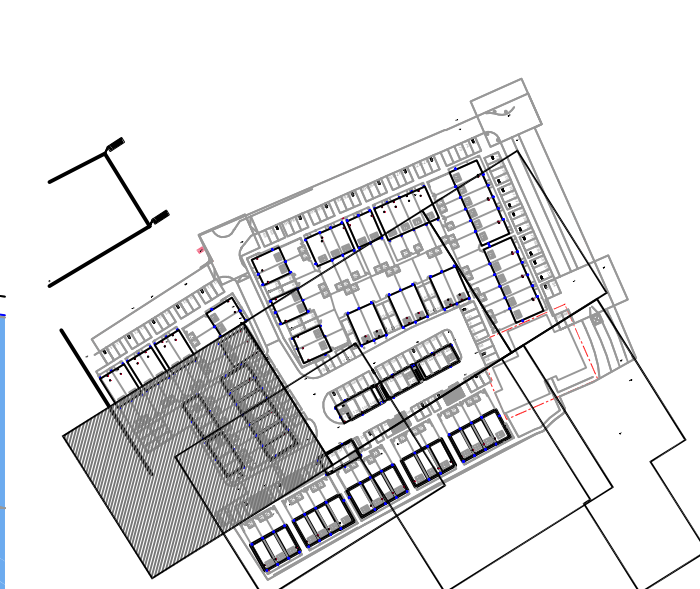

KEY PLAN

Scale 1:2500

FOR
CONSTRUCTION

C6	COVER LEVELS REDUCED, UPDATED SVP & RWP LOCATIONS ADDED.	KJ	29.11.2016
C5	ISSUED FOR DS2 PACK	KJ	27.09.2016
C4	ARCHITECT BACKGROUND UPDATED	KJ	01.09.2016
C3	DRAWING UPDATED AND RE-ISSUED WITH GROUNDWORKS PACKAGE	KJ	26.08.2016
C2	ARCHITECT'S LAYOUT UPDATED, ISSUED FOR GROUNDWORKS PACKAGE	KJ	12.08.2016
C1	CONSTRUCTION ISSUE	KJ	08.07.2016
P1	FIRST ISSUE	KJ	06.07.2016
Rev.	Description	Date	Chkd

Glanville
3 Grovelands Business Centre
Boundary Way
Hemel Hempstead, Herts. HP2 7TE
Tel: (01442) 835999 Fax: (01442) 258924
postbox@glanvillegroup.com www.glanvillegroup.com

Client : **St Edward**
Designed for life

Project : **GREEN PARK VILLAGE
READING**

Title : **PHASE 3A
PROPOSED DRAINAGE LAYOUT
Sheet 3 of 6**

Project Engineer : KJ Scale : 1:100@A1
Project Director : HBG Date : June 2016
Status : **CONSTRUCTION**

Drawing No. 4160316-1202 Rev C6