

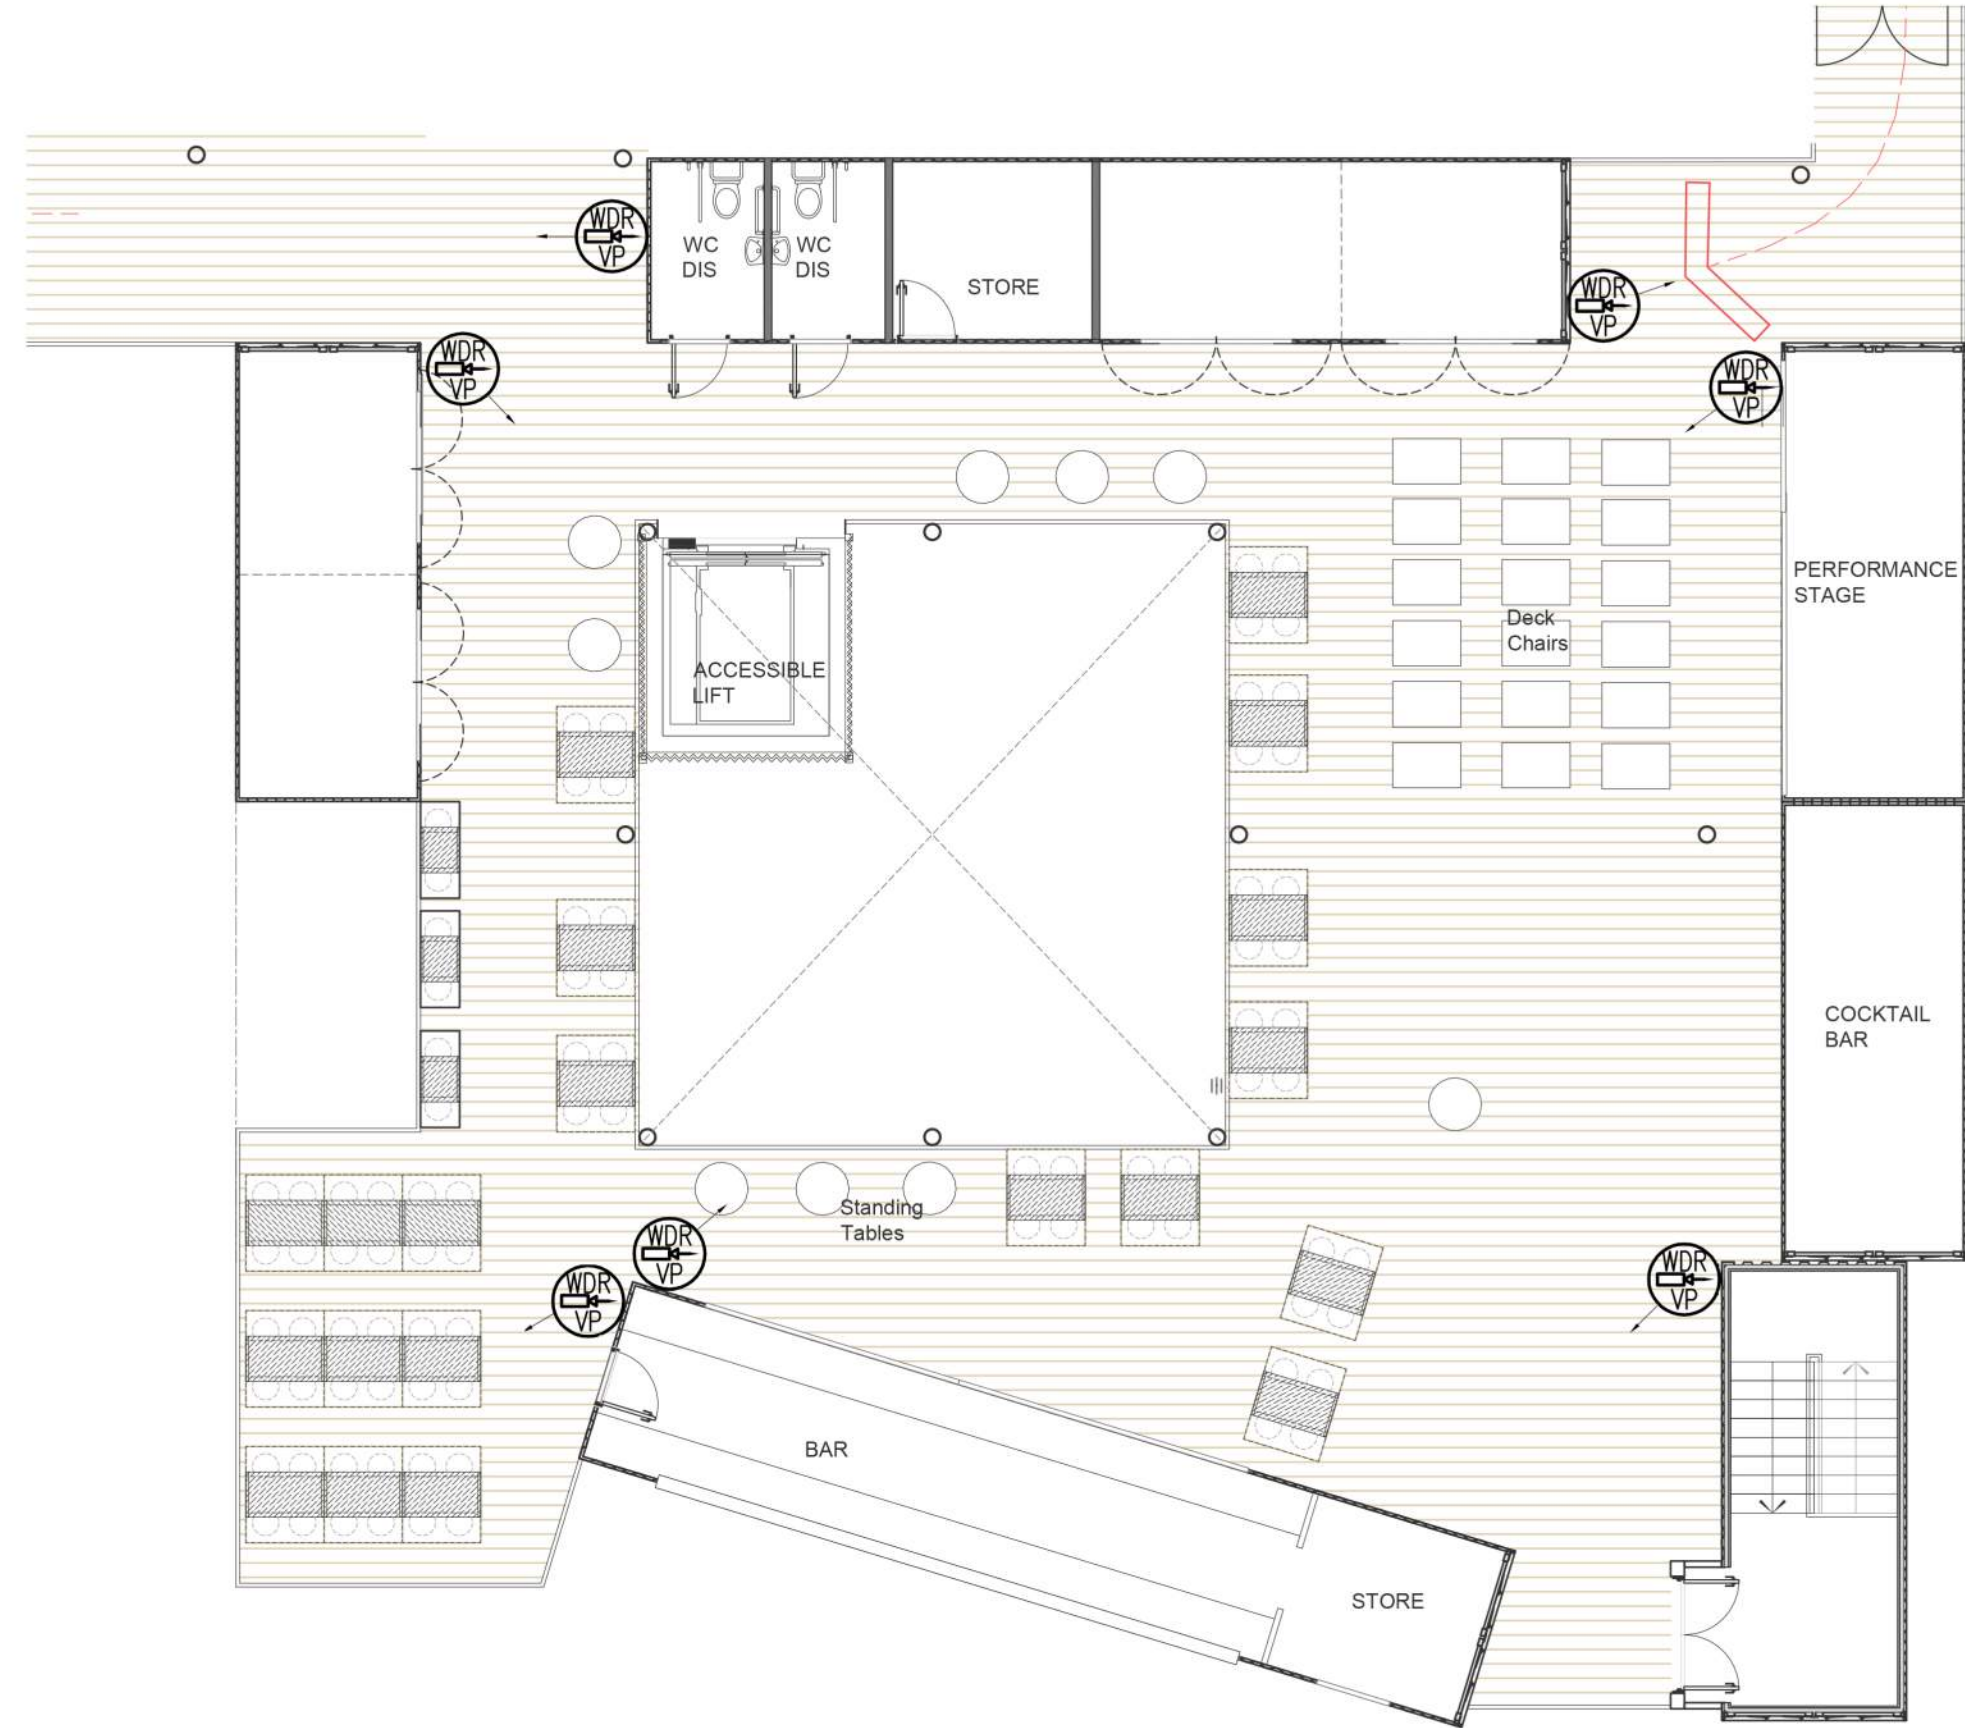


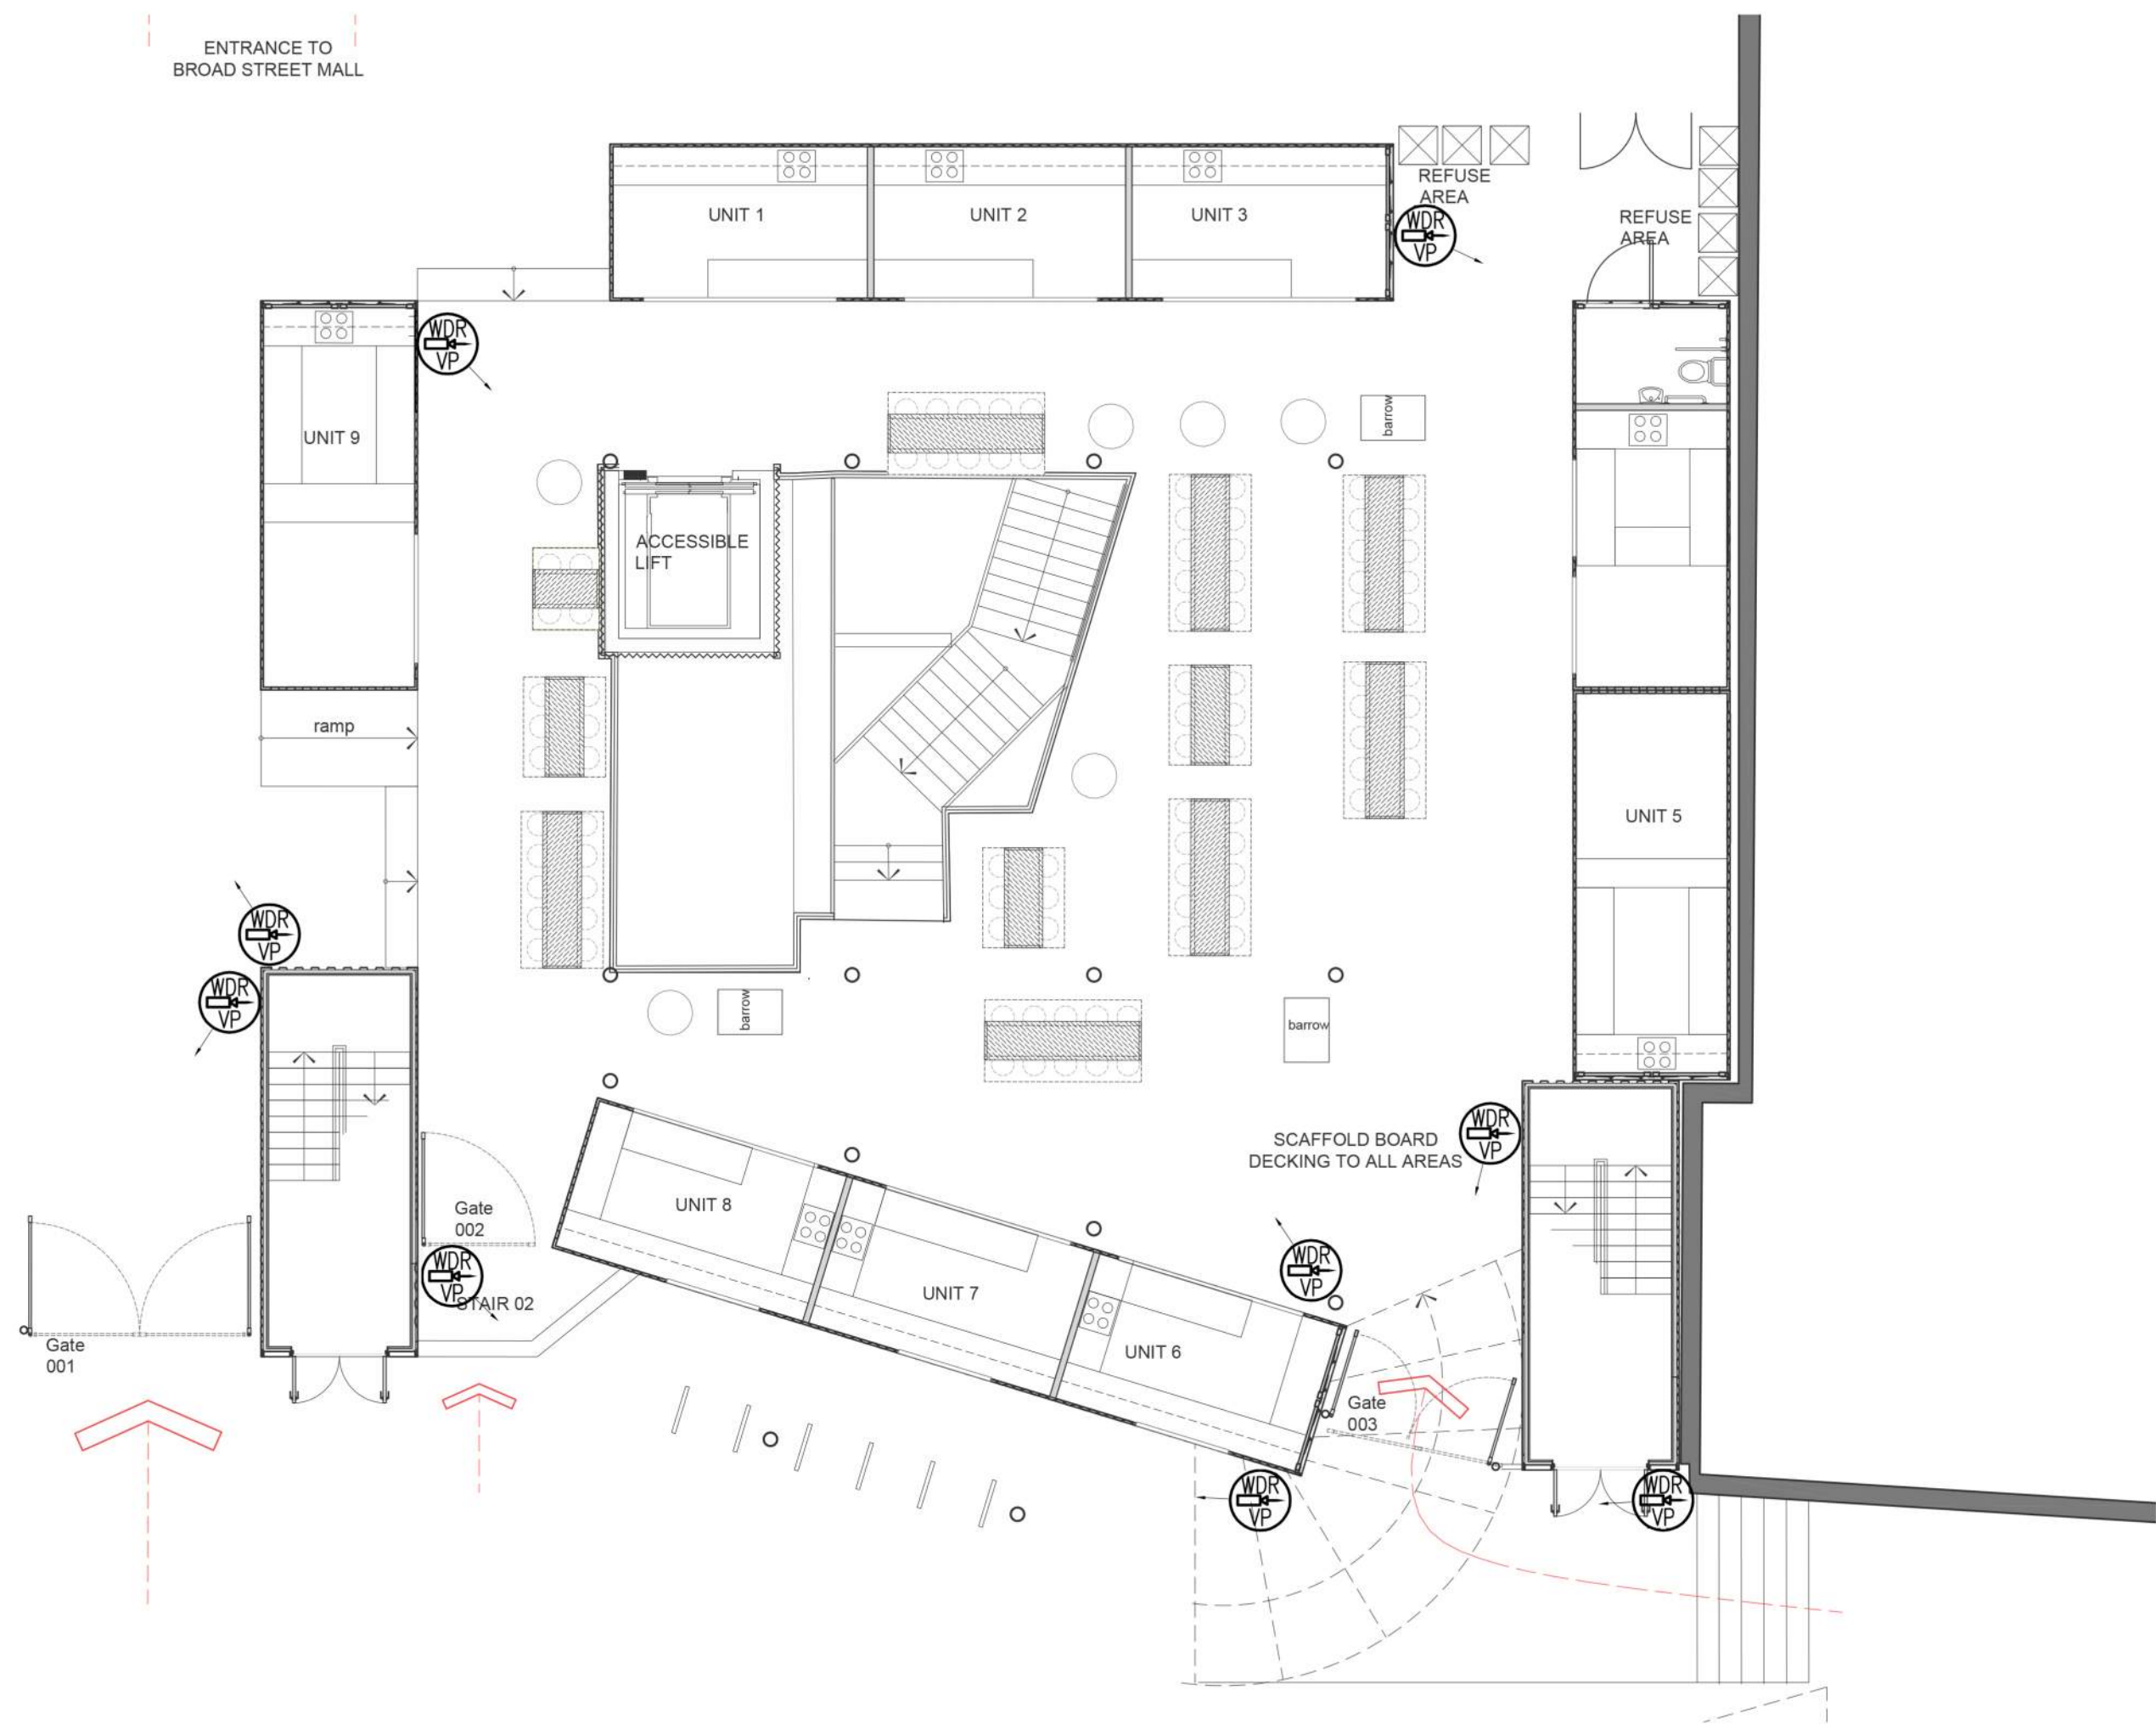

LEGEND
EXTERNAL C.C.T.V. VANDAL PROOF WIDE DYNAMIC RANGE CAMERA
RED ARROW DENOTES GENERAL DIRECTION OF CAMERA CENTRE

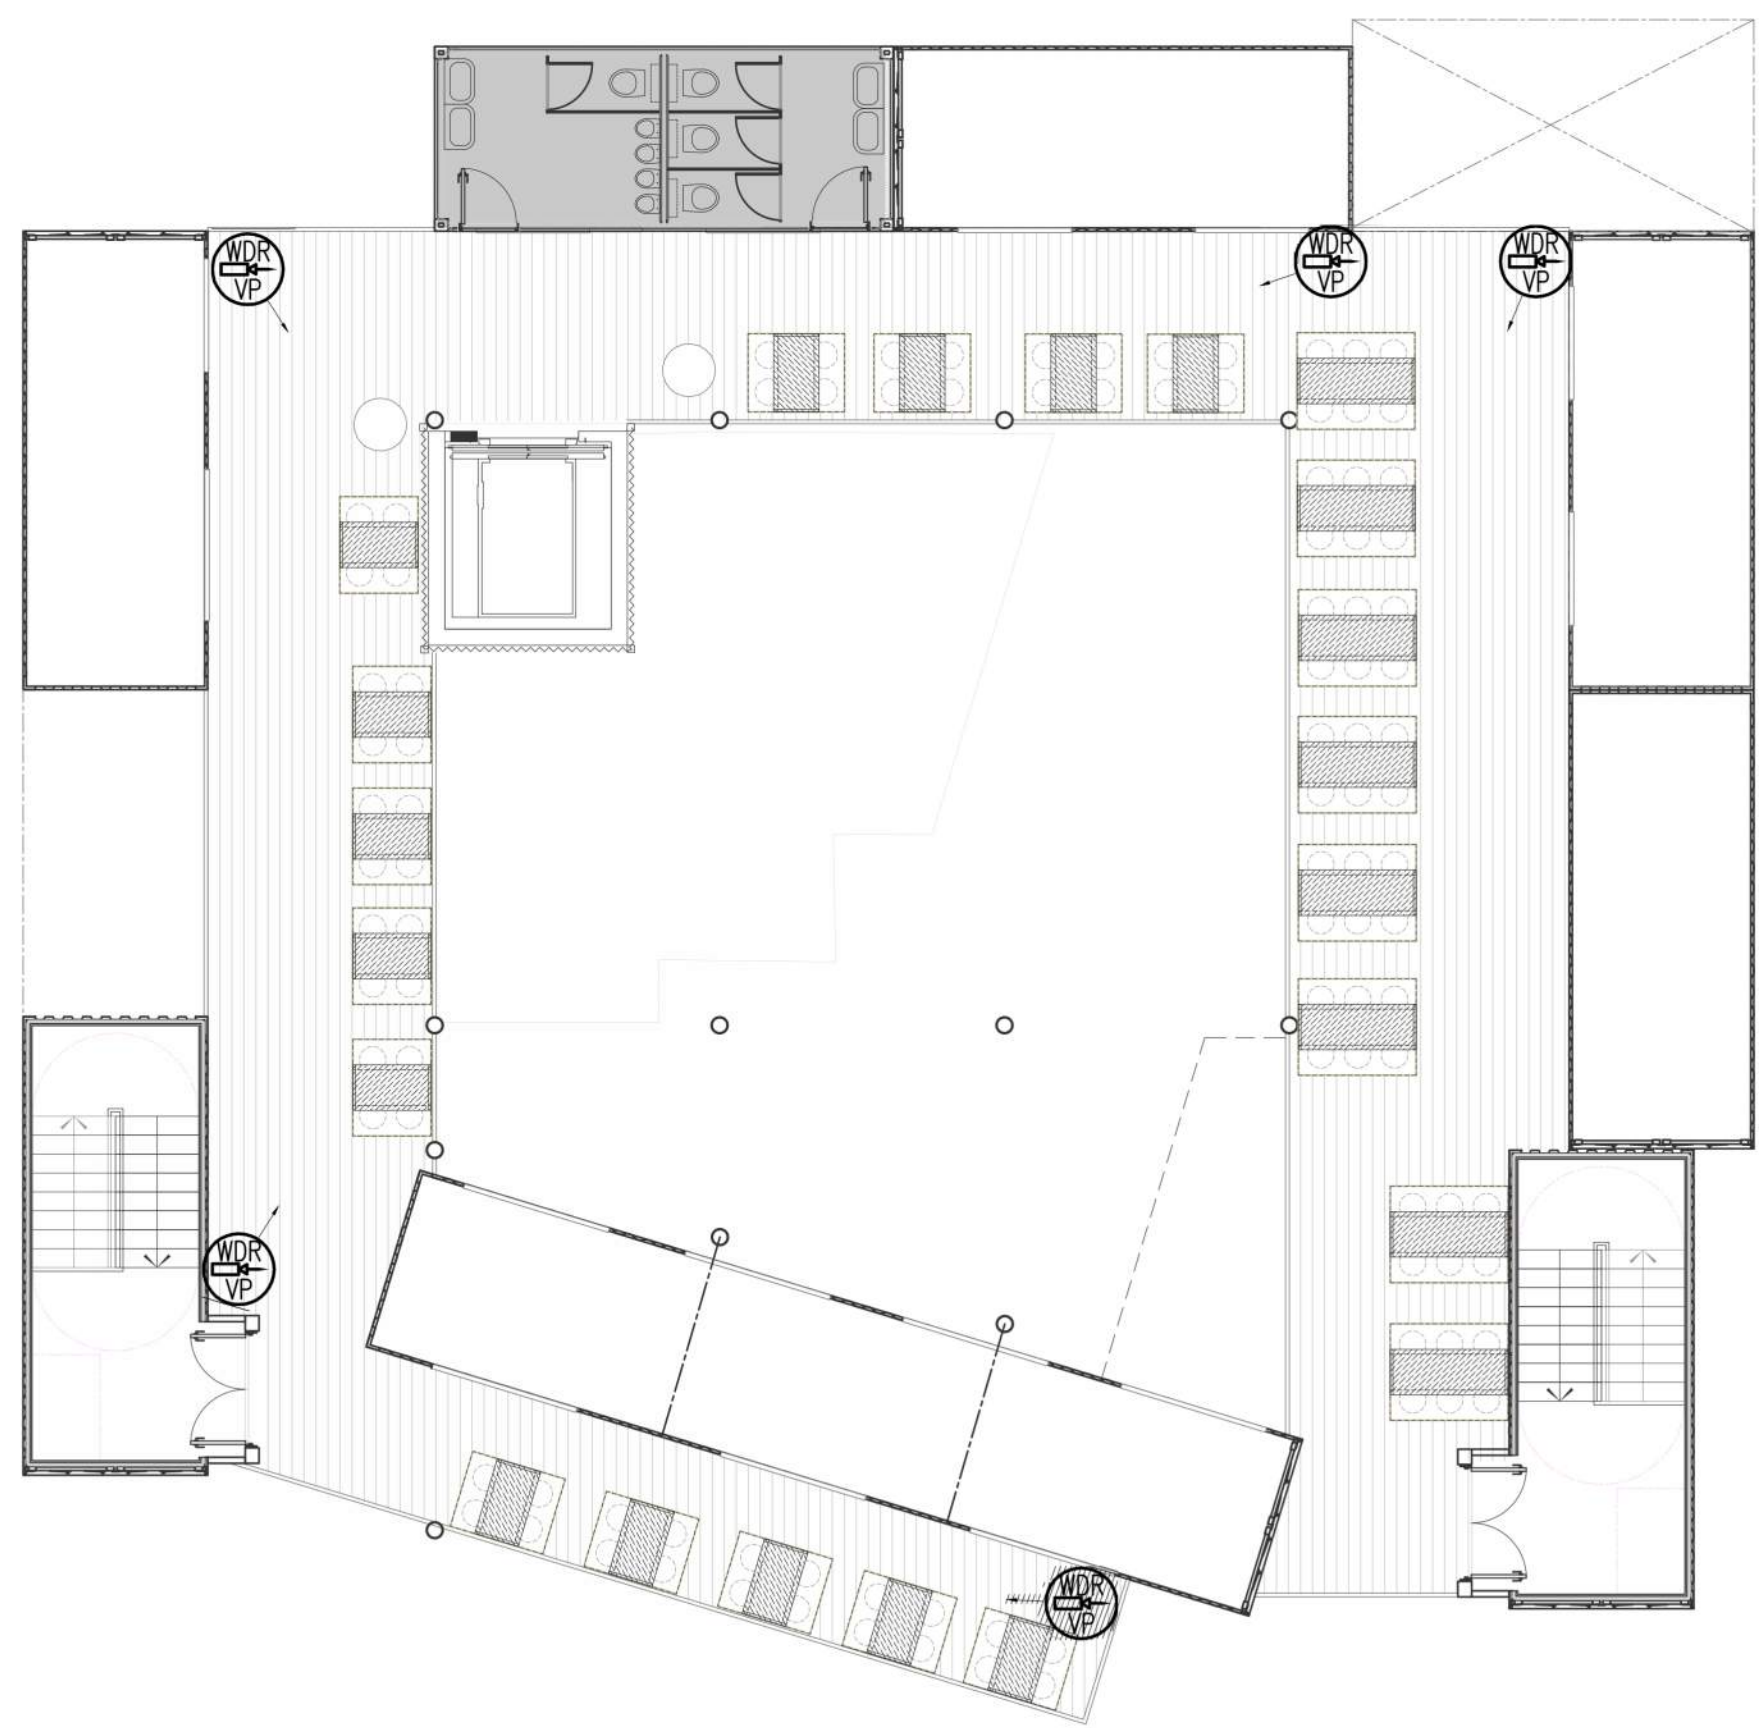

Rev	Date	Amendments	By
-	-----	-----	--

Notes

FOR INFORMATION

dowling blunt

3 Bermondsey Exchange
179-181 Bermondsey Street
London SE1 3UW

Tel: 020 7407 1444
www.dowlingblunt.co.uk
dblondon@dowlingblunt.co.uk

Client

Project

READING – SOUTH COURT
NEW SCHEME

Title

ELECTRICAL SERVICES
SECURITY LAYOUT
ALL FLOORS

Scale	1:100 @ A1		
Date	23/03/2018		
Drawn by	CK		
Electrical Checked by		Mechanical Checked by	
Drawing No.	J2949/ES/001	Revision (-)	

COPYRIGHT
THIS DRAWING IS PUBLISHED BY DOWLING BLUNT LIMITED, LONDON. ALL RIGHTS RESERVED.
NO PART OF THIS DRAWING MAY BE REPRODUCED, STORED IN A RETRIEVAL SYSTEM, OR TRANSMITTED,
IN ANY FORM OR BY ANY MEANS, ELECTRONIC, MECHANICAL, PHOTOCOPYING, RECORDING OR OTHERWISE
WITHOUT PRIOR PERMISSION OF THE COMPANY.