

FOR CONTINUATION REFER DRAWING No. 4160316/1202

GENERAL NOTES

1. THIS DRAWING MUST NOT BE SCALED OFF. WORK TO FIGURED DIMENSIONS ONLY.
2. THIS DRAWING IS TO BE READ IN CONJUNCTION WITH ALL RELEVANT DRAWINGS, DOCUMENTS & SPECIFICATIONS.
3. REFER TO DRAWING No. 4160316-1204 FOR DRAINAGE NOTES.

KEY

- Phase 3A Boundary
- Flat Boundary Excluded from Phase 3A
- Lined permeable parking space with 100mmØ connection to SW network
- Proposed FW Sewer
- Proposed FW Manhole
- Proposed FW Polyprop Inspection Chamber
- Proposed SW Sewer
- Proposed SW Manhole
- Existing Manhole Details
- Proposed FW Manhole Details
- Proposed SW Manhole Details
- Indicative SW drainage line serving individual properties
- Indicative FW drainage line serving individual properties
- Diffuser unit to permeable sub-base. 2No. Permavoid 150 units or equal.

ALL SVP AND RWP LOCATIONS TO BE CONFIRMED BY THE ARCHITECT AND ARE INDICATED FOR INFORMATION ONLY.



KEY PLAN

Scale 1:2500

FOR CONSTRUCTION

|    |                                                            |    |            |
|----|------------------------------------------------------------|----|------------|
| C6 | COVER LEVELS REDUCED, UPDATED SVP & RWP LOCATIONS ADDED.   | KJ | 29.11.2016 |
| C5 | ISSUED FOR DS2 PACK                                        | KJ | 27.09.2016 |
| C4 | ARCHITECT BACKGROUND UPDATED                               | KJ | 01.09.2016 |
| C3 | DRAWING UPDATED AND RE-ISSUED WITH GROUNDWORKS PACKAGE     | KJ | 26.08.2016 |
| C2 | ARCHITECT'S LAYOUT UPDATED, ISSUED FOR GROUNDWORKS PACKAGE | KJ | 12.08.2016 |
| C1 | CONSTRUCTION ISSUE                                         | KJ | 08.07.2016 |
| P1 | FIRST ISSUE                                                | KJ | 06.07.2016 |

| Rev. | Description | Date | Chkd |
|------|-------------|------|------|
|------|-------------|------|------|

**Glanville**  
3 Grovelands Business Centre  
Boundary Way  
Hemel Hempstead, Herts. HP2 7TE  
Tel: (01442) 835999 Fax: (01442) 258924  
postbox@glanvillegroup.com www.glanvillegroup.com


Client: **St Edward**  
Designed for life

Project: **GREEN PARK VILLAGE READING**

Title: **PHASE 3A PROPOSED DRAINAGE LAYOUT**  
Sheet 1 of 6

Project Engineer: KJ Scale: 1:100@A1  
Project Director: HBG Date: June 2016  
Status: CONSTRUCTION

Drawing No. 4160316-1200 Rev C6

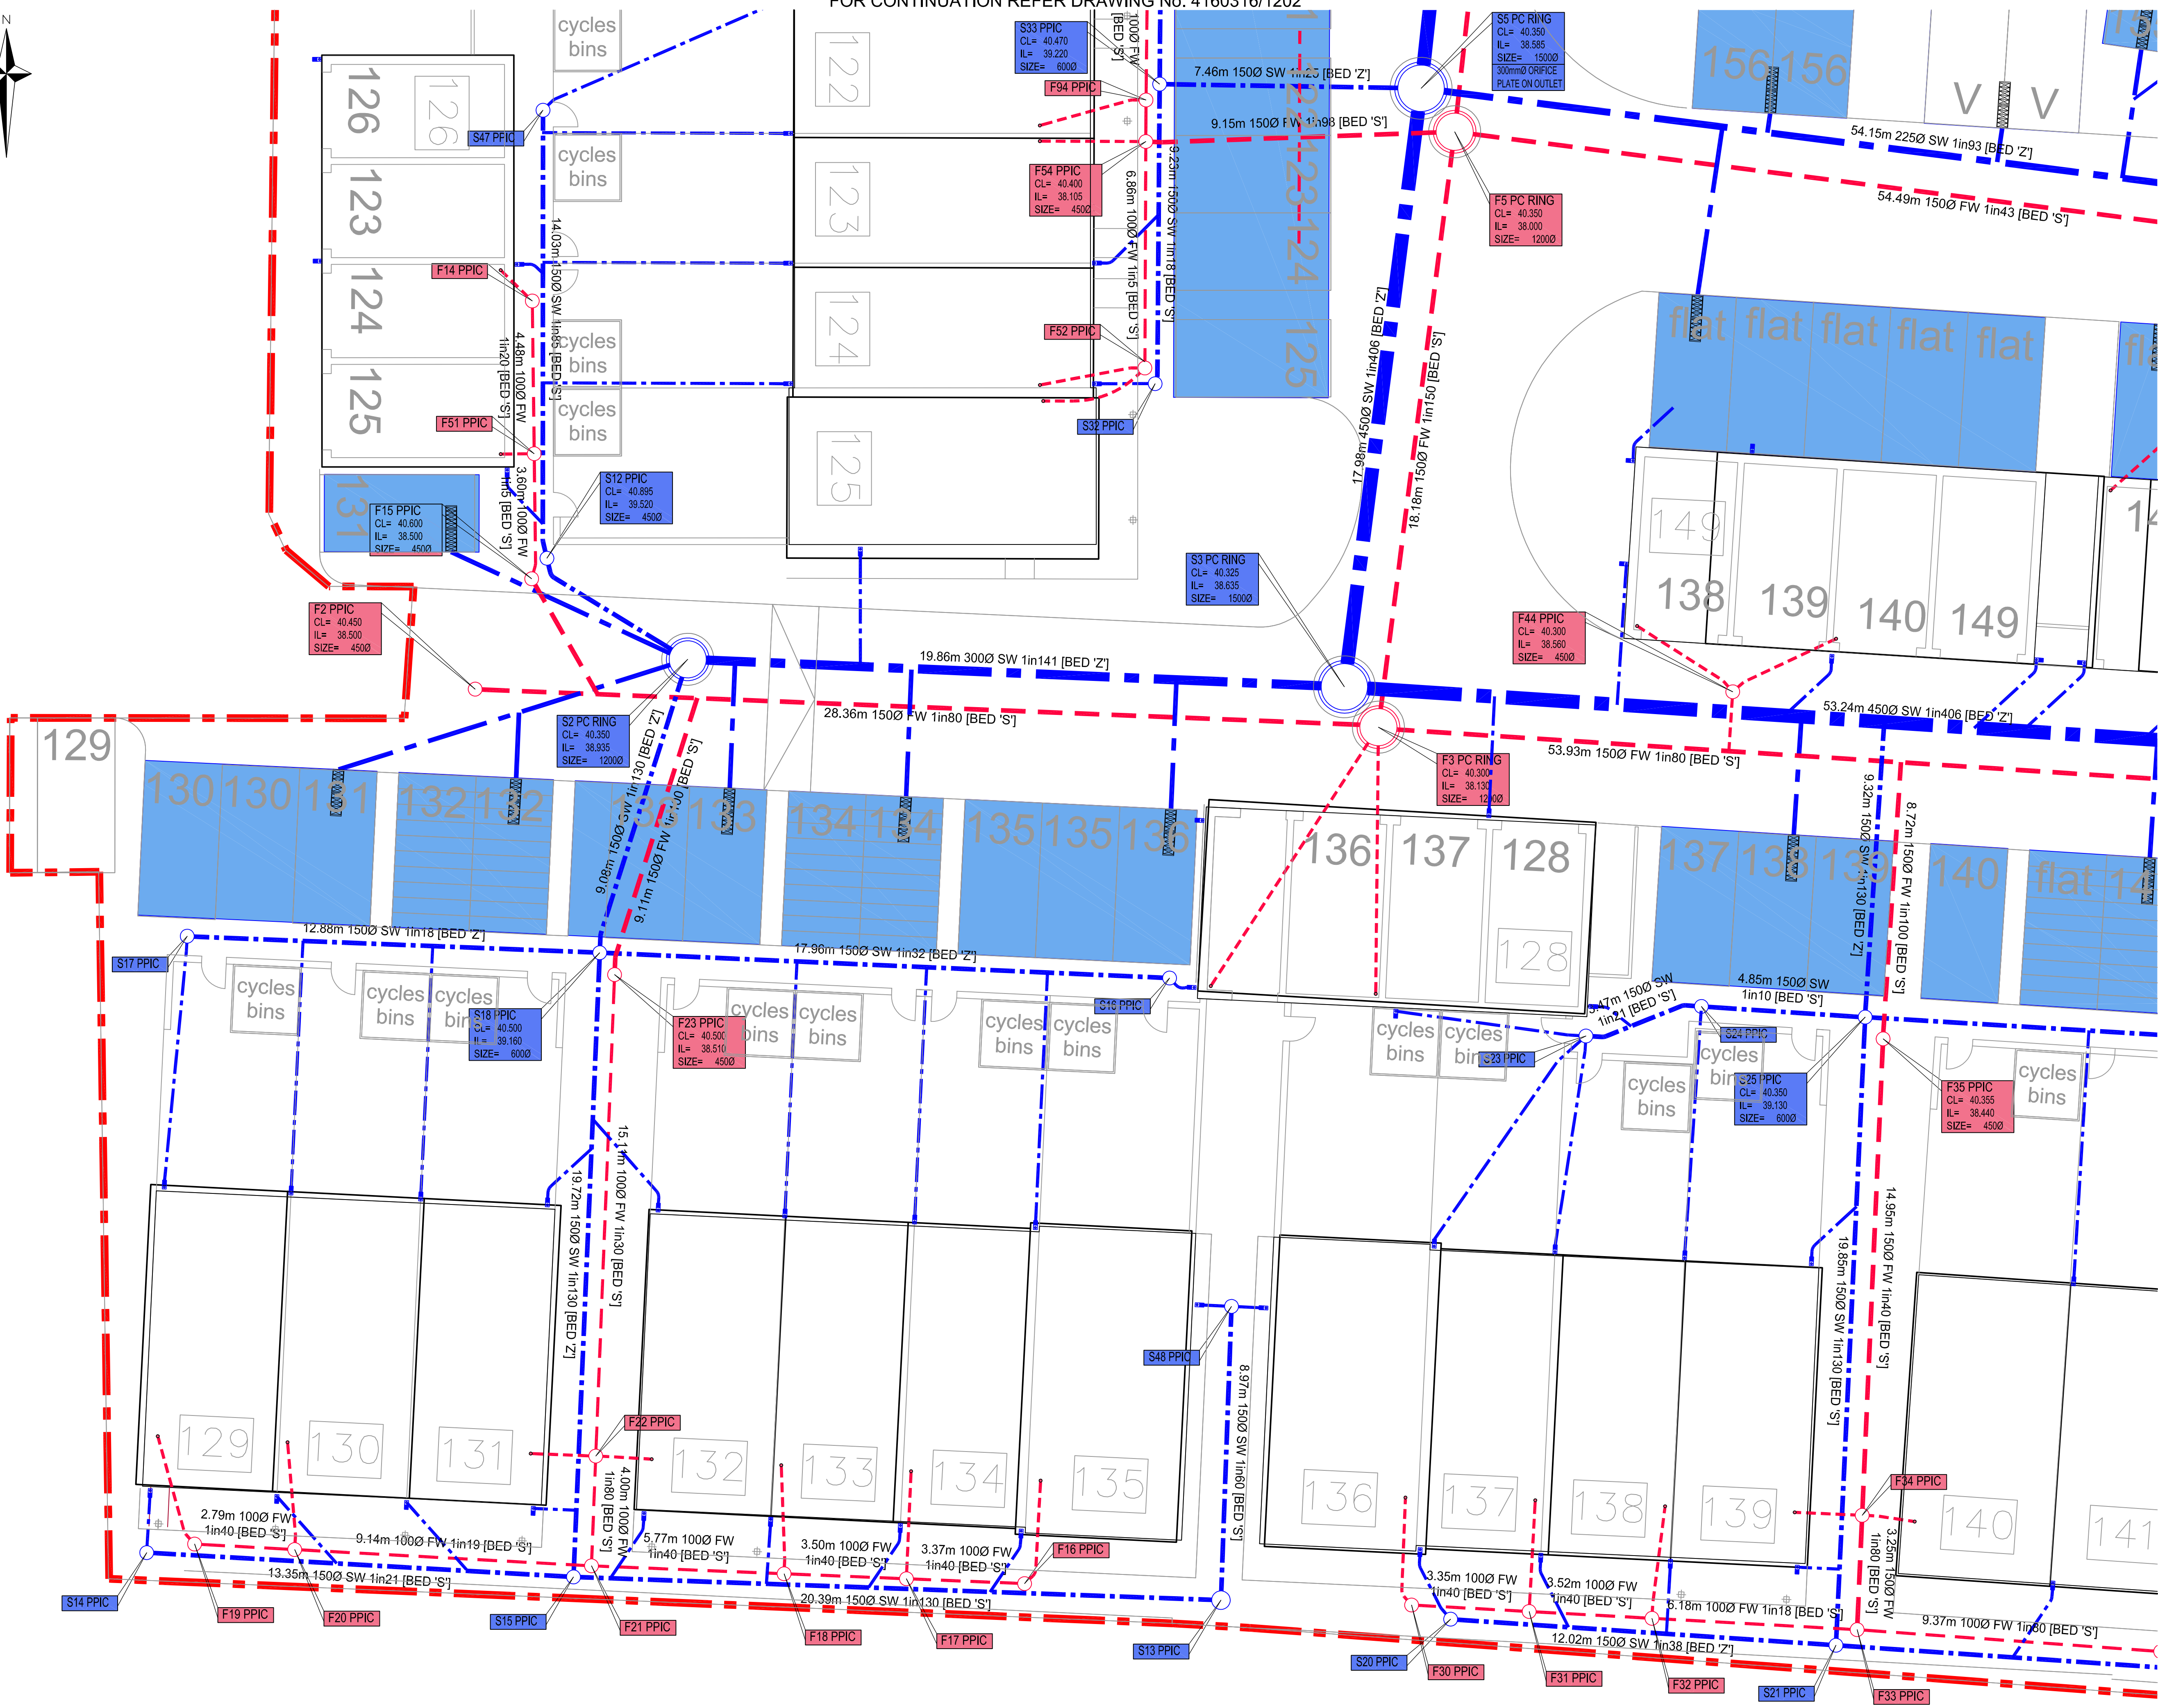

FOR CONTINUATION REFER DRAWING No. 4160316/1201