






OVERALL AREA 0M ABOVE GROUND LEVEL
SCALE: 1:1000
EMin: 0.0 LUX
EMax: 33.4 LUX
EAV: 1.6 LUX

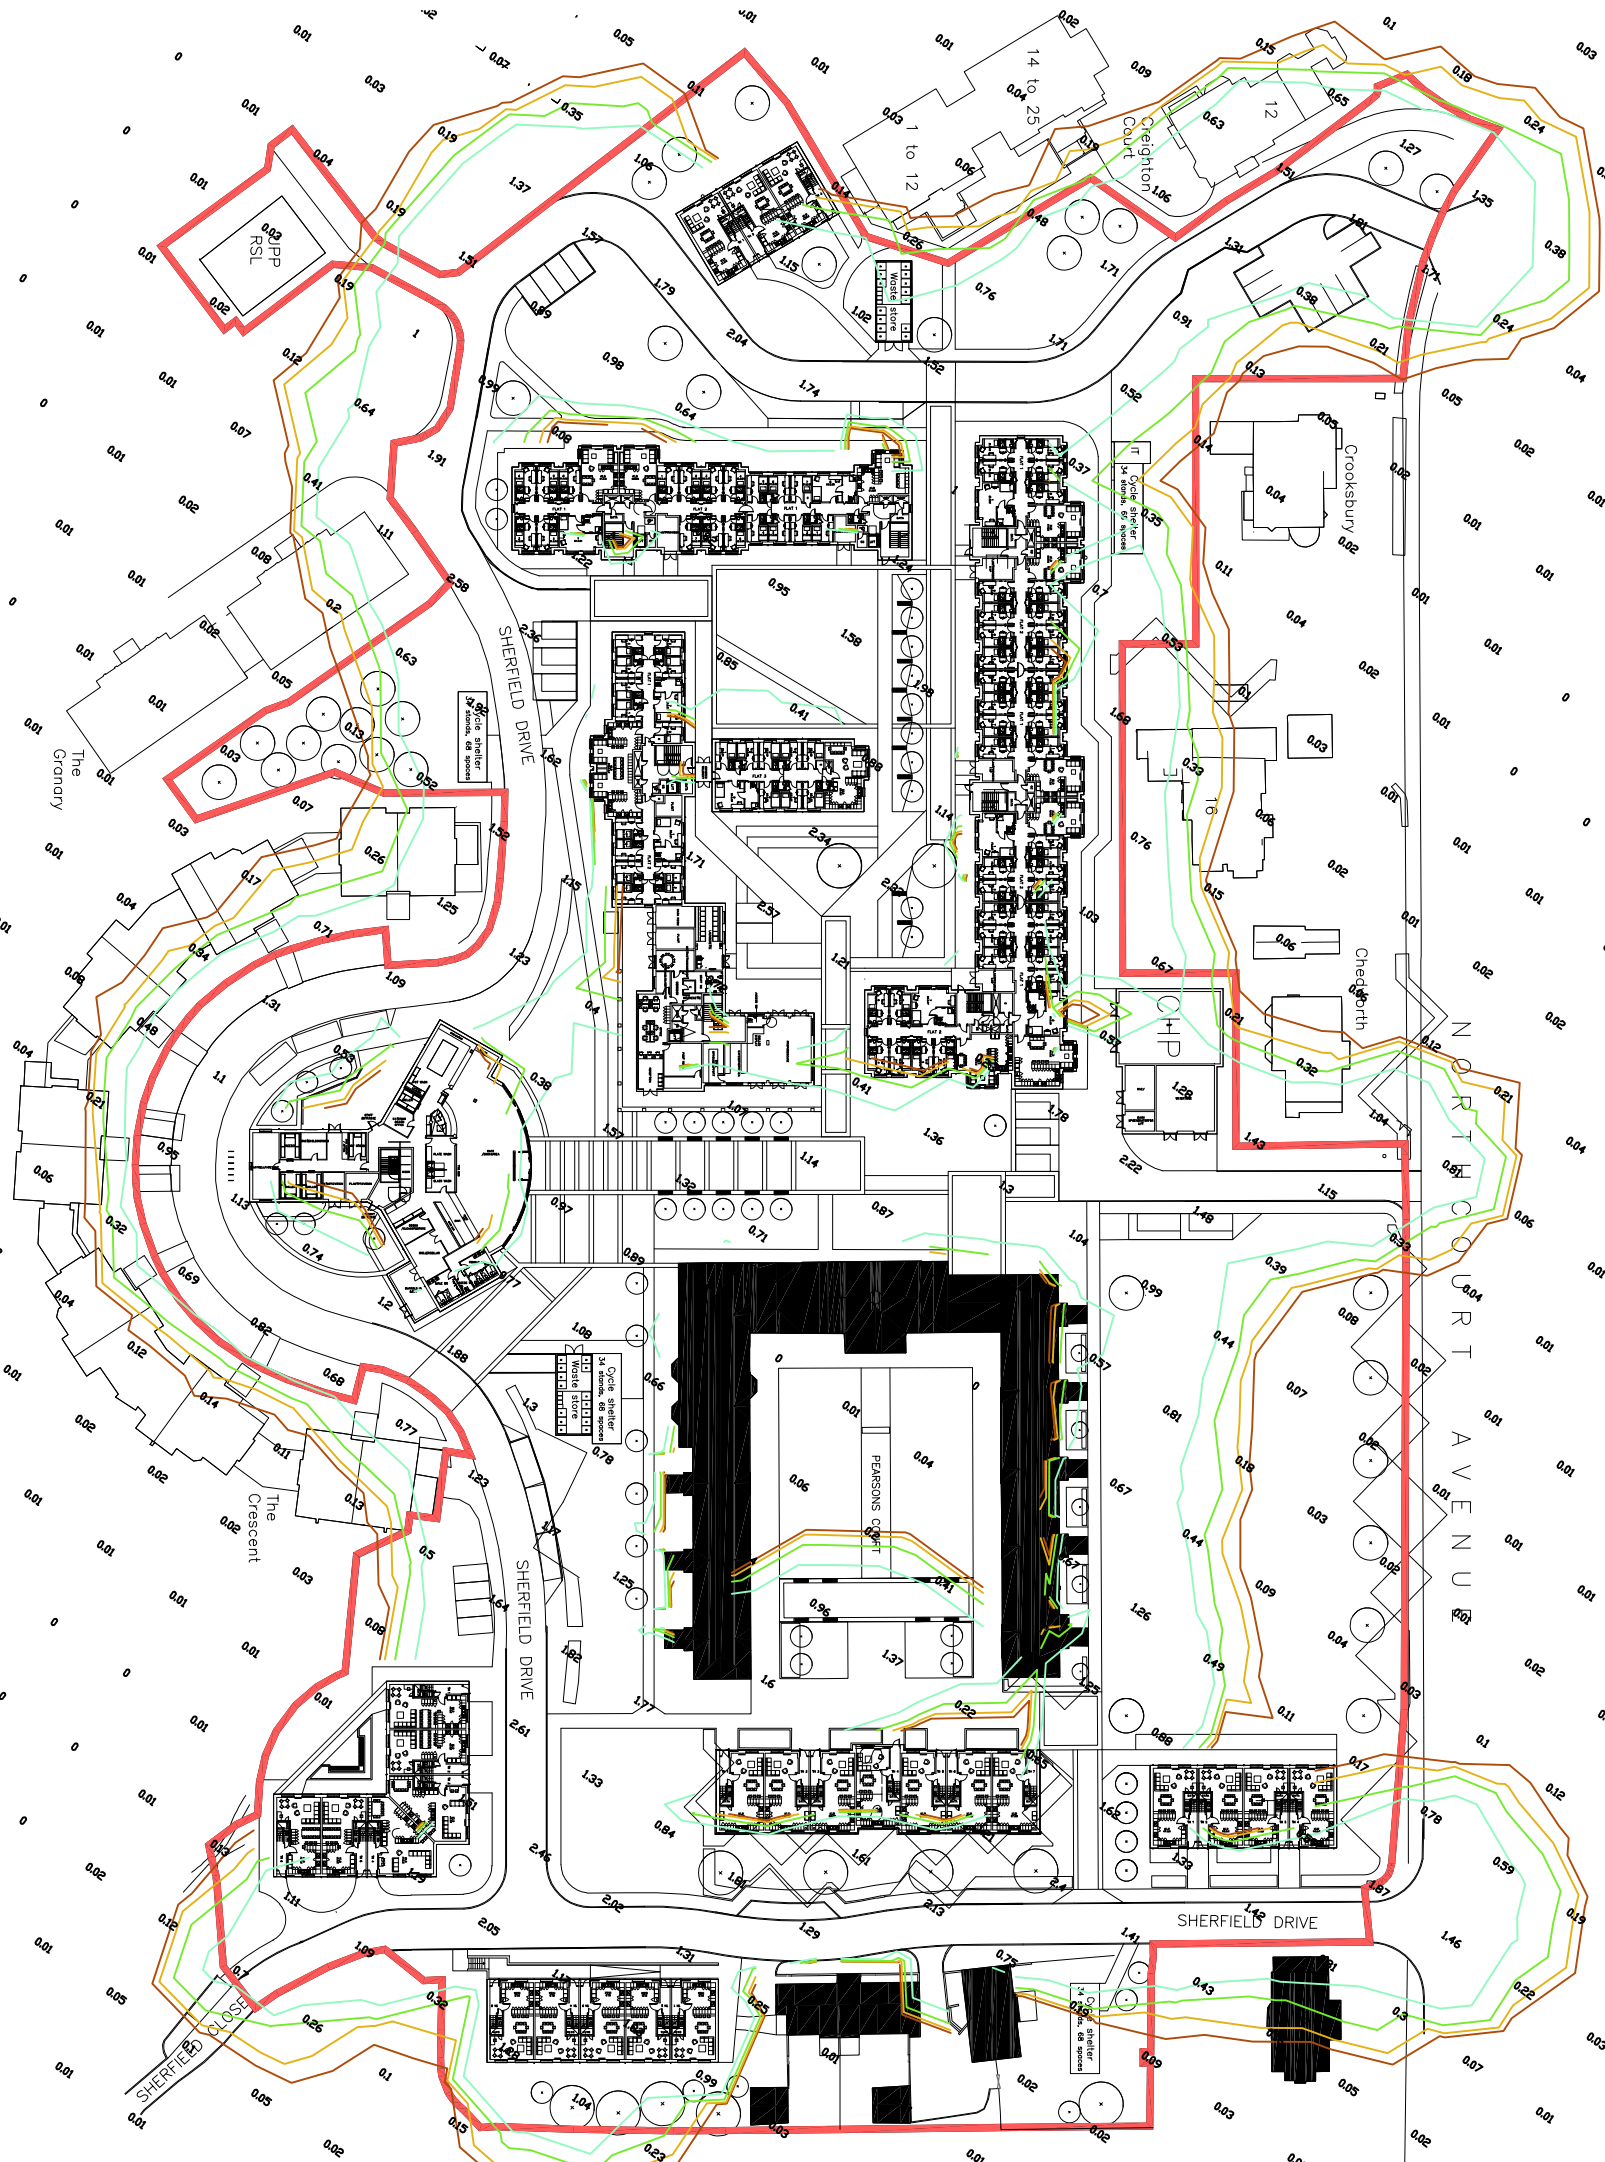

OVERALL AREA 6M ABOVE GROUND LEVEL
SCALE: 1:1000
EMin: 0.00 LUX
EMax: 2.61 LUX
EAV: 0.27 LUX

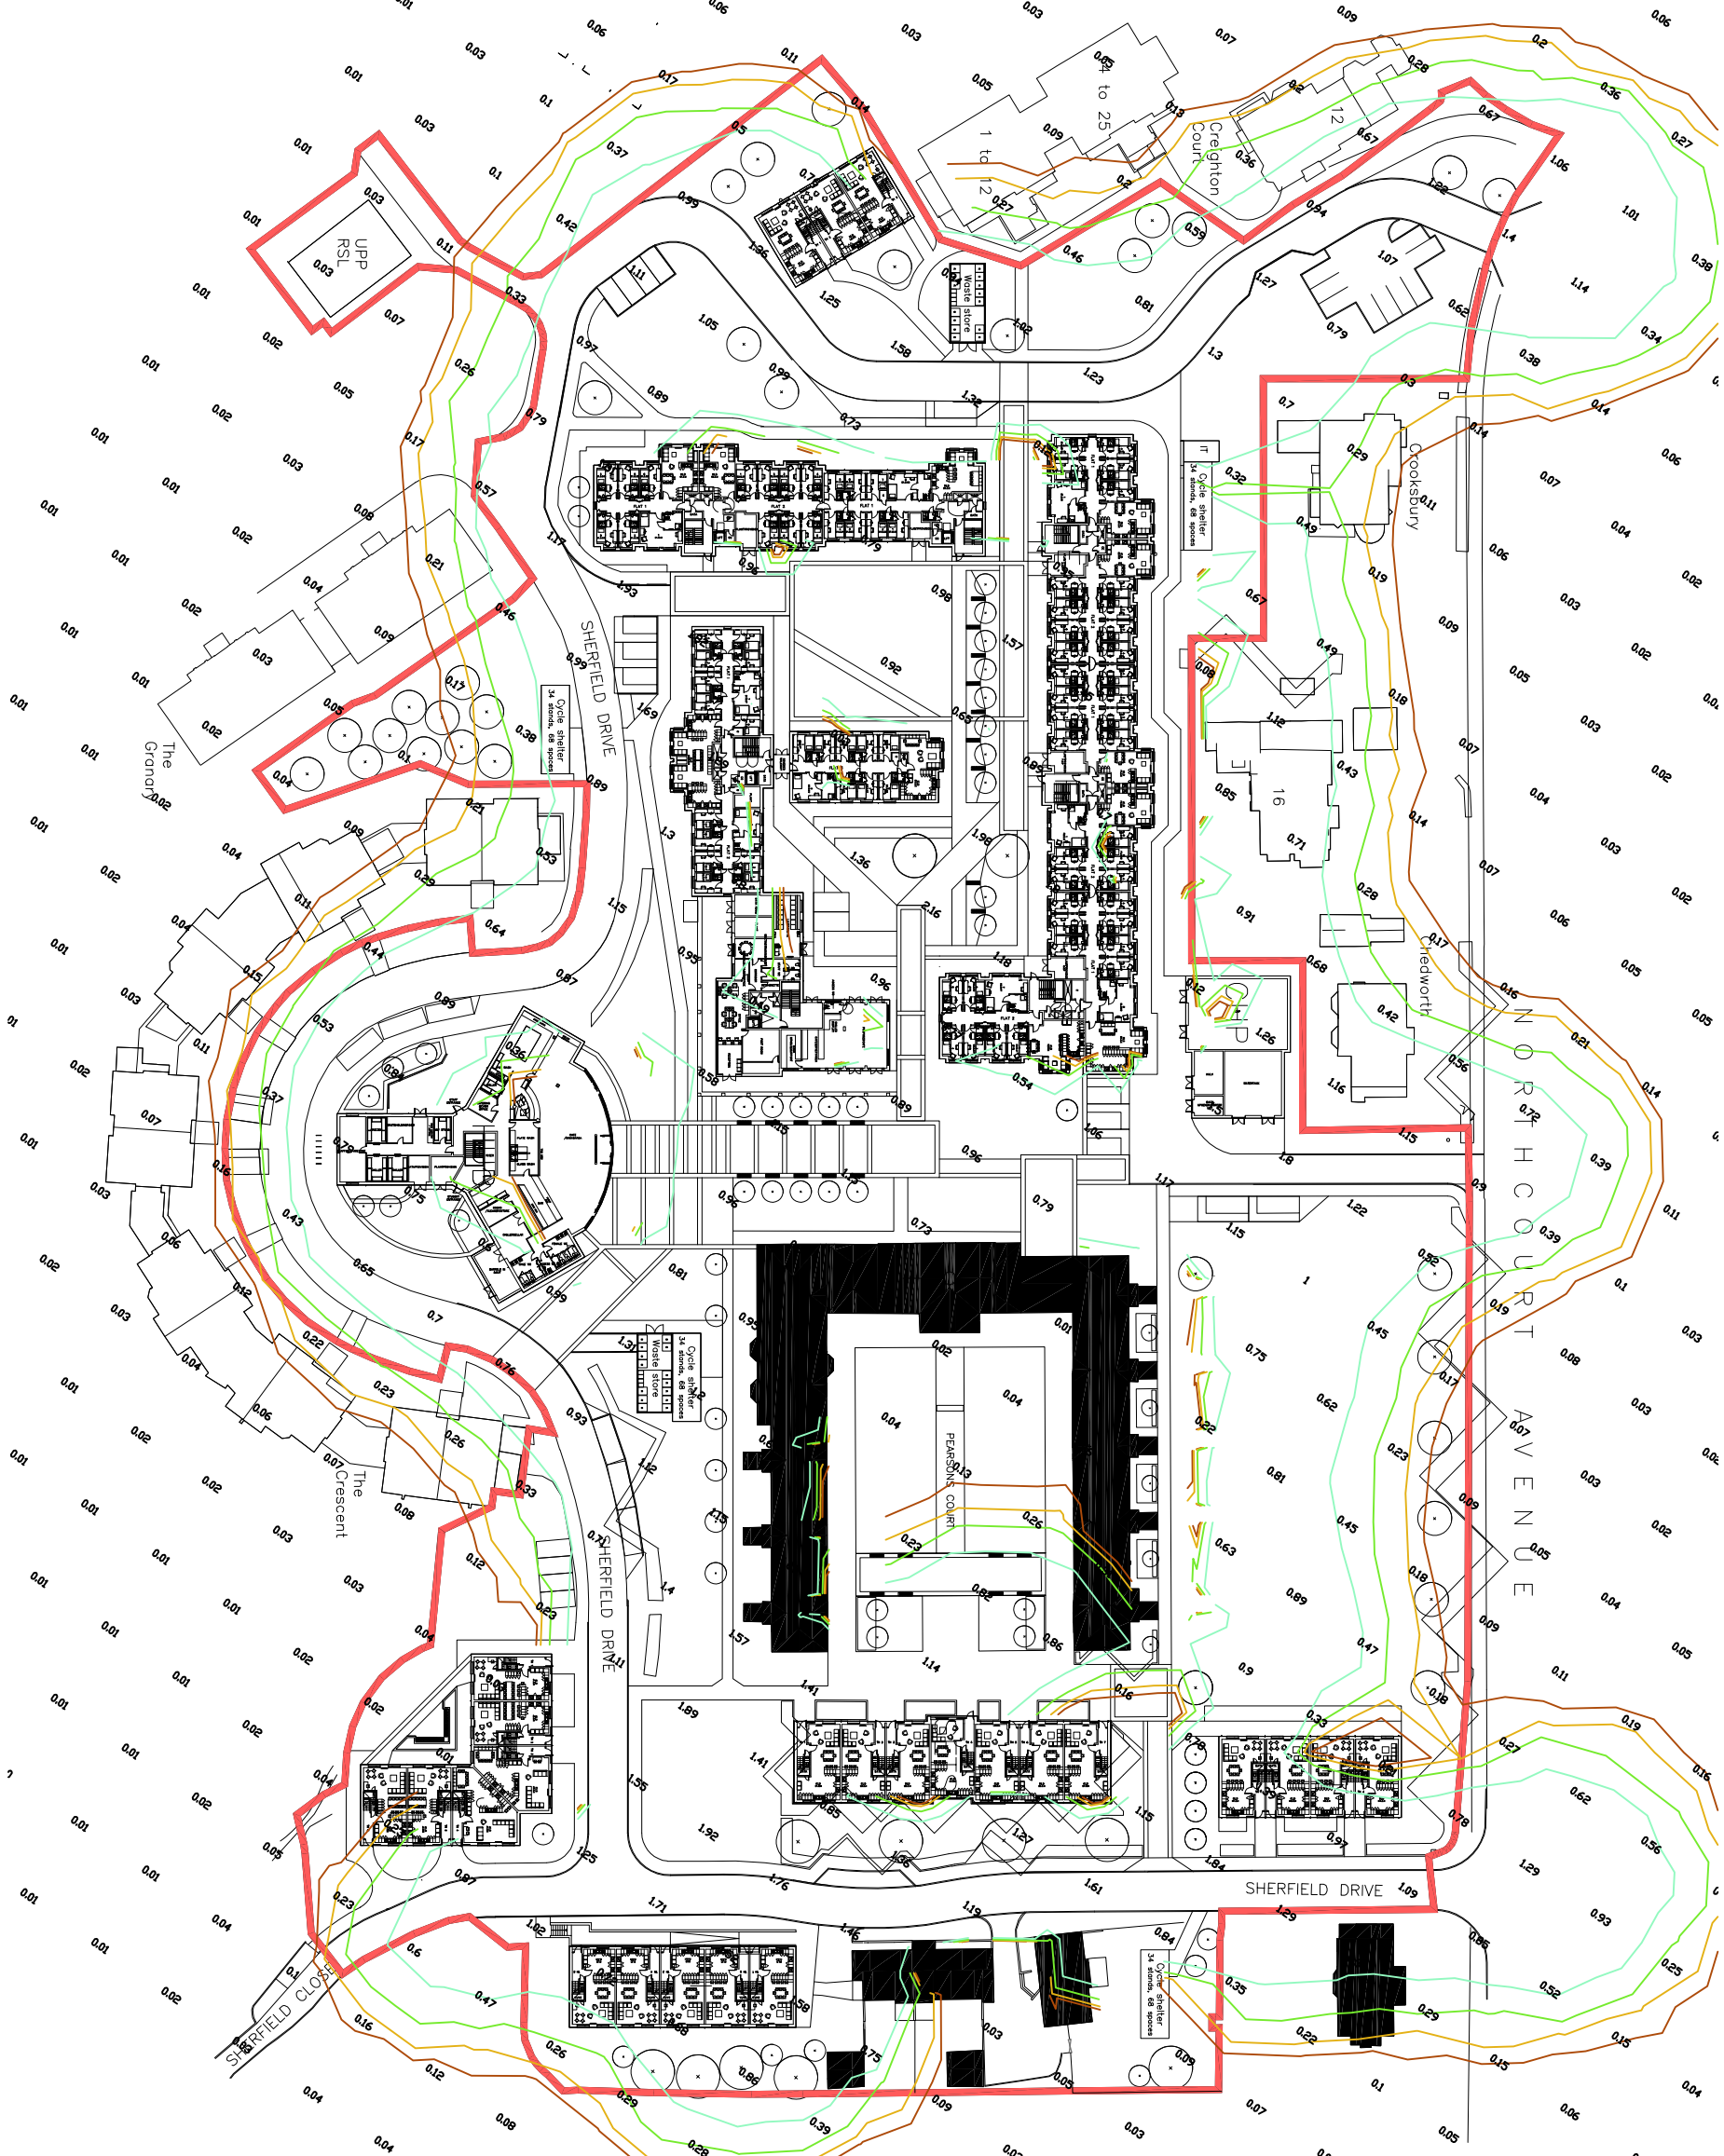


OVERALL AREA 12M ABOVE GROUND LEVEL
SCALE: 1:1000
EMin: 0.00 LUX
EMax: 2.16 LUX
EAV: 0.25LUX

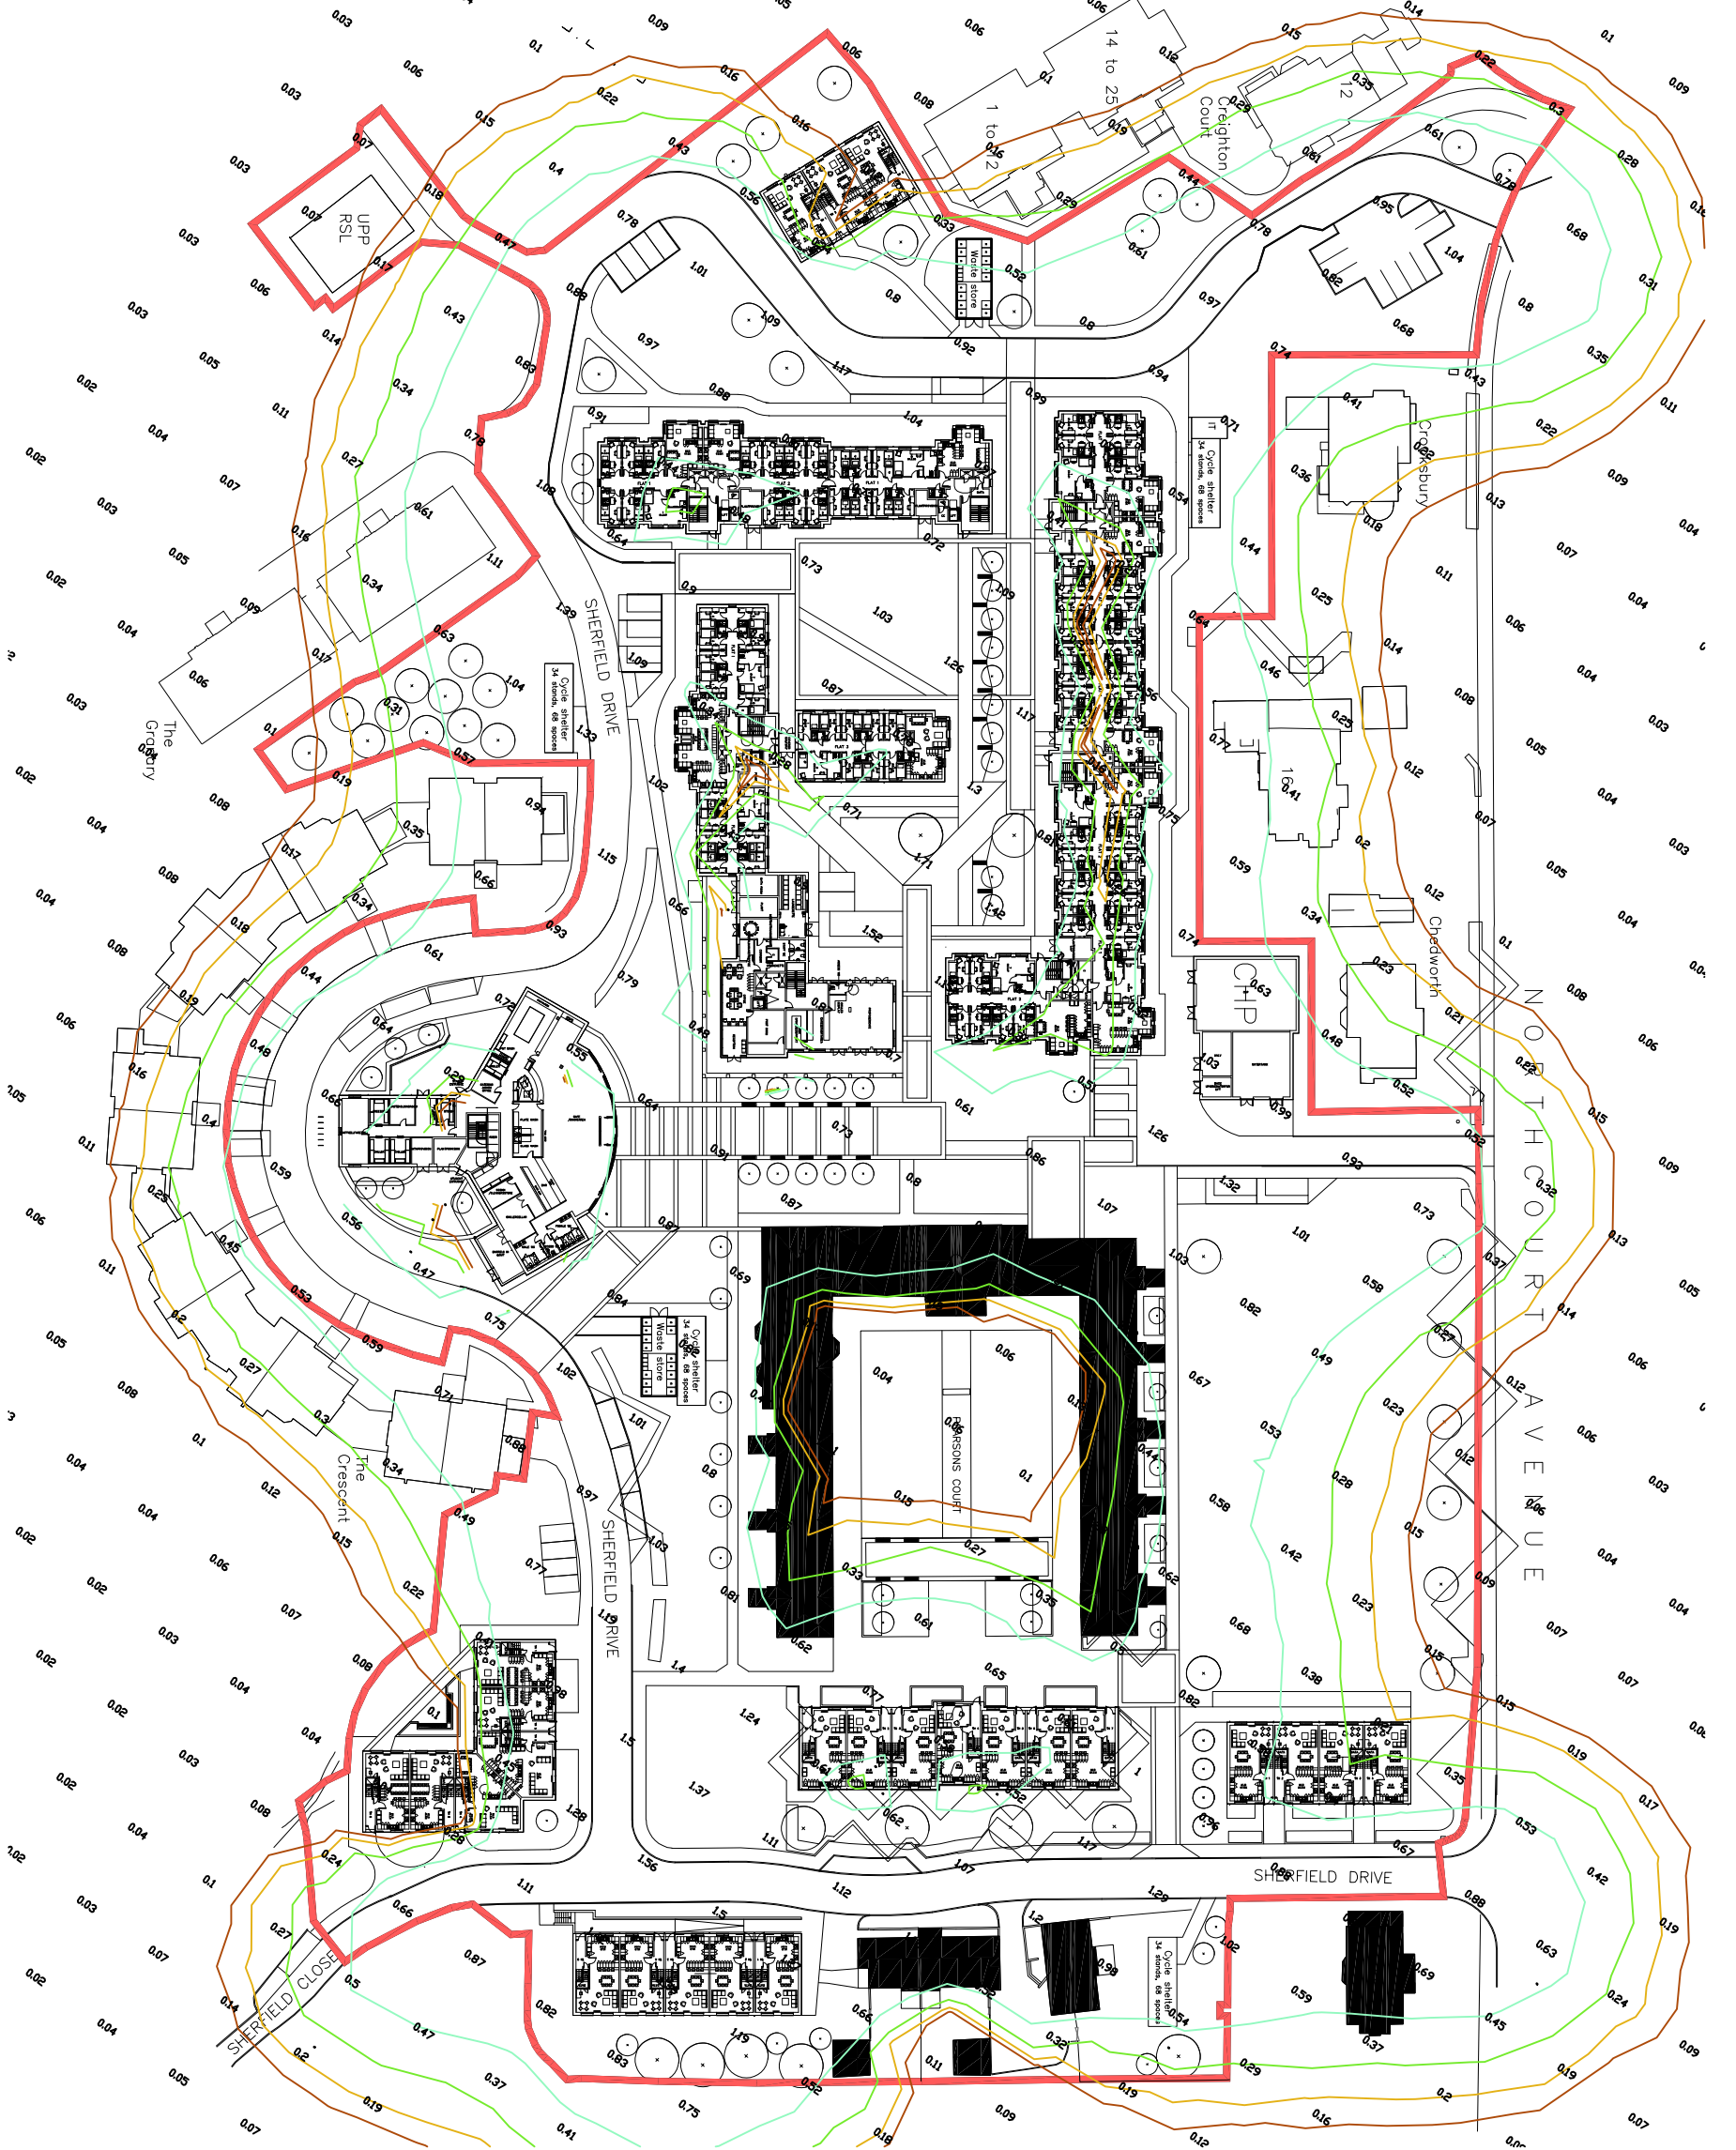

OVERALL AREA 18M ABOVE GROUND LEVEL
SCALE: 1:1000
EMin: 0.00 LUX
EMax: 1.71 LUX
EAV: 0.25 LUX

- NOTES: GENERAL
1. DO NOT SCALE FROM THIS DRAWING. IF IN DOUBT, REQUEST FURTHER INFORMATION.
 2. THIS DRAWING SHALL BE READ IN CONJUNCTION WITH THE MAIN SPECIFICATION AND THE ARCHITECTS AND STRUCTURAL ENGINEERS DRAWINGS.
 3. REFER TO ARCHITECTS DRAWINGS FOR DETAILS OF ALL SETTING OUT INFORMATION. NO DIMENSIONS SHALL BE MEASURED FROM THIS DRAWING.
 4. ANY OBSERVED DISCREPANCY WITH THIS DRAWING MUST BE REPORTED AND CLARIFICATION SOUGHT.
 5. A MAINTENANCE FACTOR OF 0.92 HAS BEEN USED FOR ALL SIMULATIONS AND COMPUTATIONAL RESULTS. THIS IS IN LINE WITH THE SOCIETY OF LIGHT AND LIGHTING GUIDELINES AND IS DERIVED AS THE RESULT OF A REAL WORLD SIMULATION OF A TYPICAL CLEANING CYCLE.
 6. THE RESULTS SHOWN ARE BASED ON A LOW LEVEL MODEL AND CALCULATIONS SHOULD BE TREATED AS A COMPARISON TOOL, NOT A REAL WORLD SIMULATION.
 7. ALL RESULTS ARE BASED ON PROPOSED LIGHTING ONLY AND DO NOT CONSIDER LIGHT ENITLED FROM THE PROPOSED ACCOMMODATION BLOCKS.
 8. LIGHTING CONTROL SHALL BE VIA A TIMECLOCK WHICH WILL SHUT OFF ALL LIGHTING AT 23:00 HRS.
 9. IT HAS BEEN ASSUMED THAT THE ENVIRONMENTAL CLASSIFICATION FOR THE SITE SHALL BE CATEGORY E1 AS DETAILED WITHIN CASE 10A.

08/11/17	NEW SCHEDULE REISED FOR PLANNING	E	DC
27/09/16	REISED FOR EMO	D	DC
24/08/16	AMENDED FOLLOWING PLANNING COMMENTS	C	DC
13/06/16	LATEST SITE PLAN ADDED	B	DC
15/03/16	NEW LAYOUTS INCORPORATED	A	DC
Date	Description	Rev	By

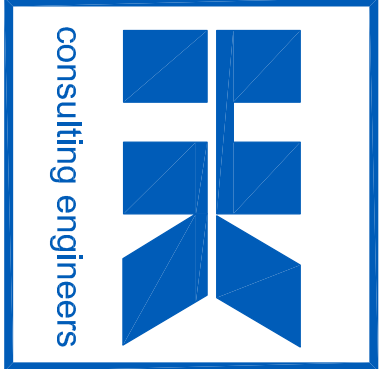

hulley & kirkwood
consulting engineers

Plymouth Office
Second Floor
Studio 5-11
Millbay Road
Plymouth
PL1 3LF
Tel No: 01752 255575
E: hk.plymouth@hulley.co.uk

...Making Buildings Work

Project:
UPP - University of Reading
St Patrick's Hall

Drawing Title:
External Lighting
LUX Plot Layout

Drawing Number:
P0263(60)SK02

Revision:
Date:
Scale:
Drawn By:
CAD Dwg File:
Arch. Base Dwg:

E
24/09/15
1:1000
KD CHK DC
P0263(60)SK02
Received 01-11-17

Issue Status:
PLANNING