





FRONT ELEVATION


- HALOGEN LIGHT
- SPOT LIGHT
- PENDANT LIGHT
- STRIP LIGHTING
- DOWNLIGHTER
- CCTV CAMERA
- TWIN POWER SOCKET
- SINGLE POWER SOCKET
- FIRE CALL POINT
- SMOKE/HEAT DETECTOR
- EMERGENCY LIGHT
- SOUNDER
- SPRINKLER HEAD

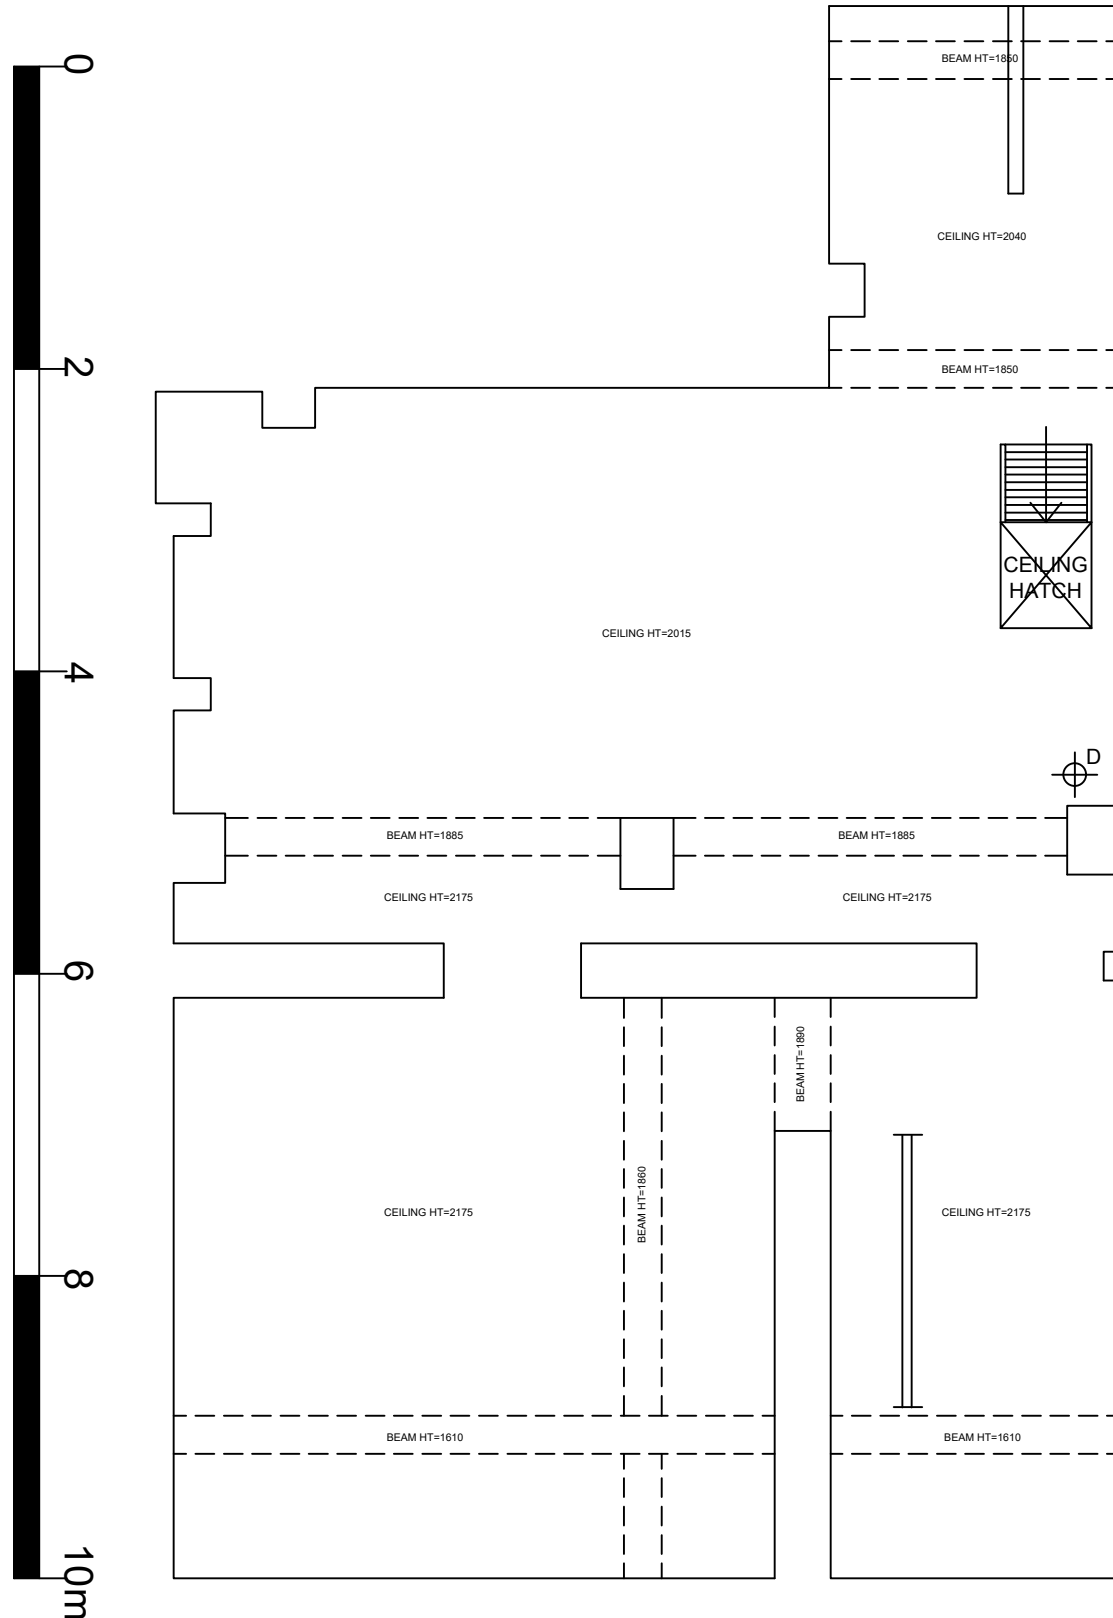


BASEMENT
INVERTED CEILING PLAN

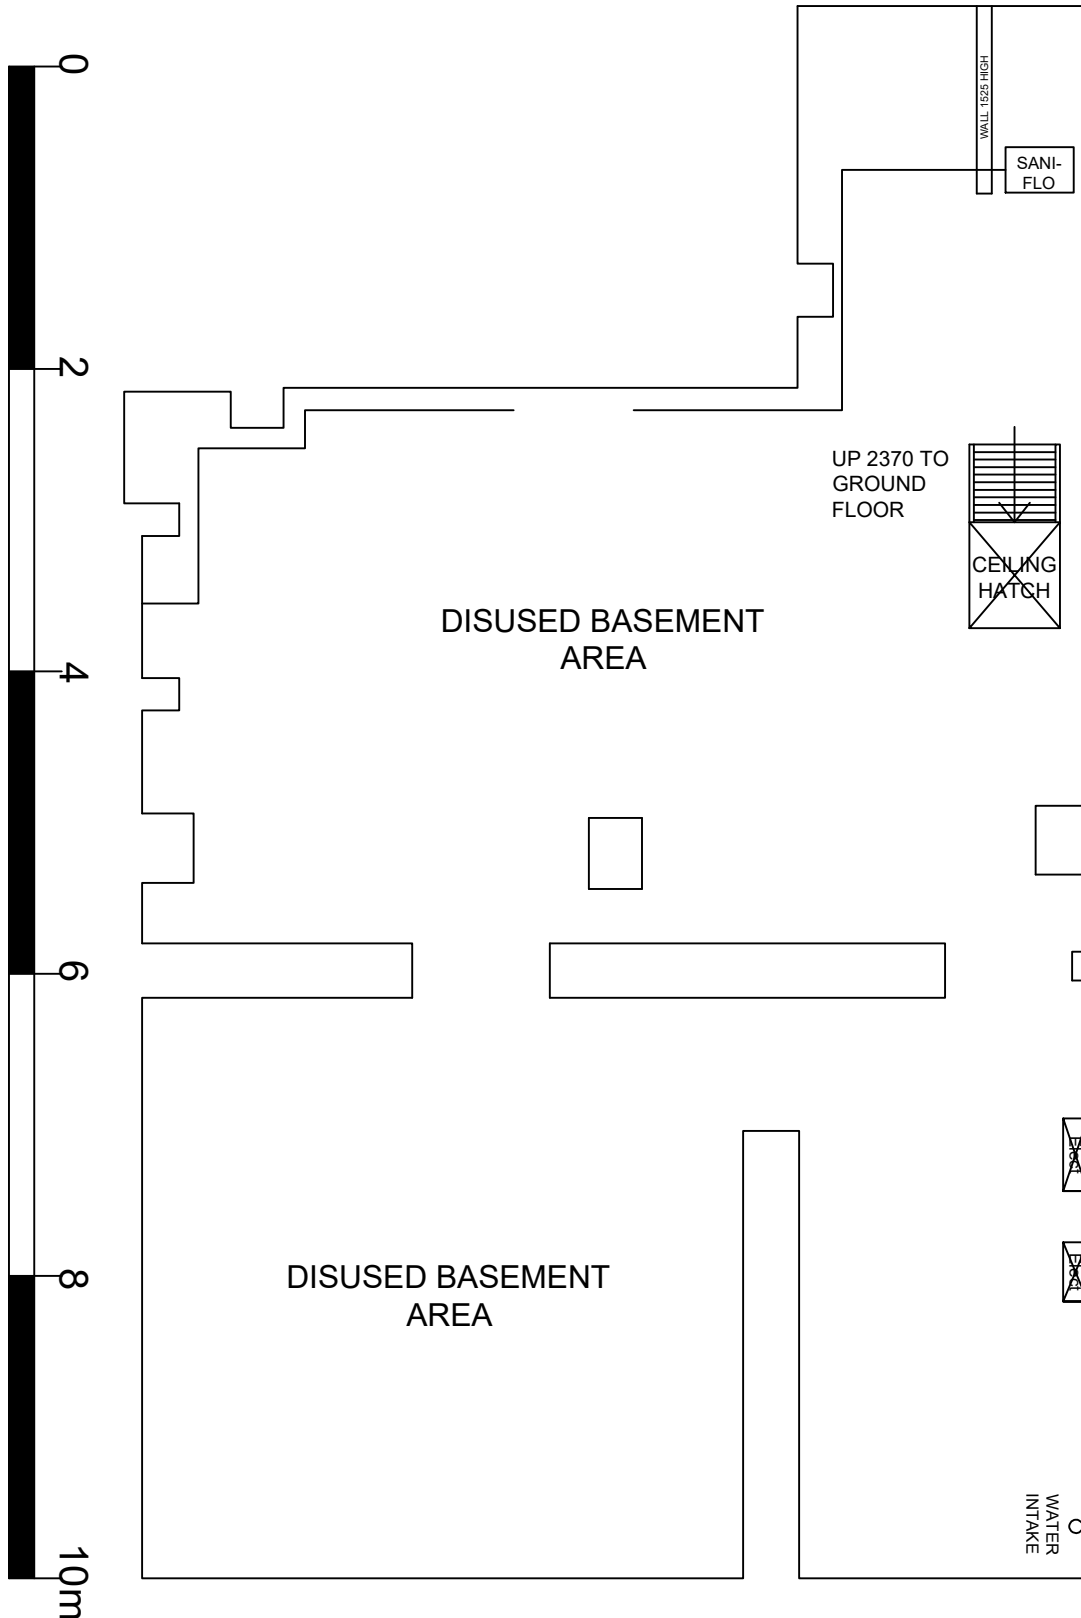

BASEMENT PLAN

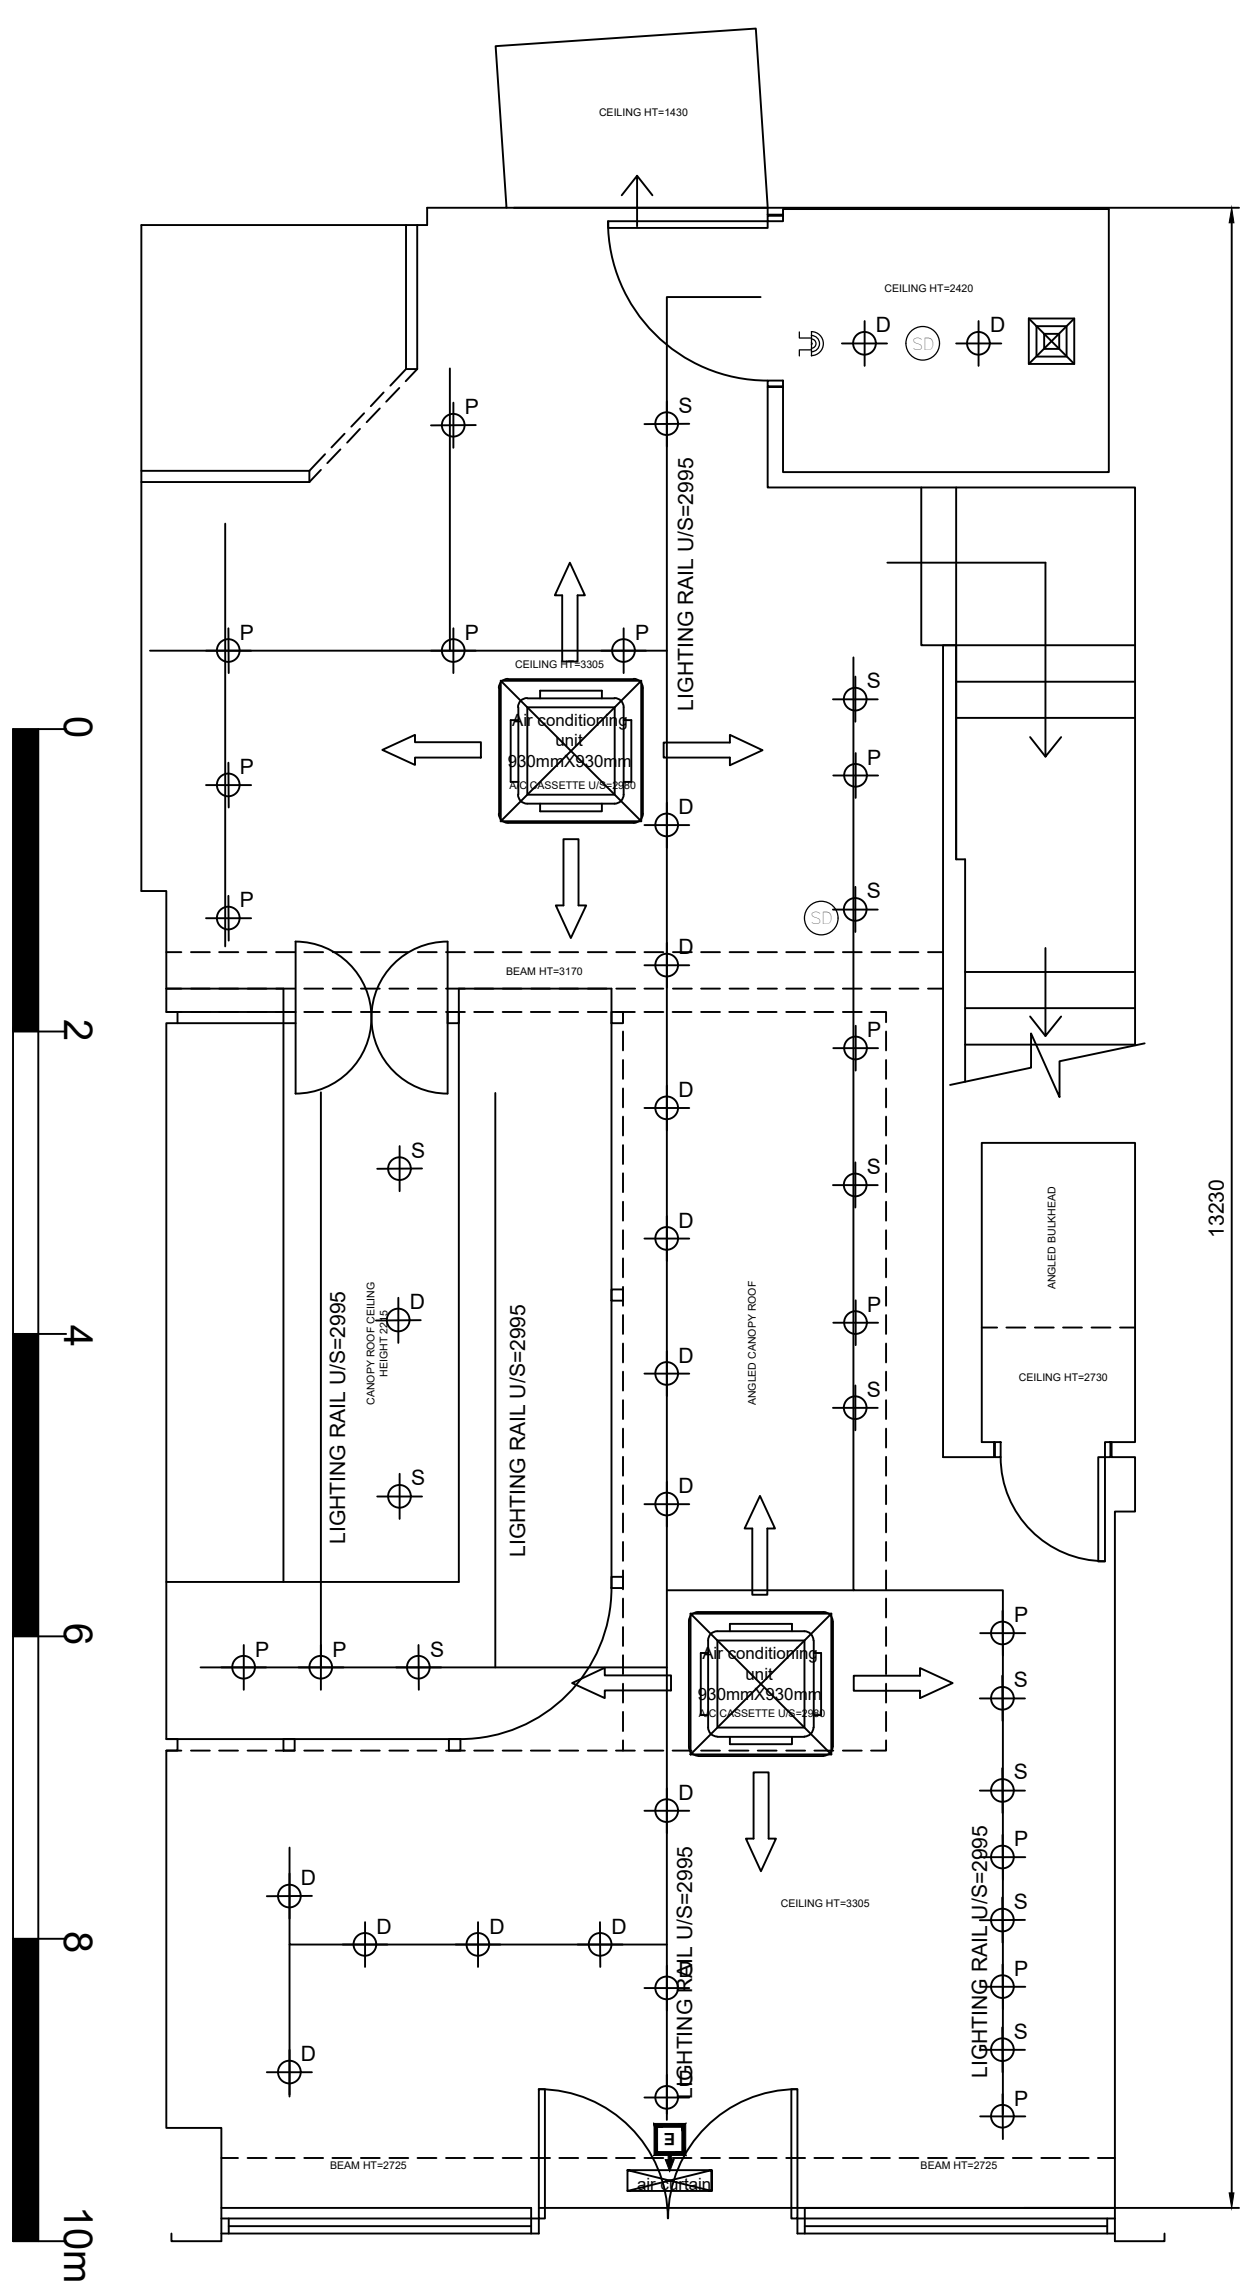

GROUND FLOOR
INVERTED CEILING PLAN

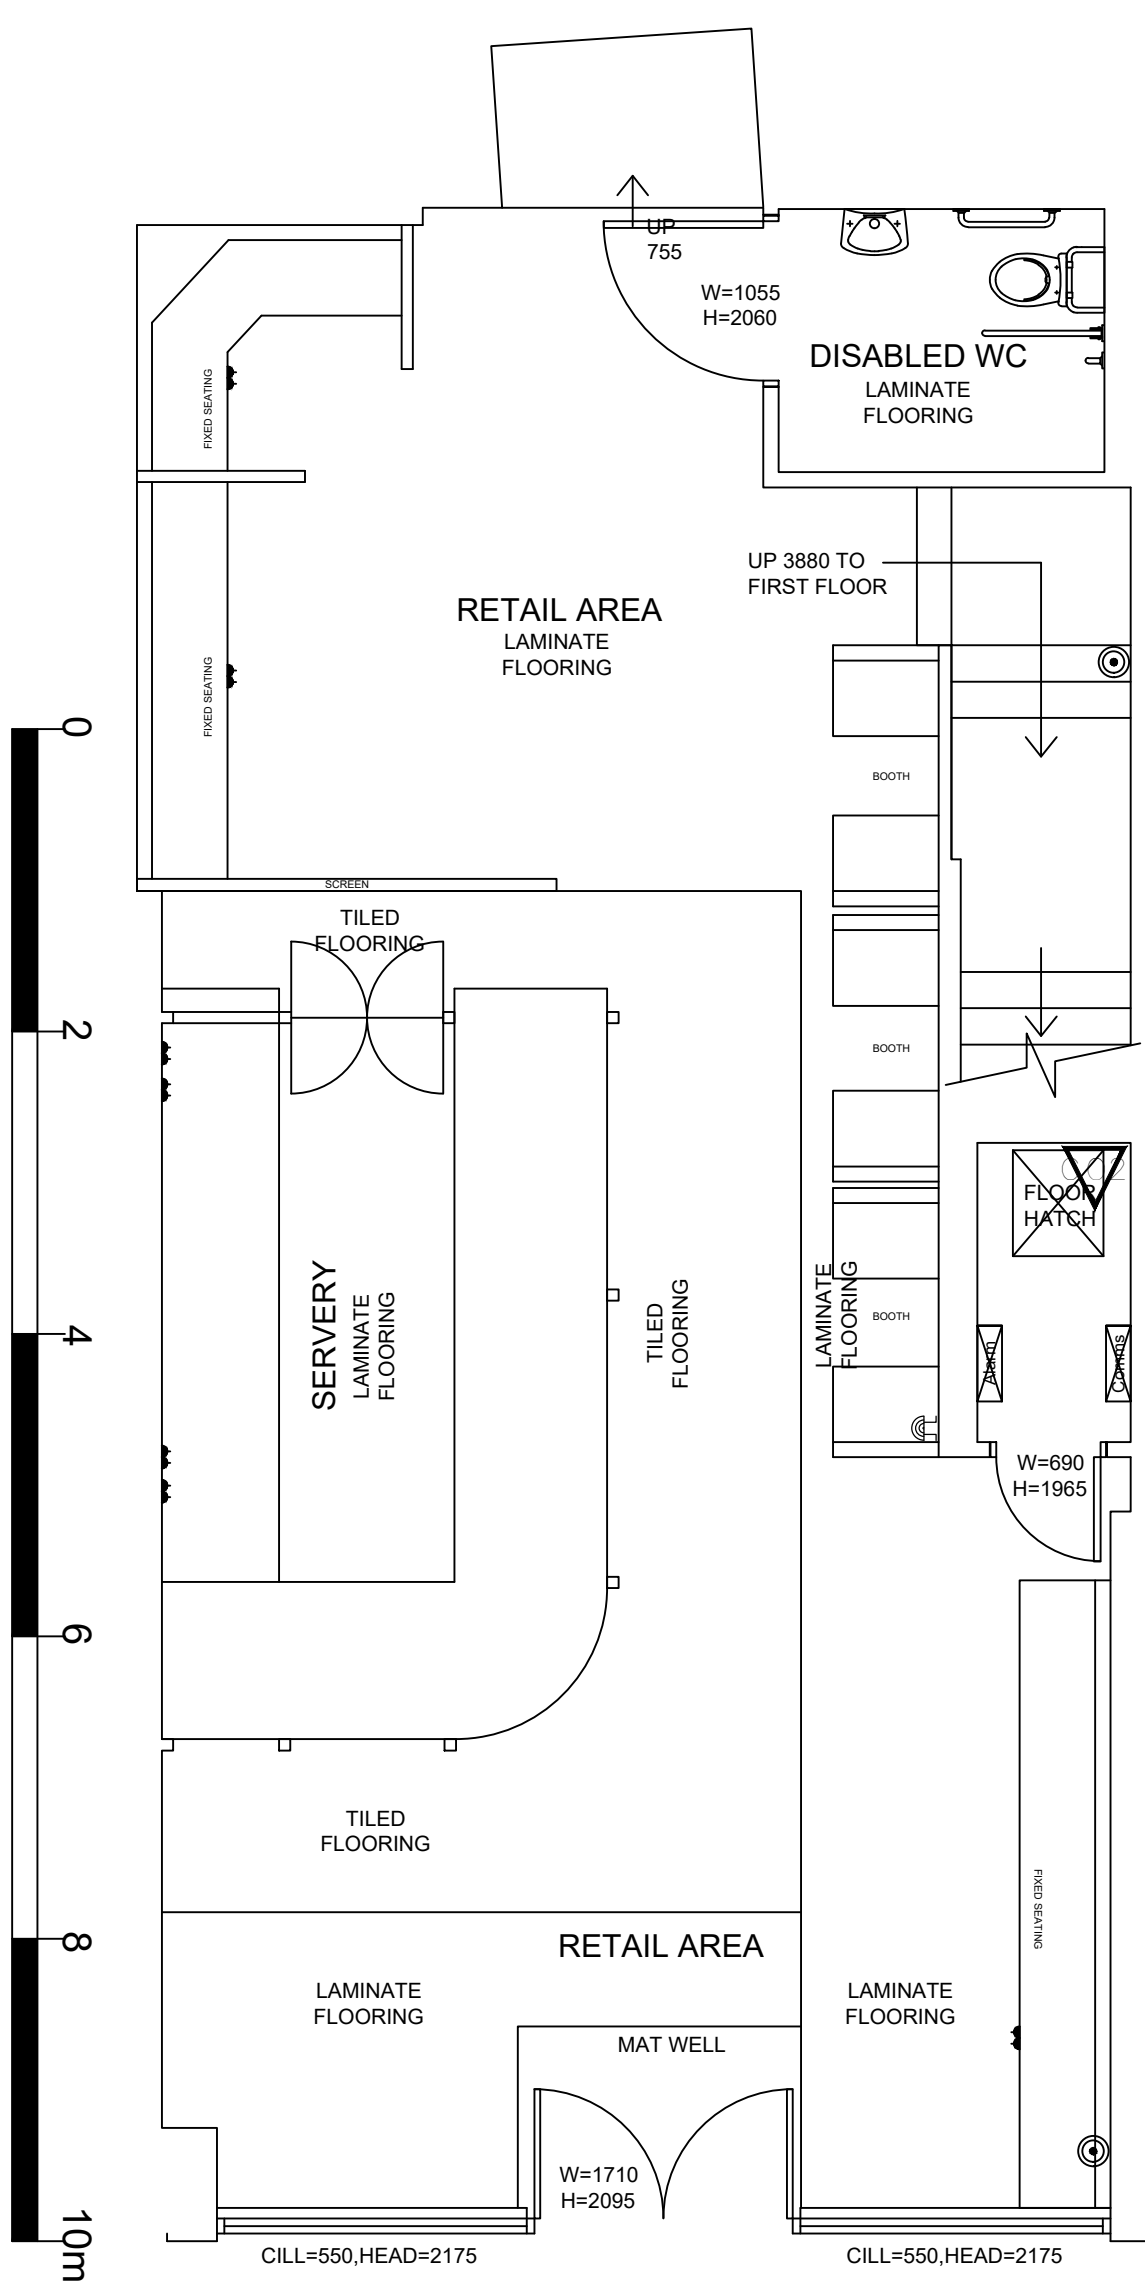

FLOOR FINISHES TO BE REVIEWED AND
CONFIRMED AFTER EXISTING SHOP
FITTINGS STRIPPED OUT.

GROUND FLOOR PLAN

MOD NO	REV	MOD NOTES	MOD DATE	BY
FLEETWOOD CADTEK LIMITED 12 STEPHEN DRIVE GRENOSIDE, SHEFFIELD, S35 8QY TELEPHONE (07733) 281111 E-MAIL: fleetcad@aol.com				
Job Title 80 Broad Street Reading				
Drawing Title Ground Floor & Basement as Existing				
Scale	1:50	Sheet	A1	
Date	22.09.17	Drawn by	SKF	
Drg. No.	17.68.01			Rev. A