




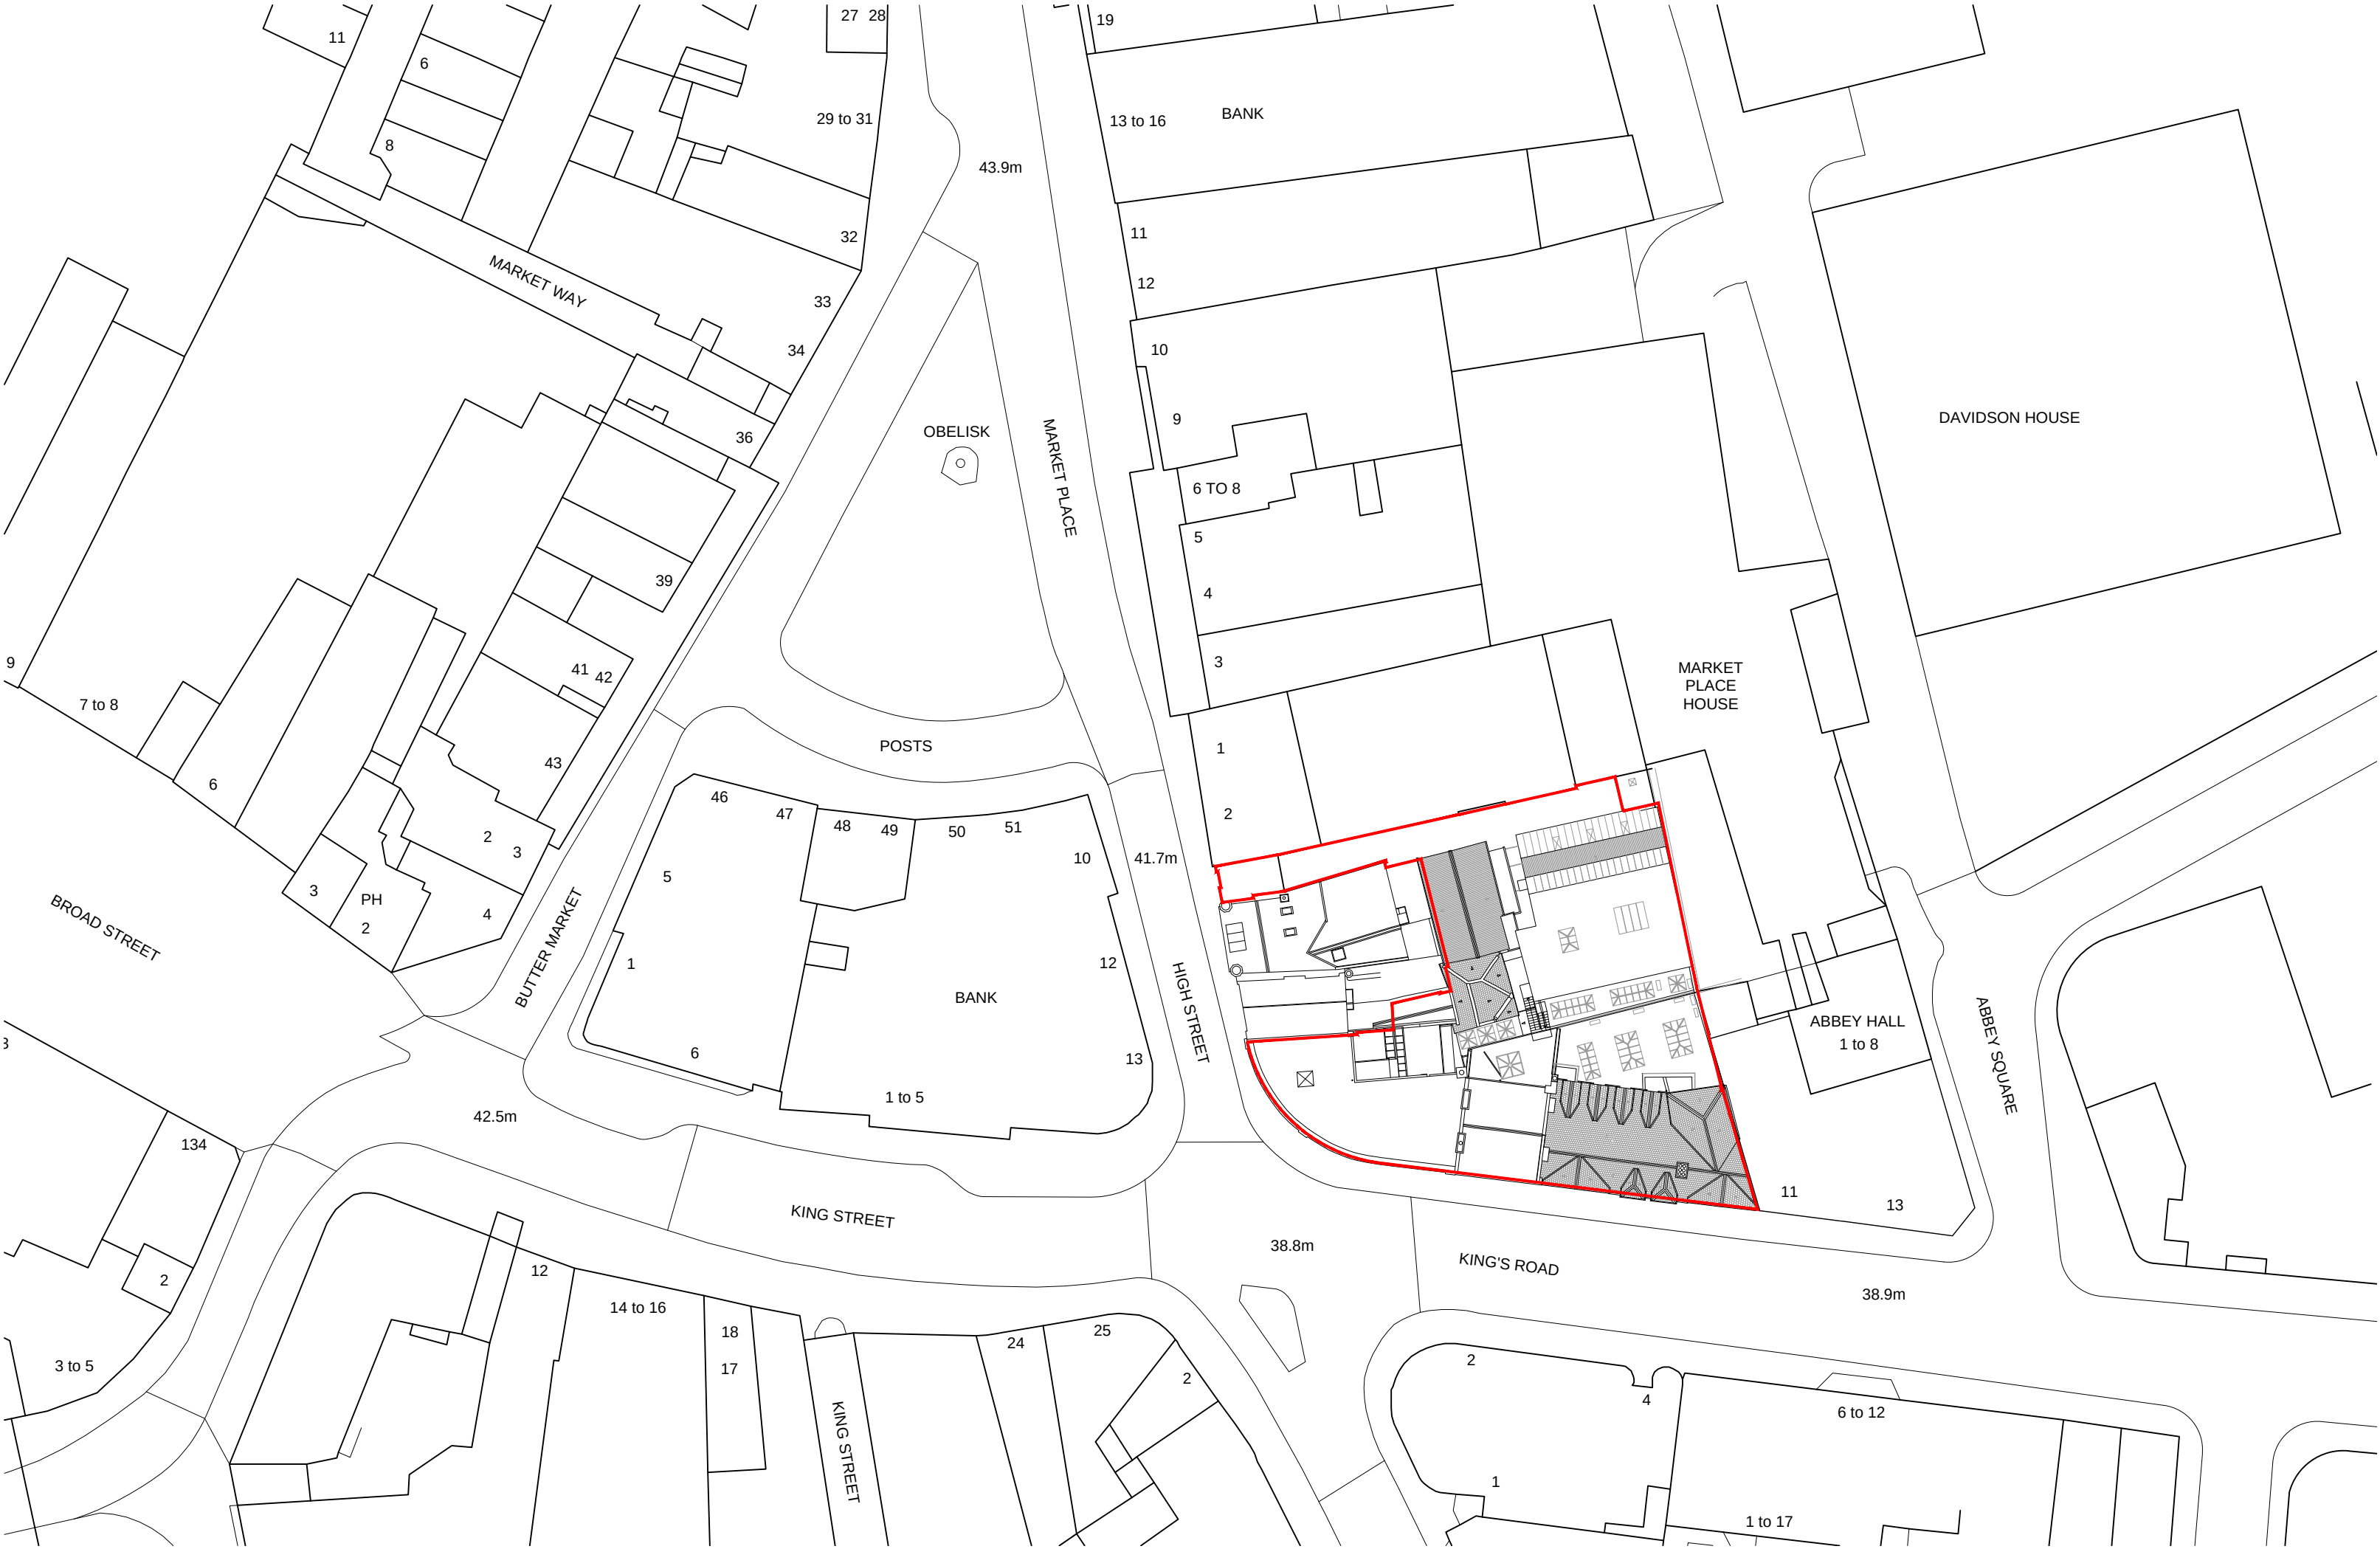

EXISTING SITE PLAN

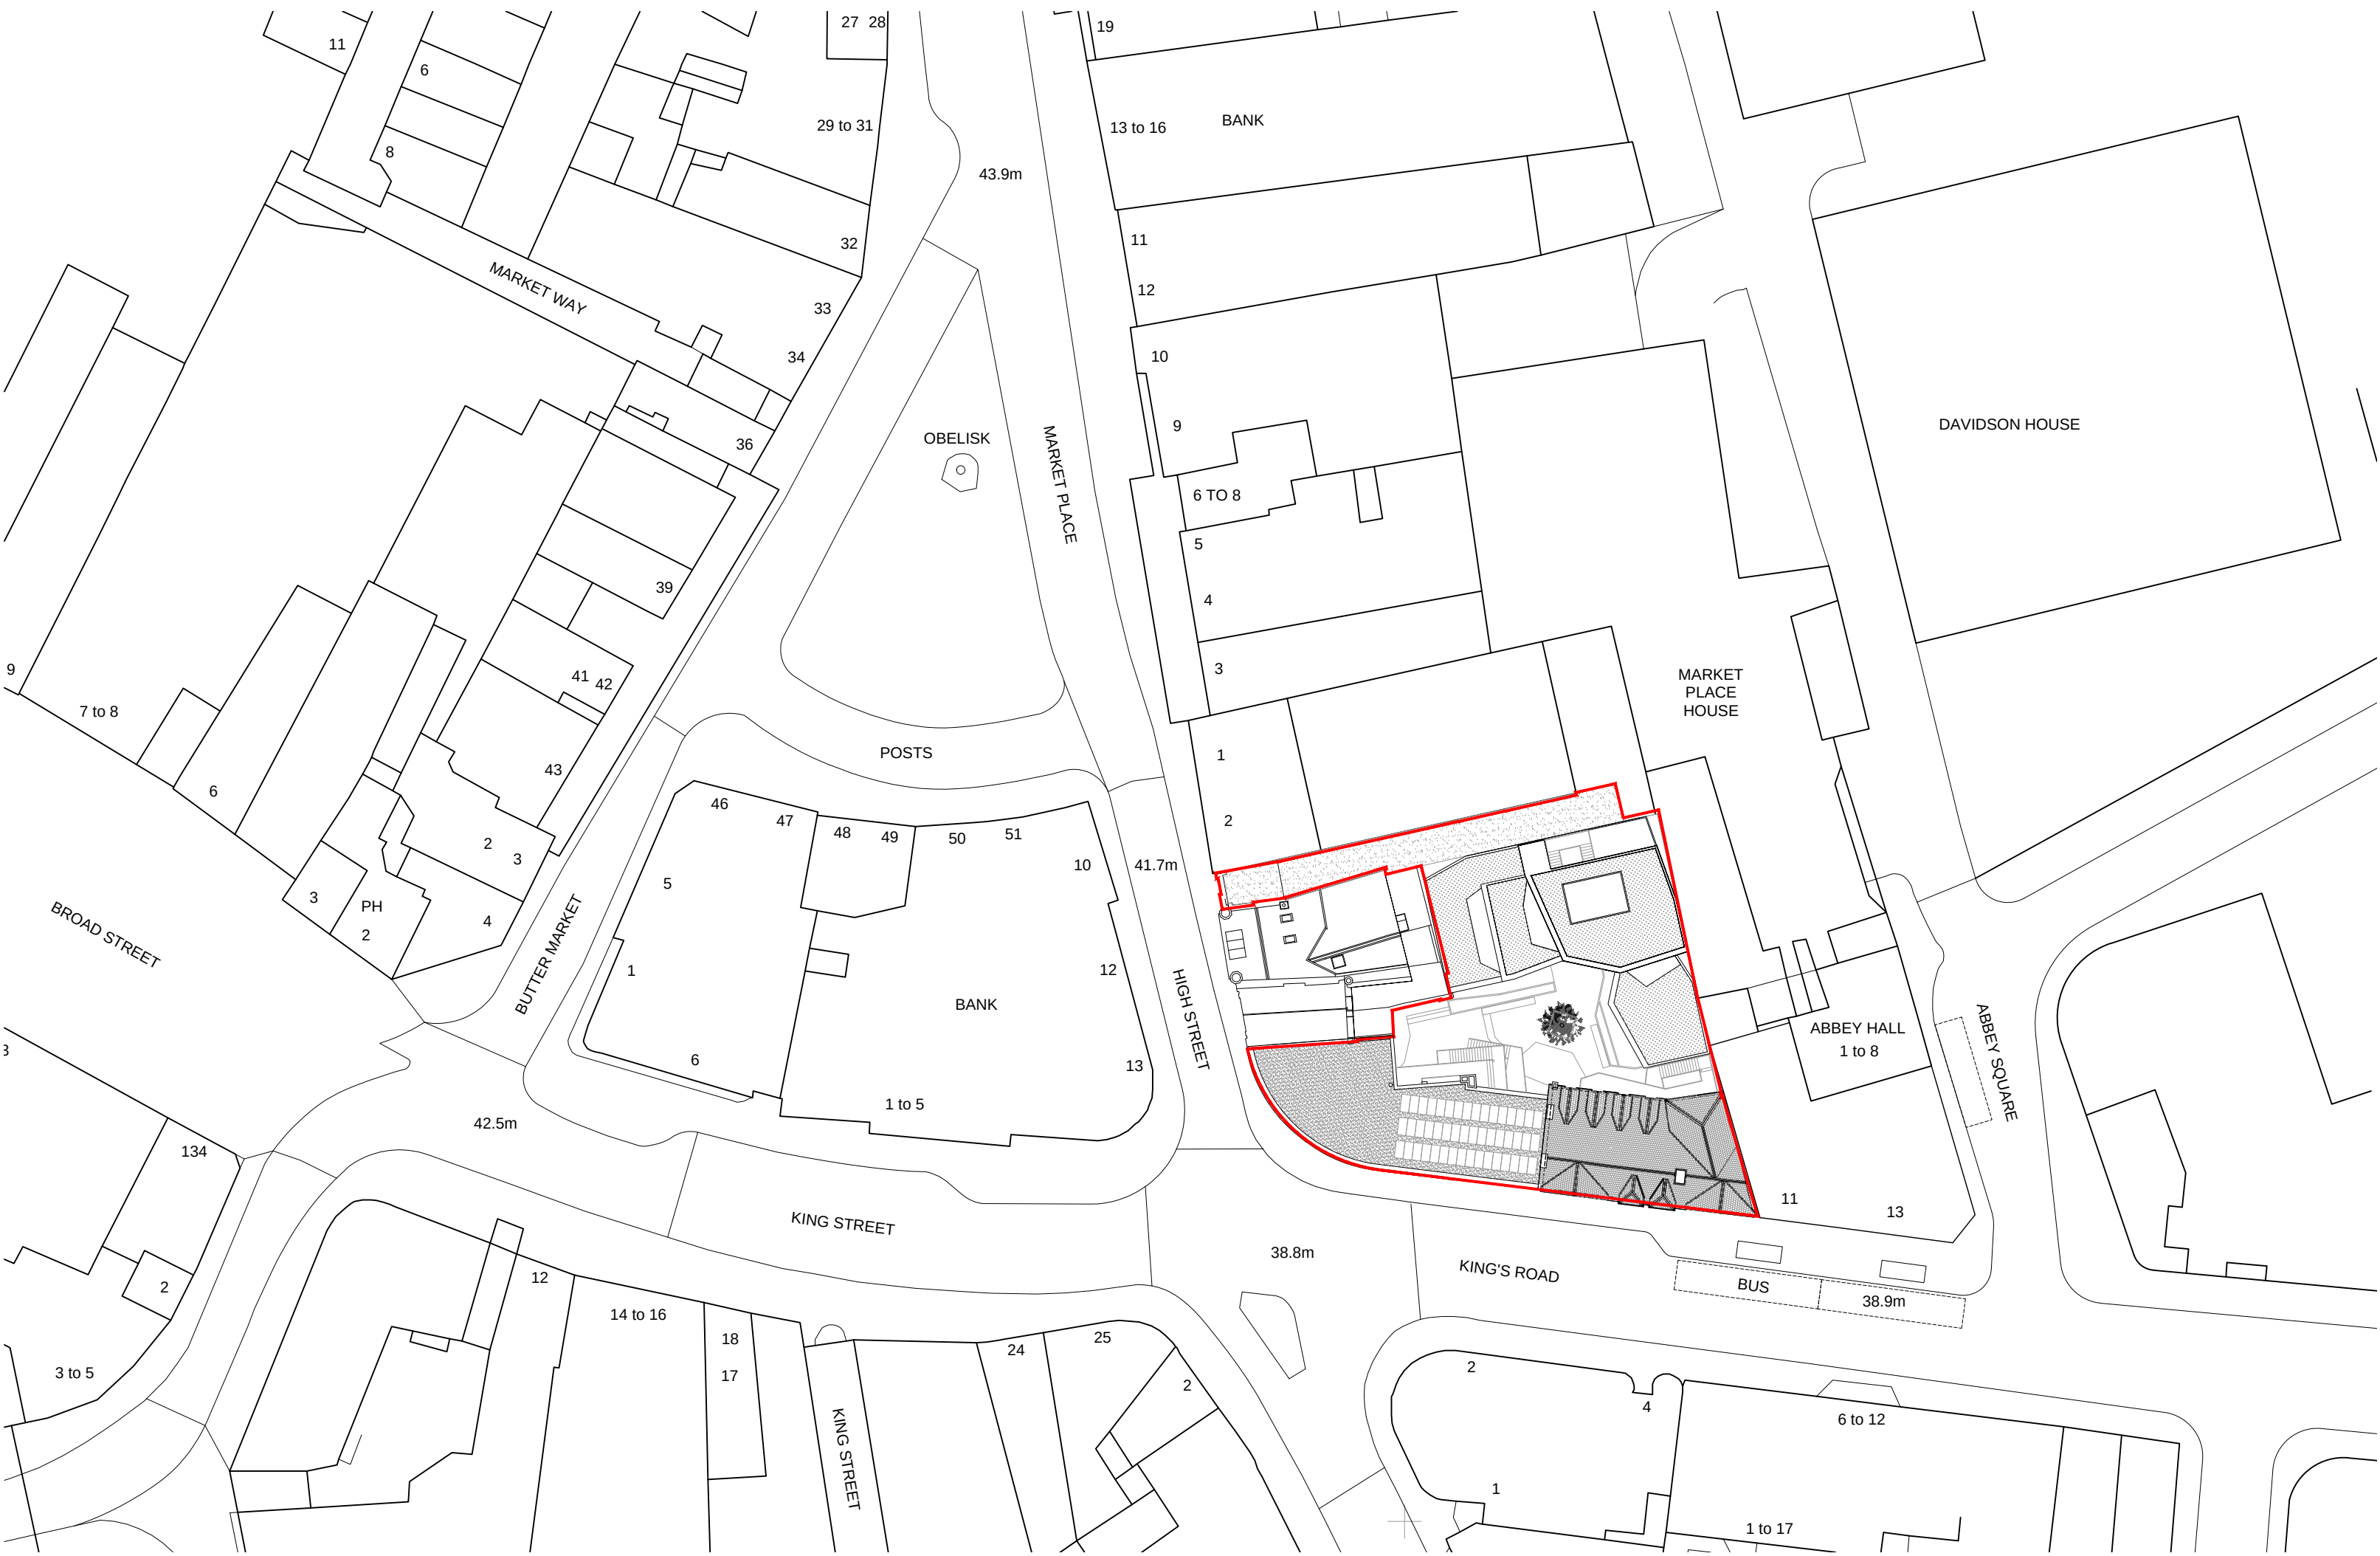

PROPOSED SITE PLAN

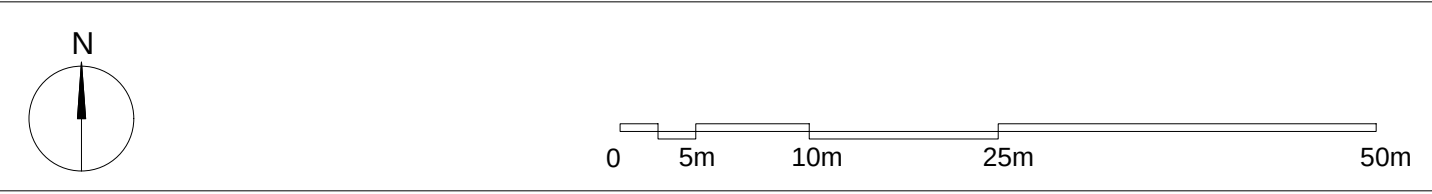

PROJECT
JACKSONS CORNER
1-9 KING'S ROAD, READING

CLIENT
READING SECURITIES 2 LLP
INTERNATIONAL HOUSE, 1-6 YARMOUTH PLACE, W1J 7BU

DESIGNERS
S333
S333
Architecture+Urbanism
London
70 Cowcross
London EC1M 6EJ
Tel : +44(0) 20 7336 7026
Fax : +44(0) 20 7336 7027
info@s333.org
www.s333.org

TITLE
EXISTING + PROPOSED SITE PLANS

	NAME	SIGNATURE	DATE
Drawn by	AMc		08.04.16
Checked			

Revision A		
Revision B		
Revision C		
Revision D		

SCALE @ FORMAT 1:500 @ A1	FILE NAME 1300 C 100 01 PLANS
ISSUE DATE 08.04.2016	PROPOSED STATUS PLANNING APPLICATION

PROJECT	TYPE	SEQUENCE No.	REV.	NOTE
1	3	0	0	1



Notes :



1. LEVELS BASED ON OS DATUM.
2. WINDOW CILL AND HEAD LEVELS MEASURED INTERNALLY.
3. SANITARY FITTINGS INDICATIVE ONLY.

Level abbreviations used :

C	CILL LEVEL
CL	CEILING LEVEL
CVL	COVER LEVEL
CP	CROWN LEVEL
DH	DOOR HEAD LEVEL
FL	FLOOR LEVEL
H	HEAD LEVEL
SP	SPRING LEVEL
U/S	UNDER SIDE
FCL	FALSE CEILING LEVEL

General abbreviations used :

AB	AIR BRICK
ACU	AIR-CON UNIT
GY	GULLY
→	JOIST DIRECTION
IC	INSPECTION COVER
MH	MANHOLE
Rad	RADIATOR
RC	RADIATOR COVER
RE	RODDING EYE
RS	ROLLER SHUTTER
RWP	RAIN WATER PIPE
S/C →	SLOPING CEILING
SVP	SOIL VENT PIPE
TOW	TOP OF WALL LEVEL
→	STEP UP
U/S	UNDER SIDE
VP	VENT PIPE
▷	FALL IN ROOF

 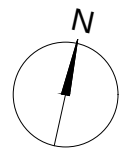

PROJECT

JACKSONS CORNER
1-9 KING'S ROAD, READING

CLIENT

READING SECURITIES 2 LLP
INTERNATIONAL HOUSE, 1-6 YARMOUTH PLACE, W1J 7BU

DESIGNERS



S333
Architecture+Urbanism
London

70 Cowcross
London EC1M 6EJ
Tel : +44(0) 20 7336 7026
Fax: +44(0) 20 7336 7027
info@s333.org
www.s333.org

TITLE


EXISTING BASEMENT PLAN

	NAME	SIGNATURE	DATE
Drawn by	AMc		
Checked			

Revision A		
Revision B		
Revision C		
Revision D		

SCALE @ FORMAT 1:100 @ A1	FILE NAME 1300 C 100 01 SURVEY PLANS
ISSUE DATE 08.04.2016	PROPOSED STATUS PLANNING APPLICATION

PROJECT	TYPE	SEQUENCE No.	REV.	NOTE
1	3	0	0	1

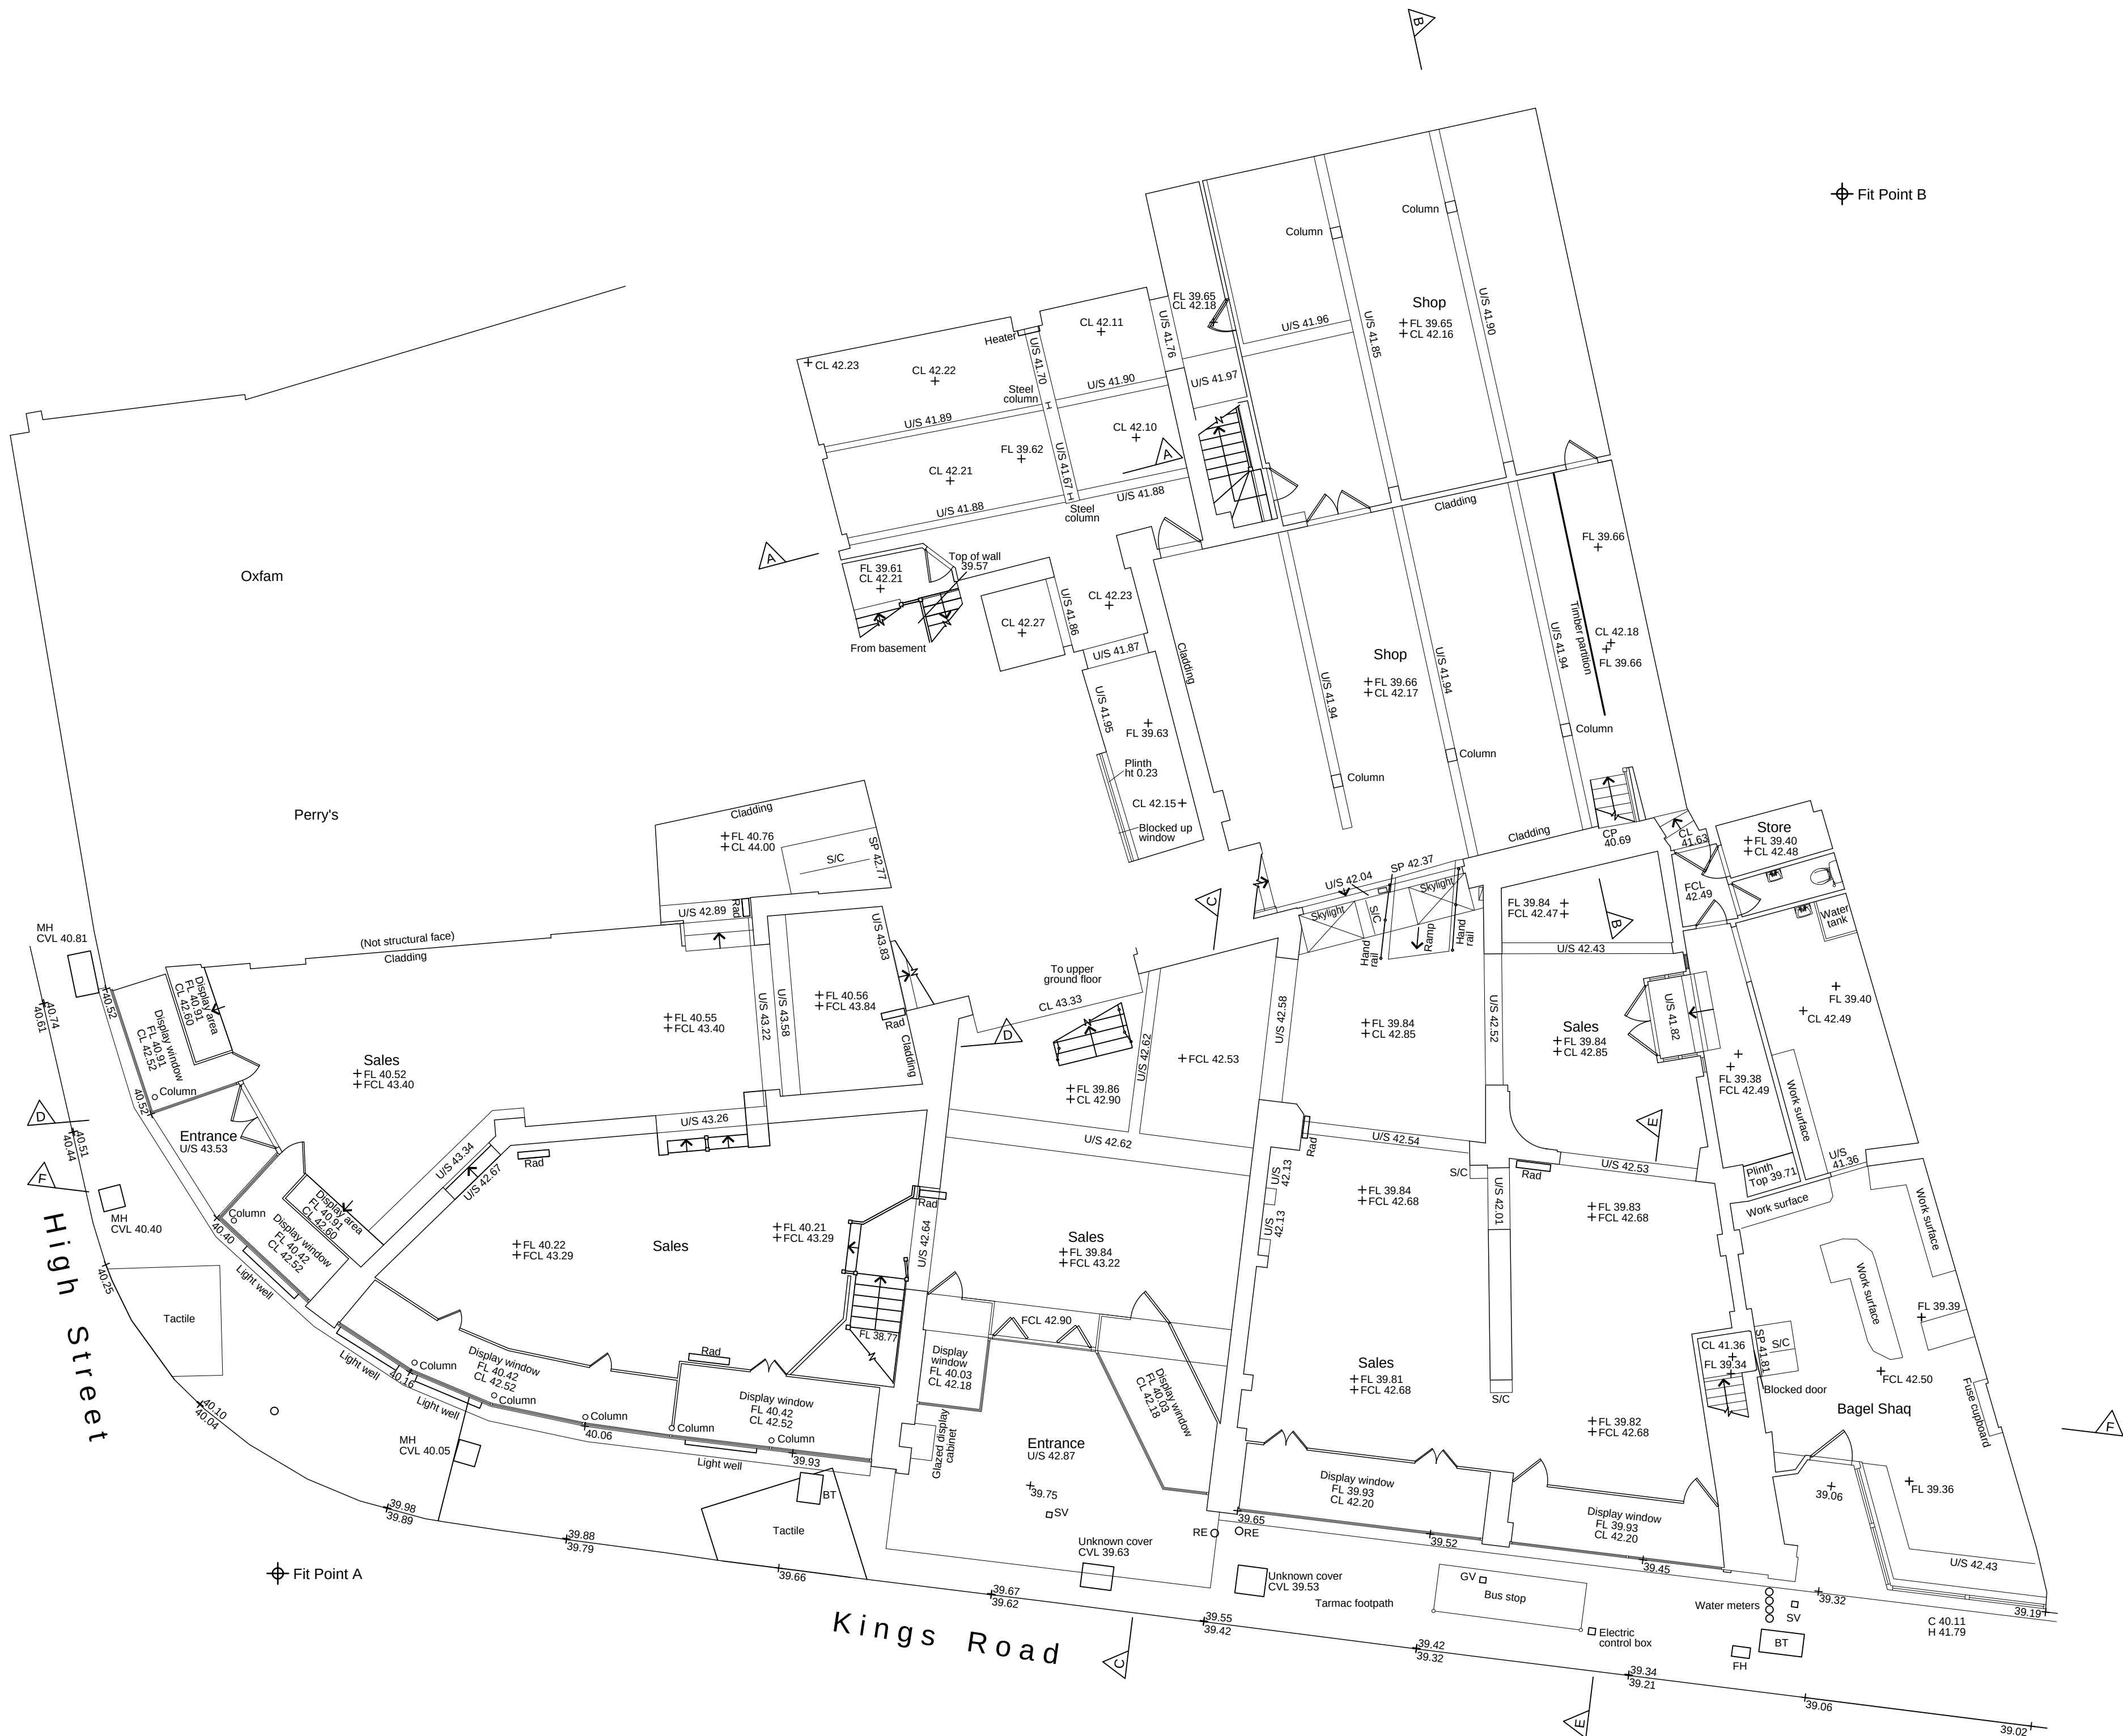

Notes :


1. LEVELS BASED ON OS DATUM.
2. WINDOW CILL AND HEAD LEVELS MEASURED INTERNALLY.
3. SANITARY FITTINGS INDICATIVE ONLY.

Level abbreviations used :

- | | |
|-----|---------------------|
| C | CILL LEVEL |
| CL | CEILING LEVEL |
| CVL | COVER LEVEL |
| CP | CROWN LEVEL |
| DH | DOOR HEAD LEVEL |
| FL | FLOOR LEVEL |
| H | HEAD LEVEL |
| SP | SPRING LEVEL |
| U/S | UNDER SIDE |
| FCL | FALSE CEILING LEVEL |

General abbreviations used :

- | | |
|-----|-------------------|
| AB | AIR BRICK |
| ACU | AIR-CON UNIT |
| GY | GULLY |
| ↖ | JOIST DIRECTION |
| IC | INSPECTION COVER |
| MH | MANHOLE |
| Rad | RADIATOR |
| RC | RADIATOR COVER |
| RE | RODDING EYE |
| RS | ROLLER SHUTTER |
| RWP | RAIN WATER PIPE |
| S/C | SLOPING CEILING |
| SVP | SOIL VENT PIPE |
| TOW | TOP OF WALL LEVEL |
| → | STEP UP |
| U/S | UNDER SIDE |
| VP | VENT PIPE |
| ▽ | FALL IN ROOF |

 

0 1m 2m 5m 10m

PROJECT

JACKSONS CORNER
1-9 KING'S ROAD, READING

CLIENT

READING SECURITIES 2 LLP
INTERNATIONAL HOUSE, 1-6 YARMOUTH PLACE, W1J 7BU

DESIGNERS

S333

S333
Architecture+Urbanism
London
70 Cowcross
London EC1M 6EJ
Tel : +44(0) 20 7336 7026
Fax: +44(0) 20 7336 7027
info@s333.org
www.s333.org


TITLE

EXISTING GROUND FLOOR PLAN

	NAME	SIGNATURE	DATE
Drawn by	AMc		
Checked			
Revision A			
Revision B			
Revision C			
Revision D			

SCALE @ FORMAT 1:100 @ A1	FILE NAME 1300 C 100 01 SURVEY PLANS
ISSUE DATE 08.04.2016	PROPOSED STATUS PLANNING APPLICATION

PROJECT	TYPE	SEQUENCE No.	REV.	NOTE
1	3	0	0	2

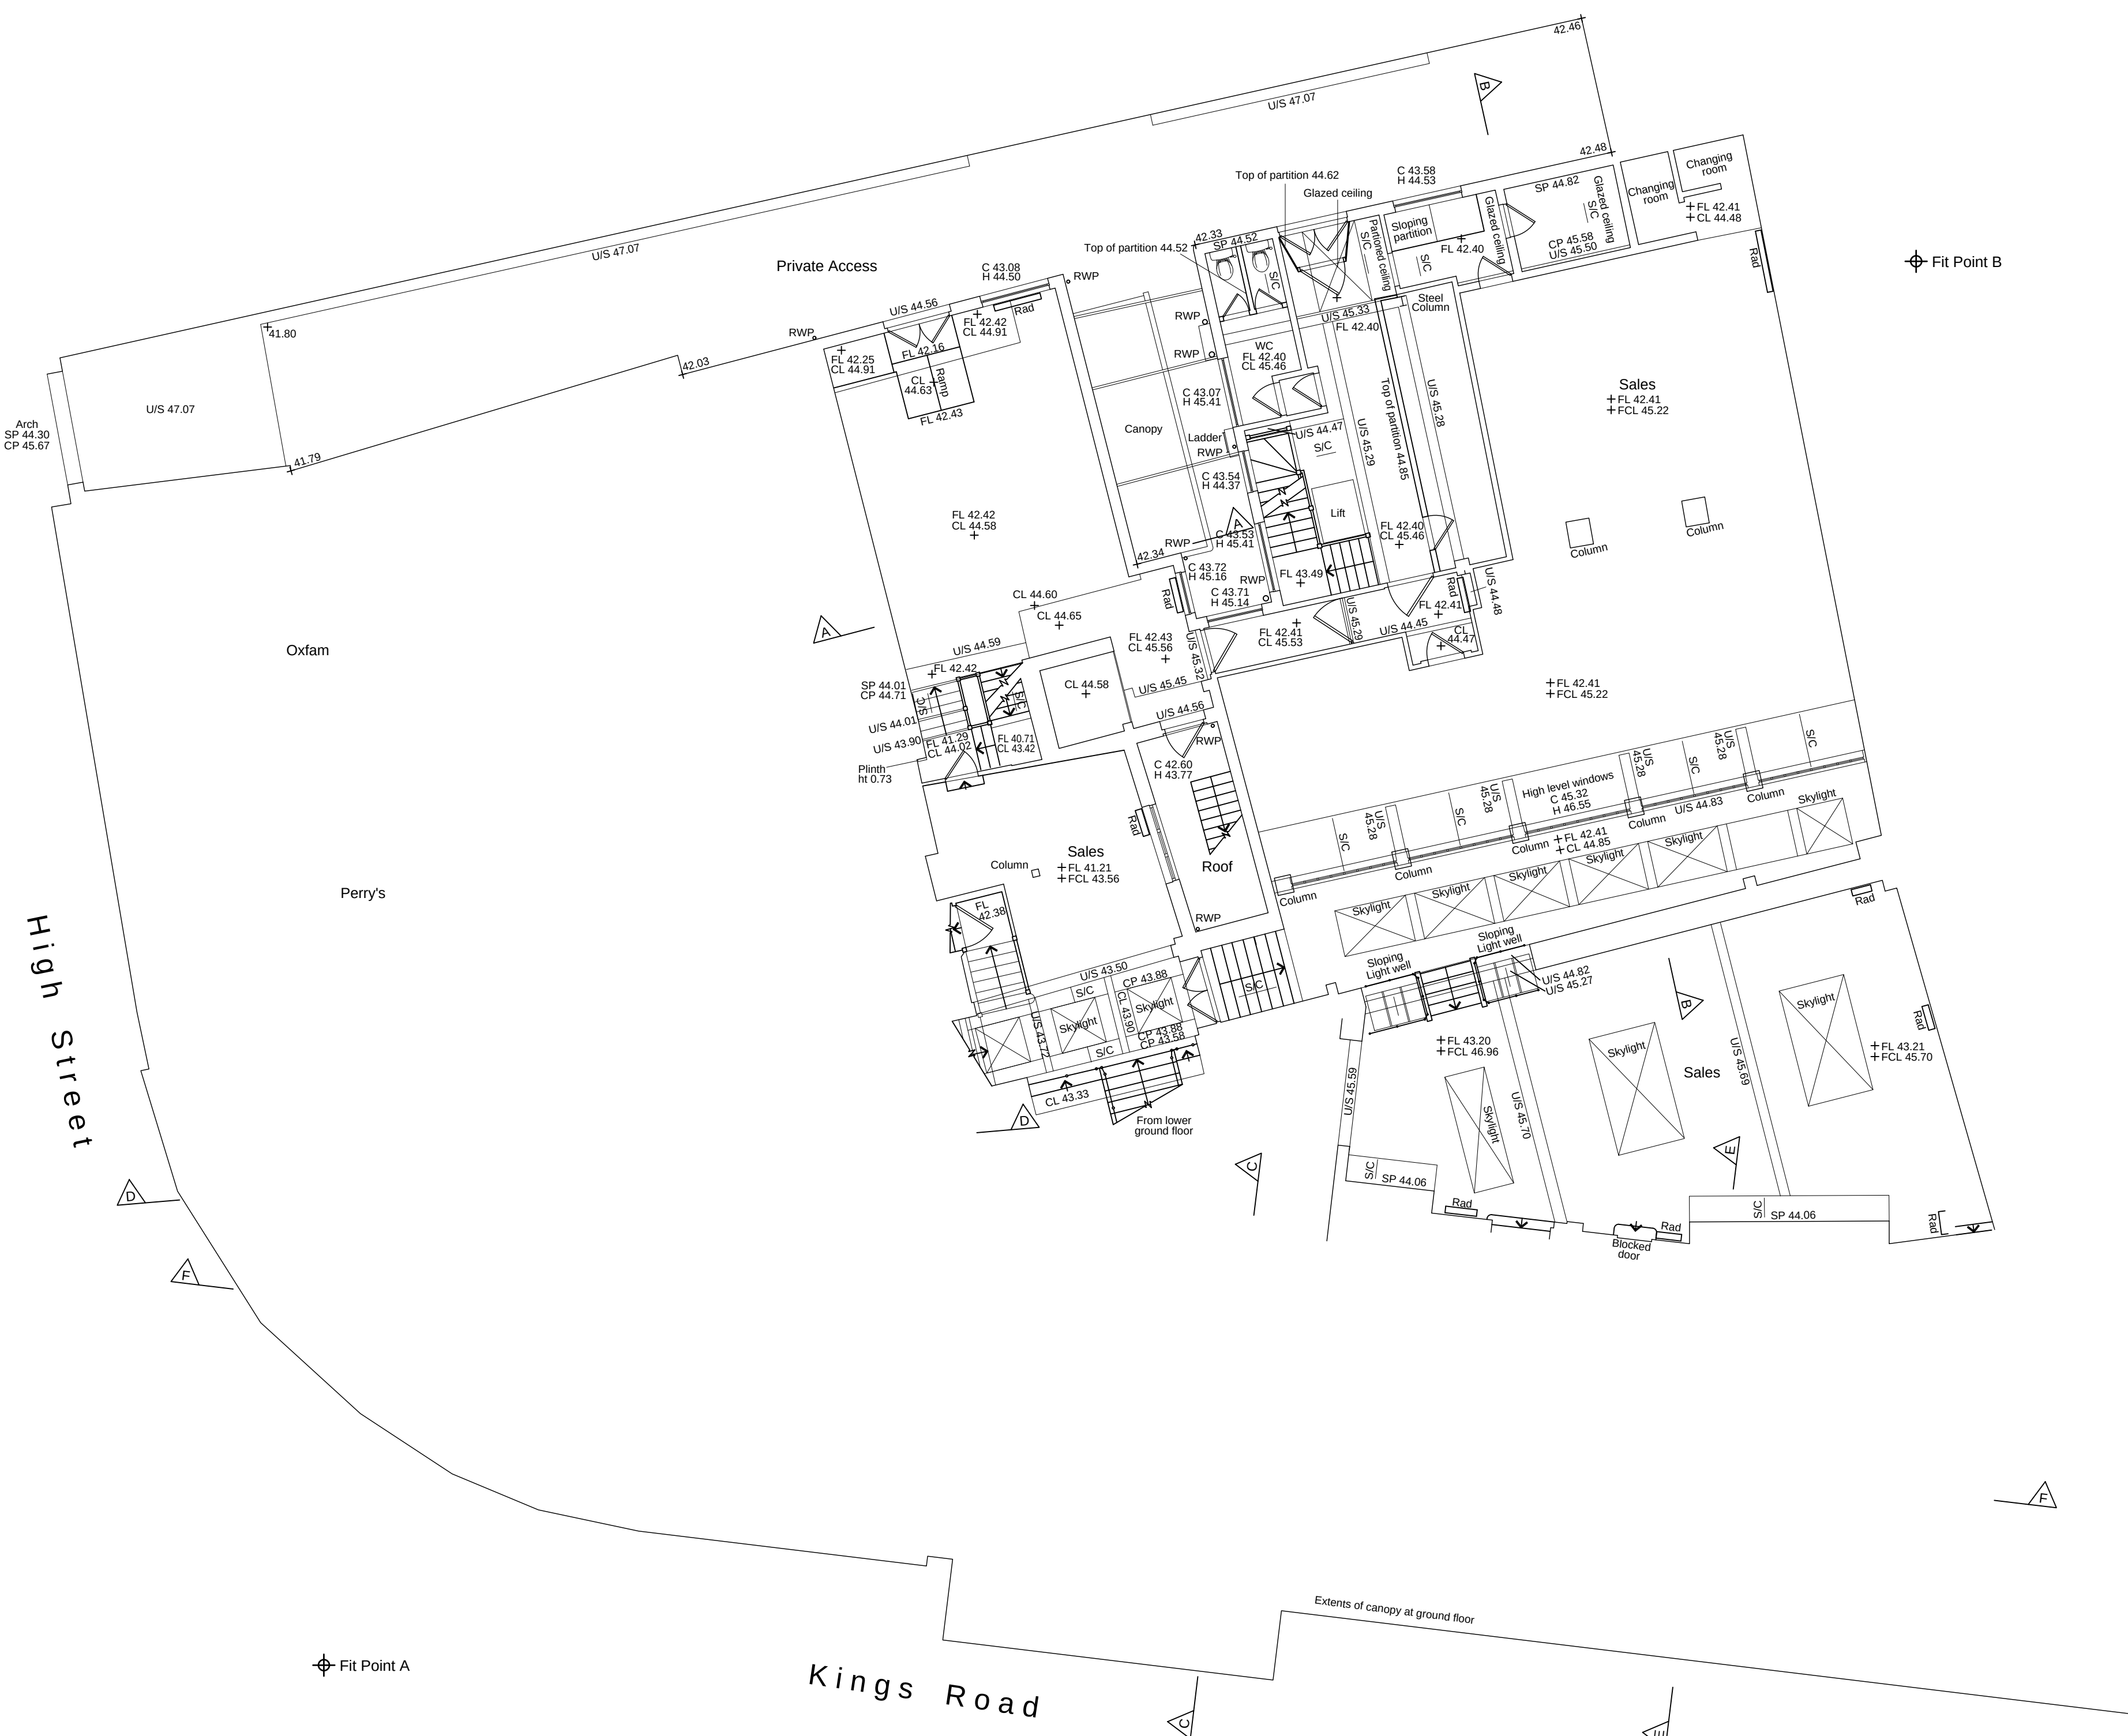

Notes :



1. LEVELS BASED ON OS DATUM.
2. WINDOW CILL AND HEAD LEVELS MEASURED INTERNALLY.
3. SANITARY FITTINGS INDICATIVE ONLY.

Level abbreviations used :

C	CILL LEVEL
CL	CEILING LEVEL
CVL	COVER LEVEL
CP	CROWN LEVEL
DH	DOOR HEAD LEVEL
FL	FLOOR LEVEL
H	HEAD LEVEL
SP	SPRING LEVEL
U/S	UNDER SIDE
FCL	FALSE CEILING LEVEL

General abbreviations used :

AB	AIR BRICK
ACU	AIR-CON UNIT
GY	GULLY
→	JOIST DIRECTION
IC	INSPECTION COVER
MH	MANHOLE
Rad	RADIATOR
RC	RADIATOR COVER
RE	RODDING EYE
RS	ROLLER SHUTTER
RWP	RAIN WATER PIPE
S/C	SLOPING CEILING
SVP	SOIL VENT PIPE
TOW	TOP OF WALL LEVEL
→	STEP UP
U/S	UNDER SIDE
VP	VENT PIPE
▷	FALL IN ROOF

  


PROJECT

JACKSONS CORNER
1-9 KING'S ROAD, READING

CLIENT

READING SECURITIES 2 LLP
INTERNATIONAL HOUSE, 1-6 YARMOUTH PLACE, W1J 7BU

DESIGNERS

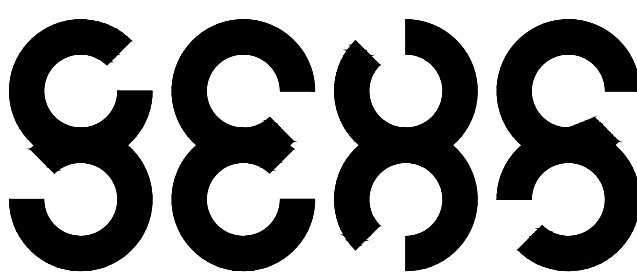

S333
Architecture+Urbanism
London

70 Cowcross
London EC1M 6EJ
Tel : +44(0) 20 7336 7026
Fax: +44(0) 20 7336 7027
info@s333.org
www.s333.org

TITLE

**EXISTING UPPER GROUND FLOOR
PLAN**

	NAME	SIGNATURE	DATE
Drawn by	AMc		
Checked			
Revision A			
Revision B			
Revision C			
Revision D			


SCALE @ FORMAT
1:100 @ A1

FILE NAME
1300 C 100 01 SURVEY PLANS

ISSUE DATE
08.04.2016

PROPOSED STATUS
PLANNING APPLICATION

PROJECT	TYPE	SEQUENCE No.	REV.	NOTE
1	3	0	0	3

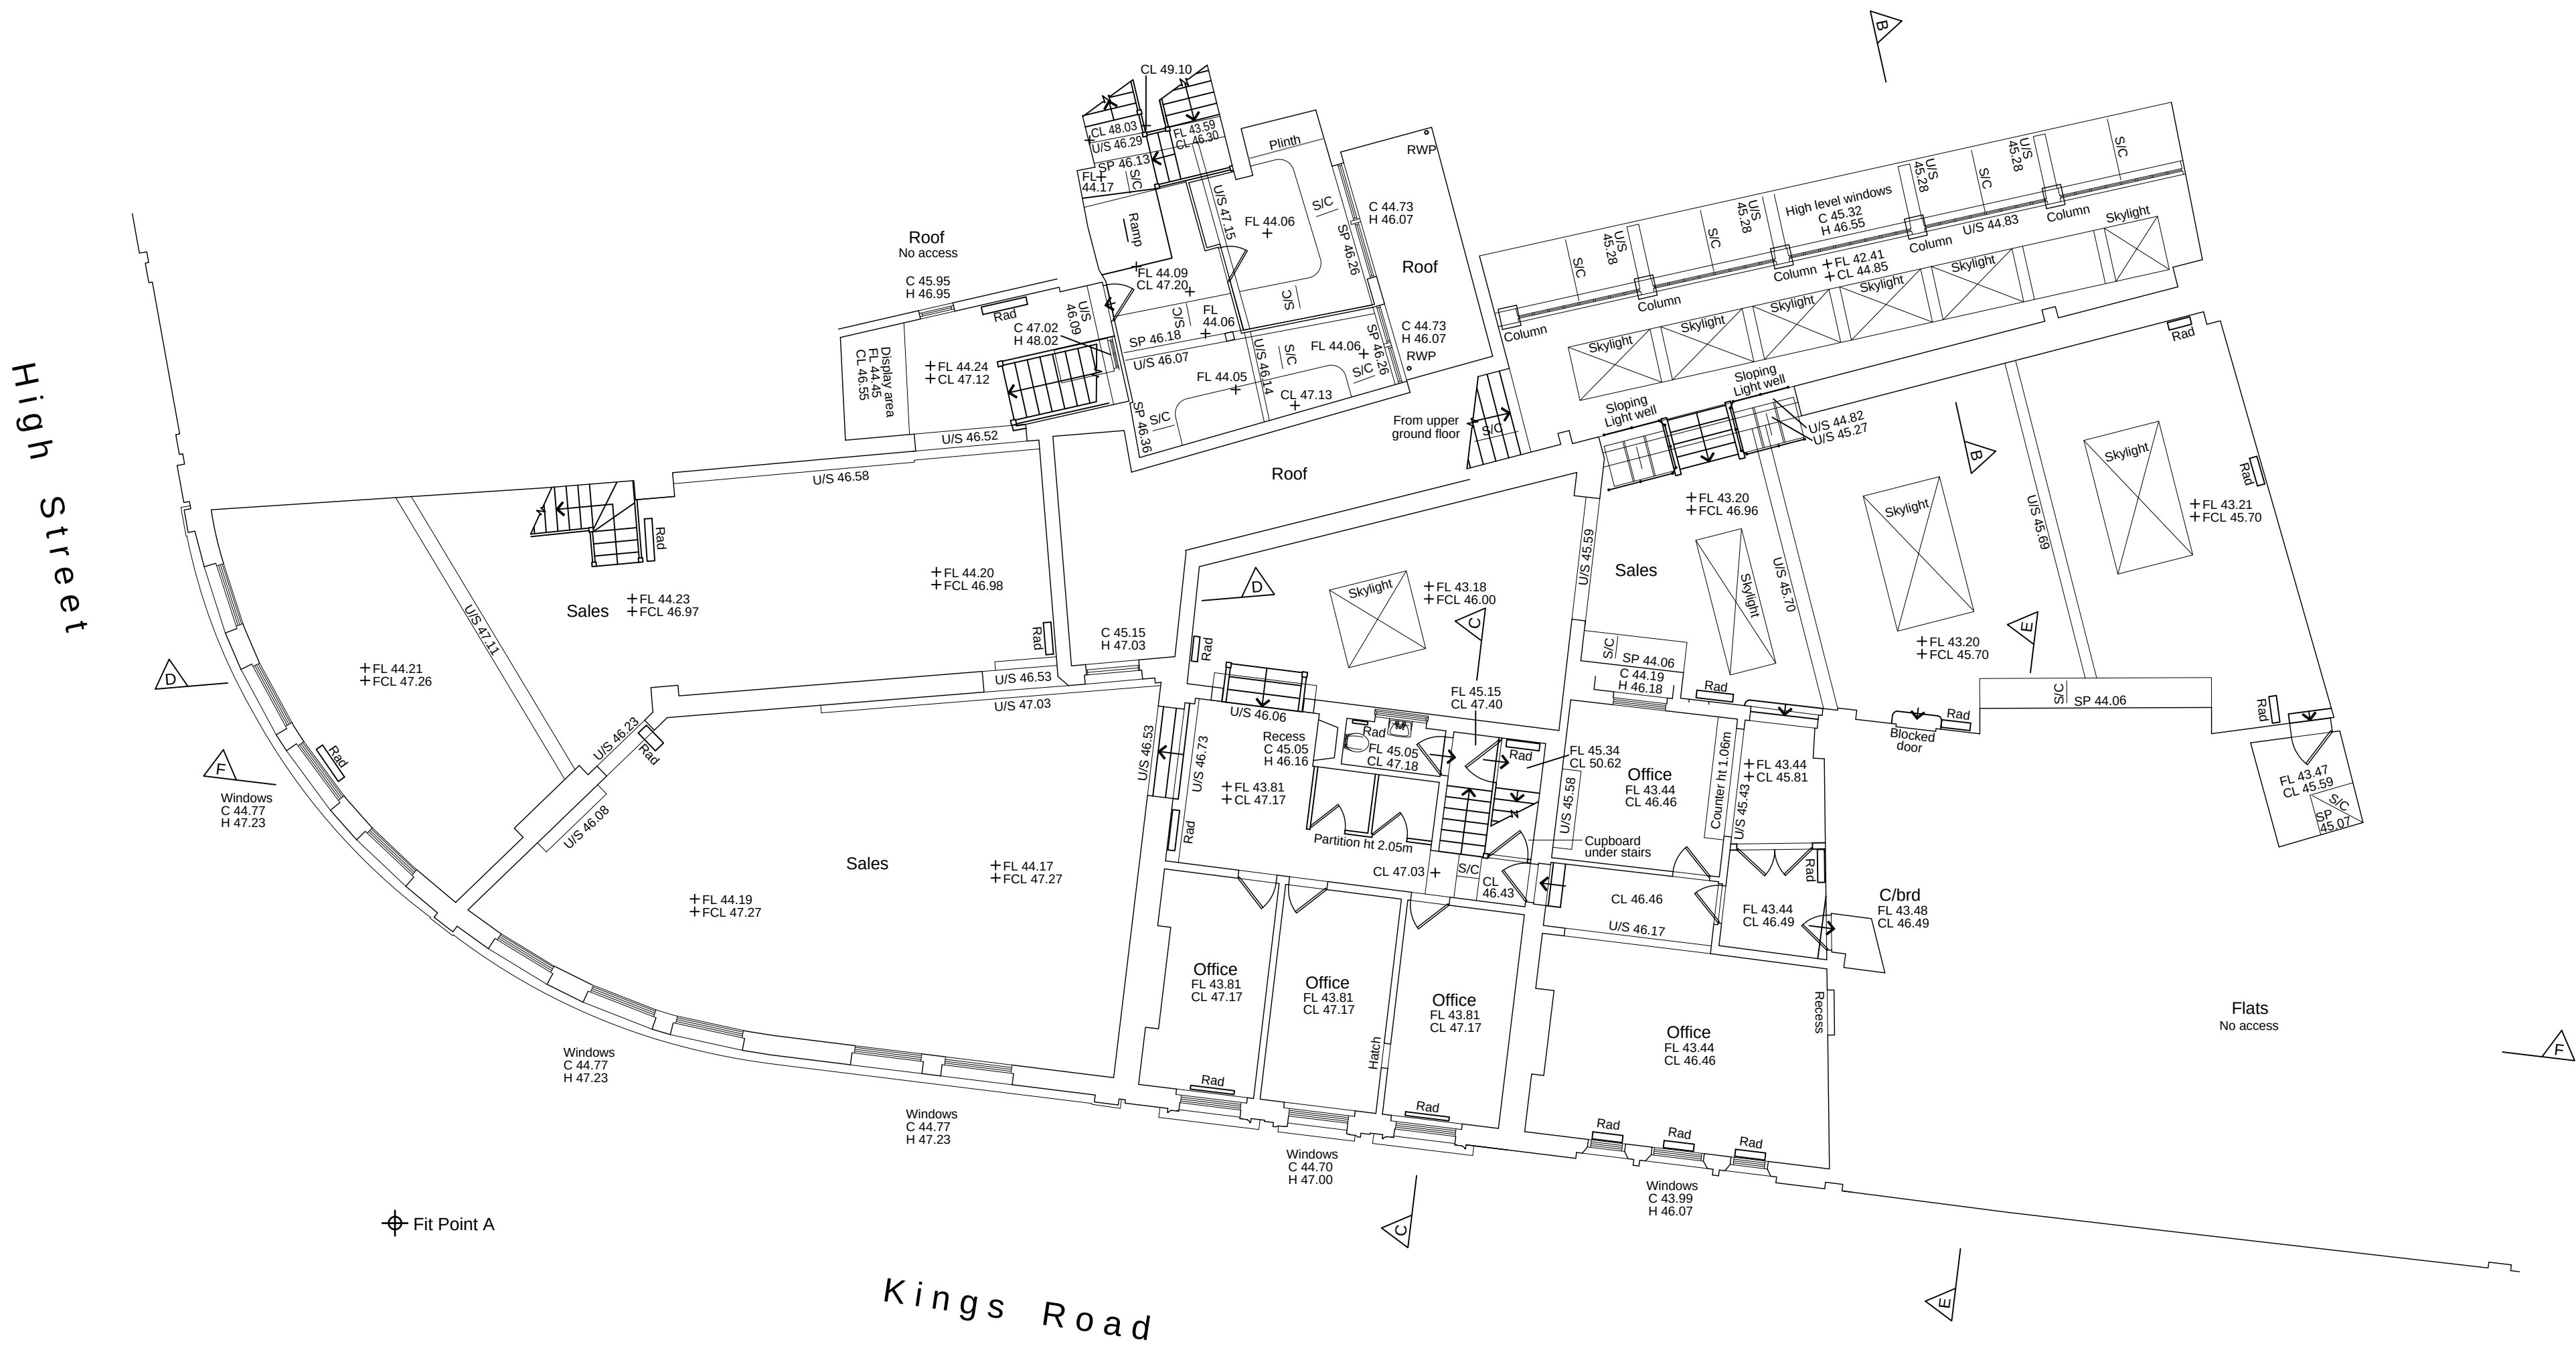

Notes :



1. LEVELS BASED ON OS DATUM.
2. WINDOW CILL AND HEAD LEVELS MEASURED INTERNALLY.
3. SANITARY FITTINGS INDICATIVE ONLY.

Level abbreviations used :

C	CILL LEVEL
CL	CEILING LEVEL
CVL	COVER LEVEL
CP	CROWN LEVEL
DH	DOOR HEAD LEVEL
FL	FLOOR LEVEL
H	HEAD LEVEL
SP	SPRING LEVEL
U/S	UNDER SIDE
FCL	FALSE CEILING LEVEL

General abbreviations used :

AB	AIR BRICK
ACU	AIR-CON UNIT
GY	GULLY
→	JOIST DIRECTION
IC	INSPECTION COVER
MH	MANHOLE
Rad	RADIATOR
RC	RADIATOR COVER
RE	RODDING EYE
RS	ROLLER SHUTTER
RWP	RAIN WATER PIPE
S/C →	SLOPING CEILING
SVP	SOIL VENT PIPE
TOW	TOP OF WALL LEVEL
→	STEP UP
U/S	UNDER SIDE
VP	VENT PIPE
▷	FALL IN ROOF

  


PROJECT

JACKSONS CORNER
1-9 KING'S ROAD, READING

CLIENT

READING SECURITIES 2 LLP
INTERNATIONAL HOUSE, 1-6 YARMOUTH PLACE, W1J 7BU

DESIGNERS

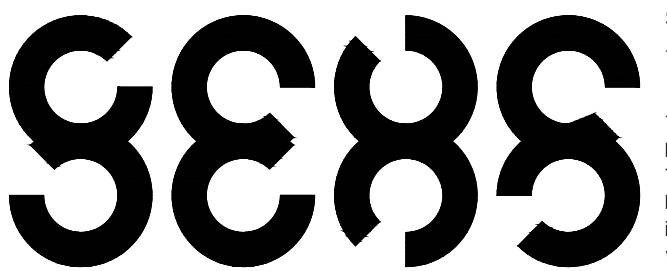

S333
Architecture+Urbanism
London

70 Cowcross
London EC1M 6EJ
Tel : +44(0) 20 7336 7026
Fax: +44(0) 20 7336 7027
info@s333.org
www.s333.org

TITLE

EXISTING FIRST FLOOR PLAN

	NAME	SIGNATURE	DATE
Drawn by	AMc		
Checked			
Revision A			
Revision B			
Revision C			
Revision D			

SCALE @ FORMAT 1:100 @ A1	FILE NAME 1300 C 100 01 SURVEY PLANS
ISSUE DATE 08.04.2016	PROPOSED STATUS PLANNING APPLICATION

PROJECT	TYPE	SEQUENCE No.	REV.	NOTE
1 3 0 0	1 1	0 0 4		



Notes :


1. LEVELS BASED ON OS DATUM.
2. WINDOW CILL AND HEAD LEVELS MEASURED INTERNALLY.
3. SANITARY FITTINGS INDICATIVE ONLY.

Level abbreviations used :

- | | |
|-----|---------------------|
| C | CILL LEVEL |
| CL | CEILING LEVEL |
| CVL | COVER LEVEL |
| CP | CROWN LEVEL |
| DH | DOOR HEAD LEVEL |
| FL | FLOOR LEVEL |
| H | HEAD LEVEL |
| SP | SPRING LEVEL |
| U/S | UNDER SIDE |
| FCL | FALSE CEILING LEVEL |

General abbreviations used :

- | | |
|-----|-------------------|
| AB | AIR BRICK |
| ACU | AIR-CON UNIT |
| GY | GULLY |
| → | JOIST DIRECTION |
| IC | INSPECTION COVER |
| MH | MANHOLE |
| Rad | RADIATOR |
| RC | RADIATOR COVER |
| RE | RODDING EYE |
| RS | ROLLER SHUTTER |
| RWP | RAIN WATER PIPE |
| S/C | SLOPING CEILING |
| SVP | SOIL VENT PIPE |
| TOW | TOP OF WALL LEVEL |
| → | STEP UP |
| U/S | UNDER SIDE |
| VP | VENT PIPE |
| ▷ | FALL IN ROOF |

 

0 1m 2m 5m 10m

PROJECT

JACKSONS CORNER
1-9 KING'S ROAD, READING

CLIENT

READING SECURITIES 2 LLP
INTERNATIONAL HOUSE, 1-6 YARMOUTH PLACE, W1J 7BU

DESIGNERS

S333
S333
Architecture+Urbanism
London
70 Cowcross
London EC1M 6EJ
Tel : +44(0) 20 7336 7026
Fax: +44(0) 20 7336 7027
info@s333.org
www.s333.org


TITLE

EXISTING SECOND FLOOR PLAN

	NAME	SIGNATURE	DATE
Drawn by	AMc		
Checked			
Revision A			
Revision B			
Revision C			
Revision D			

SCALE @ FORMAT 1:100 @ A1	FILE NAME 1300 C 100 01 SURVEY PLANS
ISSUE DATE 08.04.2016	PROPOSED STATUS PLANNING APPLICATION

PROJECT	TYPE	SEQUENCE No.	REV.	NOTE
1	3	0	0	5

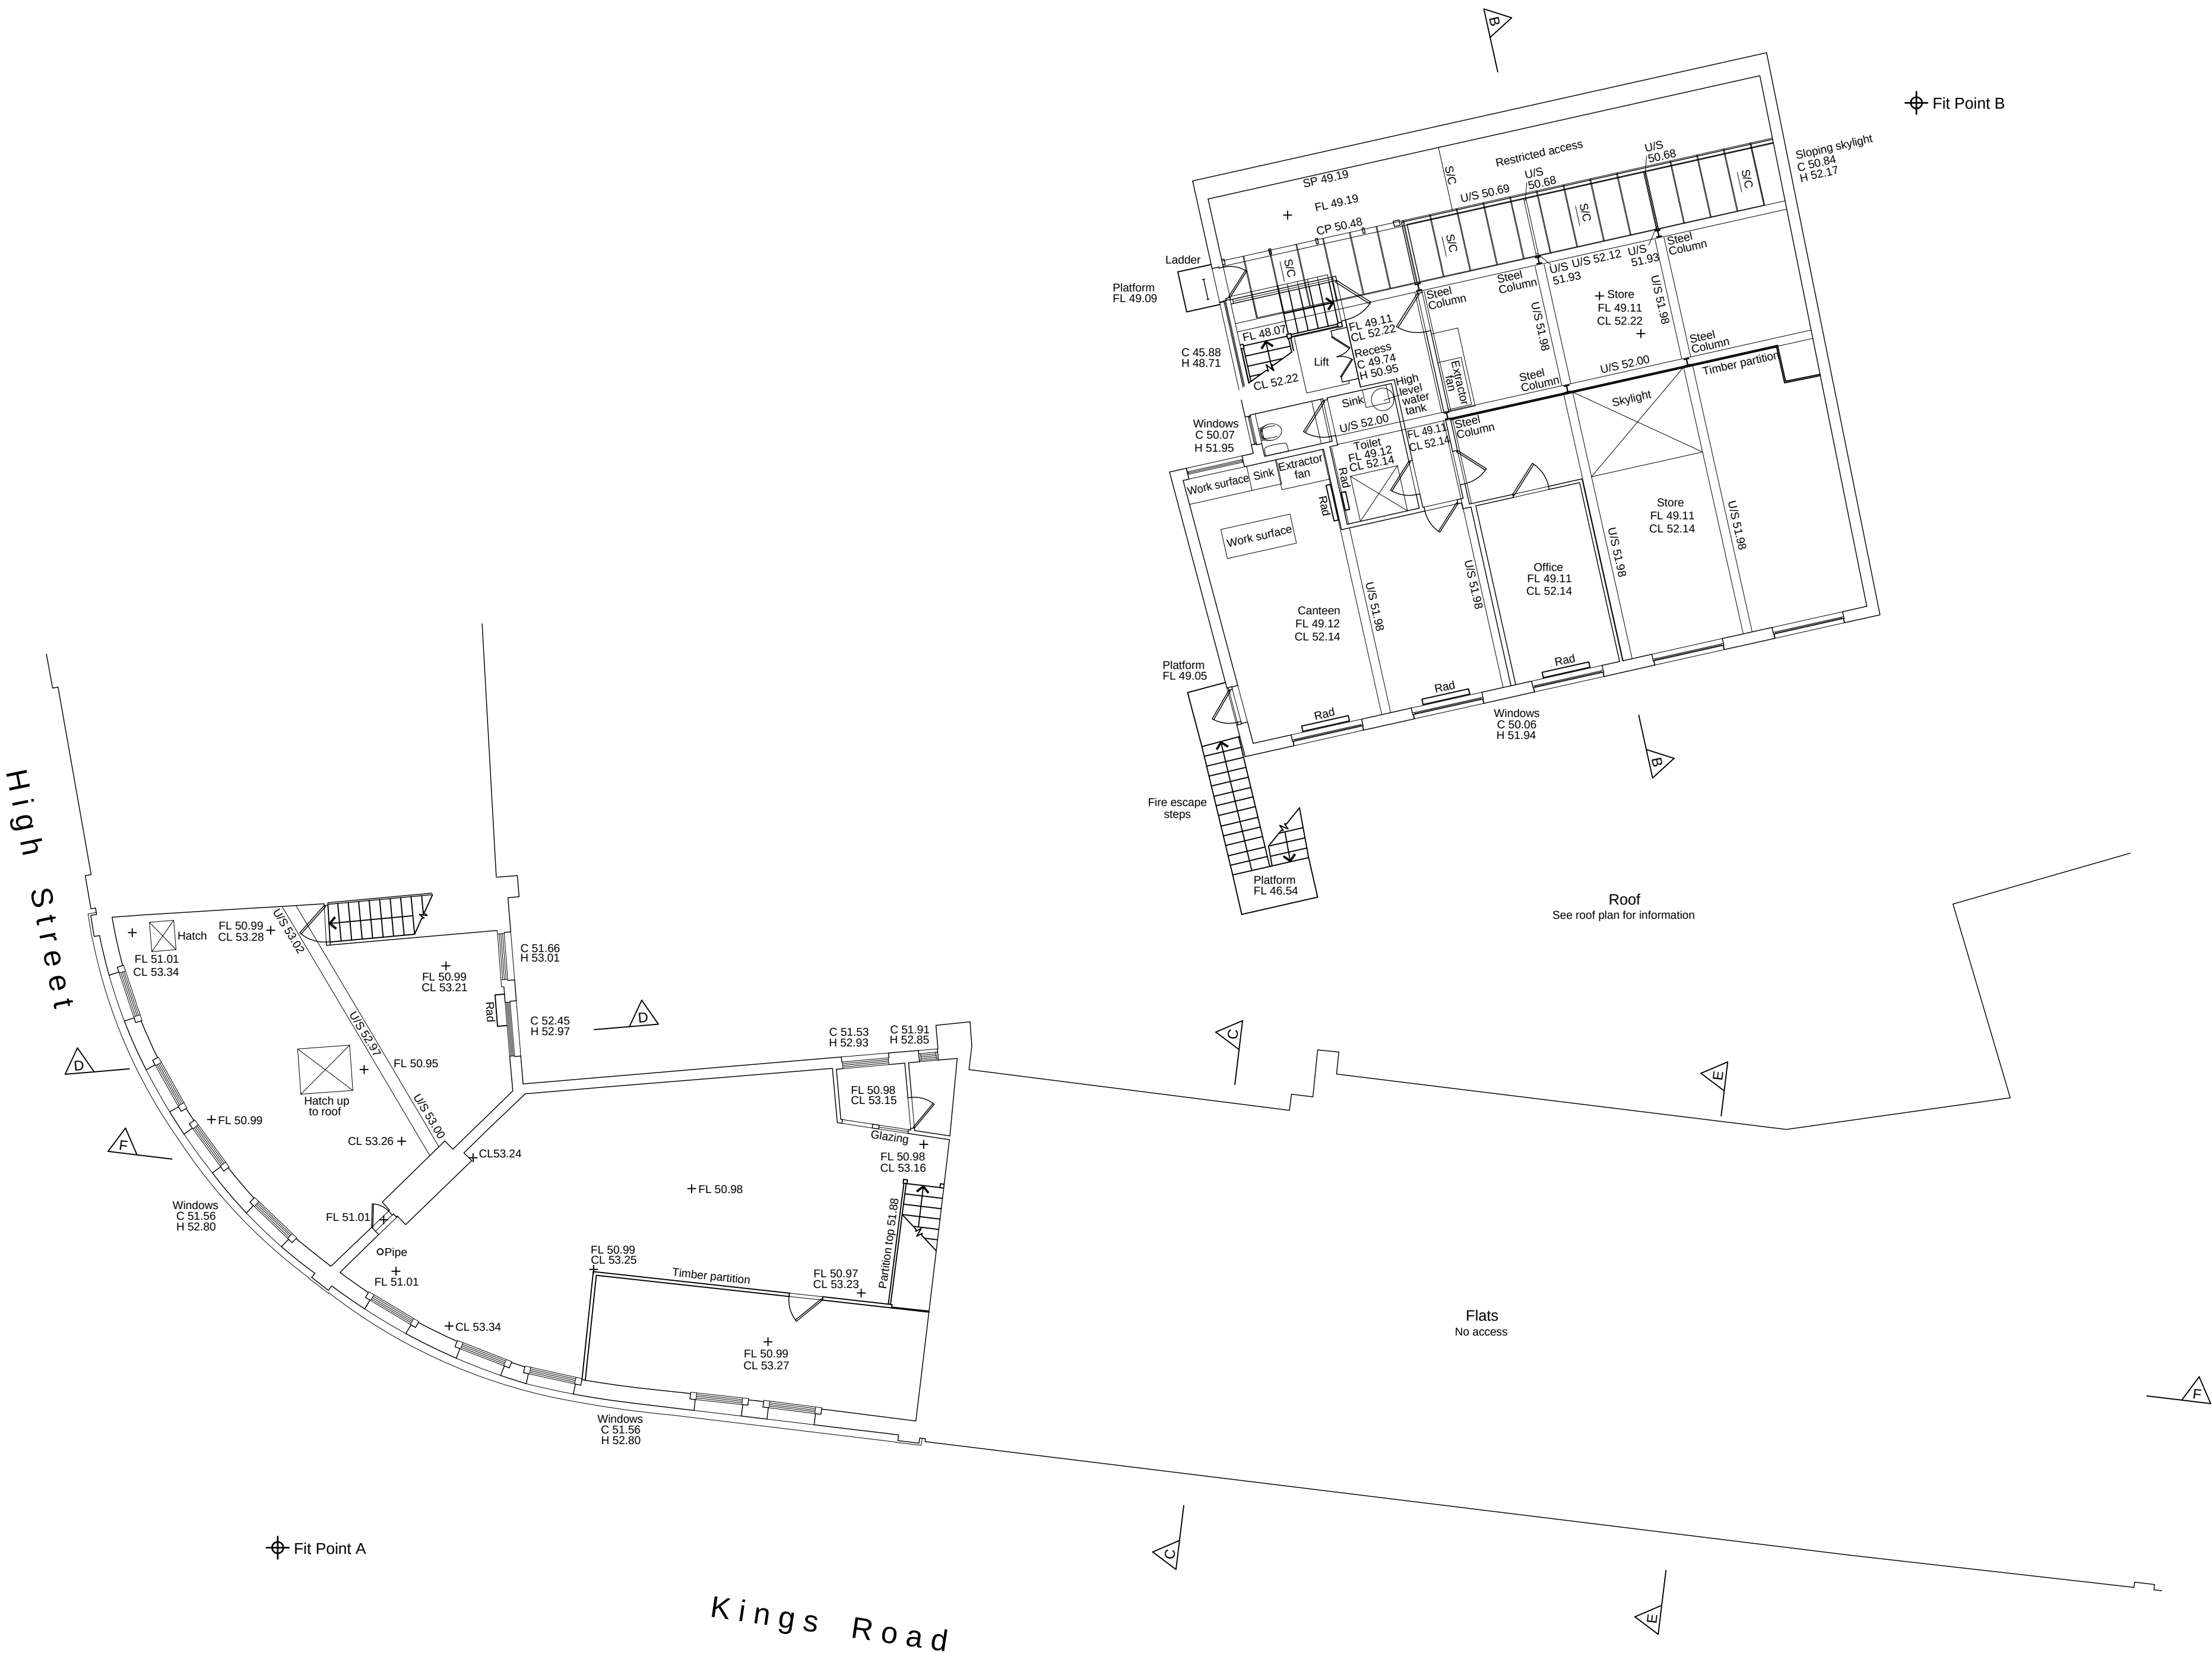

Notes :


1. LEVELS BASED ON OS DATUM.
2. WINDOW CILL AND HEAD LEVELS MEASURED INTERNALLY.
3. SANITARY FITTINGS INDICATIVE ONLY.

Level abbreviations used :

- | | |
|-----|---------------------|
| C | CILL LEVEL |
| CL | CEILING LEVEL |
| CVL | COVER LEVEL |
| CP | CROWN LEVEL |
| DH | DOOR HEAD LEVEL |
| FL | FLOOR LEVEL |
| H | HEAD LEVEL |
| SP | SPRING LEVEL |
| U/S | UNDER SIDE |
| FCL | FALSE CEILING LEVEL |

General abbreviations used :

- | | |
|-----|-------------------|
| AB | AIR BRICK |
| ACU | AIR-CON UNIT |
| GY | GULLY |
| → | JOIST DIRECTION |
| IC | INSPECTION COVER |
| MH | MANHOLE |
| Rad | RADIATOR |
| RC | RADIATOR COVER |
| RE | RODDING EYE |
| RS | ROLLER SHUTTER |
| RWP | RAIN WATER PIPE |
| S/C | SLOPING CEILING |
| SVP | SOIL VENT PIPE |
| TOW | TOP OF WALL LEVEL |
| → | STEP UP |
| U/S | UNDER SIDE |
| VP | VENT PIPE |
| ▷ | FALL IN ROOF |

 

0 1m 2m 5m 10m

PROJECT

JACKSONS CORNER
1-9 KING'S ROAD, READING

CLIENT

READING SECURITIES 2 LLP
INTERNATIONAL HOUSE, 1-6 YARMOUTH PLACE, W1J 7BU

DESIGNERS

S333
S333
Architecture+Urbanism
London
70 Cowcross
London EC1M 6EJ
Tel : +44(0) 20 7336 7026
Fax: +44(0) 20 7336 7027
info@s333.org
www.s333.org

TITLE

EXISTING THIRD FLOOR PLAN

	NAME	SIGNATURE	DATE
Drawn by	AMc		
Checked			
Revision A			
Revision B			
Revision C			
Revision D			

SCALE @ FORMAT 1:100 @ A1	FILE NAME 1300 C 100 01 SURVEY PLANS
ISSUE DATE 08.04.2016	PROPOSED STATUS PLANNING APPLICATION

PROJECT	TYPE	SEQUENCE No.	REV.	NOTE
1	3	0	0	6



Notes :



1. LEVELS BASED ON OS DATUM.
2. WINDOW CILL AND HEAD LEVELS MEASURED INTERNALLY.
3. SANITARY FITTINGS INDICATIVE ONLY.

Level abbreviations used :

C	CILL LEVEL
CL	CEILING LEVEL
CVL	COVER LEVEL
CP	CROWN LEVEL
DH	DOOR HEAD LEVEL
FL	FLOOR LEVEL
H	HEAD LEVEL
SP	SPRING LEVEL
U/S	UNDER SIDE
FCL	FALSE CEILING LEVEL

General abbreviations used :

AB	AIR BRICK
ACU	AIR-CON UNIT
GY	GULLY
→	JOIST DIRECTION
IC	INSPECTION COVER
MH	MANHOLE
Rad	RADIATOR
RC	RADIATOR COVER
RE	RODDING EYE
RS	ROLLER SHUTTER
RWP	RAIN WATER PIPE
S/C	SLOPING CEILING
SVP	SOIL VENT PIPE
TOW	TOP OF WALL LEVEL
→	STEP UP
U/S	UNDER SIDE
VP	VENT PIPE
▽	FALL IN ROOF

 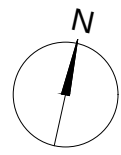

PROJECT

JACKSONS CORNER
1-9 KING'S ROAD, READING

CLIENT

READING SECURITIES 2 LLP
INTERNATIONAL HOUSE, 1-6 YARMOUTH PLACE, W1J 7BU

DESIGNERS

S333
S333
Architecture+Urbanism
London
70 Cowcross
London EC1M 6EJ
Tel : +44(0) 20 7336 7026
Fax: +44(0) 20 7336 7027
info@s333.org
www.s333.org

TITLE

EXISTING ROOF PLAN

	NAME	SIGNATURE	DATE
Drawn by	AMc		
Checked			
Revision A			
Revision B			
Revision C			
Revision D			

SCALE @ FORMAT 1:100 @ A1	FILE NAME 1300 C 100 01 SURVEY PLANS
ISSUE DATE 08.04.2016	PROPOSED STATUS PLANNING APPLICATION

PROJECT	TYPE	SEQUENCE No.	REV.	NOTE
1	3	0	0	7