



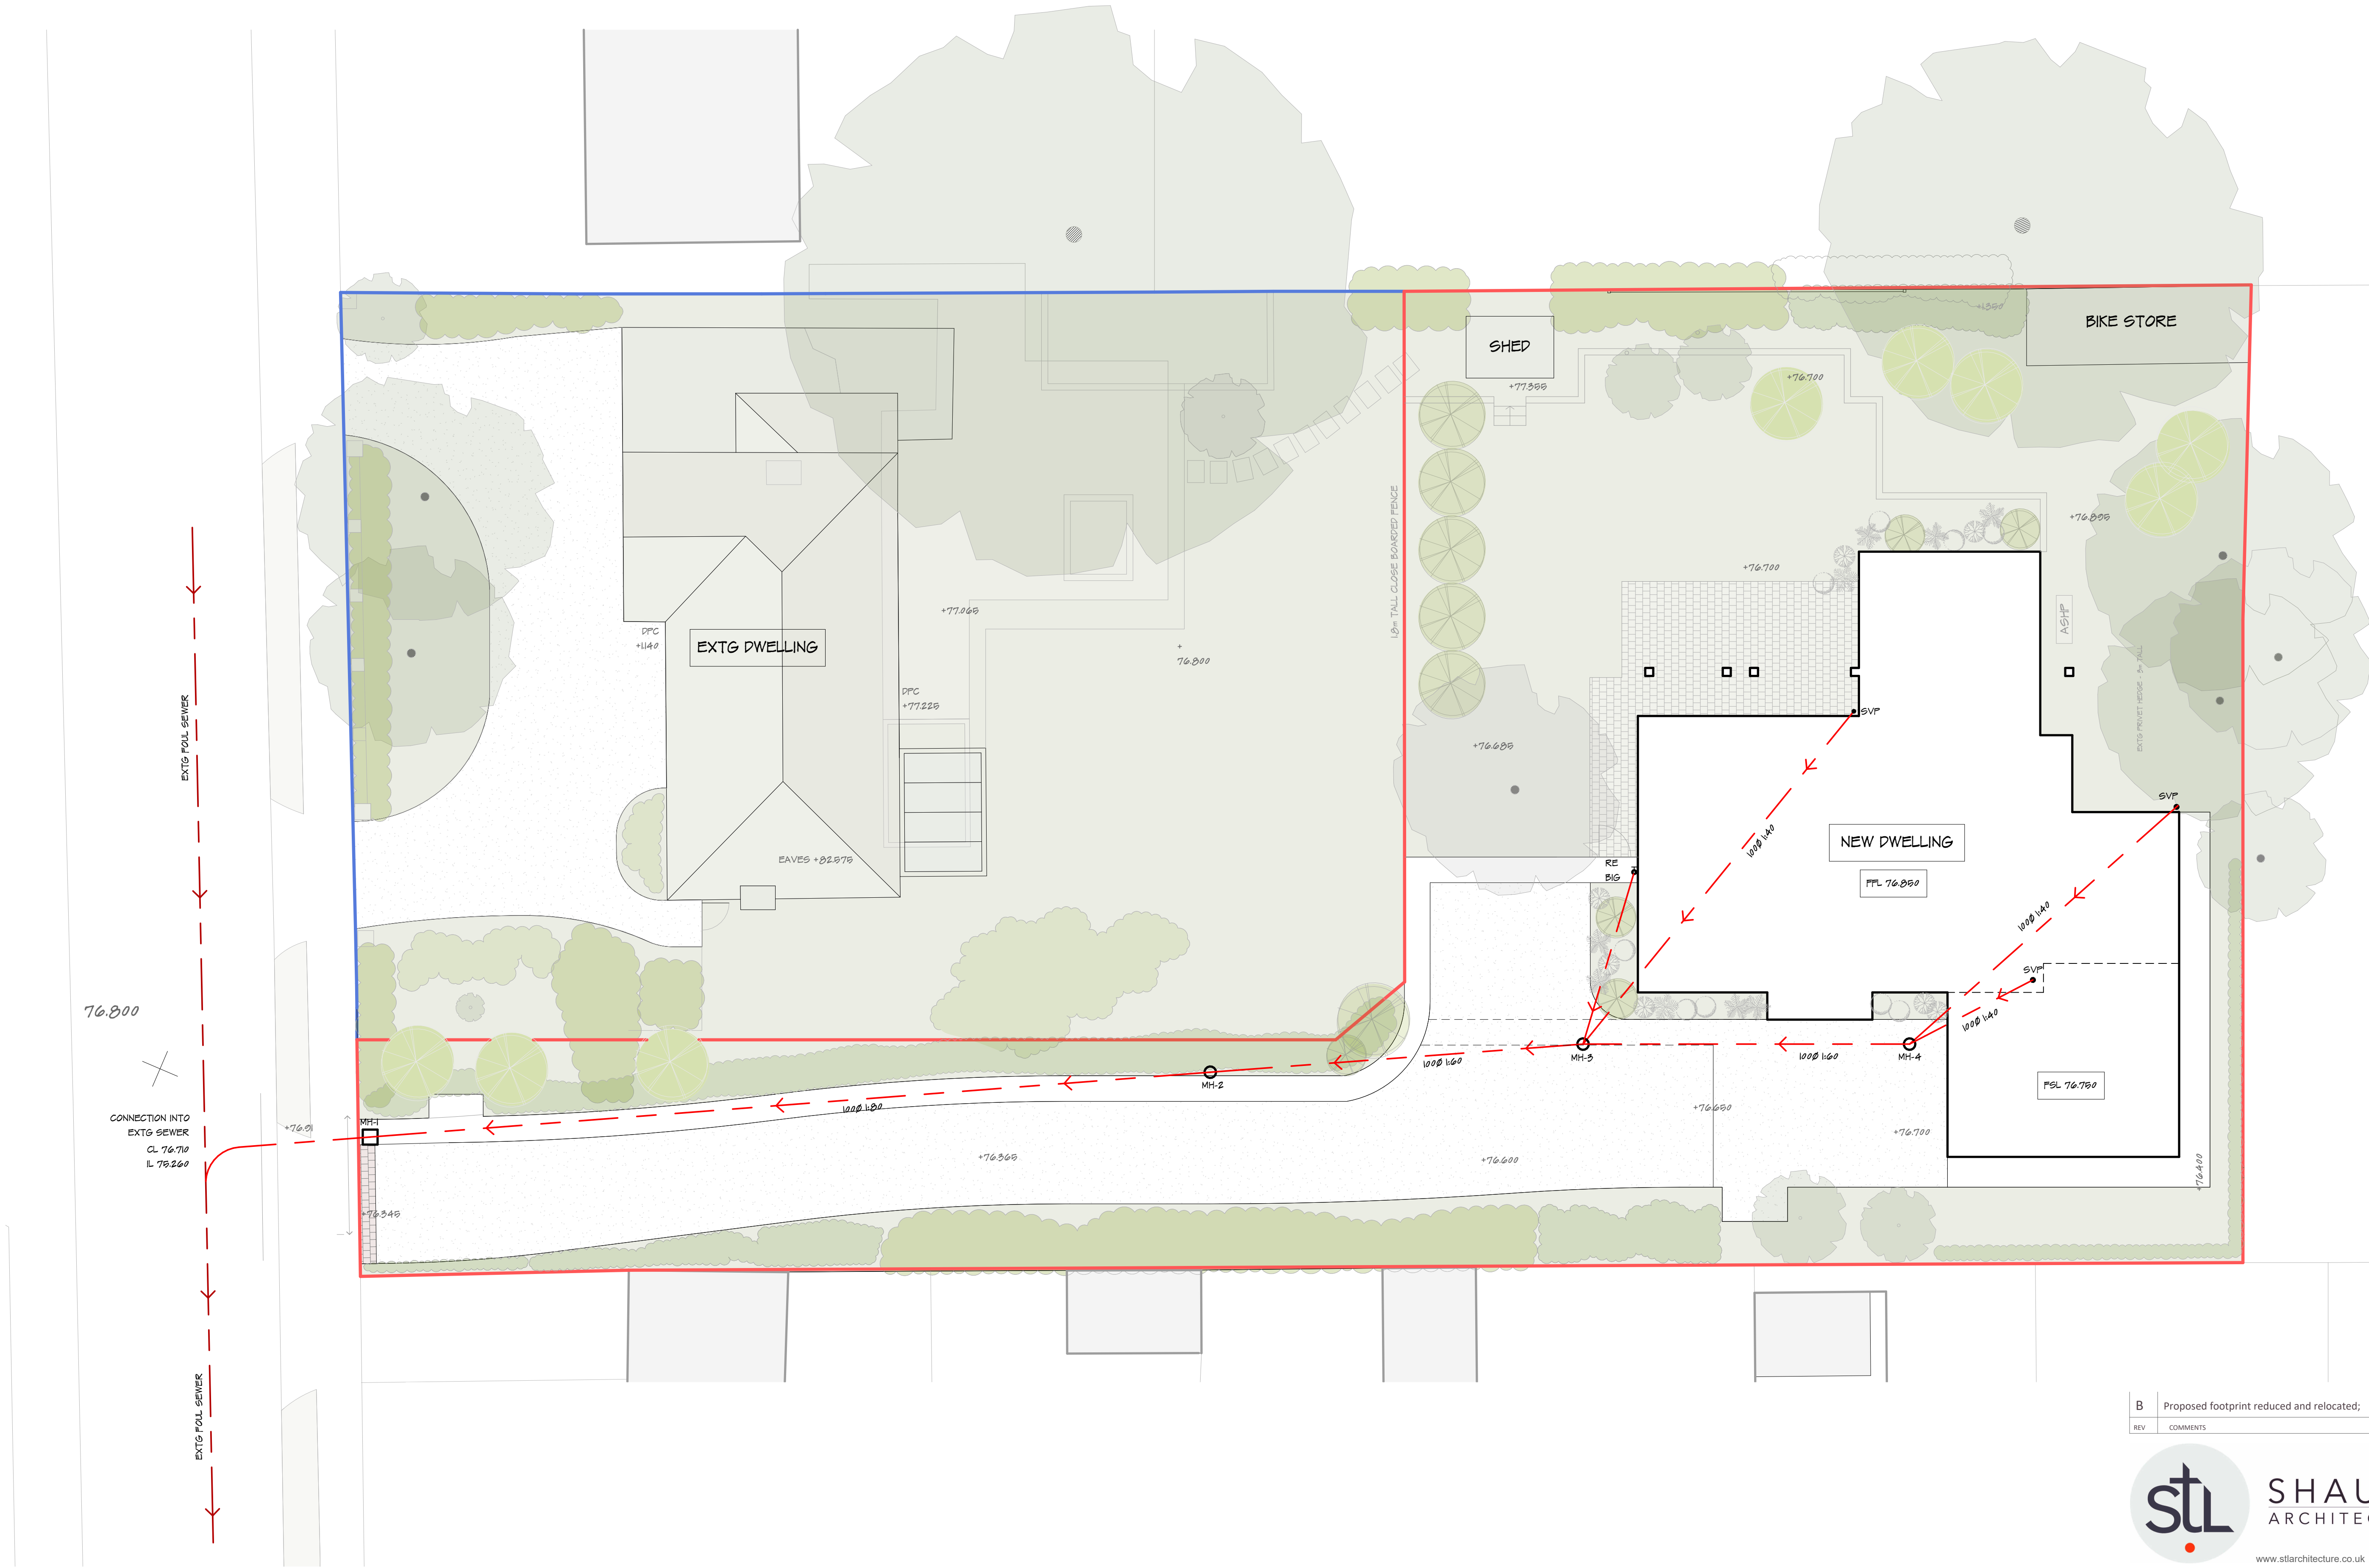

1 Foul Water Drainage Plan
1 : 100

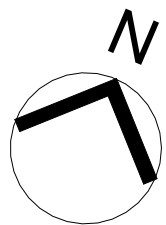

1:100 scale Bar
This Drawing has been produced for printing onto A1 size paper

DRAINAGE LEVELS

	C. L.	I. L.
MH-1	76.350	75.400
MH-2	76.420	75.730
MH-3	76.650	75.960
MH-4	76.700	76.100

B	Proposed footprint reduced and relocated;	08/05/24
REV	COMMENTS	DATE



SHAUN TANNER
ARCHITECTURE & PLANNING

www.stlarchitecture.co.uk studio@stlarchitecture.co.uk 0118 989 0808

CLIENT Mr & Mrs R. Smith
PROJECT 98 Conisboro Avenue
Caversham, Reading - RG4 7JF

DRAWING Foul Water Drainage Plan
STATUS Planning
SCALE 1 : 100
DRAWN RC **CHECKED** NO 3902/208 **REV** B
DATE July 23

THIS DRAWING MUST NOT BE SCALED UNLESS ISSUED FOR PLANNING PURPOSES. ALL DIMENSIONS ARE TO BE VERIFIED PRIOR TO SETTING OUT, COMMENCING WORK, OR PRODUCTION OF FABRICATION DRAWINGS. REPORT ANY DISCREPANCIES TO THE SUPERVISING OFFICER IMMEDIATELY. ©