

Quote Q00001

Oktra R+ 2 Blagrove Street Reading

Product Reference	Product Description	Product Code	Width	Dimensions (mm) Height	Length	Air Volume (m³/s)	Pressure Loss (Pa)
ATT19	Crosstalk	LG01V/3A/L/S	275	275	915	0.01	1
ATT20	Crosstalk	LG01V/3A/L/S	275	275	915	0.04	1
ATT21	Attenuator	LG01H/3C/L/S	500	300	1050	0.30	4
ATT22	Attenuator	LG01H/3C/L/S	500	300	1050	0.30	4
ATT23	Attenuator	LG01H/3C/L/S	500	300	1050	0.30	4
ATT24	Attenuator	LG01H/3C/L/S	500	300	1050	0.30	4
ATT25	Attenuator	LG01H/3C/L/S	500	355	1200	0.35	4
ATT26	Attenuator	LG01H/3C/L/S	500	355	1200	0.35	4
ATT27	Attenuator	LG01H/3C/L/S	300	275	1050	0.20	7
ATT28	Attenuator	LG01H/3C/L/S	300	275	1050	0.20	7

05



GENERAL NOTES


THIS DRAWING MUST NOT BE SCALED. ALL DIMENSIONS TO BE CHECKED.

THIS DRAWING IS TO BE READ IN CONJUNCTION WITH ALL RELEVANT STRUCTURAL ENGINEER'S DRAWING AND DETAILS. THE SPECIFICATION FOR THE WORKS, THE RELEVANT ARCHITECTS DRAWINGS AND ANY OTHER SPECIALISTS DRAWINGS.

NOTE THAT 'AS INSTALLED DRAWINGS' SHOULD BE USED FOR CO-ORDINATION OF MEP SYSTEMS.

MECHANICAL LEGEND

	EXISTING UNITS
	NEW UNITS
	RELOCATED UNITS
	LEAK DETECTION
	R32 GAS LEAK DETECTION
	EXISTING SERVICES
	NEW REFRIGERANT SERVICES
	NEW CONDENSATE SERVICES
	NEW PRIMARY FRESH AIR
	NEW SECONDARY SUPPLY AIR
	NEW RETURN AIR / EXTRACT
	INSULATED DUCTWORK
	EXTRACT FAN
	VOLUME CONTROL DAMPER (VCD)
	NON RETURN DAMPER (NRD)
	MOTORISED CONTROL DAMPER (MCD)
	FIRE DAMPER (FD) C/W ACCESS PANEL
	SMOKE DAMPER (SD) C/W ACCESS PANEL
	FIRE SMOKE DAMPER (FSD) C/W AP
	AC CONTROLLER
	TEMPERATURE SENSOR
	CO2 SENSOR
	HEATER BATTERY
	ATTENUATOR / SILENCER
	ACCESS PANEL
	CUT BACK LINEAR DIFFUSER

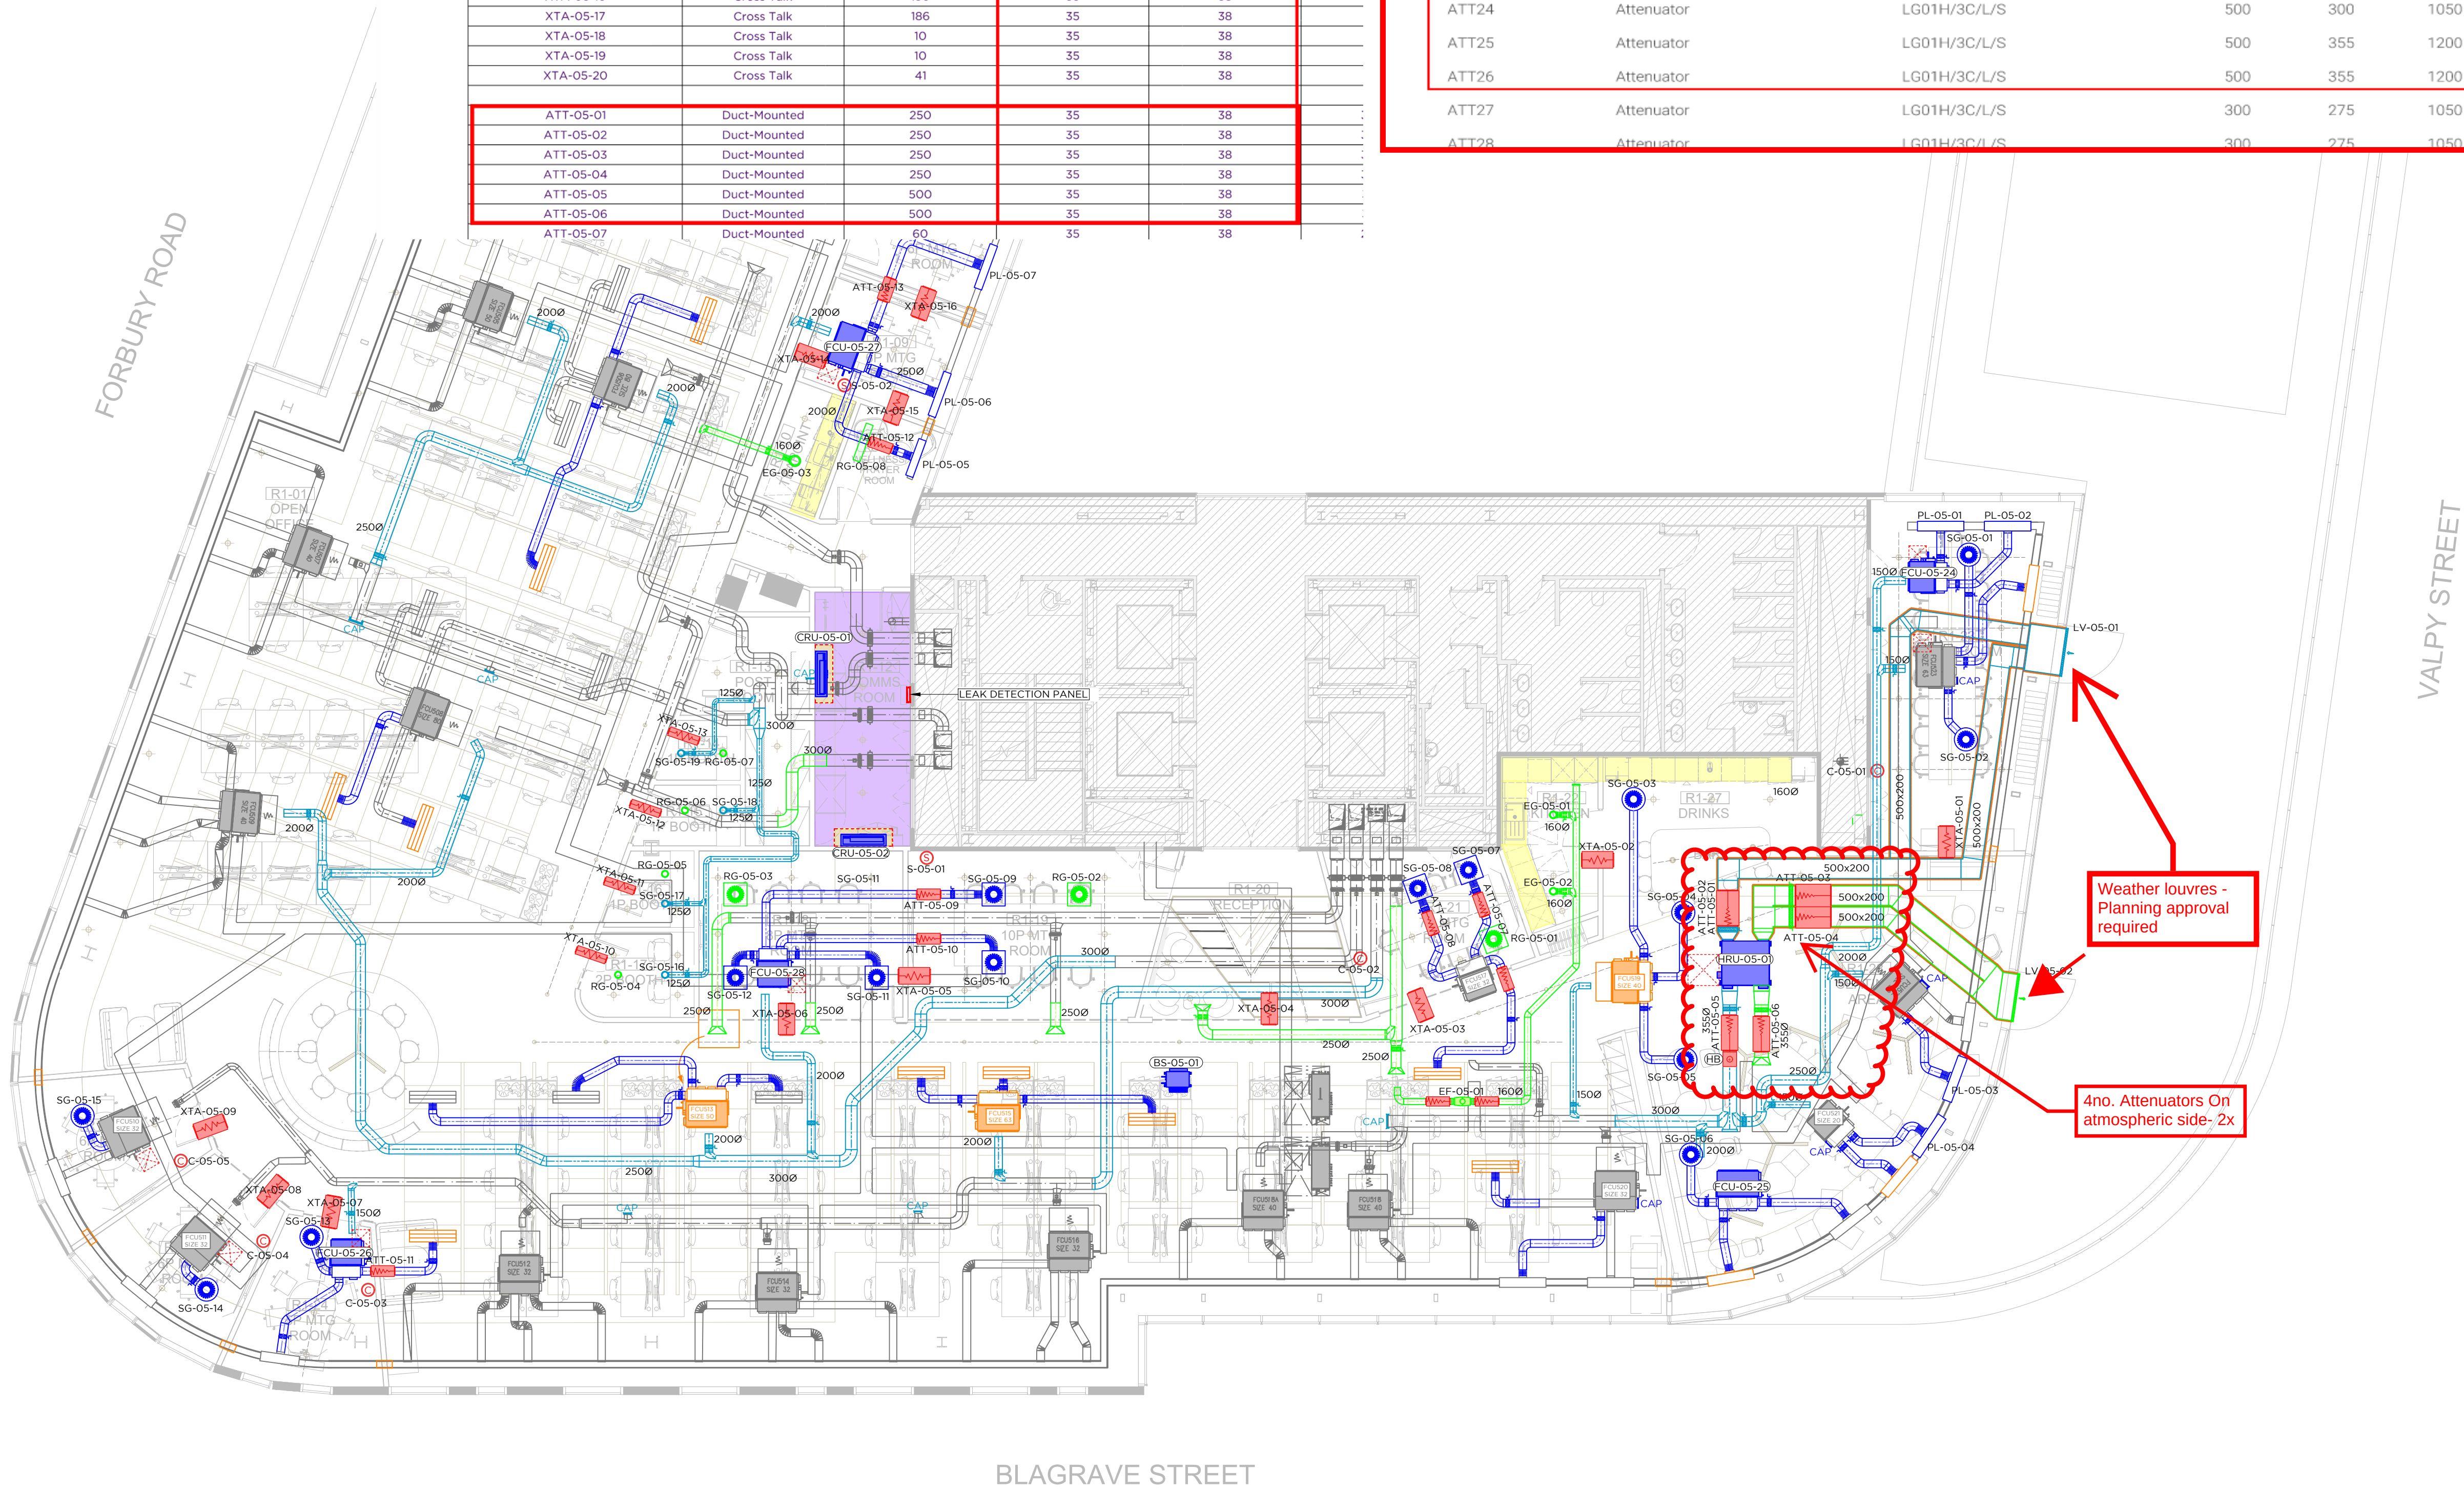

RD | Record Drawing | CA | KS | 22-05-24
Rev | Description | Dwn | Chk | Date



Conditioned Environment
245 Acton Lane, Park Royal
London NW10 7NR
T 020 8453 1010
F 020 8965 8469
E enquiries@c-env.co.uk
www.c-env.co.uk

Client

OKTRA

Project

R+
2 Blagrove Street
Reading - RG1 1AZ

Drawing Title
5th Floor Mechanical
Services Layout

Drawing Status

RECORD DRAWING

Designed By
LA

Drawn By
LA

Checked By
KS

1st Issue Date
22-05-2024

Scale @ A1
1:100

Project
S70620

Serv
M

Floor
05

Ref
MEC

Sheet
01

Rev
RD