


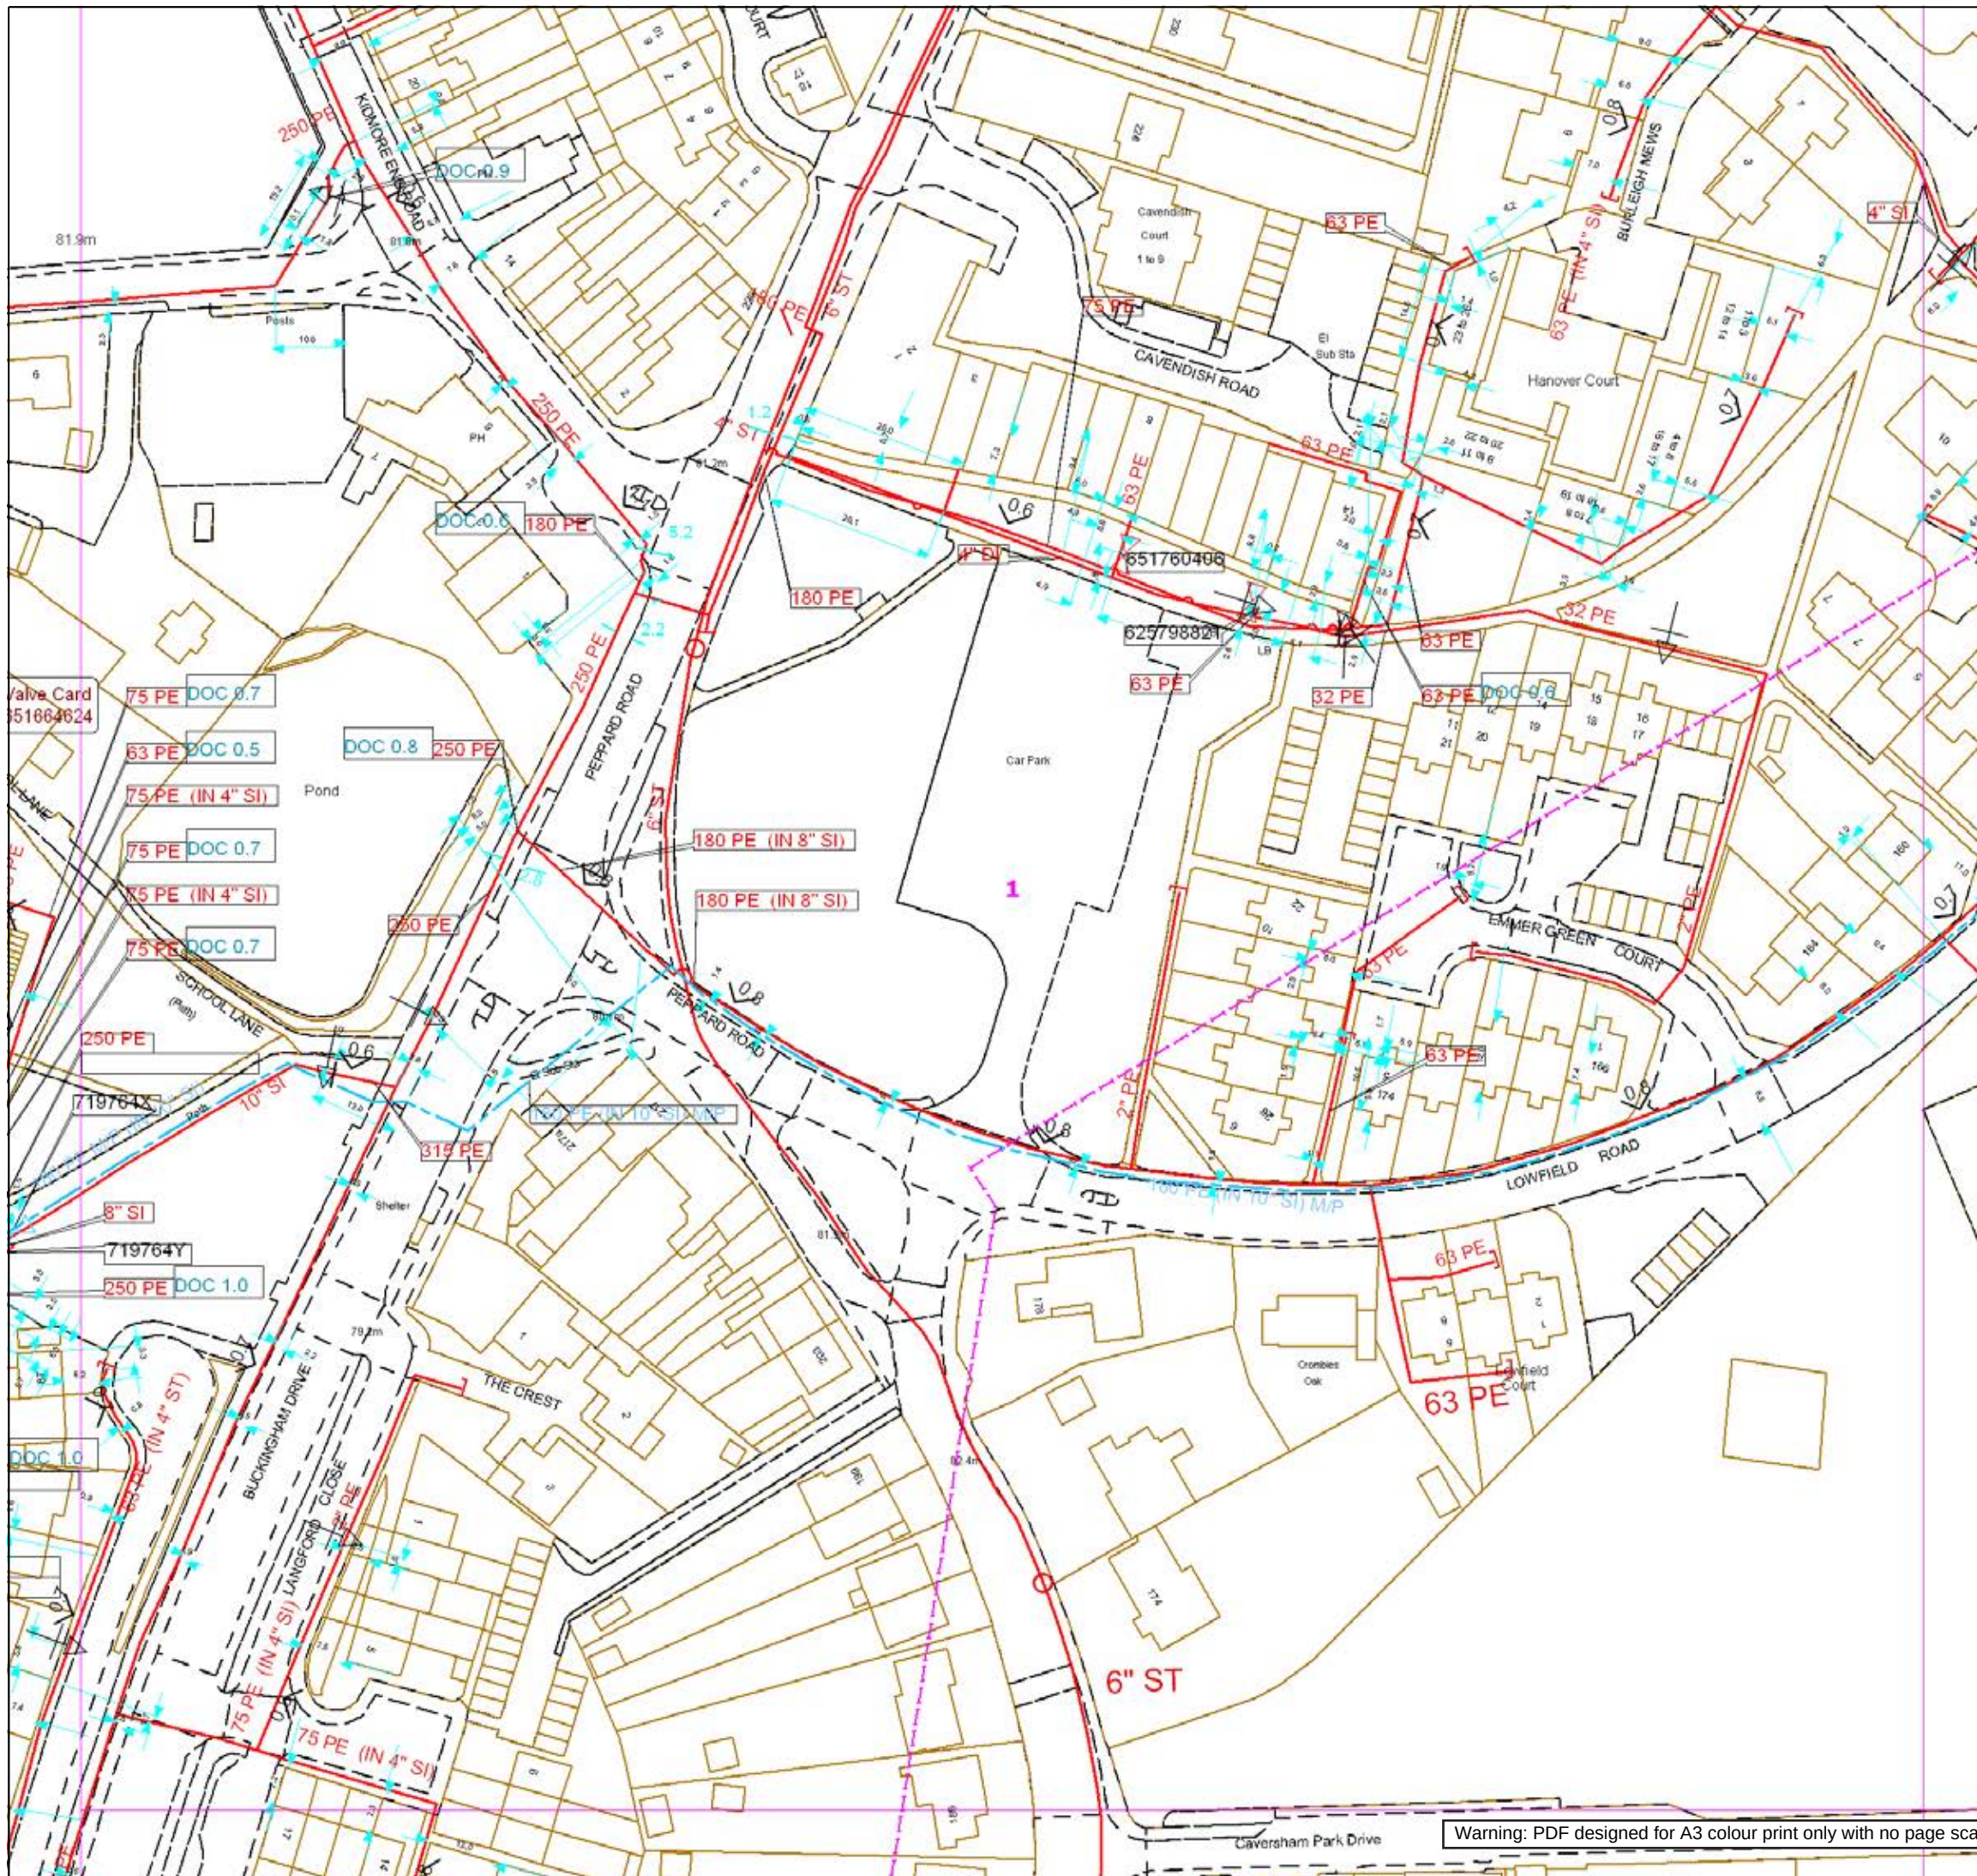

Contact Us

Mapping Enquiries:
All areas

General Enquiries:
All areas

Date Requested: 09/11/2021
Job Reference: 23827726
Site Location: 472560 176174
Requested by:
Ms Debbie Wigston
Your Scheme/Reference:
8210940
Exact Scales:
1:1000 Area or Circle dig site
1:1000 Line dig site

This plan shows the location of those pipes owned by Scotia Gas Networks (SGN) by virtue of being a licensed Gas Transporter (GT). Gas pipes owned by other GTs or third parties may also be present in this area but are not shown on this plan. Information with regard to such pipes should be obtained from the relevant owners. No warranties are given with regard to the accuracy of the information shown on this plan. Service pipes, valves, siphons, sub-connections etc. are not shown but their presence should be anticipated. You should be aware that a small percentage of our pipes/assets may be undergoing review and will temporarily be highlighted in yellow. If your proposed works are close to one of these pipes, you should contact the SGN Safety Admin Team on 0800 912 1722 for advice. No liability of any kind whatsoever is accepted by SGN or its agents, servants or sub-contractors for any error or omission contained herein. Safe digging practices, in accordance with HS (G)47, must be used to verify and establish the actual position of mains, pipes, services and other apparatus on site before any mechanical plant is used. It is your responsibility to ensure that plant location information is provided to all persons (whether direct labour or sub-contractors) working for you on or near gas apparatus. Information included on this plan should not be referred to beyond a period of 28 days from the date of issue.

Report damage immediately – KEEP EVERYONE AWAY FROM THE AREA
0800 111 999

Low Pressure Mains


Medium Pressure Mains

Intermediate Pressure Mains


High Pressure Mains

LAs

GTs

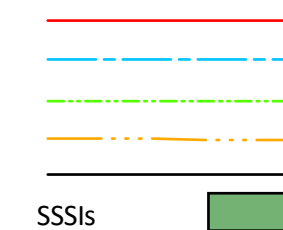


Some Examples Of Plant Items

 

Digsite: Line: Area:



This plan is reproduced from or based on the OS map by Scotia Gas Networks plc, with the sanction of the controller of HM Stationery Office. Crown Copyright Reserved. Southern Gas – 100044373 and Scotland Gas – 100044366.

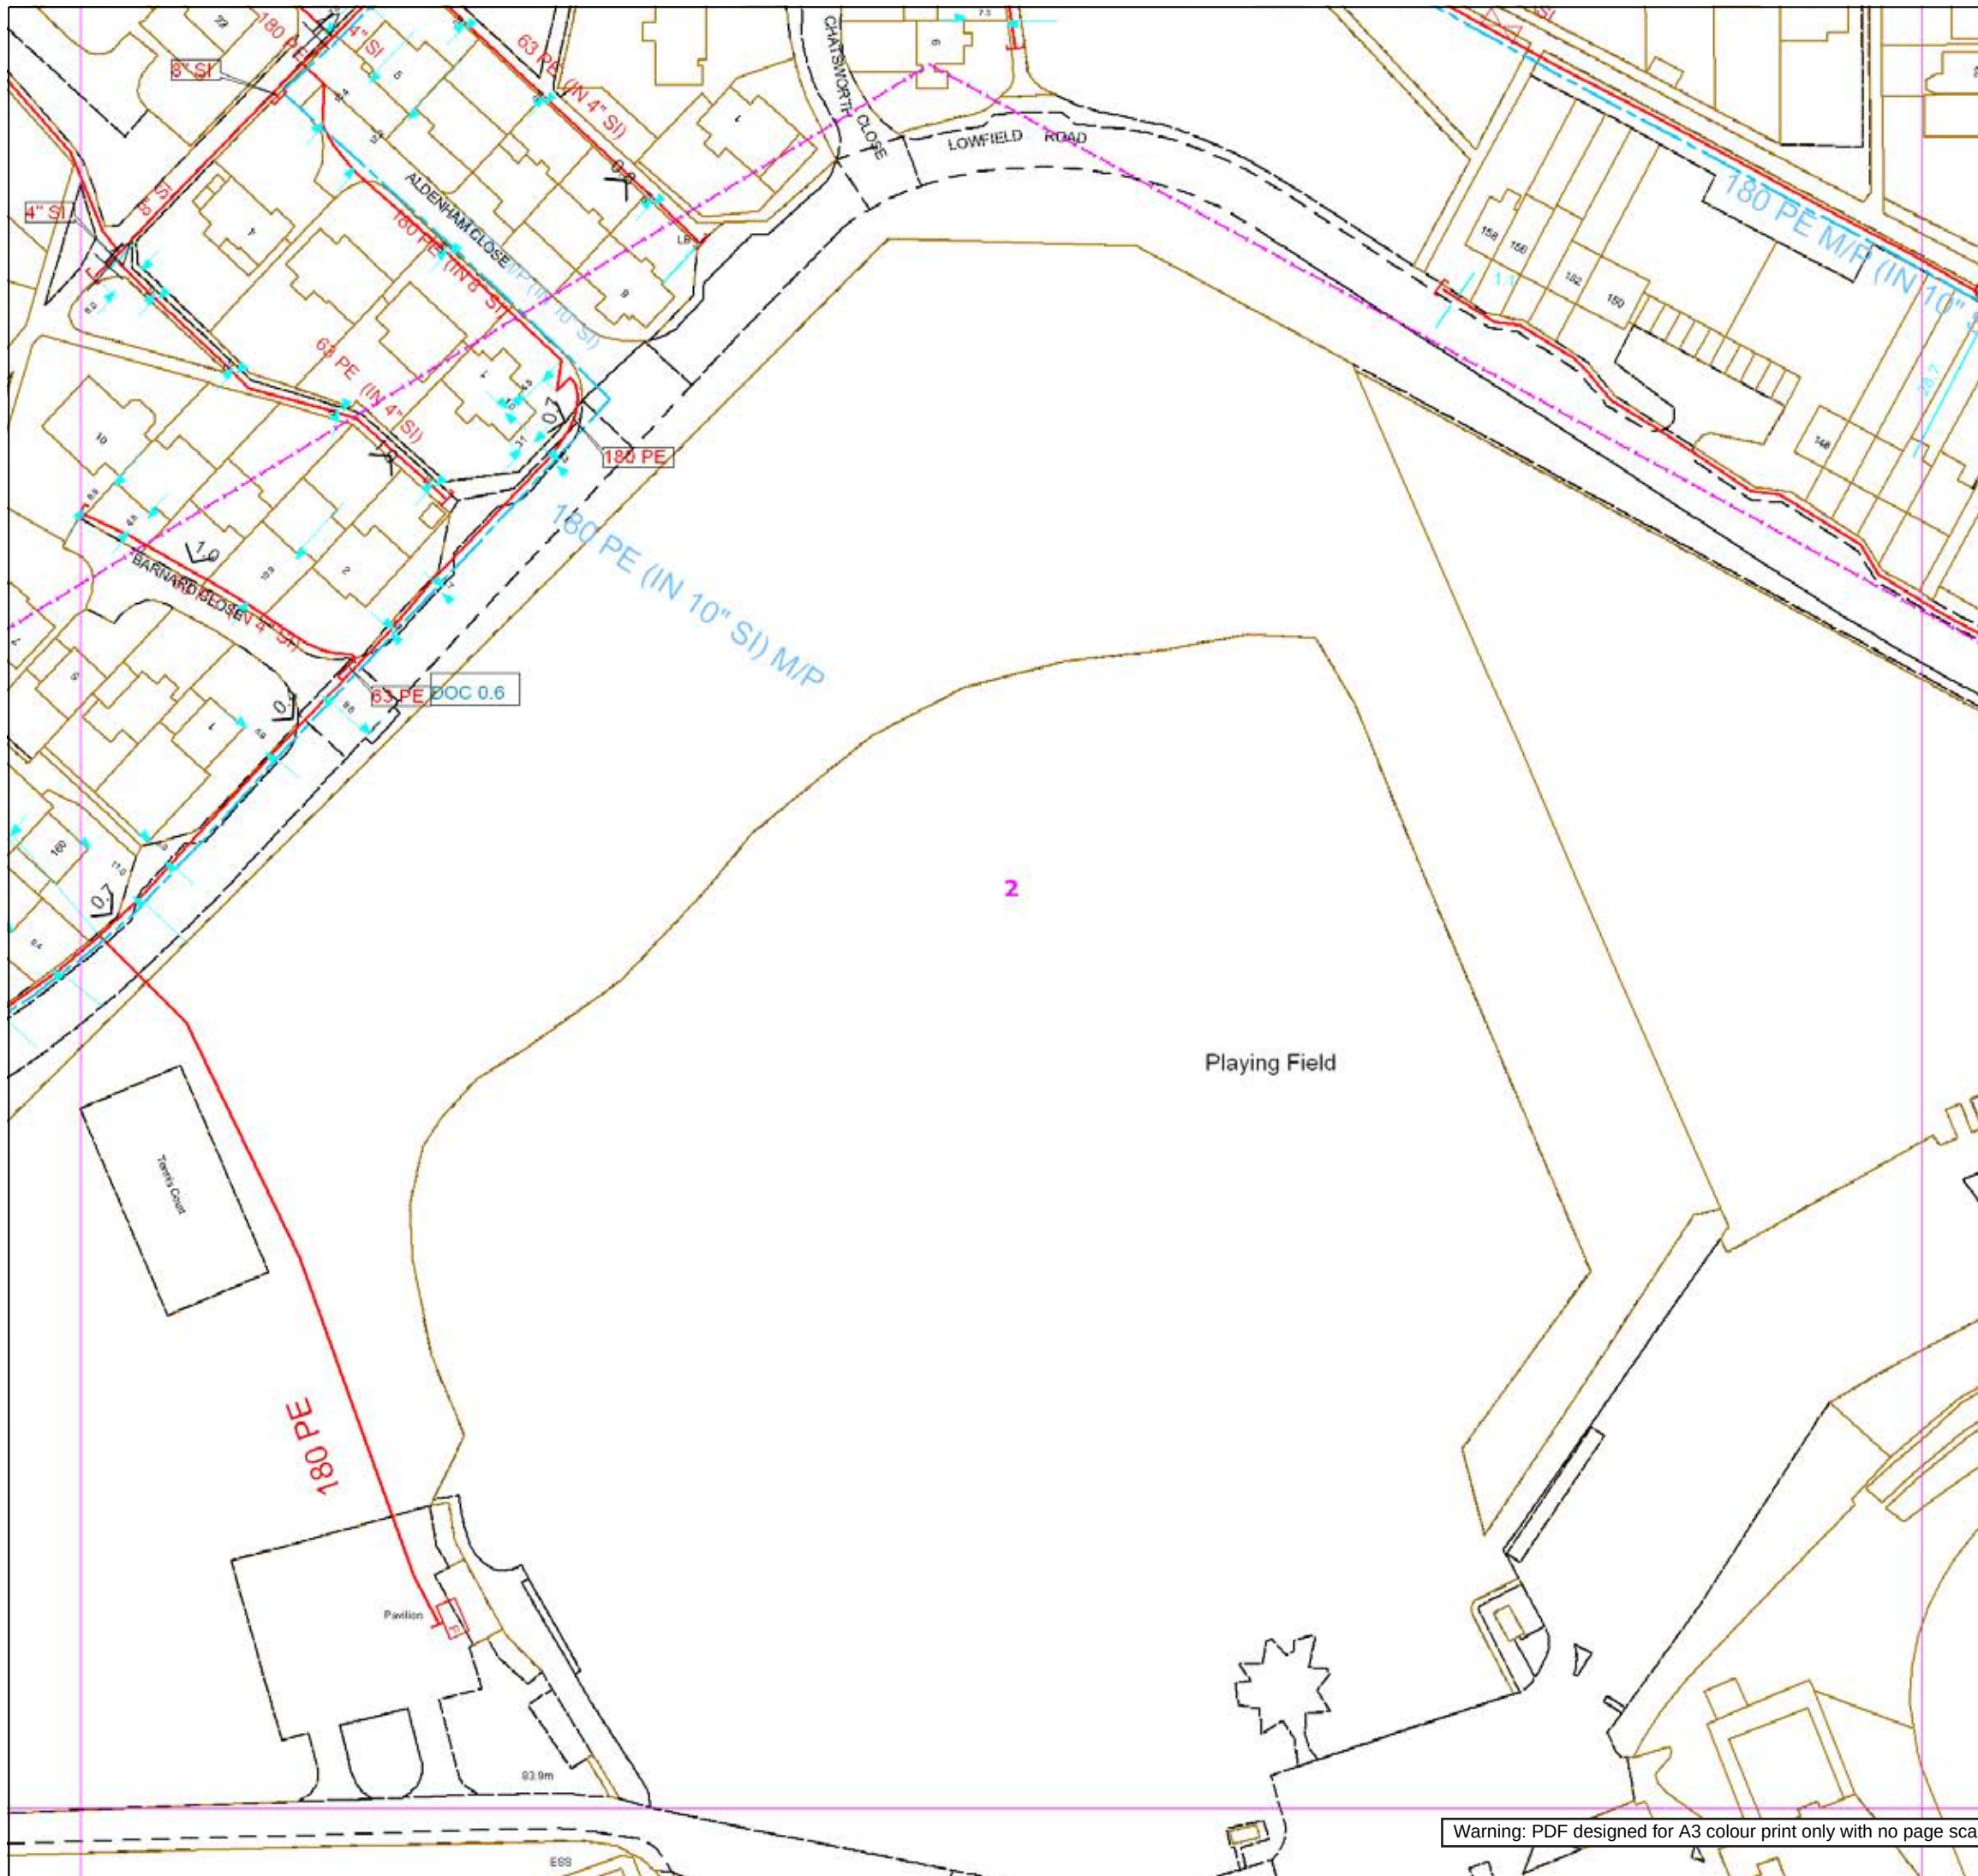

Contact Us

Mapping Enquiries:
All areas

General Enquiries:
All areas

Date Requested: 09/11/2021
Job Reference: 23827726
Site Location: 472560 176174
Requested by:
Ms Debbie Wigston
Your Scheme/Reference:
8210940
Exact Scales:
1:1000 Area or Circle dig site
1:1000 Line dig site

This plan shows the location of those pipes owned by Scotia Gas Networks (SGN) by virtue of being a licensed Gas Transporter (GT). Gas pipes owned by other GTs or third parties may also be present in this area but are not shown on this plan. Information with regard to such pipes should be obtained from the relevant owners. No warranties are given with regard to the accuracy of the information shown on this plan. Service pipes, valves, siphons, sub-connections etc. are not shown but their presence should be anticipated. You should be aware that a small percentage of our pipes/assets may be undergoing review and will temporarily be highlighted in yellow. If your proposed works are close to one of these pipes, you should contact the SGN Safety Admin Team on 0800 912 1722 for advice. No liability of any kind whatsoever is accepted by SGN or its agents, servants or sub-contractors for any error or omission contained herein. Safe digging practices, in accordance with HS (G)47, must be used to verify and establish the actual position of mains, pipes, services and other apparatus on site before any mechanical plant is used. It is your responsibility to ensure that plant location information is provided to all persons (whether direct labour or sub-contractors) working for you on or near gas apparatus. Information included on this plan should not be referred to beyond a period of 28 days from the date of issue.

Report damage immediately – KEEP EVERYONE AWAY FROM THE AREA
0800 111 999

Low Pressure Mains

 
Medium Pressure Mains

Intermediate Pressure Mains

High Pressure Mains

LAs

GTs



SSSIs



Some Examples Of Plant Items


Valve Syphon Depth of Cover Diameter Change Material Change

Digsite: Line: Area:



This plan is reproduced from or based on the OS map by Scotia Gas Networks plc, with the sanction of the controller of HM Stationary Office. Crown Copyright Reserved. Southern Gas – 100044373 and Scotland Gas – 100044366.

Warning: PDF designed for A3 colour print only with no page scaling.

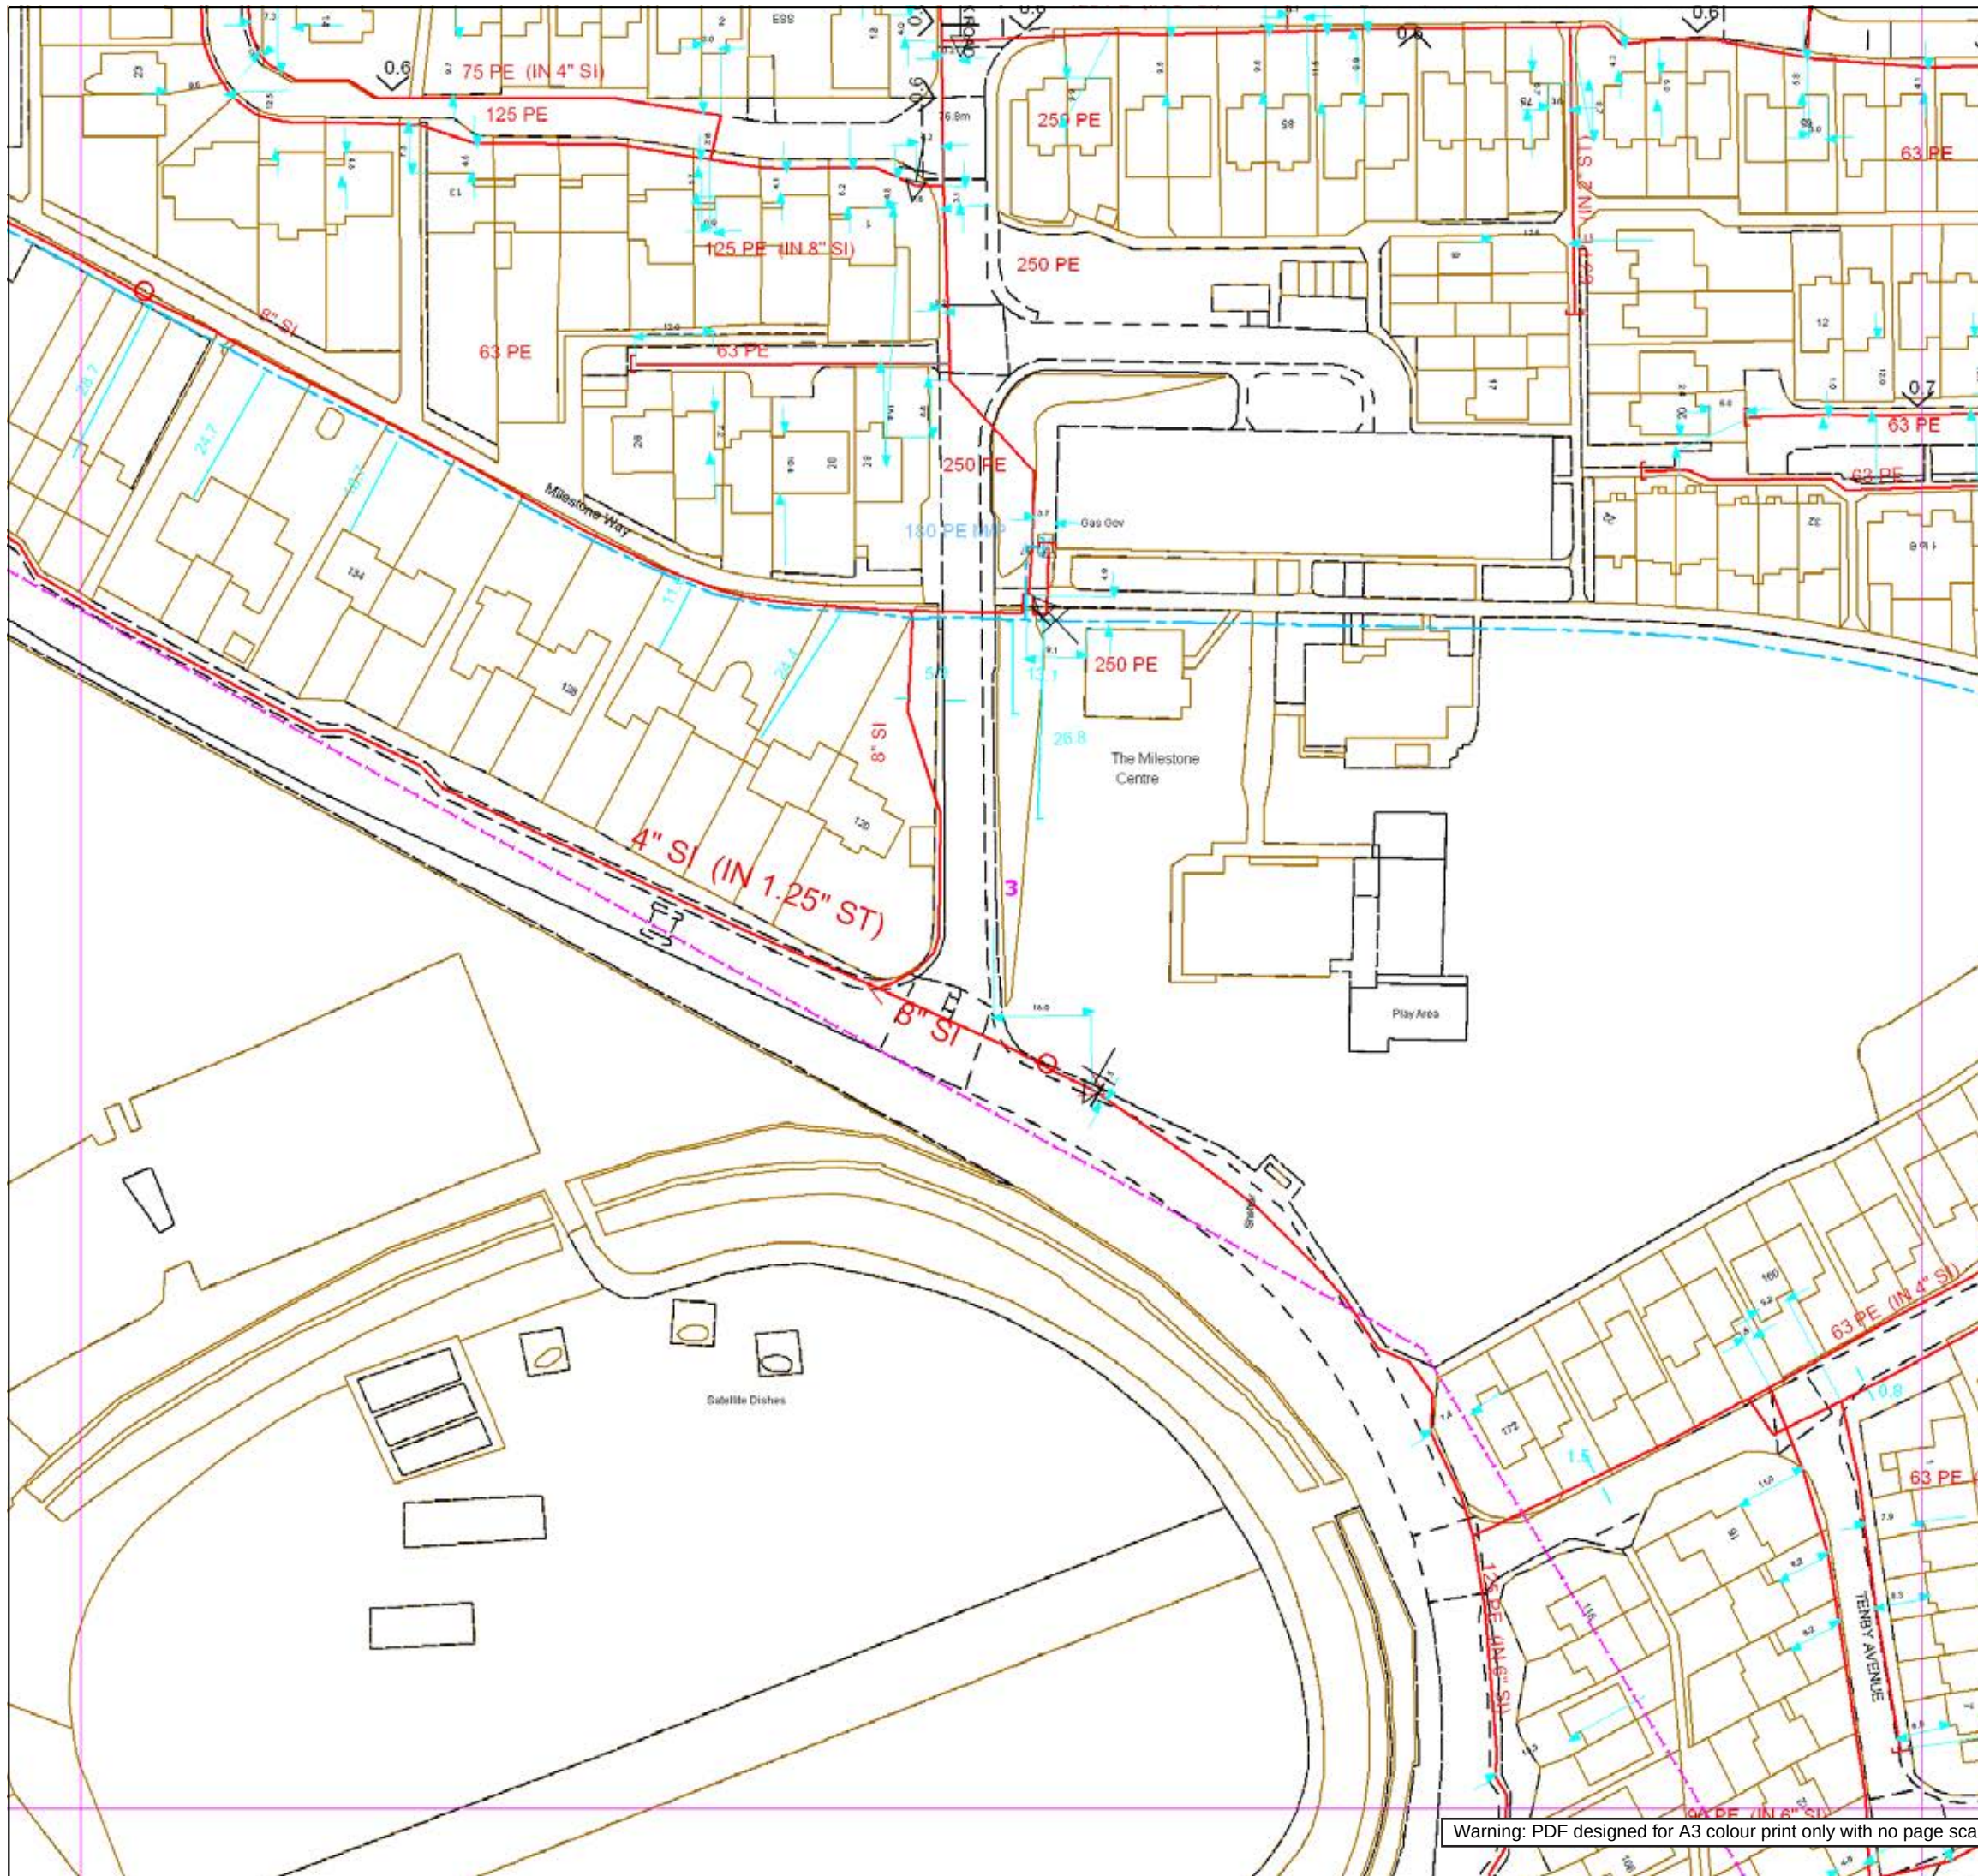

SGN
Your gas. Our network.

Contact Us

Mapping Enquiries:
All areas

General Enquiries:
All areas

Date Requested: 09/11/2021
Job Reference: 23827726
Site Location: 472560 176174
Requested by:
Ms Debbie Wigston
Your Scheme/Reference:
8210940
Exact Scales:
1:1000 Area or Circle dig site
1:1000 Line dig site

This plan shows the location of those pipes owned by Scotia Gas Networks (SGN) by virtue of being a licensed Gas Transporter (GT). Gas pipes owned by other GTs or third parties may also be present in this area but are not shown on this plan. Information with regard to such pipes should be obtained from the relevant owners. No warranties are given with regard to the accuracy of the information shown on this plan. Service pipes, valves, siphons, sub-connections etc. are not shown but their presence should be anticipated. You should be aware that a small percentage of our pipes/assets may be undergoing review and will temporarily be highlighted in yellow. If your proposed works are close to one of these pipes, you should contact the SGN Safety Admin Team on 0800 912 1722 for advice. No liability of any kind whatsoever is accepted by SGN or its agents, servants or sub-contractors for any error or omission contained herein. Safe digging practices, in accordance with HS (G)47, must be used to verify and establish the actual position of mains, pipes, services and other apparatus on site before any mechanical plant is used. It is your responsibility to ensure that plant location information is provided to all persons (whether direct labour or sub-contractors) working for you on or near gas apparatus. Information included on this plan should not be referred to beyond a period of 28 days from the date of issue.

Report damage immediately – KEEP EVERYONE AWAY FROM THE AREA
0800 111 999

Low Pressure Mains

Medium Pressure Mains

Intermediate Pressure Mains

High Pressure Mains

LAs

GTs

SSSIs

Some Examples Of Plant Items


Valve  Syphon  Depth of Cover  Diameter Change  Material Change 

Digsite: Line:  Area: 



This plan is reproduced from or based on the OS map by Scotia Gas Networks plc, with the sanction of the controller of HM Stationery Office. Crown Copyright Reserved. Southern Gas – 100044373 and Scotland Gas – 100044366.

Warning: PDF designed for A3 colour print only with no page scaling.

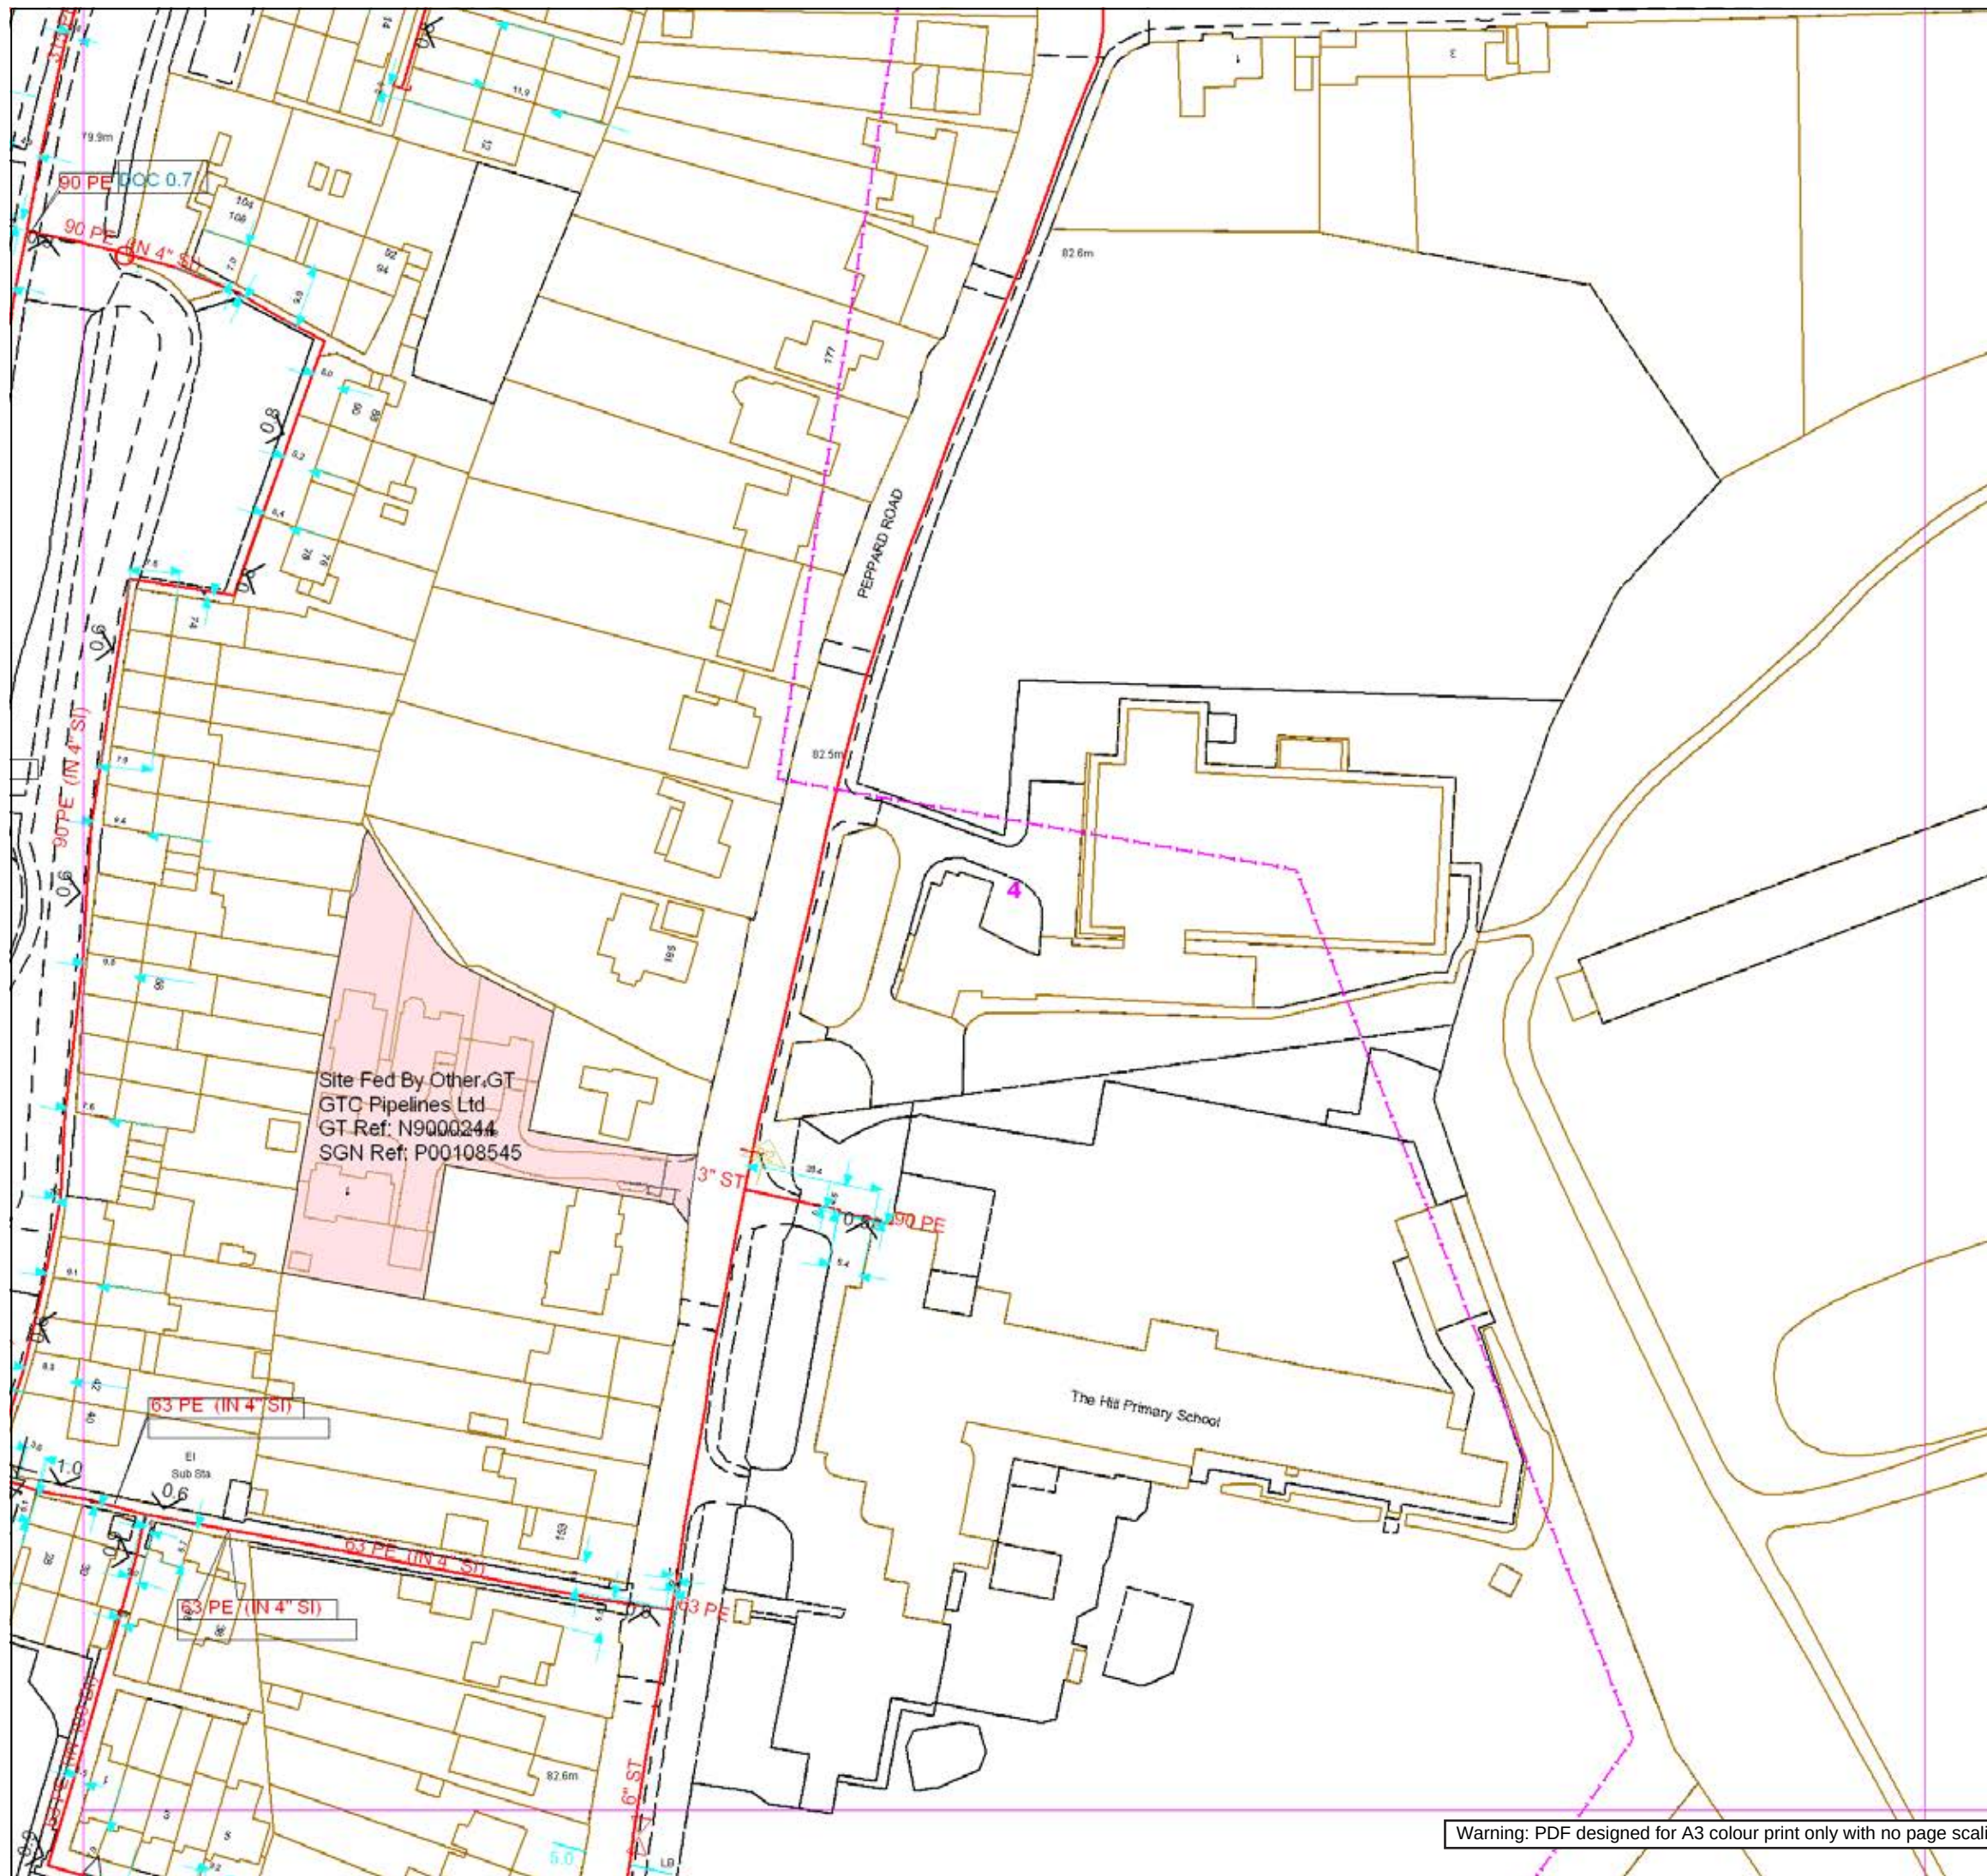



Contact Us
Mapping Enquiries:
All areas

General Enquiries:
All areas

Date Requested: 09/11/2021
Job Reference: 23827726
Site Location: 472560 176174
Requested by:
Ms Debbie Wigston
Your Scheme/Reference:
8210940
Exact Scales:
1:1000 Area or Circle dig site
1:1000 Line dig site

This plan shows the location of those pipes owned by Scotia Gas Networks (SGN) by virtue of being a licensed Gas Transporter (GT). Gas pipes owned by other GTs or third parties may also be present in this area but are not shown on this plan. Information with regard to such pipes should be obtained from the relevant owners. No warranties are given with regard to the accuracy of the information shown on this plan. Service pipes, valves, siphons, sub-connections etc. are not shown but their presence should be anticipated. You should be aware that a small percentage of our pipes/assets may be undergoing review and will temporarily be highlighted in yellow. If your proposed works are close to one of these pipes, you should contact the SGN Safety Admin Team on 0800 912 1722 for advice. No liability of any kind whatsoever is accepted by SGN or its agents, servants or sub-contractors for any error or omission contained herein. Safe digging practices, in accordance with HS (G)47, must be used to verify and establish the actual position of mains, pipes, services and other apparatus on site before any mechanical plant is used. It is your responsibility to ensure that plant location information is provided to all persons (whether direct labour or sub-contractors) working for you on or near gas apparatus. Information included on this plan should not be referred to beyond a period of 28 days from the date of issue.

Report damage immediately – KEEP EVERYONE AWAY FROM THE AREA
0800 111 999

Low Pressure Mains

Medium Pressure Mains

Intermediate Pressure Mains

High Pressure Mains

LAs

GTs

SSSIs

Some Examples Of Plant Items

Valve

Syphon

Depth of Cover

Diameter Change

Material Change


Digsite:

Line:

Area:



This plan is reproduced from or based on the OS map by Scotia Gas Networks plc, with the sanction of the controller of HM Stationery Office. Crown Copyright Reserved. Southern Gas – 100044373 and Scotland Gas – 100044366.

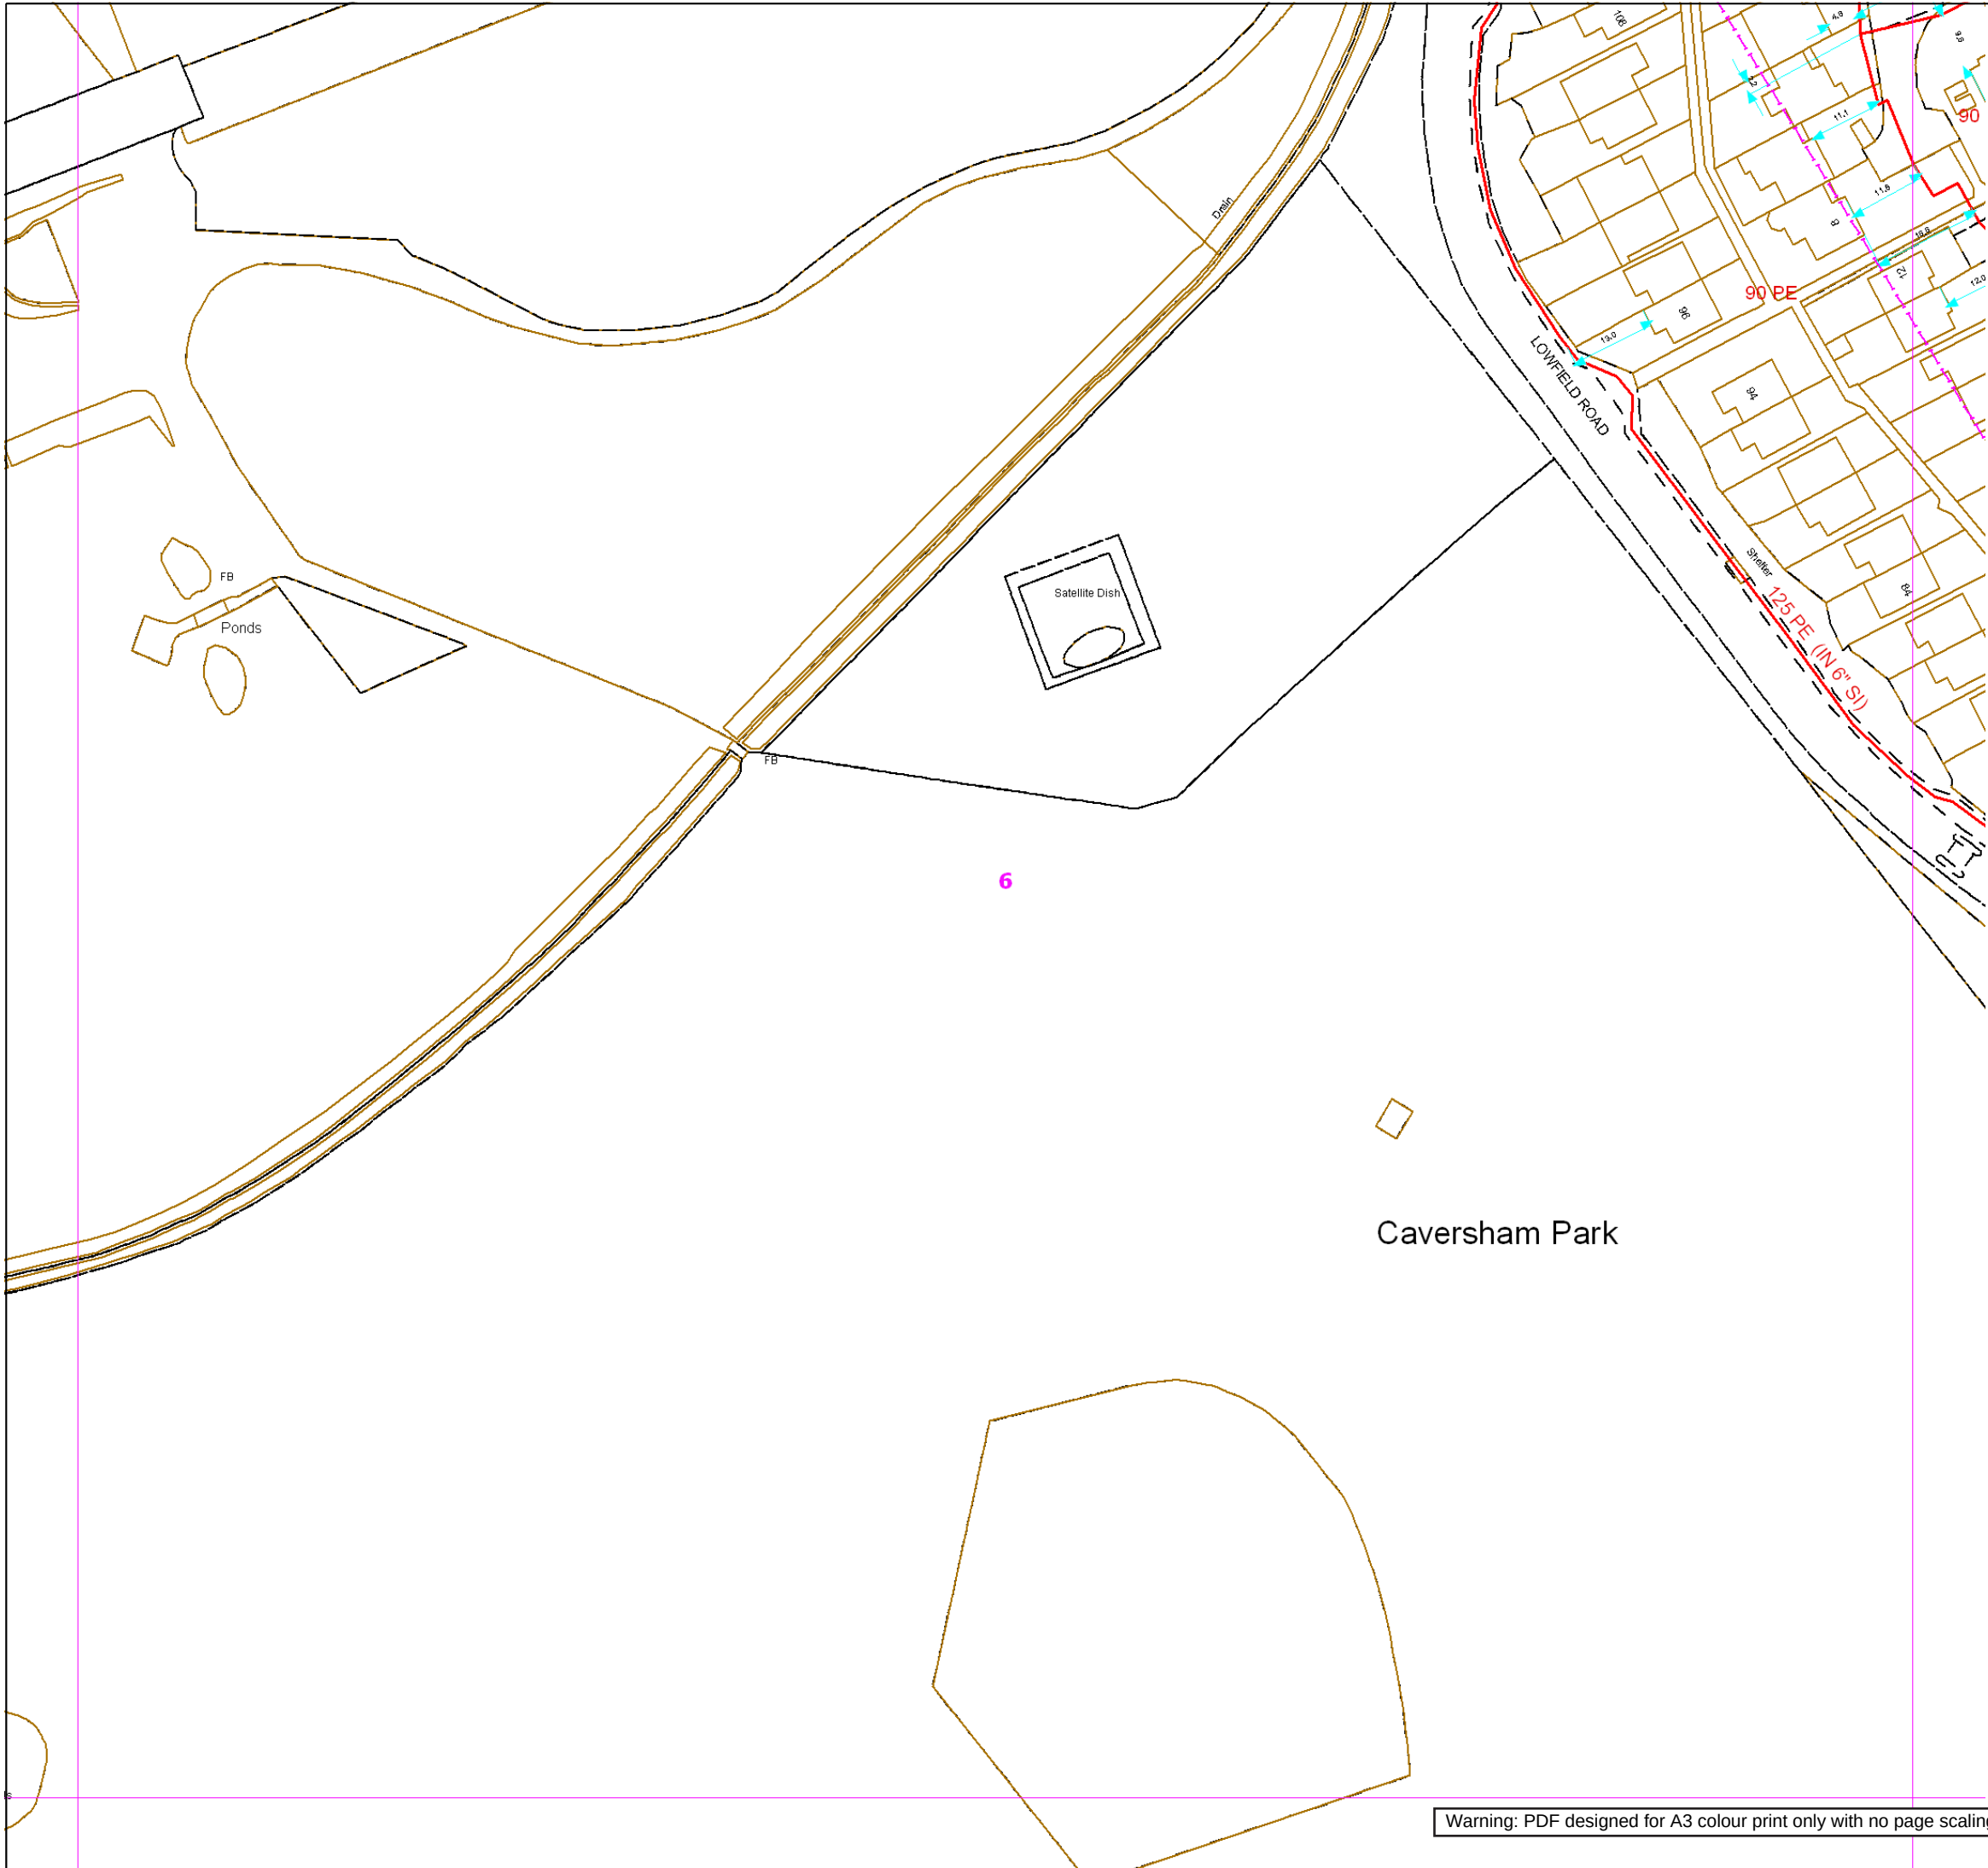

Contact Us

Mapping Enquiries:
All areas

General Enquiries:
All areas

Date Requested: 09/11/2021
Job Reference: 23827726
Site Location: 472560 176174
Requested by:
Ms Debbie Wigston
Your Scheme/Reference:
8210940
Exact Scales:
1:1000 Area or Circle dig site
1:1000 Line dig site

This plan shows the location of those pipes owned by Scotia Gas Networks (SGN) by virtue of being a licensed Gas Transporter (GT). Gas pipes owned by other GTs or third parties may also be present in this area but are not shown on this plan. Information with regard to such pipes should be obtained from the relevant owners. No warranties are given with regard to the accuracy of the information shown on this plan. Service pipes, valves, siphons, sub-connections etc. are not shown but their presence should be anticipated. You should be aware that a small percentage of our pipes/assets may be undergoing review and will temporarily be highlighted in yellow. If your proposed works are close to one of these pipes, you should contact the SGN Safety Admin Team on 0800 912 1722 for advice. No liability of any kind whatsoever is accepted by SGN or its agents, servants or sub-contractors for any error or omission contained herein. Safe digging practices, in accordance with HS (G)47, must be used to verify and establish the actual position of mains, pipes, services and other apparatus on site before any mechanical plant is used. It is your responsibility to ensure that plant location information is provided to all persons (whether direct labour or sub-contractors) working for you on or near gas apparatus. Information included on this plan should not be referred to beyond a period of 28 days from the date of issue.

Report damage immediately – KEEP EVERYONE AWAY FROM THE AREA
0800 111 999

Low Pressure Mains	
Medium Pressure Mains	
Intermediate Pressure Mains	
High Pressure Mains	
LAs	
GTs	
SSSIs	


Some Examples Of Plant Items

Valve		Syphon		Depth of Cover		Diameter Change		Material Change	
-------	--	--------	--	----------------	--	-----------------	--	-----------------	--

Digsite: Line: Area:



This plan is reproduced from or based on the OS map by Scotia Gas Networks plc, with the sanction of the controller of HM Stationery Office. Crown Copyright Reserved. Southern Gas – 100044373 and Scotland Gas – 100044366.

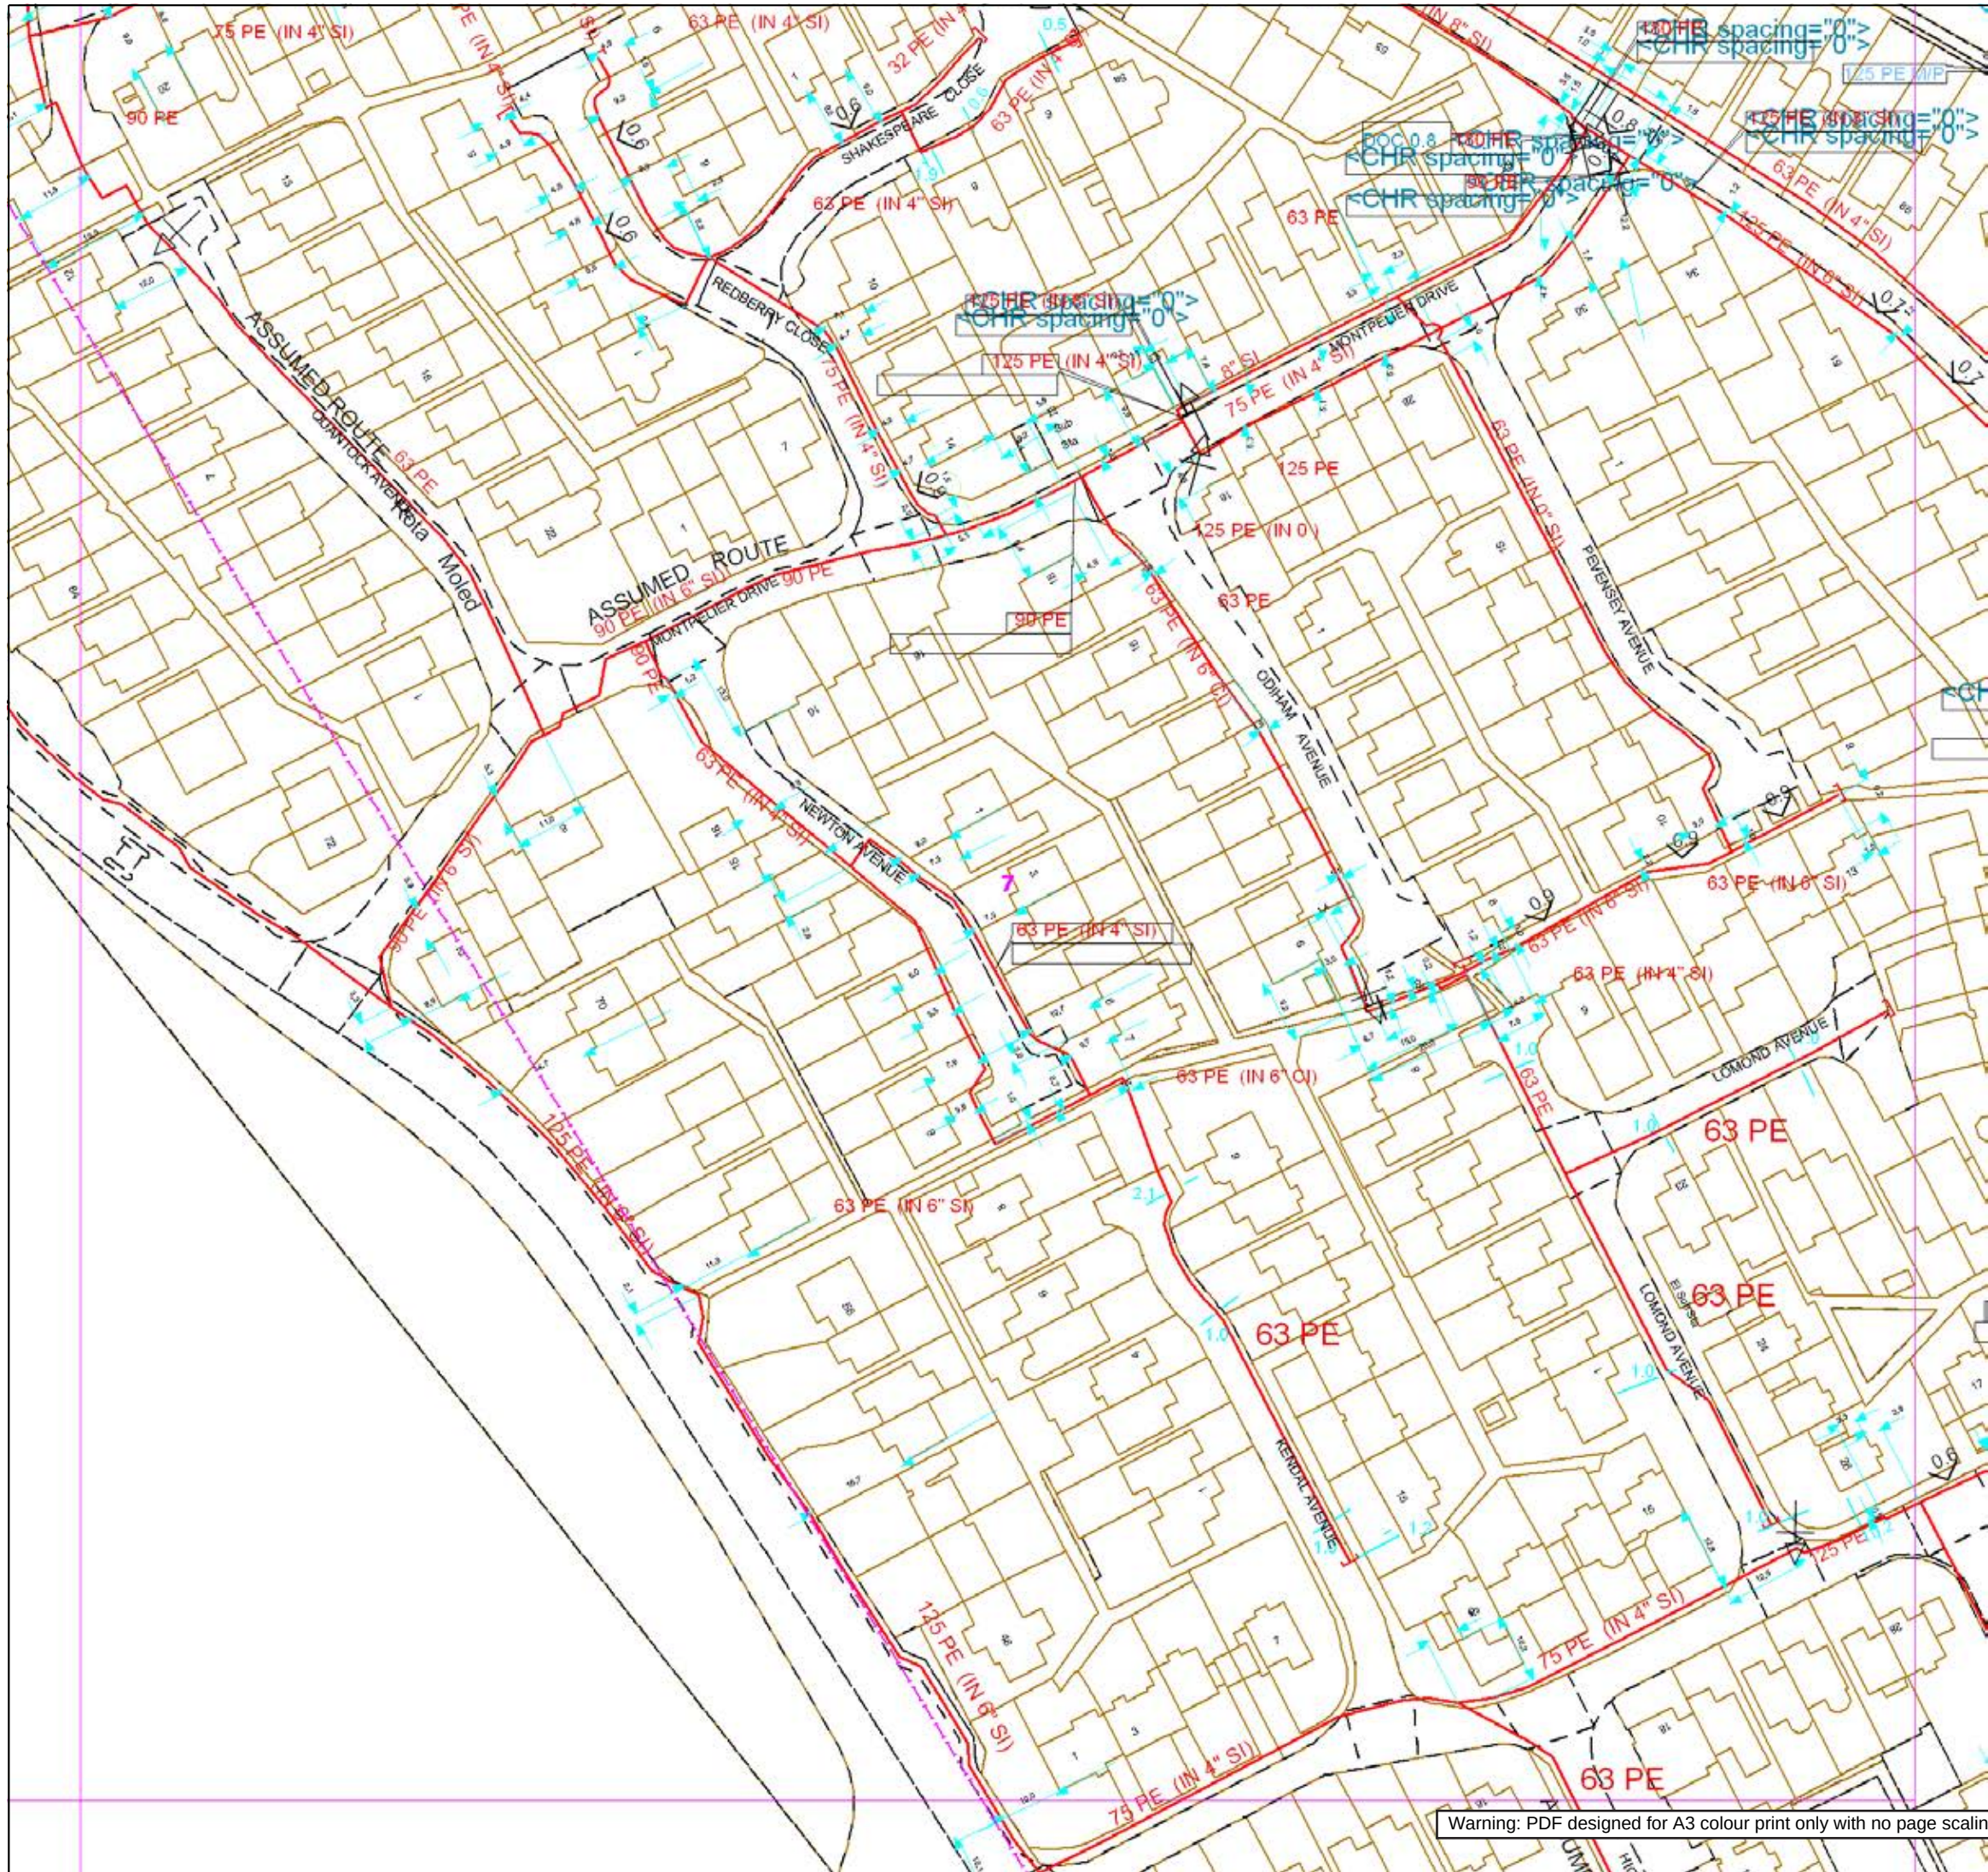

Contact Us
Mapping Enquiries: All areas
General Enquiries: All areas

Date Requested: 09/11/2021
Job Reference: 23827726
Site Location: 472560 176174
Requested by:
Ms Debbie Wigston
Your Scheme/Reference:
8210940
Exact Scales:
1:1000 Area or Circle dig site
1:1000 Line dig site

This plan shows the location of those pipes owned by Scotia Gas Networks (SGN) by virtue of being a licensed Gas Transporter (GT). Gas pipes owned by other GTs or third parties may also be present in this area but are not shown on this plan. Information with regard to such pipes should be obtained from the relevant owners. No warranties are given with regard to the accuracy of the information shown on this plan. Service pipes, valves, siphons, sub-connections etc. are not shown but their presence should be anticipated. You should be aware that a small percentage of our pipes/assets may be undergoing review and will temporarily be highlighted in yellow. If your proposed works are close to one of these pipes, you should contact the SGN Safety Admin Team on 0800 912 1722 for advice. No liability of any kind whatsoever is accepted by SGN or its agents, servants or sub-contractors for any error or omission contained herein. Safe digging practices, in accordance with HS (G)47, must be used to verify and establish the actual position of mains, pipes, services and other apparatus on site before any mechanical plant is used. It is your responsibility to ensure that plant location information is provided to all persons (whether direct labour or sub-contractors) working for you on or near gas apparatus. Information included on this plan should not be referred to beyond a period of 28 days from the date of issue.

Report damage immediately – KEEP EVERYONE AWAY FROM THE AREA
0800 111 999


Low Pressure Mains
Medium Pressure Mains
Intermediate Pressure Mains
High Pressure Mains
LAS
GTs
SSSIs

Some Examples Of Plant Items
Valve Siphon Depth of Cover Diameter Change Material Change

Digsite: Line: Area:



This plan is reproduced from or based on the OS map by Scotia Gas Networks plc, with the sanction of the controller of HM Stationery Office. Crown Copyright Reserved. Southern Gas – 100044373 and Scotland Gas – 100044366.

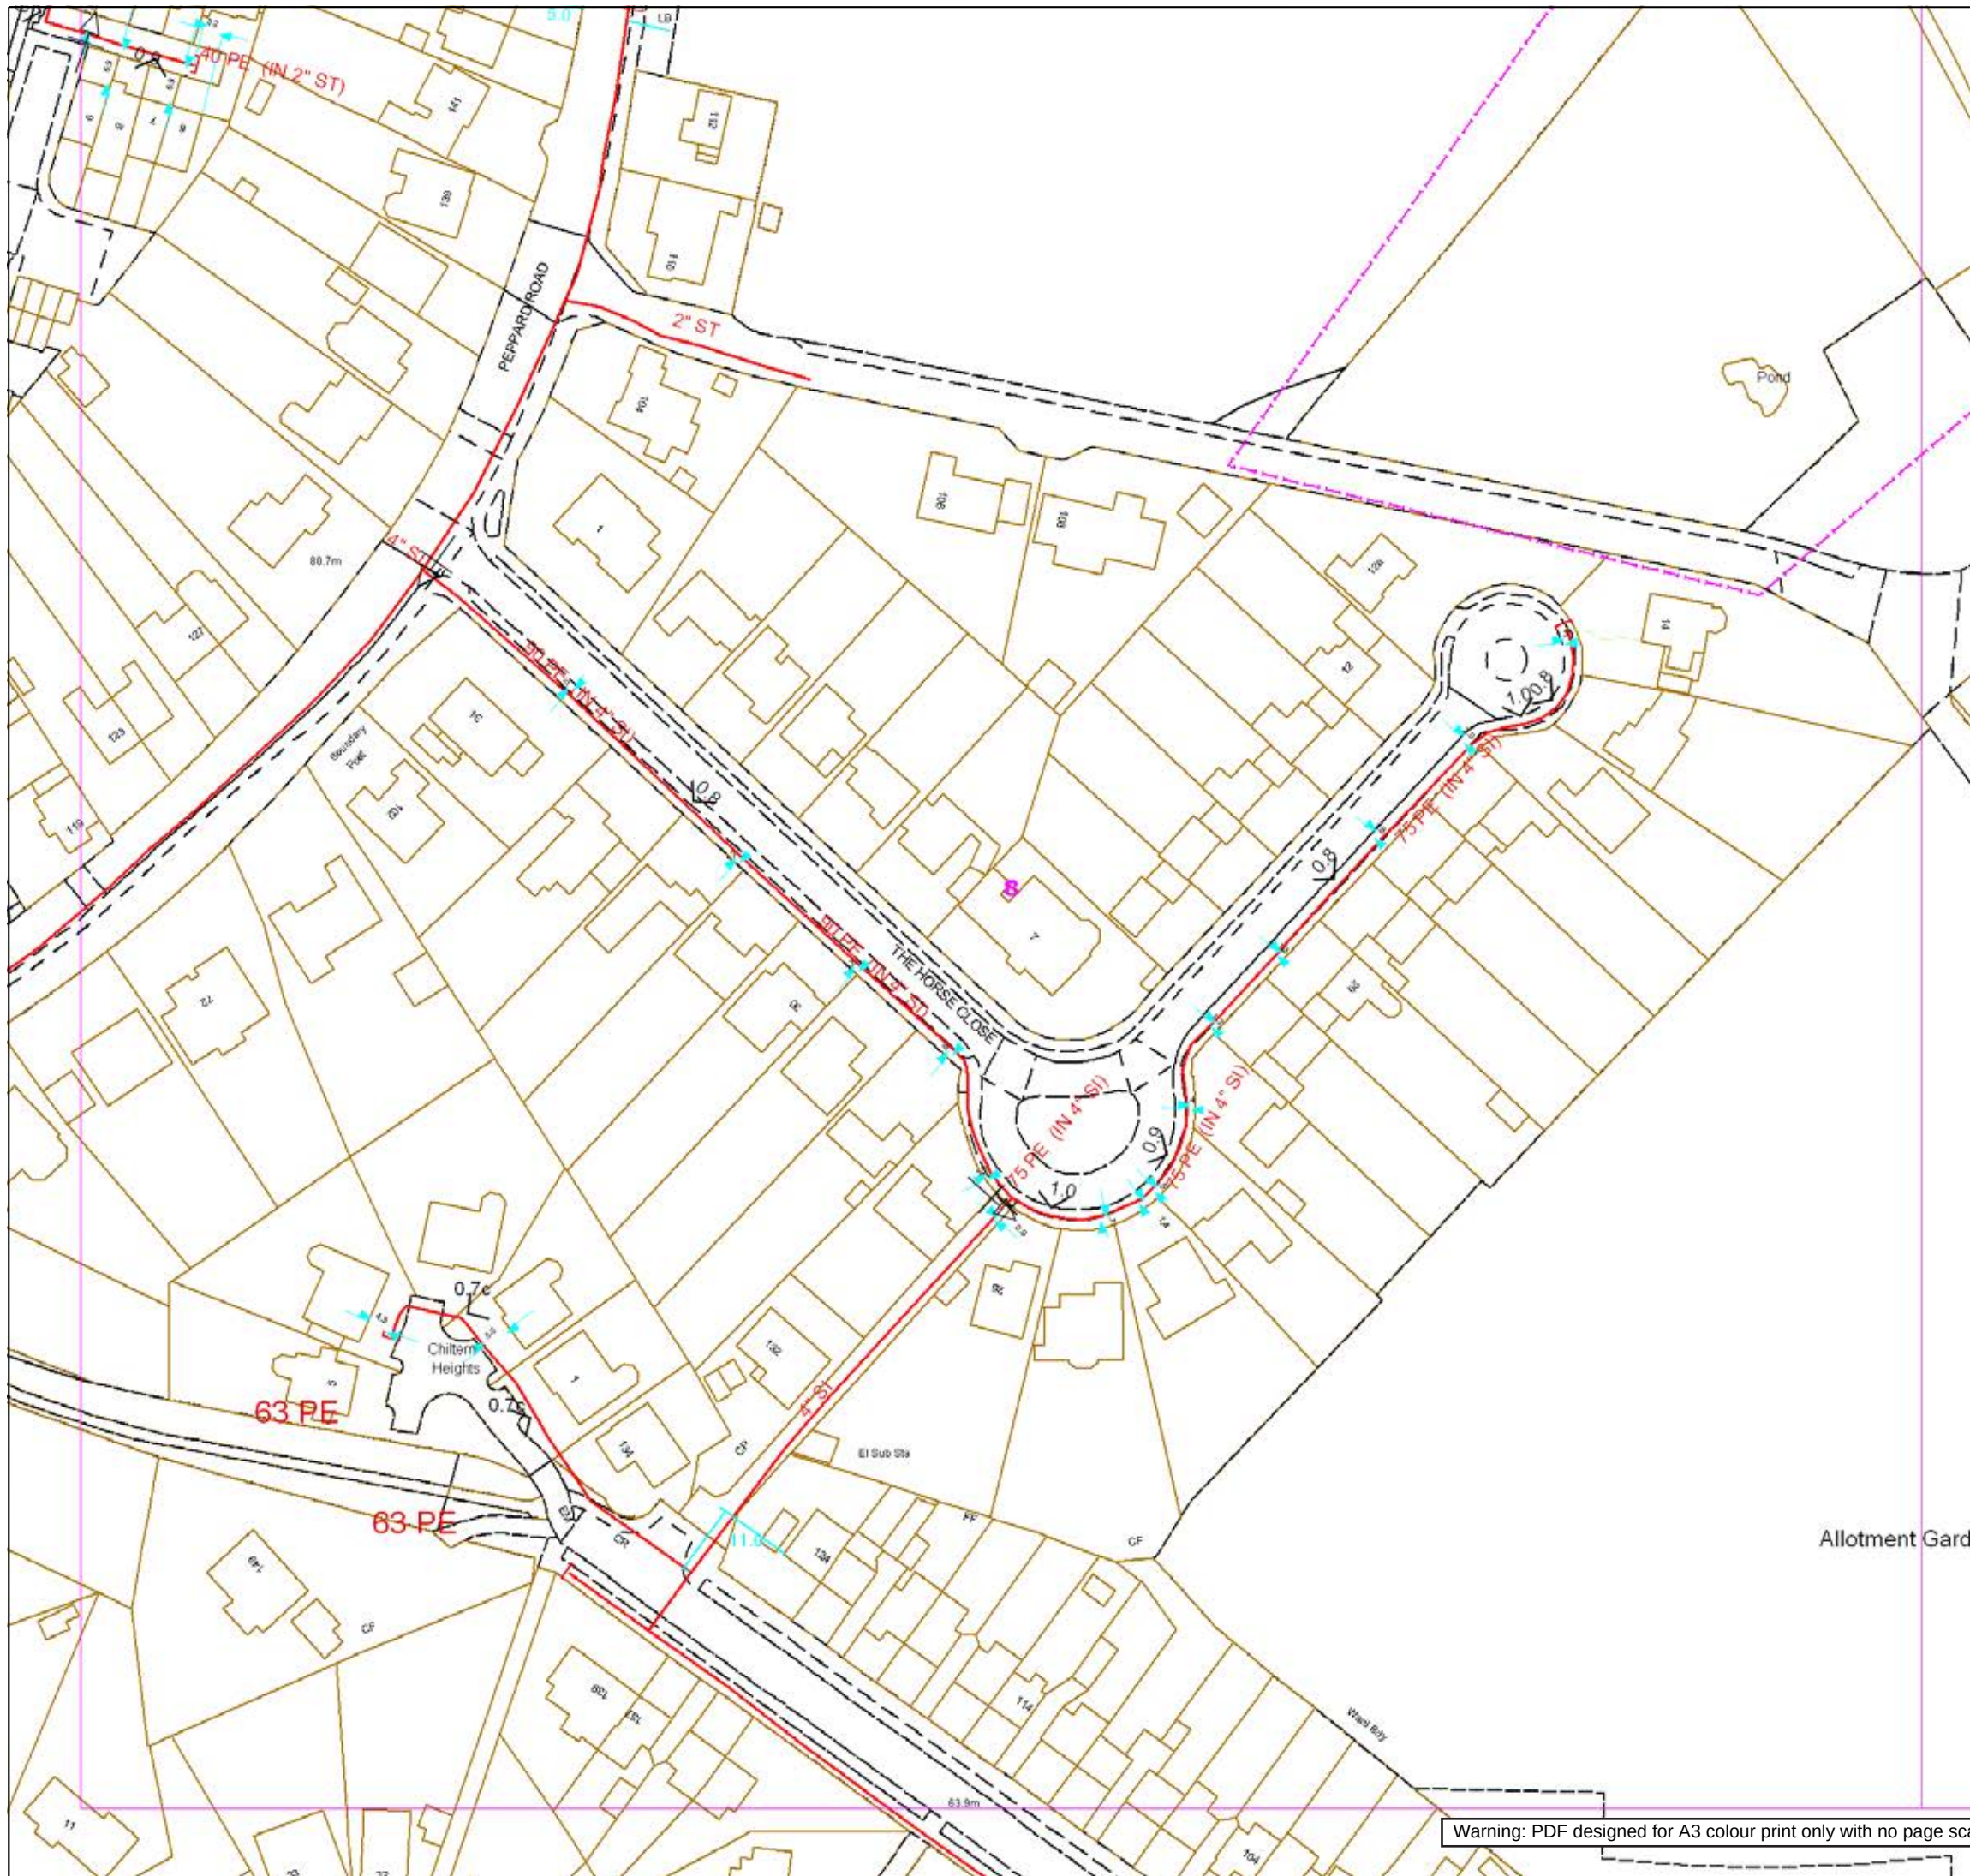

Contact Us

Mapping Enquiries:
All areas

General Enquiries:
All areas

Date Requested: 09/11/2021
Job Reference: 23827726
Site Location: 472560 176174
Requested by:
Ms Debbie Wigston
Your Scheme/Reference:
8210940
Exact Scales:
1:1000 Area or Circle dig site
1:1000 Line dig site

This plan shows the location of those pipes owned by Scotia Gas Networks (SGN) by virtue of being a licensed Gas Transporter (GT). Gas pipes owned by other GTs or third parties may also be present in this area but are not shown on this plan. Information with regard to such pipes should be obtained from the relevant owners. No warranties are given with regard to the accuracy of the information shown on this plan. Service pipes, valves, siphons, sub-connections etc. are not shown but their presence should be anticipated. You should be aware that a small percentage of our pipes/assets may be undergoing review and will temporarily be highlighted in yellow. If your proposed works are close to one of these pipes, you should contact the SGN Safety Admin Team on 0800 912 1722 for advice. No liability of any kind whatsoever is accepted by SGN or its agents, servants or sub-contractors for any error or omission contained herein. Safe digging practices, in accordance with HS (G)47, must be used to verify and establish the actual position of mains, pipes, services and other apparatus on site before any mechanical plant is used. It is your responsibility to ensure that plant location information is provided to all persons (whether direct labour or sub-contractors) working for you on or near gas apparatus. Information included on this plan should not be referred to beyond a period of 28 days from the date of issue.

Report damage immediately – KEEP EVERYONE AWAY FROM THE AREA
0800 111 999

Low Pressure Mains

Medium Pressure Mains

Intermediate Pressure Mains

High Pressure Mains

LAs

GTs



Some Examples Of Plant Items

Valve



Syphon



Depth of Cover



Diameter Change



Material Change



Digsite:

Line:




Area:



This plan is reproduced from or based on the OS map by Scotia Gas Networks plc, with the sanction of the controller of HM Stationery Office. Crown Copyright Reserved. Southern Gas – 100044373 and Scotland Gas – 100044366.

Warning: PDF designed for A3 colour print only with no page scaling.

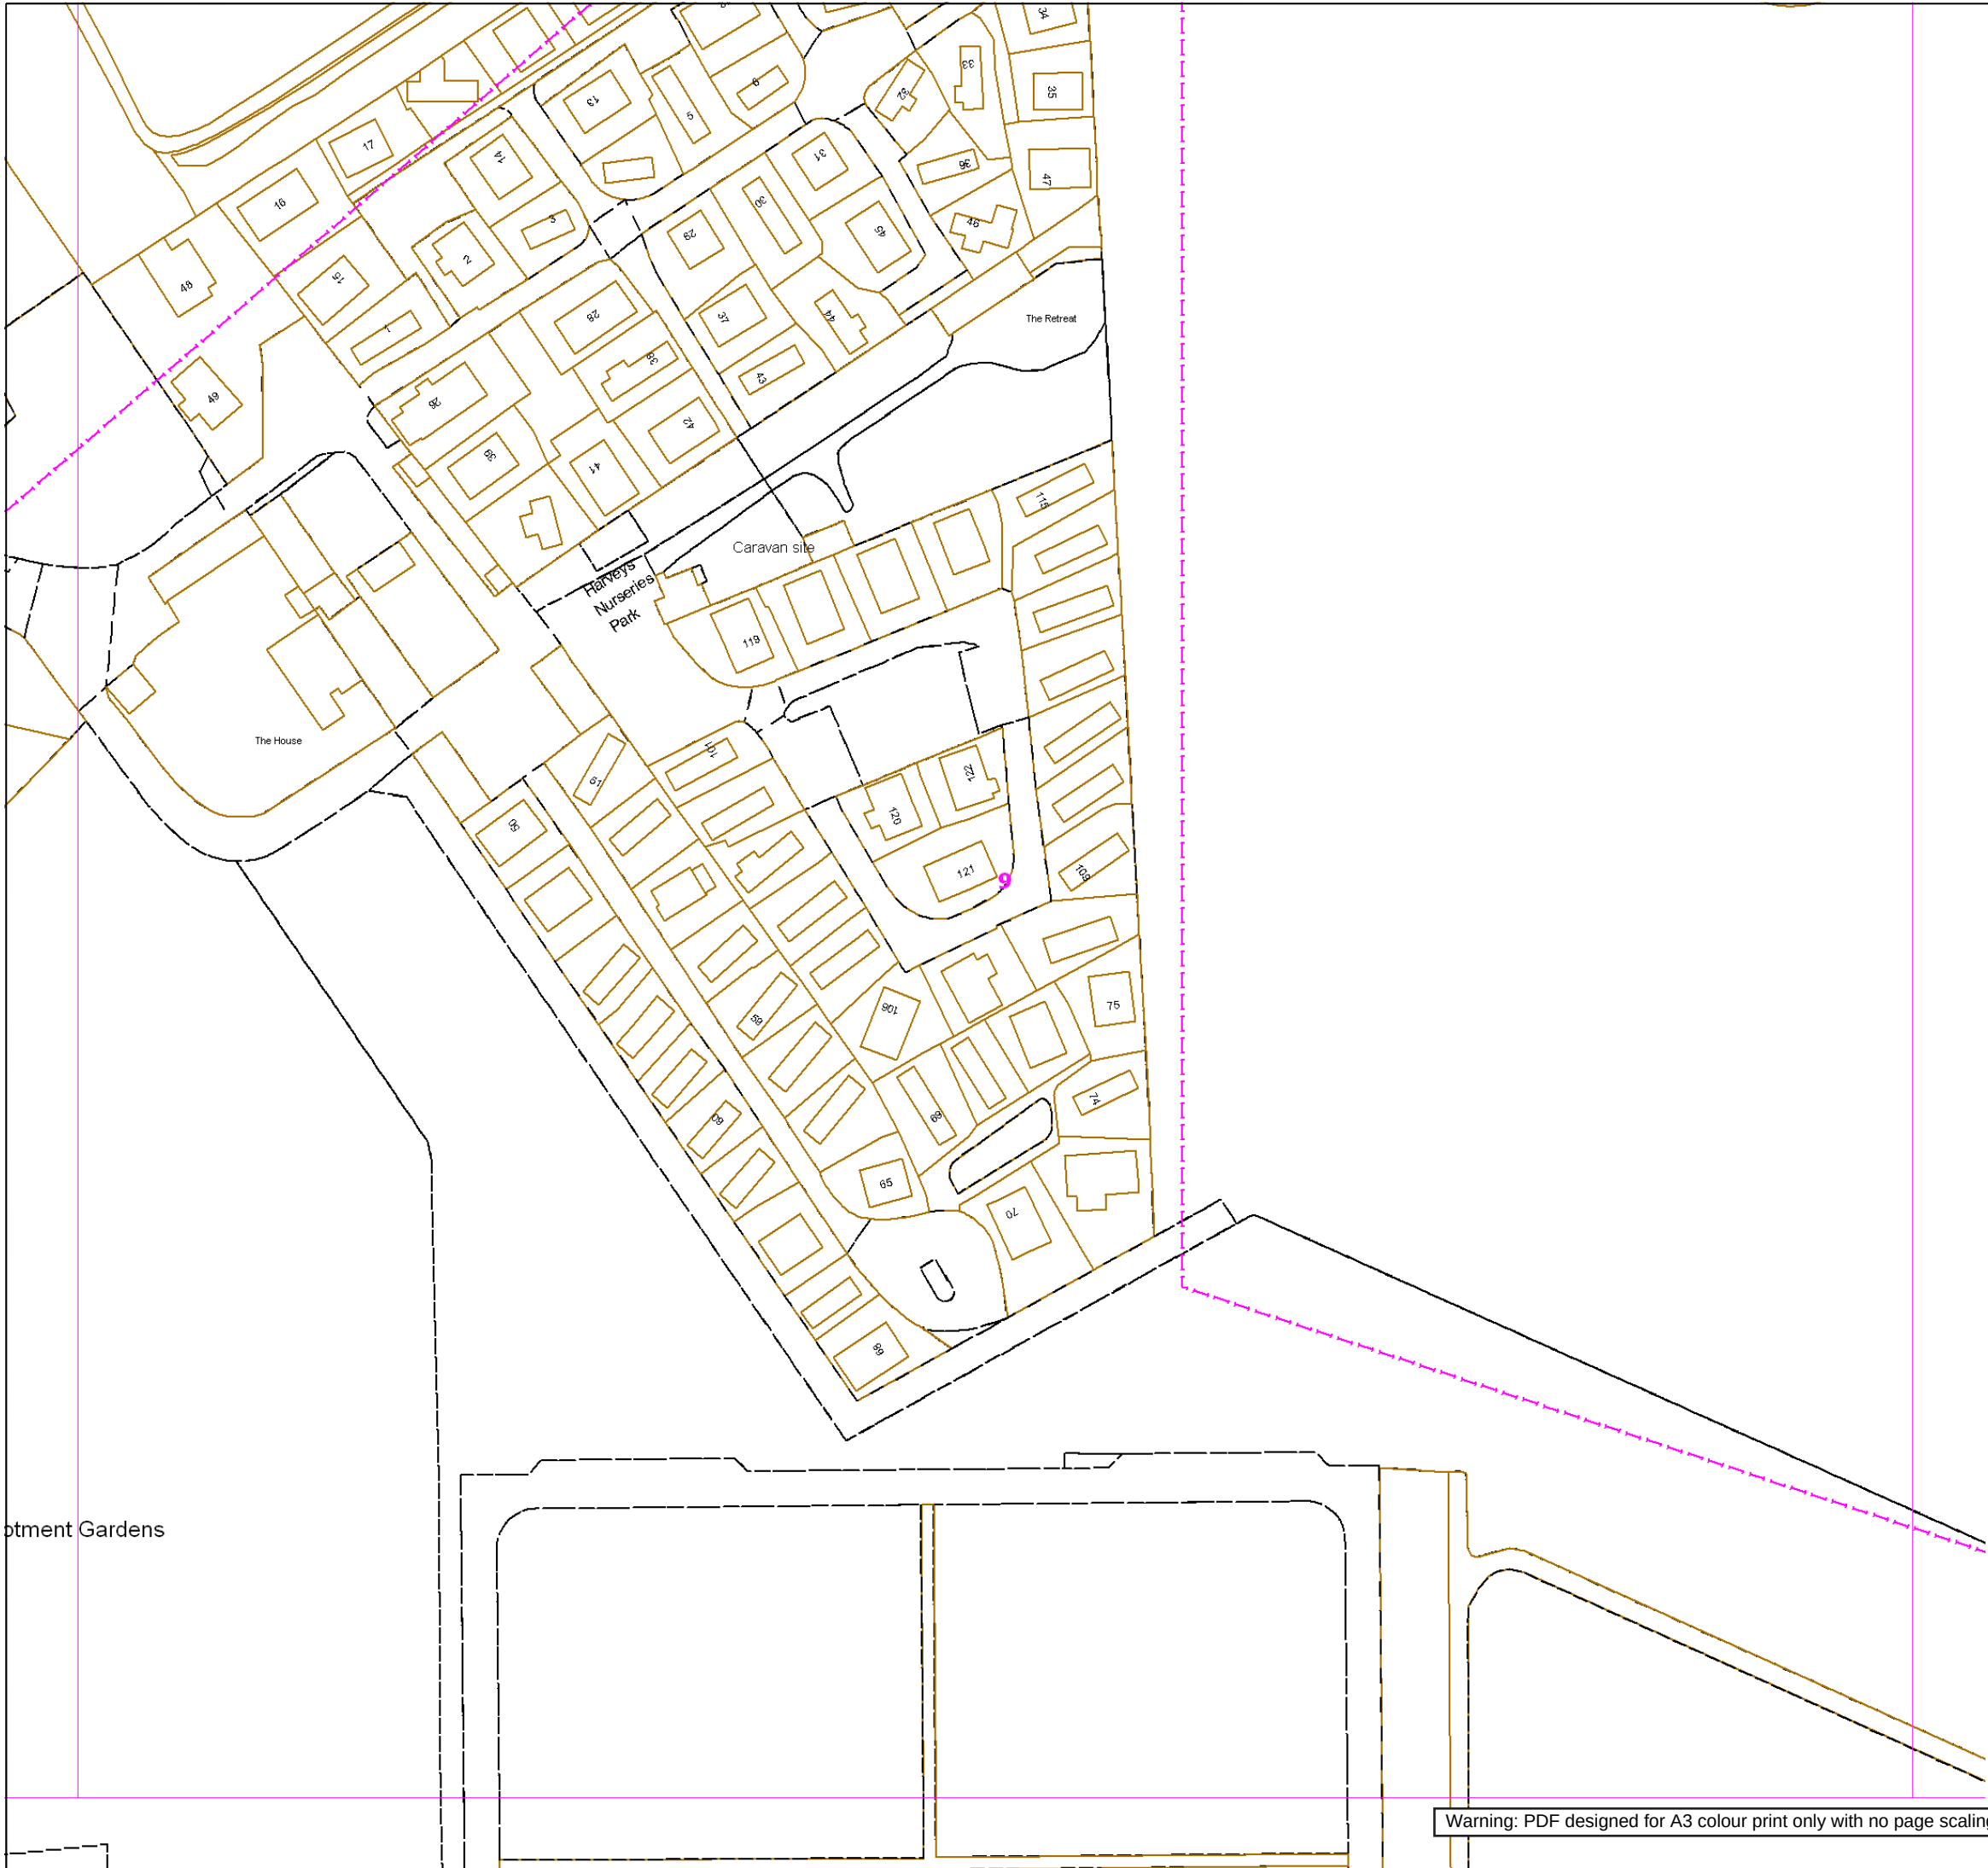

Contact Us
Mapping Enquiries: All areas
General Enquiries: All areas

Date Requested: 09/11/2021
Job Reference: 23827726
Site Location: 472560 176174
Requested by:
Ms Debbie Wigston
Your Scheme/Reference:
8210940
Exact Scales:
1:1000 Area or Circle dig site
1:1000 Line dig site

This plan shows the location of those pipes owned by Scotia Gas Networks (SGN) by virtue of being a licensed Gas Transporter (GT). Gas pipes owned by other GTs or third parties may also be present in this area but are not shown on this plan. Information with regard to such pipes should be obtained from the relevant owners. No warranties are given with regard to the accuracy of the information shown on this plan. Service pipes, valves, siphons, sub-connections etc. are not shown but their presence should be anticipated. You should be aware that a small percentage of our pipes/assets may be undergoing review and will temporarily be highlighted in yellow. If your proposed works are close to one of these pipes, you should contact the SGN Safety Admin Team on 0800 912 1722 for advice. No liability of any kind whatsoever is accepted by SGN or its agents, servants or sub-contractors for any error or omission contained herein. Safe digging practices, in accordance with HS (G)47, must be used to verify and establish the actual position of mains, pipes, services and other apparatus on site before any mechanical plant is used. It is your responsibility to ensure that plant location information is provided to all persons (whether direct labour or sub-contractors) working for you on or near gas apparatus. Information included on this plan should not be referred to beyond a period of 28 days from the date of issue.

Report damage immediately – KEEP EVERYONE AWAY FROM THE AREA
0800 111 999

Low Pressure Mains
Medium Pressure Mains
Intermediate Pressure Mains
High Pressure Mains
LAs
GTs
SSSIs


Some Examples Of Plant Items
Valve
Siphon
Depth of Cover
Diameter Change
Material Change

Digsite: Line: Area:



This plan is reproduced from or based on the OS map by Scotia Gas Networks plc, with the sanction of the controller of HM Stationery Office. Crown Copyright Reserved. Southern Gas – 100044373 and Scotland Gas – 100044366.

Warning: PDF designed for A3 colour print only with no page scaling.

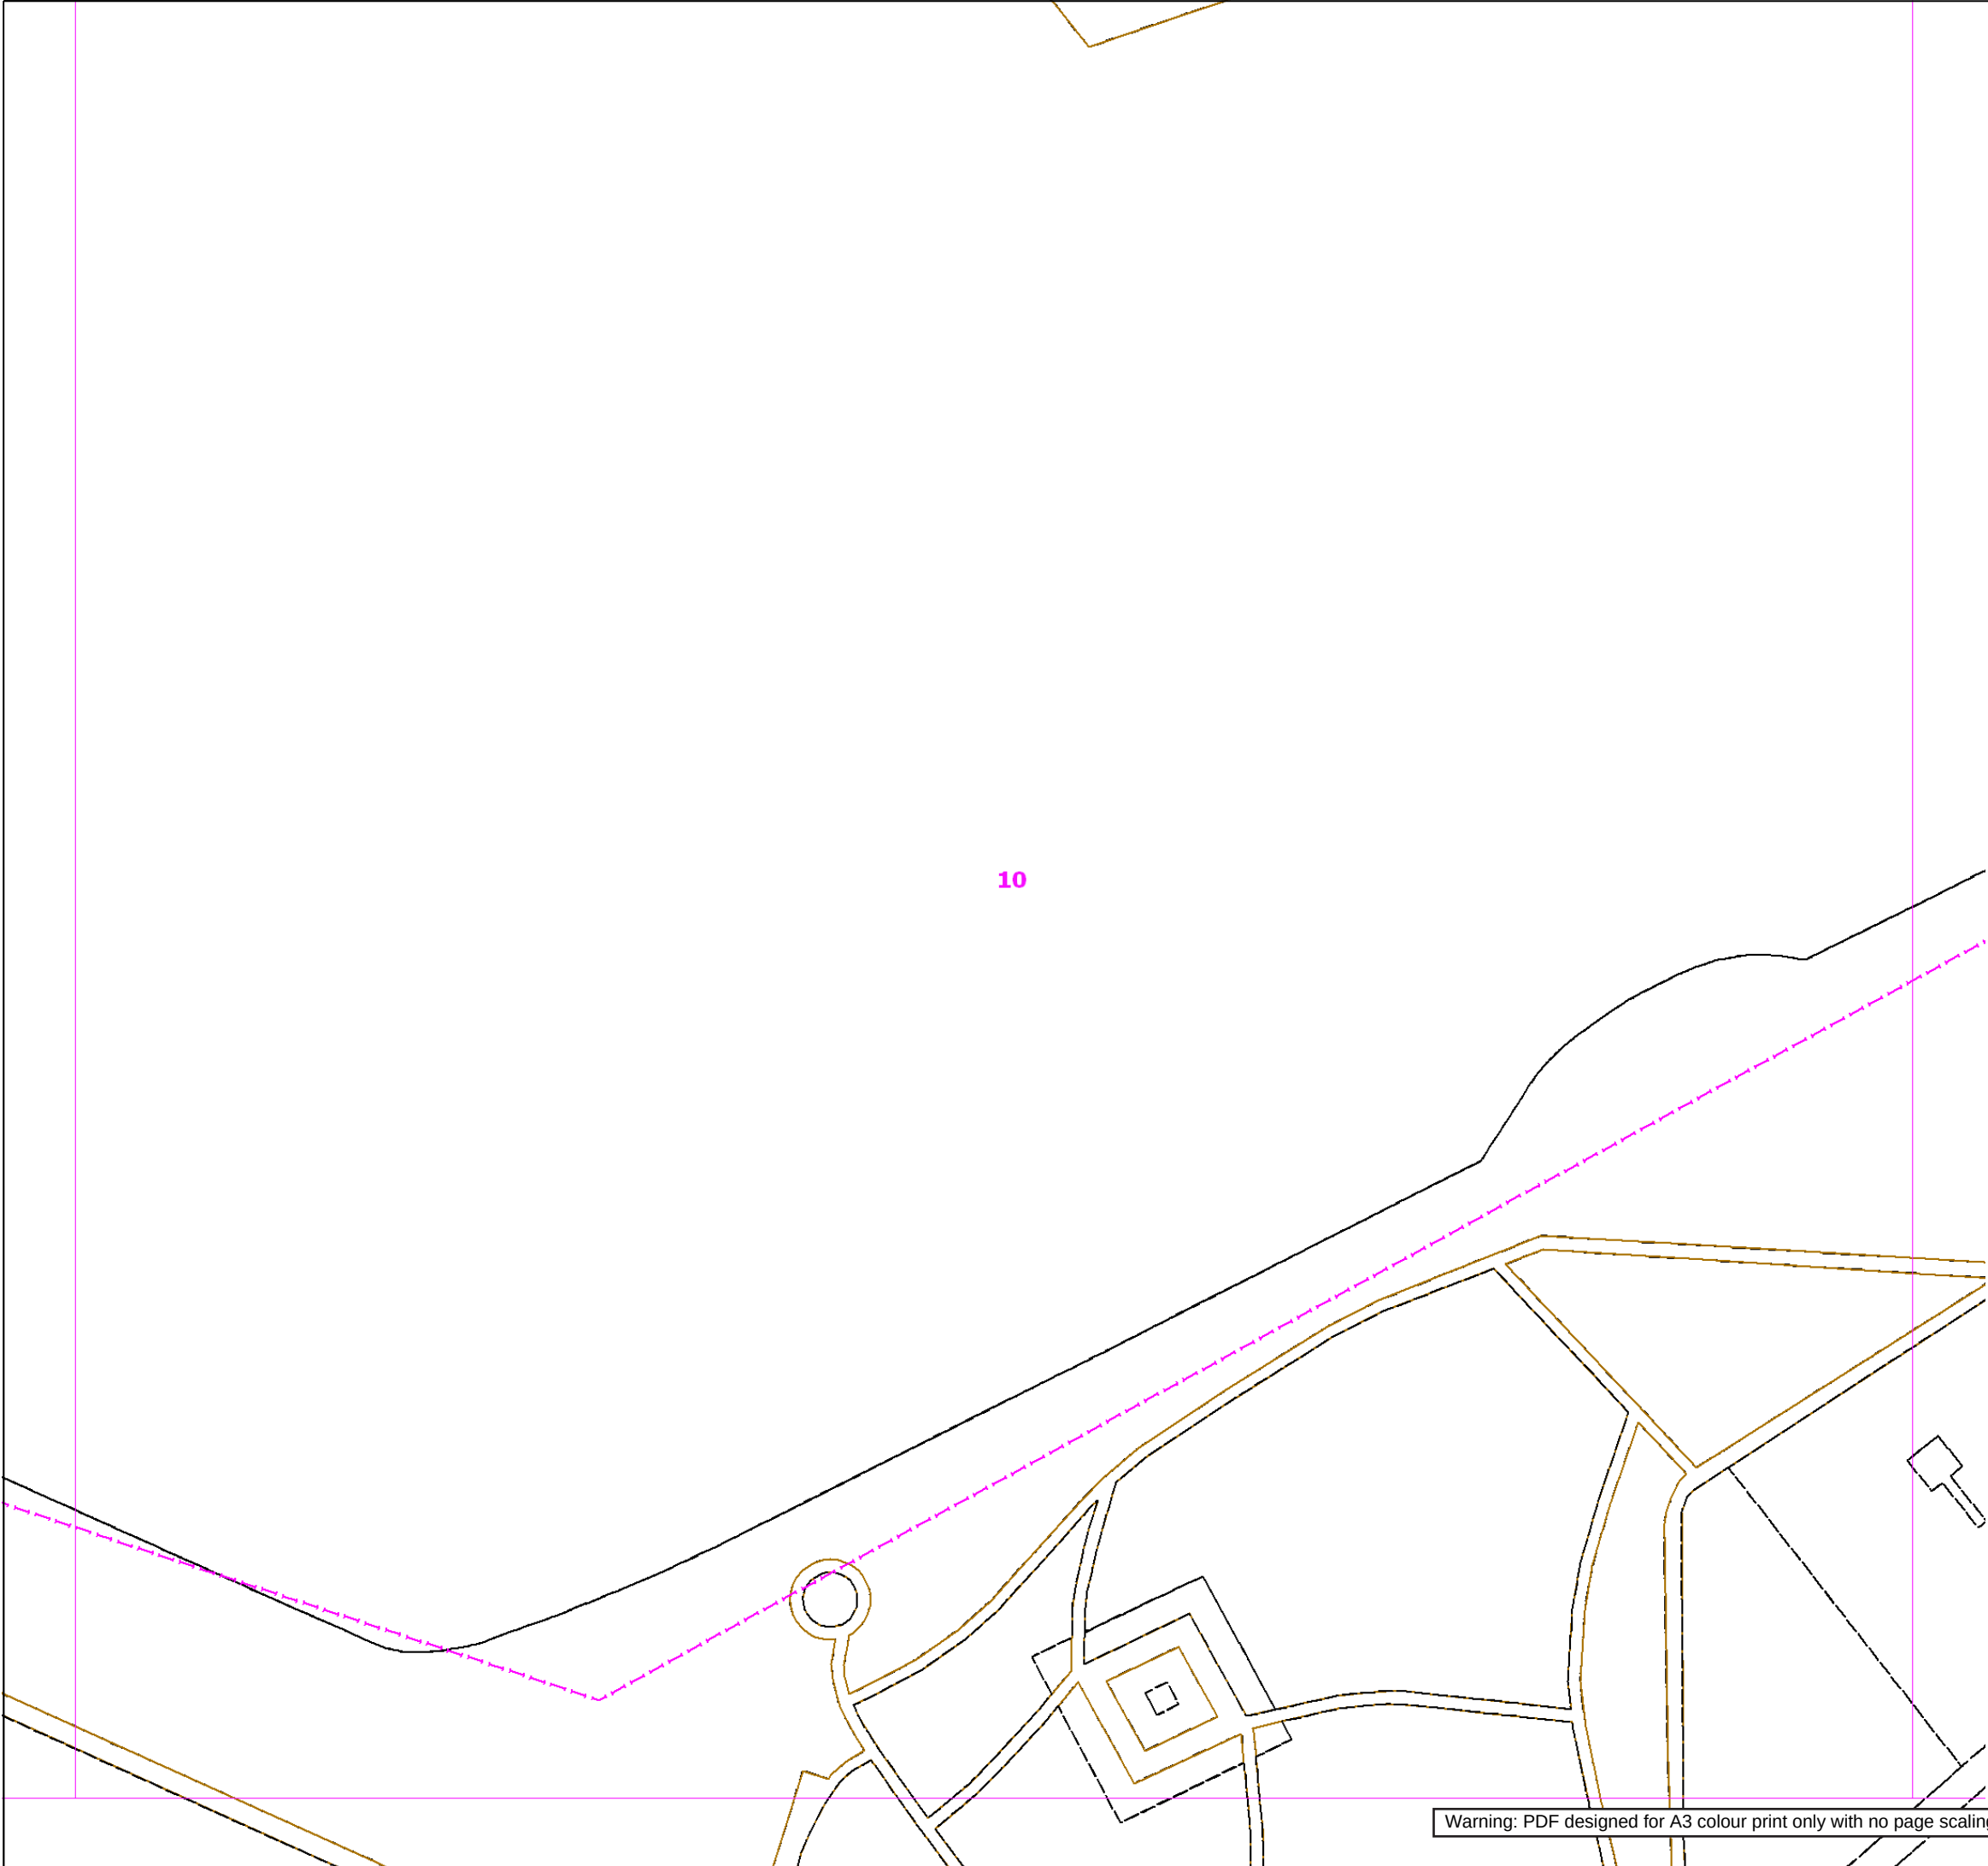

Contact Us
Mapping Enquiries: All areas
General Enquiries: All areas

Date Requested: 09/11/2021
Job Reference: 23827726
Site Location: 472560 176174
Requested by:
Ms Debbie Wigston
Your Scheme/Reference:
8210940
Exact Scales:
1:1000 Area or Circle dig site
1:1000 Line dig site

This plan shows the location of those pipes owned by Scotia Gas Networks (SGN) by virtue of being a licensed Gas Transporter (GT). Gas pipes owned by other GTs or third parties may also be present in this area but are not shown on this plan. Information with regard to such pipes should be obtained from the relevant owners. No warranties are given with regard to the accuracy of the information shown on this plan. Service pipes, valves, siphons, sub-connections etc. are not shown but their presence should be anticipated. You should be aware that a small percentage of our pipes/assets may be undergoing review and will temporarily be highlighted in yellow. If your proposed works are close to one of these pipes, you should contact the SGN Safety Admin Team on 0800 912 1722 for advice. No liability of any kind whatsoever is accepted by SGN or its agents, servants or sub-contractors for any error or omission contained herein. Safe digging practices, in accordance with HS (G)47, must be used to verify and establish the actual position of mains, pipes, services and other apparatus on site before any mechanical plant is used. It is your responsibility to ensure that plant location information is provided to all persons (whether direct labour or sub-contractors) working for you on or near gas apparatus. Information included on this plan should not be referred to beyond a period of 28 days from the date of issue.

Report damage immediately – KEEP EVERYONE AWAY FROM THE AREA
0800 111 999


Low Pressure Mains
Medium Pressure Mains
Intermediate Pressure Mains
High Pressure Mains
LAs
GTs
SSSIs

Some Examples Of Plant Items
Valve Syphon Depth of Cover Diameter Change Material Change

Digsite: Line: Area:



This plan is reproduced from or based on the OS map by Scotia Gas Networks plc, with the sanction of the controller of HM Stationery Office. Crown Copyright Reserved. Southern Gas – 100044373 and Scotland Gas – 100044366.

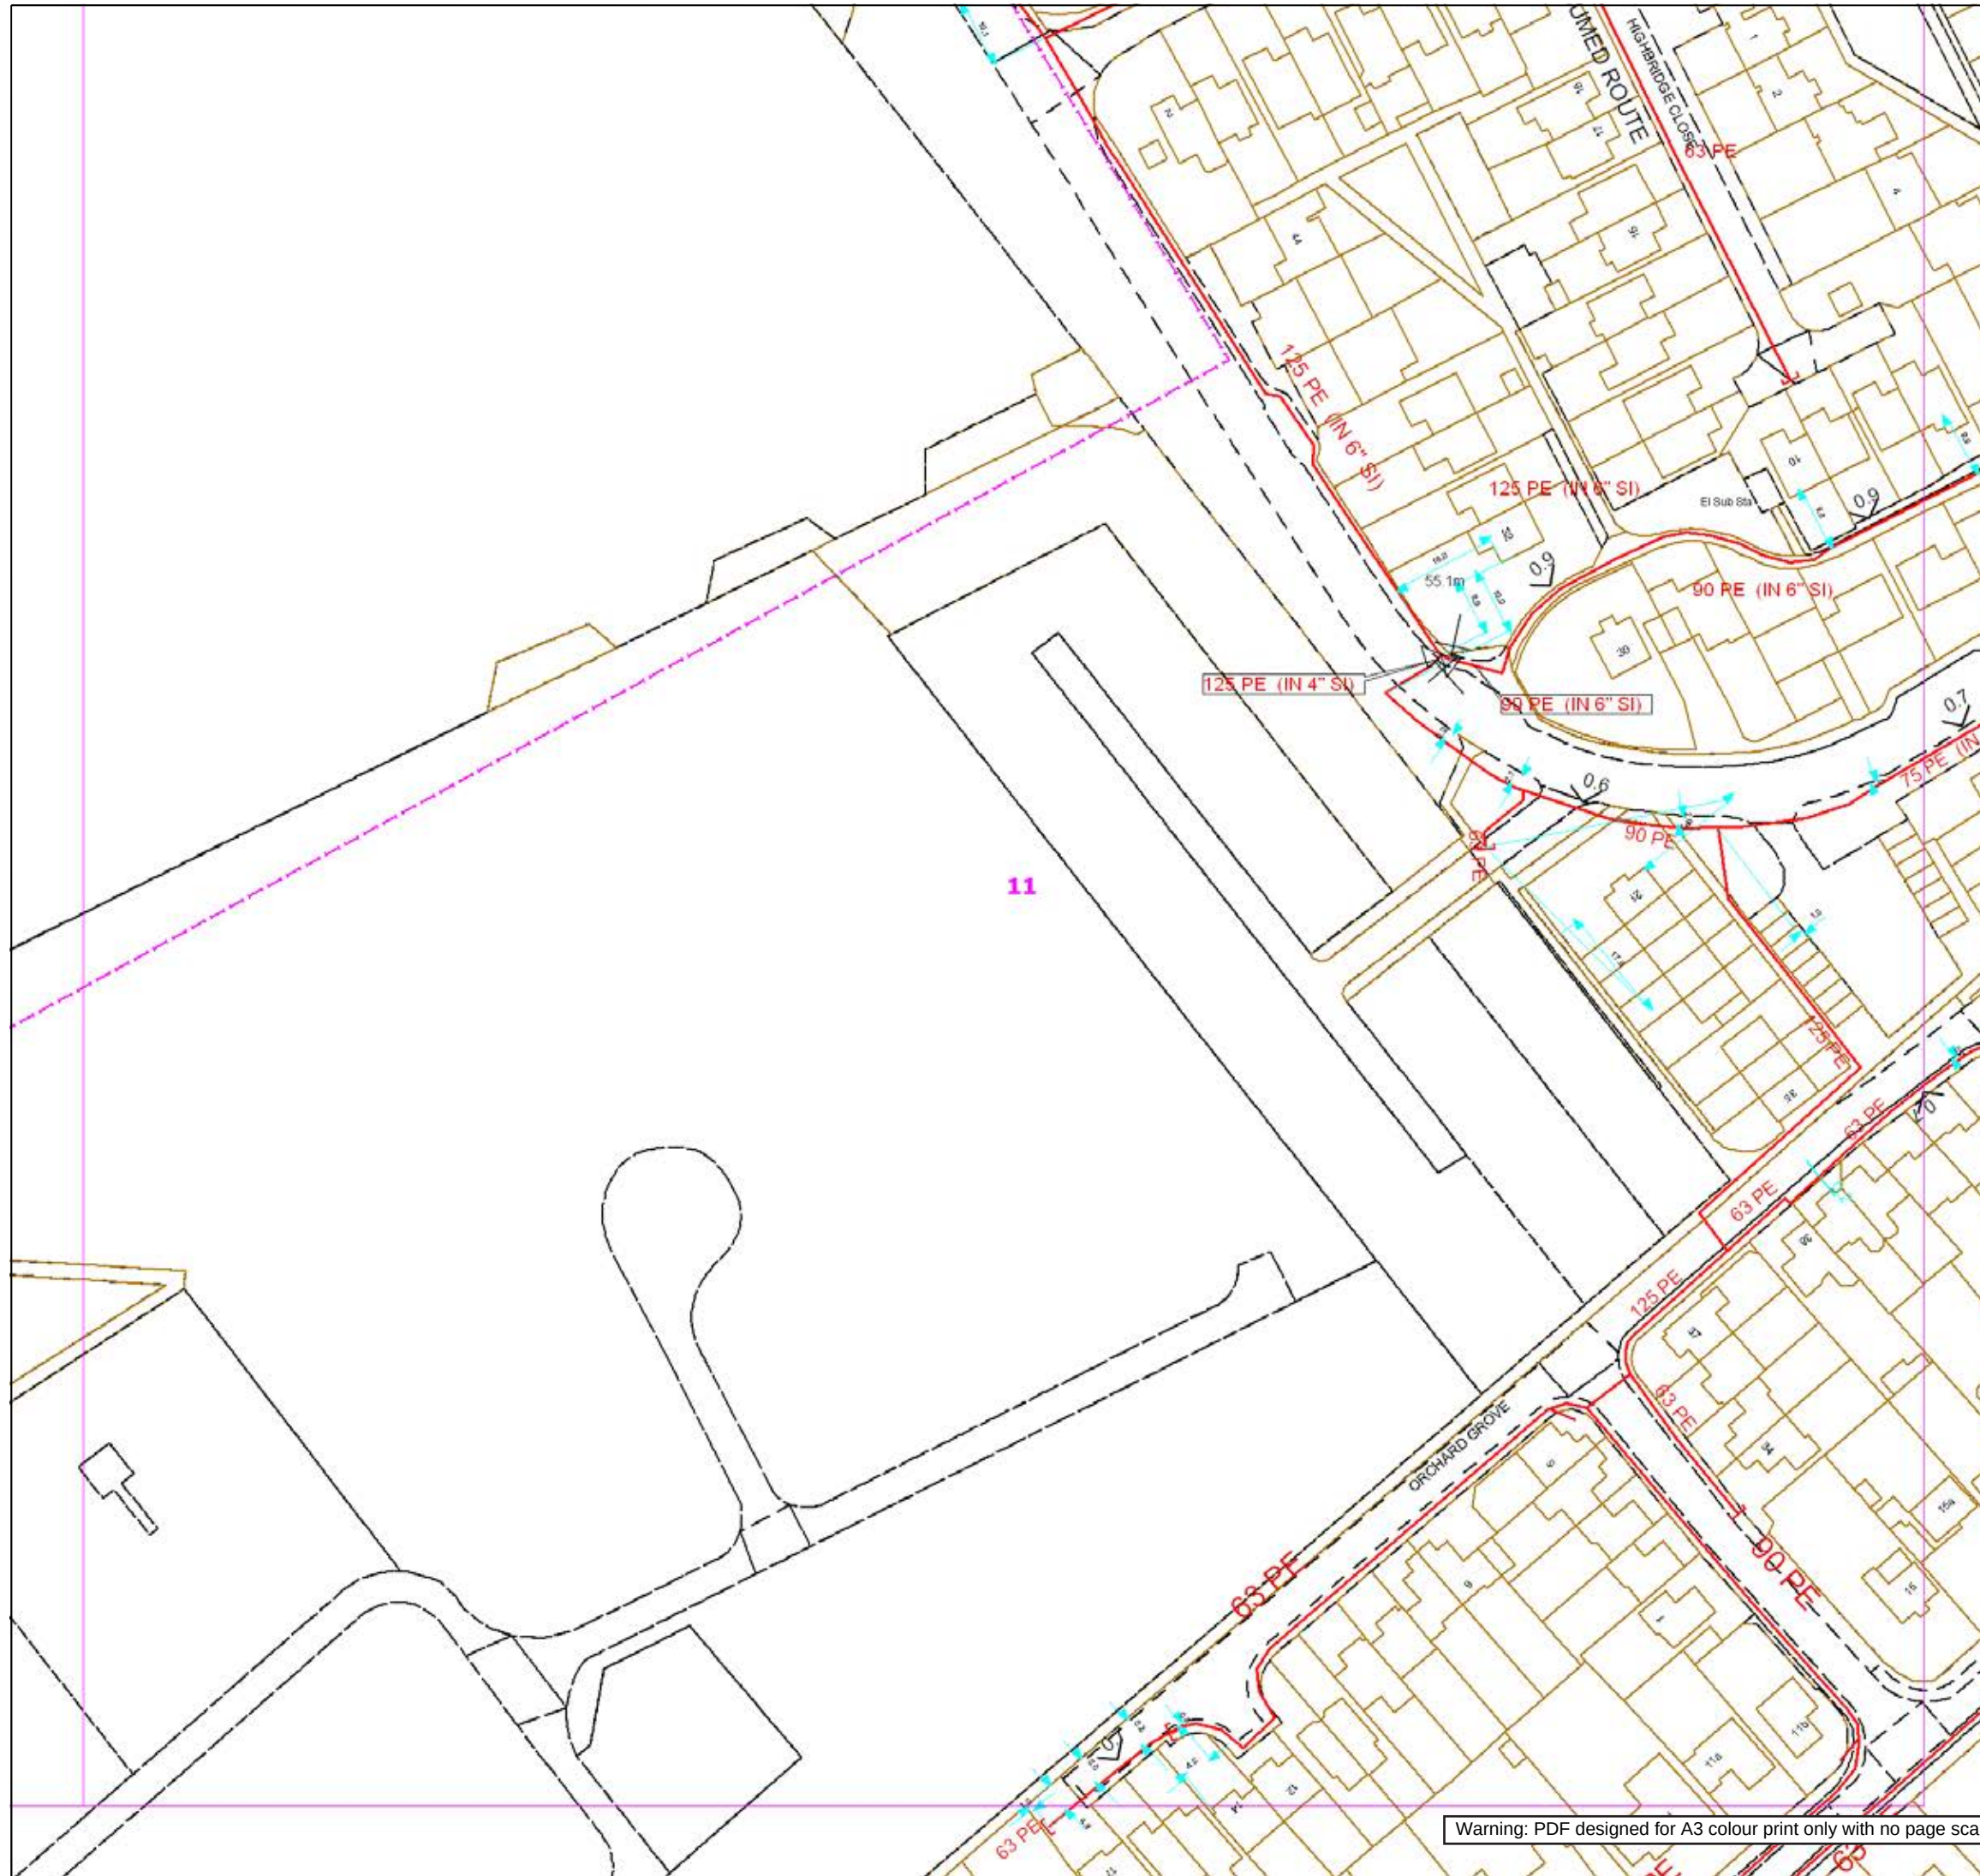

SGN
Your gas. Our network.

Contact Us

Mapping Enquiries:
All areas

General Enquiries:
All areas

Date Requested: 09/11/2021
Job Reference: 23827726
Site Location: 472560 176174
Requested by:
Ms Debbie Wigston
Your Scheme/Reference:
8210940
Exact Scales:
1:1000 Area or Circle dig site
1:1000 Line dig site

This plan shows the location of those pipes owned by Scotia Gas Networks (SGN) by virtue of being a licensed Gas Transporter (GT). Gas pipes owned by other GTs or third parties may also be present in this area but are not shown on this plan. Information with regard to such pipes should be obtained from the relevant owners. No warranties are given with regard to the accuracy of the information shown on this plan. Service pipes, valves, siphons, sub-connections etc. are not shown but their presence should be anticipated. You should be aware that a small percentage of our pipes/assets may be undergoing review and will temporarily be highlighted in yellow. If your proposed works are close to one of these pipes, you should contact the SGN Safety Admin Team on 0800 912 1722 for advice. No liability of any kind whatsoever is accepted by SGN or its agents, servants or sub-contractors for any error or omission contained herein. Safe digging practices, in accordance with HS (G)47, must be used to verify and establish the actual position of mains, pipes, services and other apparatus on site before any mechanical plant is used. It is your responsibility to ensure that plant location information is provided to all persons (whether direct labour or sub-contractors) working for you on or near gas apparatus. Information included on this plan should not be referred to beyond a period of 28 days from the date of issue.

Report damage immediately – KEEP EVERYONE AWAY FROM THE AREA
0800 111 999

Low Pressure Mains

 
Medium Pressure Mains

Intermediate Pressure Mains

High Pressure Mains

LAs

GTs



SSSIs



Some Examples Of Plant Items

Valve



Syphon



Depth of Cover



Diameter Change



Material Change

 


Digsite:

Line:



Area:




This plan is reproduced from or based on the OS map by Scotia Gas Networks plc, with the sanction of the controller of HM Stationery Office. Crown Copyright Reserved. Southern Gas – 100044373 and Scotland Gas – 100044366.

Warning: PDF designed for A3 colour print only with no page scaling.

Appendix F

Service Records – Scottish and Southern Electricity Networks (Electricity)

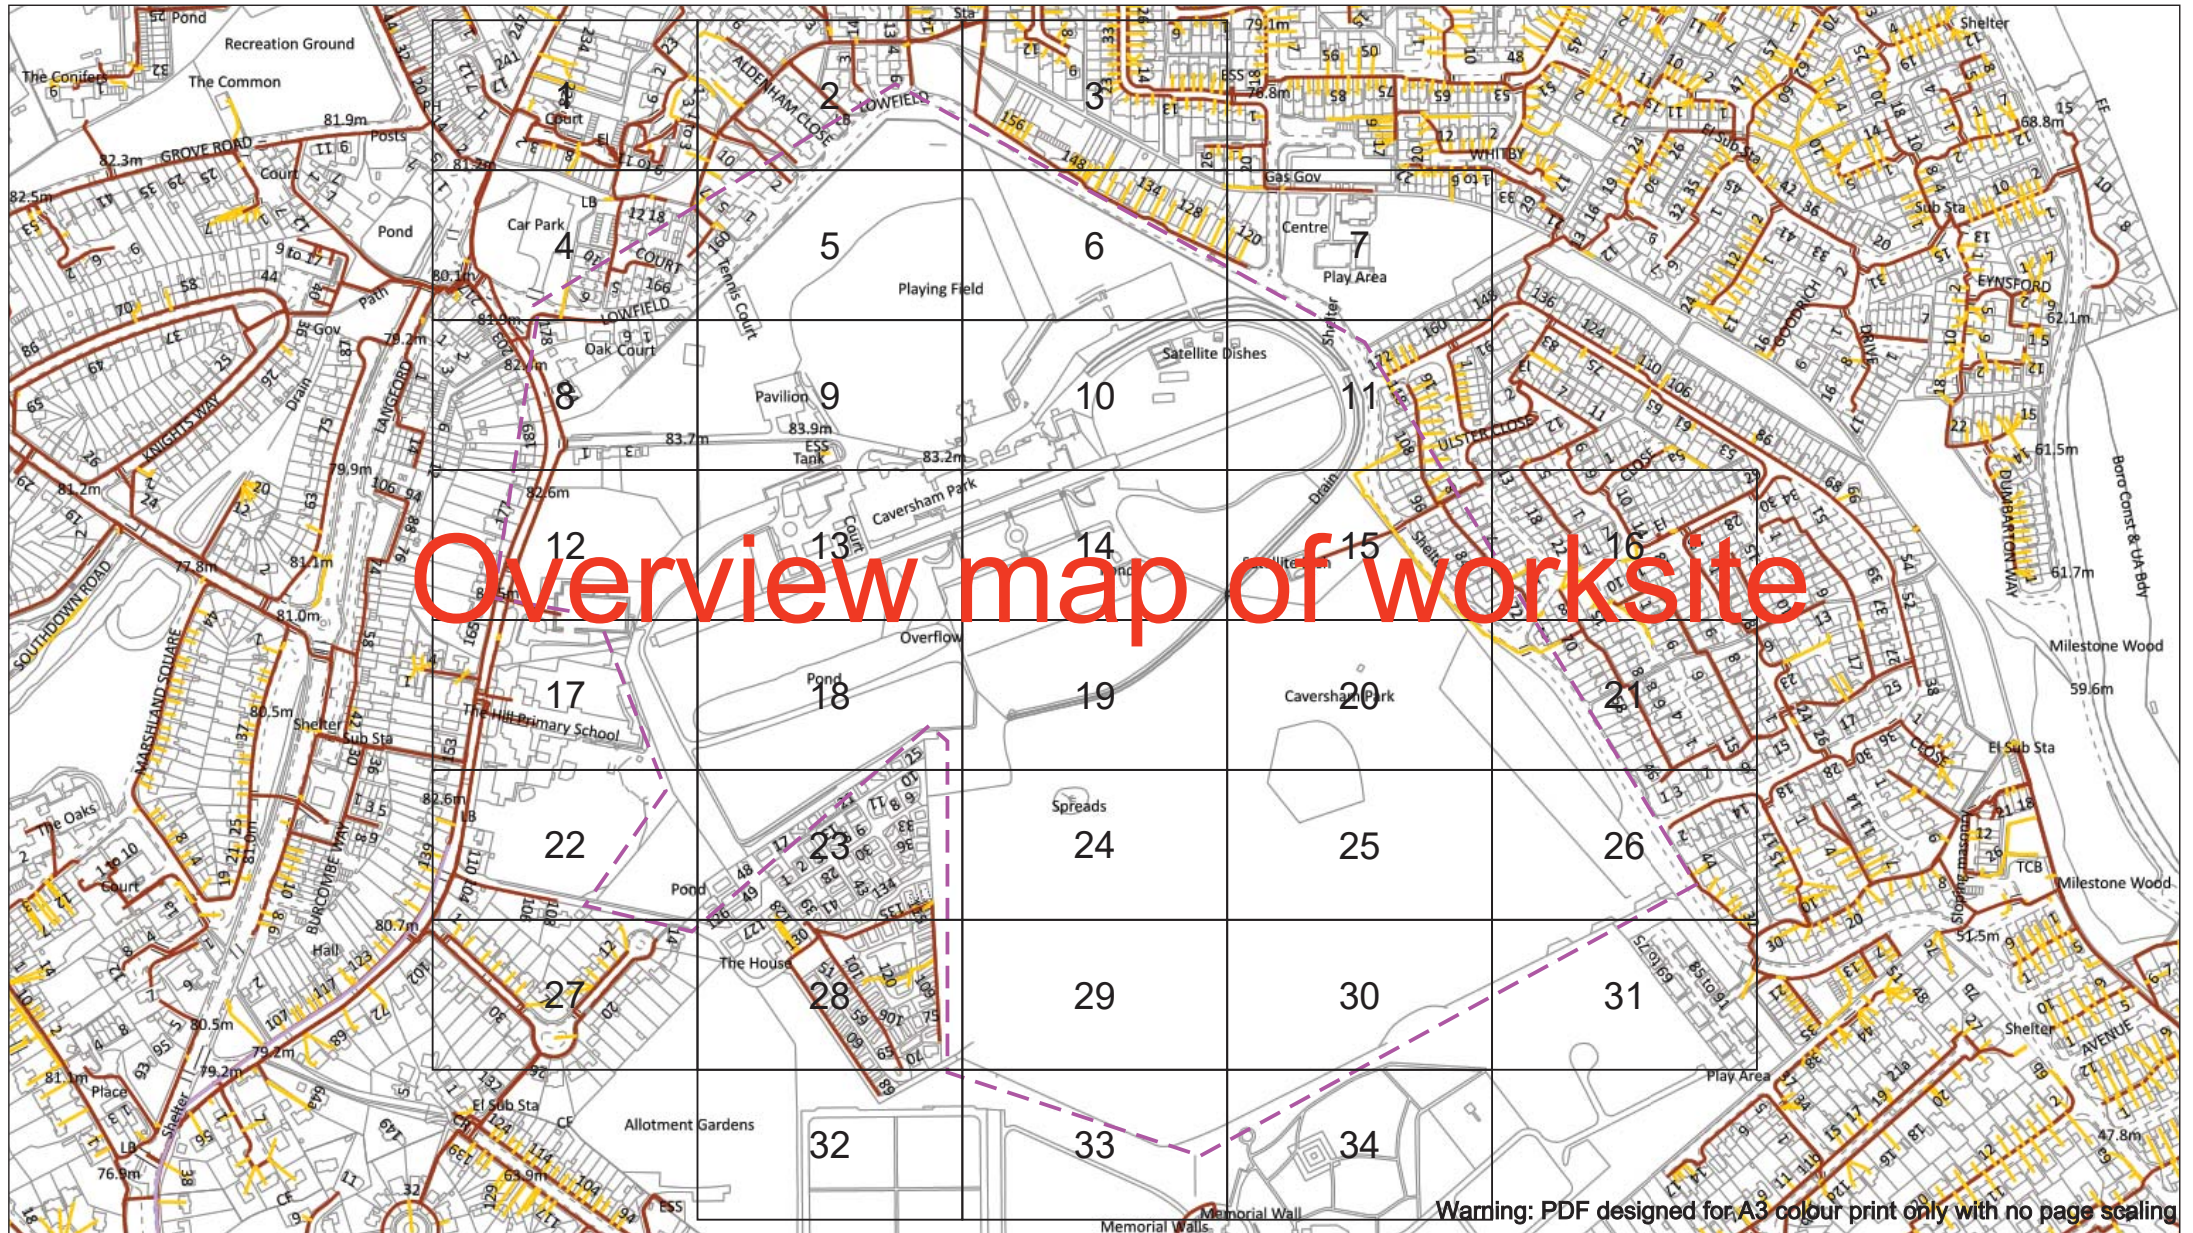

Warning: PDF designed for A3 colour print only with no page scaling

Date Requested: 09/11/2021
Job Reference: 23827726
Site Location: 472556 176139
Requested by:
Ms Debbie Wigston
Your Scheme/Reference:
8210940

Scale: 1:4100 (When plotted at A3)

WARNING
There may have been subsequent alteration to the surface levels. Trial holes must be undertaken to determine position and depths of cables. HS (G) 47 Booklet from the Health and Safety Executive – Avoiding Danger from Buried Cables – should be consulted before commencing excavation work.

WHEN WORKING IN THE VICINITY OF OVERHEAD LINES THE HEALTH AND SAFETY GUIDANCE NOTES GS6 SHOULD BE CONSULTED (AVAILABLE FROM THE HSE WEBSITE)

Voltages (V)				
LV (Low Voltage) and Services	Up to 1,000V			
HV (High Voltage)	Over 1,000V to 11,000V			
EHV (Extra High Voltage)	22,000V to 132,000V			
Transmission	275,000V and 400,000V			
NORMAL DEPTH TO THE TOP OF THE CABLE WHEN LAID				
	LV	HV	EHV	
Footpath/Unmade	0.45m	0.45m	0.6m	0.8m
Road Crossing	0.6m	0.6m	0.75m	0.9m
Agricultural	1m	1m	1m	1.1m

Legend

- Service Cable
- LV Mains
- 2-3.3kV
- 6.6kV
- 11kV
- 22kV
- 33kV
- 66kV
- 132kV
- 275kV
- 400kV
- Flow Duct
- Pile Cable


Distribution Structures (Electric)

- Pole, Existing Location
- Pole Structure, Existing Location - Single
- Pole Structure, Existing Location - H
- Duct Route
- Cross Section Route

Southern Electric Power Distribution plc
Registered Office: No.1 Forbury Place
43 Forbury Road Reading RG1 3JH
Registered in England & Wales No.04094290

If you're unsure & need to seek advice before commencing excavations please contact:
General Enquiries: 0800 048 3516

Subject to revision – Master held by SSEN Asset Data Team:
AssetData@ssen.com
01256 337 294

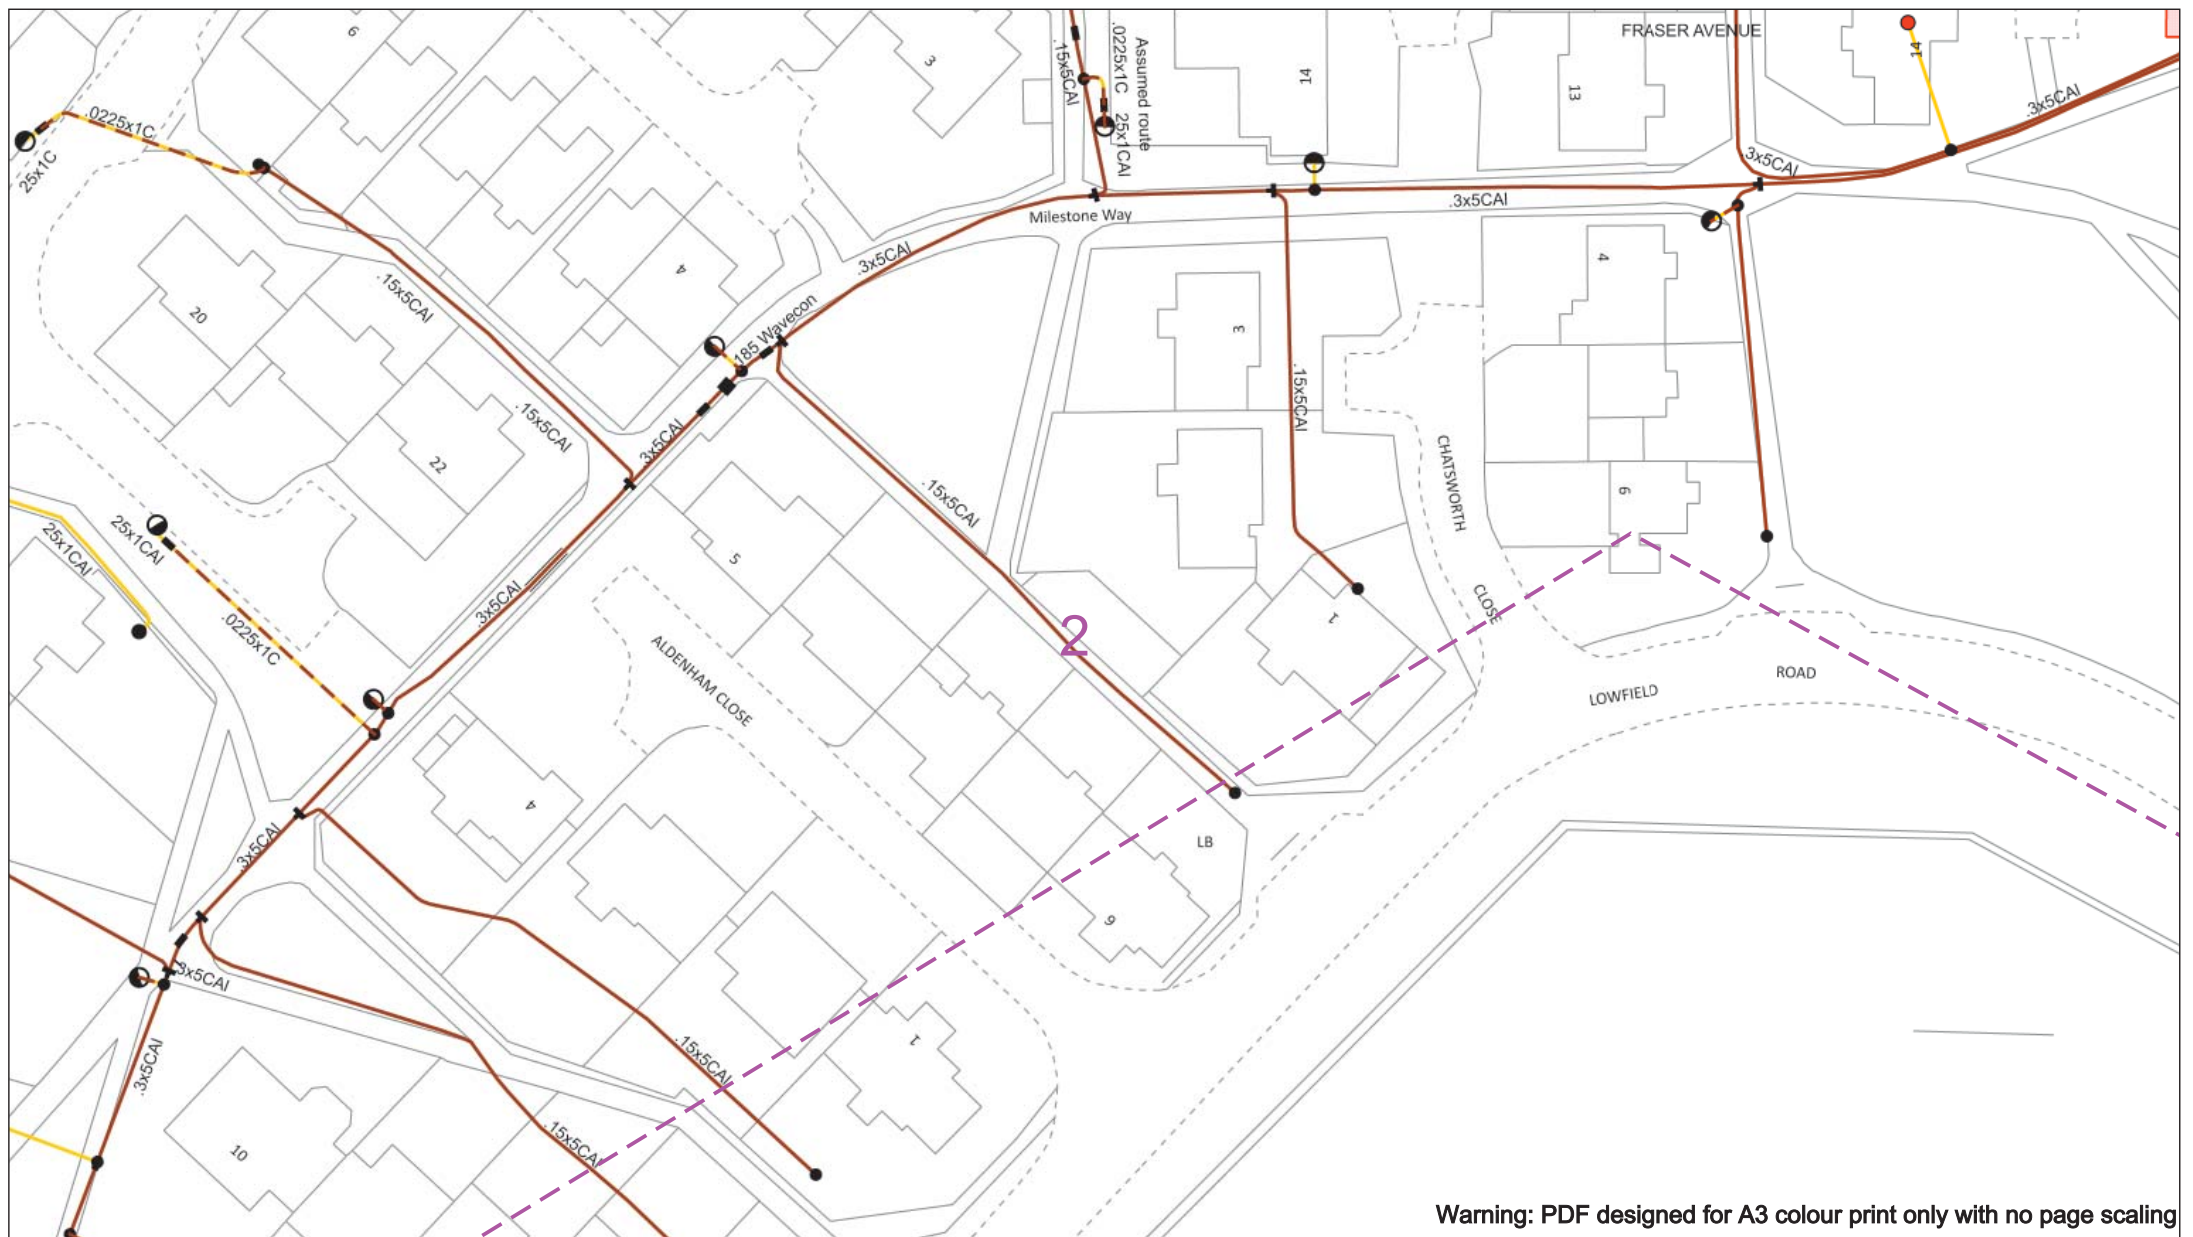

Warning: PDF designed for A3 colour print only with no page scaling

0 50m

Dig Sites Area: Line:

Date Requested: 09/11/2021
Job Reference: 23827726
Site Location: 472556 176139
Requested by:
Ms Debbie Wigston
Your Scheme/Reference: 8210940

WARNING

There may have been subsequent alteration to the surface levels. Trial holes must be undertaken to determine position and depths of cables. HS (G) 47 Booklet from the Health and Safety Executive – Avoiding Danger from Buried Cables – should be consulted before commencing excavation work.

WHEN WORKING IN THE VICINITY OF OVERHEAD LINES THE HEALTH AND SAFETY GUIDANCE NOTES GS6 SHOULD BE CONSULTED (AVAILABLE FROM THE HSE WEBSITE)

Voltages (V)				
LV (Low Voltage) and Services	Up to 1,000V			
LV Mains	Over 1,000V to 11,000V			
HV (High Voltage)	22,000V to 132,000V			
EHV (Extra High Voltage)	275,000V and 400,000V			
Transmission	275,000V and 400,000V			

NORMAL DEPTH TO THE TOP OF THE CABLE WHEN LAID				
Services	LV	HV	EHV	EHV
Footpath/Unmade	0.45m	0.45m	0.6m	0.8m
Road Crossing	0.6m	0.6m	0.75m	0.9m
Agricultural	1m	1m	1m	1.1m

Legend

- Service Cable
- LV Mains
- 2-3.3kV
- 6.6kV
- 11kV
- 22kV
- 33kV
- 66kV
- 132kV
- 275kV
- 400kV
- Flare Cable
- Pole Cable

Distribution Structures (Electric)

- Pole, Existing Location
- Pole Structure, Existing Location - Single
- Pole Structure, Existing Location - H
- Duct Route
- Cross Section Route


Southern Electric Power Distribution plc
Registered Office: No.1 Forbury Place
43 Forbury Road Reading RG1 3JH
Registered in England & Wales No.04094290

If you're unsure & need to seek advice before commencing excavations please contact:
General Enquiries: 0800 048 3516

Subject to revision – Master held by SSEN Asset Data Team:
AssetData@ssen.com
01256 337 294

BASED UPON THE ORDNANCE SURVEY MAP WITH THE SANCTION OF THE CONTROLLER OF H.M STATIONERY OFFICE CROWN COPYRIGHT RESERVED.

This copy has been made by or with the authority of Scottish and Southern Energy Power Distribution Ltd. Pursuant to section 47 of the Copyright, Designs and Patents Act 1988 ('The Act'). Unless the Act provides a relevant exception to copyright the copy must not be copied without prior permission of the copyright owner. Plans generated by DigSAFE Pro™ software provided by LinesearchbeforeUdig.

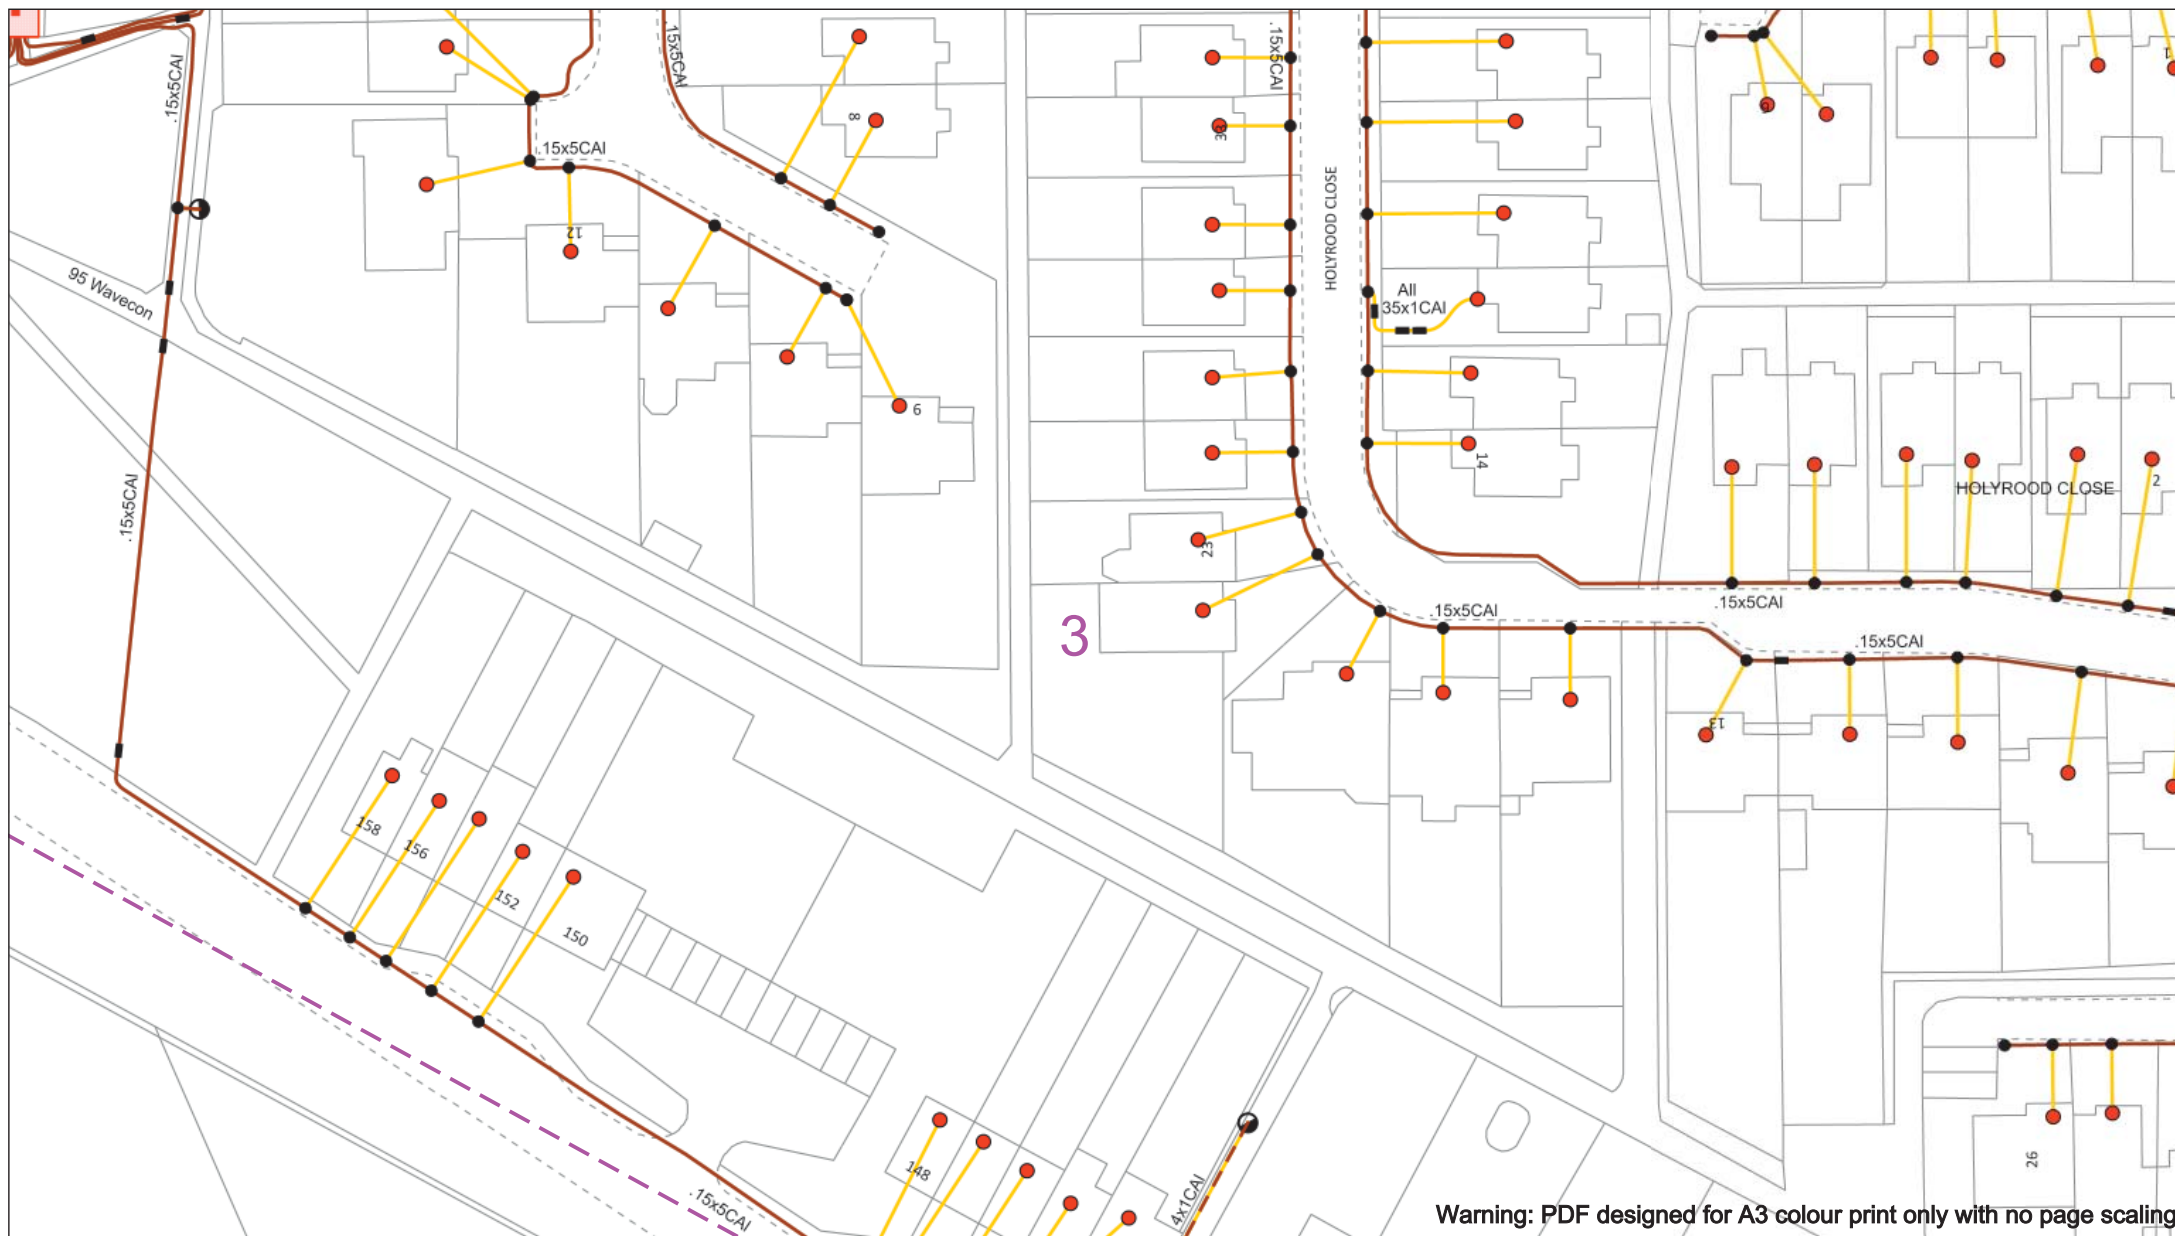

Warning: PDF designed for A3 colour print only with no page scaling

050m

Dig Sites

Area:

Line:

Date Requested: 09/11/2021

Job Reference: 23827726

Site Location: 472556 176139

Requested by: Ms Debbie Wigston

Your Scheme/Reference: 8210940

WARNING

There may have been subsequent alteration to the surface levels. Trial holes must be undertaken to determine position and depths of cables. HS (G) 47 Booklet from the Health and Safety Executive – Avoiding Danger from Buried Cables – should be consulted before commencing excavation work.

WHEN WORKING IN THE VICINITY OF OVERHEAD LINES THE HEALTH AND SAFETY GUIDANCE NOTES GS6 SHOULD BE CONSULTED (AVAILABLE FROM THE HSE WEBSITE)

Voltages (V)				
LV (Low Voltage) and Services	Up to 1,000V			
LV Mains	Over 1,000V to 11,000V			
EHV (Extra High Voltage)	22,000V to 132,000V			
Transmission	275,000V and 400,000V			

NORMAL DEPTH TO THE TOP OF THE CABLE WHEN LAID				
Services	LV	HV	EHV	
Footpath/Unmade	0.45m	0.45m	0.6m	0.8m
Road Crossing	0.6m	0.6m	0.75m	0.9m
Agricultural	1m	1m	1m	1.1m

Legend

Service Cable

LV Mains

2 – 3.3kV

6.6kV

11kV

22kV

33kV

66kV

132kV

275kV

400kV

Fibre Optic

Pilot Cable

Distribution Structures (Electric)

Pole, Existing Location

Pole Structure, Existing Location - Single

Pole Structure, Existing Location - H

Duct Route

Cross Section Route


Southern Electric Power Distribution plc
Registered Office: No.1 Forbury Place
43 Forbury Road Reading RG1 3JH
Registered in England & Wales No.04094290

If you're unsure & need to seek advice before commencing excavations please contact:
General Enquiries: 0800 048 3516

Subject to revision – Master held by SSEN Asset Data Team:
AssetData@ssen.com
01256 337 294

BASED UPON THE ORDNANCE SURVEY MAP WITH THE SANCTION OF THE CONTROLLER OF H.M STATIONERY OFFICE CROWN COPYRIGHT RESERVED.

This copy has been made by or with the authority of Scottish and Southern Energy Power Distribution Ltd. Pursuant to section 47 of the Copyright, Designs and Patents Act 1988 ('The Act'). Unless the Act provides a relevant exception to copyright the copy must not be copied without prior permission of the copyright owner. Plans generated by DigSAFE Pro™ software provided by LinesearchbeforeUdig.

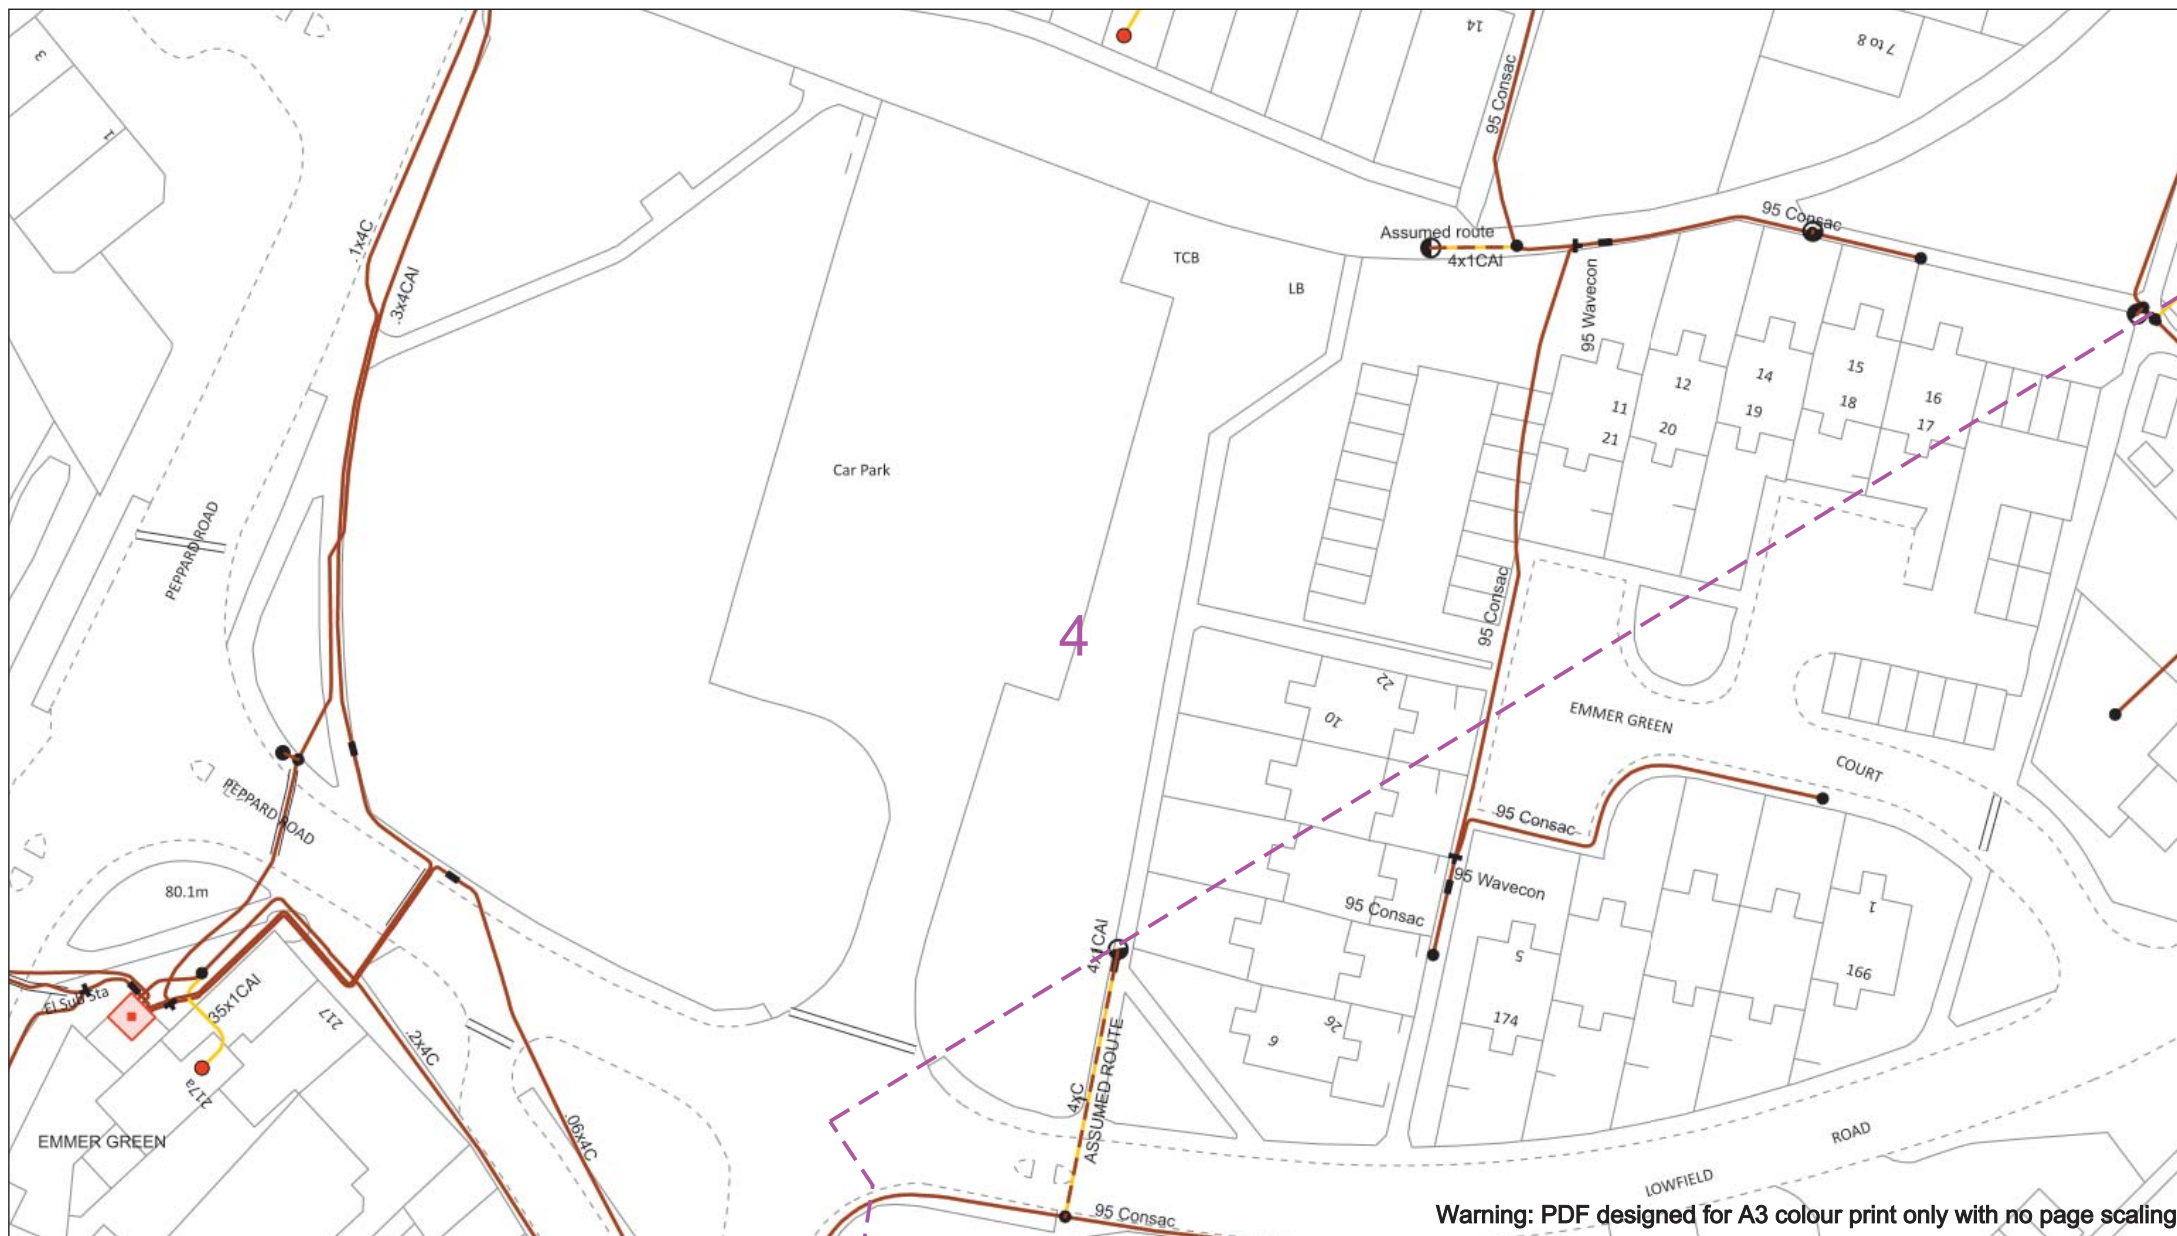

0 50m

Dig Sites Area: Line:

Date Requested: 09/11/2021
Job Reference: 23827726
Site Location: 472556 176139
Requested by: Ms Debbie Wigston
Your Scheme/Reference: 8210940

WARNING

There may have been subsequent alteration to the surface levels. Trial holes must be undertaken to determine position and depths of cables. HS (G) 47 Booklet from the Health and Safety Executive – Avoiding Danger from Buried Cables – should be consulted before commencing excavation work.

WHEN WORKING IN THE VICINITY OF OVERHEAD LINES THE HEALTH AND SAFETY GUIDANCE NOTES GS6 SHOULD BE CONSULTED (AVAILABLE FROM THE HSE WEBSITE)

Voltages (V)				
LV (Low Voltage) and Services	Up to 1,000V			
LV Mains	Over 1,000V to 11,000V			
HV (High Voltage)	22,000V to 132,000V			
EHV (Extra High Voltage)	275,000V and 400,000V			
Transmission	275,000V and 400,000V			

NORMAL DEPTH TO THE TOP OF THE CABLE WHEN LAID				
	LV	HV	EHV	
Footpath/Unmade	0.45m	0.45m	0.6m	0.8m
Road Crossing	0.6m	0.6m	0.75m	0.9m
Agricultural	1m	1m	1m	1.1m

Legend

- Service Cable
- LV Mains
- 2-3.3kV
- 6.6kV
- 11kV
- 22kV
- 33kV
- 66kV
- 132kV
- 275kV
- 400kV
- Flow Optic
- Pole Cable

Distribution Structures (Electric)

- Pole, Existing Location
- Pole Structure, Existing Location - Single
- Pole Structure, Existing Location - H
- Duct Route
- Cross Section Route


Southern Electric Power Distribution plc
Registered Office: No.1 Forbury Place
43 Forbury Road Reading RG1 3JH
Registered in England & Wales No.04094290

If you're unsure & need to seek advice before commencing excavations please contact:
General Enquiries: 0800 048 3516

Subject to revision – Master held by SSEN Asset Data Team:
AssetData@ssen.com
01256 337 294

BASED UPON THE ORDNANCE SURVEY MAP WITH THE SANCTION OF THE CONTROLLER OF H.M STATIONERY OFFICE CROWN COPYRIGHT RESERVED.

This copy has been made by or with the authority of Scottish and Southern Energy Power Distribution Ltd. Pursuant to section 47 of the Copyright, Designs and Patents Act 1988 ('The Act'). Unless the Act provides a relevant exception to copyright the copy must not be copied without prior permission of the copyright owner. Plans generated by DigSAFE Pro™ software provided by LinesearchbeforeUdig.

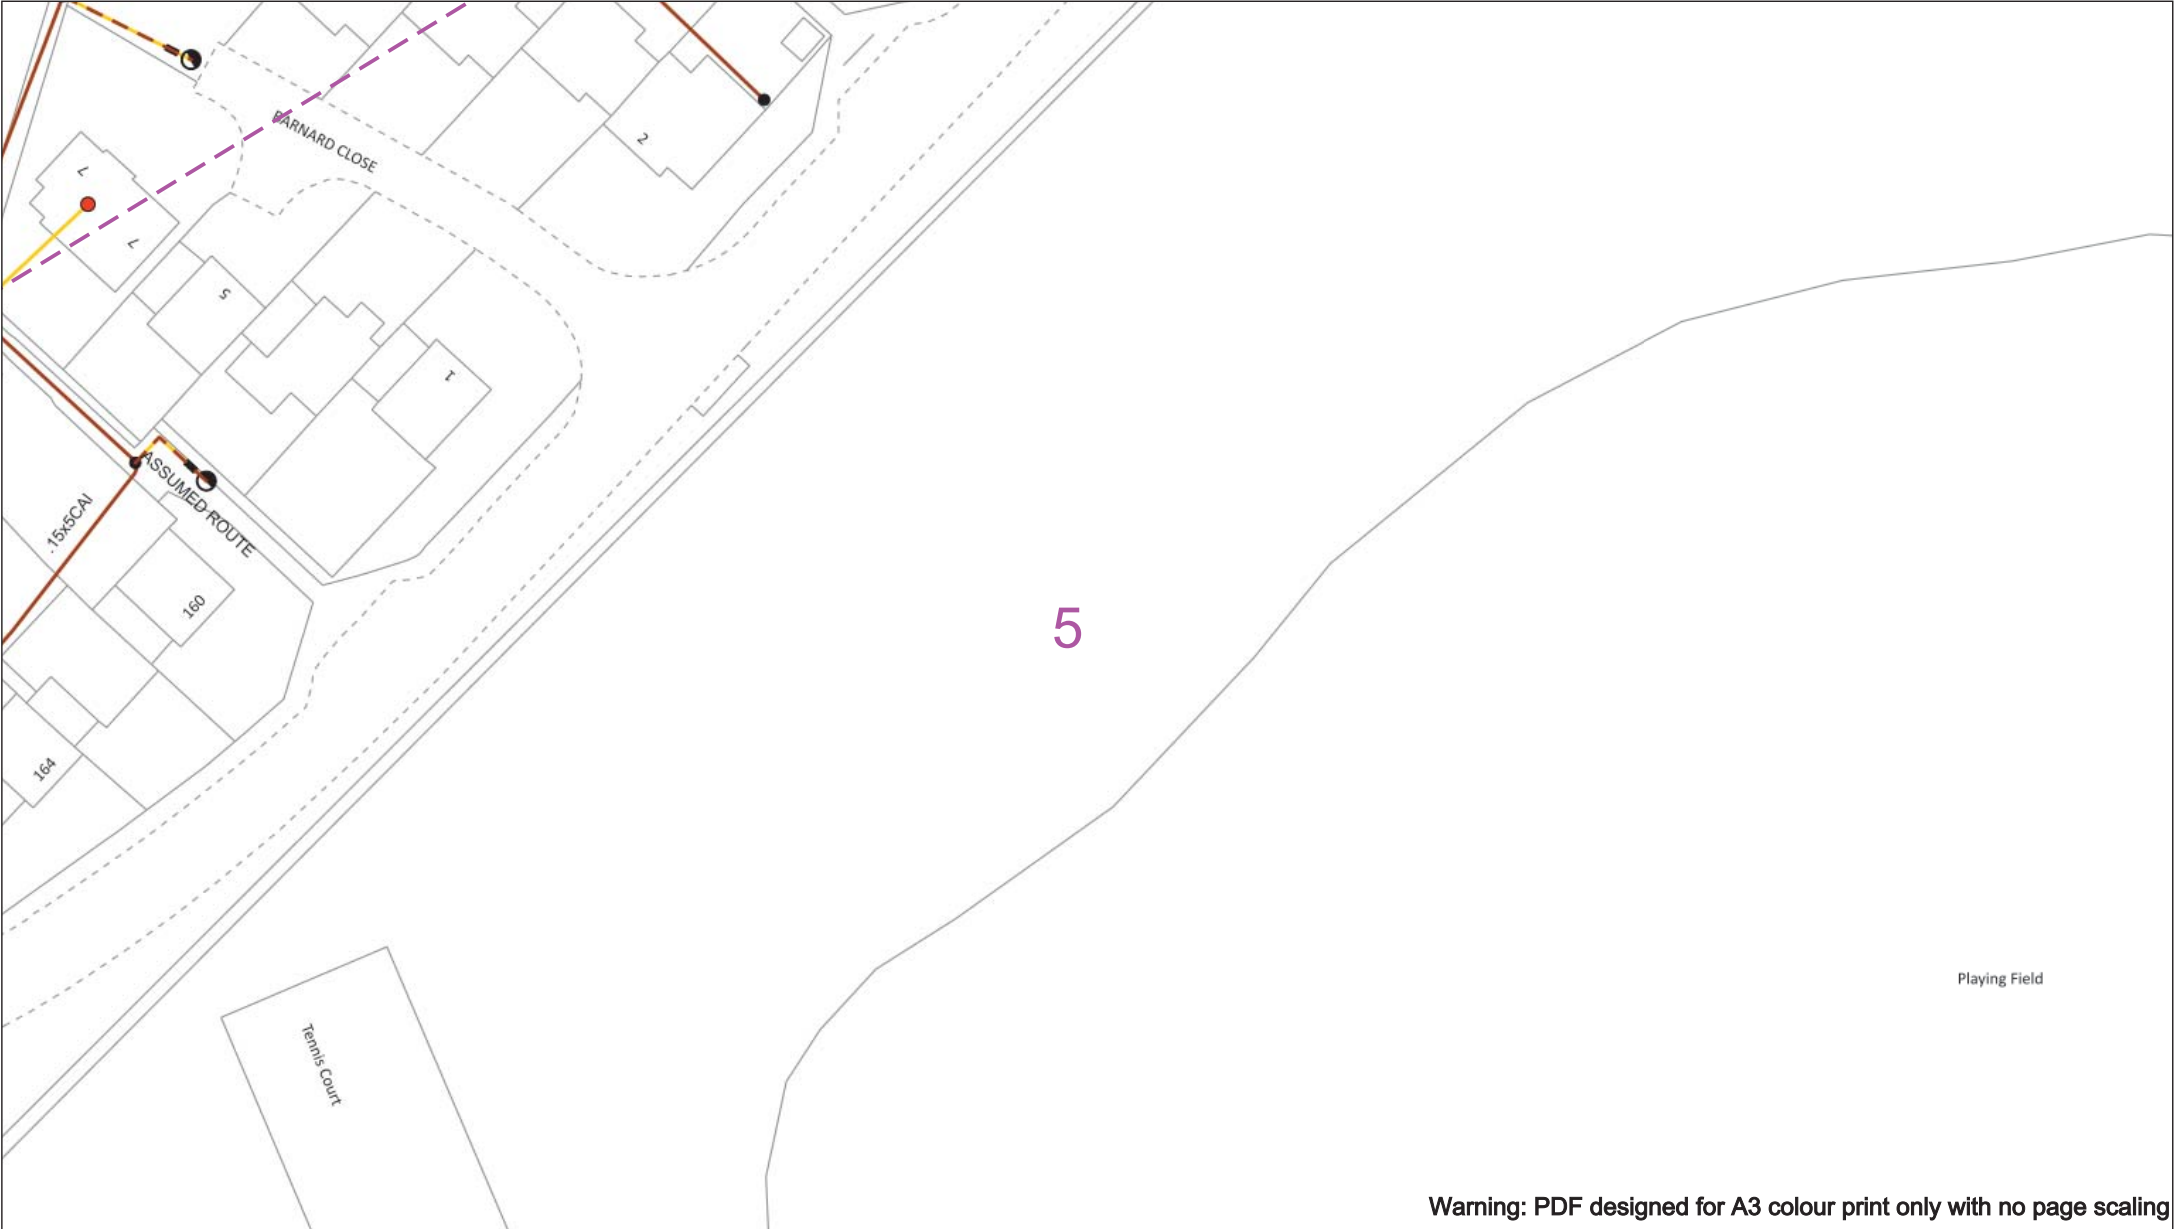

Warning: PDF designed for A3 colour print only with no page scaling

050m

Dig Sites

Area:

Line:

Date Requested: 09/11/2021

Job Reference: 23827726

Site Location: 472556 176139

Requested by: Ms Debbie Wigston

Your Scheme/Reference: 8210940

WARNING

There may have been subsequent alteration to the surface levels. Trial holes must be undertaken to determine position and depths of cables. HS (G) 47 Booklet from the Health and Safety Executive – Avoiding Danger from Buried Cables – should be consulted before commencing excavation work.

WHEN WORKING IN THE VICINITY OF OVERHEAD LINES THE HEALTH AND SAFETY GUIDANCE NOTES GS6 SHOULD BE CONSULTED (AVAILABLE FROM THE HSE WEBSITE)

Voltages (V)

LV (Low Voltage) and Services

Up to 1,000V

HV (High Voltage)

Over 1,000V to 11,000V

EHV (Extra High Voltage)

22,000V to 132,000V

Transmission

275,000V and 400,000V

NORMAL DEPTH TO THE TOP OF THE CABLE WHEN LAID

Services	LV	HV	EHV
Footpath/Unmade	0.45m	0.45m	0.6m
Road Crossing	0.6m	0.6m	0.75m
Agricultural	1m	1m	1.1m

Legend

Service Cable

LV Mains

2 – 3.3kV

6.6kV

11kV

22kV

33kV

66kV

132kV

275kV

400kV

Fibre Optic

Pilot Cable

Distribution Structures (Electric)

Pole, Existing Location

Pole Structure, Existing Location - Single

Pole Structure, Existing Location - H

Duct Route

Cross Section Route

Southern Electric Power Distribution plc

Registered Office: No.1 Forbury Place

43 Forbury Road Reading RG1 3JH

Registered in England & Wales No.04094290

If you're unsure & need to seek advice before commencing excavations please contact:

General Enquiries: 0800 048 3516


Subject to revision – Master held by SSEN Asset Data Team:

Asset.Data@ssen.com

01256 337 294

BASED UPON THE ORDNANCE SURVEY MAP WITH THE SANCTION OF THE CONTROLLER OF H.M STATIONERY OFFICE CROWN COPYRIGHT RESERVED.

This copy has been made by or with the authority of Scottish and Southern Energy Power Distribution Ltd. Pursuant to section 47 of the Copyright, Designs and Patents Act 1988 ('The Act'). Unless the Act provides a relevant exception to copyright the copy must not be copied without prior permission of the copyright owner. Plans generated by DigSAFE Pro™ software provided by LinesearchbeforeUdig.

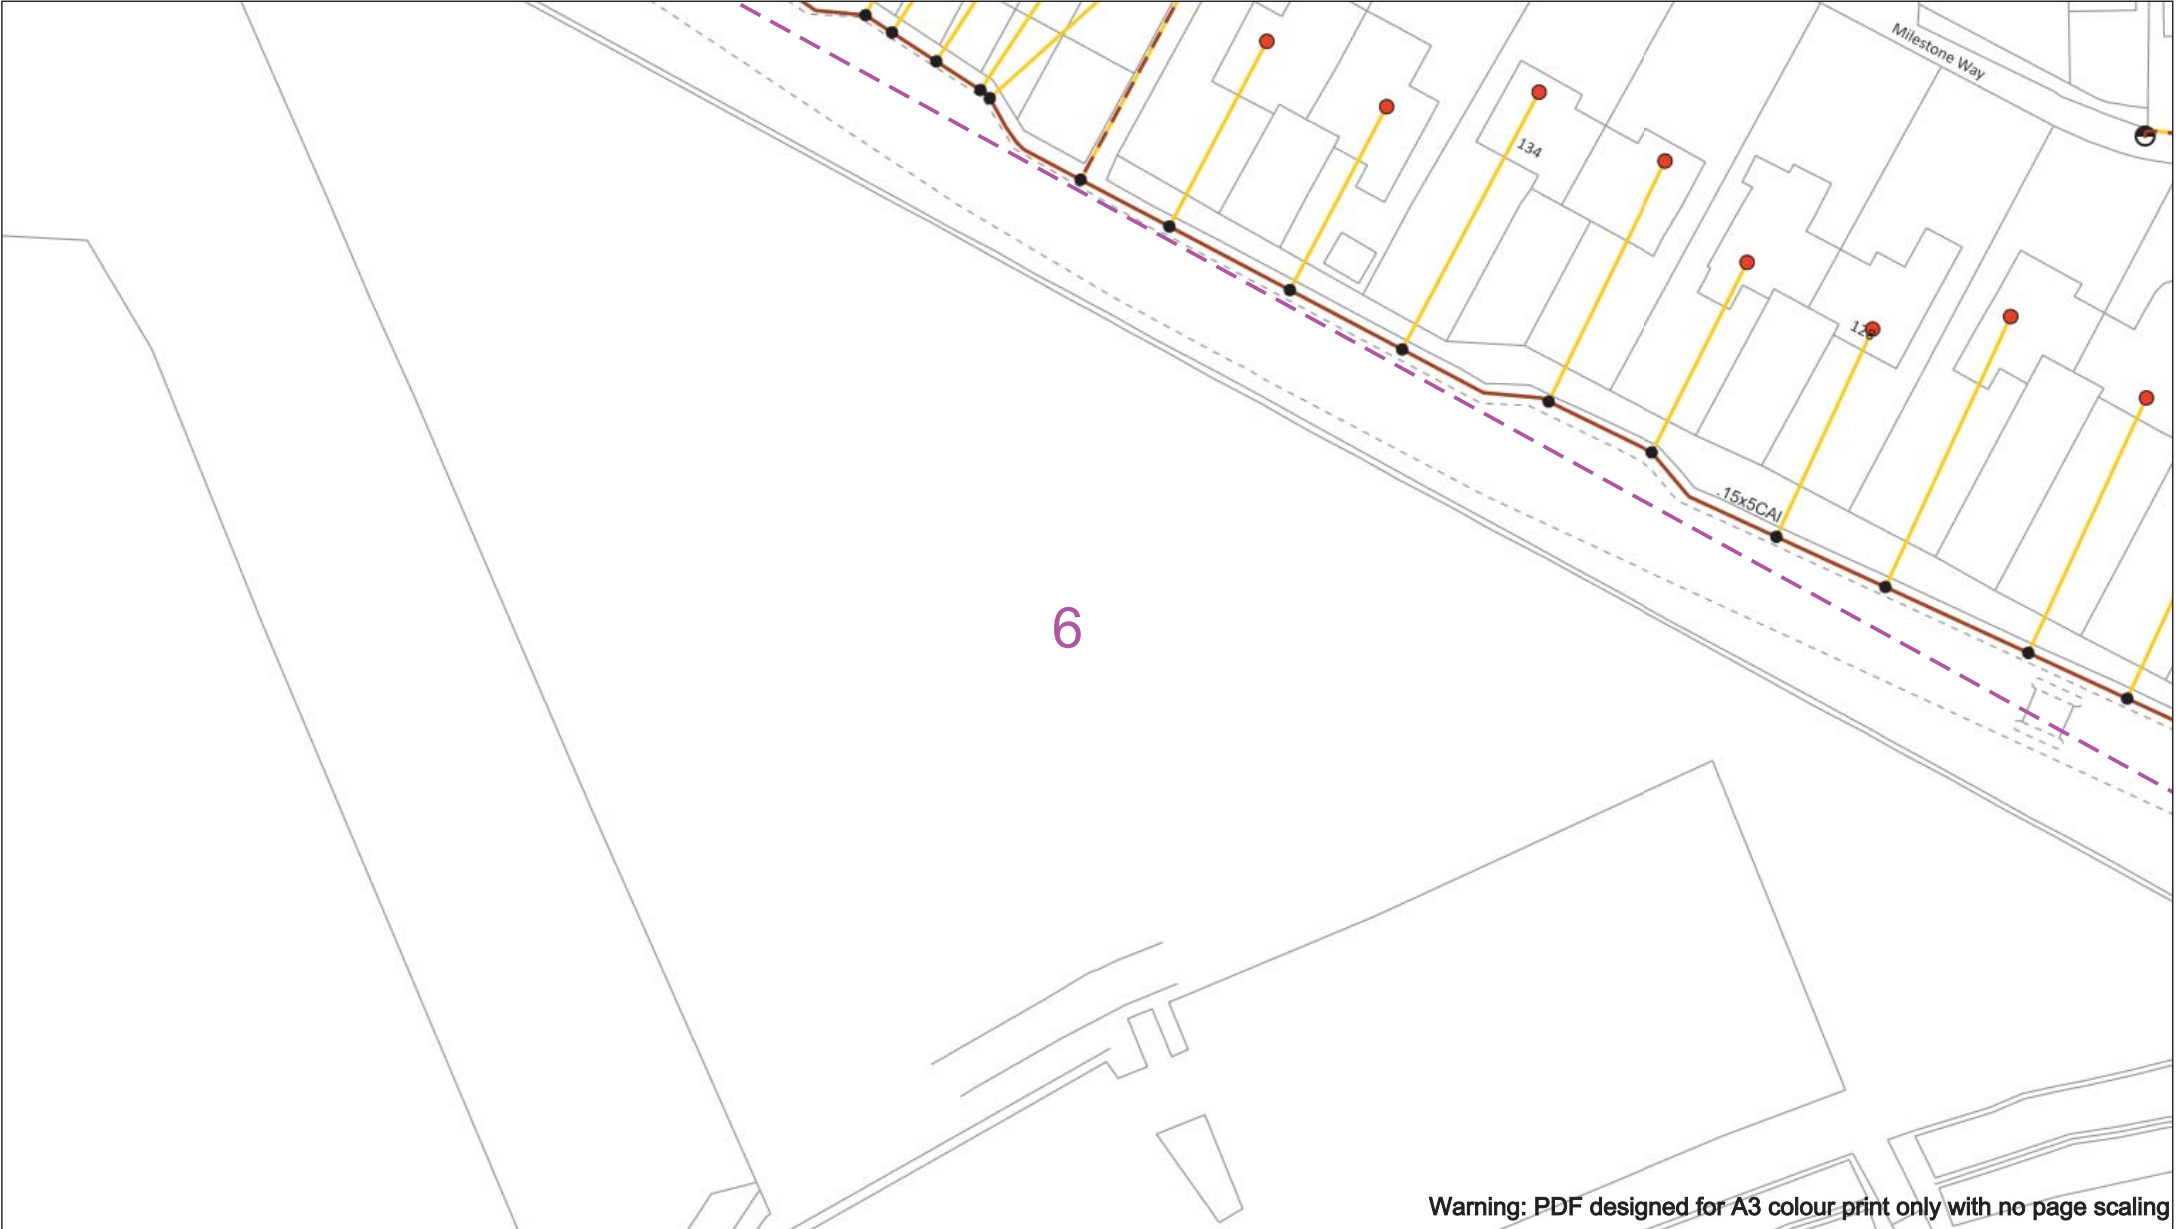

050m

Dig Sites

Area:

Line:

Date Requested: 09/11/2021

Job Reference: 23827726

Site Location: 472556 176139

Requested by: Ms Debbie Wigston

Your Scheme/Reference: 8210940

WARNING

There may have been subsequent alteration to the surface levels. Trial holes must be undertaken to determine position and depths of cables. HS (G) 47 Booklet from the Health and Safety Executive – Avoiding Danger from Buried Cables – should be consulted before commencing excavation work.

WHEN WORKING IN THE VICINITY OF OVERHEAD LINES THE HEALTH AND SAFETY GUIDANCE NOTES GS6 SHOULD BE CONSULTED (AVAILABLE FROM THE HSE WEBSITE)

Voltages (V)				
LV (Low Voltage) and Services	Up to 1,000V			
HV (High Voltage)	Over 1,000V to 11,000V			
EHV (Extra High Voltage)	22,000V to 132,000V			
Transmission	275,000V and 400,000V			

NORMAL DEPTH TO THE TOP OF THE CABLE WHEN LAID				
Services	LV	HV	EHV	
Footpath/Unmade	0.45m	0.45m	0.6m	0.8m
Road Crossing	0.6m	0.6m	0.75m	0.9m
Agricultural	1m	1m	1m	1.1m

Legend

Service Cable

LV Mains

2 – 3.3kV

6.6kV

11kV

22kV

33kV

66kV

132kV

275kV

400kV

Fibre Optic

Pilot Cable

Distribution Structures (Electric)

Pole, Existing Location

Pole Structure, Existing Location - Single

Pole Structure, Existing Location - H

Duct Route

Cross Section Route

Southern Electric Power Distribution plc

Registered Office: No.1 Forbury Place

43 Forbury Road Reading RG1 3JH

Registered in England & Wales No.04094290

If you're unsure & need to seek advice before commencing excavations please contact:

General Enquiries: 0800 048 3516


Subject to revision – Master held by SSEN Asset Data Team:

Asset.Data@ssen.com

01256 337 294

BASED UPON THE ORDNANCE SURVEY MAP WITH THE SANCTION OF THE CONTROLLER OF H.M. STATIONERY OFFICE CROWN COPYRIGHT RESERVED.

This copy has been made by or with the authority of Scottish and Southern Energy Power Distribution Ltd. Pursuant to section 47 of the Copyright, Designs and Patents Act 1988 ('The Act'). Unless the Act provides a relevant exception to copyright the copy must not be copied without prior permission of the copyright owner. Plans generated by DigSAFE Pro™ software provided by LinesearchbeforeUdig.

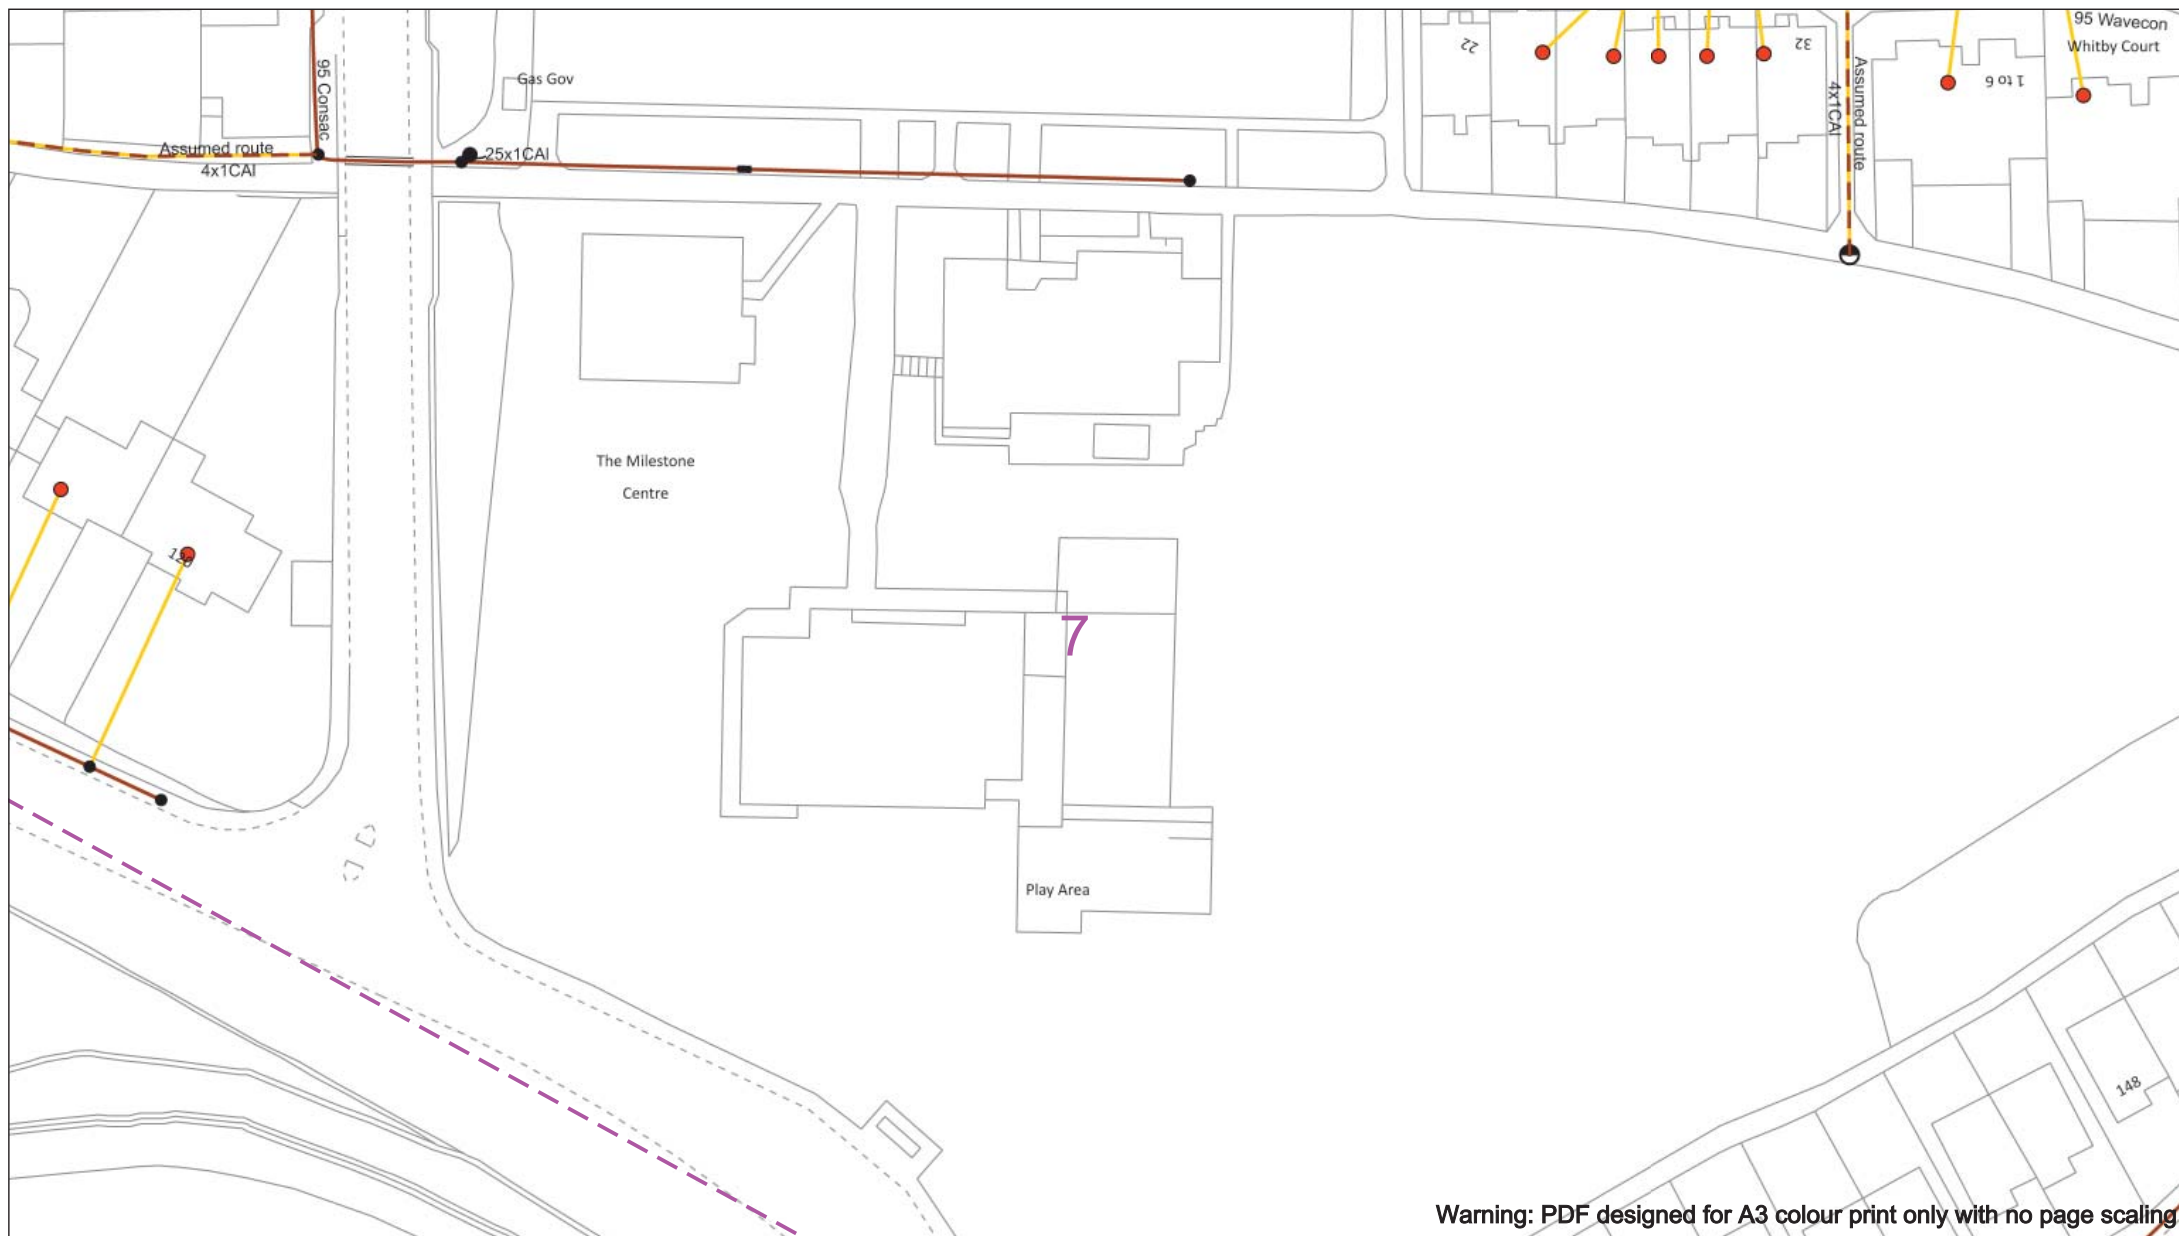

0 50m

Dig Sites Area: Line:

Date Requested: 09/11/2021
Job Reference: 23827726
Site Location: 472556 176139
Requested by:
Ms Debbie Wigston
Your Scheme/Reference: 8210940

WARNING

There may have been subsequent alteration to the surface levels. Trial holes must be undertaken to determine position and depths of cables. HS (G) 47 Booklet from the Health and Safety Executive – Avoiding Danger from Buried Cables – should be consulted before commencing excavation work.

WHEN WORKING IN THE VICINITY OF OVERHEAD LINES THE HEALTH AND SAFETY GUIDANCE NOTES GS6 SHOULD BE CONSULTED (AVAILABLE FROM THE HSE WEBSITE)

Voltages (V)			
LV (Low Voltage) and Services	Up to 1,000V		
HV (High Voltage)	Over 1,000V to 11,000V		
EHV (Extra High Voltage)	22,000V to 132,000V		
Transmission	275,000V and 400,000V		

NORMAL DEPTH TO THE TOP OF THE CABLE WHEN LAID				
	Services	LV	HV	EHV
Footpath/Unmade	0.45m	0.45m	0.6m	0.8m
Road Crossing	0.6m	0.6m	0.75m	0.9m
Agricultural	1m	1m	1m	1.1m

Legend

- Service Cable
- LV Mains
- 2 – 3.3kV
- 6.6kV
- 11kV
- 22kV
- 33kV
- 66kV
- 132kV
- 275kV
- 400kV
- Fibre Optic
- Pile Cable

Distribution Structures (Electric)

- Pole, Existing Location
- Pole Structure, Existing Location - Single
- Pole Structure, Existing Location - H
- Duct Route
- Cross Section Route


Southern Electric Power Distribution plc
Registered Office: No.1 Forbury Place
43 Forbury Road Reading RG1 3JH
Registered in England & Wales No.04094290

If you're unsure & need to seek advice before commencing excavations please contact:
General Enquiries: 0800 048 3516

Subject to revision – Master held by SSEN Asset Data Team:
Asset.Data@ssen.com
01256 337 294

BASED UPON THE ORDNANCE SURVEY MAP WITH THE SANCTION OF THE CONTROLLER OF H.M STATIONERY OFFICE CROWN COPYRIGHT RESERVED.

This copy has been made by or with the authority of Scottish and Southern Energy Power Distribution Ltd. Pursuant to section 47 of the Copyright, Designs and Patents Act 1988 ('The Act'). Unless the Act provides a relevant exception to copyright the copy must not be copied without prior permission of the copyright owner. Plans generated by DigSAFE Pro™ software provided by LinesearchbeforeUdig.

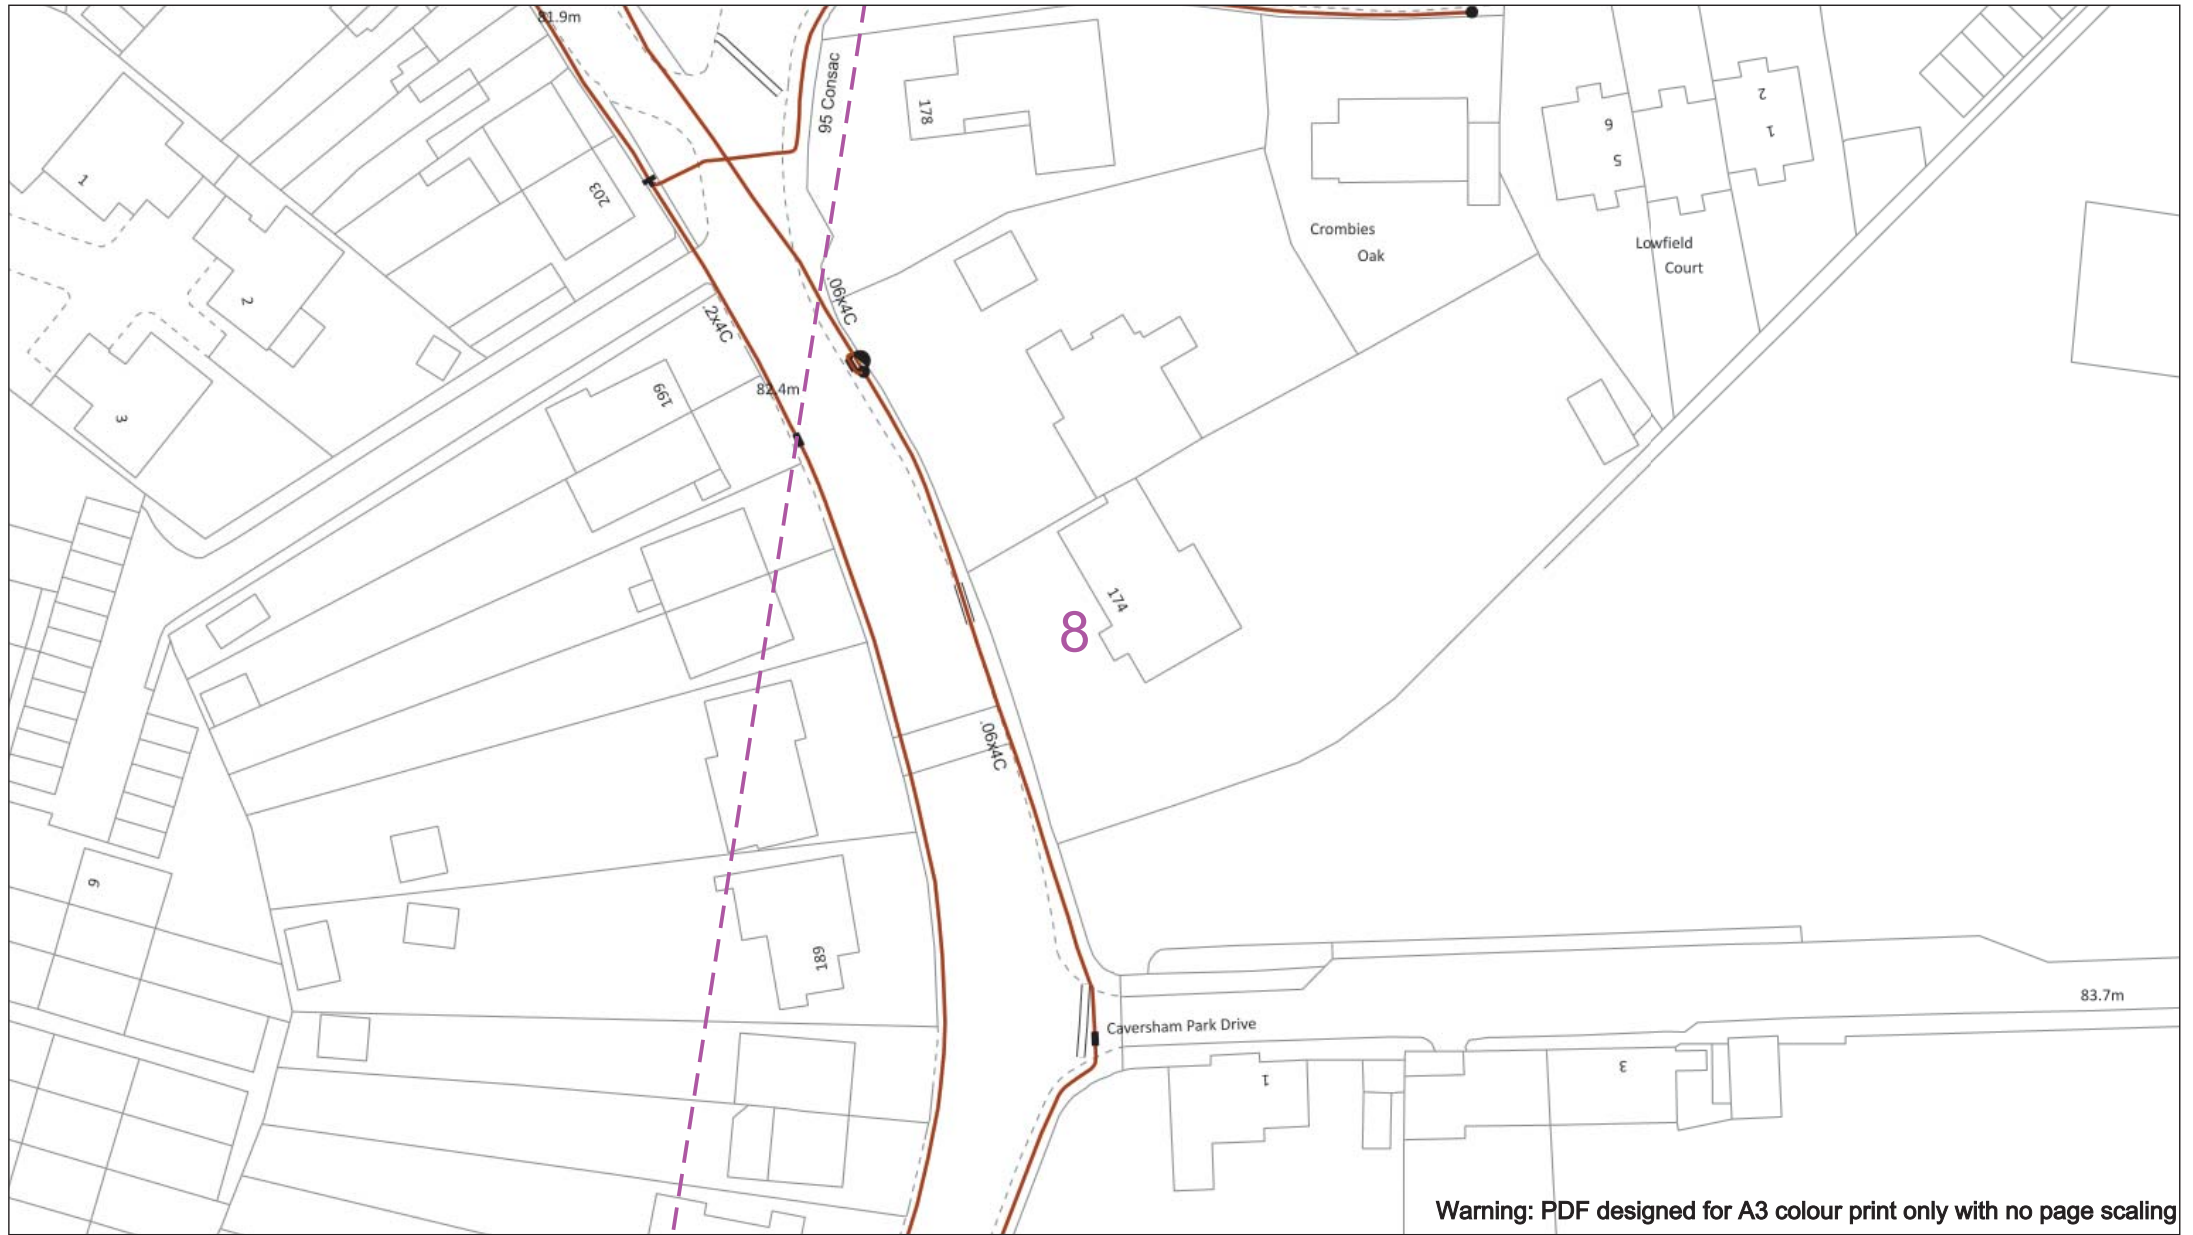

050m

Dig Sites

Area:

Line:

Date Requested: 09/11/2021

Job Reference: 23827726

Site Location: 472556 176139

Requested by: Ms Debbie Wigston

Your Scheme/Reference: 8210940

WARNING

There may have been subsequent alteration to the surface levels. Trial holes must be undertaken to determine position and depths of cables. HS (G) 47 Booklet from the Health and Safety Executive – Avoiding Danger from Buried Cables – should be consulted before commencing excavation work.

WHEN WORKING IN THE VICINITY OF OVERHEAD LINES THE HEALTH AND SAFETY GUIDANCE NOTES GS6 SHOULD BE CONSULTED (AVAILABLE FROM THE HSE WEBSITE)

Voltages (V)				
LV (Low Voltage) and Services	Up to 1,000V			
LV Mains	Over 1,000V to 11,000V			
EHV (Extra High Voltage)	22,000V to 132,000V			
Transmission	275,000V and 400,000V			

NORMAL DEPTH TO THE TOP OF THE CABLE WHEN LAID				
Services	LV	LV	EHV	EHV
Footpath/Unmade	0.45m	0.45m	0.6m	0.8m
Road Crossing	0.6m	0.6m	0.75m	0.9m
Agricultural	1m	1m	1m	1.1m

Legend

Service Cable

LV Mains

2 – 3.3kV

6.6kV

11kV

22kV

33kV

66kV

132kV

275kV

400kV

Fibre Optic

Pilot Cable

Distribution Structures (Electric)

Pole, Existing Location

Pole Structure, Existing Location - Single

Pole Structure, Existing Location - H

Duct Route

Cross Section Route


Southern Electric Power Distribution plc
Registered Office: No.1 Forbury Place
43 Forbury Road Reading RG1 3JH
Registered in England & Wales No.04094290

If you're unsure & need to seek advice before commencing excavations please contact:
General Enquiries: 0800 048 3516

Subject to revision – Master held by SSEN Asset Data Team:
AssetData@ssen.com
01256 337 294

BASED UPON THE ORDNANCE SURVEY MAP WITH THE SANCTION OF THE CONTROLLER OF H.M STATIONERY OFFICE CROWN COPYRIGHT RESERVED.

This copy has been made by or with the authority of Scottish and Southern Energy Power Distribution Ltd. Pursuant to section 47 of the Copyright, Designs and Patents Act 1988 ('The Act'). Unless the Act provides a relevant exception to copyright the copy must not be copied without prior permission of the copyright owner. Plans generated by DigSAFE Pro™ software provided by LinesearchbeforeUdig.

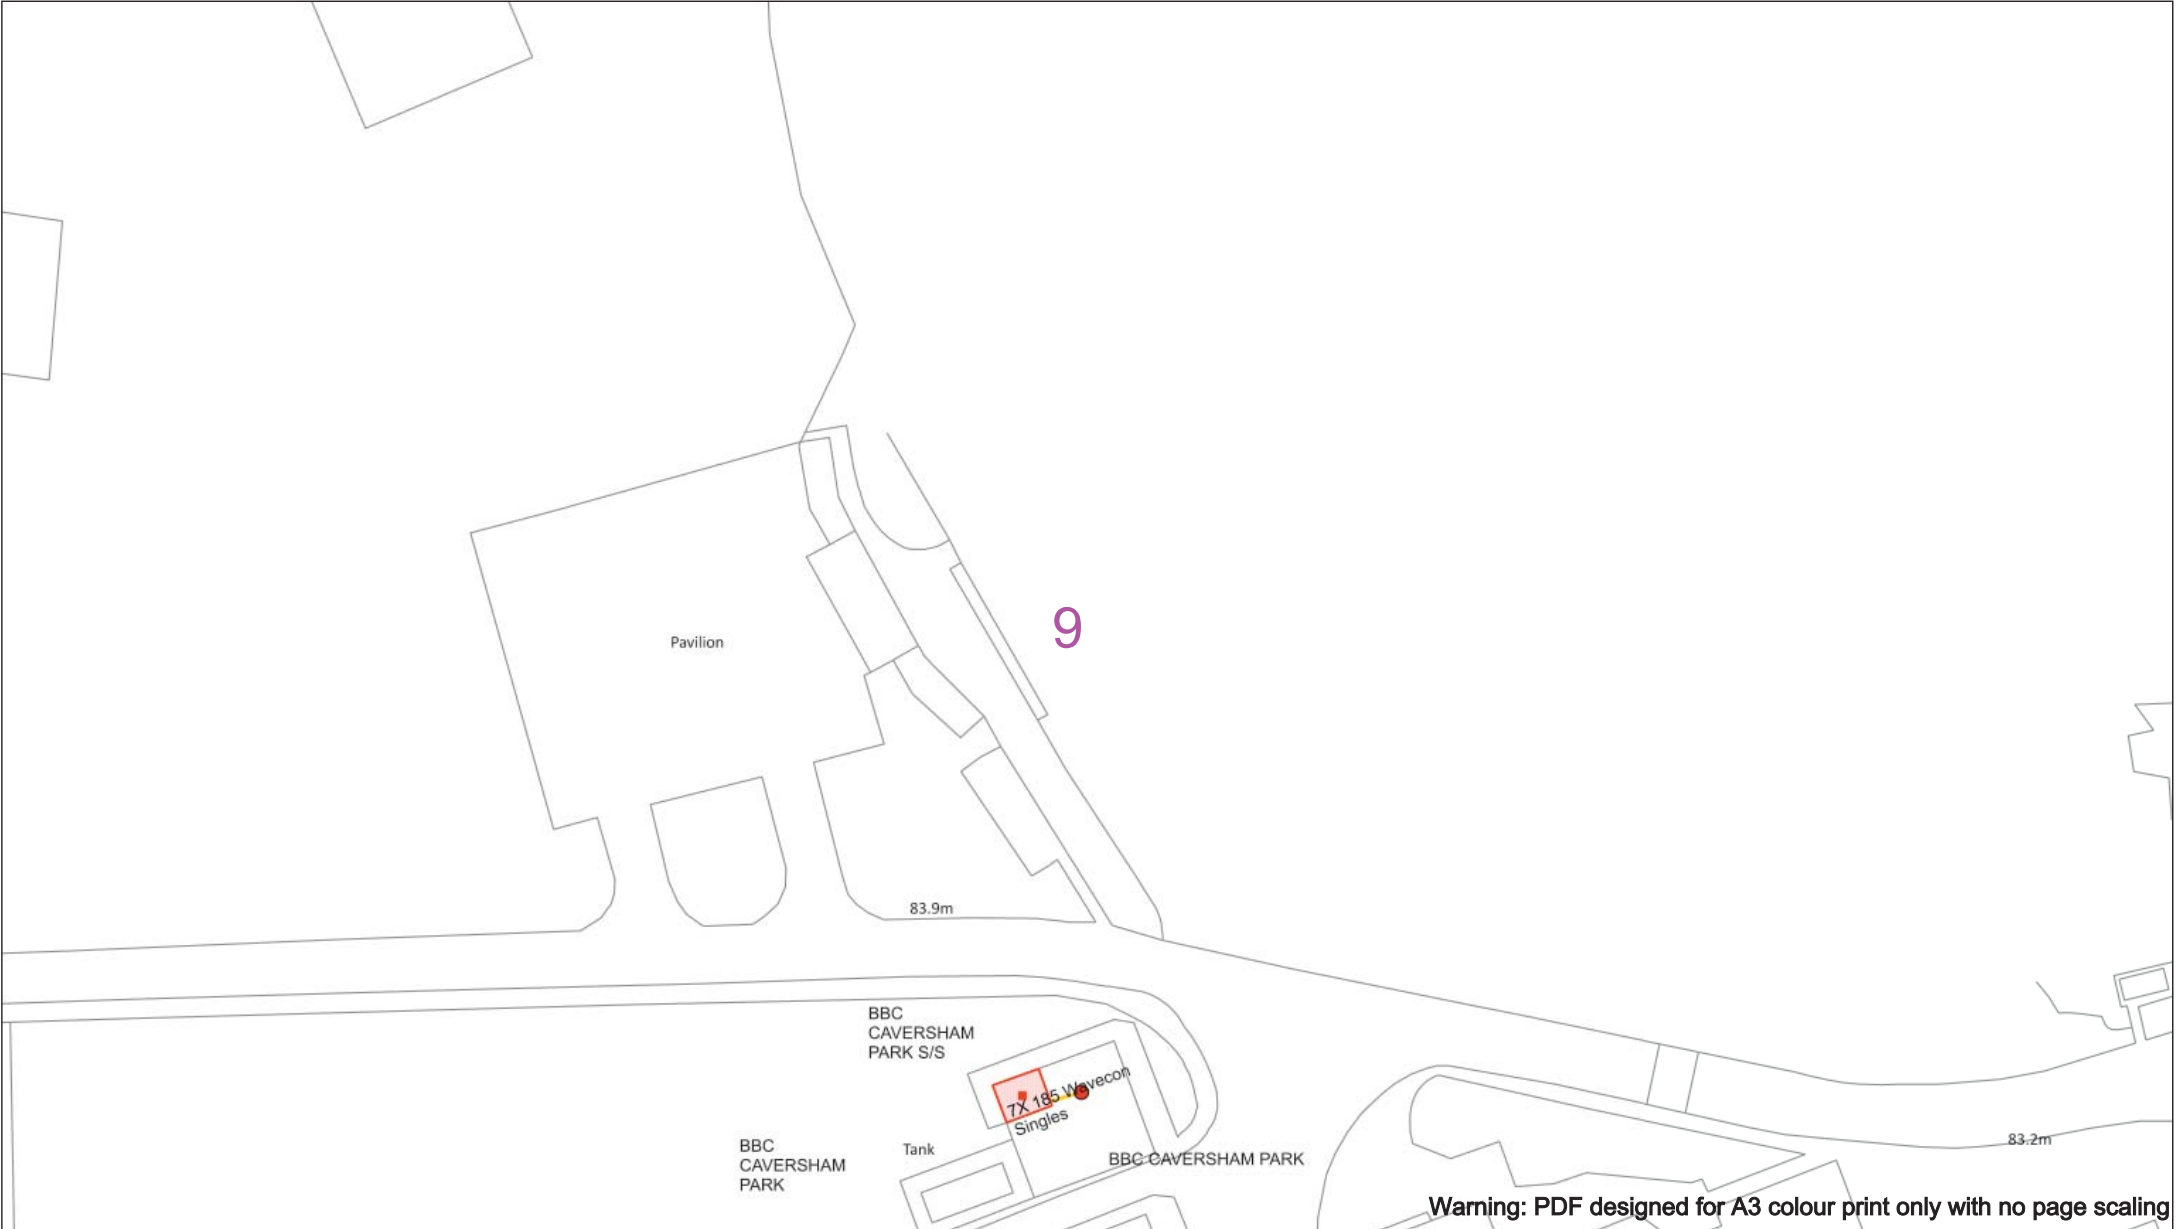

050m

Dig Sites

Area:

Line:

Date Requested: 09/11/2021

Job Reference: 23827726

Site Location: 472556 176139

Requested by: Ms Debbie Wigston

Your Scheme/Reference: 8210940

WARNING

There may have been subsequent alteration to the surface levels. Trial holes must be undertaken to determine position and depths of cables. HS (G) 47 Booklet from the Health and Safety Executive – Avoiding Danger from Buried Cables – should be consulted before commencing excavation work.

WHEN WORKING IN THE VICINITY OF OVERHEAD LINES THE HEALTH AND SAFETY GUIDANCE NOTES GS6 SHOULD BE CONSULTED (AVAILABLE FROM THE HSE WEBSITE)

Voltages (V)				
LV (Low Voltage) and Services	Up to 1,000V			
HV (High Voltage)	Over 1,000V to 11,000V			
EHV (Extra High Voltage)	22,000V to 132,000V			
Transmission	275,000V and 400,000V			

NORMAL DEPTH TO THE TOP OF THE CABLE WHEN LAID				
Services	LV	HV	EHV	
Footpath/Unmade	0.45m	0.45m	0.6m	0.8m
Road Crossing	0.6m	0.6m	0.75m	0.9m
Agricultural	1m	1m	1m	1.1m

Legend

Service Cable

LV Mains

2 – 3.3kV

6.6kV

11kV

22kV

33kV

66kV

132kV

275kV

400kV

Fibre Optic

Pilot Cable

Distribution Structures (Electric)

Pole, Existing Location

Pole Structure, Existing Location - Single

Pole Structure, Existing Location - H

Duct Route

Cross Section Route

Southern Electric Power Distribution plc

Registered Office: No.1 Forbury Place

43 Forbury Road Reading RG1 3JH

Registered in England & Wales No.04094290

If you're unsure & need to seek advice before commencing excavations please contact:

General Enquiries: 0800 048 3516

Subject to revision – Master held by SS&N Asset Data Team:

Asset.Data@ssn.com

01256 337 294

BASED UPON THE ORDNANCE SURVEY MAP WITH THE SANCTION OF THE CONTROLLER OF H.M STATIONERY OFFICE CROWN COPYRIGHT RESERVED.

This copy has been made by or with the authority of Scottish and Southern Energy Power Distribution Ltd. Pursuant to section 47 of the Copyright, Designs and Patents Act 1988 ('The Act'). Unless the Act provides a relevant exception to copyright the copy must not be copied without prior permission of the copyright owner. Plans generated by DigSAFE Pro™ software provided by LinesearchbeforeUdig.



Warning: PDF designed for A3 colour print only with no page scaling



Scale: 1:500 (When plotted at A3)

Legend

- Service Cable
- LV Mains
- 2 – 3.3kV
- 6.6kV
- 11kV
- 22kV
- 33kV
- 66kV
- 132kV
- 275kV
- 400kV
- Fibre Optic
- Pilot Cable

- Distribution Structures [Electric]
 - Pole, Existing Location
 - Pole Structure, Existing Location - Single
 - Pole Structure, Existing Location - H
- Duct Route
- Cross Section Route



Subject to revision – Master held by SSEN Asset Data Team:
Asset.Data@sse.com
 01256 337 294

This copy has been made by or with the authority of Scottish and Southern Energy Power Distribution Ltd. Pursuant to section 47 of the Copyright, Designs and Patents Act 1988 ('The Act'). Unless the Act provides a relevant exception to copyright the copy must not be copied without prior permission of the copyright owner. Plans generated by DigSAFE Pro™ software provided by LinesearchbeforeUdig.



Warning: PDF designed for A3 colour print only with no page scaling

0

50m

Dig Sites

Area:

Line:

Date Requested: 09/11/2021

Job Reference: 23827726

Site Location: 472556 176139

Requested by:
Ms Debbie Wigston

Your Scheme/Reference: 8210940

WARNING

There may have been subsequent alteration to the surface levels. Trial holes must be undertaken to determine position and depths of cables. HS (G) 47 Booklet from the Health and Safety Executive – Avoiding Danger from Buried Cables – should be consulted before commencing excavation work.

WHEN WORKING IN THE VICINITY OF OVERHEAD LINES THE HEALTH AND SAFETY GUIDANCE NOTES GS6 SHOULD BE CONSULTED (AVAILABLE FROM THE HSE WEBSITE)

Voltages (V)				
LV (Low Voltage) and Services	Up to 1,000V			
HV (High Voltage)	Over 1,000V to 11,000V			
EHV (Extra High Voltage)	22,000V to 132,000V			
Transmission	275,000V and 400,000V			

NORMAL DEPTH TO THE TOP OF THE CABLE WHEN LAID				
Services	LV	HV	EHV	
Footpath/Unmade	0.45m	0.45m	0.6m	0.8m
Road Crossing	0.6m	0.6m	0.75m	0.9m
Agricultural	1m	1m	1m	1.1m

Legend

Service Cable

LV Mains

2 – 3.3kV

6.6kV

11kV

22kV

33kV

66kV

132kV

275kV

400kV

Fibre Optic

Pilot Cable

Distribution Structures (Electric)

Pole, Existing Location

Pole Structure, Existing Location - Single

Pole Structure, Existing Location - H

Duct Route

Cross Section Route

Southern Electric Power Distribution plc
Registered Office: No.1 Forbury Place
43 Forbury Road Reading RG1 3JH
Registered in England & Wales No.04094290

If you're unsure & need to seek advice before commencing excavations please contact:
General Enquiries: 0800 048 3516

Subject to revision – Master held by SSEN Asset Data Team:
AssetData@sse.com
01256 337 294

BASED UPON THE ORDNANCE SURVEY MAP WITH THE SANCTION OF THE CONTROLLER OF H.M. STATIONERY OFFICE CROWN COPYRIGHT RESERVED.
This copy has been made by or with the authority of Scottish and Southern Energy Power Distribution Ltd. Pursuant to section 47 of the Copyright, Designs and Patents Act 1988 ('The Act'). Unless the Act provides a relevant exception to copyright the copy must not be copied without prior permission of the copyright owner. Plans generated by DigSAFE Pro™ software provided by LinesearchbeforeUdig.



WARNING

WHEN WORKING IN THE VICINITY OF OVERHEAD LINES THE HEALTH AND SAFETY GUIDANCE NOTES GS6 SHOULD BE CONSULTED (AVAILABLE FROM THE HSE WEBSITE)

	Voltages (V)
LV (Low Voltage) and Services	Up to 1,000V
HV (High Voltage)	Over 1,000V to 11,000V
EHV (Extra High Voltage)	22,000V to 132,000V
Transmission	275,000V and 400,000V

Legend

- Service Cable
- LV Mains
- 2 – 3.3kV
- 6.6kV
- 11kV
- 22kV
- 33kV
- 66kV
- 132kV
- 275kV
- 400kV
- Fibre Optic
- Pilot Cable


Southern Electric Power Distribution plc
Registered Office: No.1 Forbury Place
43 Forbury Road Reading RG1 3JH
Registered In England & Wales No.04094290

If you're unsure & need to seek advice before commencing excavations please contact:
General Enquiries: 0800 048 3516

Subject to revision – Master held by SSEN Asset Data Team:
Asset.Data@sse.com
 01256 337 294

BASED UPON THE ORDNANCE SURVEY MAP WITH THE SANCTION OF THE CONTROLLER OF H.M. STATIONERY OFFICE CROWN COPYRIGHT RESERVED

This copy has been made by or with the authority of Scottish and Southern Energy Power Distribution Ltd. Pursuant to section 47 of the Copyright, Designs and Patents Act 1988 ('The Act'). Unless the Act provides a relevant exception to copyright the copy must not be copied without prior permission of the copyright owner. Plans generated by DigSAFE Pro™ software provided by LinesearchbeforeUdig.

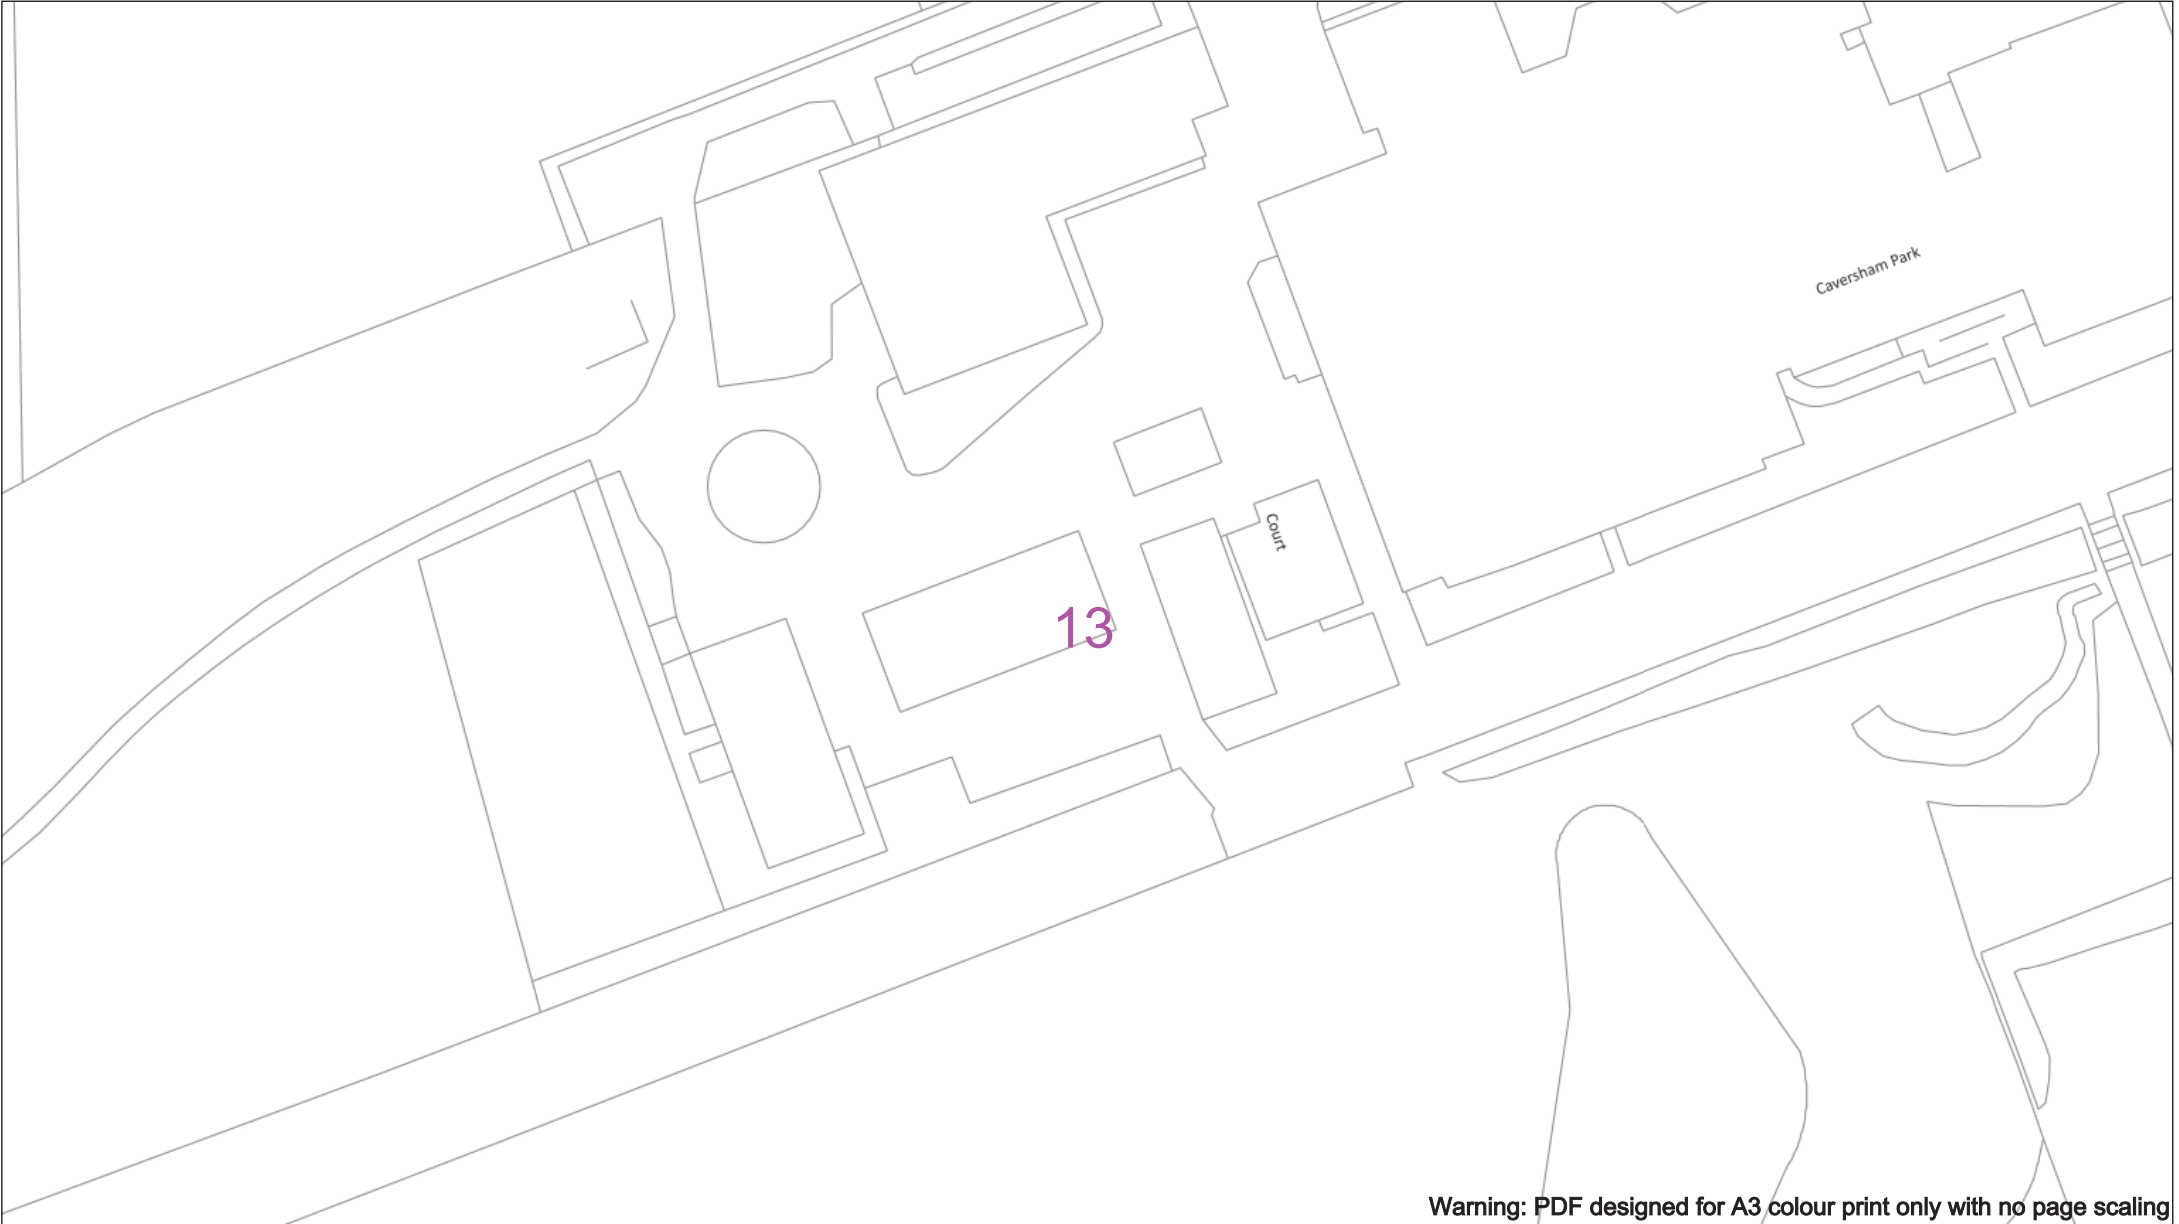

050m

Dig Sites

Area:

Line:

Date Requested: 09/11/2021

Job Reference: 23827726

Site Location: 472556 176139

Requested by: Ms Debbie Wigston

Your Scheme/Reference: 8210940

WARNING

There may have been subsequent alteration to the surface levels. Trial holes must be undertaken to determine position and depths of cables. HS (G) 47 Booklet from the Health and Safety Executive – Avoiding Danger from Buried Cables – should be consulted before commencing excavation work.

WHEN WORKING IN THE VICINITY OF OVERHEAD LINES THE HEALTH AND SAFETY GUIDANCE NOTES GS6 SHOULD BE CONSULTED (AVAILABLE FROM THE HSE WEBSITE)

Voltages (V)

LV (Low Voltage) and Services	Up to 1,000V
HV (High Voltage)	Over 1,000V to 11,000V
EHV (Extra High Voltage)	22,000V to 132,000V
Transmission	275,000V and 400,000V

NORMAL DEPTH TO THE TOP OF THE CABLE WHEN LAID

Services	LV	HV	EHV
Footpath/Unmade	0.45m	0.45m	0.6m
Road Crossing	0.6m	0.6m	0.75m
Agricultural	1m	1m	1.1m

Service Cable

LV Mains

2 – 3.3kV

6.6kV

11kV

22kV

33kV

66kV

132kV

275kV

400kV

Fibre Optic

Pile Cable

Pole, Existing Location

Pole Structure, Existing Location - Single

Pole Structure, Existing Location - H

Duct Route

Cross Section Route


Southern Electric Power Distribution plc
Registered Office: No.1 Forbury Place
43 Forbury Road Reading RG1 3JH
Registered in England & Wales No.04094290

If you're unsure & need to seek advice before commencing excavations please contact:
General Enquiries: 0800 048 3516

Subject to revision – Master held by SSEN Asset Data Team:
AssetData@se.com
01256 337 294

BASED UPON THE ORDNANCE SURVEY MAP WITH THE SANCTION OF THE CONTROLLER OF H.M STATIONERY OFFICE CROWN COPYRIGHT RESERVED.

This copy has been made by or with the authority of Scottish and Southern Energy Power Distribution Ltd. Pursuant to section 47 of the Copyright, Designs and Patents Act 1988 ('The Act'). Unless the Act provides a relevant exception to copyright the copy must not be copied without prior permission of the copyright owner. Plans generated by DigSAFE Pro™ software provided by LinesearchbeforeUdig.

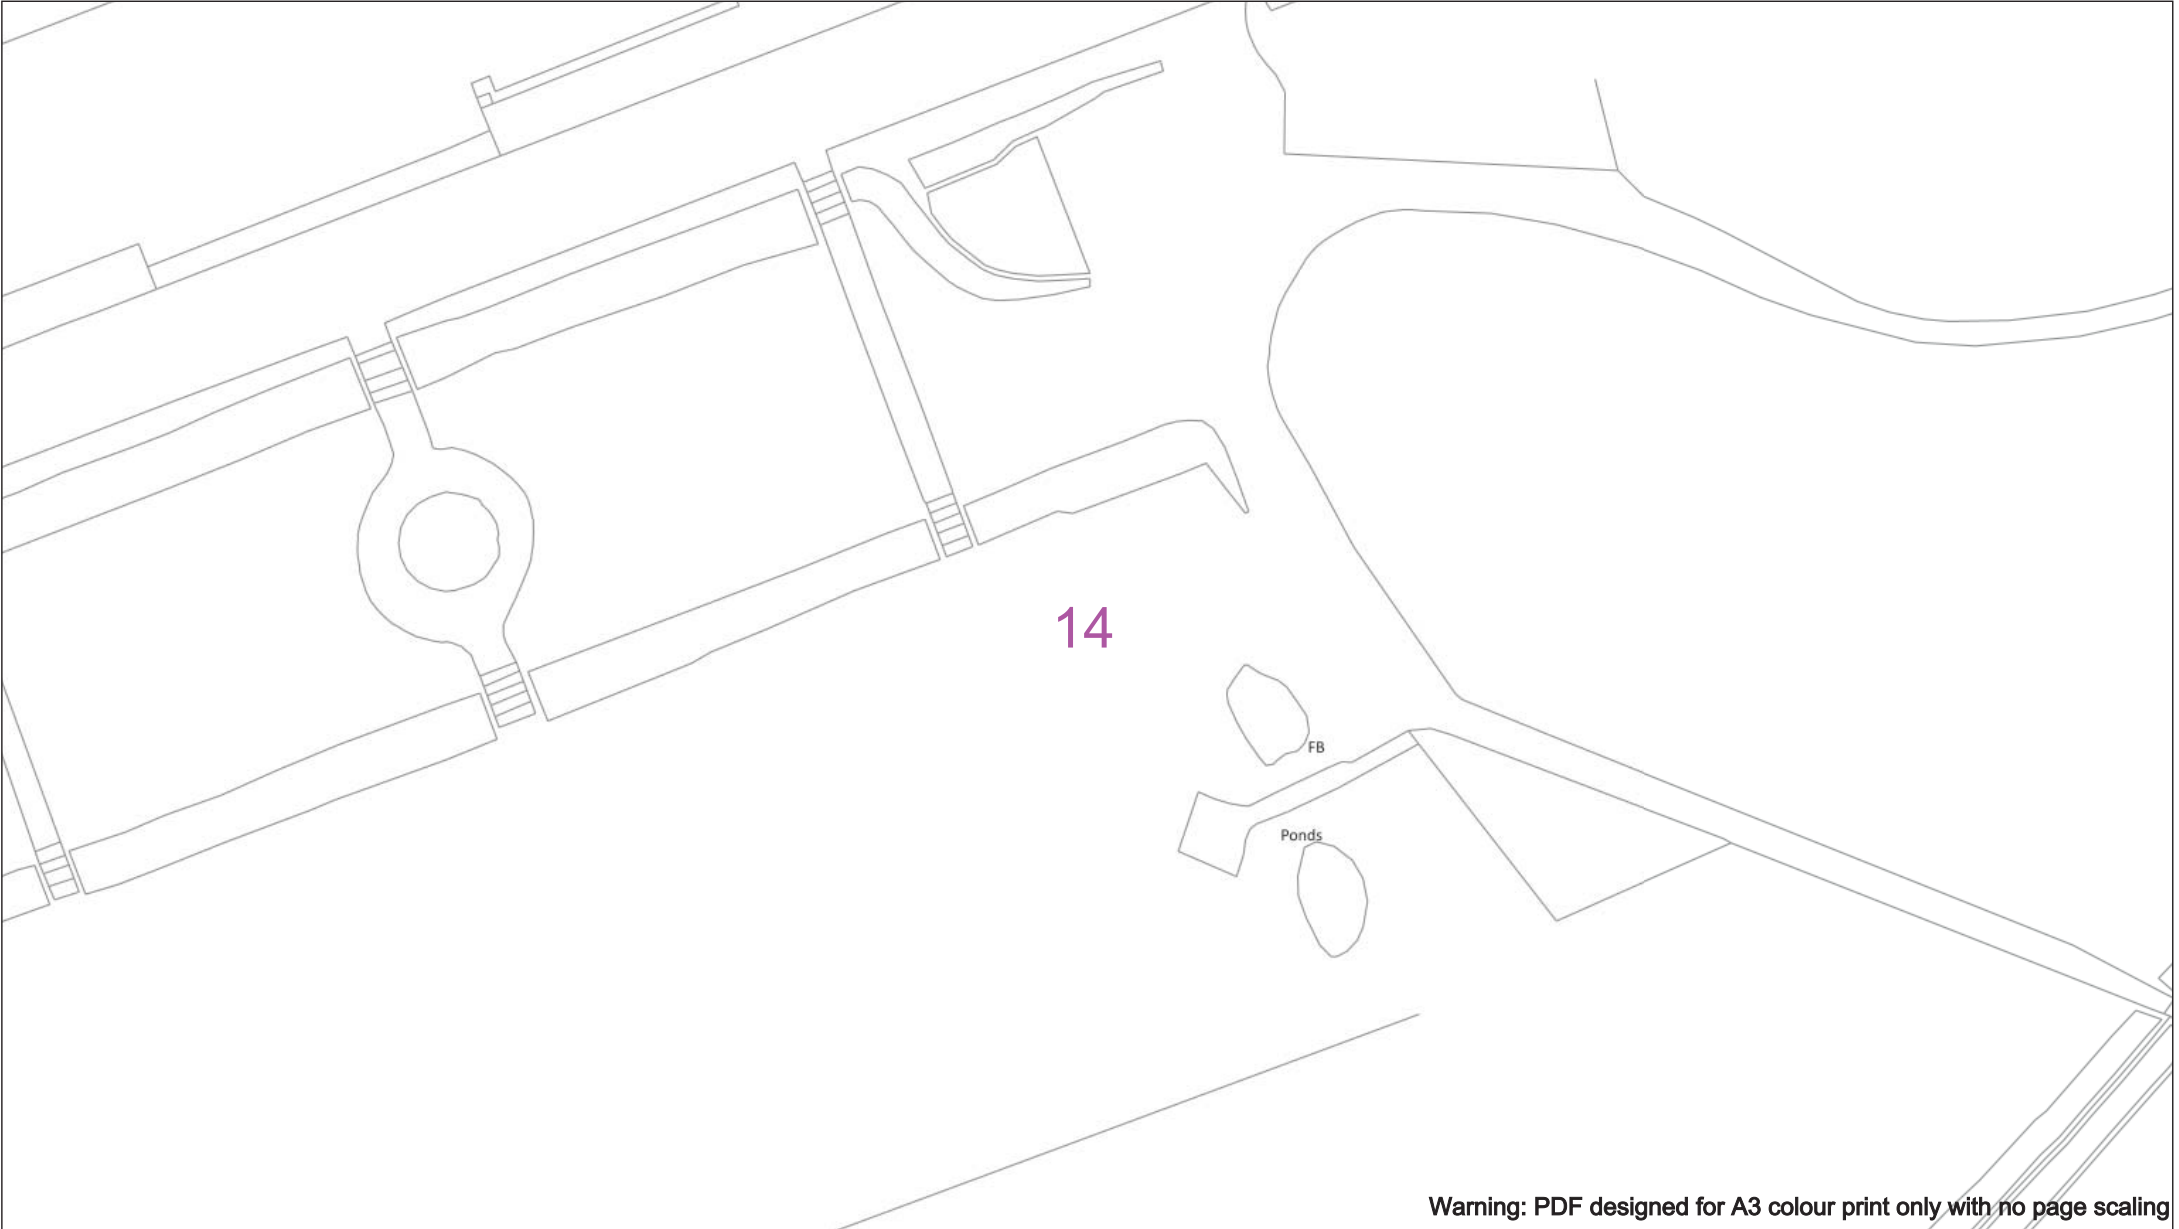

Warning: PDF designed for A3 colour print only with no page scaling

050m

Dig Sites

Area: 

Line: 

Date Requested: 09/11/2021

Job Reference: 23827726

Site Location: 472556 176139

Requested by: Ms Debbie Wigston

Your Scheme/Reference: 8210940

WARNING

There may have been subsequent alteration to the surface levels. Trial holes must be undertaken to determine position and depths of cables. HS (G) 47 Booklet from the Health and Safety Executive – Avoiding Danger from Buried Cables – should be consulted before commencing excavation work.

WHEN WORKING IN THE VICINITY OF OVERHEAD LINES THE HEALTH AND SAFETY GUIDANCE NOTES GS6 SHOULD BE CONSULTED (AVAILABLE FROM THE HSE WEBSITE)

Voltages (V)

LV (Low Voltage) and Services Up to 1,000V

HV (High Voltage) Over 1,000V to 11,000V

EHV (Extra High Voltage) 22,000V to 132,000V

Transmission 275,000V and 400,000V

NORMAL DEPTH TO THE TOP OF THE CABLE WHEN LAID

	Services	LV	HV	EHV
Footpath/Unmade	0.45m	0.45m	0.6m	0.8m
Road Crossing	0.6m	0.6m	0.75m	0.9m
Agricultural	1m	1m	1m	1.1m

Legend

 Service Cable

 LV Mains

 2 – 3.3kV

 6.6kV

 11kV

 132kV

 275kV

 400kV

 Fibre Optic

 Pipe Cable

Distribution Structures (Electric)

 Pole, Existing Location

 Pole Structure, Existing Location - Single

 Pole Structure, Existing Location - H

 Duct Route

 Cross Section Route



Southern Electric Power Distribution plc

Registered Office: No.1 Forbury Place

43 Forbury Road Reading RG1 3JH

Registered in England & Wales No.04094290

If you're unsure & need to seek advice before commencing excavations please contact:

General Enquiries: 0800 048 3516


Subject to revision – Master held by SSAN Asset Data Team:

Asset.Data@se.com

01256 337 294

BASED UPON THE ORDNANCE SURVEY MAP WITH THE SANCTION OF THE CONTROLLER OF H.M STATIONERY OFFICE CROWN COPYRIGHT RESERVED.

This copy has been made by or with the authority of Scottish and Southern Energy Power Distribution Ltd. Pursuant to section 47 of the Copyright, Designs and Patents Act 1988 ('The Act'). Unless the Act provides a relevant exception to copyright the copy must not be copied without prior permission of the copyright owner. Plans generated by DigSAFE Pro™ software provided by LinesearchbeforeUdig.

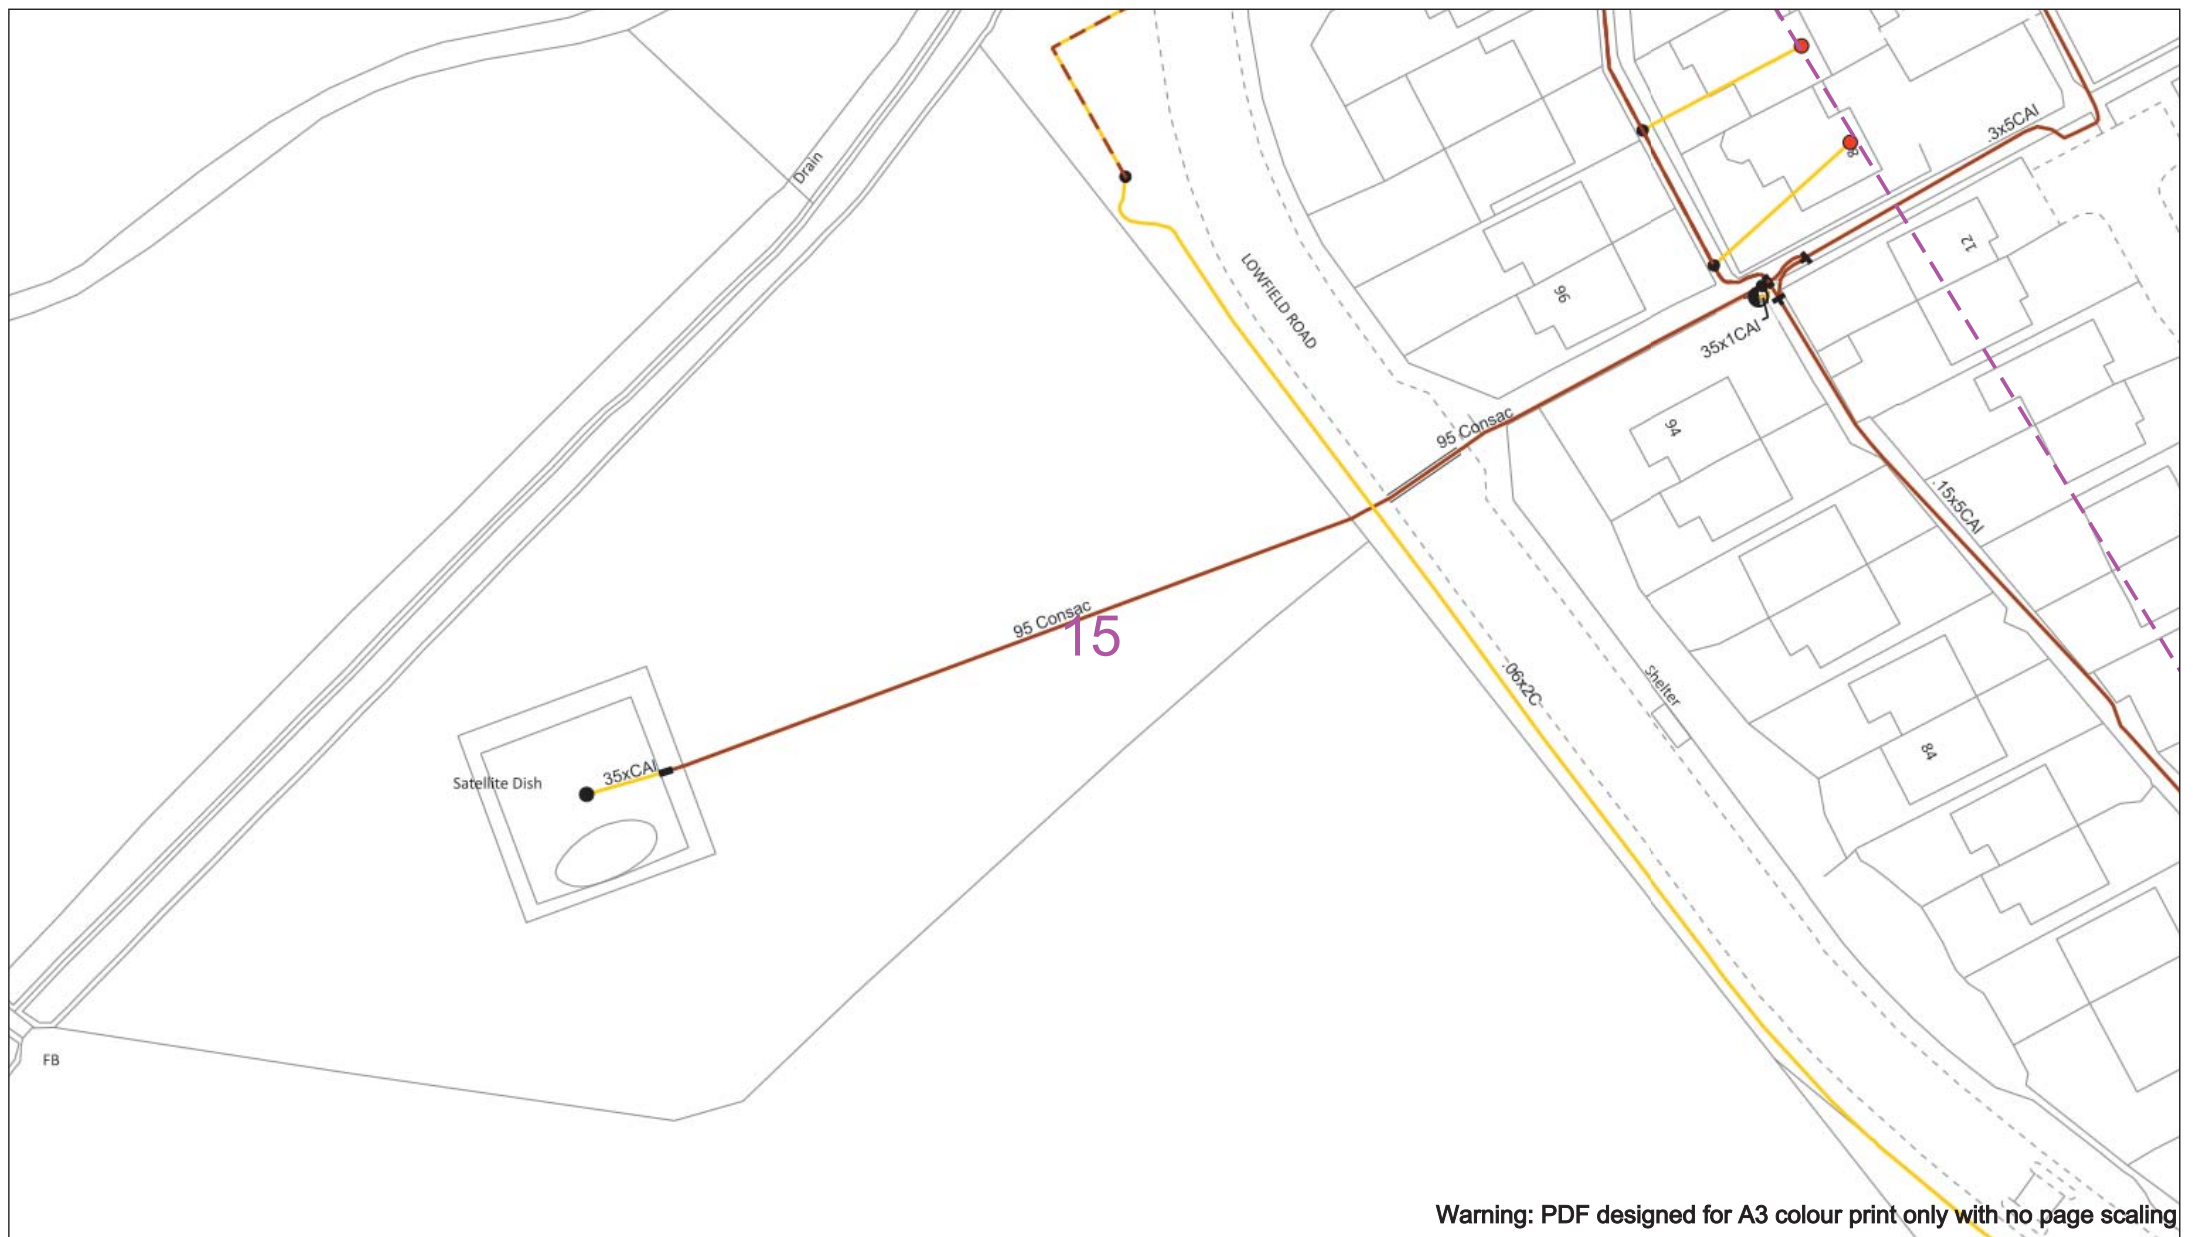

Warning: PDF designed for A3 colour print only with no page scaling

050m

Dig Sites

Area:

Line:

Date Requested: 09/11/2021

Job Reference: 23827726

Site Location: 472556 176139

Requested by: Ms Debbie Wigston

Your Scheme/Reference: 8210940

WARNING

There may have been subsequent alteration to the surface levels. Trial holes must be undertaken to determine position and depths of cables. HS (G) 47 Booklet from the Health and Safety Executive – Avoiding Danger from Buried Cables – should be consulted before commencing excavation work.

WHEN WORKING IN THE VICINITY OF OVERHEAD LINES THE HEALTH AND SAFETY GUIDANCE NOTES GS6 SHOULD BE CONSULTED (AVAILABLE FROM THE HSE WEBSITE)

Voltages (V)				
LV (Low Voltage) and Services	Up to 1,000V			
HV (High Voltage)	Over 1,000V to 11,000V			
EHV (Extra High Voltage)	22,000V to 132,000V			
Transmission	275,000V and 400,000V			

NORMAL DEPTH TO THE TOP OF THE CABLE WHEN LAID				
Services	LV	HV	EHV	
Footpath/Unmade	0.45m	0.45m	0.6m	0.8m
Road Crossing	0.6m	0.6m	0.75m	0.9m
Agricultural	1m	1m	1m	1.1m

Legend

Service Cable

LV Mains

2 – 3.3kV

6.6kV

11kV

22kV

33kV

66kV

132kV

275kV

400kV

Fibre Optic

Pole Cable

Distribution Structures (Electric)

Pole, Existing Location

Pole Structure, Existing Location - Single

Pole Structure, Existing Location - H

Duct Route

Cross Section Route


Southern Electric Power Distribution plc
Registered Office: No.1 Forbury Place
43 Forbury Road Reading RG1 3JH
Registered in England & Wales No.04094290

If you're unsure & need to seek advice before commencing excavations please contact:
General Enquiries: 0800 048 3516

Subject to revision – Master held by SSEN Asset Data Team:
AssetData@ssen.com
01236 337 294

BASED UPON THE ORDINANCE SURVEY MAP WITH THE SANCTION OF THE CONTROLLER OF H.M STATIONERY OFFICE CROWN COPYRIGHT RESERVED.

This copy has been made by or with the authority of Scottish and Southern Energy Power Distribution Ltd. Pursuant to section 47 of the Copyright, Designs and Patents Act 1988 ('The Act'). Unless the Act provides a relevant exception to copyright the copy must not be copied without prior permission of the copyright owner. Plans generated by DigSAFE Pro™ software provided by LinesearchbeforeUdig.

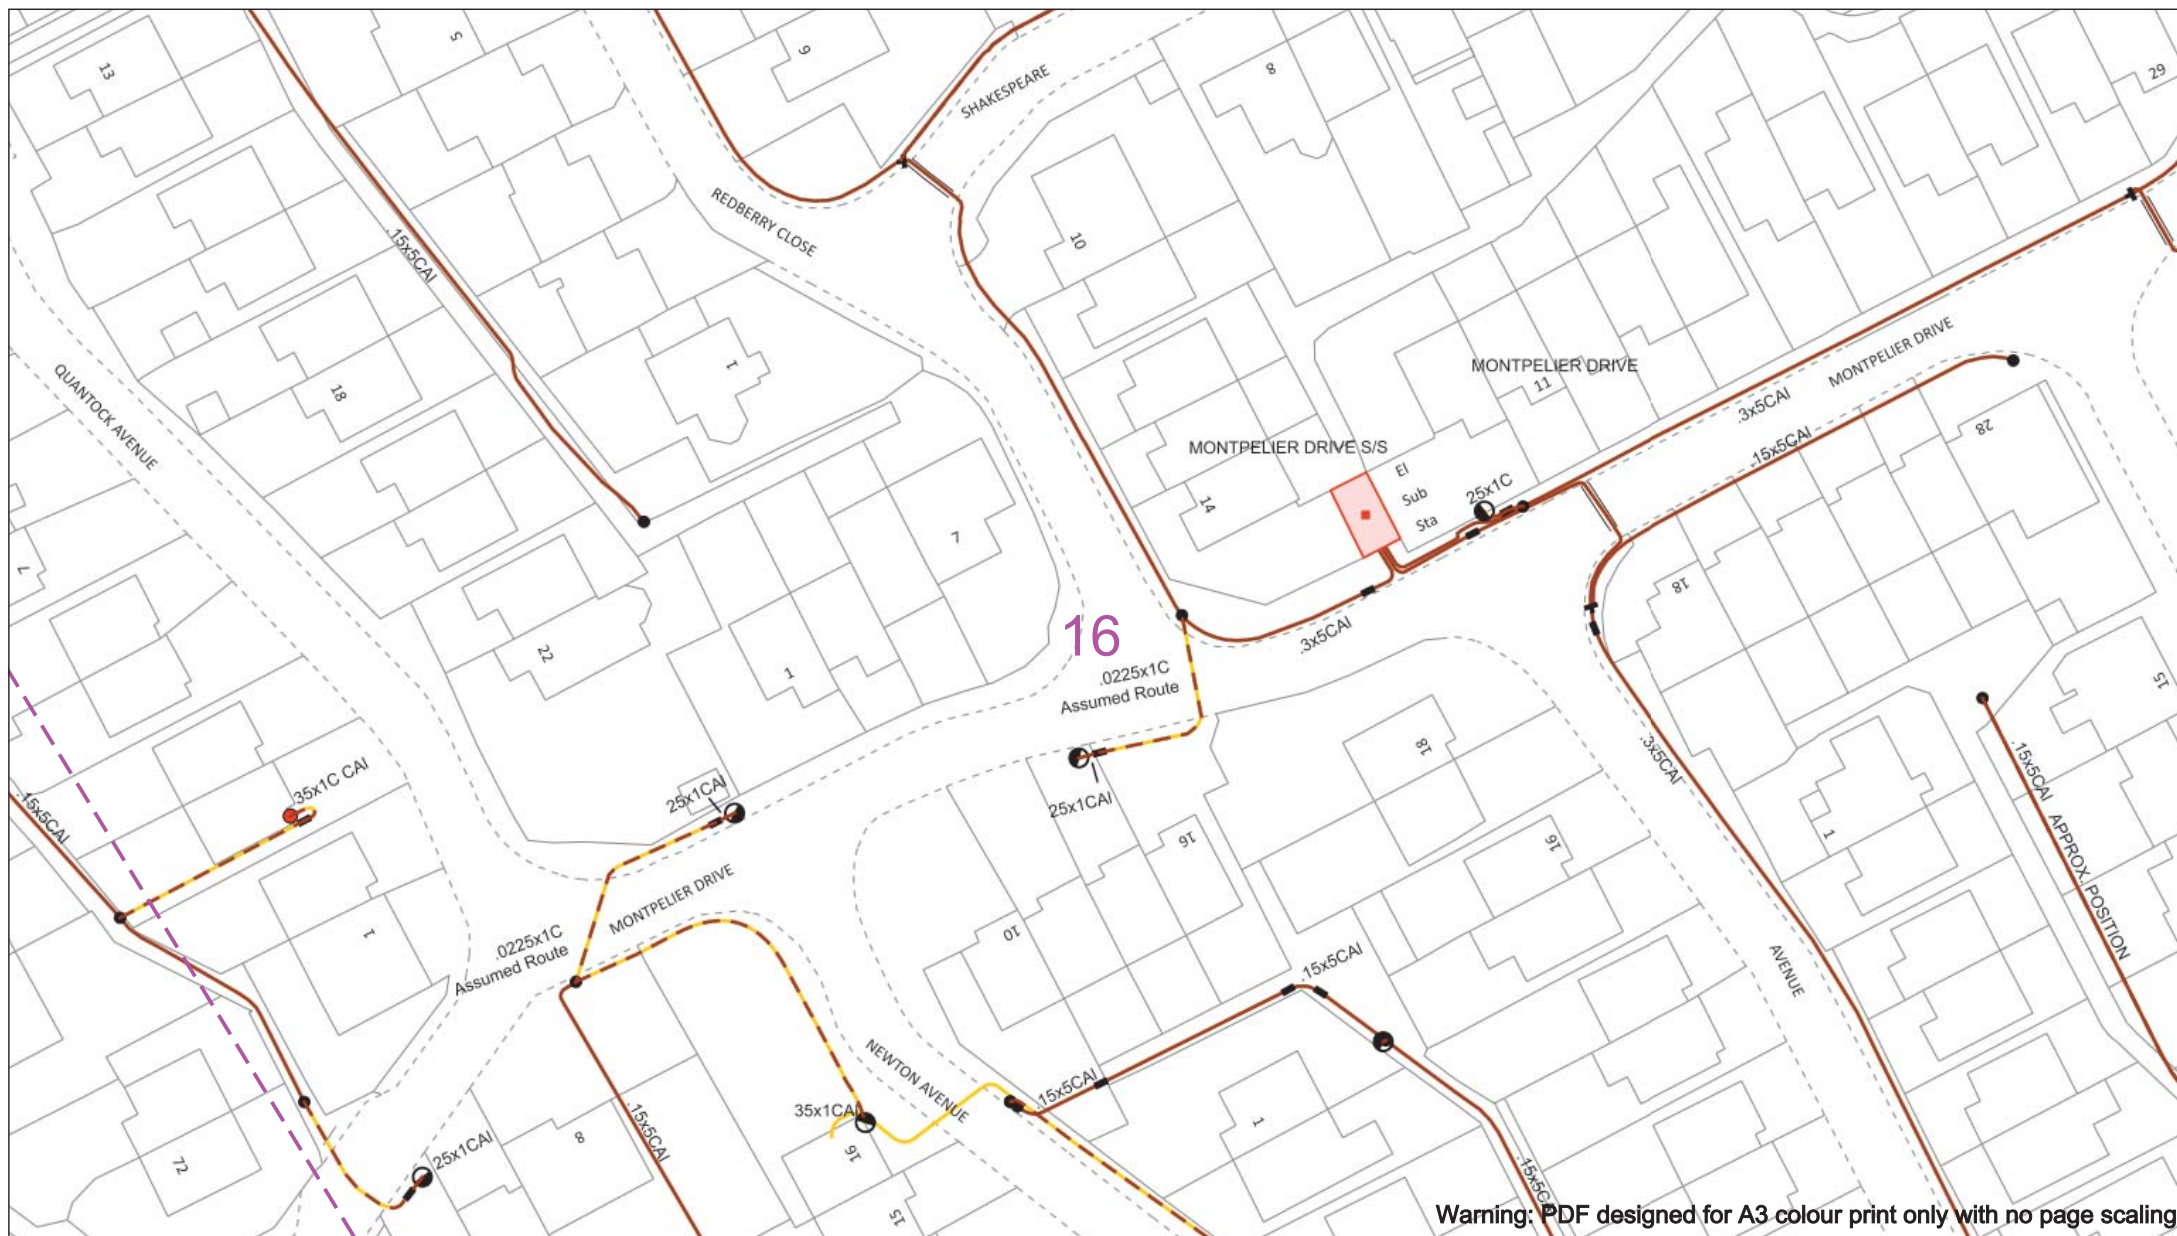

0 50m

Dig Sites Area: Line:

Date Requested: 09/11/2021
Job Reference: 23827726
Site Location: 472556 176139
Requested by:
Ms Debbie Wigston
Your Scheme/Reference: 8210940

WARNING

There may have been subsequent alteration to the surface levels. Trial holes must be undertaken to determine position and depths of cables. HS (G) 47 Booklet from the Health and Safety Executive – Avoiding Danger from Buried Cables – should be consulted before commencing excavation work.

WHEN WORKING IN THE VICINITY OF OVERHEAD LINES THE HEALTH AND SAFETY GUIDANCE NOTES GS6 SHOULD BE CONSULTED (AVAILABLE FROM THE HSE WEBSITE)

Voltages (V)				
LV (Low Voltage) and Services	Up to 1,000V			
LV Mains	Over 1,000V to 11,000V			
HV (High Voltage)	22,000V to 132,000V			
EHV (Extra High Voltage)	275,000V and 400,000V			
Transmission				

NORMAL DEPTH TO THE TOP OF THE CABLE WHEN LAID				
Services	LV	HV	EHV	
Footpath/Unmade	0.45m	0.45m	0.6m	0.8m
Road Crossing	0.6m	0.6m	0.75m	0.9m
Agricultural	1m	1m	1m	1.1m

Legend

Service Cable

LV Mains

2 – 3.3kV

6.6kV

11kV

22kV

33kV

66kV

132kV

275kV

400kV

Flow Optic

Pole Cable

Distribution Structures (Electric)

Pole, Existing Location

Pole Structure, Existing Location - Single

Pole Structure, Existing Location - H

Duct Route

Cross Section Route


Southern Electric Power Distribution plc
Registered Office: No.1 Forbury Place
43 Forbury Road Reading RG1 3JH
Registered in England & Wales No.04094290

If you're unsure & need to seek advice before commencing excavations please contact:
General Enquiries: 0800 048 3516

Subject to revision – Master held by SSEN Asset Data Team:
Asset.Data@ssen.com
01256 337 294

BASED UPON THE ORDNANCE SURVEY MAP WITH THE SANCTION OF THE CONTROLLER OF H.M STATIONERY OFFICE CROWN COPYRIGHT RESERVED.

This copy has been made by or with the authority of Scottish and Southern Energy Power Distribution Ltd. Pursuant to section 47 of the Copyright, Designs and Patents Act 1988 ('The Act'). Unless the Act provides a relevant exception to copyright the copy must not be copied without prior permission of the copyright owner. Plans generated by DigSAFE Pro™ software provided by LinesearchbeforeUdig.

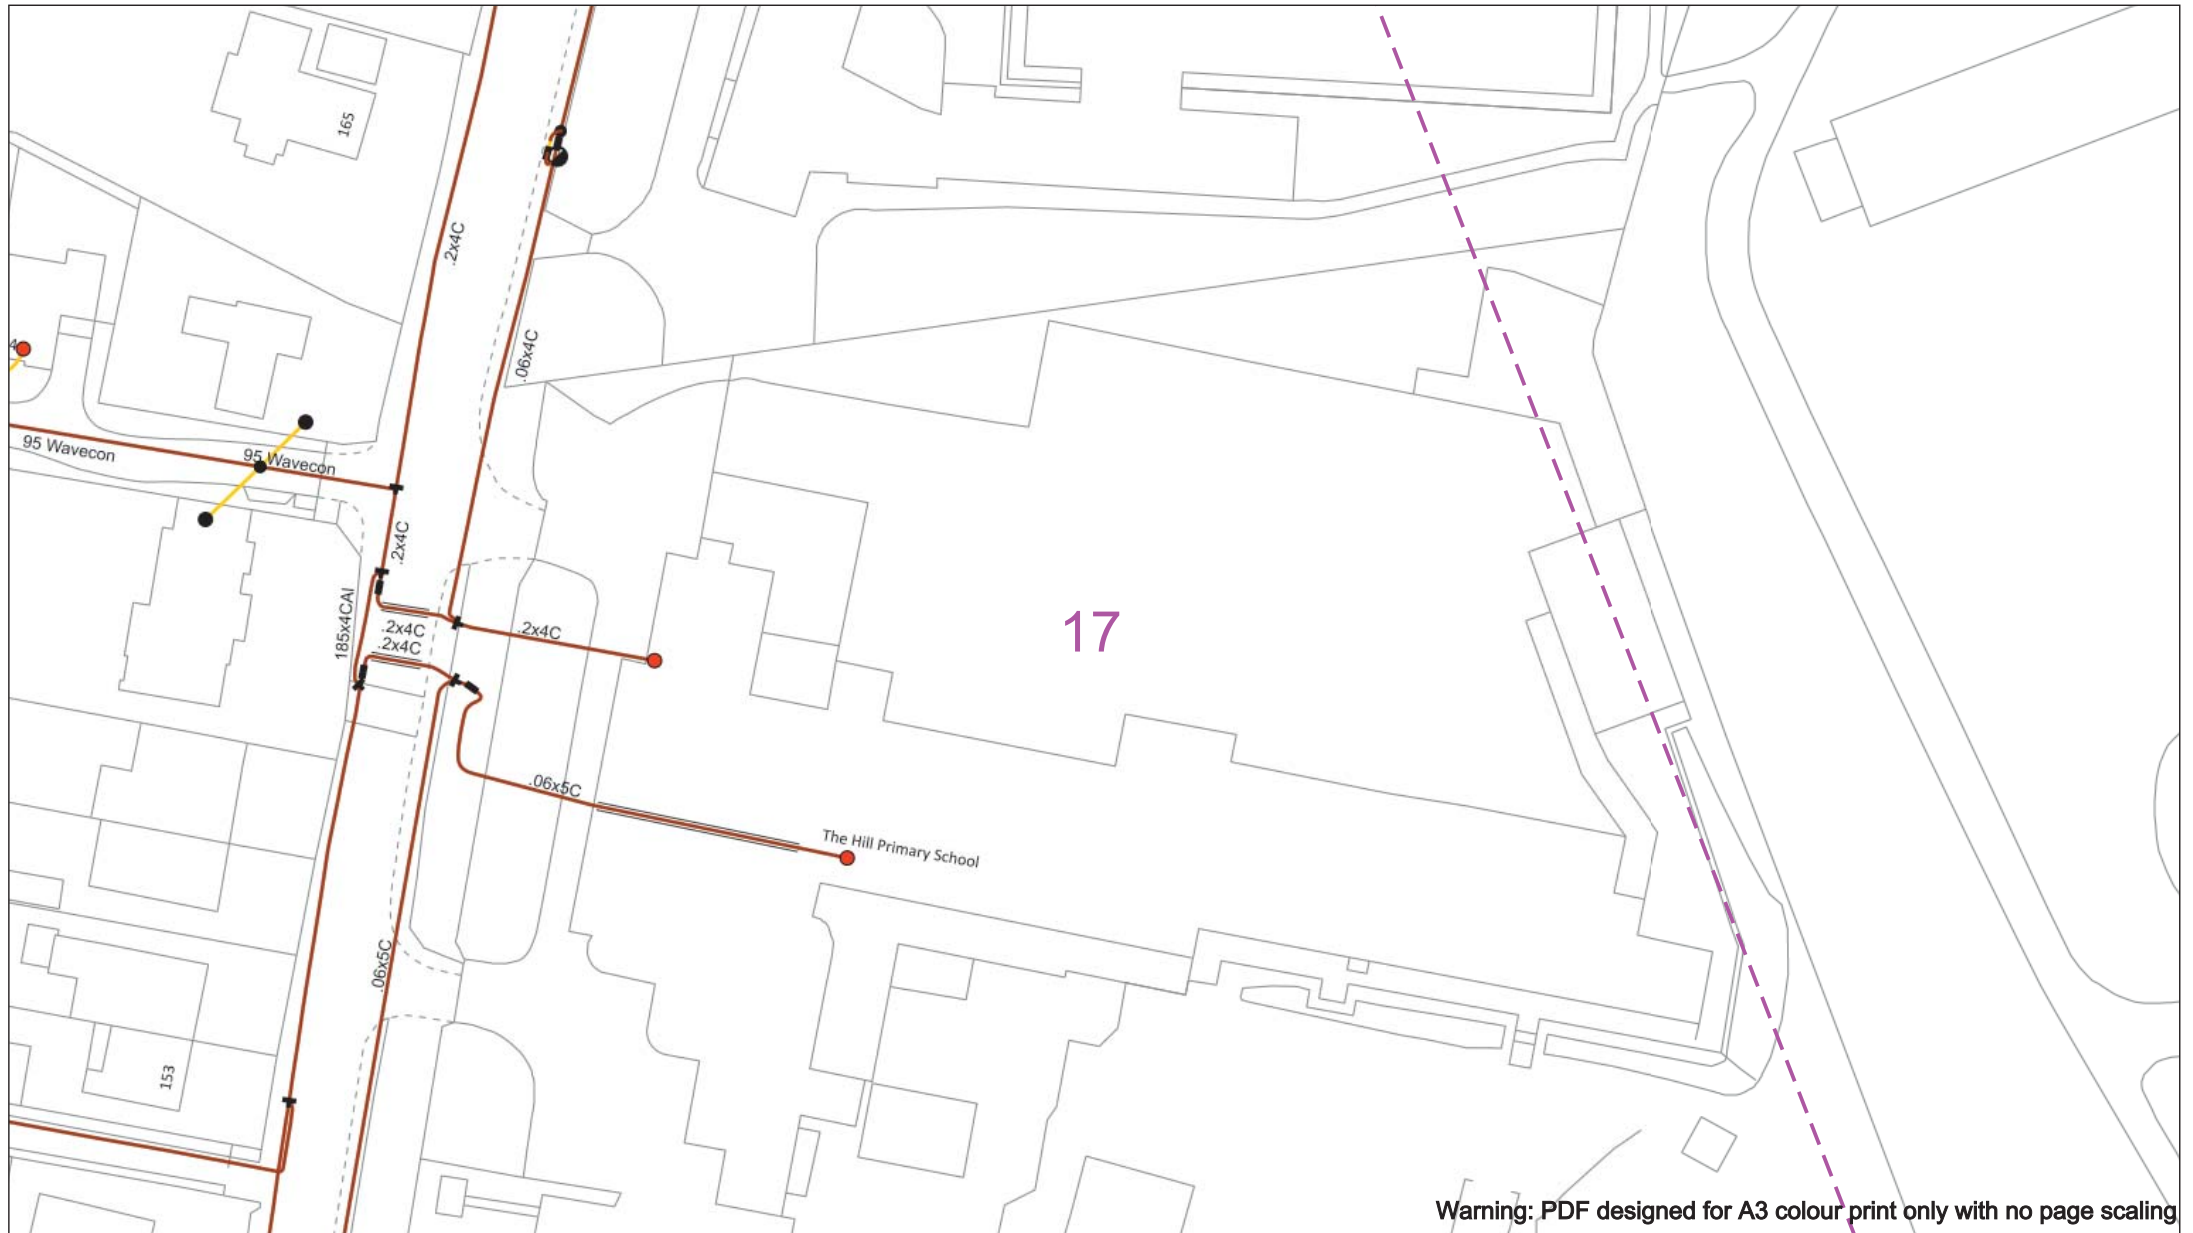

050m

Dig Sites

Area:

Line:

Date Requested: 09/11/2021

Job Reference: 23827726

Site Location: 472556 176139

Requested by: Ms Debbie Wigston

Your Scheme/Reference: 8210940

WARNING

There may have been subsequent alteration to the surface levels. Trial holes must be undertaken to determine position and depths of cables. HS (G) 47 Booklet from the Health and Safety Executive – Avoiding Danger from Buried Cables – should be consulted before commencing excavation work.

WHEN WORKING IN THE VICINITY OF OVERHEAD LINES THE HEALTH AND SAFETY GUIDANCE NOTES GS6 SHOULD BE CONSULTED (AVAILABLE FROM THE HSE WEBSITE)

Voltages (V)				
LV (Low Voltage) and Services	Up to 1,000V			
HV (High Voltage)	Over 1,000V to 11,000V			
EHV (Extra High Voltage)	22,000V to 132,000V			
Transmission	275,000V and 400,000V			

NORMAL DEPTH TO THE TOP OF THE CABLE WHEN LAID				
Services	LV	HV	EHV	
Footpath/Unmade	0.45m	0.45m	0.6m	0.8m
Road Crossing	0.6m	0.6m	0.75m	0.9m
Agricultural	1m	1m	1m	1.1m

Legend

Service Cable

LV Mains

2 – 3.3kV

6.6kV

11kV

22kV

33kV

66kV

132kV

275kV

400kV

Fibre Optic

Pilot Cable

Distribution Structures (Electric)

Pole, Existing Location

Pole Structure, Existing Location - Single

Pole Structure, Existing Location - H

Duct Route

Cross Section Route


Southern Electric Power Distribution plc
Registered Office: No.1 Forbury Place
43 Forbury Road Reading RG1 3JH
Registered in England & Wales No.04094290

If you're unsure & need to seek advice before commencing excavations please contact:
General Enquiries: 0800 048 3516

Subject to revision – Master held by SSEN Asset Data Team:
AssetData@ssen.com
01256 337 294

BASED UPON THE ORDNANCE SURVEY MAP WITH THE SANCTION OF THE CONTROLLER OF H.M. STATIONERY OFFICE CROWN COPYRIGHT RESERVED.

This copy has been made by or with the authority of Scottish and Southern Energy Power Distribution Ltd. Pursuant to section 47 of the Copyright, Designs and Patents Act 1988 ('The Act'). Unless the Act provides a relevant exception to copyright the copy must not be copied without prior permission of the copyright owner. Plans generated by DigSAFE Pro™ software provided by LinesearchbeforeUdig.

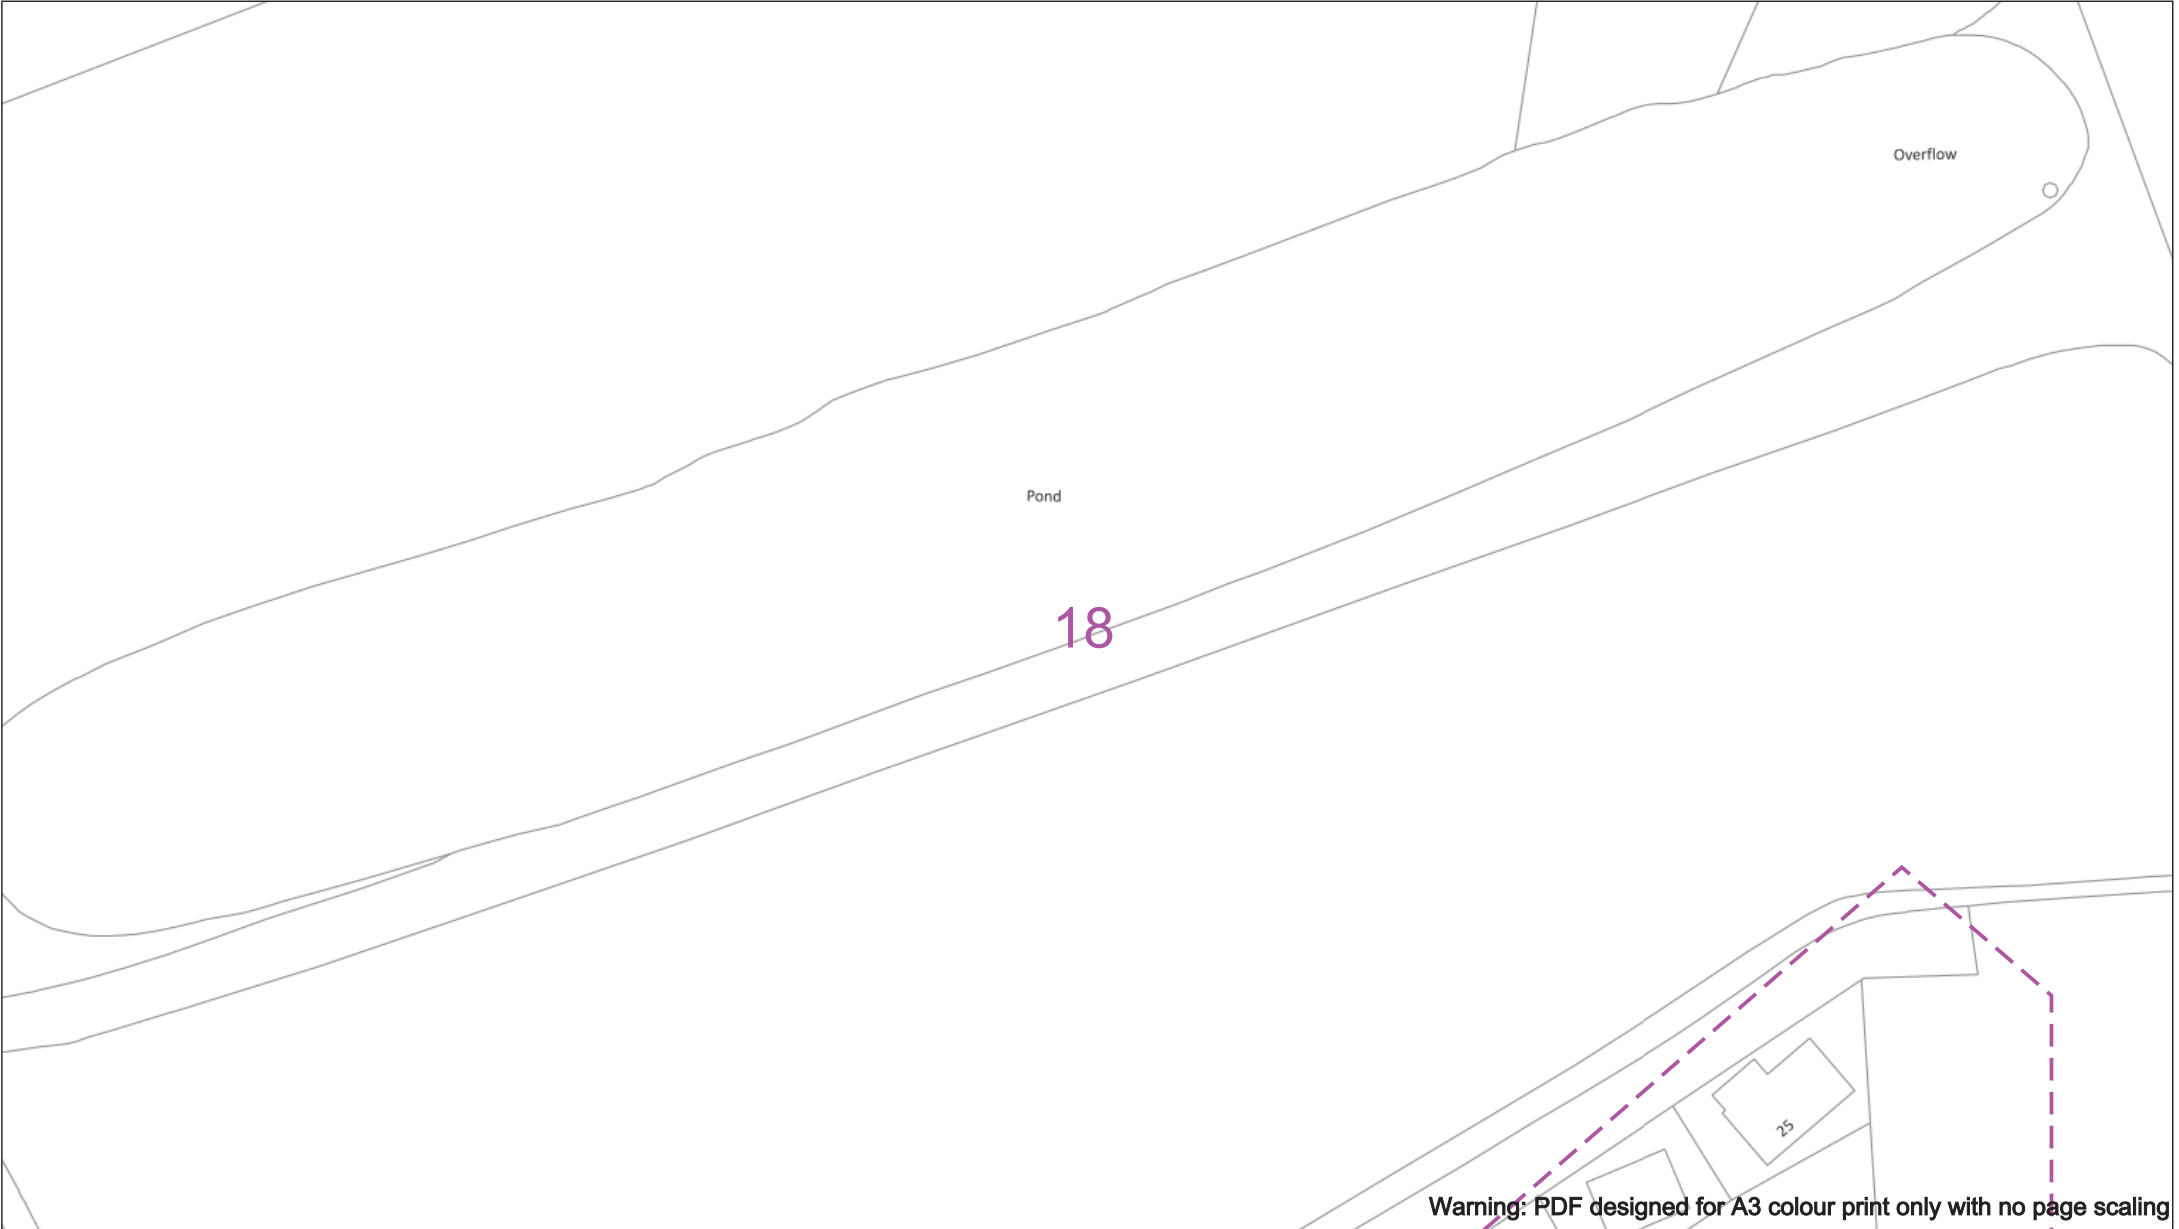

Warning: PDF designed for A3 colour print only with no page scaling

050m

Dig Sites

Area:

Line:

Date Requested: 09/11/2021

Job Reference: 23827726

Site Location: 472556 176139

Requested by: Ms Debbie Wigston

Your Scheme/Reference: 8210940

WARNING

There may have been subsequent alteration to the surface levels. Trial holes must be undertaken to determine position and depths of cables. HS (G) 47 Booklet from the Health and Safety Executive – Avoiding Danger from Buried Cables – should be consulted before commencing excavation work.

WHEN WORKING IN THE VICINITY OF OVERHEAD LINES THE HEALTH AND SAFETY GUIDANCE NOTES GS6 SHOULD BE CONSULTED (AVAILABLE FROM THE HSE WEBSITE)

Voltages (V)

LV (Low Voltage) and Services

Up to 1,000V

HV (High Voltage)

Over 1,000V to 11,000V

EHV (Extra High Voltage)

22,000V to 132,000V

Transmission

275,000V and 400,000V

NORMAL DEPTH TO THE TOP OF THE CABLE WHEN LAID

Services	LV	HV	EHV
Footpath/Unmade	0.45m	0.45m	0.6m
Road Crossing	0.6m	0.6m	0.75m
Agricultural	1m	1m	1.1m

Legend

Service Cable

LV Mains

2 – 3.3kV

6.6kV

11kV

22kV

33kV

66kV

132kV

275kV

400kV

Fibre Optic

Pilot Cable

Distribution Structures (Electric)

Pole, Existing Location

Pole Structure, Existing Location - Single

Pole Structure, Existing Location - H

Duct Route

Cross Section Route

Southern Electric Power Distribution plc

Registered Office: No.1 Forbury Place

43 Forbury Road Reading RG1 3JH

Registered in England & Wales No.04094290

If you're unsure & need to seek advice before commencing excavations please contact:

General Enquiries: 0800 048 3516


Subject to revision – Master held by SSEN Asset Data Team:

Asset.Data@ssen.com

01256 337 294

BASED UPON THE ORDNANCE SURVEY MAP WITH THE SANCTION OF THE CONTROLLER OF H.M STATIONERY OFFICE CROWN COPYRIGHT RESERVED.

This copy has been made by or with the authority of Scottish and Southern Energy Power Distribution Ltd. Pursuant to section 47 of the Copyright, Designs and Patents Act 1988 ('The Act'). Unless the Act provides a relevant exception to copyright the copy must not be copied without prior permission of the copyright owner. Plans generated by DigSAFE Pro™ software provided by LinesearchbeforeUdig.

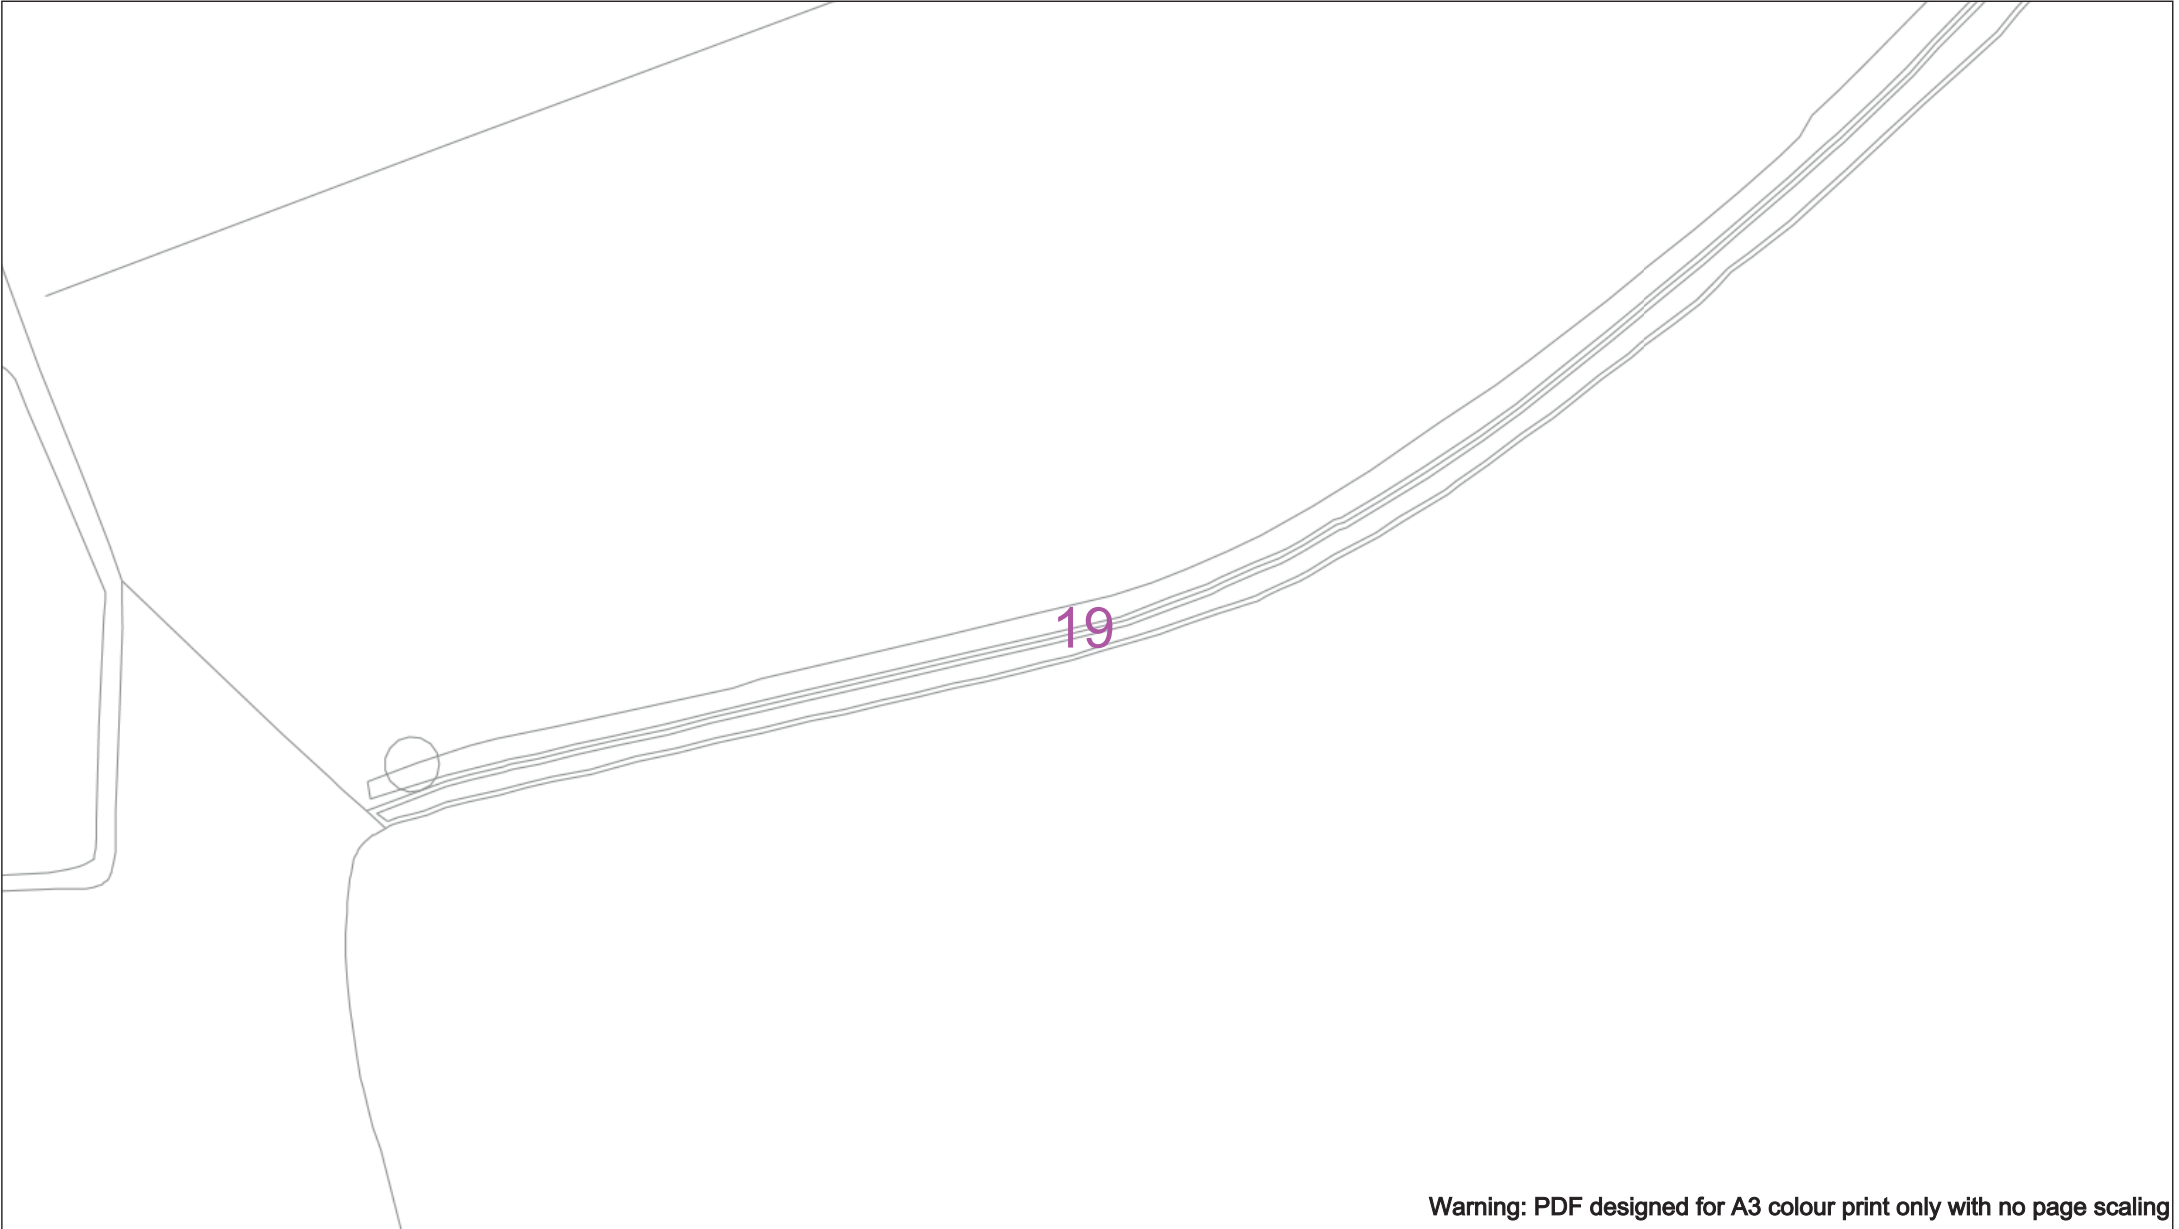

Warning: PDF designed for A3 colour print only with no page scaling

050m

Dig Sites

Area: 

Line: 

Date Requested: 09/11/2021

Job Reference: 23827726

Site Location: 472556 176139

Requested by:
Ms Debbie Wigston

Your Scheme/Reference: 8210940

WARNING

There may have been subsequent alteration to the surface levels. Trial holes must be undertaken to determine position and depths of cables. HS (G) 47 Booklet from the Health and Safety Executive – Avoiding Danger from Buried Cables – should be consulted before commencing excavation work.

WHEN WORKING IN THE VICINITY OF OVERHEAD LINES THE HEALTH AND SAFETY GUIDANCE NOTES GS6 SHOULD BE CONSULTED (AVAILABLE FROM THE HSE WEBSITE)

Voltages (V)				
LV (Low Voltage) and Services	Up to 1,000V			
HV (High Voltage)	Over 1,000V to 11,000V			
EHV (Extra High Voltage)	22,000V to 132,000V			
Transmission	275,000V and 400,000V			

NORMAL DEPTH TO THE TOP OF THE CABLE WHEN LAID				
Services	LV	HV	EHV	
Footpath/Unmade	0.45m	0.45m	0.6m	0.8m
Road Crossing	0.6m	0.6m	0.75m	0.9m
Agricultural	1m	1m	1m	1.1m

Legend

 Service Cable

 LV Mains

 2 – 3.3kV

 6.6kV

 11kV

 22kV

 33kV

 66kV

 132kV

 275kV

 400kV

 Fibre Optic

 Pilot Cable

 Pole, Existing Location

 Pole Structure, Existing Location - Single

 Pole Structure, Existing Location - H

 Duct Route

 Cross Section Route



Scottish & Southern

Electricity Networks

Southern Electric Power Distribution plc

Registered Office: No.1 Forbury Place

43 Forbury Road Reading RG1 3JH

Registered in England & Wales No.04094290

If you're unsure & need to seek advice before commencing excavations please contact:

General Enquiries: 0800 048 3516


Subject to revision – Master held by SSEN Asset Data Team:

Asset.Data@sen.com

01256 337 294

BASED UPON THE ORDNANCE SURVEY MAP WITH THE SANCTION OF THE CONTROLLER OF H.M STATIONERY OFFICE CROWN COPYRIGHT RESERVED.

This copy has been made by or with the authority of Scottish and Southern Energy Power Distribution Ltd. Pursuant to section 47 of the Copyright, Designs and Patents Act 1988 ('The Act'). Unless the Act provides a relevant exception to copyright the copy must not be copied without prior permission of the copyright owner. Plans generated by DigSAFE Pro™ software provided by LinesearchbeforeUdig.

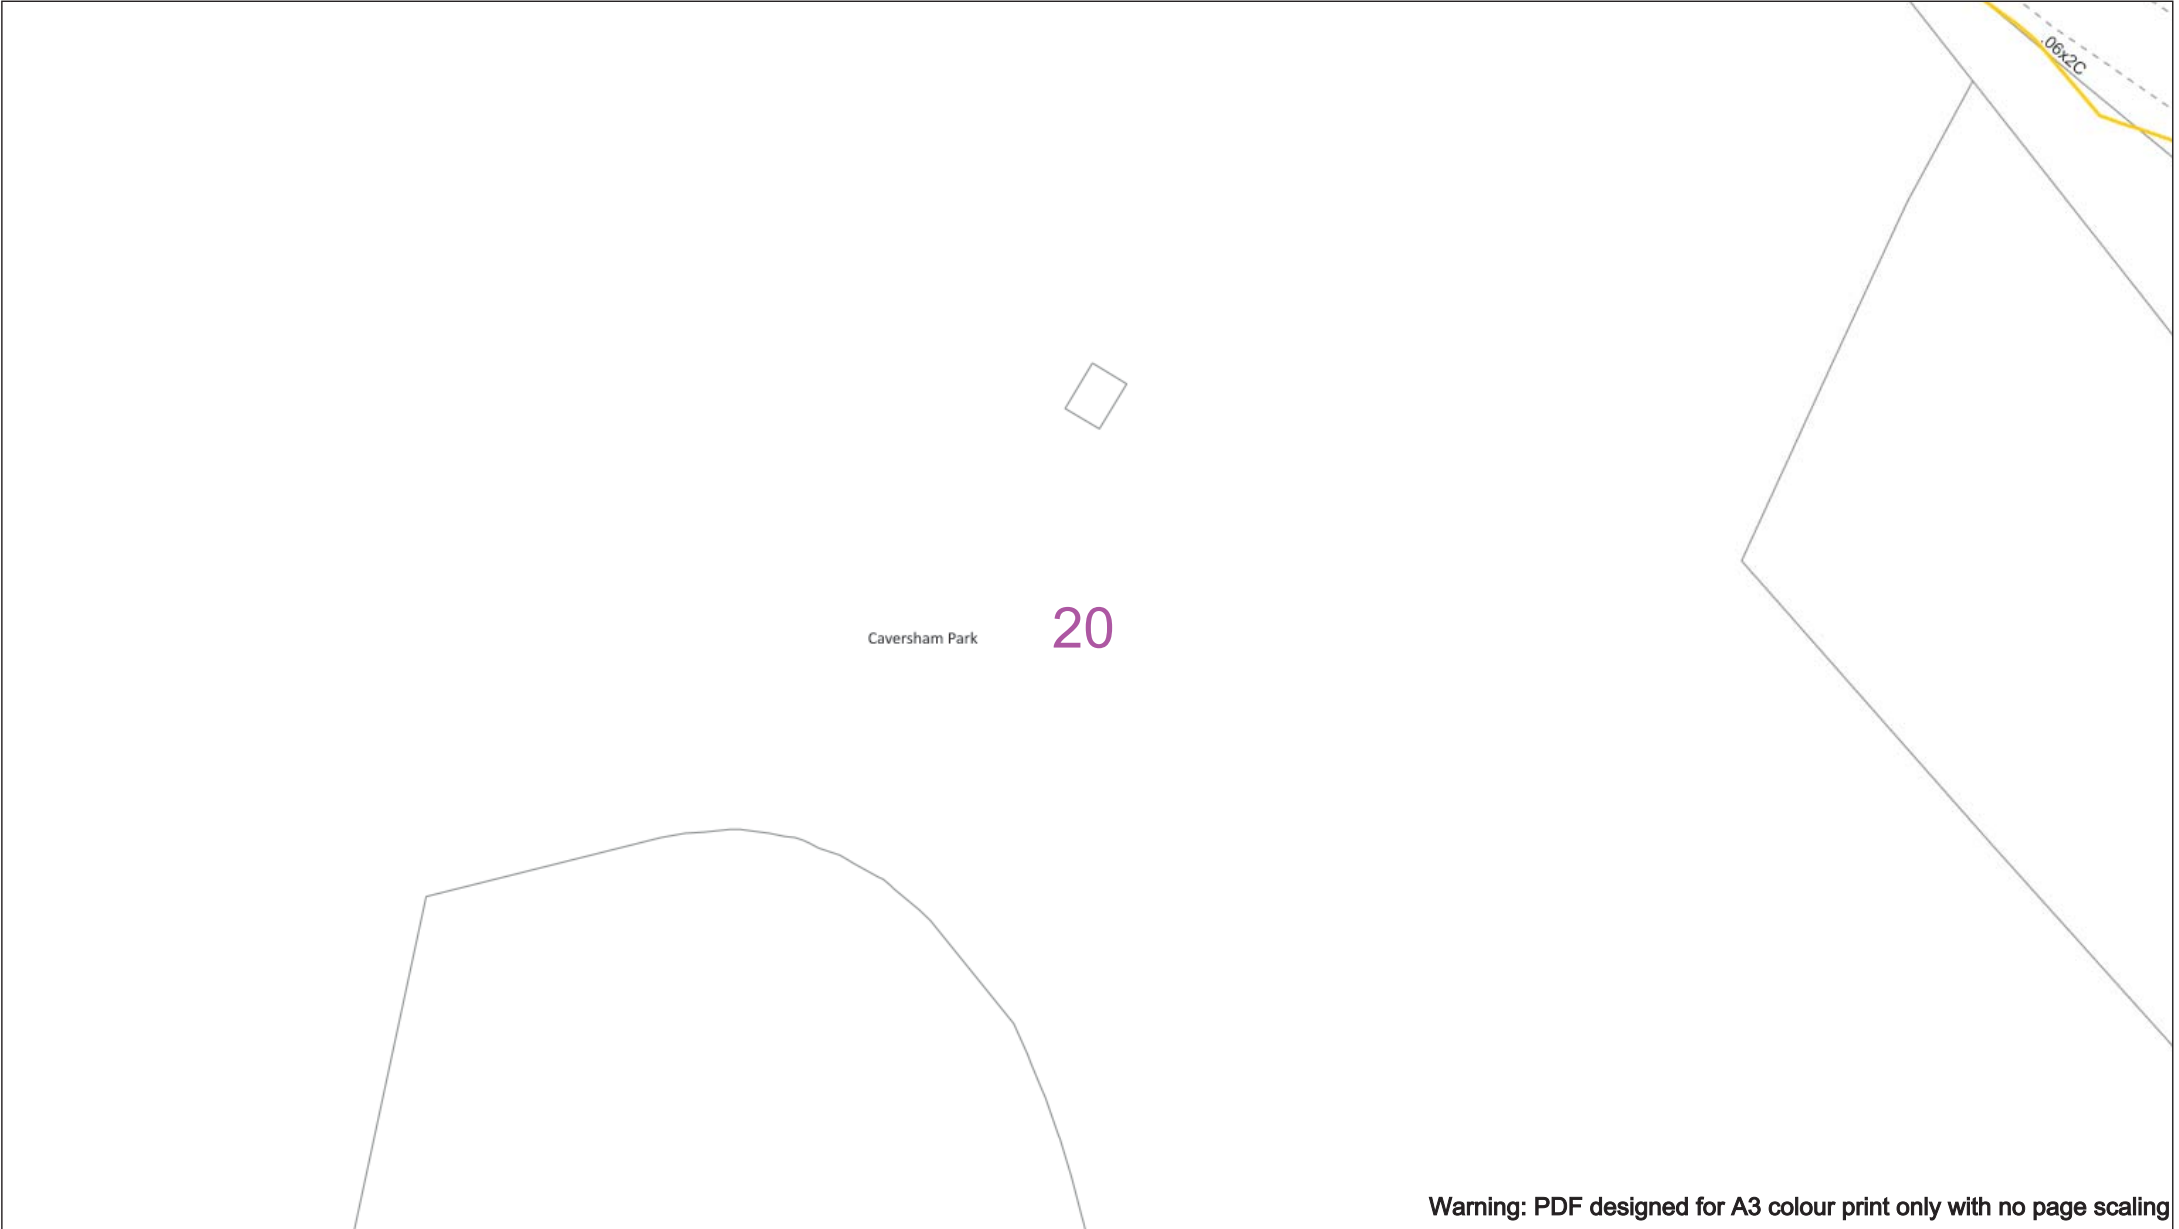

050m

Dig Sites

Area:

Line:

Date Requested: 09/11/2021

Job Reference: 23827726

Site Location: 472556 176139

Requested by: Ms Debbie Wigston

Your Scheme/Reference: 8210940

WARNING

There may have been subsequent alteration to the surface levels. Trial holes must be undertaken to determine position and depths of cables. HS (G) 47 Booklet from the Health and Safety Executive – Avoiding Danger from Buried Cables – should be consulted before commencing excavation work.

WHEN WORKING IN THE VICINITY OF OVERHEAD LINES THE HEALTH AND SAFETY GUIDANCE NOTES GS6 SHOULD BE CONSULTED (AVAILABLE FROM THE HSE WEBSITE)

Voltages (V)

LV (Low Voltage) and Services

Up to 1,000V

HV (High Voltage)

Over 1,000V to 11,000V

EHV (Extra High Voltage)

22,000V to 132,000V

Transmission

275,000V and 400,000V

NORMAL DEPTH TO THE TOP OF THE CABLE WHEN LAID

Services	LV	HV	EHV
Footpath/Unmade	0.45m	0.45m	0.6m
Road Crossing	0.6m	0.6m	0.75m
Agricultural	1m	1m	1.1m

Service Cable

LV Mains

2 – 3.3kV

6.6kV

11kV

22kV

33kV

66kV

132kV

275kV

400kV

Fibre Optic

Pilot Cable

Distribution Structures (Electric)

Pole, Existing Location

Pole Structure, Existing Location - Single

Pole Structure, Existing Location - H

Duct Route

Cross Section Route

Southern Electric Power Distribution plc

Registered Office: No.1 Forbury Place

43 Forbury Road Reading RG1 3JH

Registered in England & Wales No.04094290

If you're unsure & need to seek advice before commencing excavations please contact:

General Enquiries: 0800 048 3516


Subject to revision – Master held by SSEN Asset Data Team:

Asset.Data@ssen.com

01256 337 294

BASED UPON THE ORDNANCE SURVEY MAP WITH THE SANCTION OF THE CONTROLLER OF H.M STATIONERY OFFICE CROWN COPYRIGHT RESERVED.

This copy has been made by or with the authority of Scottish and Southern Energy Power Distribution Ltd. Pursuant to section 47 of the Copyright, Designs and Patents Act 1988 ('The Act'). Unless the Act provides a relevant exception to copyright the copy must not be copied without prior permission of the copyright owner. Plans generated by DigSAFE Pro™ software provided by LinesearchbeforeUdig.

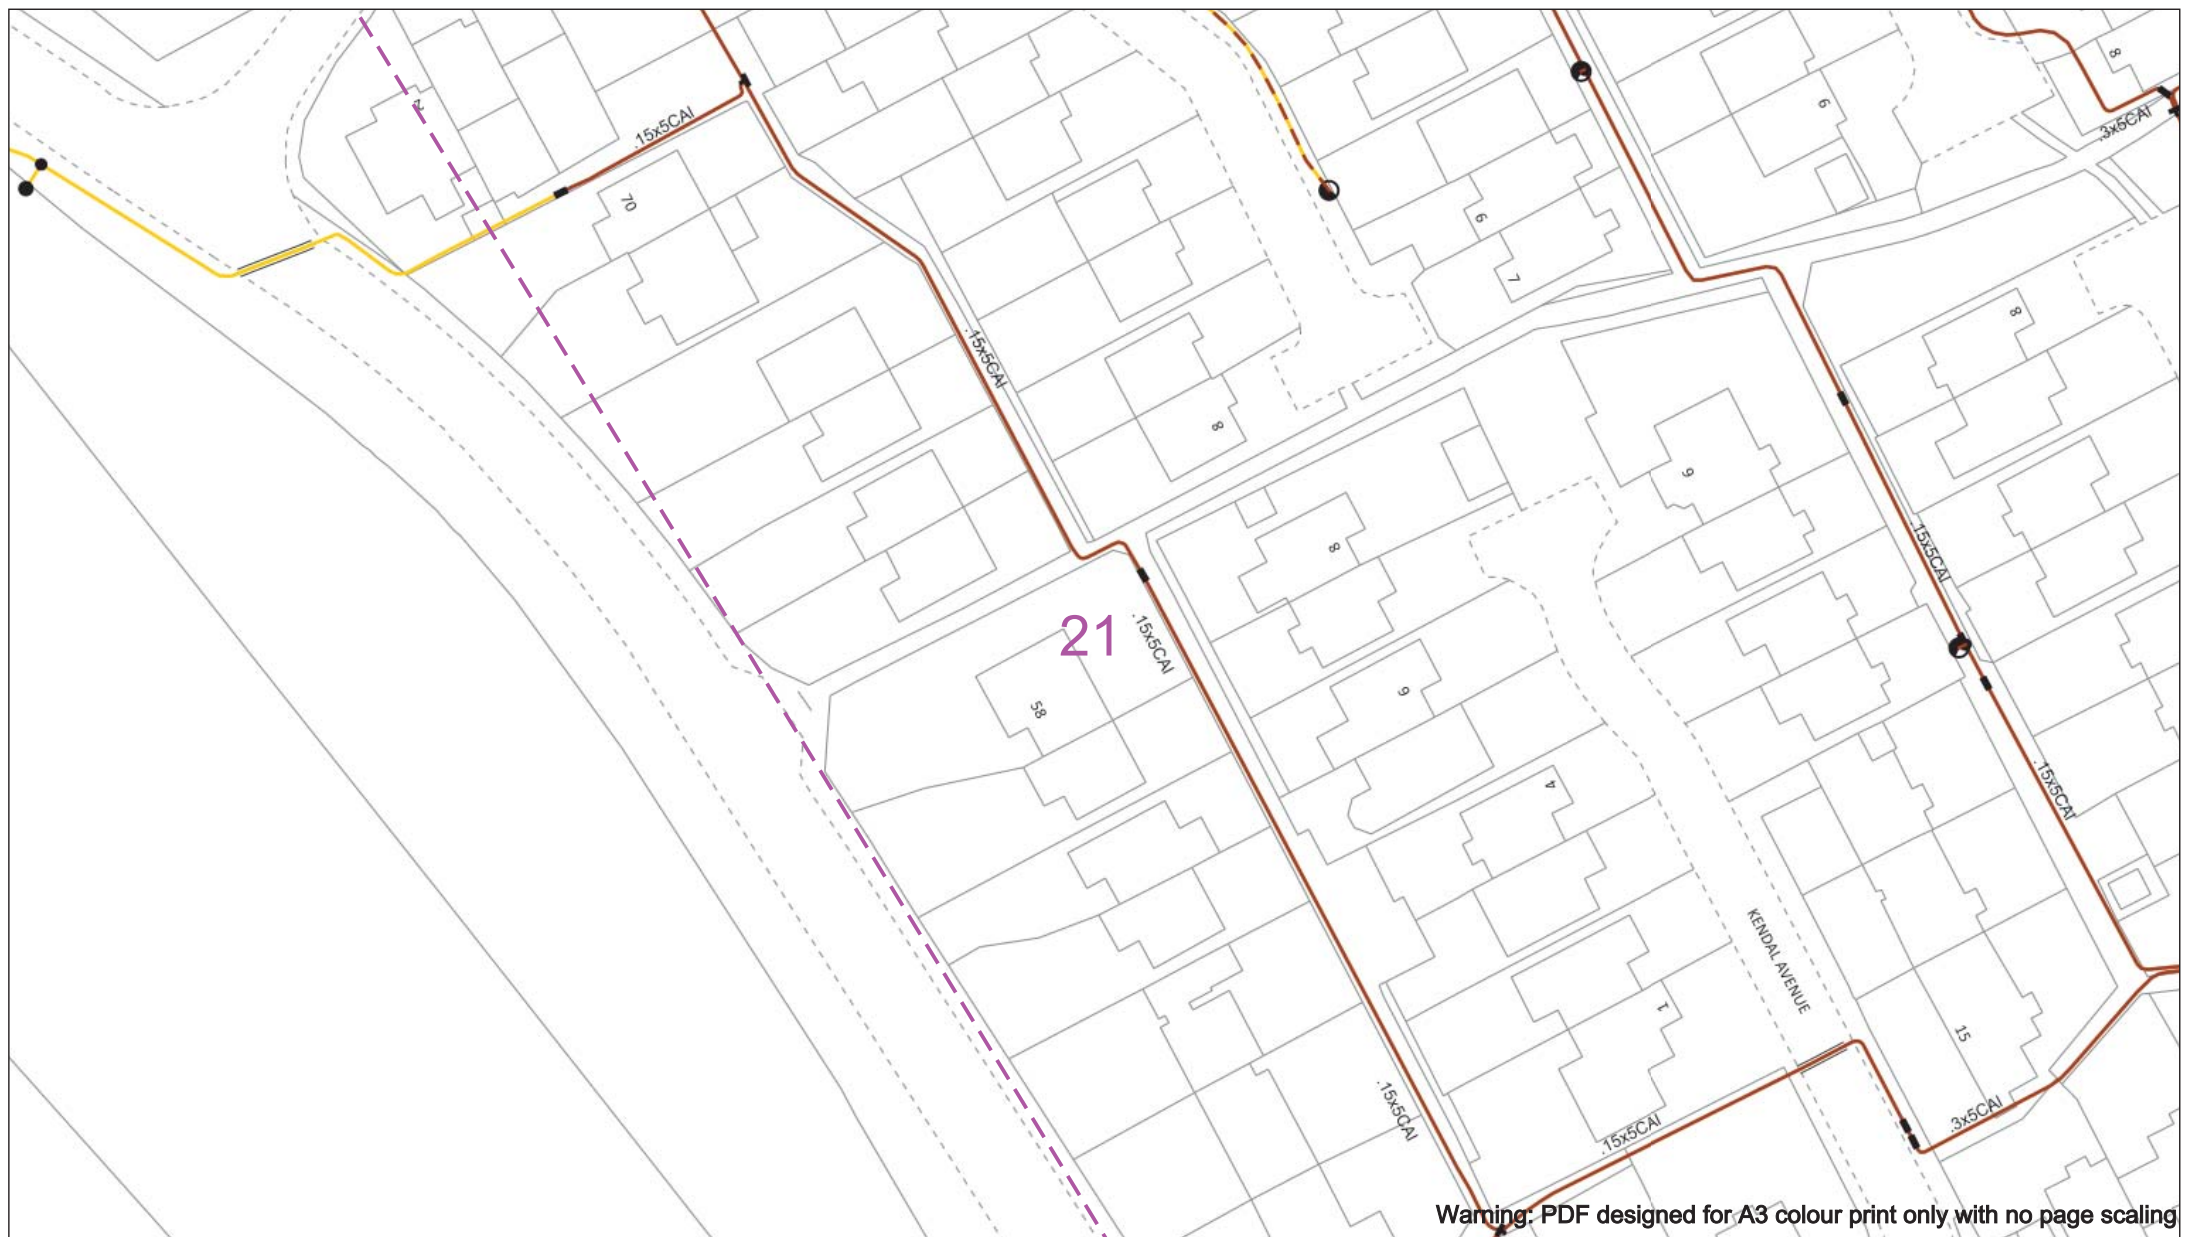

Warning: PDF designed for A3 colour print only with no page scaling

050m

Dig Sites

Area:

Line:

Date Requested: 09/11/2021

Job Reference: 23827726

Site Location: 472556 176139

Requested by: Ms Debbie Wigston

Your Scheme/Reference: 8210940

WARNING

There may have been subsequent alteration to the surface levels. Trial holes must be undertaken to determine position and depths of cables. HS (G) 47 Booklet from the Health and Safety Executive – Avoiding Danger from Buried Cables – should be consulted before commencing excavation work.

WHEN WORKING IN THE VICINITY OF OVERHEAD LINES THE HEALTH AND SAFETY GUIDANCE NOTES GS6 SHOULD BE CONSULTED (AVAILABLE FROM THE HSE WEBSITE)

Scale: 1:500 (When plotted at A3)

Voltages (V)

LV (Low Voltage) and Services

Up to 1,000V

HV (High Voltage)

Over 1,000V to 11,000V

EHV (Extra High Voltage)

22,000V to 132,000V

Transmission

275,000V and 400,000V

NORMAL DEPTH TO THE TOP OF THE CABLE WHEN LAID

	LV	HV	EHV
Footpath/Unmade	0.45m	0.45m	0.6m
Road Crossing	0.6m	0.6m	0.75m
Agricultural	1m	1m	1.1m

Legend

Service Cable

LV Mains

2 – 3.3kV

6.6kV

11kV

22kV

33kV

66kV

132kV

275kV

400kV

Fibre Optic

Pilot Cable

Distribution Structures (Electric)

Pole, Existing Location

Pole Structure, Existing Location - Single

Pole Structure, Existing Location - H

Duct Route

Cross Section Route

Southern Electric Power Distribution plc

Registered Office: No.1 Forbury Place

43 Forbury Road Reading RG1 3JH

Registered in England & Wales No.04094290

If you're unsure & need to seek advice before commencing excavations please contact:

General Enquiries: 0800 048 3516


Subject to revision – Master held by SSEN Asset Data Team:

AssetData@sen.com

01256 337 294

BASED UPON THE ORDNANCE SURVEY MAP WITH THE SANCTION OF THE CONTROLLER OF H.M STATIONERY OFFICE CROWN COPYRIGHT RESERVED.

This copy has been made by or with the authority of Scottish and Southern Energy Power Distribution Ltd. Pursuant to section 47 of the Copyright, Designs and Patents Act 1988 ('The Act'). Unless the Act provides a relevant exception to copyright the copy must not be copied without prior permission of the copyright owner. Plans generated by DigSAFE Pro™ software provided by LinesearchbeforeUdig.

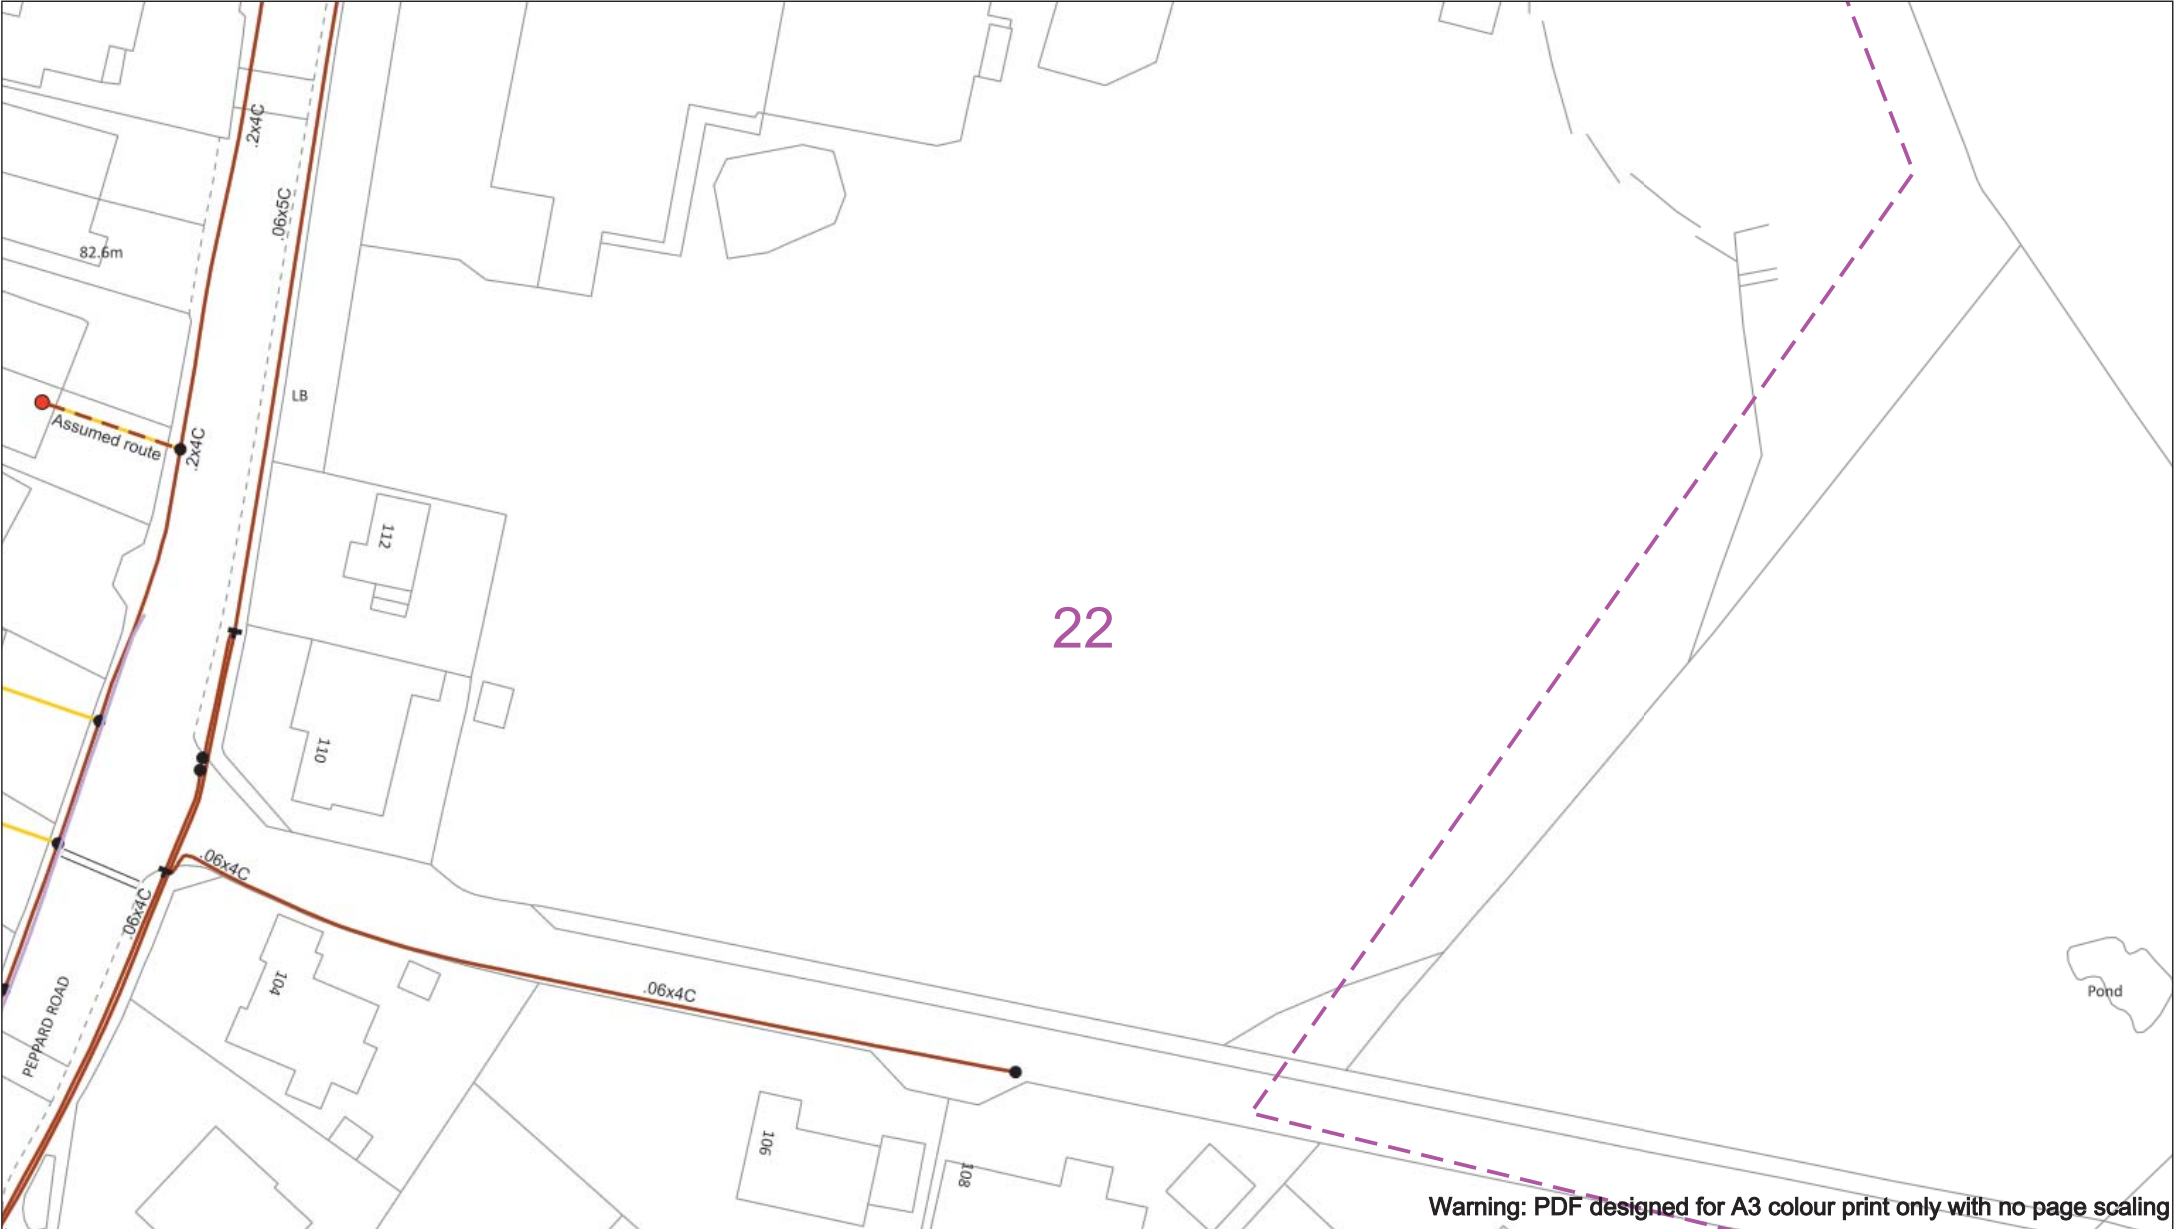

Warning: PDF designed for A3 colour print only with no page scaling

050m

Dig Sites

Area:

Line:

Date Requested: 09/11/2021

Job Reference: 23827726

Site Location: 472556 176139

Requested by: Ms Debbie Wigston

Your Scheme/Reference: 8210940

WARNING

There may have been subsequent alteration to the surface levels. Trial holes must be undertaken to determine position and depths of cables. HS (G) 47 Booklet from the Health and Safety Executive – Avoiding Danger from Buried Cables – should be consulted before commencing excavation work.

WHEN WORKING IN THE VICINITY OF OVERHEAD LINES THE HEALTH AND SAFETY GUIDANCE NOTES GS6 SHOULD BE CONSULTED (AVAILABLE FROM THE HSE WEBSITE)

Voltages (V)				
LV (Low Voltage) and Services	Up to 1,000V			
HV (High Voltage)	Over 1,000V to 11,000V			
EHV (Extra High Voltage)	22,000V to 132,000V			
Transmission	275,000V and 400,000V			

NORMAL DEPTH TO THE TOP OF THE CABLE WHEN LAID				
Services	LV	HV	EHV	
Footpath/Unmade	0.45m	0.45m	0.6m	0.8m
Road Crossing	0.6m	0.6m	0.75m	0.9m
Agricultural	1m	1m	1m	1.1m

Legend

Service Cable

LV Mains

2 – 3.3kV

6.6kV

11kV

22kV

33kV

66kV

132kV

275kV

400kV

Fibre Optic

Pilot Cable

Distribution Structures (Electric)

Pole, Existing Location

Pole Structure, Existing Location - Single

Pole Structure, Existing Location - H

Duct Route

Cross Section Route

Southern Electric Power Distribution plc

Registered Office: No.1 Forbury Place

43 Forbury Road Reading RG1 3JH

Registered in England & Wales No.04094290

If you're unsure & need to seek advice before commencing excavations please contact:

General Enquiries: 0800 048 3516


Subject to revision – Master held by SSEN Asset Data Team:

Asset.Data@ssen.com

01256 337 294

BASED UPON THE ORDNANCE SURVEY MAP WITH THE SANCTION OF THE CONTROLLER OF H.M. STATIONERY OFFICE CROWN COPYRIGHT RESERVED.

This copy has been made by or with the authority of Scottish and Southern Energy Power Distribution Ltd. Pursuant to section 47 of the Copyright, Designs and Patents Act 1988 ('The Act'). Unless the Act provides a relevant exception to copyright the copy must not be copied without prior permission of the copyright owner. Plans generated by DigSAFE Pro™ software provided by LinesearchbeforeUdig.

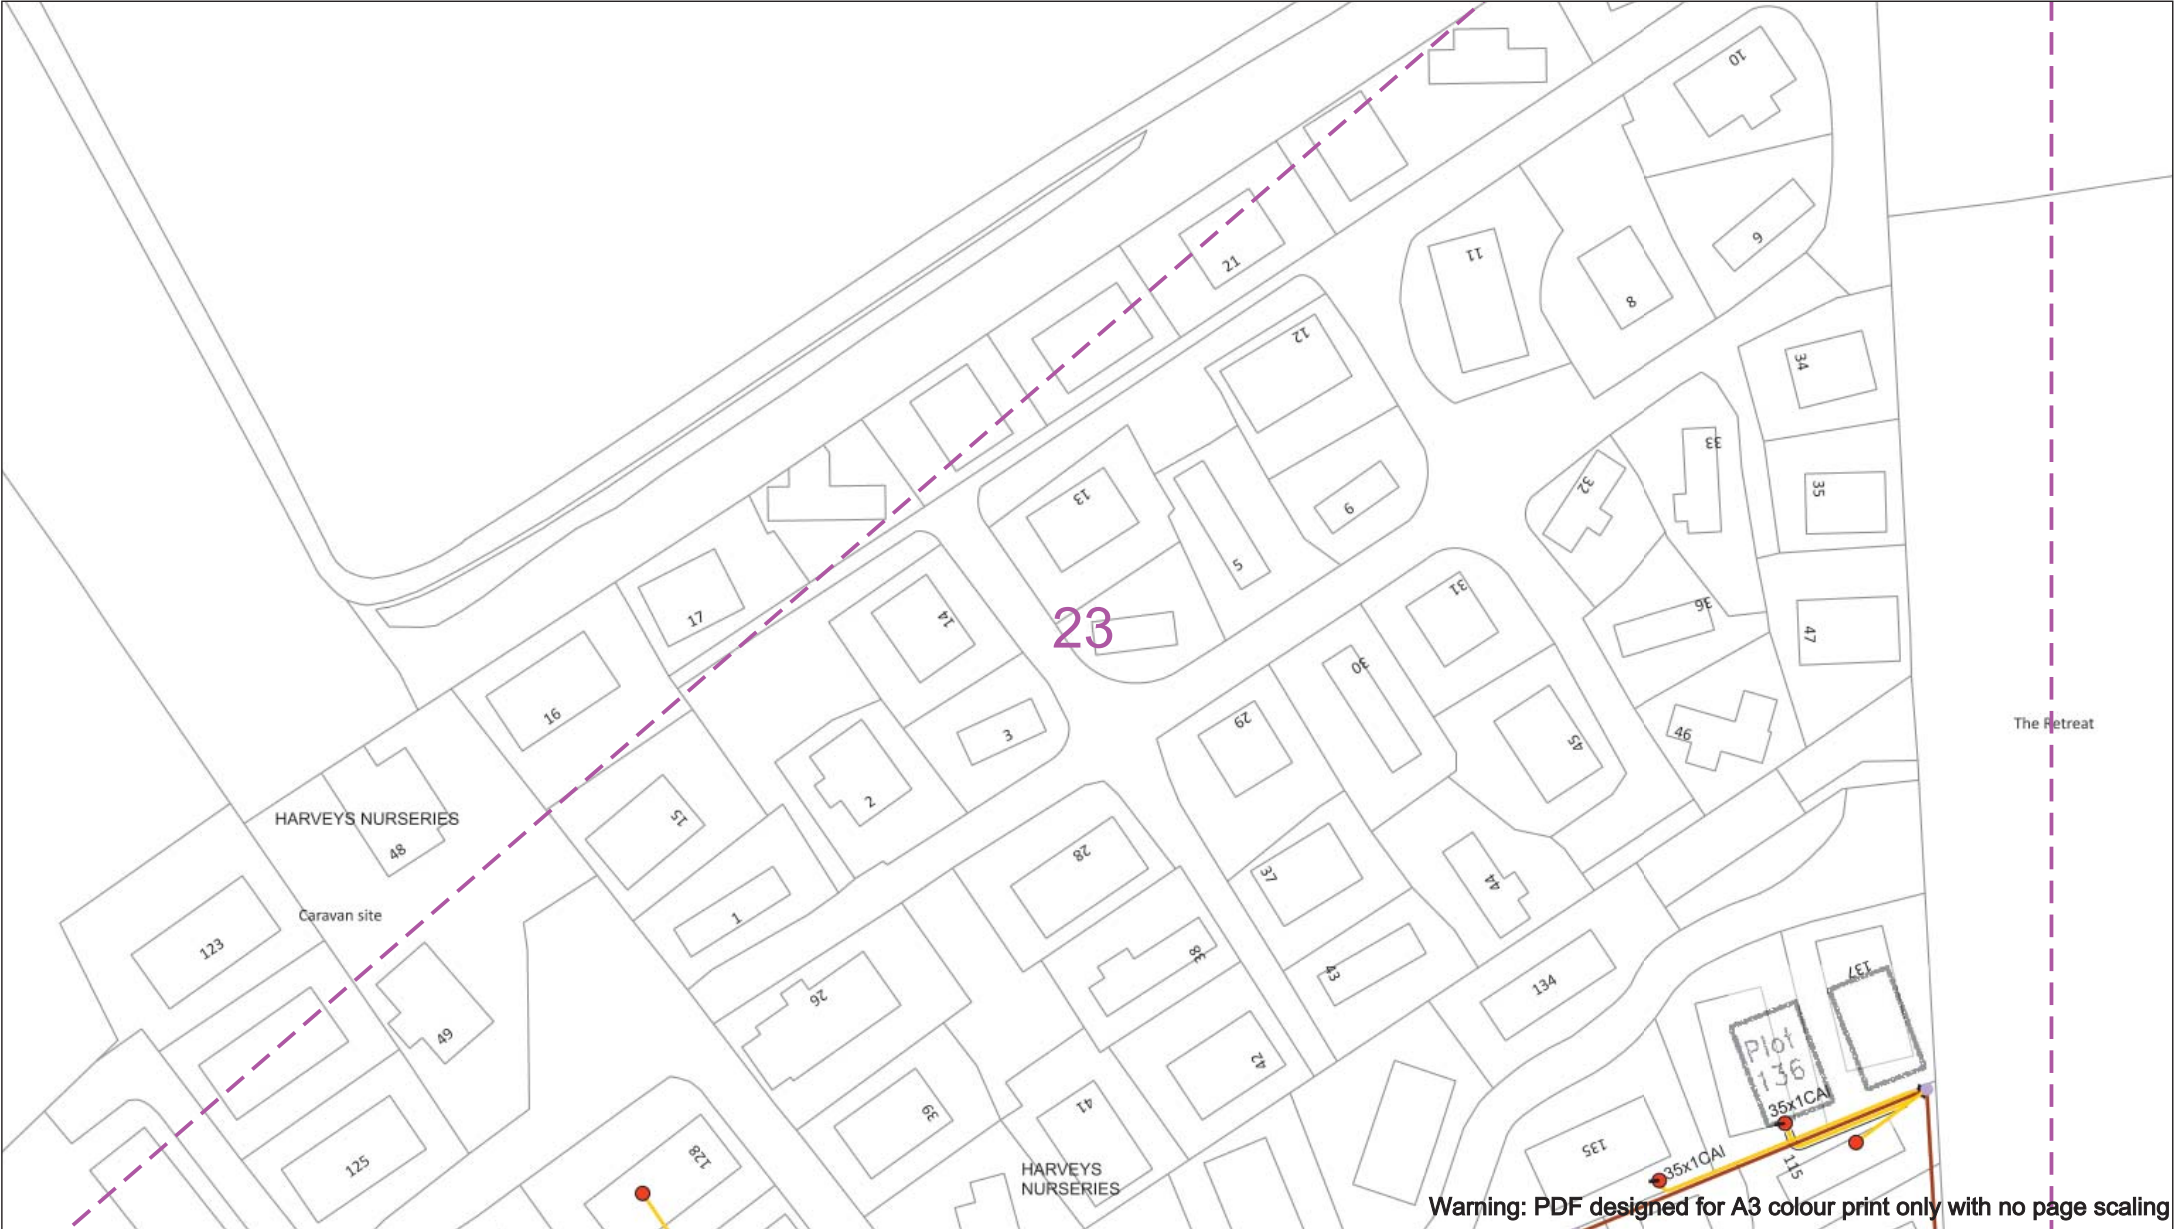

050m

Dig Sites

Area:

Line:

Date Requested: 09/11/2021

Job Reference: 23827726

Site Location: 472556 176139

Requested by: Ms Debbie Wigston

Your Scheme/Reference: 8210940

WARNING

There may have been subsequent alteration to the surface levels. Trial holes must be undertaken to determine position and depths of cables. HS (G) 47 Booklet from the Health and Safety Executive – Avoiding Danger from Buried Cables – should be consulted before commencing excavation work.

WHEN WORKING IN THE VICINITY OF OVERHEAD LINES THE HEALTH AND SAFETY GUIDANCE NOTES GS6 SHOULD BE CONSULTED (AVAILABLE FROM THE HSE WEBSITE)

Voltages (V)				
LV (Low Voltage) and Services	Up to 1,000V			
LV Mains	Over 1,000V to 11,000V			
HV (High Voltage)	22,000V to 132,000V			
EHV (Extra High Voltage)	275,000V and 400,000V			
Transmission	275,000V and 400,000V			

NORMAL DEPTH TO THE TOP OF THE CABLE WHEN LAID				
Services	LV	HV	EHV	
Footpath/Unmade	0.45m	0.45m	0.6m	0.8m
Road Crossing	0.6m	0.6m	0.75m	0.9m
Agricultural	1m	1m	1m	1.1m

Legend

Service Cable

LV Mains

2 – 3.3kV

6.6kV

11kV

22kV

33kV

66kV

132kV

275kV

400kV

Fibre Optic

Pilot Cable

Distribution Structures (Electric)

Pole, Existing Location

Pole Structure, Existing Location - Single

Pole Structure, Existing Location - H

Duct Route

Cross Section Route

Southern Electric Power Distribution plc

Registered Office: No.1 Forbury Place

43 Forbury Road Reading RG1 3JH

Registered in England & Wales No.04094290

If you're unsure & need to seek advice before commencing excavations please contact:

General Enquiries: 0800 048 3516

Subject to revision – Master held by SSEN Asset Data Team:


Asset.Data@ssen.com

01256 337 294

Scale: 1:500 (When plotted at A3)

BASED UPON THE ORDNANCE SURVEY MAP WITH THE SANCTION OF THE CONTROLLER OF H.M STATIONERY OFFICE CROWN COPYRIGHT RESERVED.

This copy has been made by or with the authority of Scottish and Southern Energy Power Distribution Ltd. Pursuant to section 47 of the Copyright, Designs and Patents Act 1988 ('The Act'). Unless the Act provides a relevant exception to copyright the copy must not be copied without prior permission of the copyright owner. Plans generated by DigSAFE Pro™ software provided by LinesearchbeforeUdig.

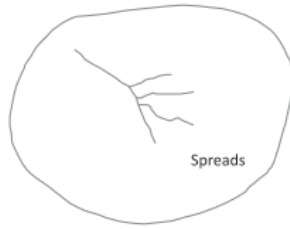

24

Warning: PDF designed for A3 colour print only with no page scaling

050m

Dig Sites

Area:

Line:

Date Requested: 09/11/2021

Job Reference: 23827726

Site Location: 472556 176139

Requested by: Ms Debbie Wigston

Your Scheme/Reference: 8210940

WARNING

There may have been subsequent alteration to the surface levels. Trial holes must be undertaken to determine position and depths of cables. HS (G) 47 Booklet from the Health and Safety Executive – Avoiding Danger from Buried Cables – should be consulted before commencing excavation work.

WHEN WORKING IN THE VICINITY OF OVERHEAD LINES THE HEALTH AND SAFETY GUIDANCE NOTES GS6 SHOULD BE CONSULTED (AVAILABLE FROM THE HSE WEBSITE)

Voltages (V)

LV (Low Voltage) and Services	Up to 1,000V
HV (High Voltage)	Over 1,000V to 11,000V
EHV (Extra High Voltage)	22,000V to 132,000V
Transmission	275,000V and 400,000V

NORMAL DEPTH TO THE TOP OF THE CABLE WHEN LAID

Services	LV	HV	EHV
Footpath/Unmade	0.45m	0.45m	0.6m
Road Crossing	0.6m	0.6m	0.75m
Agricultural	1m	1m	1.1m

Legend

	Service Cable
	LV Mains
	2 – 3.3kV
	6.6kV
	11kV
	22kV
	33kV
	66kV
	132kV
	275kV
	400kV
	Fibre Optic
	Pile Cable

Distribution Structures (Electric)

	Pole, Existing Location
	Pole Structure, Existing Location - Single
	Pole Structure, Existing Location - H
	Duct Route
	Cross Section Route

Southern Electric Power Distribution plc

Registered Office: No.1 Forbury Place

43 Forbury Road Reading RG1 3JH

Registered in England & Wales No.04094290

If you're unsure & need to seek advice before commencing excavations please contact:

General Enquiries: 0800 048 3516

Subject to revision – Master held by SSEN Asset Data Team:

Asset.Data@sen.com

01256 337 294

Scale: 1:500 (When plotted at A3)

BASED UPON THE ORDNANCE SURVEY MAP WITH THE SANCTION OF THE CONTROLLER OF H.M STATIONERY OFFICE CROWN COPYRIGHT RESERVED.

This copy has been made by or with the authority of Scottish and Southern Energy Power Distribution Ltd. Pursuant to section 47 of the Copyright, Designs and Patents Act 1988 ('The Act'). Unless the Act provides a relevant exception to copyright the copy must not be copied without prior permission of the copyright owner. Plans generated by DigSAFE Pro™ software provided by LinesearchbeforeUdig.

Warning: PDF designed for A3 colour print only with no page scaling

0

50m

Dig Sites

Area: 

Line: 

Date Requested: 09/11/2021

Job Reference: 23827726

Site Location: 472556 176139

Requested by:
Ms Debbie Wigston

Your Scheme/Reference: 8210940

WARNING

There may have been subsequent alteration to the surface levels. Trial holes must be undertaken to determine position and depths of cables. HS (G) 47 Booklet from the Health and Safety Executive – Avoiding Danger from Buried Cables – should be consulted before commencing excavation work.

WHEN WORKING IN THE VICINITY OF OVERHEAD LINES THE HEALTH AND SAFETY GUIDANCE NOTES GS6 SHOULD BE CONSULTED (AVAILABLE FROM THE HSE WEBSITE)

Voltages (V)

LV (Low Voltage) and Services	Up to 1,000V
HV (High Voltage)	Over 1,000V to 11,000V
EHV (Extra High Voltage)	22,000V to 132,000V
Transmission	275,000V and 400,000V

NORMAL DEPTH TO THE TOP OF THE CABLE WHEN LAID

Services	LV	HV	EHV	
Footpath/Unmade	0.45m	0.45m	0.6m	0.8m
Road Crossing	0.6m	0.6m	0.75m	0.9m
Agricultural	1m	1m	1m	1.1m

Legend

 Service Cable

 LV Mains

 2 – 3.3kV

 6.6kV

 11kV

 22kV

 33kV

 66kV

 132kV

 275kV

 400kV

 Fibre Optic

 Pilot Cable

Distribution Structures (Electric)

 Pole, Existing Location

 Pole Structure, Existing Location - Single

 Pole Structure, Existing Location - H

 Duct Route

 Cross Section Route



Southern Electric Power Distribution plc

Registered Office: No.1 Forbury Place

43 Forbury Road Reading RG1 3JH

Registered in England & Wales No.04094290

If you're unsure & need to seek advice before commencing excavations please contact:

General Enquiries: 0800 048 3516

Subject to revision – Master held by SSEN Asset Data Team:

Asset.Data@ssen.com

01256 337 294

BASED UPON THE ORDNANCE SURVEY MAP WITH THE SANCTION OF THE CONTROLLER OF H.M STATIONERY OFFICE CROWN COPYRIGHT RESERVED.

This copy has been made by or with the authority of Scottish and Southern Energy Power Distribution Ltd. Pursuant to section 47 of the Copyright, Designs and Patents Act 1988 ('The Act'). Unless the Act provides a relevant exception to copyright the copy must not be copied without prior permission of the copyright owner. Plans generated by DigSAFE Pro™ software provided by LinesearchbeforeUdig.



WARNING

There may have been subsequent alteration to the surface levels. Trial holes must be undertaken to determine position and depths of cables. HS (G) 47 Booklet from the Health and Safety Executive – Avoiding Danger from Buried Cables – should be consulted before commencing excavation work.

Scale: 1:500 (When plotted at A3)

Legend

- Service Cable
- LV Mains
- 2 - 3.3kV
- 6.6kV
- 11kV
- 22kV
- 33kV
- 66kV
- 132kV
- 275kV
- 400kV
- Fibre Optic


Other-Item Structures [Electric]

- Pole, Existing Location
- Pole Structure, Existing Location - Single
- Pole Structure, Existing Location - M
- Duct Route
- Cross Section Route



Subject to revision – Master held by SSEN Asset Data Team:
Asset.Data@sse.com
 01256 337 294

BASED UPON THE ORDNANCE SURVEY MAP WITH THE SANCTION OF THE CONTROLLER OF H.M STATIONERY OFFICE CROWN COPYRIGHT RESERVED.
This copy has been made by or with the authority of Scottish and Southern Energy Power Distribution Ltd. Pursuant to section 47 of the Copyright, Designs and Patents Act 1988 ('The Act'). Unless the Act provides a relevant exception to copyright the copy must not be copied without prior permission of the copyright owner. Plans generated by DigSAFE Pro™ software provided by LinesearchbeforeUddig.

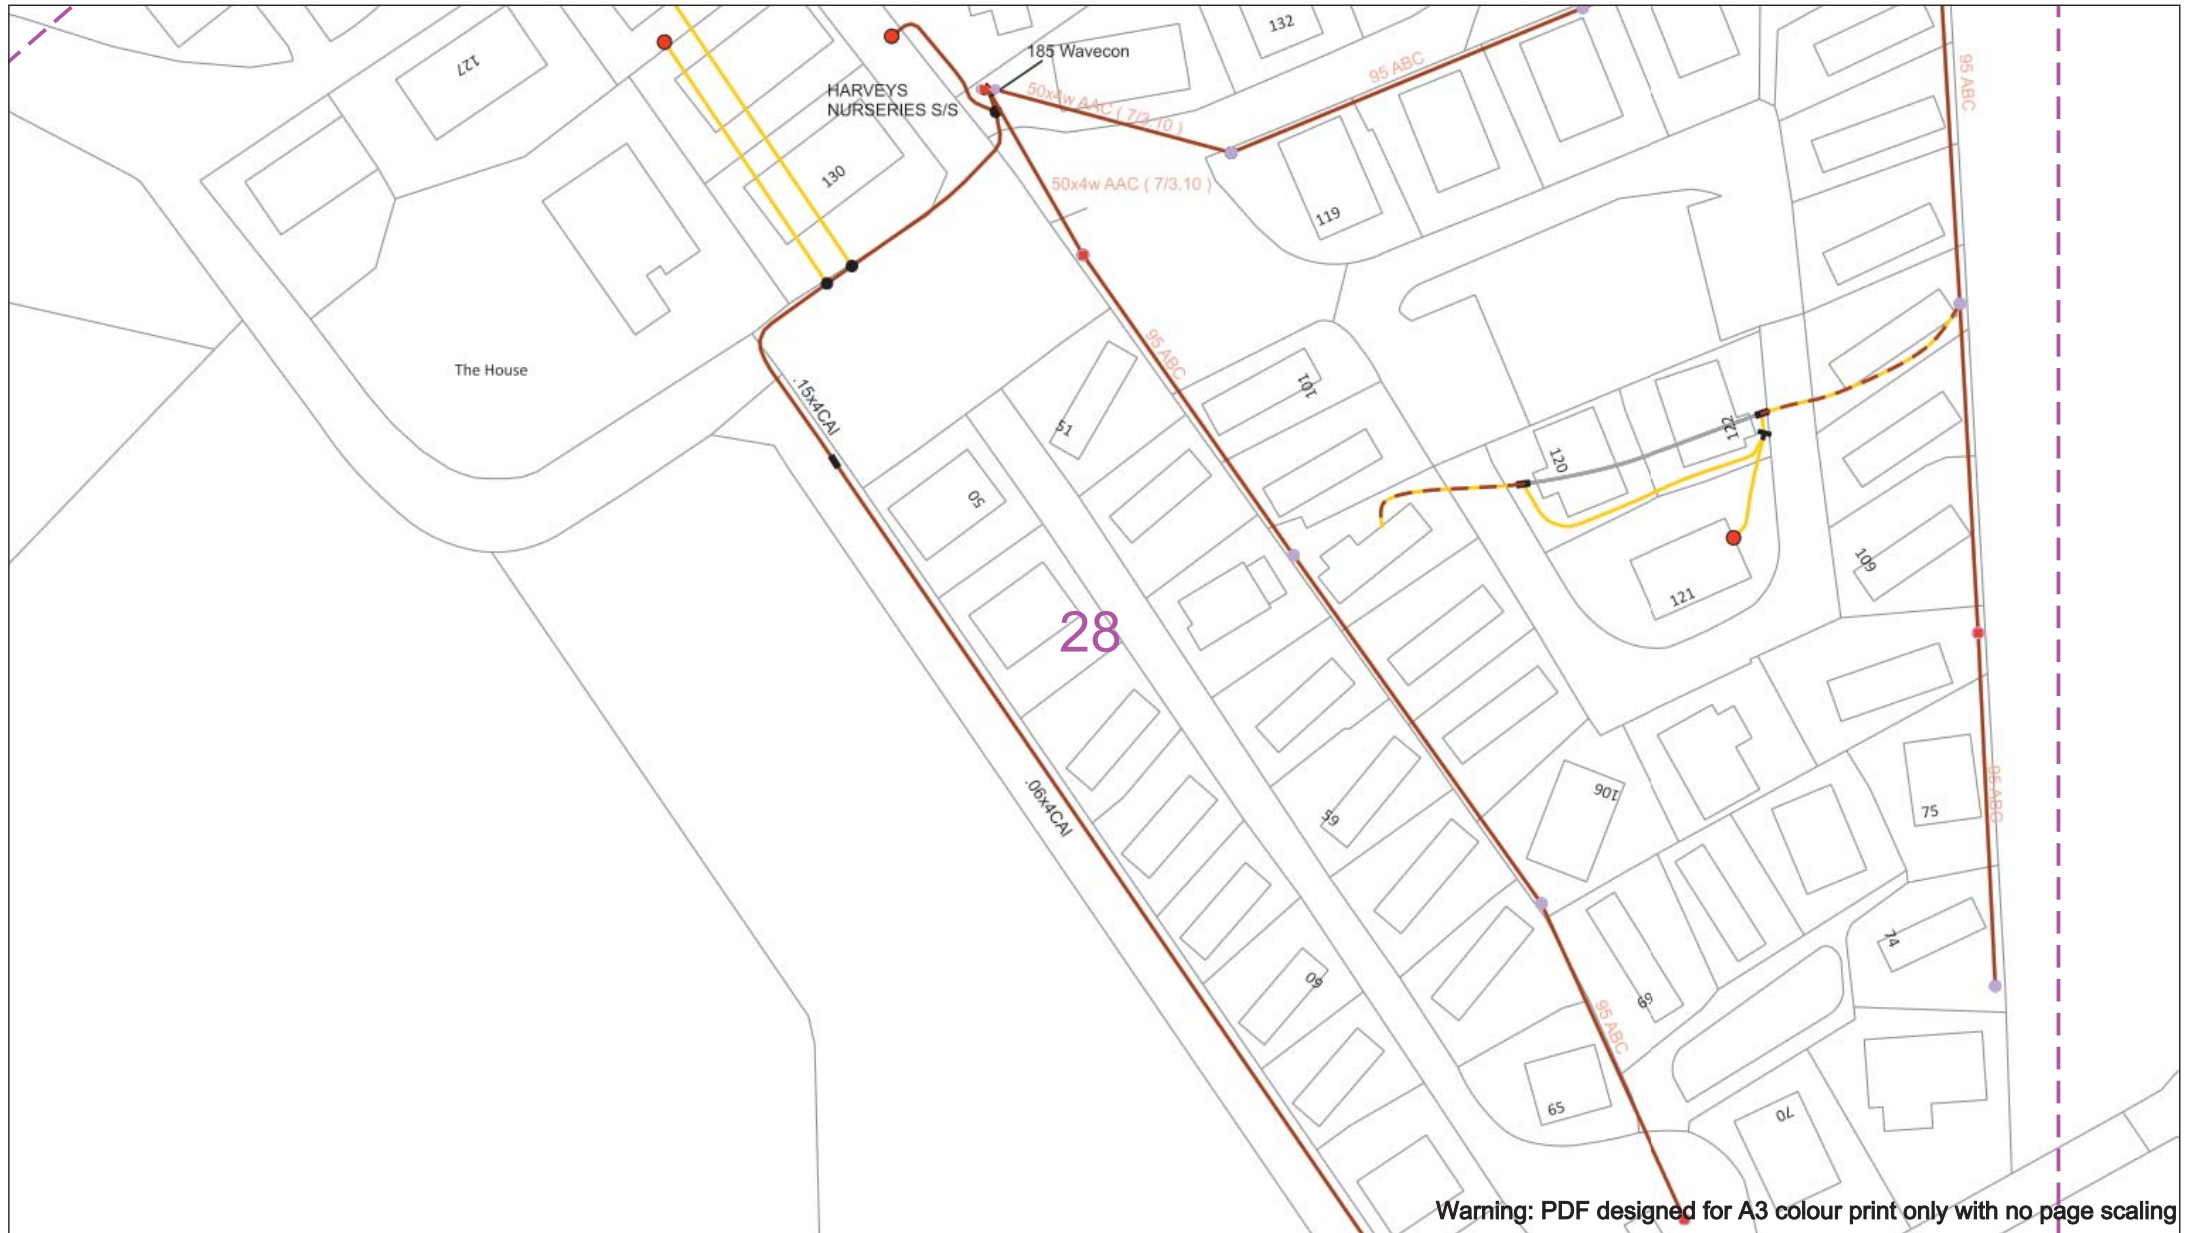

Warning: PDF designed for A3 colour print only with no page scaling

050m

Dig Sites

Area:

Line:

Date Requested: 09/11/2021

Job Reference: 23827726

Site Location: 472556 176139

Requested by: Ms Debbie Wigston

Your Scheme/Reference: 8210940

WARNING

There may have been subsequent alteration to the surface levels. Trial holes must be undertaken to determine position and depths of cables. HS (G) 47 Booklet from the Health and Safety Executive – Avoiding Danger from Buried Cables – should be consulted before commencing excavation work.

WHEN WORKING IN THE VICINITY OF OVERHEAD LINES THE HEALTH AND SAFETY GUIDANCE NOTES GS6 SHOULD BE CONSULTED (AVAILABLE FROM THE HSE WEBSITE)

Voltages (V)				
LV (Low Voltage) and Services	Up to 1,000V			
LV Mains	Over 1,000V to 11,000V			
HV (High Voltage)	22,000V to 132,000V			
EHV (Extra High Voltage)	275,000V and 400,000V			
Transmission	275,000V and 400,000V			

NORMAL DEPTH TO THE TOP OF THE CABLE WHEN LAID				
	Services	LV	HV	EHV
Footpath/Unmade	0.45m	0.45m	0.6m	0.8m
Road Crossing	0.6m	0.6m	0.75m	0.9m
Agricultural	1m	1m	1m	1.1m

Legend

Service Cable

LV Mains

2 – 3.3kV

6.6kV

11kV

22kV

33kV

66kV

132kV

275kV

400kV

Flow Optic

Pole Cable

Distribution Structures (Electric)

Pole, Existing Location

Pole Structure, Existing Location - Single

Pole Structure, Existing Location - H

Duct Route

Cross Section Route

Southern Electric Power Distribution plc

Registered Office: No.1 Forbury Place

43 Forbury Road Reading RG1 3JH

Registered in England & Wales No.04094290

If you're unsure & need to seek advice before commencing excavations please contact:

General Enquiries: 0800 048 3516

Subject to revision – Master held by SSEN Asset Data Team:

AssetData@ssen.com

01256 337 294

Scale: 1:500 (When plotted at A3)

BASED UPON THE ORDNANCE SURVEY MAP WITH THE SANCTION OF THE CONTROLLER OF H.M. STATIONERY OFFICE CROWN COPYRIGHT RESERVED.

This copy has been made by or with the authority of Scottish and Southern Energy Power Distribution Ltd. Pursuant to section 47 of the Copyright, Designs and Patents Act 1988 ('The Act'). Unless the Act provides a relevant exception to copyright the copy must not be copied without prior permission of the copyright owner. Plans generated by DigSAFE Pro™ software provided by LinesearchbeforeUdig.

Warning: PDF designed for A3 colour print only with no page scaling

050m

Dig Sites

Area: 

Line: 

Date Requested: 09/11/2021

Job Reference: 23827726

Site Location: 472556 176139

Requested by: Ms Debbie Wigston

Your Scheme/Reference: 8210940

WARNING

There may have been subsequent alteration to the surface levels. Trial holes must be undertaken to determine position and depths of cables. HS (G) 47 Booklet from the Health and Safety Executive – Avoiding Danger from Buried Cables – should be consulted before commencing excavation work.

WHEN WORKING IN THE VICINITY OF OVERHEAD LINES THE HEALTH AND SAFETY GUIDANCE NOTES GS6 SHOULD BE CONSULTED (AVAILABLE FROM THE HSE WEBSITE)

Voltages (V)

LV (Low Voltage) and Services	Up to 1,000V
HV (High Voltage)	Over 1,000V to 11,000V
EHV (Extra High Voltage)	22,000V to 132,000V
Transmission	275,000V and 400,000V

NORMAL DEPTH TO THE TOP OF THE CABLE WHEN LAID

Services	LV	HV	EHV
Footpath/Unmade	0.45m	0.45m	0.6m
Road Crossing	0.6m	0.6m	0.75m
Agricultural	1m	1m	1.1m

Legend

	Service Cable
	LV Mains
	2 – 3.3kV
	6.6kV
	11kV
	22kV
	33kV
	66kV
	132kV
	275kV
	400kV
	Fluoro-Optic
	Pilot Cable

Distribution Structures (Electric)

	Pole, Existing Location
	Pole Structure, Existing Location - Single
	Pole Structure, Existing Location - H
	Duct Route
	Cross Section Route



Southern Electric Power Distribution plc

Registered Office: No.1 Forbury Place
43 Forbury Road Reading RG1 3JH
Registered in England & Wales No.04094290

If you're unsure & need to seek advice before commencing excavations please contact:
General Enquiries: 0800 048 3516

Subject to revision – Master held by SSEN Asset Data Team:
Asset.Data@ssen.com
01256 337 294

BASED UPON THE ORDNANCE SURVEY MAP WITH THE SANCTION OF THE CONTROLLER OF H.M STATIONERY OFFICE CROWN COPYRIGHT RESERVED.

This copy has been made by or with the authority of Scottish and Southern Energy Power Distribution Ltd. Pursuant to section 47 of the Copyright, Designs and Patents Act 1988 ('The Act'). Unless the Act provides a relevant exception to copyright the copy must not be copied without prior permission of the copyright owner. Plans generated by DigSAFE Pro™ software provided by LinesearchbeforeUdig.

30

Warning: PDF designed for A3 colour print only with no page scaling

0 50m

Dig Sites Area: Line:

Date Requested: 09/11/2021
Job Reference: 23827726
Site Location: 472556 176139
Requested by:
Ms Debbie Wigston
Your Scheme/Reference: 8210940

WARNING

There may have been subsequent alteration to the surface levels. Trial holes must be undertaken to determine position and depths of cables. HS (G) 47 Booklet from the Health and Safety Executive – Avoiding Danger from Buried Cables – should be consulted before commencing excavation work.

WHEN WORKING IN THE VICINITY OF OVERHEAD LINES THE HEALTH AND SAFETY GUIDANCE NOTES GS6 SHOULD BE CONSULTED (AVAILABLE FROM THE HSE WEBSITE)

Scale: 1:500 (When plotted at A3)

Voltages (V)				
LV (Low Voltage) and Services	Up to 1,000V			
HV (High Voltage)	Over 1,000V to 11,000V			
EHV (Extra High Voltage)	22,000V to 132,000V			
Transmission	275,000V and 400,000V			

NORMAL DEPTH TO THE TOP OF THE CABLE WHEN LAID				
Services	LV	HV	EHV	
Footpath/Unmade	0.45m	0.45m	0.6m	0.8m
Road Crossing	0.6m	0.6m	0.75m	0.9m
Agricultural	1m	1m	1m	1.1m

Legend	
Service Cable	
LV Mains	
2 – 3.3kV	
6.6kV	
11kV	
22kV	
33kV	
66kV	
132kV	
275kV	
400kV	
Flow Cable	
Pile Cable	

Distribution Structures (Electric)	
Pole, Existing Location	
Pole Structure, Existing Location - Single	
Pole Structure, Existing Location - H	
Duct Route	
Cross Section Route	



Southern Electric Power Distribution plc
Registered Office: No.1 Forbury Place
43 Forbury Road Reading RG1 3JH
Registered in England & Wales No.04094290

If you're unsure & need to seek advice before commencing excavations please contact:
General Enquiries: 0800 048 3516

Subject to revision – Master held by SSN Asset Data Team:
Asset.Data@sen.com
01256 337 294



WARNING

WHEN WORKING IN THE VICINITY OF OVERHEAD LINES THE HEALTH AND SAFETY GUIDANCE NOTES GS6 SHOULD BE CONSULTED (AVAILABLE FROM THE HSE WEBSITE)

Voltages (V)	
LV (Low Voltage) and Services	Up to 1,000V
HV (High Voltage)	Over 1,000V to 11,000V
EHV (Extra High Voltage)	22,000V to 132,000V
Transmission	275,000V and 400,000V

NORMAL DEPTH TO THE TOP OF THE CABLE WHEN LAID				
	Services	LV	HV	EHV
Footpath/Unmade	0.45m	0.45m	0.6m	0.8m
Road Crossing	0.6m	0.6m	0.75m	0.9m
Agricultural	1m	1m	1m	1.1m

Legend

- Service Cable
- 1V Mains
- 2 – 3.3kV
- 5.5kV
- 11kV
- 22kV
- 33kV
- 66kV
- 132kV
- 275kV
- 400kV
- Fibre Optic
- Pilot Cable

Distribution Structures [Electric]

- Pole, Existing Location
- Pole Structure, Existing Location
- Pole Structure, Existing Location

Duct Route


Cross Section Route



If you're unsure & need to seek advice before commencing excavations please contact:
General Enquiries: 0800 048 3516

Subject to revision – Master held by SSEN Asset Data Team:
Asset.Data@sse.com
 01256 337 294

This copy has been made by or with the authority of Scottish and Southern Energy Power Distribution Ltd. Pursuant to section 47 of the Copyright, Designs and Patents Act 1988 ("The Act"). Unless the Act provides a relevant exception to copyright this copy must not be copied without prior permission of the copyright owner. Plans generated by DigSAFE Pro™ software provided by LinesearchbeforeUdig.

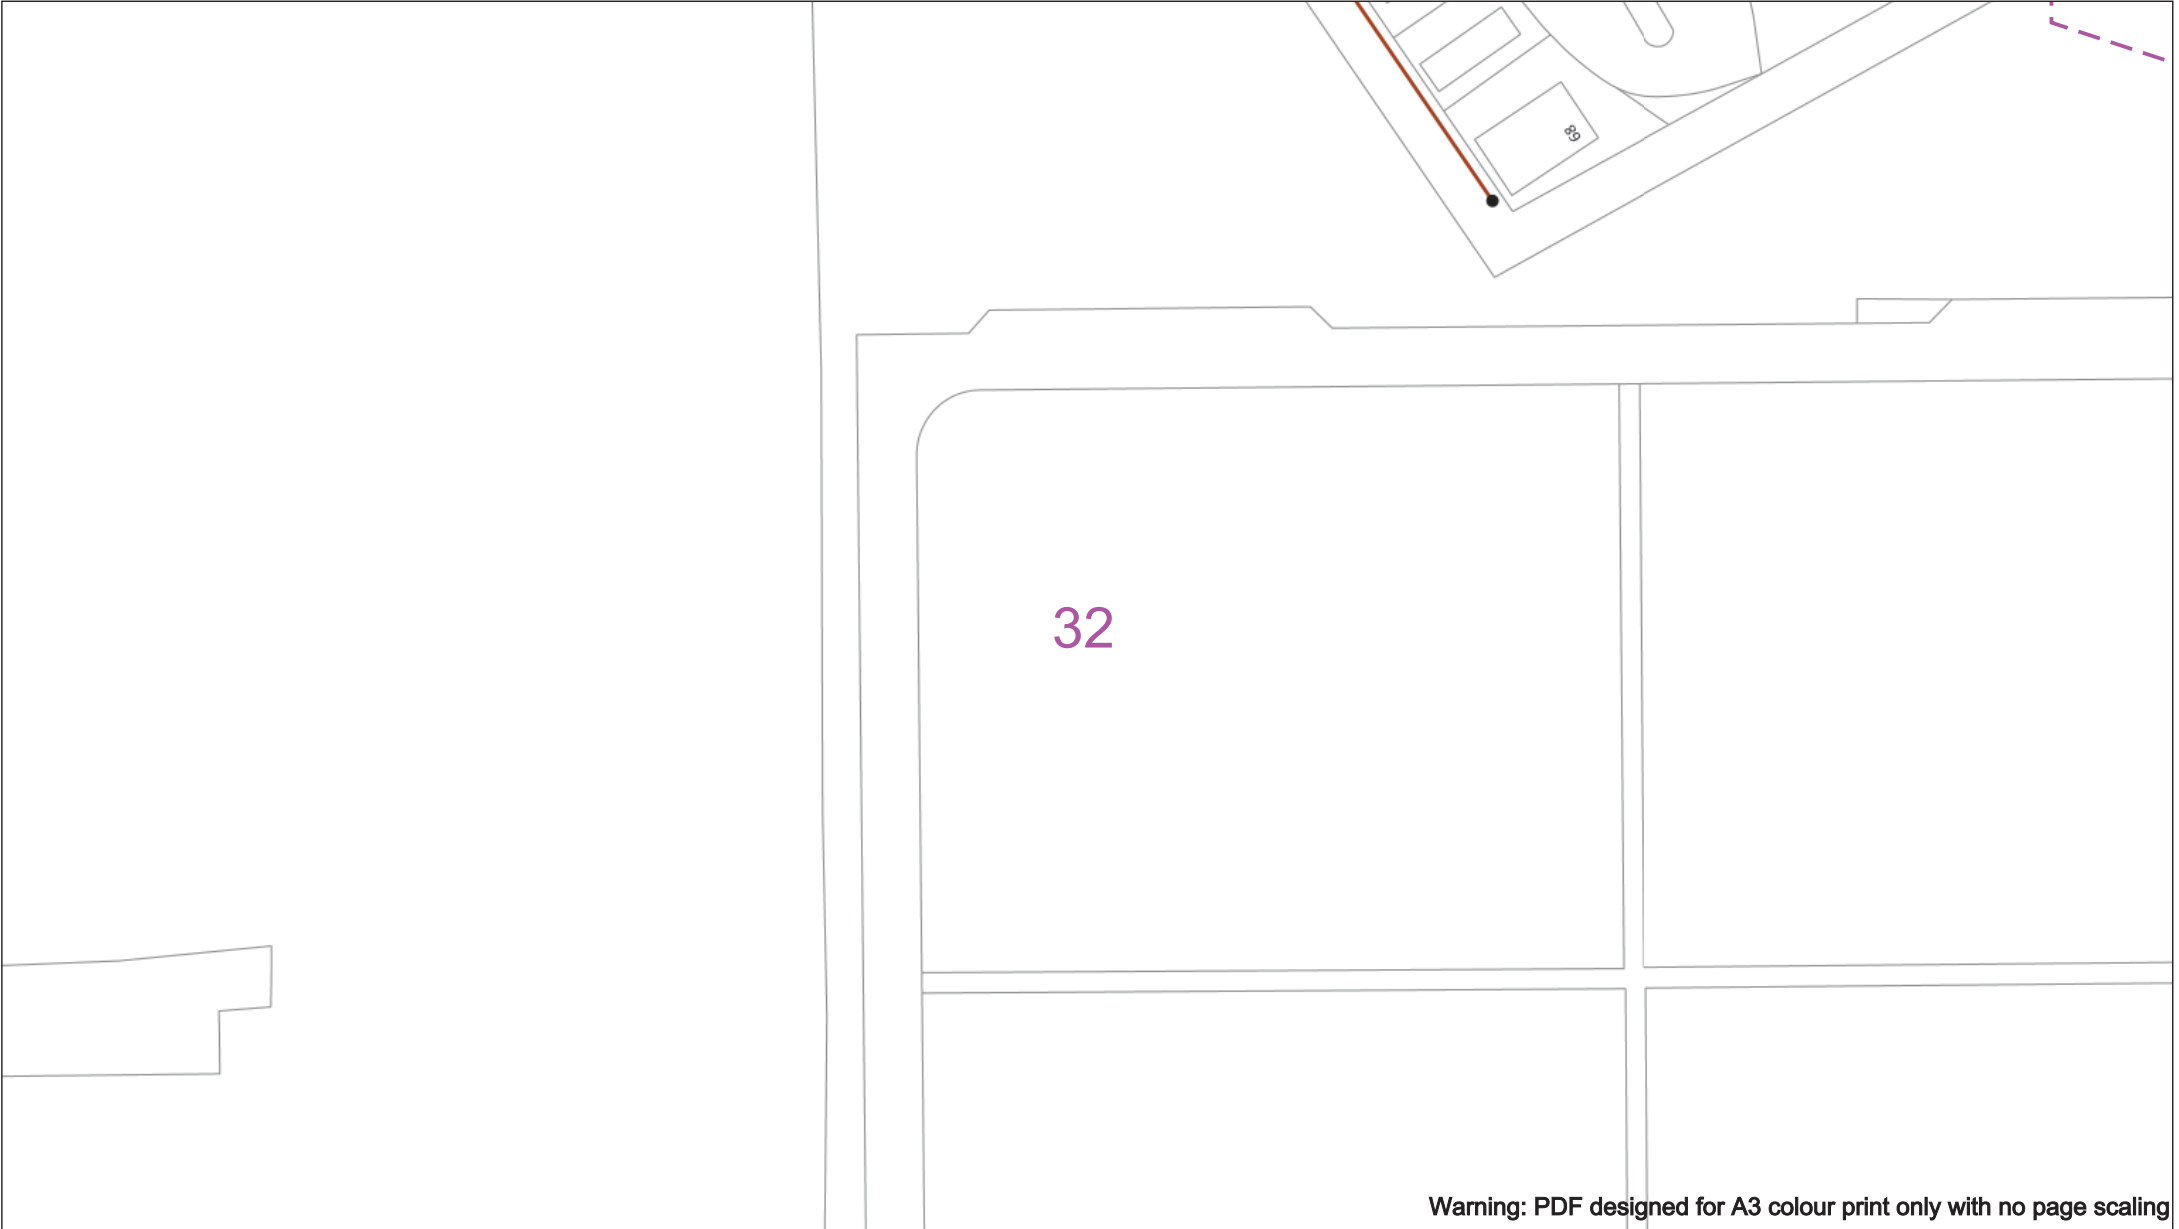

Warning: PDF designed for A3 colour print only with no page scaling

050m

Dig Sites

Area:

Line:

Date Requested: 09/11/2021

Job Reference: 23827726

Site Location: 472556 176139

Requested by: Ms Debbie Wigston

Your Scheme/Reference: 8210940

WARNING

There may have been subsequent alteration to the surface levels. Trial holes must be undertaken to determine position and depths of cables. HS (G) 47 Booklet from the Health and Safety Executive – Avoiding Danger from Buried Cables – should be consulted before commencing excavation work.

WHEN WORKING IN THE VICINITY OF OVERHEAD LINES THE HEALTH AND SAFETY GUIDANCE NOTES GS6 SHOULD BE CONSULTED (AVAILABLE FROM THE HSE WEBSITE)

Voltages (V)				
LV (Low Voltage) and Services	Up to 1,000V			
HV (High Voltage)	Over 1,000V to 11,000V			
EHV (Extra High Voltage)	22,000V to 132,000V			
Transmission	275,000V and 400,000V			

NORMAL DEPTH TO THE TOP OF THE CABLE WHEN LAID				
Services	LV	HV	EHV	
Footpath/Unmade	0.45m	0.45m	0.6m	0.8m
Road Crossing	0.6m	0.6m	0.75m	0.9m
Agricultural	1m	1m	1m	1.1m

Legend

Service Cable

LV Mains

2 – 3.3kV

6.6kV

11kV

22kV

33kV

66kV

132kV

275kV

400kV

Fibre Optic

Pilot Cable

Distribution Structures (Electric)

Pole, Existing Location

Pole Structure, Existing Location - Single

Pole Structure, Existing Location - H

Duct Route

Cross Section Route

Southern Electric Power Distribution plc
Registered Office: No.1 Forbury Place
43 Forbury Road Reading RG1 3JH
Registered in England & Wales No.04094290

If you're unsure & need to seek advice before commencing excavations please contact:
General Enquiries: 0800 048 3516

Subject to revision – Master held by SSEN Asset Data Team:
Asset.Data@ssen.com
01256 337 294

BASED UPON THE ORDNANCE SURVEY MAP WITH THE SANCTION OF THE CONTROLLER OF H.M STATIONERY OFFICE CROWN COPYRIGHT RESERVED.

This copy has been made by or with the authority of Scottish and Southern Energy Power Distribution Ltd. Pursuant to section 47 of the Copyright, Designs and Patents Act 1988 ('The Act'). Unless the Act provides a relevant exception to copyright the copy must not be copied without prior permission of the copyright owner. Plans generated by DigSAFE Pro™ software provided by LinesearchbeforeUdig.



Warning: PDF designed for A3 colour print only with no page scaling

0 50m

Dig Sites Area: Line:

Date Requested: 09/11/2021
Job Reference: 23827726
Site Location: 472556 176139
Requested by:
Ms Debbie Wigston
Your Scheme/Reference: 8210940

WARNING

There may have been subsequent alteration to the surface levels. Trial holes must be undertaken to determine position and depths of cables. HS (G) 47 Booklet from the Health and Safety Executive – Avoiding Danger from Buried Cables – should be consulted before commencing excavation work.

WHEN WORKING IN THE VICINITY OF OVERHEAD LINES THE HEALTH AND SAFETY GUIDANCE NOTES GS6 SHOULD BE CONSULTED (AVAILABLE FROM THE HSE WEBSITE)

Voltages (V)				
LV (Low Voltage) and Services	Up to 1,000V			
HV (High Voltage)	Over 1,000V to 11,000V			
EHV (Extra High Voltage)	22,000V to 132,000V			
Transmission	275,000V and 400,000V			

NORMAL DEPTH TO THE TOP OF THE CABLE WHEN LAID				
Services	LV	HV	EHV	
Footpath/Unmade	0.45m	0.45m	0.6m	0.8m
Road Crossing	0.6m	0.6m	0.75m	0.9m
Agricultural	1m	1m	1m	1.1m

Legend

- Service Cable
- LV Mains
- 2 – 3.3kV
- 6.6kV
- 11kV
- 22kV
- 33kV
- 66kV
- 132kV
| 275kV | 400kV | Fibre Optic | Pilot Cable |

Distribution Structures (Electric)

- Pole, Existing Location
- Pole Structure, Existing Location - Single
- Pole Structure, Existing Location - H
- Duct Route
- Cross Section Route


Southern Electric Power Distribution plc
Registered Office: No.1 Forbury Place
43 Forbury Road Reading RG1 3JH
Registered in England & Wales No.04094290

If you're unsure & need to seek advice before commencing excavations please contact:
General Enquiries: 0800 048 3516

Subject to revision – Master held by SSN Asset Data Team:
Asset.Data@ssn.com
01256 337 294

BASED UPON THE ORDNANCE SURVEY MAP WITH THE SANCTION OF THE CONTROLLER OF H.M. STATIONERY OFFICE CROWN COPYRIGHT RESERVED.

This copy has been made by or with the authority of Scottish and Southern Energy Power Distribution Ltd. Pursuant to section 47 of the Copyright, Designs and Patents Act 1988 ('The Act'). Unless the Act provides a relevant exception to copyright the copy must not be copied without prior permission of the copyright owner. Plans generated by DigSAFE Pro™ software provided by LinesearchbeforeUdig.

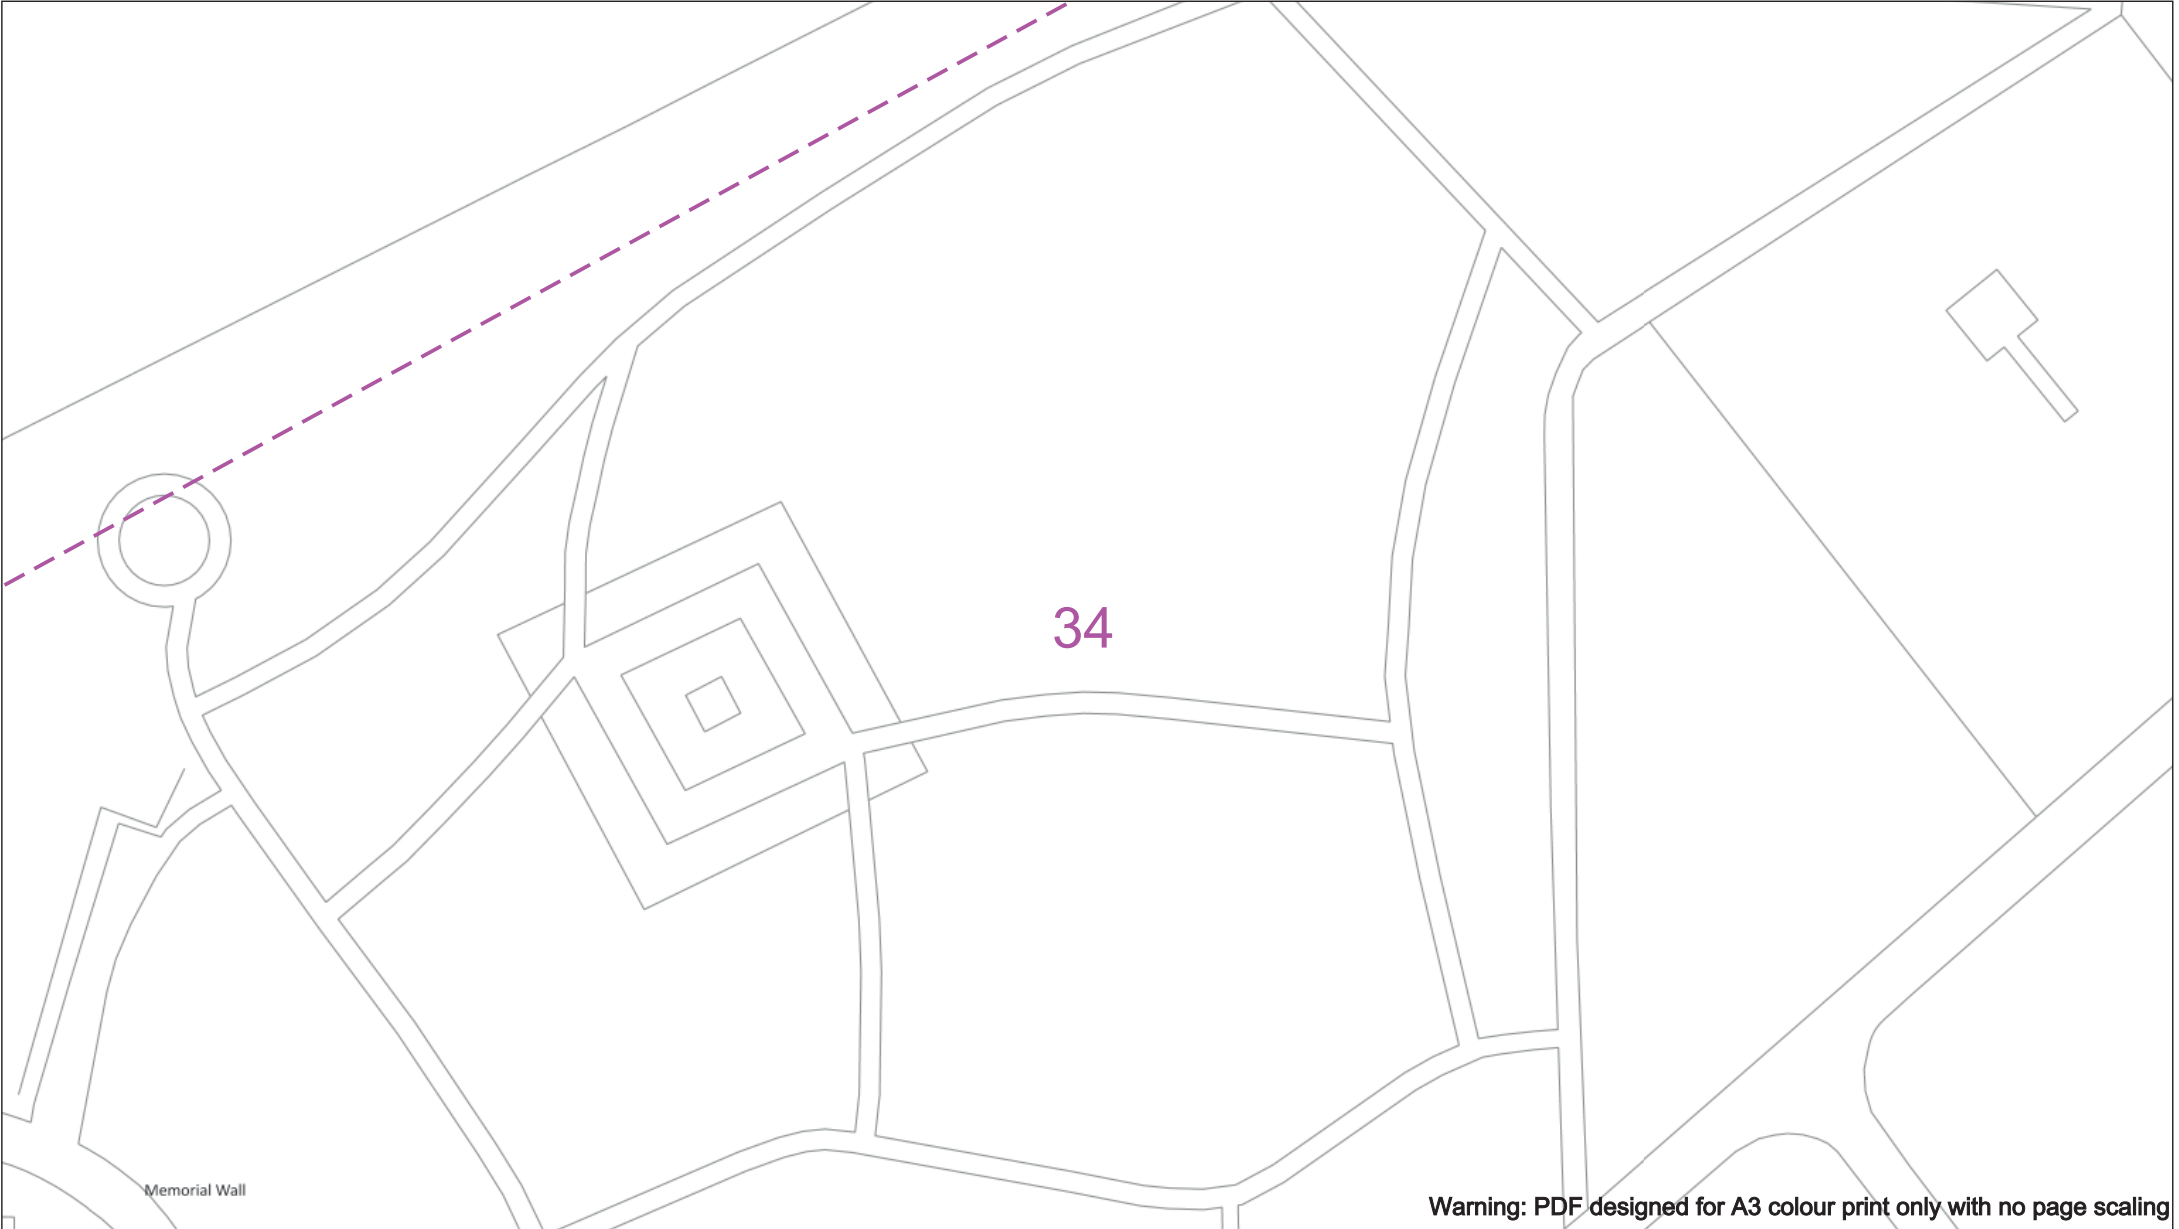

Memorial Wall

Warning: PDF designed for A3 colour print only with no page scaling

050m

Dig Sites

Area:

Line:

Date Requested: 09/11/2021

Job Reference: 23827726

Site Location: 472556 176139

Requested by: Ms Debbie Wigston

Your Scheme/Reference: 8210940

WARNING

There may have been subsequent alteration to the surface levels. Trial holes must be undertaken to determine position and depths of cables. HS (G) 47 Booklet from the Health and Safety Executive – Avoiding Danger from Buried Cables – should be consulted before commencing excavation work.

WHEN WORKING IN THE VICINITY OF OVERHEAD LINES THE HEALTH AND SAFETY GUIDANCE NOTES GS6 SHOULD BE CONSULTED (AVAILABLE FROM THE HSE WEBSITE)

Voltages (V)

LV (Low Voltage) and Services

Up to 1,000V

HV (High Voltage)

Over 1,000V to 11,000V

EHV (Extra High Voltage)

22,000V to 132,000V

Transmission

275,000V and 400,000V

NORMAL DEPTH TO THE TOP OF THE CABLE WHEN LAID

Services	LV	HV	EHV
Footpath/Unmade	0.45m	0.45m	0.6m
Road Crossing	0.6m	0.6m	0.75m
Agricultural	1m	1m	1.1m

Legend

Service Cable

LV Mains

2 – 3.3kV

6.6kV

11kV

22kV

33kV

66kV

132kV

275kV

400kV

Fibre Optic

Pilot Cable

Distribution Structures (Electric)

Pole, Existing Location

Pole Structure, Existing Location - Single

Pole Structure, Existing Location - H

Duct Route


Cross Section Route

Southern Electric Power Distribution plc
Registered Office: No.1 Forbury Place
43 Forbury Road Reading RG1 3JH
Registered in England & Wales No.04094290

If you're unsure & need to seek advice before commencing excavations please contact:
General Enquiries: 0800 048 3516

Subject to revision – Master held by SSEN Asset Data Team:
Asset.Data@scn.com
01256 337 294

BASED UPON THE ORDNANCE SURVEY MAP WITH THE SANCTION OF THE CONTROLLER OF H.M STATIONERY OFFICE CROWN COPYRIGHT RESERVED.
This copy has been made by or with the authority of Scottish and Southern Energy Power Distribution Ltd. Pursuant to section 47 of the Copyright, Designs and Patents Act 1988 ('The Act'). Unless the Act provides a relevant exception to copyright the copy must not be copied without prior permission of the copyright owner. Plans generated by DigSAFE Pro™ software provided by LinesearchbeforeUdig.

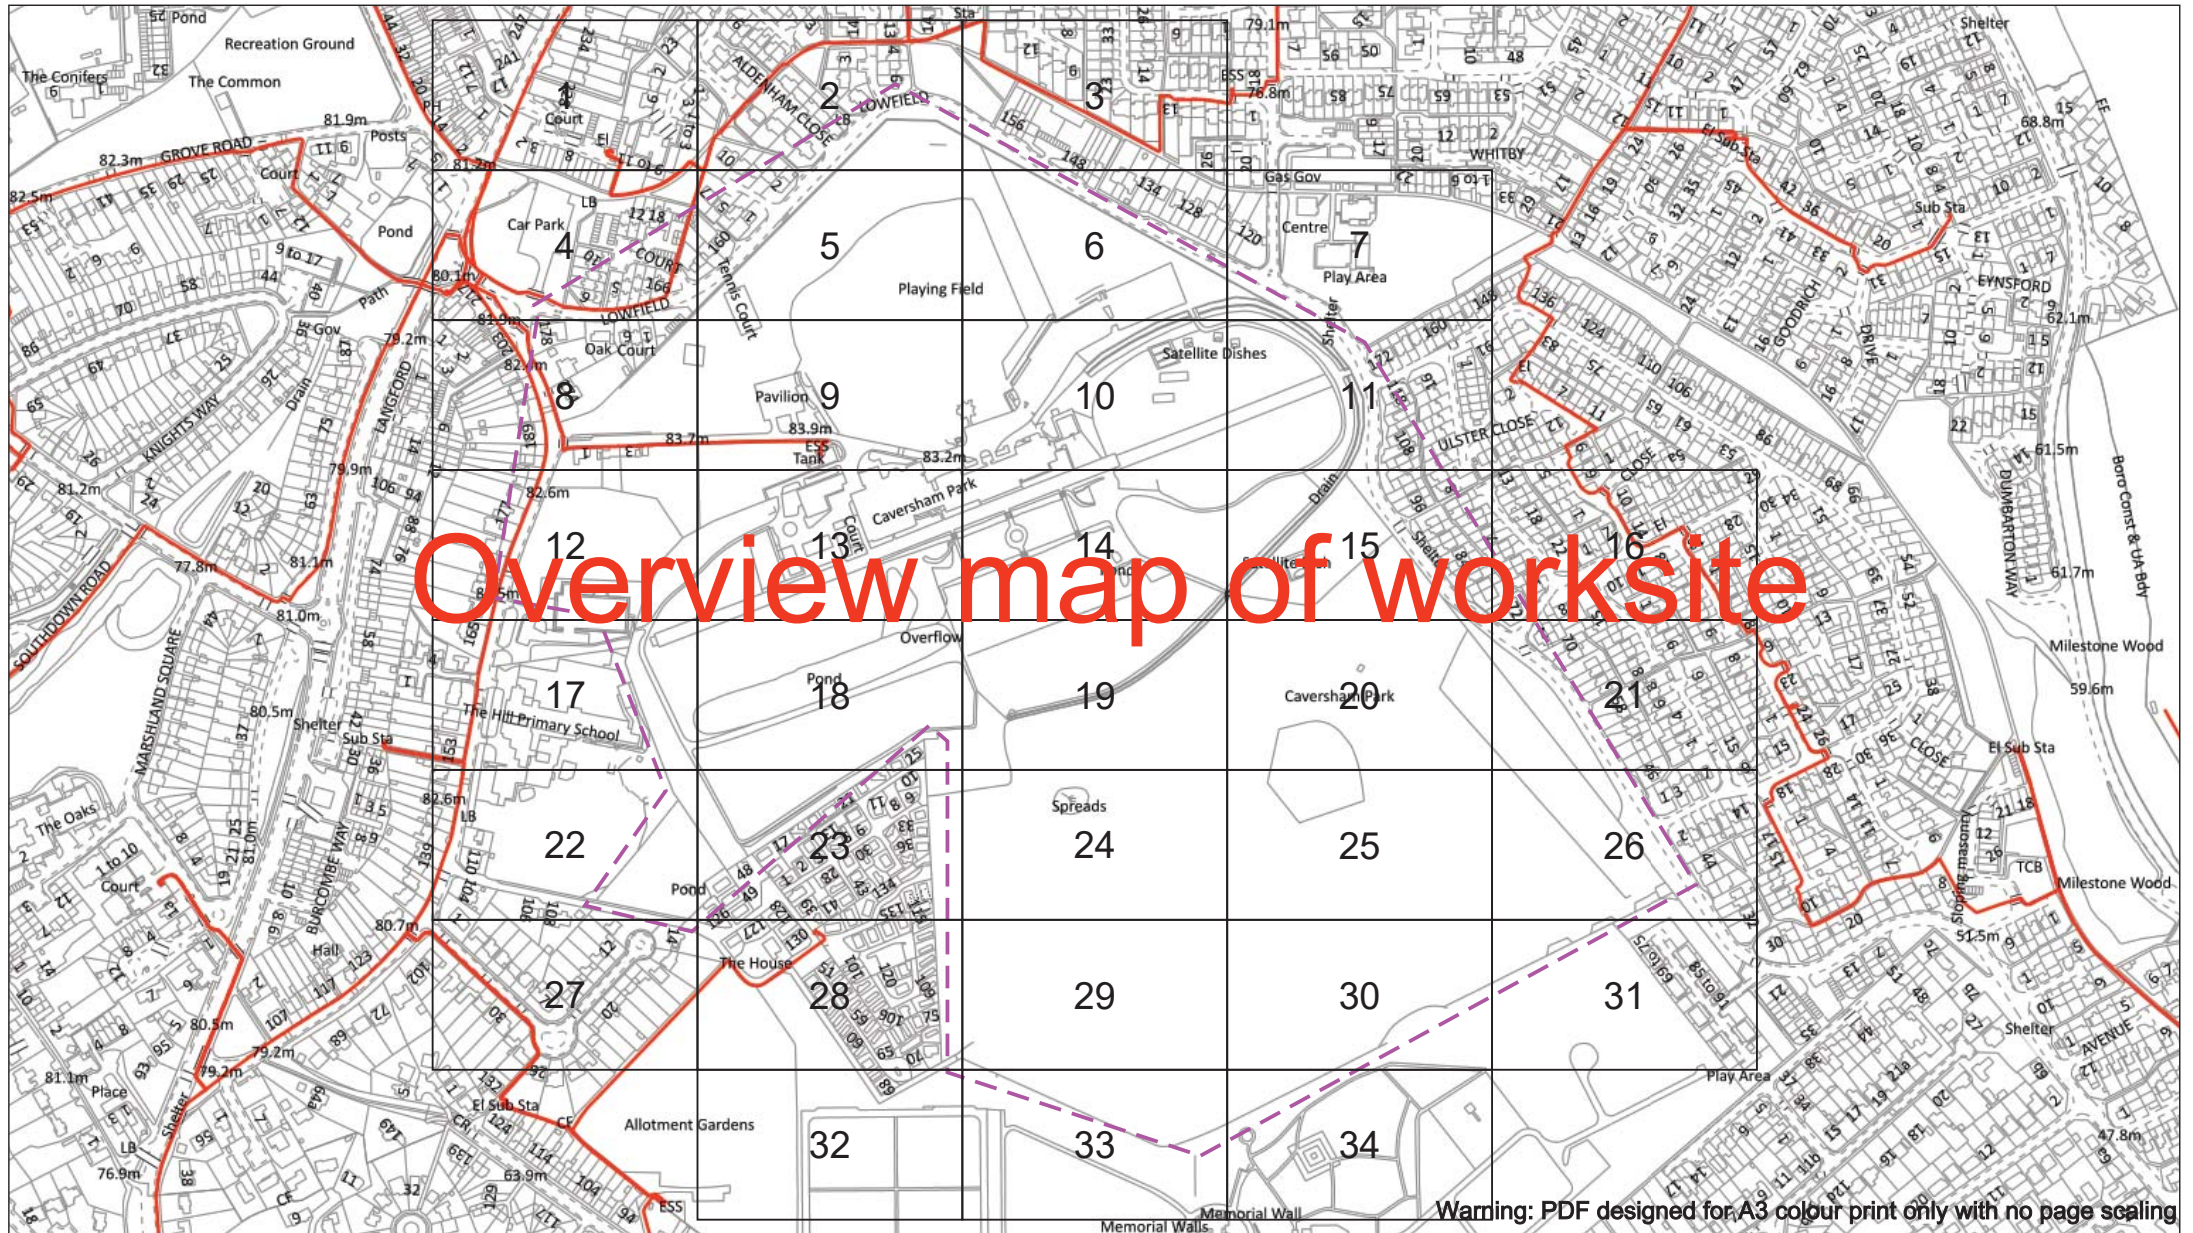

Warning: PDF designed for A3 colour print only with no page scaling

Date Requested: 09/11/2021
Job Reference: 23827726
Site Location: 472556 176139
Requested by:
Ms Debbie Wigston
Your Scheme/Reference:
8210940

Scale: 1:4100 (When plotted at A3)

WARNING
There may have been subsequent alteration to the surface levels. Trial holes must be undertaken to determine position and depths of cables. HS (G) 47 Booklet from the Health and Safety Executive – Avoiding Danger from Buried Cables – should be consulted before commencing excavation work.

WHEN WORKING IN THE VICINITY OF OVERHEAD LINES THE HEALTH AND SAFETY GUIDANCE NOTES GS6 SHOULD BE CONSULTED (AVAILABLE FROM THE HSE WEBSITE)

Voltages (V)				
LV (Low Voltage) and Services	Up to 1,000V	LV	HV	EHV
HV (High Voltage)	Over 1,000V to 11,000V			
EHV (Extra High Voltage)	22,000V to 132,000V			
Transmission	275,000V and 400,000V			
NORMAL DEPTH TO THE TOP OF THE CABLE WHEN LAID				
Services	LV	HV	EHV	
Footpath/Unmade	0.45m	0.45m	0.6m	0.8m
Road Crossing	0.6m	0.6m	0.75m	0.9m
Agricultural	1m	1m	1m	1.1m

Legend

- Service Cable
- LV Mains
- 2-3.3kV
- 6.6kV
- 11kV
- 22kV
- 33kV
- 66kV
- 132kV
- 275kV
- 400kV
- Flow Cyclic
- Pilot Cable

Distribution Structures (Electric)


- Pole, Existing Location
- Pole Structure, Existing Location - Single
- Pole Structure, Existing Location - H
- Duct Route
- Cross Section Route



Southern Electric Power Distribution plc
Registered Office: No.1 Forbury Place
43 Forbury Road Reading RG1 3JH
Registered in England & Wales No.04094290

If you're unsure & need to seek advice before commencing excavations please contact:
General Enquiries: 0800 048 3516

Subject to revision – Master held by SSEN Asset Data Team:
AssetData@scsn.com
01256 337 294

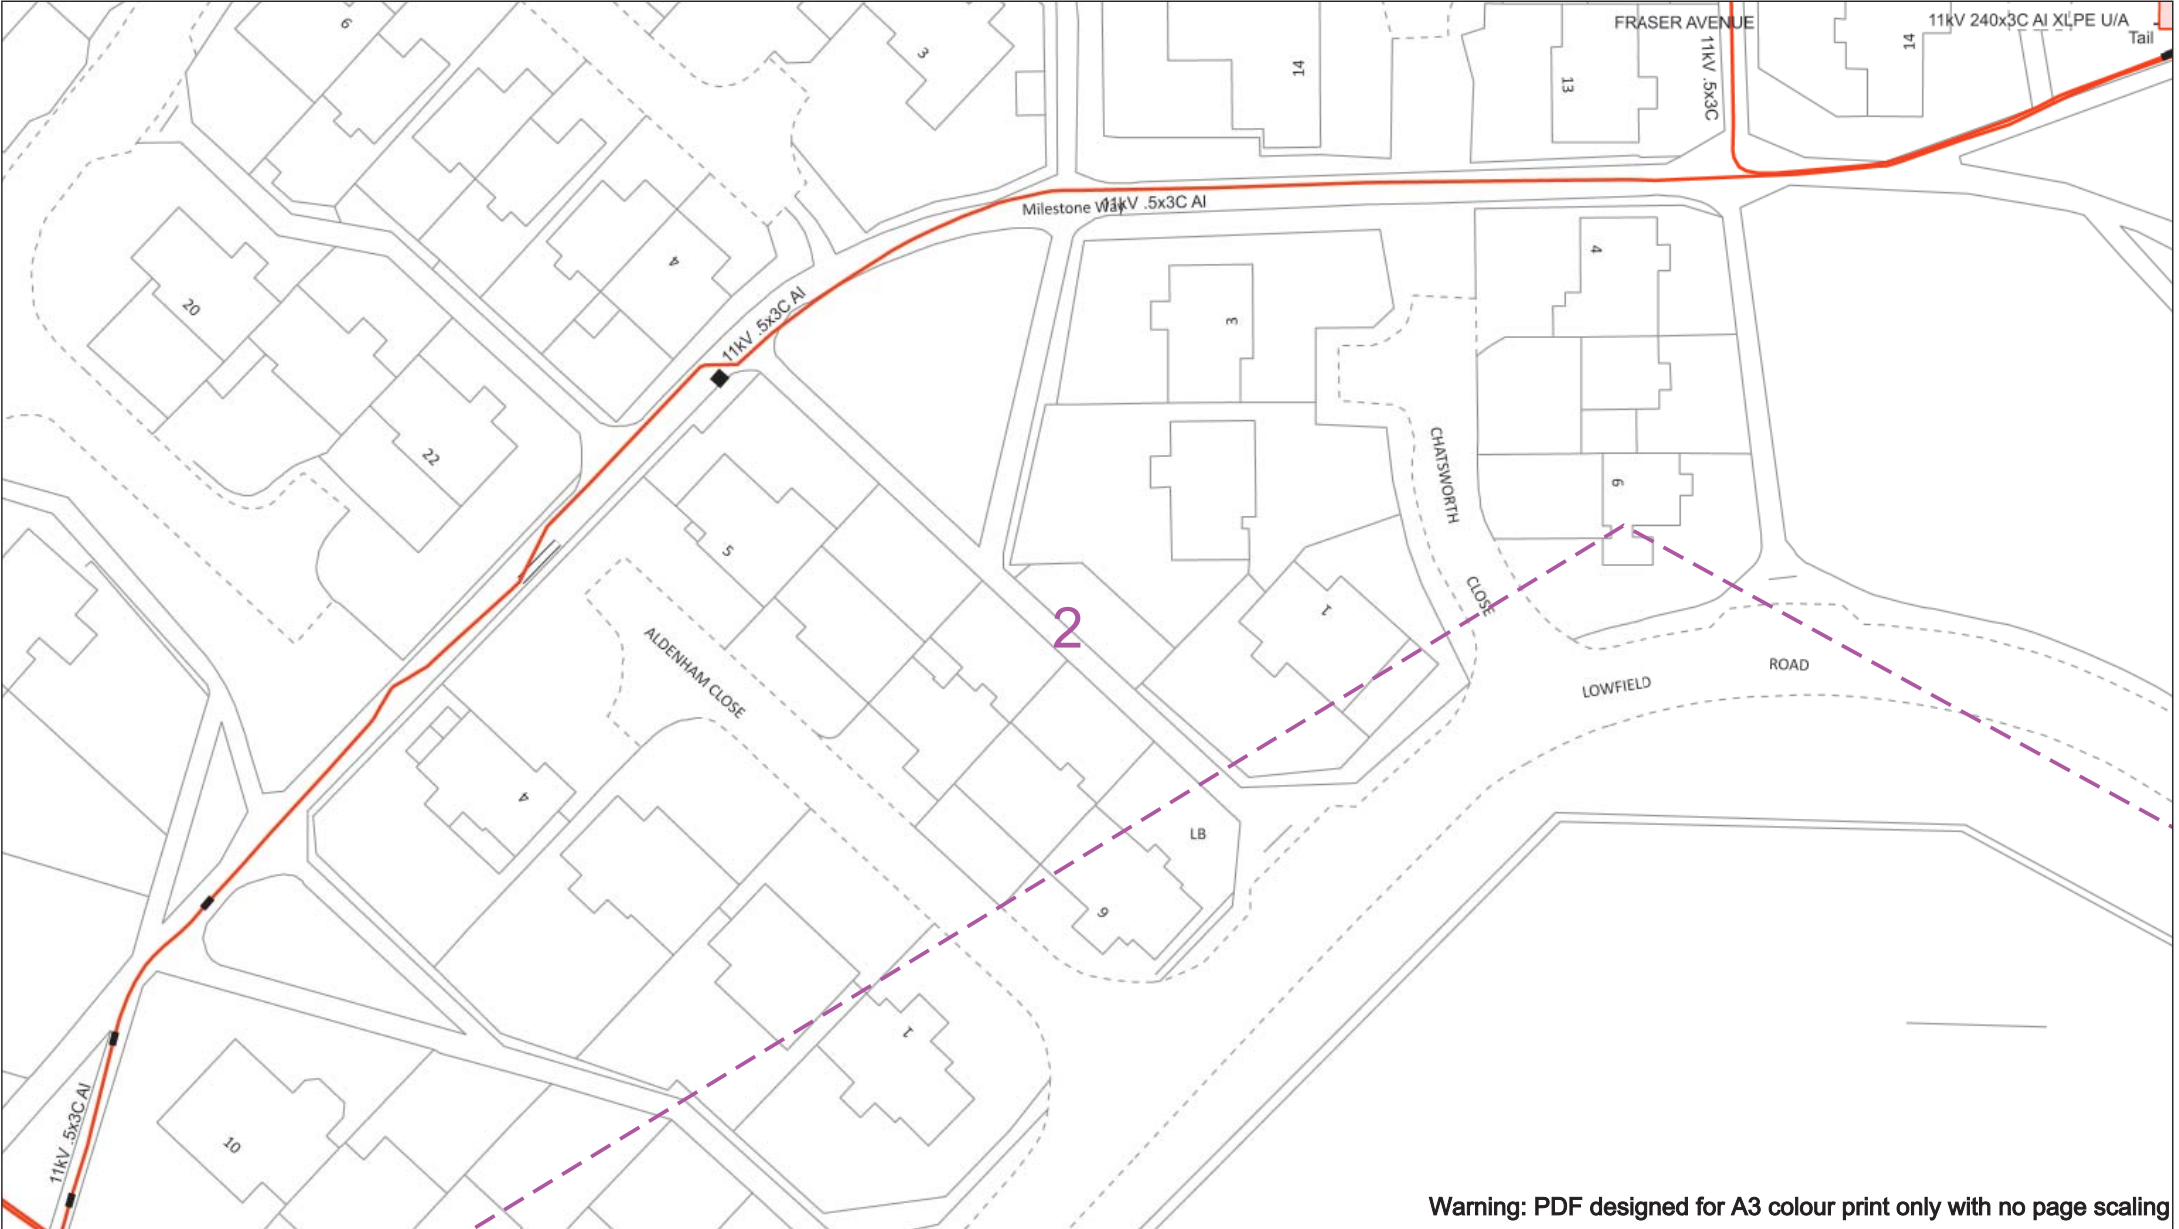

Warning: PDF designed for A3 colour print only with no page scaling

050m

Dig Sites

Area:

Line:

Date Requested: 09/11/2021

Job Reference: 23827726

Site Location: 472556 176139

Requested by: Ms Debbie Wigston

Your Scheme/Reference: 8210940

WARNING

There may have been subsequent alteration to the surface levels. Trial holes must be undertaken to determine position and depths of cables. HS (G) 47 Booklet from the Health and Safety Executive – Avoiding Danger from Buried Cables – should be consulted before commencing excavation work.

WHEN WORKING IN THE VICINITY OF OVERHEAD LINES THE HEALTH AND SAFETY GUIDANCE NOTES GS6 SHOULD BE CONSULTED (AVAILABLE FROM THE HSE WEBSITE)

Voltages (V)				
LV (Low Voltage) and Services	Up to 1,000V			
LV Mains	Over 1,000V to 11,000V			
HV (High Voltage)	22,000V to 132,000V			
EHV (Extra High Voltage)	275,000V and 400,000V			
Transmission	275,000V and 400,000V			

NORMAL DEPTH TO THE TOP OF THE CABLE WHEN LAID				
Services	LV	HV	EHV	
Footpath/Unmade	0.45m	0.45m	0.6m	0.8m
Road Crossing	0.6m	0.6m	0.75m	0.9m
Agricultural	1m	1m	1m	1.1m

Legend

Service Cable

LV Mains

2 – 3.3kV

6.6kV

11kV

22kV

33kV

66kV

132kV

275kV

400kV

Fluo Optic

Pile Cable

Distribution Structures (Electric)

Pole, Existing Location

Pole Structure, Existing Location - Single

Pole Structure, Existing Location - H

Duct Route

Cross Section Route


Southern Electric Power Distribution plc
Registered Office: No.1 Forbury Place
43 Forbury Road Reading RG1 3JH
Registered in England & Wales No.04094290

If you're unsure & need to seek advice before commencing excavations please contact:
General Enquiries: 0800 048 3516

Subject to revision – Master held by SSEN Asset Data Team:
AssetData@ssen.com
01256 337 294

BASED UPON THE ORDNANCE SURVEY MAP WITH THE SANCTION OF THE CONTROLLER OF H.M STATIONERY OFFICE CROWN COPYRIGHT RESERVED.

This copy has been made by or with the authority of Scottish and Southern Energy Power Distribution Ltd. Pursuant to section 47 of the Copyright, Designs and Patents Act 1988 ('The Act'). Unless the Act provides a relevant exception to copyright the copy must not be copied without prior permission of the copyright owner. Plans generated by DigSAFE Pro™ software provided by LinesearchbeforeUdig.

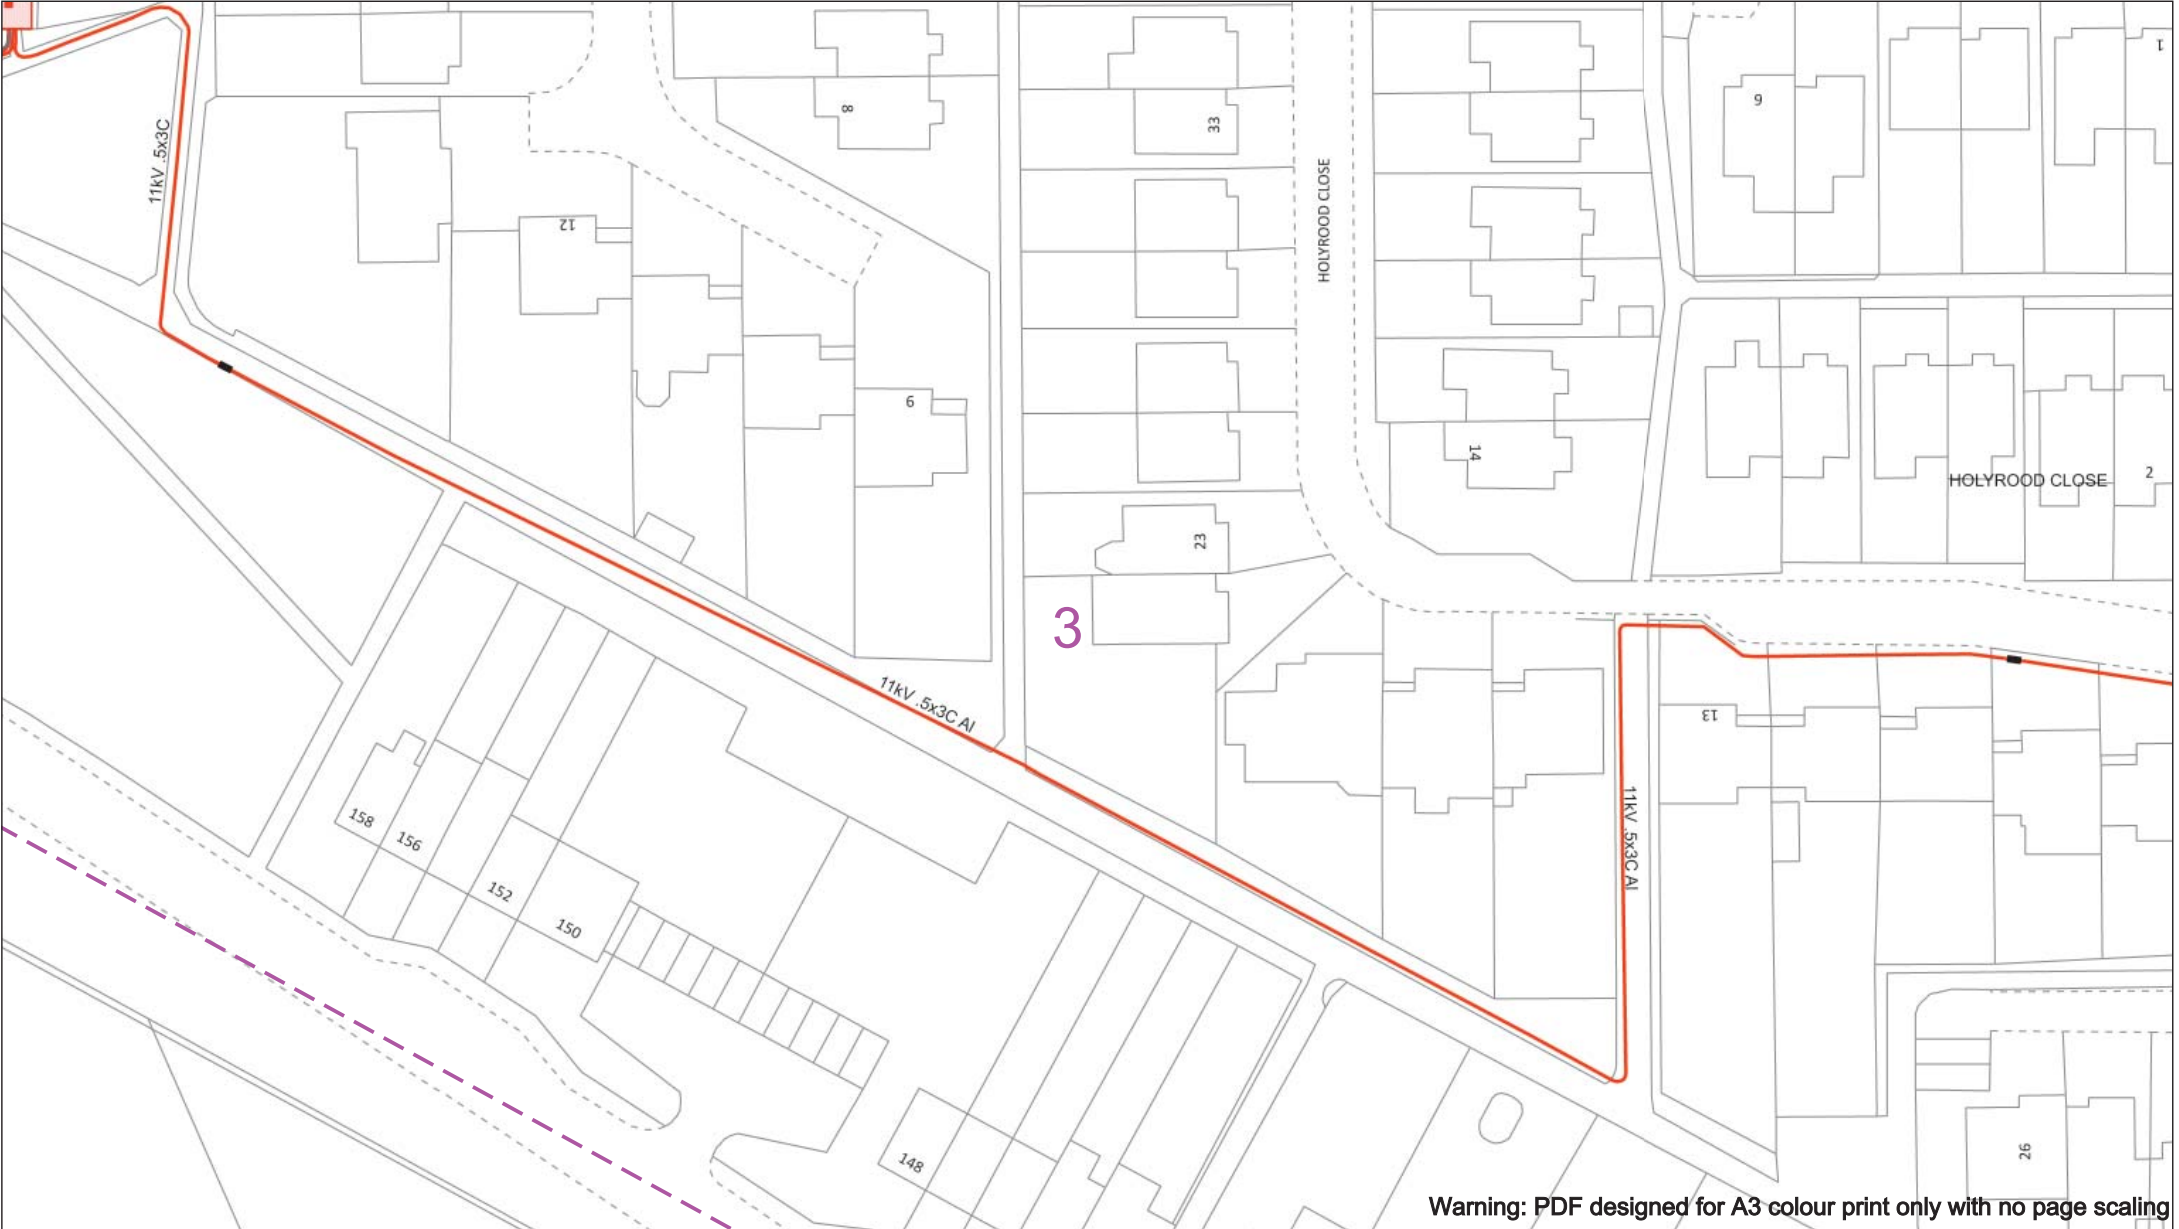

050m

Dig Sites

Area:

Line:

Date Requested: 09/11/2021

Job Reference: 23827726

Site Location: 472556 176139

Requested by: Ms Debbie Wigston

Your Scheme/Reference: 8210940

WARNING

There may have been subsequent alteration to the surface levels. Trial holes must be undertaken to determine position and depths of cables. HS (G) 47 Booklet from the Health and Safety Executive – Avoiding Danger from Buried Cables – should be consulted before commencing excavation work.

WHEN WORKING IN THE VICINITY OF OVERHEAD LINES THE HEALTH AND SAFETY GUIDANCE NOTES GS6 SHOULD BE CONSULTED (AVAILABLE FROM THE HSE WEBSITE)

Voltages (V)				
LV (Low Voltage) and Services	Up to 1,000V			
HV (High Voltage)	Over 1,000V to 11,000V			
EHV (Extra High Voltage)	22,000V to 132,000V			
Transmission	275,000V and 400,000V			

NORMAL DEPTH TO THE TOP OF THE CABLE WHEN LAID				
	LV	HV	EHV	EHV
Footpath/Unmade	0.45m	0.45m	0.6m	0.8m
Road Crossing	0.6m	0.6m	0.75m	0.9m
Agricultural	1m	1m	1m	1.1m

Legend

Service Cable

LV Mains

2 – 3.3kV

6.6kV

11kV

22kV

33kV

66kV

132kV

275kV

400kV

Flow Cyclic

Pole Cable

Distribution Structures (Electric)

Pole, Existing Location

Pole Structure, Existing Location - Single

Pole Structure, Existing Location - H

Duct Route

Cross Section Route

Southern Electric Power Distribution plc

Registered Office: No.1 Forbury Place

43 Forbury Road Reading RG1 3JH

Registered in England & Wales No.04094290

If you're unsure & need to seek advice before commencing excavations please contact:

General Enquiries: 0800 048 3516


Subject to revision – Master held by SSEN Asset Data Team:

AssetData@scsn.com

01256 337 294

BASED UPON THE ORDNANCE SURVEY MAP WITH THE SANCTION OF THE CONTROLLER OF H.M STATIONERY OFFICE CROWN COPYRIGHT RESERVED.

This copy has been made by or with the authority of Scottish and Southern Energy Power Distribution Ltd. Pursuant to section 47 of the Copyright, Designs and Patents Act 1988 ('The Act'). Unless the Act provides a relevant exception to copyright the copy must not be copied without prior permission of the copyright owner. Plans generated by DigSAFE Pro™ software provided by LinesearchbeforeUdig.

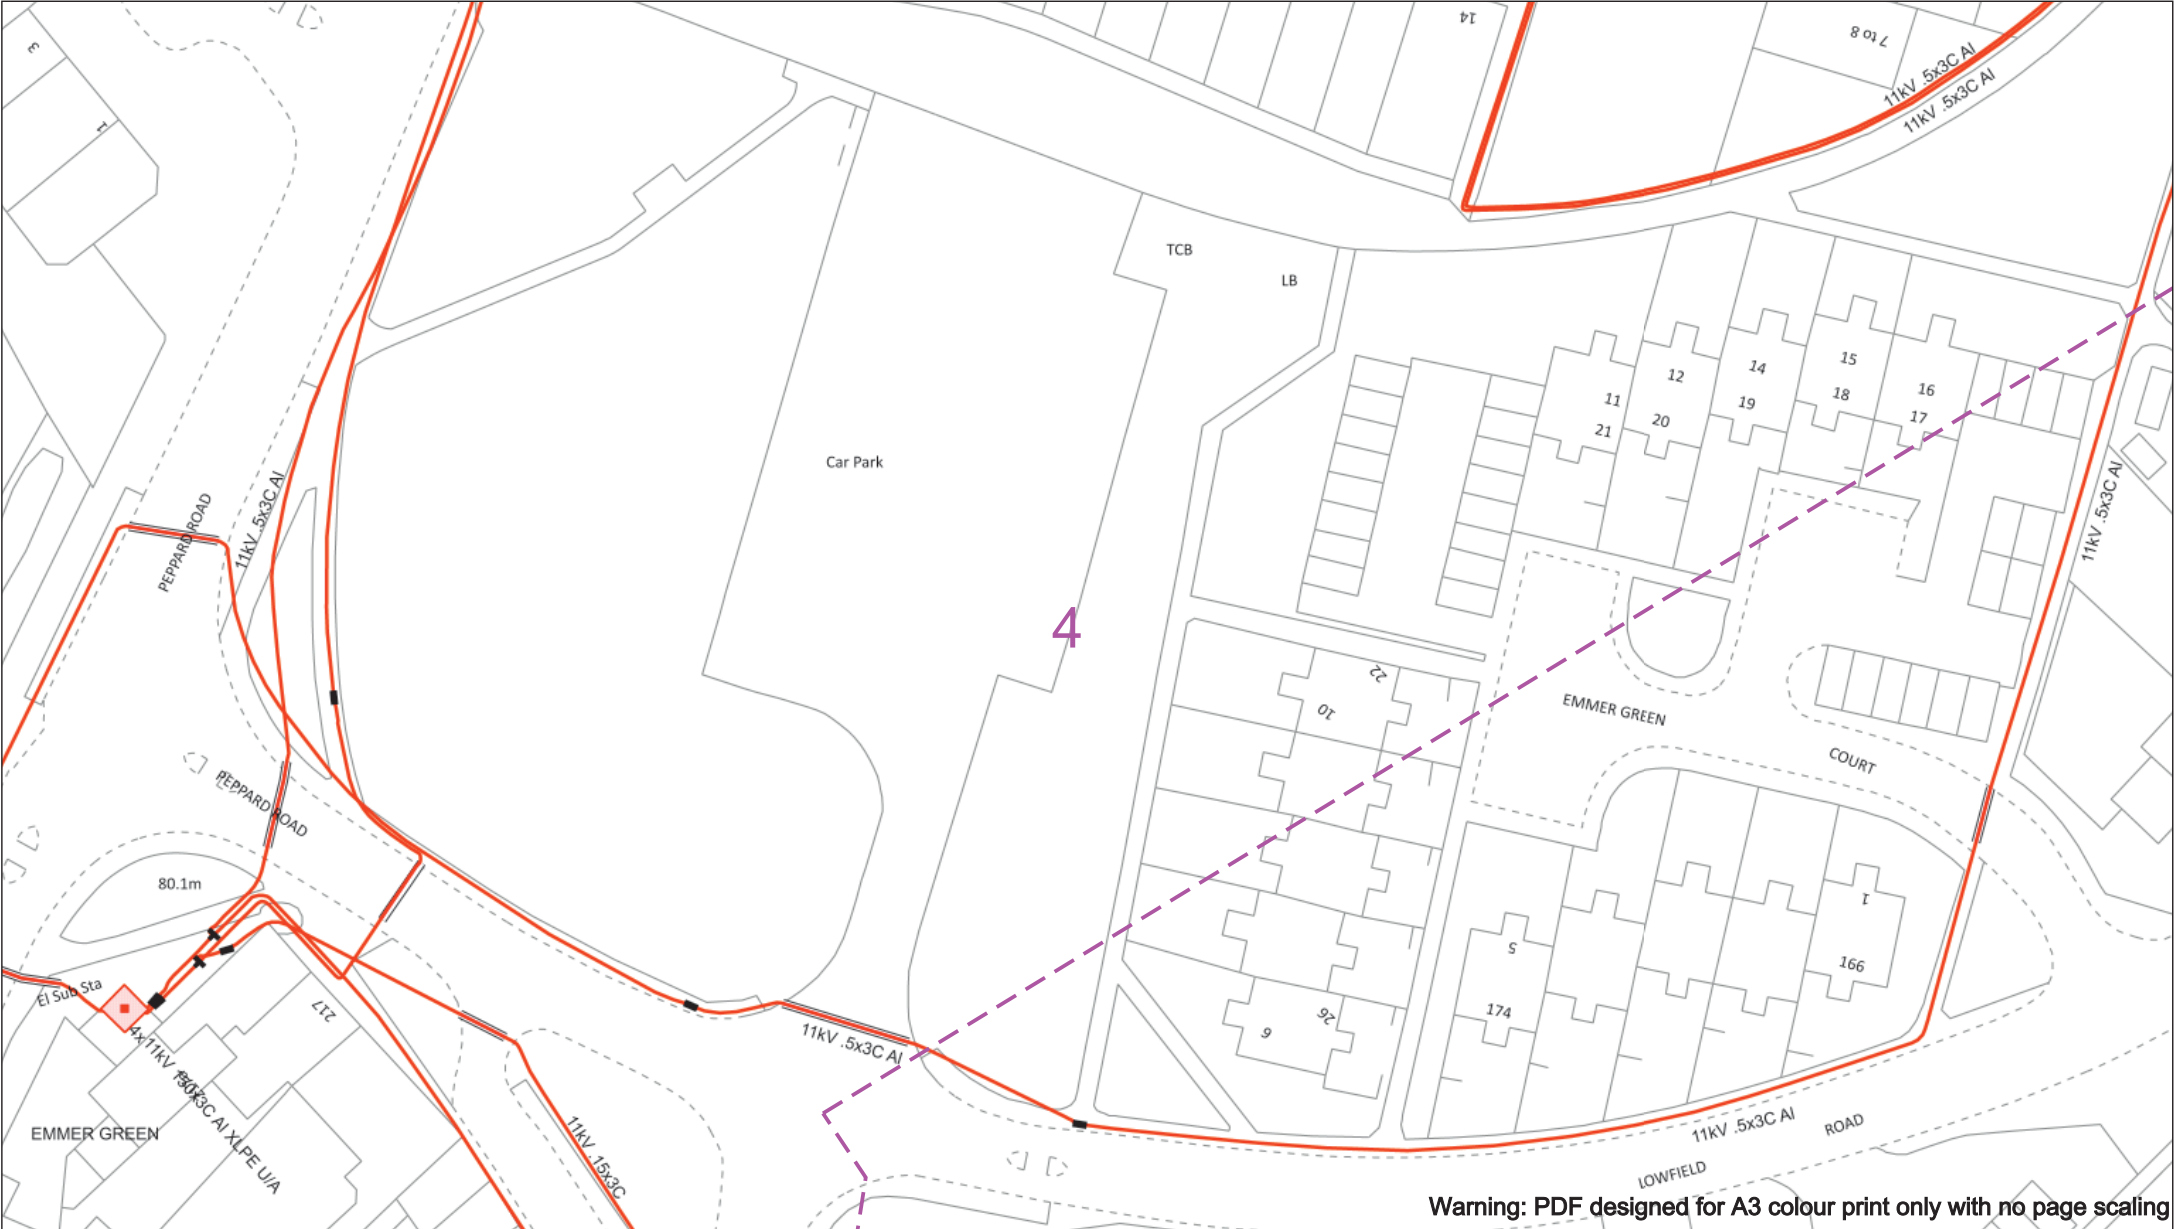

0 50m

Dig Sites Area: Line:

Date Requested: 09/11/2021
Job Reference: 23827726
Site Location: 472556 176139
Requested by:
Ms Debbie Wigston
Your Scheme/Reference: 8210940

WARNING

There may have been subsequent alteration to the surface levels. Trial holes must be undertaken to determine position and depths of cables. HS (G) 47 Booklet from the Health and Safety Executive – Avoiding Danger from Buried Cables – should be consulted before commencing excavation work.

WHEN WORKING IN THE VICINITY OF OVERHEAD LINES THE HEALTH AND SAFETY GUIDANCE NOTES GS6 SHOULD BE CONSULTED (AVAILABLE FROM THE HSE WEBSITE)

Voltages (V)				
LV (Low Voltage) and Services	Up to 1,000V			
LV Mains	Over 1,000V to 11,000V			
HV (High Voltage)	22,000V to 132,000V			
EHV (Extra High Voltage)	275,000V and 400,000V			
Transmission	275,000V and 400,000V			

NORMAL DEPTH TO THE TOP OF THE CABLE WHEN LAID				
Services	LV	HV	EHV	
Footpath/Unmade	0.45m	0.45m	0.6m	0.8m
Road Crossing	0.6m	0.6m	0.75m	0.9m
Agricultural	1m	1m	1m	1.1m

Legend

- Service Cable
- LV Mains
- 2 – 3.3kV
- 6.6kV
- 11kV
- 22kV
- 33kV
- 66kV
- 132kV
- 275kV
- 400kV
- Flow Cable
- Pole Cable

Distribution Structures (Electric)

- Pole, Existing Location
- Pole Structure, Existing Location - Single
- Pole Structure, Existing Location - H
- Duct Route
- Cross Section Route


Southern Electric Power Distribution plc
Registered Office: No.1 Forbury Place
43 Forbury Road Reading RG1 3JH
Registered in England & Wales No.04094290

If you're unsure & need to seek advice before commencing excavations please contact:
General Enquiries: 0800 048 3516

Subject to revision – Master held by SSEN Asset Data Team:
AssetData@scn.com
01256 337 294

BASED UPON THE ORDNANCE SURVEY MAP WITH THE SANCTION OF THE CONTROLLER OF H.M STATIONERY OFFICE CROWN COPYRIGHT RESERVED.

This copy has been made by or with the authority of Scottish and Southern Energy Power Distribution Ltd. Pursuant to section 47 of the Copyright, Designs and Patents Act 1988 ('The Act'). Unless the Act provides a relevant exception to copyright the copy must not be copied without prior permission of the copyright owner. Plans generated by DigSAFE Pro™ software provided by LinesearchbeforeUdig.

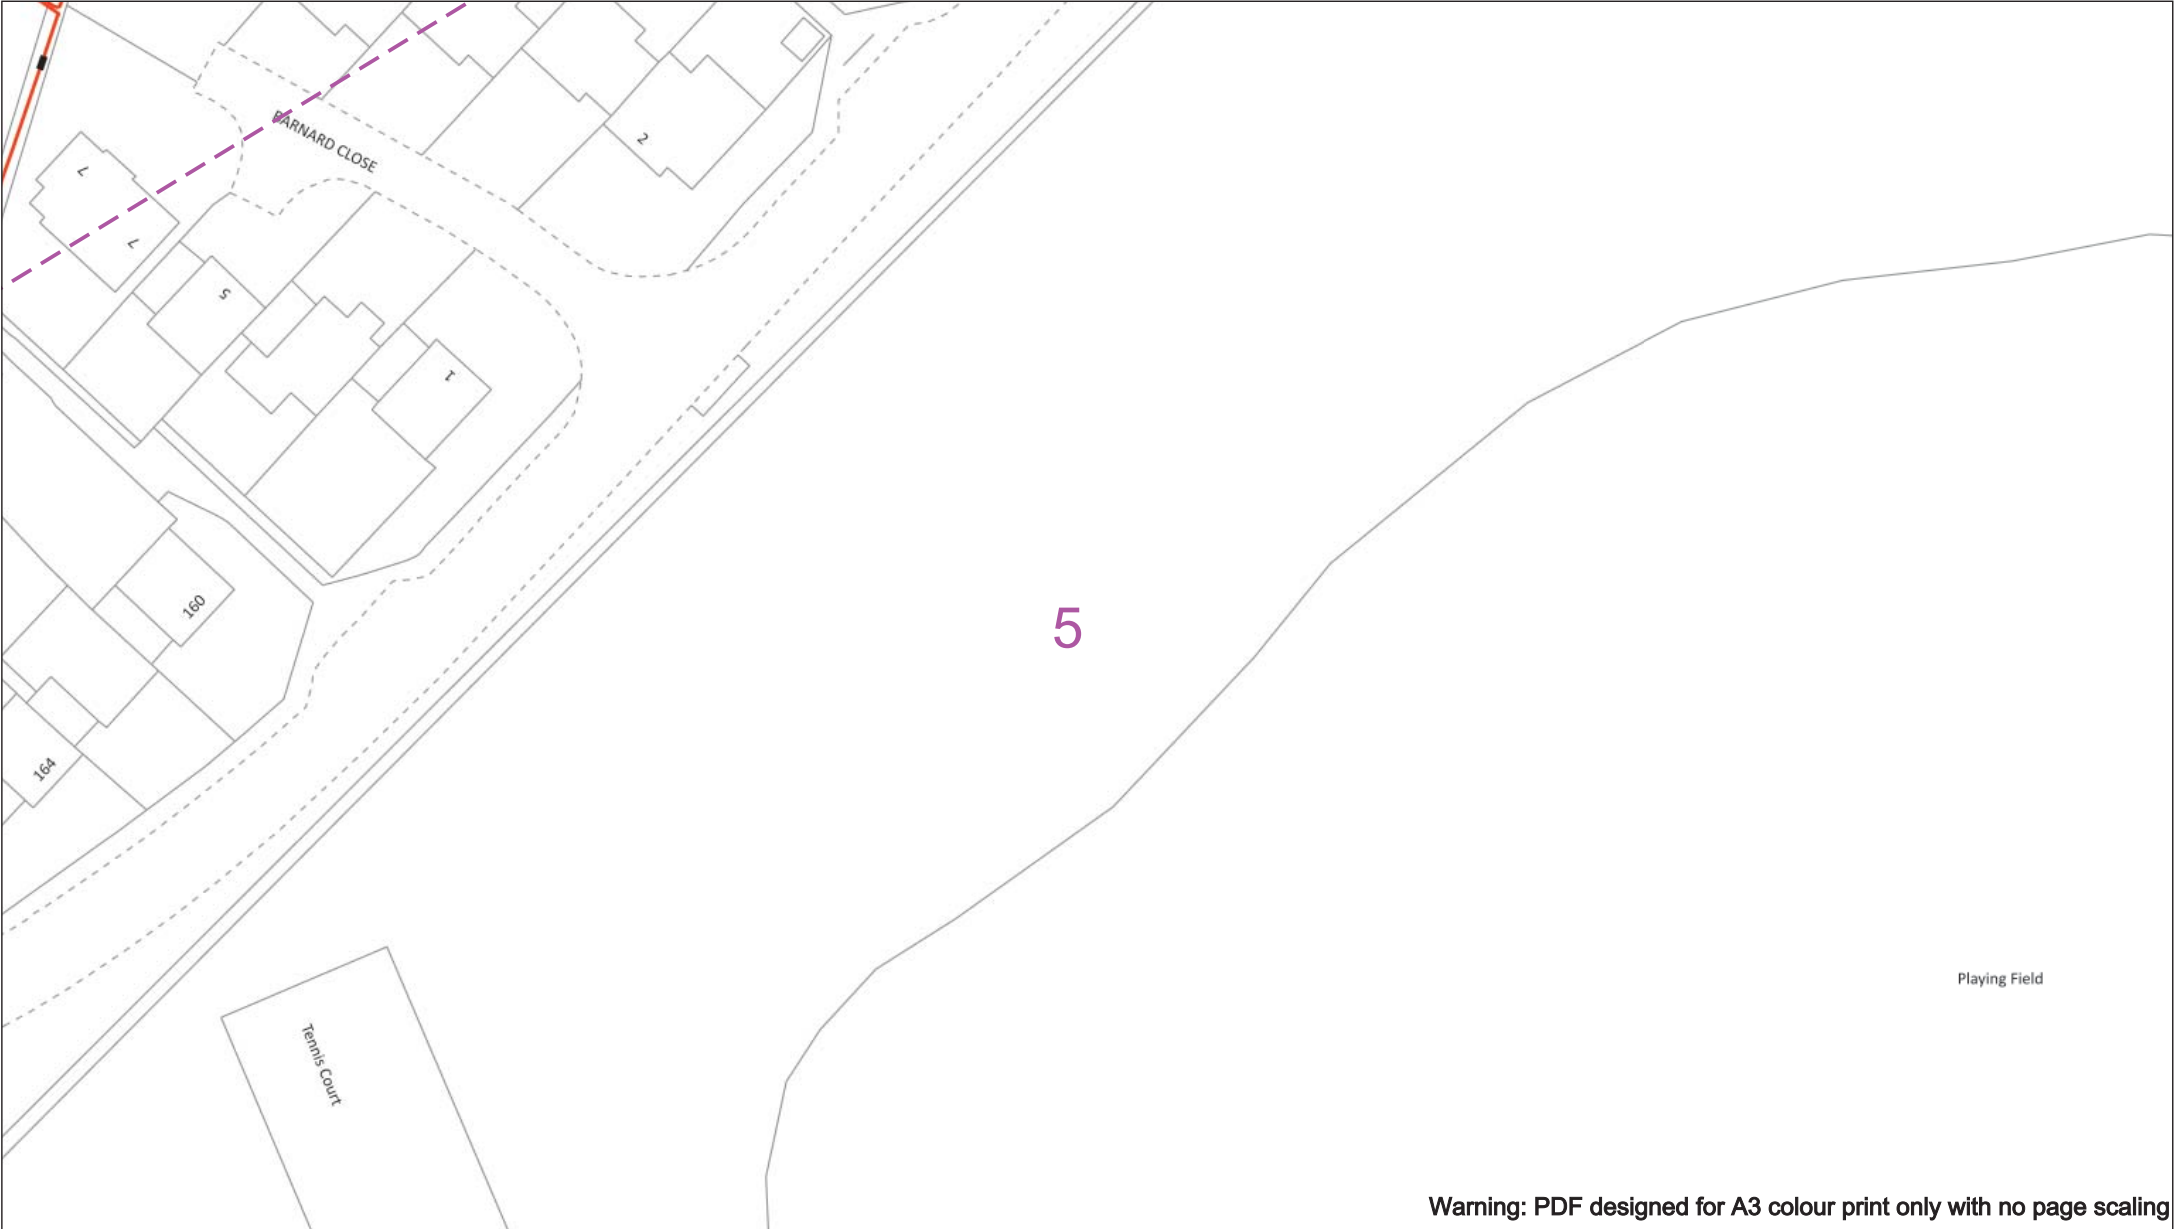

Warning: PDF designed for A3 colour print only with no page scaling

050m

Dig Sites

Area: 

Line: 

Date Requested: 09/11/2021

Job Reference: 23827726

Site Location: 472556 176139

Requested by: Ms Debbie Wigston

Your Scheme/Reference: 8210940

WARNING

There may have been subsequent alteration to the surface levels. Trial holes must be undertaken to determine position and depths of cables. HS (G) 47 Booklet from the Health and Safety Executive – Avoiding Danger from Buried Cables – should be consulted before commencing excavation work.

WHEN WORKING IN THE VICINITY OF OVERHEAD LINES THE HEALTH AND SAFETY GUIDANCE NOTES GS6 SHOULD BE CONSULTED (AVAILABLE FROM THE HSE WEBSITE)

Voltages (V)				
LV (Low Voltage) and Services	Up to 1,000V			
HV (High Voltage)	Over 1,000V to 11,000V			
EHV (Extra High Voltage)	22,000V to 132,000V			
Transmission	275,000V and 400,000V			

NORMAL DEPTH TO THE TOP OF THE CABLE WHEN LAID				
Services	LV	HV	EHV	
Footpath/Unmade	0.45m	0.45m	0.6m	0.8m
Road Crossing	0.6m	0.6m	0.75m	0.9m
Agricultural	1m	1m	1m	1.1m

Legend

 Service Cable

 LV Mains

 2 – 3.3kV

 6.6kV

 11kV

 22kV

 33kV

 66kV

 132kV

 275kV

 400kV

 Fibre Optic

 Pilot Cable

Distribution Structures (Electric)

 Pole, Existing Location

 Pole Structure, Existing Location - Single

 Pole Structure, Existing Location - H

 Pole Structure, Existing Location - H

 Duct Route

 Cross Section Route



Southern Electric Power Distribution plc

Registered Office: No.1 Forbury Place

43 Forbury Road Reading RG1 3JH

Registered in England & Wales No.04094290

If you're unsure & need to seek advice before commencing excavations please contact:

General Enquiries: 0800 048 3516


Subject to revision – Master held by SSEN Asset Data Team:

AssetData@ssen.com

01256 337 294

BASED UPON THE ORDNANCE SURVEY MAP WITH THE SANCTION OF THE CONTROLLER OF H.M STATIONERY OFFICE CROWN COPYRIGHT RESERVED.

This copy has been made by or with the authority of Scottish and Southern Energy Power Distribution Ltd. Pursuant to section 47 of the Copyright, Designs and Patents Act 1988 ('The Act'). Unless the Act provides a relevant exception to copyright the copy must not be copied without prior permission of the copyright owner. Plans generated by DigSAFE Pro™ software provided by LinesearchbeforeUdig.

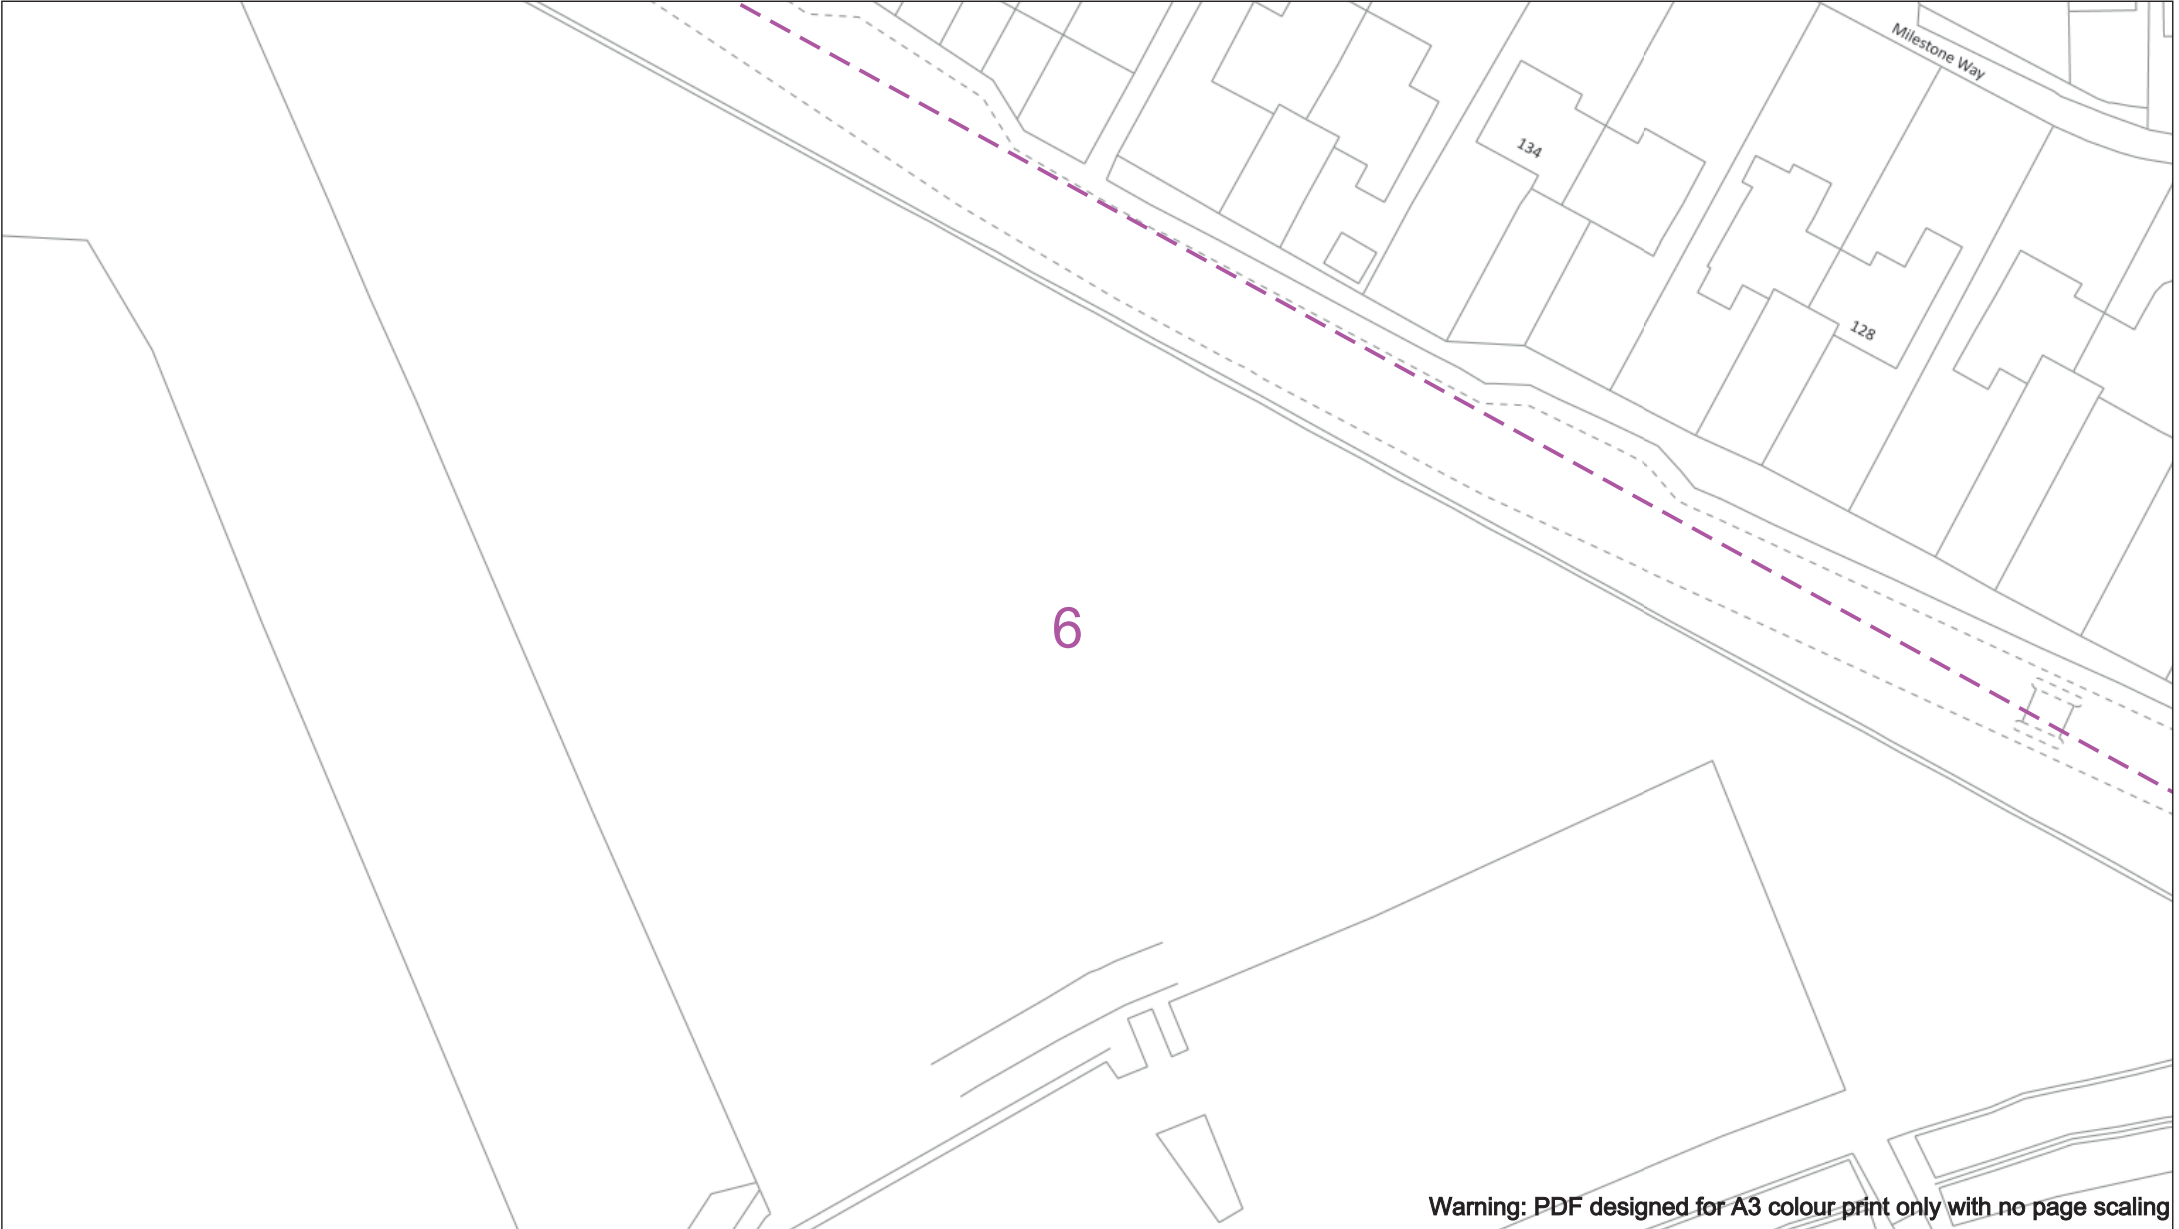

Warning: PDF designed for A3 colour print only with no page scaling

050m

Dig Sites

Area:

Line:

Date Requested: 09/11/2021
Job Reference: 23827726
Site Location: 472556 176139
Requested by:
Ms Debbie Wigston
Your Scheme/Reference: 8210940

WARNING

There may have been subsequent alteration to the surface levels. Trial holes must be undertaken to determine position and depths of cables. HS (G) 47 Booklet from the Health and Safety Executive – Avoiding Danger from Buried Cables – should be consulted before commencing excavation work.

WHEN WORKING IN THE VICINITY OF OVERHEAD LINES THE HEALTH AND SAFETY GUIDANCE NOTES GS6 SHOULD BE CONSULTED (AVAILABLE FROM THE HSE WEBSITE)

Voltages (V)

LV (Low Voltage) and Services	Up to 1,000V
HV (High Voltage)	Over 1,000V to 11,000V
EHV (Extra High Voltage)	22,000V to 132,000V
Transmission	275,000V and 400,000V

NORMAL DEPTH TO THE TOP OF THE CABLE WHEN LAID

Services	LV	HV	EHV
Footpath/Unmade	0.45m	0.45m	0.6m
Road Crossing	0.6m	0.6m	0.75m
Agricultural	1m	1m	1.1m

Service Cable

LV Mains

2 – 3.3kV

6.6kV

11kV

22kV

33kV

66kV

132kV

275kV

400kV

Fibre Optic

Pole Cable

Pole, Existing Location

Pole Structure, Existing Location - Single

Pole Structure, Existing Location - H

Duct Route

Cross Section Route


Southern Electric Power Distribution plc
Registered Office: No.1 Forbury Place
43 Forbury Road Reading RG1 3JH
Registered in England & Wales No.04094290

If you're unsure & need to seek advice before commencing excavations please contact:
General Enquiries: 0800 048 3516

Subject to revision – Master held by SSEN Asset Data Team:
Asset.Data@ssen.com
01256 337 294

BASED UPON THE ORDNANCE SURVEY MAP WITH THE SANCTION OF THE CONTROLLER OF H.M STATIONERY OFFICE CROWN COPYRIGHT RESERVED.

This copy has been made by or with the authority of Scottish and Southern Energy Power Distribution Ltd. Pursuant to section 47 of the Copyright, Designs and Patents Act 1988 ('The Act'). Unless the Act provides a relevant exception to copyright the copy must not be copied without prior permission of the copyright owner. Plans generated by DigSAFE Pro™ software provided by LinesearchbeforeUdig.

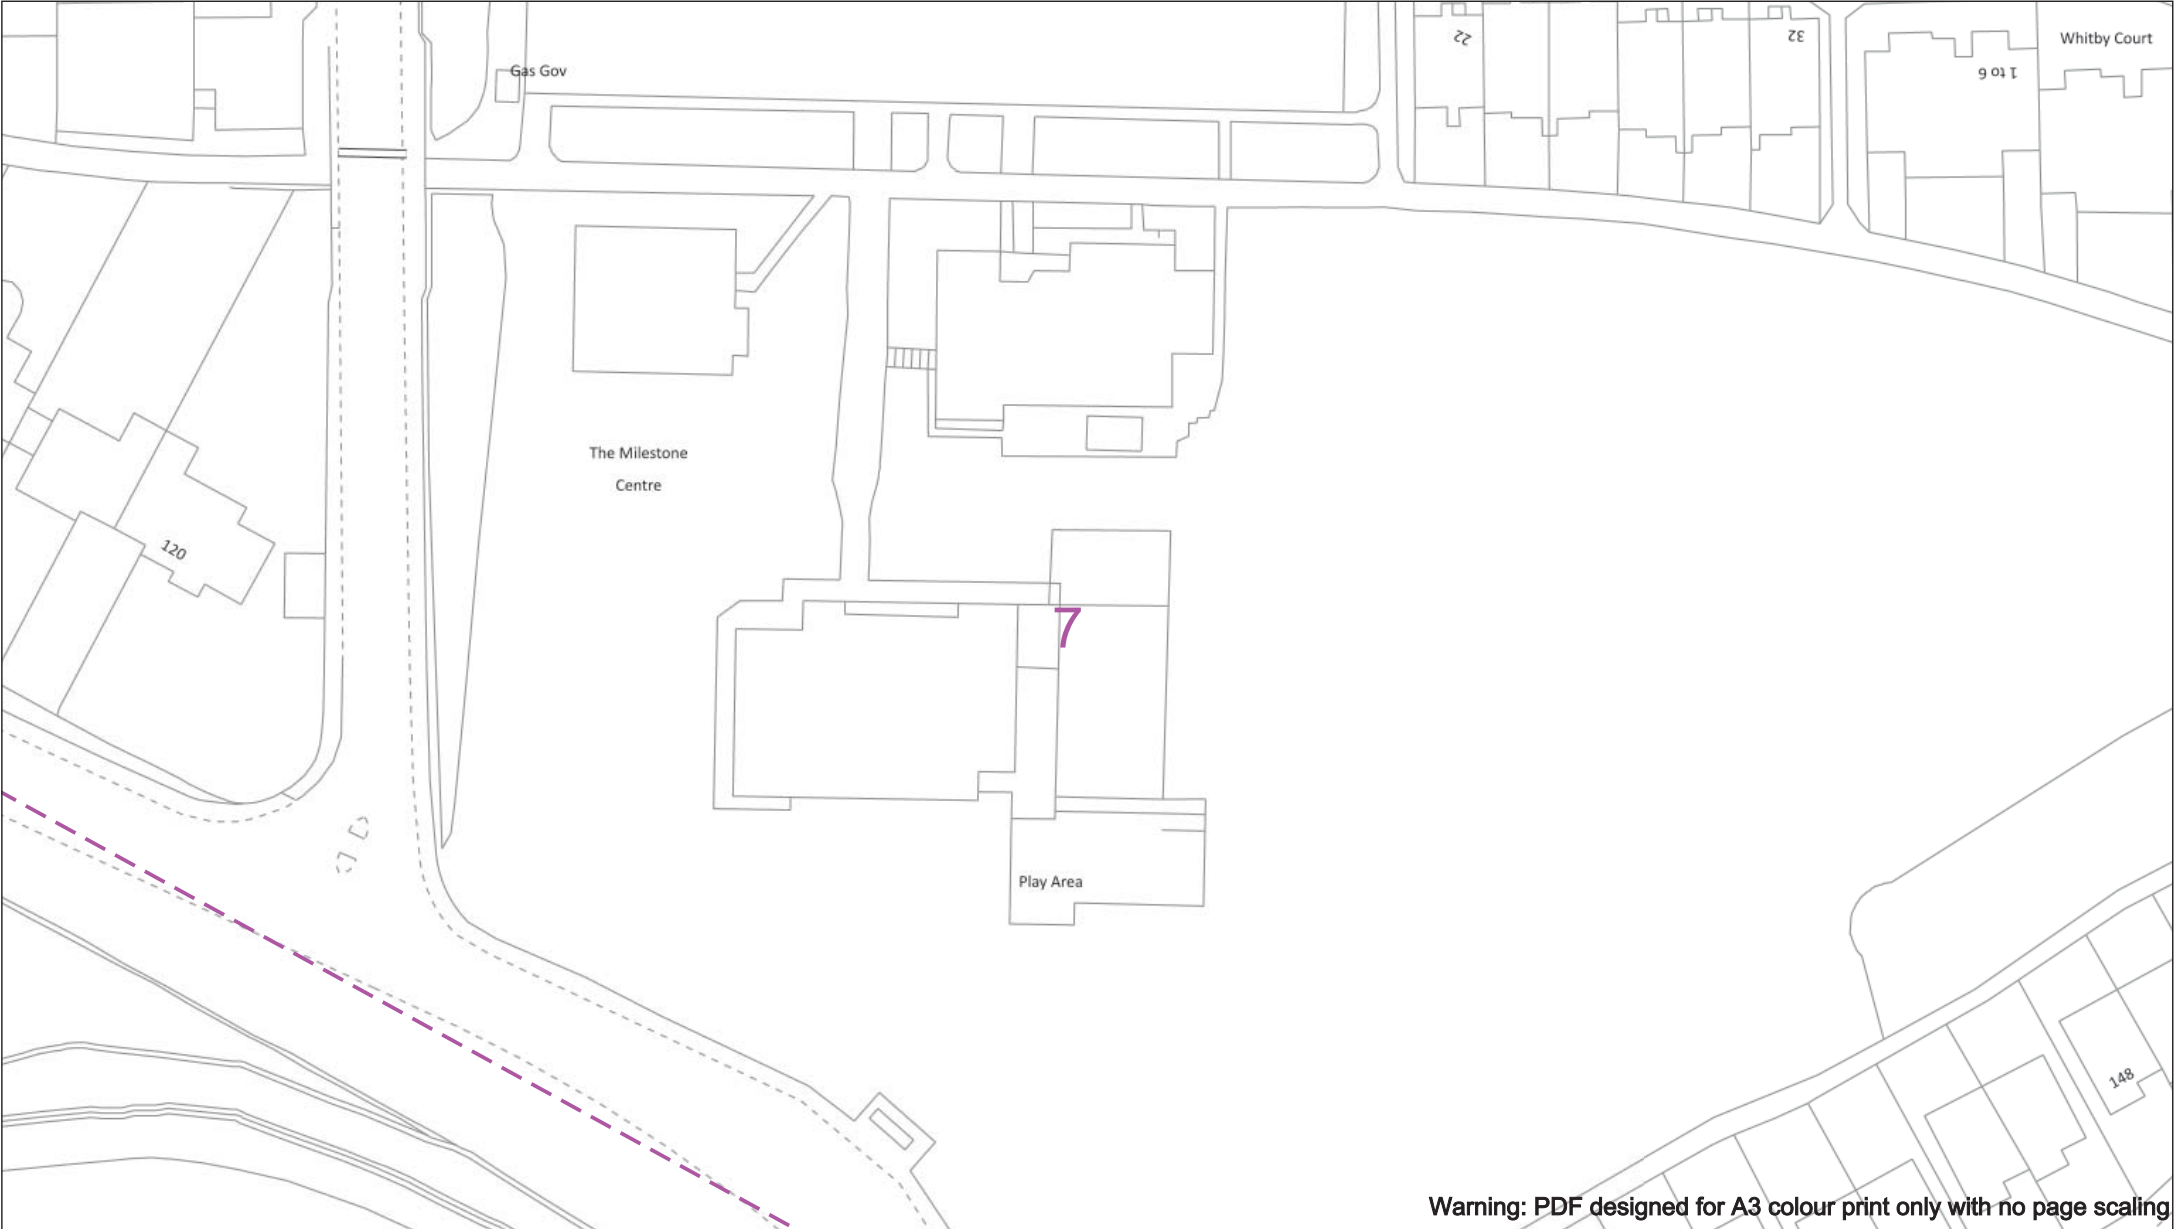

Warning: PDF designed for A3 colour print only with no page scaling

050m

Dig Sites

Area:

Line:

Date Requested: 09/11/2021

Job Reference: 23827726

Site Location: 472556 176139

Requested by: Ms Debbie Wigston

Your Scheme/Reference: 8210940

WARNING

There may have been subsequent alteration to the surface levels. Trial holes must be undertaken to determine position and depths of cables. HS (G) 47 Booklet from the Health and Safety Executive – Avoiding Danger from Buried Cables – should be consulted before commencing excavation work.

WHEN WORKING IN THE VICINITY OF OVERHEAD LINES THE HEALTH AND SAFETY GUIDANCE NOTES GS6 SHOULD BE CONSULTED (AVAILABLE FROM THE HSE WEBSITE)

Voltages (V)

LV (Low Voltage) and Services

Up to 1,000V

HV (High Voltage)

Over 1,000V to 11,000V

EHV (Extra High Voltage)

22,000V to 132,000V

Transmission

275,000V and 400,000V

NORMAL DEPTH TO THE TOP OF THE CABLE WHEN LAID

	Services	LV	HV	EHV
Footpath/Unmade	0.45m	0.45m	0.6m	0.8m
Road Crossing	0.6m	0.6m	0.75m	0.9m
Agricultural	1m	1m	1m	1.1m

Legend

Service Cable

LV Mains

2 – 3.3kV

6.6kV

11kV

22kV

33kV

66kV

132kV

275kV

400kV

Fluo Optic

Pole Cable

Distribution Structures (Electric)

Pole, Existing Location

Pole Structure, Existing Location - Single

Pole Structure, Existing Location - H

Duct Route

Cross Section Route


Southern Electric Power Distribution plc
Registered Office: No.1 Forbury Place
43 Forbury Road Reading RG1 3JH
Registered in England & Wales No.04094290

If you're unsure & need to seek advice before commencing excavations please contact:
General Enquiries: 0800 048 3516

Subject to revision – Master held by SSEN Asset Data Team:
AssetData@se.com
01256 337 294

BASED UPON THE ORDNANCE SURVEY MAP WITH THE SANCTION OF THE CONTROLLER OF H.M STATIONERY OFFICE CROWN COPYRIGHT RESERVED.

This copy has been made by or with the authority of Scottish and Southern Energy Power Distribution Ltd. Pursuant to section 47 of the Copyright, Designs and Patents Act 1988 ('The Act'). Unless the Act provides a relevant exception to copyright the copy must not be copied without prior permission of the copyright owner. Plans generated by DigSAFE Pro™ software provided by LinesearchbeforeUdig.

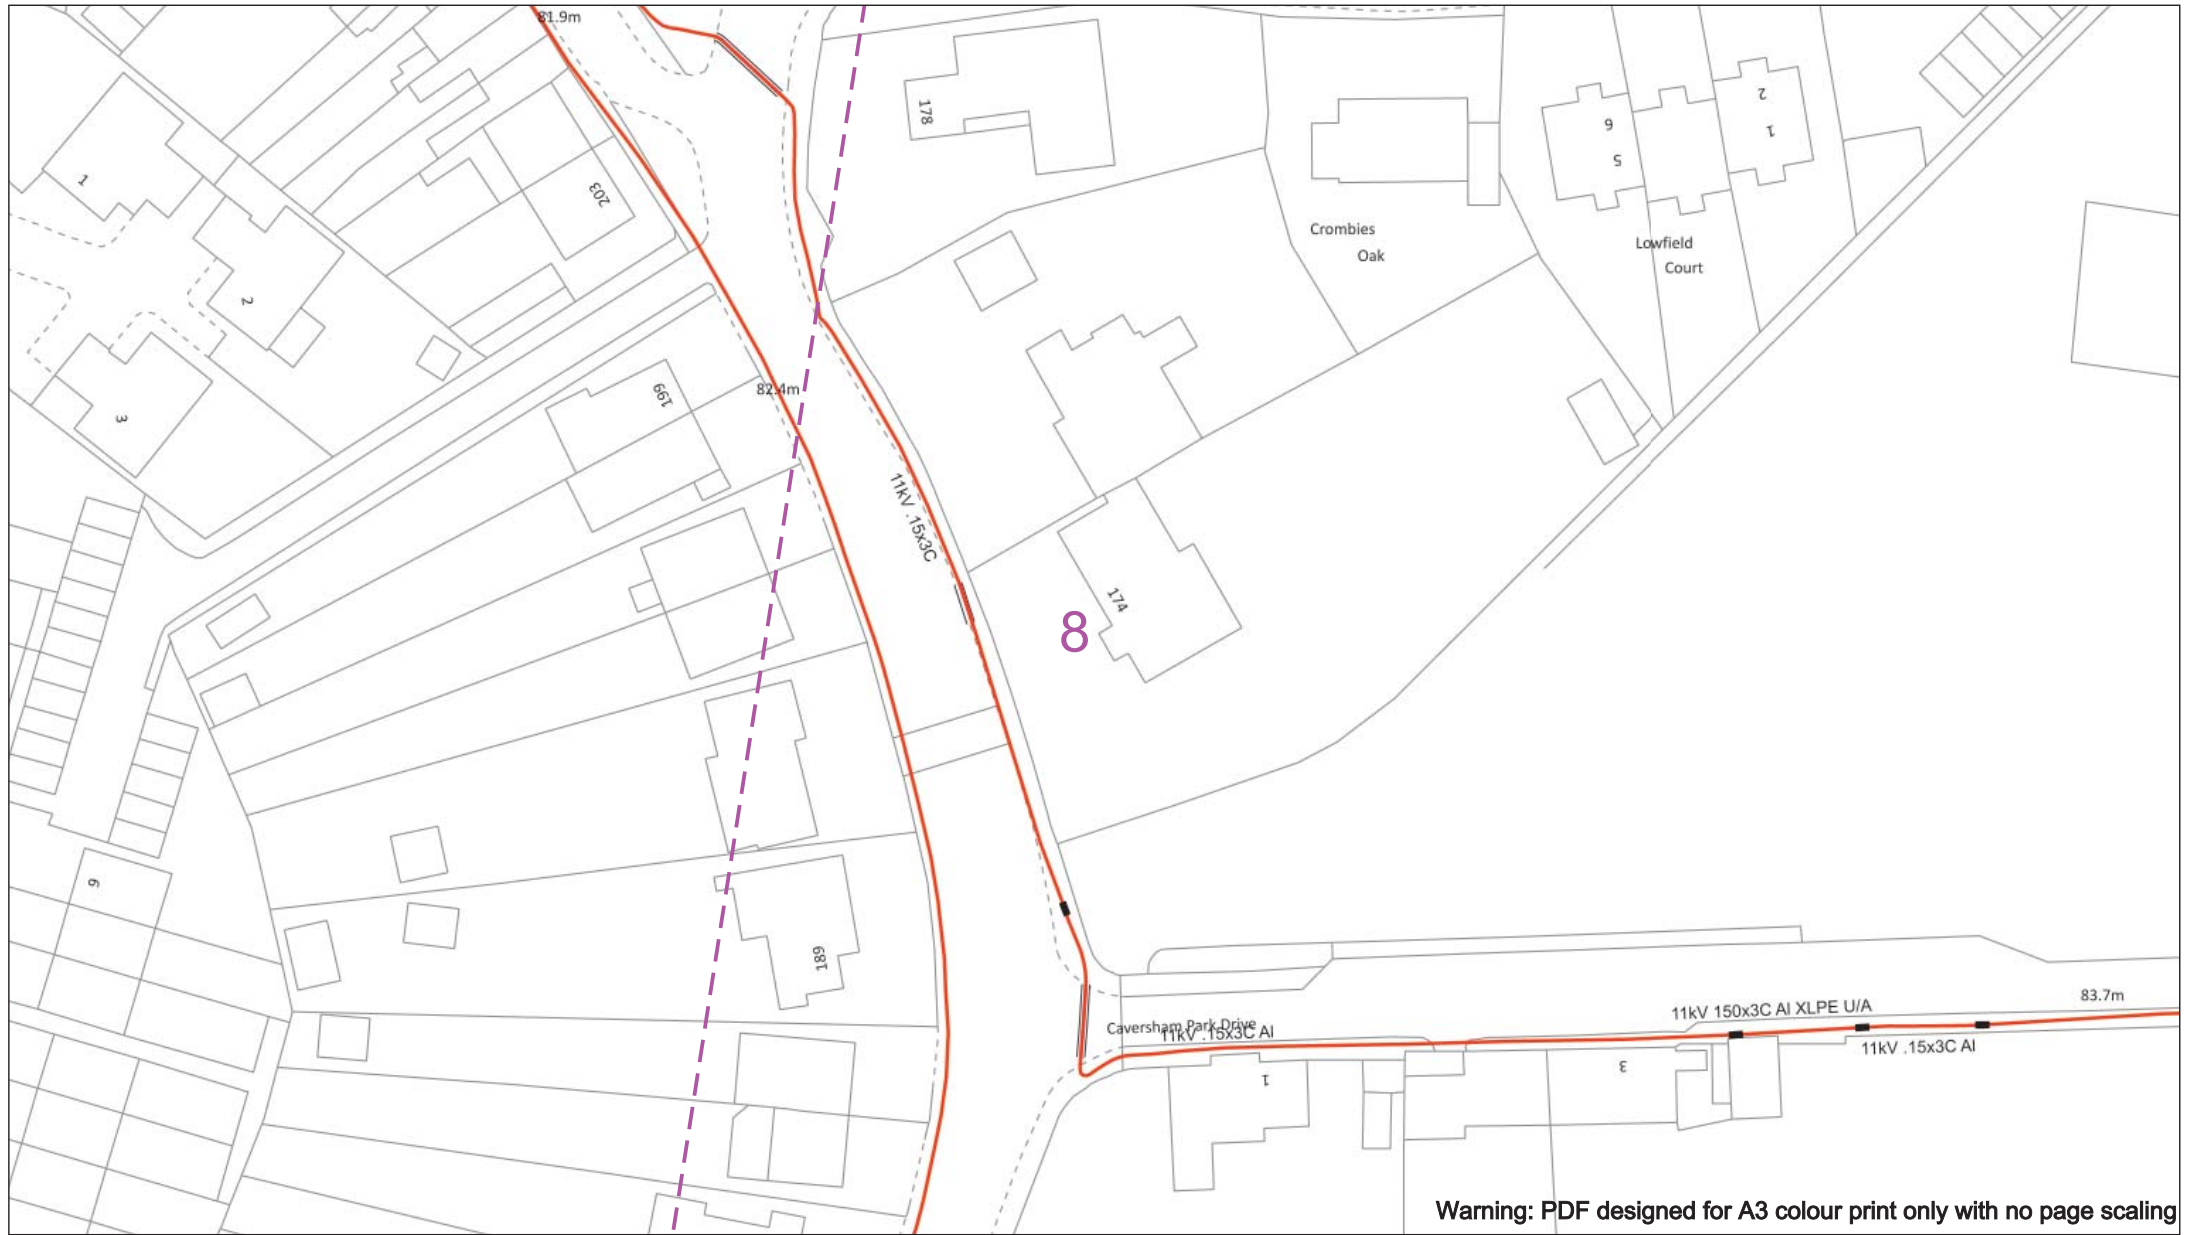

Warning: PDF designed for A3 colour print only with no page scaling

050m

Dig Sites

Area:

Line:

Date Requested: 09/11/2021

Job Reference: 23827726

Site Location: 472556 176139

Requested by: Ms Debbie Wigston

Your Scheme/Reference: 8210940

WARNING

There may have been subsequent alteration to the surface levels. Trial holes must be undertaken to determine position and depths of cables. HS (G) 47 Booklet from the Health and Safety Executive – Avoiding Danger from Buried Cables – should be consulted before commencing excavation work.

WHEN WORKING IN THE VICINITY OF OVERHEAD LINES THE HEALTH AND SAFETY GUIDANCE NOTES GS6 SHOULD BE CONSULTED (AVAILABLE FROM THE HSE WEBSITE)

Voltages (V)				
LV (Low Voltage) and Services	Up to 1,000V			
HV (High Voltage)	Over 1,000V to 11,000V			
EHV (Extra High Voltage)	22,000V to 132,000V			
Transmission	275,000V and 400,000V			

NORMAL DEPTH TO THE TOP OF THE CABLE WHEN LAID				
Services	LV	HV	EHV	
Footpath/Unmade	0.45m	0.45m	0.6m	0.8m
Road Crossing	0.6m	0.6m	0.75m	0.9m
Agricultural	1m	1m	1m	1.1m

Legend

Service Cable

LV Mains

2 – 3.3kV

6.6kV

11kV

22kV

33kV

66kV

132kV

275kV

400kV

Flow Optic

Pole Cable

Distribution Structures (Electric)

Pole, Existing Location

Pole Structure, Existing Location - Single

Pole Structure, Existing Location - H

Duct Route

Cross Section Route

Southern Electric Power Distribution plc

Registered Office: No.1 Forbury Place

43 Forbury Road Reading RG1 3JH

Registered in England & Wales No.04094290

If you're unsure & need to seek advice before commencing excavations please contact:

General Enquiries: 0800 048 3516

Subject to revision – Master held by SSEN Asset Data Team:

Asset.Data@ssen.com

01256 337 294

BASED UPON THE ORDNANCE SURVEY MAP WITH THE SANCTION OF THE CONTROLLER OF H.M STATIONERY OFFICE CROWN COPYRIGHT RESERVED.

This copy has been made by or with the authority of Scottish and Southern Energy Power Distribution Ltd. Pursuant to section 47 of the Copyright, Designs and Patents Act 1988 ('The Act'). Unless the Act provides a relevant exception to copyright the copy must not be copied without prior permission of the copyright owner. Plans generated by DigSAFE Pro™ software provided by LinesearchbeforeUdig.



WARNING

There may have been subsequent alteration to the surface levels. Trial holes must be undertaken to determine position and depths of cables. HS (G) 47 Booklet from the Health and Safety Executive – Avoiding Danger from Buried Cables – should be consulted before commencing excavation work.

Scale: 1:500 (When plotted at A3)

Legend

- Service Cable
- LV Mains
- 2 - 3 kV
- 6-66 kV
- 110V
- 220V
- 33kV
- 66kV
- 132kV
- 275kV
- 400kV
- Fibre Optic
- Pilot Cable

Distribution Structures (Electronic)

- Pole, Existing Location
- Pole Structure, Existing Location - Single
- Pole Structure, Existing Location - M
- Duct Route
- Cross Section Route




Southern Electric Power Distribution plc
Registered Office: No.1 Forbury Place
43 Forbury Road Reading RG1 3HH
Registered in England & Wales No.04094290

If you're unsure & need to seek advice before commencing excavations please contact:
General Enquiries: 0800 048 3516

Subject to revision – Master held by SSEN Asset Data Team:
Asset.Data@sse.com
01256 337 294

BASED UPON THE ORDNANCE SURVEY MAP WITH THE SANCTION OF THE CONTROLLER OF H.M STATIONERY OFFICE CROWN COPYRIGHT RESERVED.

This copy has been made by or with the authority of Scottish and Southern Energy Power Distribution Ltd. Pursuant to section 47 of the Copyright, Designs and Patents Act 1988 ('The Act'). Unless the Act provides a relevant exception to copyright the copy must not be copied without prior permission of the copyright owner. Plans generated by DigSAFE Pro™ software provided by LinesearchbeforeUdig.

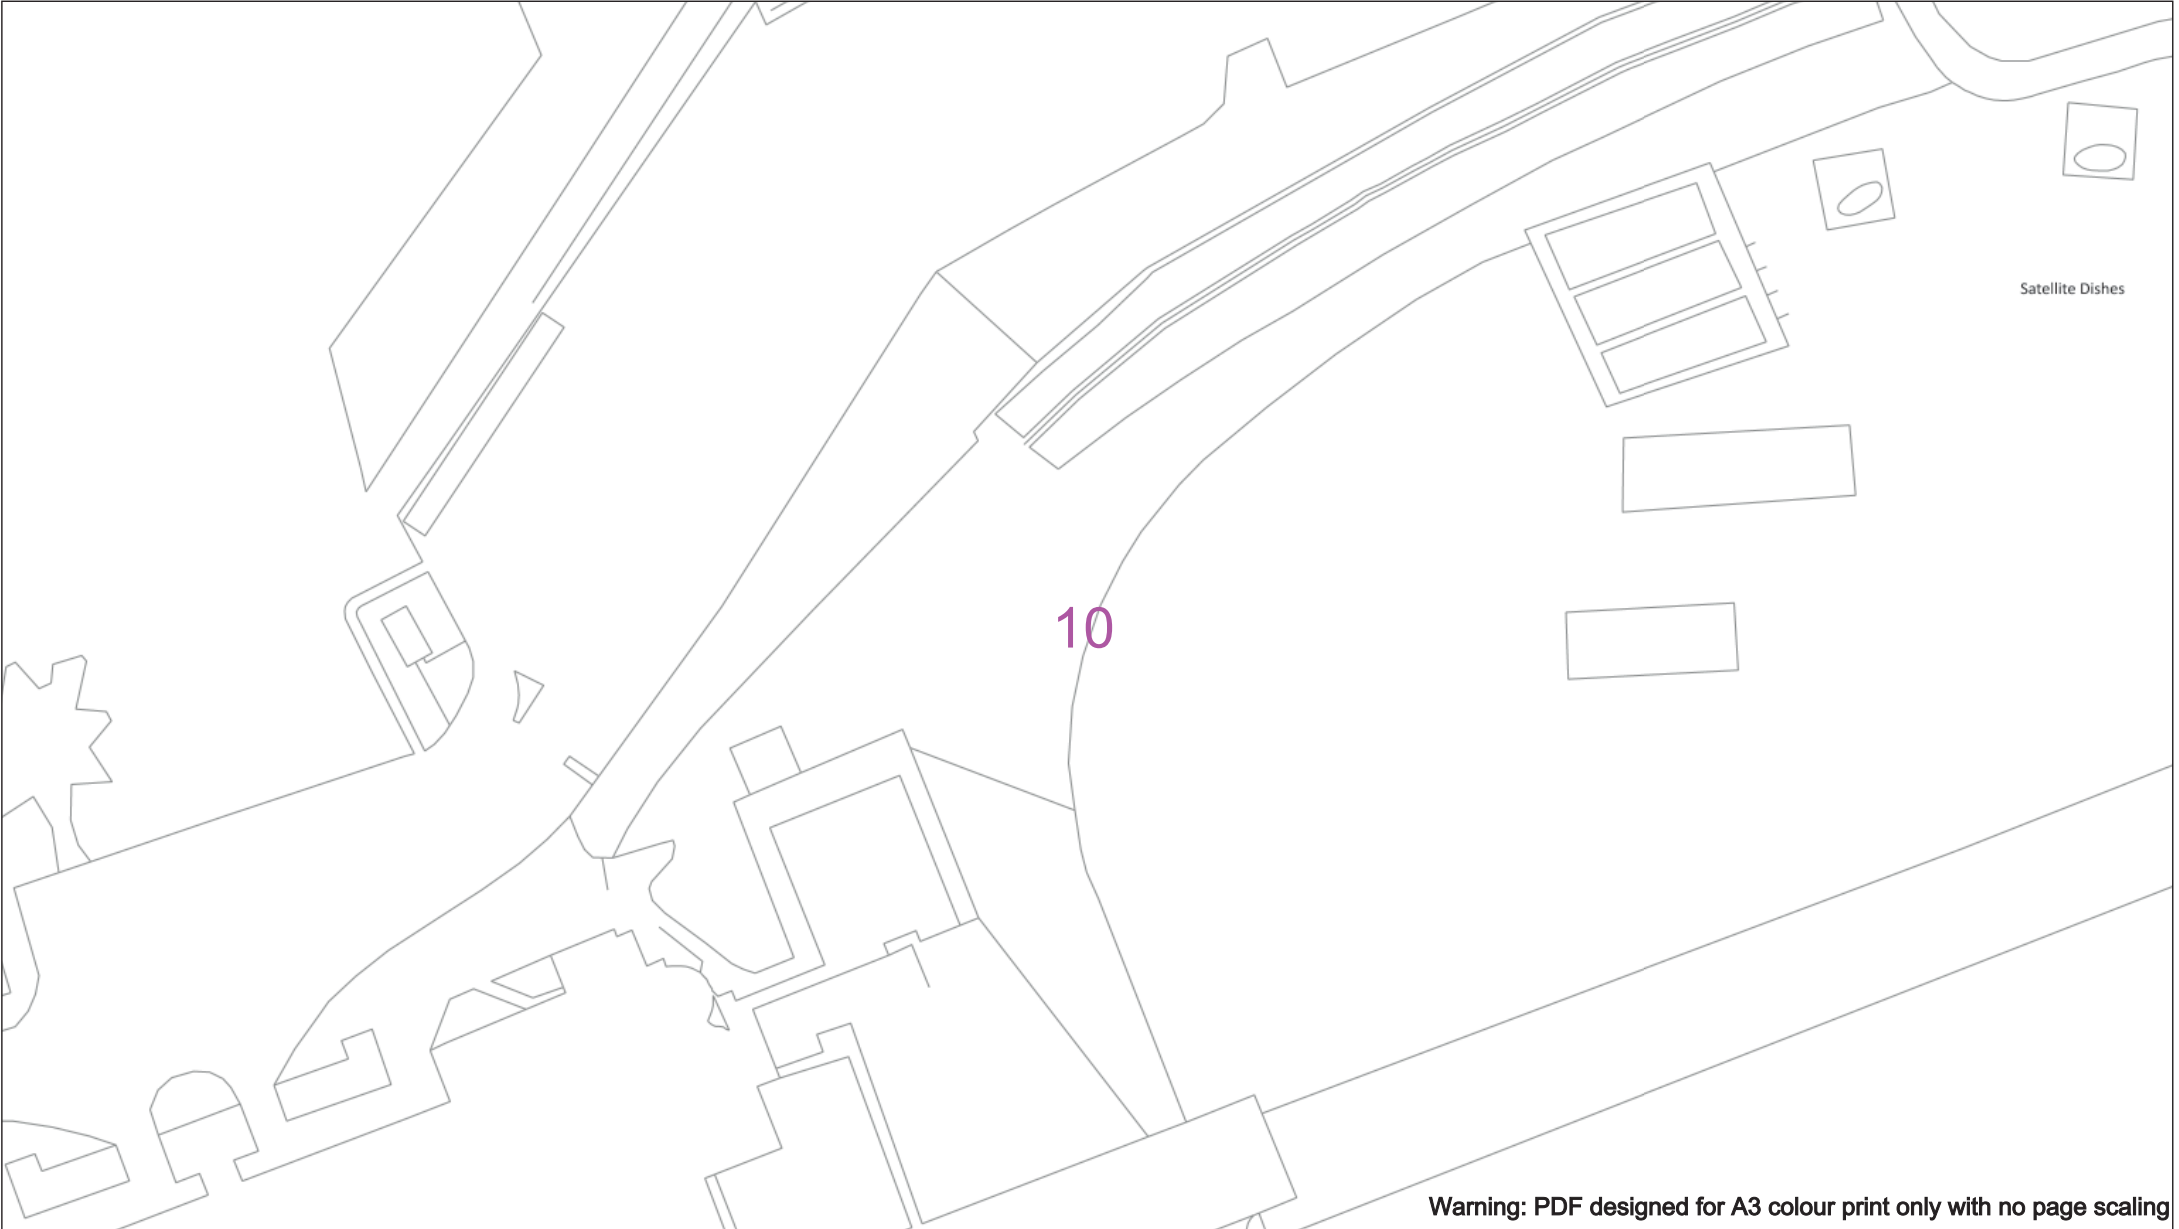

Satellite Dishes

10

Warning: PDF designed for A3 colour print only with no page scaling

050m

Dig Sites

Area: 

Line: 

Date Requested: 09/11/2021

Job Reference: 23827726

Site Location: 472556 176139

Requested by: Ms Debbie Wigston

Your Scheme/Reference: 8210940

WARNING

There may have been subsequent alteration to the surface levels. Trial holes must be undertaken to determine position and depths of cables. HS (G) 47 Booklet from the Health and Safety Executive – Avoiding Danger from Buried Cables – should be consulted before commencing excavation work.

WHEN WORKING IN THE VICINITY OF OVERHEAD LINES THE HEALTH AND SAFETY GUIDANCE NOTES GS6 SHOULD BE CONSULTED (AVAILABLE FROM THE HSE WEBSITE)

Scale: 1:500 (When plotted at A3)

Voltages (V)

LV (Low Voltage) and Services Up to 1,000V

HV (High Voltage) Over 1,000V to 11,000V

EHV (Extra High Voltage) 22,000V to 132,000V

Transmission 275,000V and 400,000V

NORMAL DEPTH TO THE TOP OF THE CABLE WHEN LAID

Services	LV	HV	EHV
Footpath/Unmade	0.45m	0.45m	0.6m
Road Crossing	0.6m	0.6m	0.75m
Agricultural	1m	1m	1.1m

Legend

 Service Cable

 LV Mains

 2 – 3.3kV

 6.6kV

 11kV

 22kV

 33kV

 66kV

 132kV

 275kV

 400kV

 Fibre Optic

 Pilot Cable

Distribution Structures (Electric)

 Pole, Existing Location

 Pole Structure, Existing Location - Single

 Pole Structure, Existing Location - H

 Duct Route

 Cross Section Route



Southern Electric Power Distribution plc

Registered Office: No.1 Forbury Place

43 Forbury Road Reading RG1 3JH

Registered in England & Wales No.04094290

If you're unsure & need to seek advice before commencing excavations please contact:

General Enquiries: 0800 048 3516


Subject to revision – Master held by SSEN Asset Data Team:

Asset.Data@ssen.com

01256 337 294

BASED UPON THE ORDNANCE SURVEY MAP WITH THE SANCTION OF THE CONTROLLER OF H.M. STATIONERY OFFICE CROWN COPYRIGHT RESERVED.

This copy has been made by or with the authority of Scottish and Southern Energy Power Distribution Ltd. Pursuant to section 47 of the Copyright, Designs and Patents Act 1988 ('The Act'). Unless the Act provides a relevant exception to copyright the copy must not be copied without prior permission of the copyright owner. Plans generated by DigSAFE Pro™ software provided by LinesearchbeforeUdig.

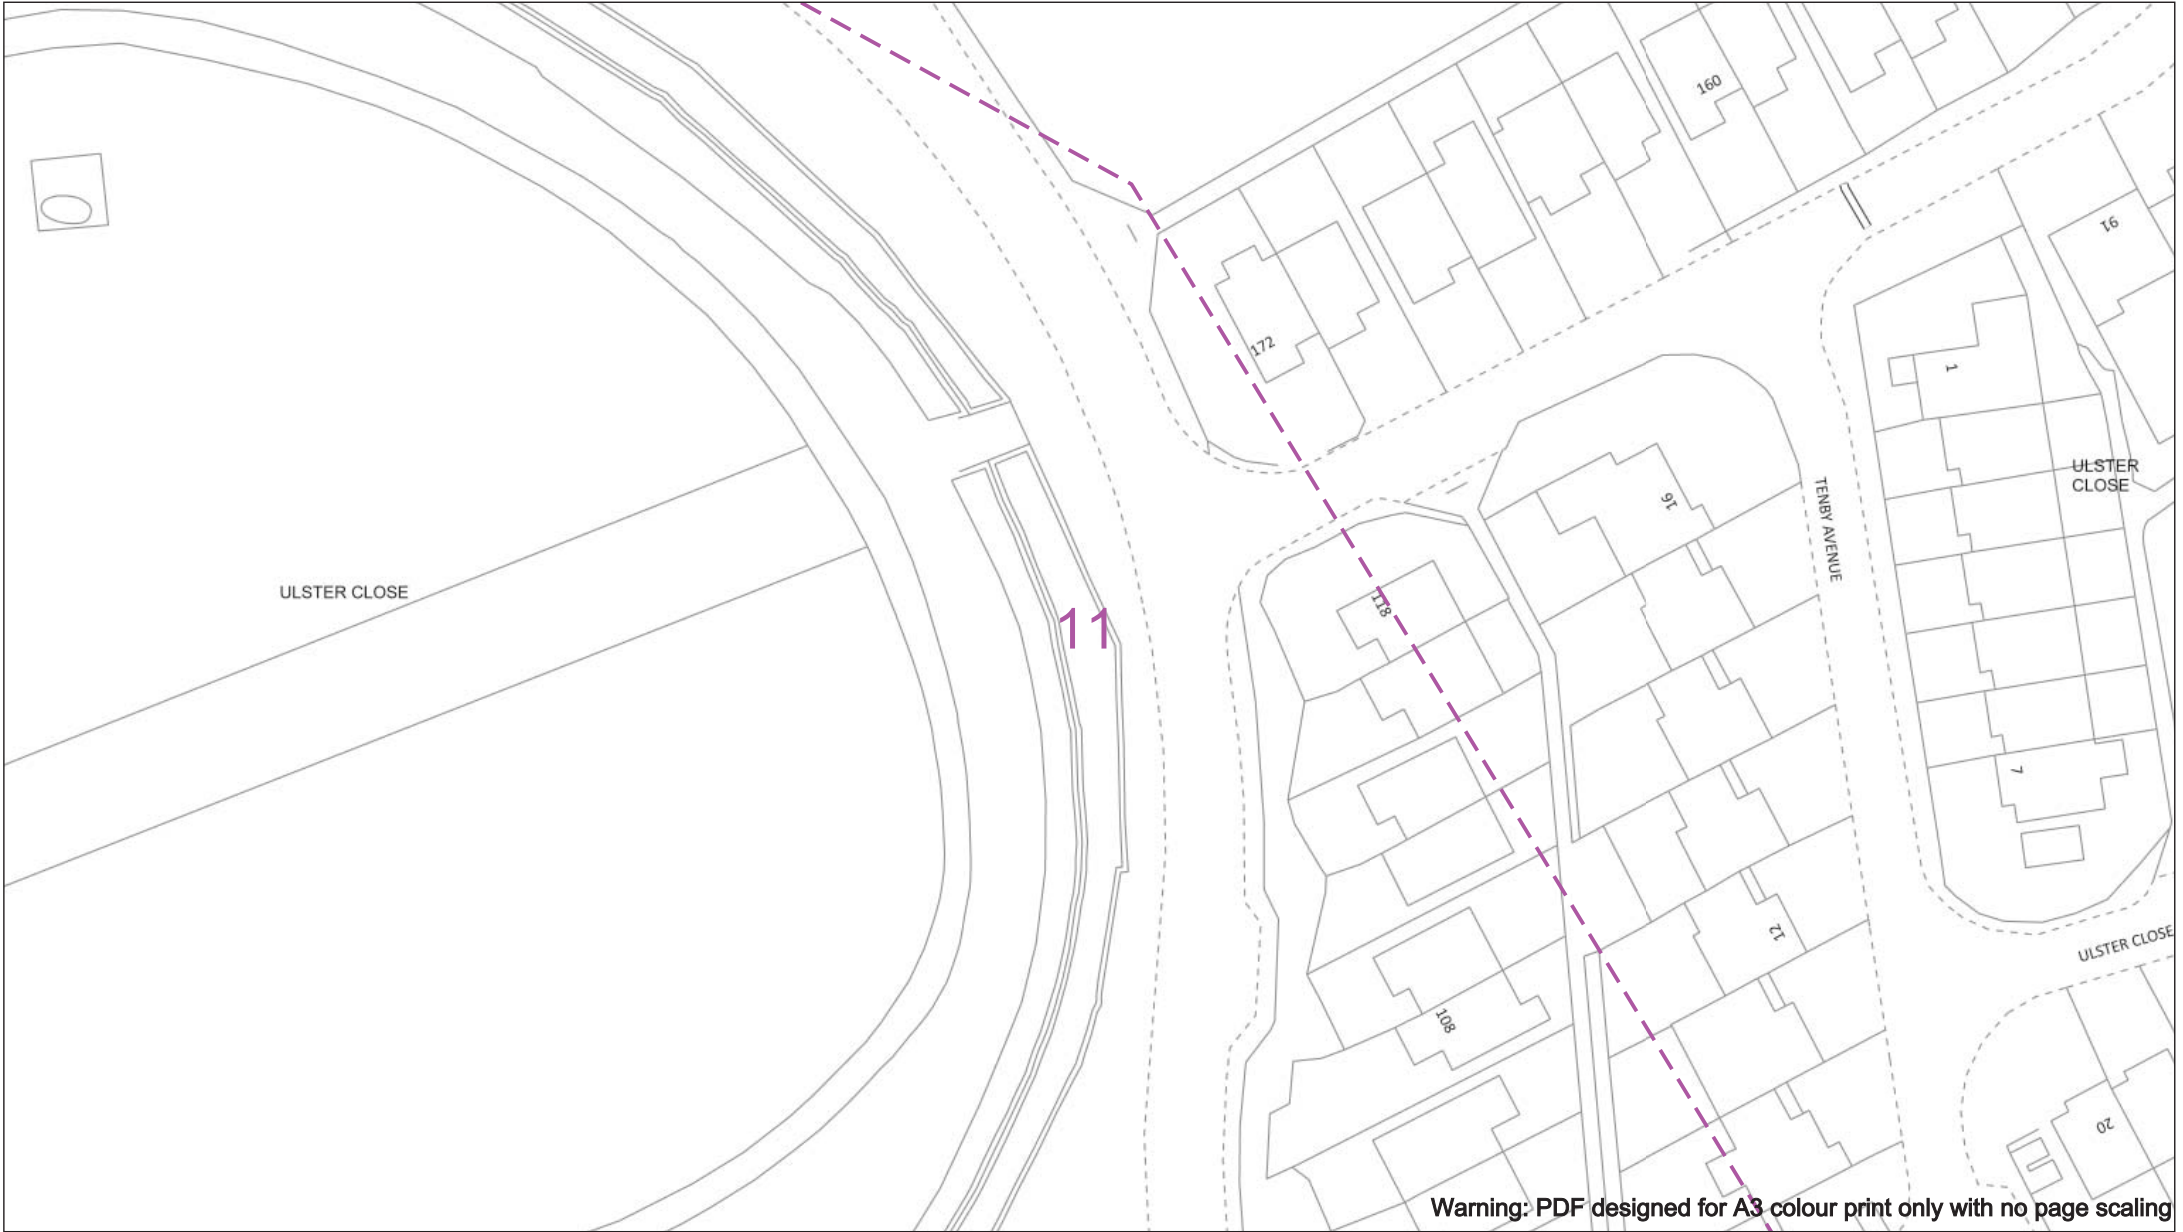

050m

Dig Sites

Area:

Line:

Date Requested: 09/11/2021

Job Reference: 23827726

Site Location: 472556 176139

Requested by: Ms Debbie Wigston

Your Scheme/Reference: 8210940

WARNING

There may have been subsequent alteration to the surface levels. Trial holes must be undertaken to determine position and depths of cables. HS (G) 47 Booklet from the Health and Safety Executive – Avoiding Danger from Buried Cables – should be consulted before commencing excavation work.

WHEN WORKING IN THE VICINITY OF OVERHEAD LINES THE HEALTH AND SAFETY GUIDANCE NOTES GS6 SHOULD BE CONSULTED (AVAILABLE FROM THE HSE WEBSITE)

Voltages (V)				
LV (Low Voltage) and Services	Up to 1,000V			
HV (High Voltage)	Over 1,000V to 11,000V			
EHV (Extra High Voltage)	22,000V to 132,000V			
Transmission	275,000V and 400,000V			

NORMAL DEPTH TO THE TOP OF THE CABLE WHEN LAID				
Services	LV	HV	EHV	
Footpath/Unmade	0.45m	0.45m	0.6m	0.8m
Road Crossing	0.6m	0.6m	0.75m	0.9m
Agricultural	1m	1m	1m	1.1m

Legend

Service Cable

LV Mains

2 – 3.3kV

6.6kV

11kV

22kV

33kV

66kV

132kV

275kV

400kV

Fibre Optic

Pilot Cable

Distribution Structures (Electric)

Pole, Existing Location

Pole Structure, Existing Location - Single

Pole Structure, Existing Location - H

Duct Route

Cross Section Route

Southern Electric Power Distribution plc

Registered Office: No.1 Forbury Place

43 Forbury Road Reading RG1 3JH

Registered in England & Wales No.04094290

If you're unsure & need to seek advice before commencing excavations please contact:

General Enquiries: 0800 048 3516


Subject to revision – Master held by SSEN Asset Data Team:

AssetData@ssen.com

01256 337 294

BASED UPON THE ORDNANCE SURVEY MAP WITH THE SANCTION OF THE CONTROLLER OF H.M. STATIONERY OFFICE CROWN COPYRIGHT RESERVED.

This copy has been made by or with the authority of Scottish and Southern Energy Power Distribution Ltd. Pursuant to section 47 of the Copyright, Designs and Patents Act 1988 ('The Act'). Unless the Act provides a relevant exception to copyright the copy must not be copied without prior permission of the copyright owner. Plans generated by DigSAFE Pro™ software provided by LinesearchbeforeUdig.

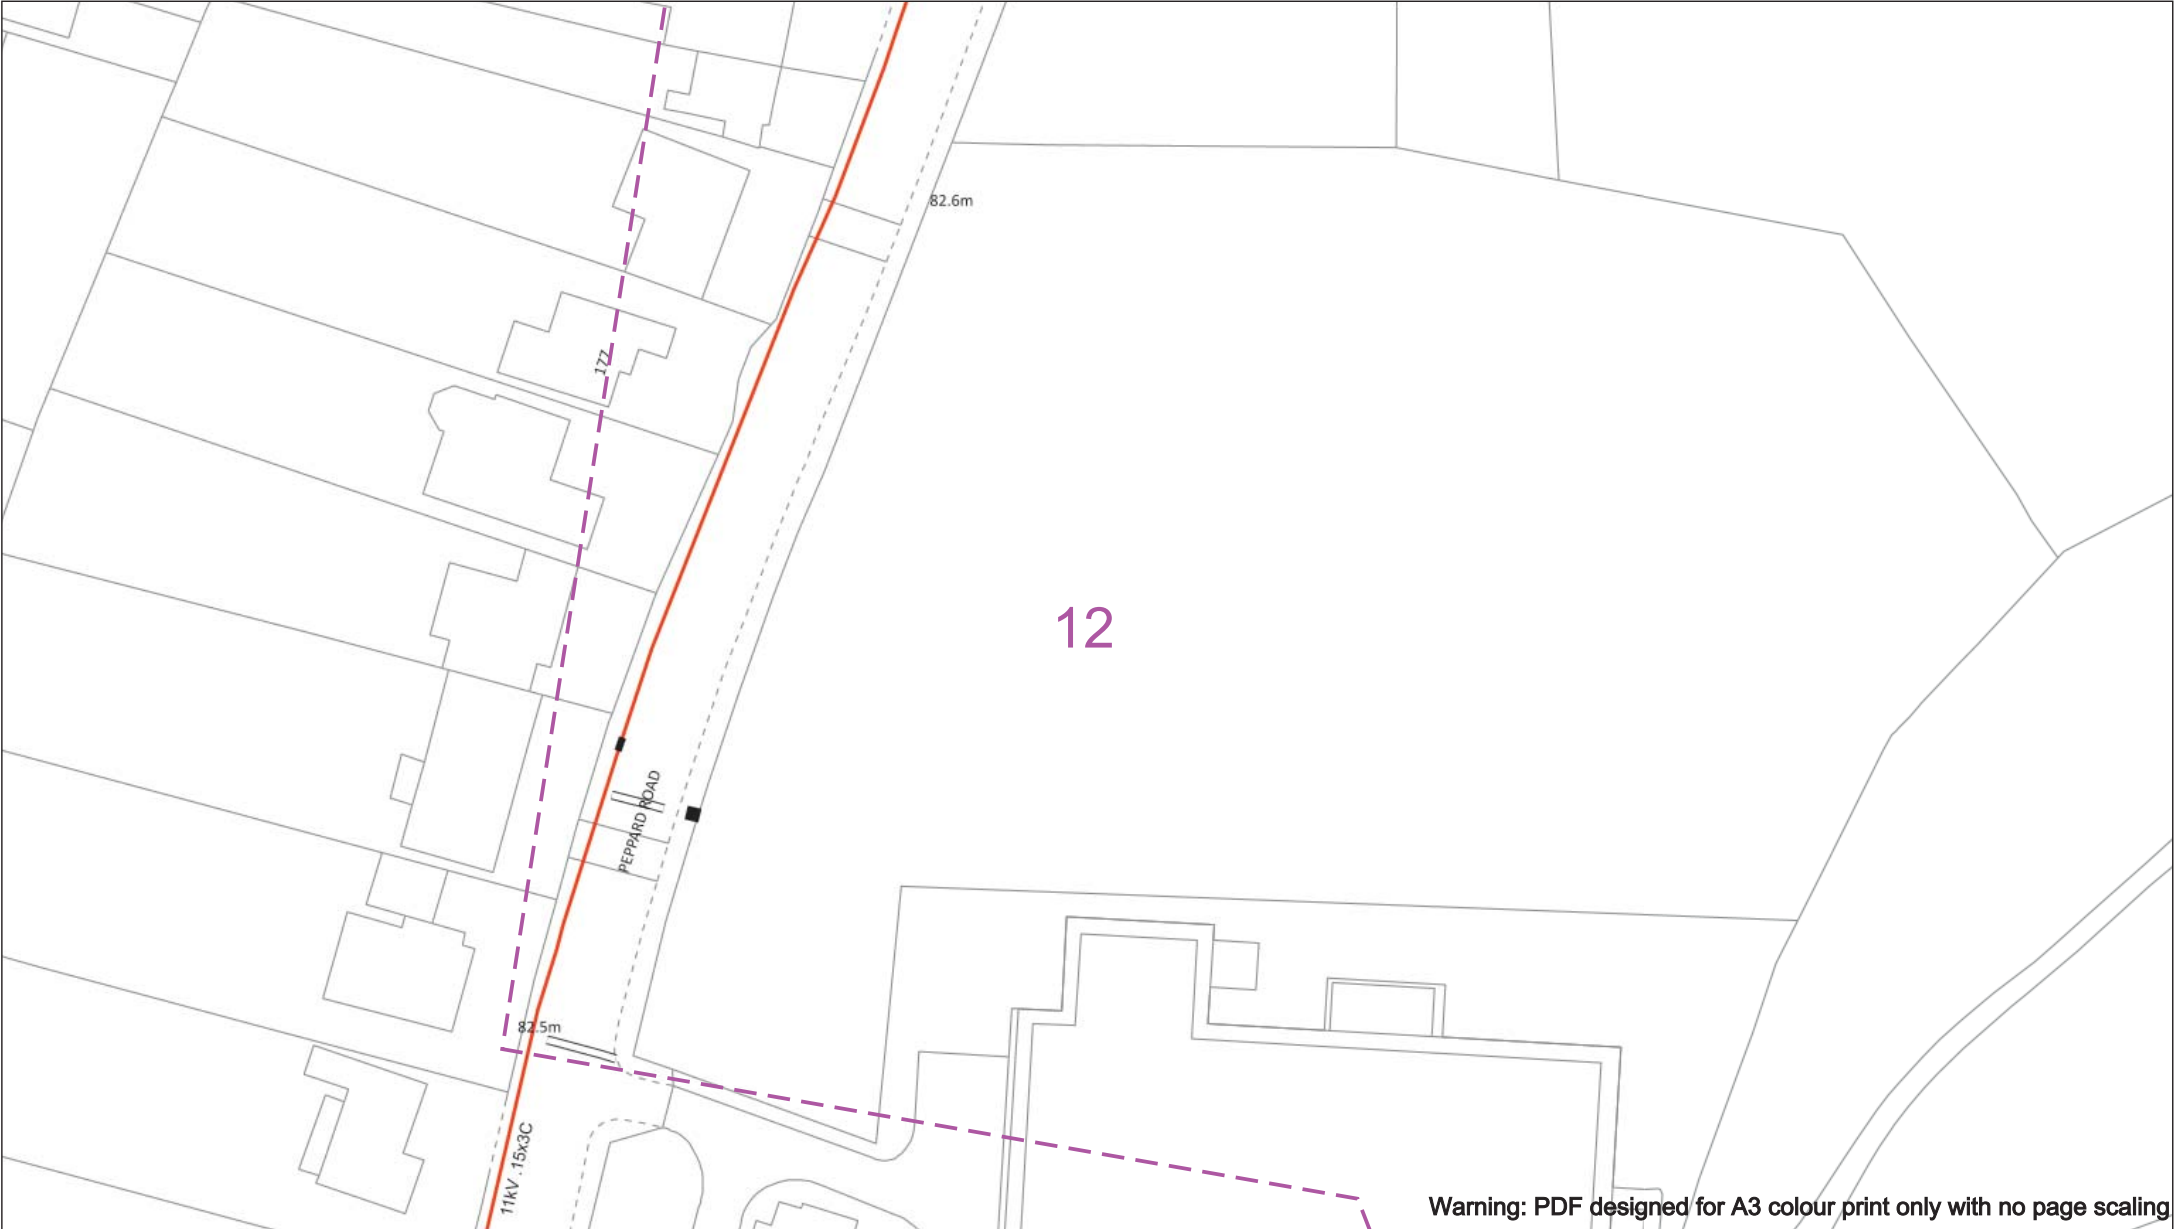

Warning: PDF designed for A3 colour print only with no page scaling

050m

Dig Sites

Area:

Line:

Date Requested: 09/11/2021

Job Reference: 23827726

Site Location: 472556 176139

Requested by: Ms Debbie Wigston

Your Scheme/Reference: 8210940

WARNING

There may have been subsequent alteration to the surface levels. Trial holes must be undertaken to determine position and depths of cables. HS (G) 47 Booklet from the Health and Safety Executive – Avoiding Danger from Buried Cables – should be consulted before commencing excavation work.

WHEN WORKING IN THE VICINITY OF OVERHEAD LINES THE HEALTH AND SAFETY GUIDANCE NOTES GS6 SHOULD BE CONSULTED (AVAILABLE FROM THE HSE WEBSITE)

Voltages (V)			
LV (Low Voltage) and Services	Up to 1,000V		
HV (High Voltage)	Over 1,000V to 11,000V		
EHV (Extra High Voltage)	22,000V to 132,000V		
Transmission	275,000V and 400,000V		

NORMAL DEPTH TO THE TOP OF THE CABLE WHEN LAID				
Services	LV	HV	EHV	
Footpath/Unmade	0.45m	0.45m	0.6m	0.8m
Road Crossing	0.6m	0.6m	0.75m	0.9m
Agricultural	1m	1m	1m	1.1m

Legend

Service Cable

LV Mains

2 – 3.3kV

6.6kV

11kV

22kV

33kV

66kV

132kV

275kV

400kV

Flow Cyclic

Pole Cable

Distribution Structures (Electric)

Pole, Existing Location

Pole Structure, Existing Location - Single

Pole Structure, Existing Location - H

Duct Route


Cross Section Route

Southern Electric Power Distribution plc
Registered Office: No.1 Forbury Place
43 Forbury Road Reading RG1 3JH
Registered in England & Wales No.04094290

If you're unsure & need to seek advice before commencing excavations please contact:
General Enquiries: 0800 048 3516

Subject to revision – Master held by SSEN Asset Data Team:
Asset.Data@ssen.com
01256 337 294

BASED UPON THE ORDNANCE SURVEY MAP WITH THE SANCTION OF THE CONTROLLER OF H.M STATIONERY OFFICE CROWN COPYRIGHT RESERVED.
This copy has been made by or with the authority of Scottish and Southern Energy Power Distribution Ltd. Pursuant to section 47 of the Copyright, Designs and Patents Act 1988 ('The Act'). Unless the Act provides a relevant exception to copyright the copy must not be copied without prior permission of the copyright owner. Plans generated by DigSAFE Pro™ software provided by LinesearchbeforeUdig.

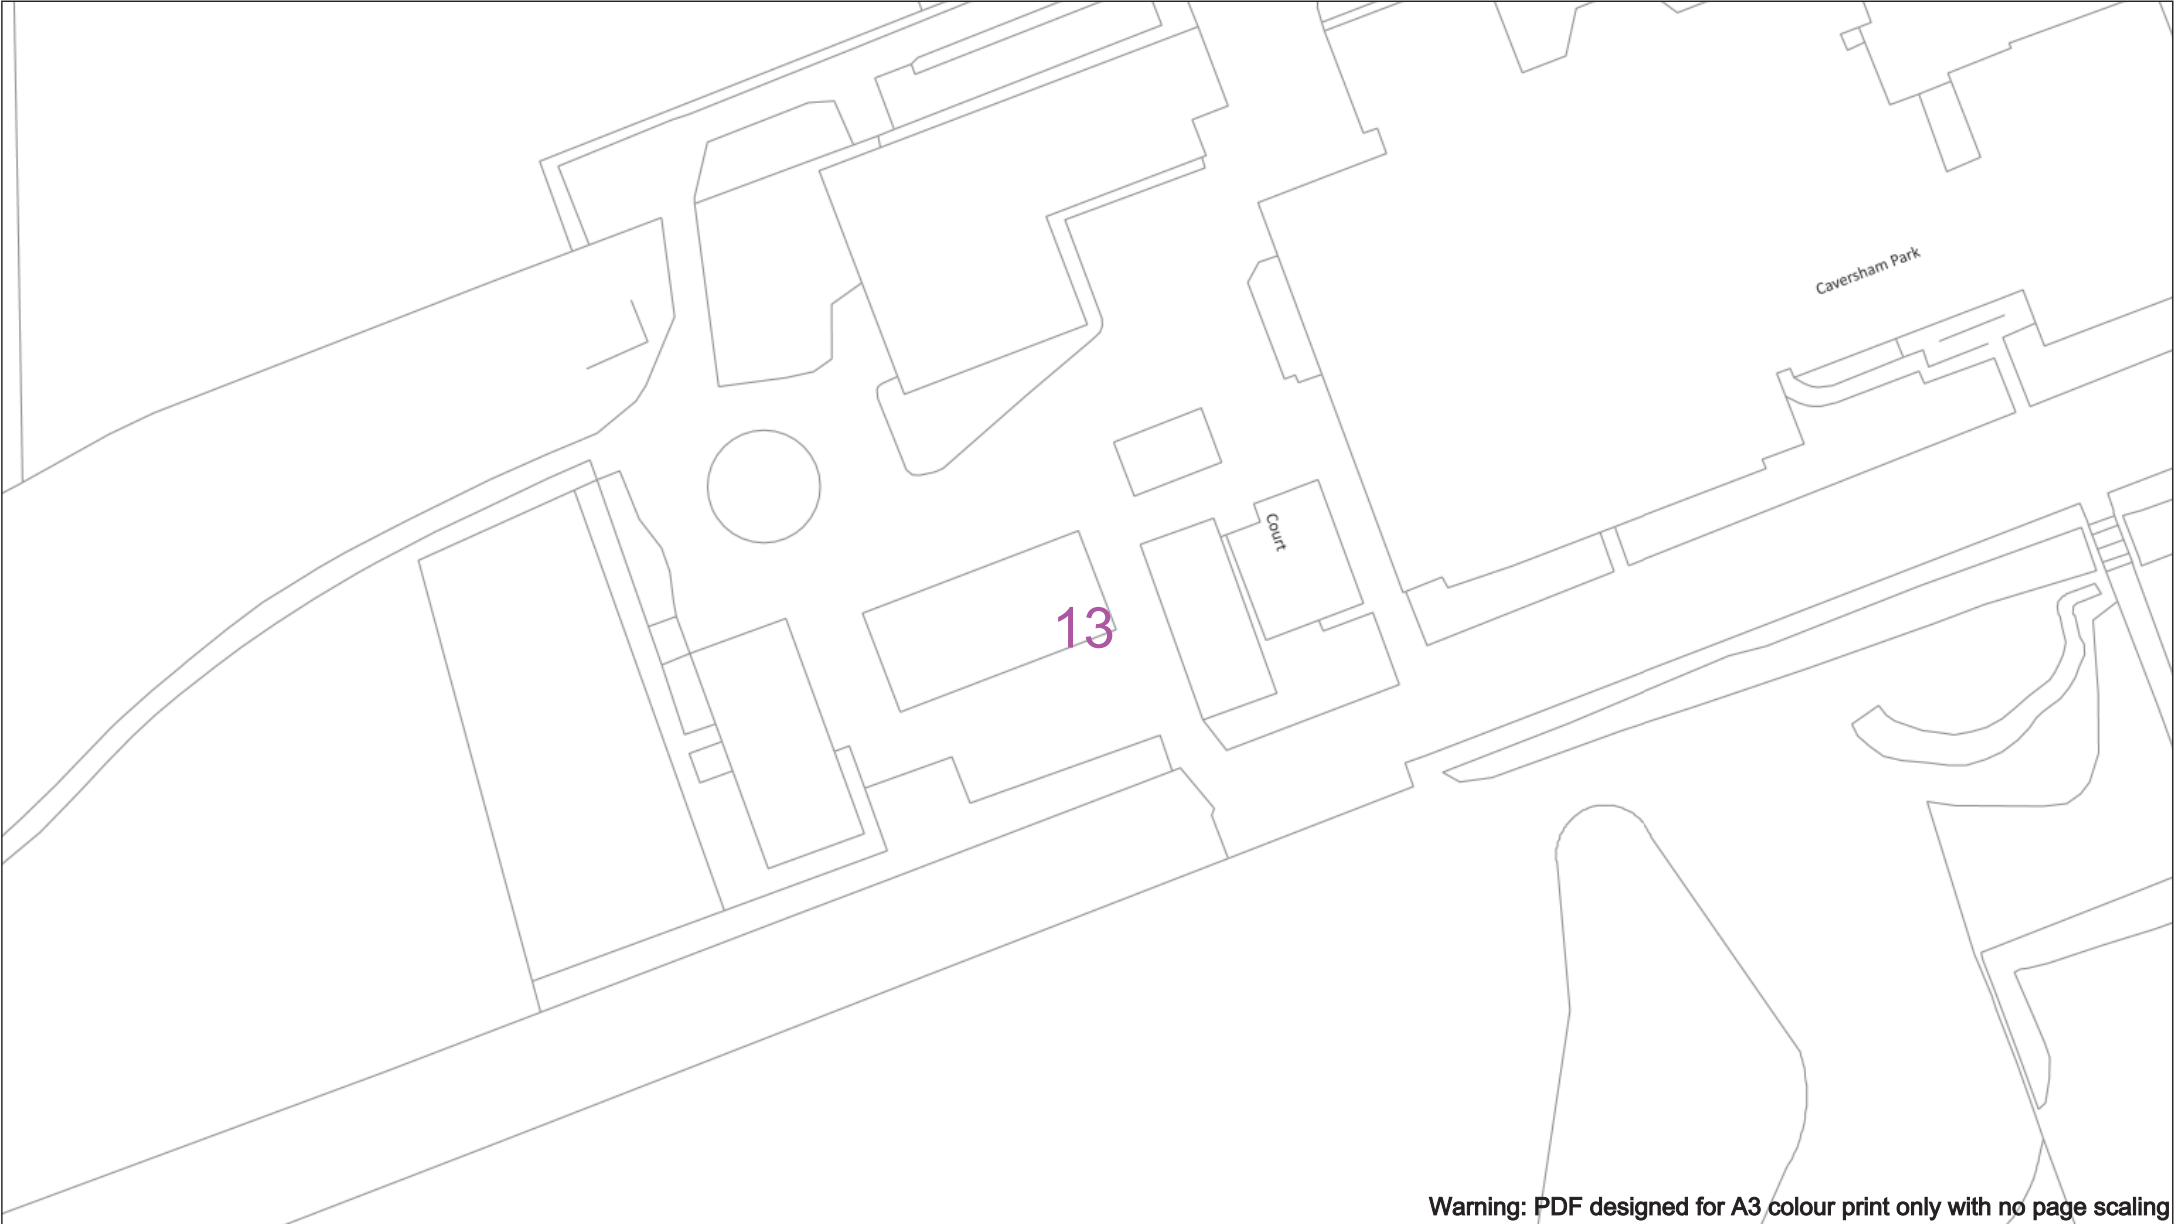

050m

Dig Sites

Area:

Line:

Date Requested: 09/11/2021

Job Reference: 23827726

Site Location: 472556 176139

Requested by: Ms Debbie Wigston

Your Scheme/Reference: 8210940

WARNING

There may have been subsequent alteration to the surface levels. Trial holes must be undertaken to determine position and depths of cables. HS (G) 47 Booklet from the Health and Safety Executive – Avoiding Danger from Buried Cables – should be consulted before commencing excavation work.

WHEN WORKING IN THE VICINITY OF OVERHEAD LINES THE HEALTH AND SAFETY GUIDANCE NOTES GS6 SHOULD BE CONSULTED (AVAILABLE FROM THE HSE WEBSITE)

Voltages (V)

LV (Low Voltage) and Services	Up to 1,000V
HV (High Voltage)	Over 1,000V to 11,000V
EHV (Extra High Voltage)	22,000V to 132,000V
Transmission	275,000V and 400,000V

NORMAL DEPTH TO THE TOP OF THE CABLE WHEN LAID

Services	LV	HV	EHV
Footpath/Unmade	0.45m	0.45m	0.6m
Road Crossing	0.6m	0.6m	0.75m
Agricultural	1m	1m	1.1m

Legend

Service Cable

LV Mains

2 – 3.3kV

6.6kV

11kV

22kV

33kV

66kV

132kV

275kV

400kV

Fibre Optic

Pilot Cable

Distribution Structures (Electric)

Pole, Existing Location

Pole Structure, Existing Location - Single

Pole Structure, Existing Location - H

Duct Route

Cross Section Route

Southern Electric Power Distribution plc

Registered Office: No.1 Forbury Place

43 Forbury Road Reading RG1 3JH

Registered in England & Wales No.04094290

If you're unsure & need to seek advice before commencing excavations please contact:

General Enquiries: 0800 048 3516


Subject to revision – Master held by SSEN Asset Data Team:

Asset.Data@se.com

01256 337 294

BASED UPON THE ORDNANCE SURVEY MAP WITH THE SANCTION OF THE CONTROLLER OF H.M STATIONERY OFFICE CROWN COPYRIGHT RESERVED.

This copy has been made by or with the authority of Scottish and Southern Energy Power Distribution Ltd. Pursuant to section 47 of the Copyright, Designs and Patents Act 1988 ('The Act'). Unless the Act provides a relevant exception to copyright the copy must not be copied without prior permission of the copyright owner. Plans generated by DigSAFE Pro™ software provided by LinesearchbeforeUdig.

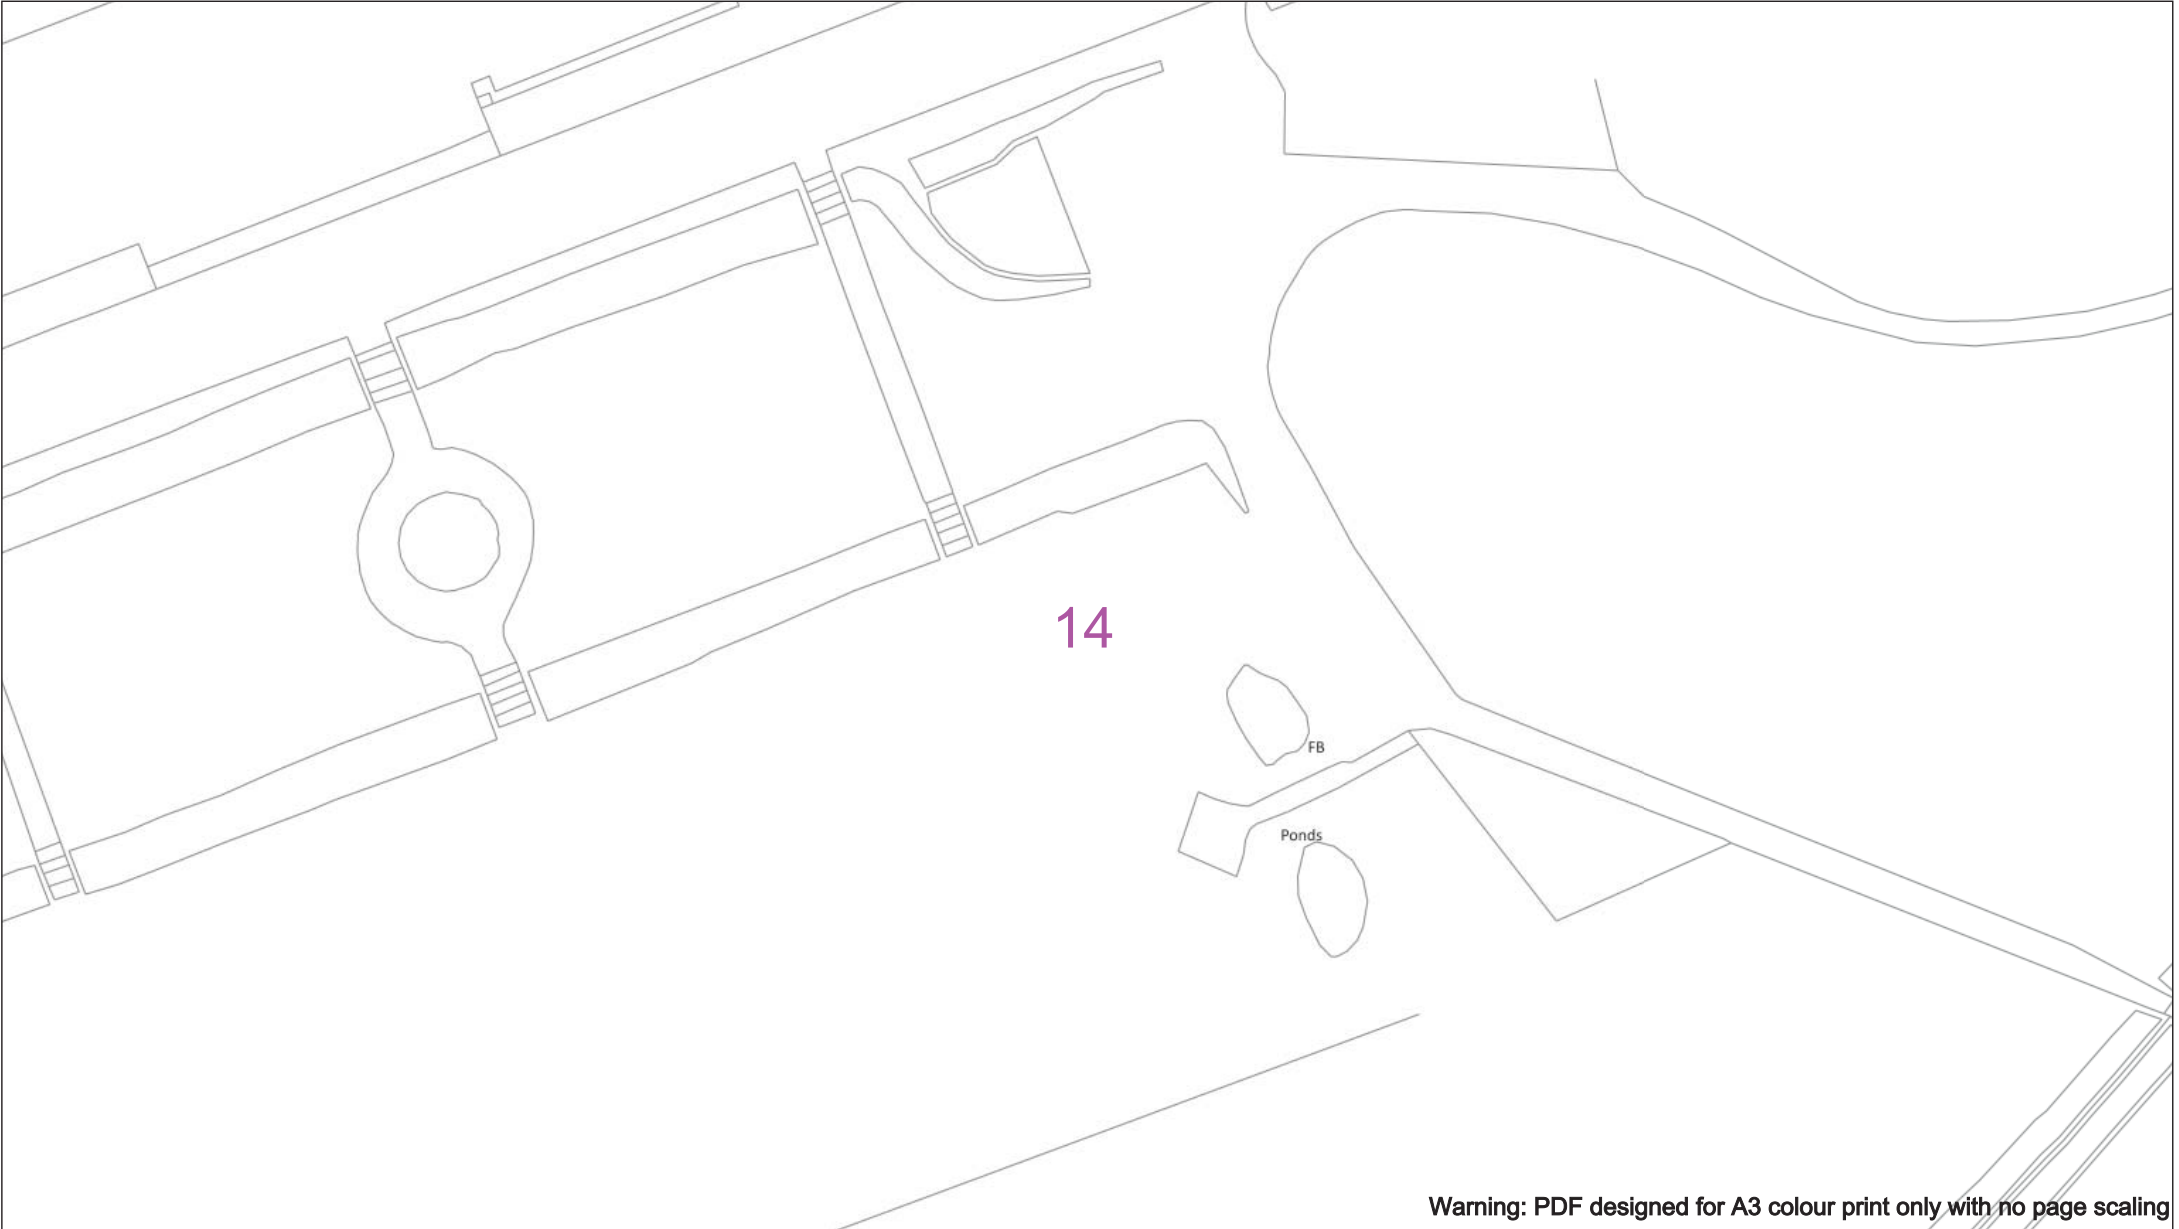

050m

Dig Sites

Area: 

Line: 

Date Requested: 09/11/2021

Job Reference: 23827726

Site Location: 472556 176139

Requested by: Ms Debbie Wigston

Your Scheme/Reference: 8210940

WARNING

There may have been subsequent alteration to the surface levels. Trial holes must be undertaken to determine position and depths of cables. HS (G) 47 Booklet from the Health and Safety Executive – Avoiding Danger from Buried Cables – should be consulted before commencing excavation work.

WHEN WORKING IN THE VICINITY OF OVERHEAD LINES THE HEALTH AND SAFETY GUIDANCE NOTES GS6 SHOULD BE CONSULTED (AVAILABLE FROM THE HSE WEBSITE)

Voltages (V)

LV (Low Voltage) and Services Up to 1,000V

HV (High Voltage) Over 1,000V to 11,000V

EHV (Extra High Voltage) 22,000V to 132,000V

Transmission 275,000V and 400,000V

NORMAL DEPTH TO THE TOP OF THE CABLE WHEN LAID

	Services	LV	HV	EHV
Footpath/Unmade	0.45m	0.45m	0.6m	0.8m
Road Crossing	0.6m	0.6m	0.75m	0.9m
Agricultural	1m	1m	1m	1.1m

Legend

 Service Cable

 LV Mains

 2 – 3.3kV

 6.6kV

 11kV

 132kV

 275kV

 400kV

 Fibre Optic

 Pipe Cable

Distribution Structures (Electric)

 Pole, Existing Location

 Pole Structure, Existing Location - Single

 Pole Structure, Existing Location - H

 Duct Route

 Cross Section Route



Southern Electric Power Distribution plc

Registered Office: No.1 Forbury Place

43 Forbury Road Reading RG1 3JH

Registered in England & Wales No.04094290

If you're unsure & need to seek advice before commencing excavations please contact:

General Enquiries: 0800 048 3516


Subject to revision – Master held by SSEN Asset Data Team:

Asset.Data@ssen.com

01256 337 294

BASED UPON THE ORDNANCE SURVEY MAP WITH THE SANCTION OF THE CONTROLLER OF H.M STATIONERY OFFICE CROWN COPYRIGHT RESERVED.

This copy has been made by or with the authority of Scottish and Southern Energy Power Distribution Ltd. Pursuant to section 47 of the Copyright, Designs and Patents Act 1988 ('The Act'). Unless the Act provides a relevant exception to copyright the copy must not be copied without prior permission of the copyright owner. Plans generated by DigSAFE Pro™ software provided by LinesearchbeforeUdig.

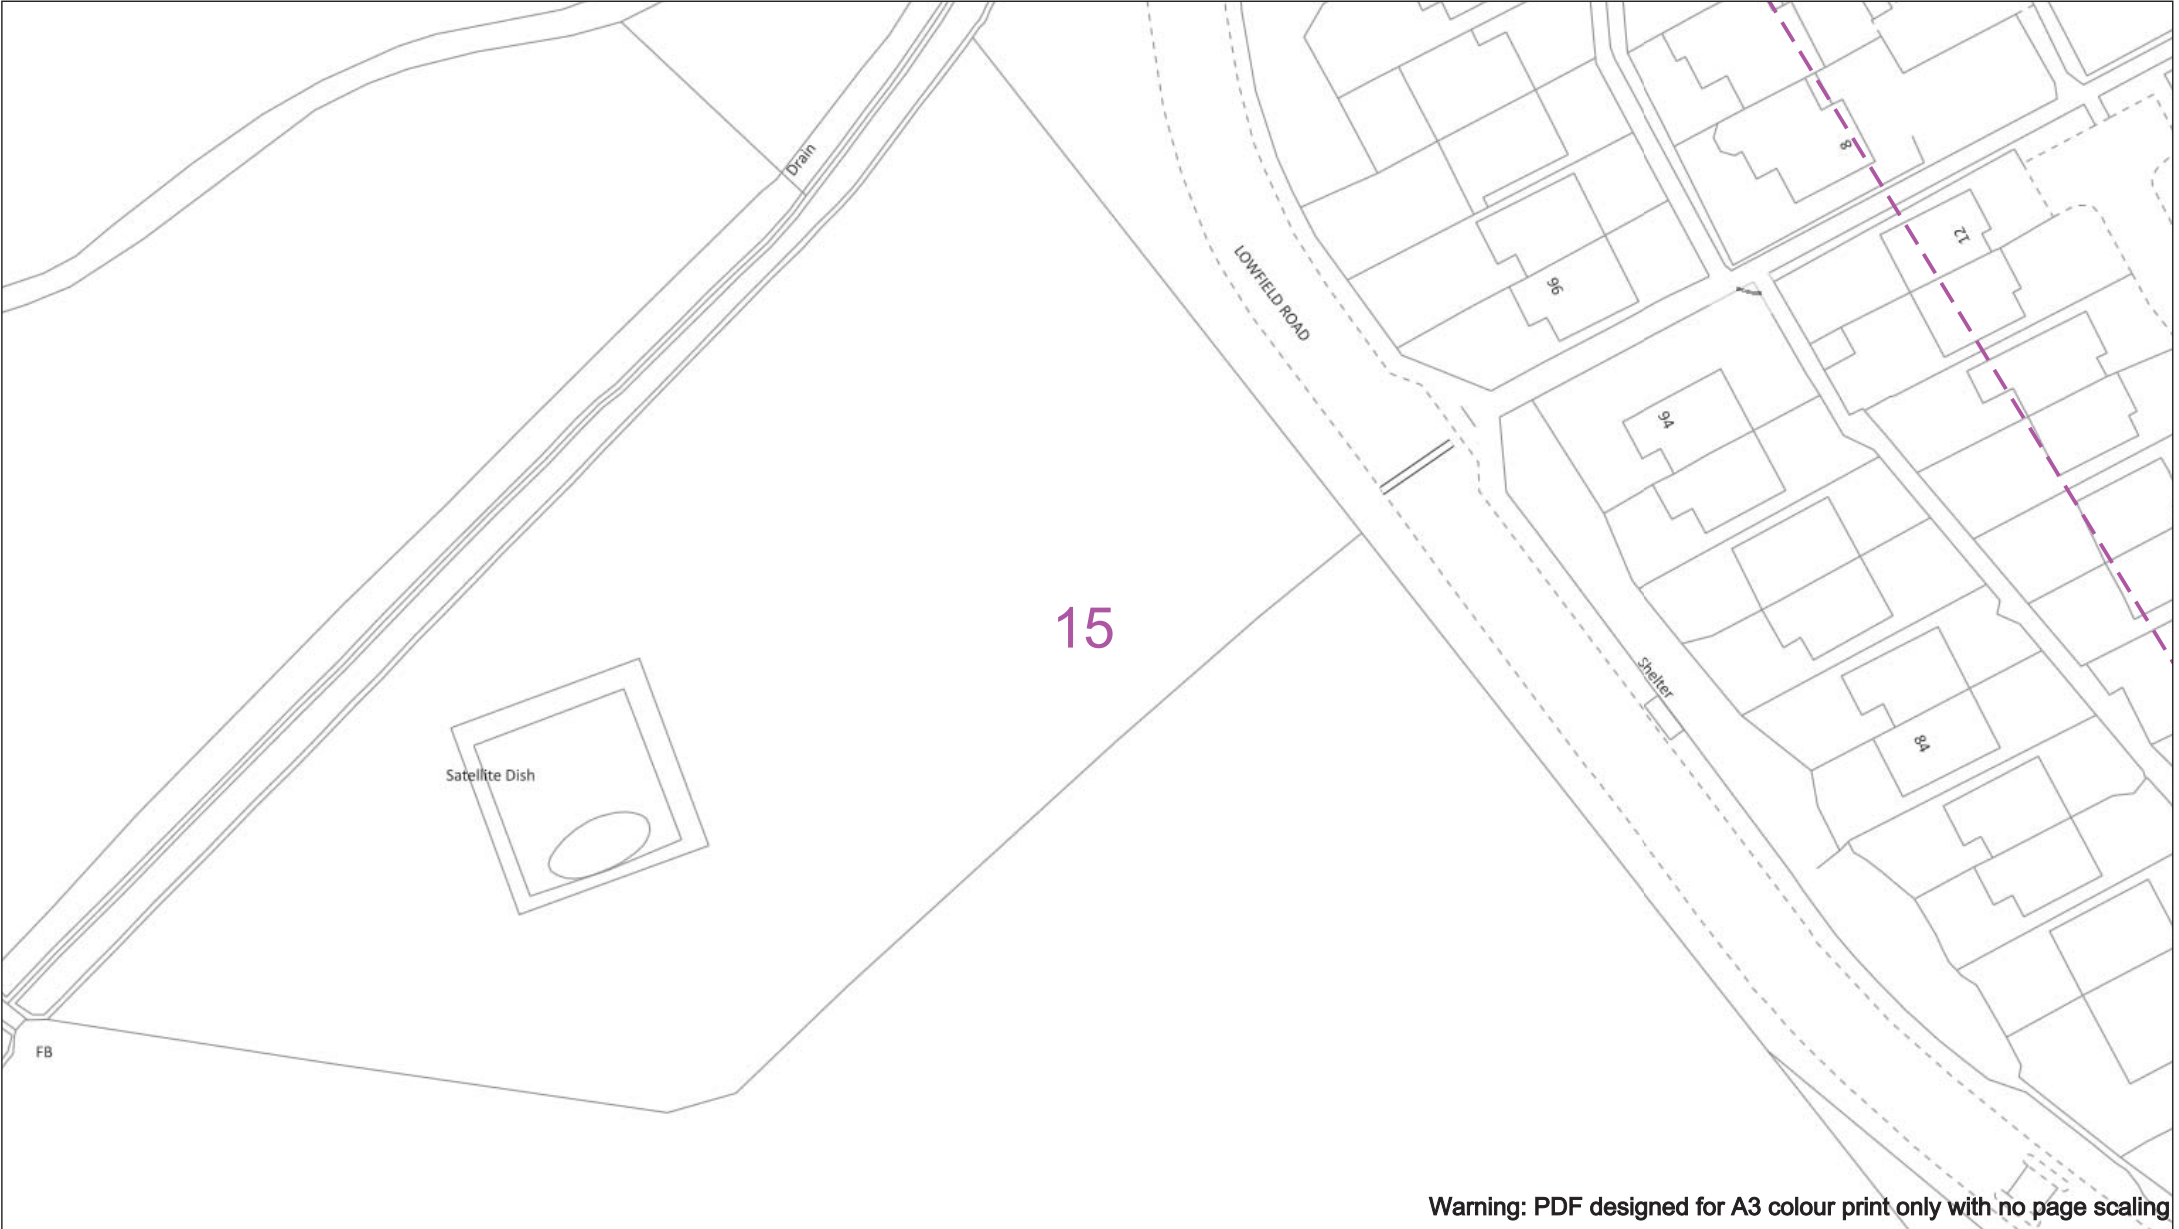

Warning: PDF designed for A3 colour print only with no page scaling

050m

Dig Sites

Area:

Line:

Date Requested: 09/11/2021

Job Reference: 23827726

Site Location: 472556 176139

Requested by: Ms Debbie Wigston

Your Scheme/Reference: 8210940

WARNING

There may have been subsequent alteration to the surface levels. Trial holes must be undertaken to determine position and depths of cables. HS (G) 47 Booklet from the Health and Safety Executive – Avoiding Danger from Buried Cables – should be consulted before commencing excavation work.

WHEN WORKING IN THE VICINITY OF OVERHEAD LINES THE HEALTH AND SAFETY GUIDANCE NOTES GS6 SHOULD BE CONSULTED (AVAILABLE FROM THE HSE WEBSITE)

Scale: 1:500 (When plotted at A3)

Voltages (V)

LV (Low Voltage) and Services

Up to 1,000V

HV (High Voltage)

Over 1,000V to 11,000V

EHV (Extra High Voltage)

22,000V to 132,000V

Transmission

275,000V and 400,000V

NORMAL DEPTH TO THE TOP OF THE CABLE WHEN LAID

Services	LV	HV	EHV
Footpath/Unmade	0.45m	0.45m	0.6m
Road Crossing	0.6m	0.6m	0.75m
Agricultural	1m	1m	1.1m

Legend

Service Cable

LV Mains

2 – 3.3kV

6.6kV

11kV

22kV

33kV

66kV

132kV

275kV

400kV

Fibre Optic

Pilot Cable

Distribution Structures (Electric)

Pole, Existing Location

Pole Structure, Existing Location - Single

Pole Structure, Existing Location - H

Duct Route

Cross Section Route

Southern Electric Power Distribution plc

Registered Office: No.1 Forbury Place

43 Forbury Road Reading RG1 3JH

Registered in England & Wales No.04094290

If you're unsure & need to seek advice before commencing excavations please contact:

General Enquiries: 0800 048 3516


Subject to revision – Master held by SSEN Asset Data Team:

Asset.Data@se.com

01256 337 294

BASED UPON THE ORDINANCE SURVEY MAP WITH THE SANCTION OF THE CONTROLLER OF H.M STATIONERY OFFICE CROWN COPYRIGHT RESERVED.

This copy has been made by or with the authority of Scottish and Southern Energy Power Distribution Ltd. Pursuant to section 47 of the Copyright, Designs and Patents Act 1988 ('The Act'). Unless the Act provides a relevant exception to copyright the copy must not be copied without prior permission of the copyright owner. Plans generated by DigSAFE Pro™ software provided by LinesearchbeforeUdig.

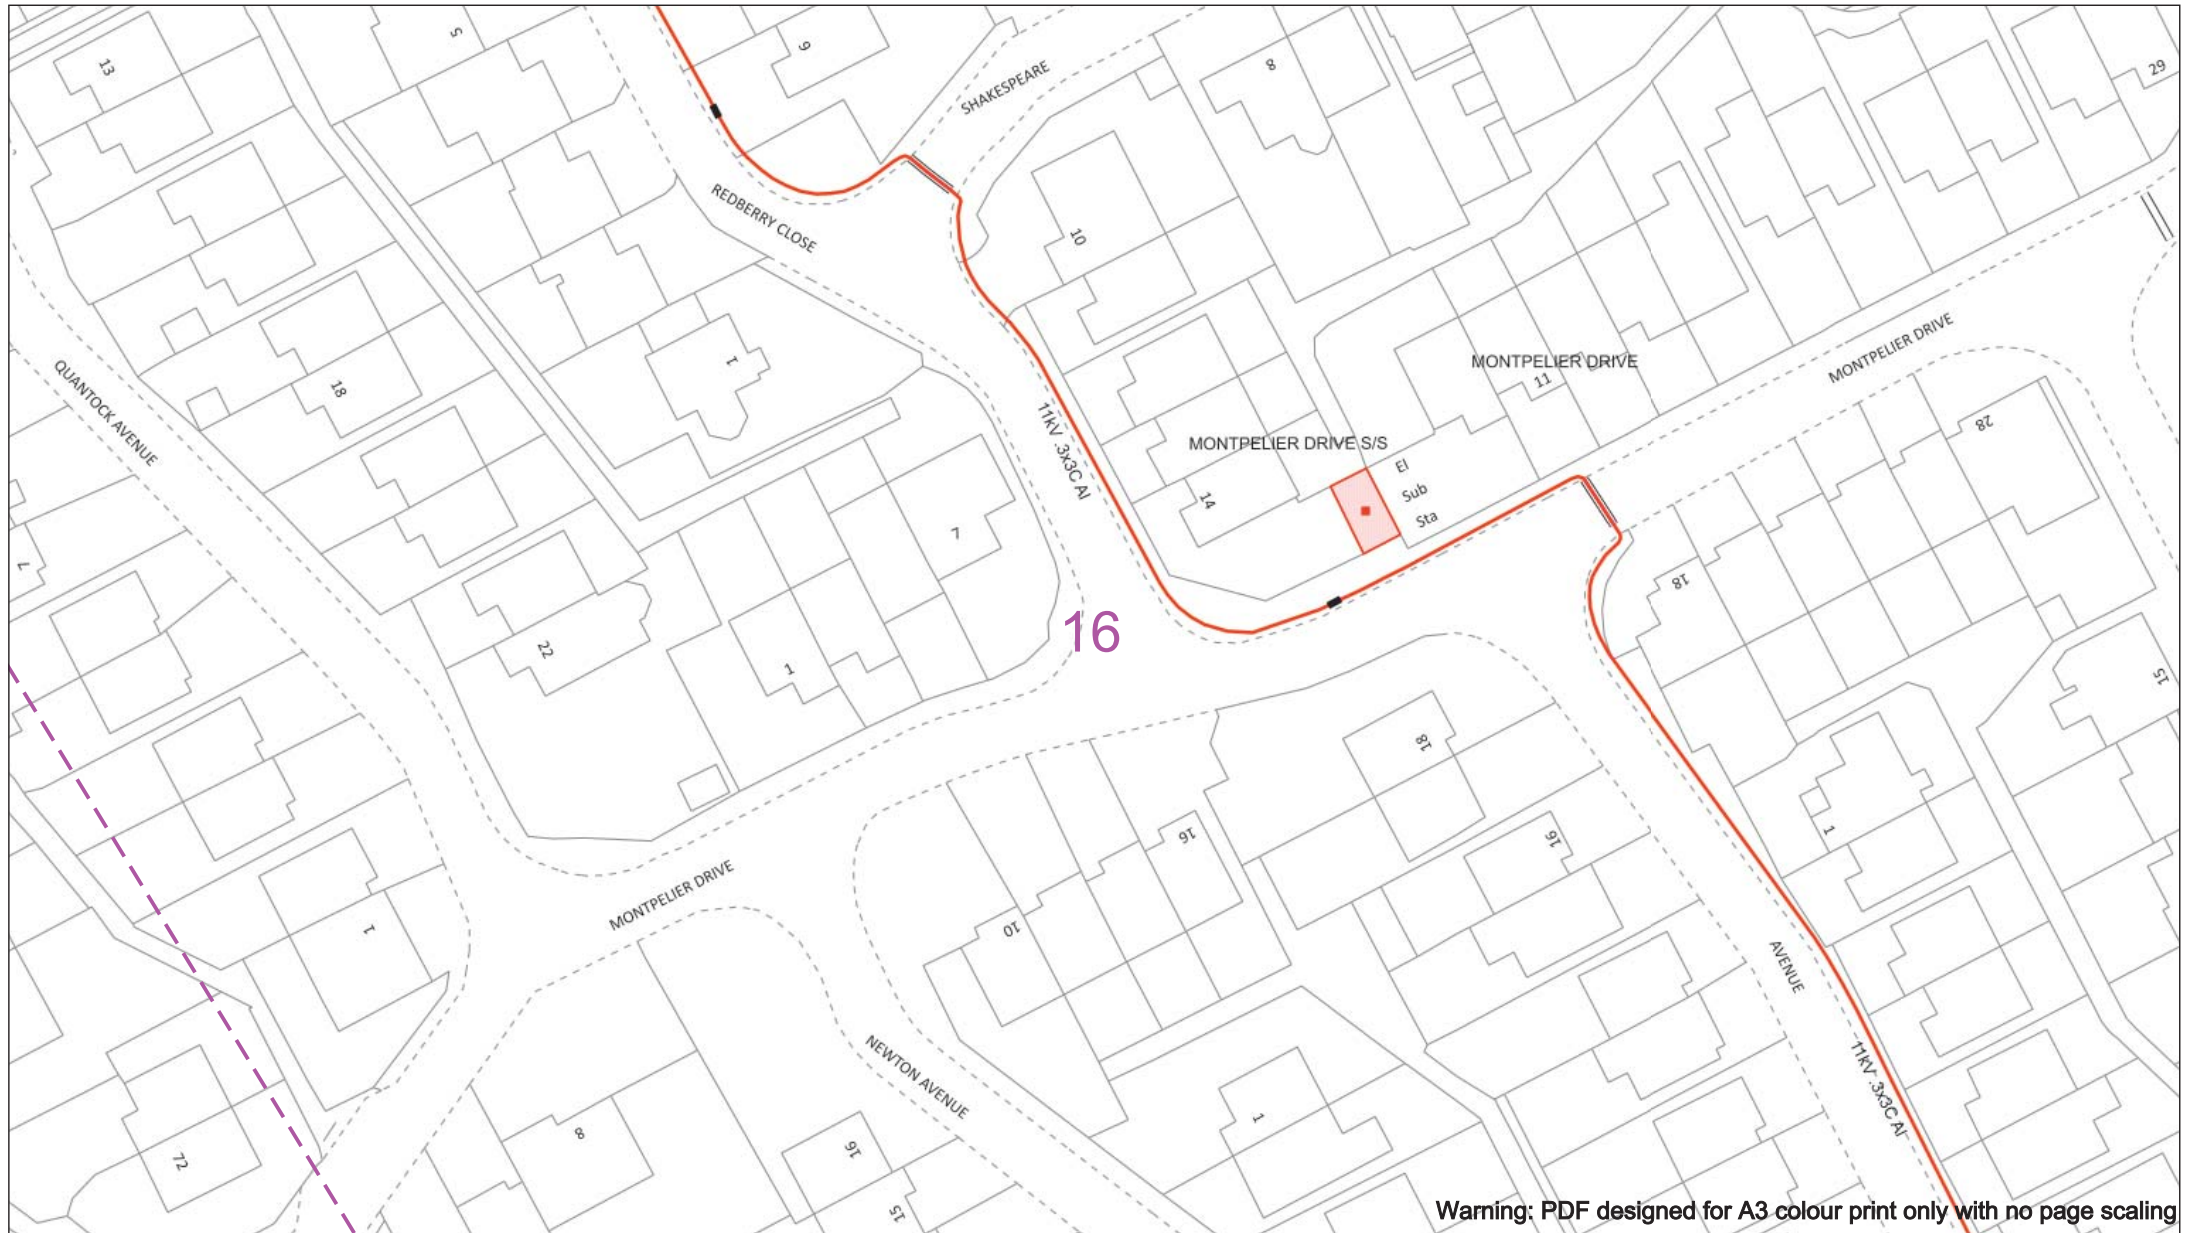

Warning: PDF designed for A3 colour print only with no page scaling

050m

Dig Sites

Area:

Line:

Date Requested: 09/11/2021

Job Reference: 23827726

Site Location: 472556 176139

Requested by: Ms Debbie Wigston

Your Scheme/Reference: 8210940

WARNING

There may have been subsequent alteration to the surface levels. Trial holes must be undertaken to determine position and depths of cables. HS (G) 47 Booklet from the Health and Safety Executive – Avoiding Danger from Buried Cables – should be consulted before commencing excavation work.

WHEN WORKING IN THE VICINITY OF OVERHEAD LINES THE HEALTH AND SAFETY GUIDANCE NOTES GS6 SHOULD BE CONSULTED (AVAILABLE FROM THE HSE WEBSITE)

Voltages (V)				
LV (Low Voltage) and Services	Up to 1,000V			
HV (High Voltage)	Over 1,000V to 11,000V			
EHV (Extra High Voltage)	22,000V to 132,000V			
Transmission	275,000V and 400,000V			

NORMAL DEPTH TO THE TOP OF THE CABLE WHEN LAID				
Services	LV	HV	EHV	
Footpath/Unmade	0.45m	0.45m	0.6m	0.8m
Road Crossing	0.6m	0.6m	0.75m	0.9m
Agricultural	1m	1m	1m	1.1m

Legend

Service Cable

LV Mains

2-3.3kV

6.6kV

11kV

22kV

33kV

66kV

132kV

275kV

400kV

Fibre Optic

Pilot Cable

Distribution Structures (Electric)

Pole, Existing Location

Pole Structure, Existing Location - Single

Pole Structure, Existing Location - H

Duct Route

Cross Section Route


Southern Electric Power Distribution plc
Registered Office: No.1 Forbury Place
43 Forbury Road Reading RG1 3JH
Registered in England & Wales No.04094290

If you're unsure & need to seek advice before commencing excavations please contact:
General Enquiries: 0800 048 3516

Subject to revision – Master held by SSEN Asset Data Team:
AssetData@ssen.com
01256 337 294

BASED UPON THE ORDNANCE SURVEY MAP WITH THE SANCTION OF THE CONTROLLER OF H.M STATIONERY OFFICE CROWN COPYRIGHT RESERVED.

This copy has been made by or with the authority of Scottish and Southern Energy Power Distribution Ltd. Pursuant to section 47 of the Copyright, Designs and Patents Act 1988 ('The Act'). Unless the Act provides a relevant exception to copyright the copy must not be copied without prior permission of the copyright owner. Plans generated by DigSAFE Pro™ software provided by LinesearchbeforeUdig.

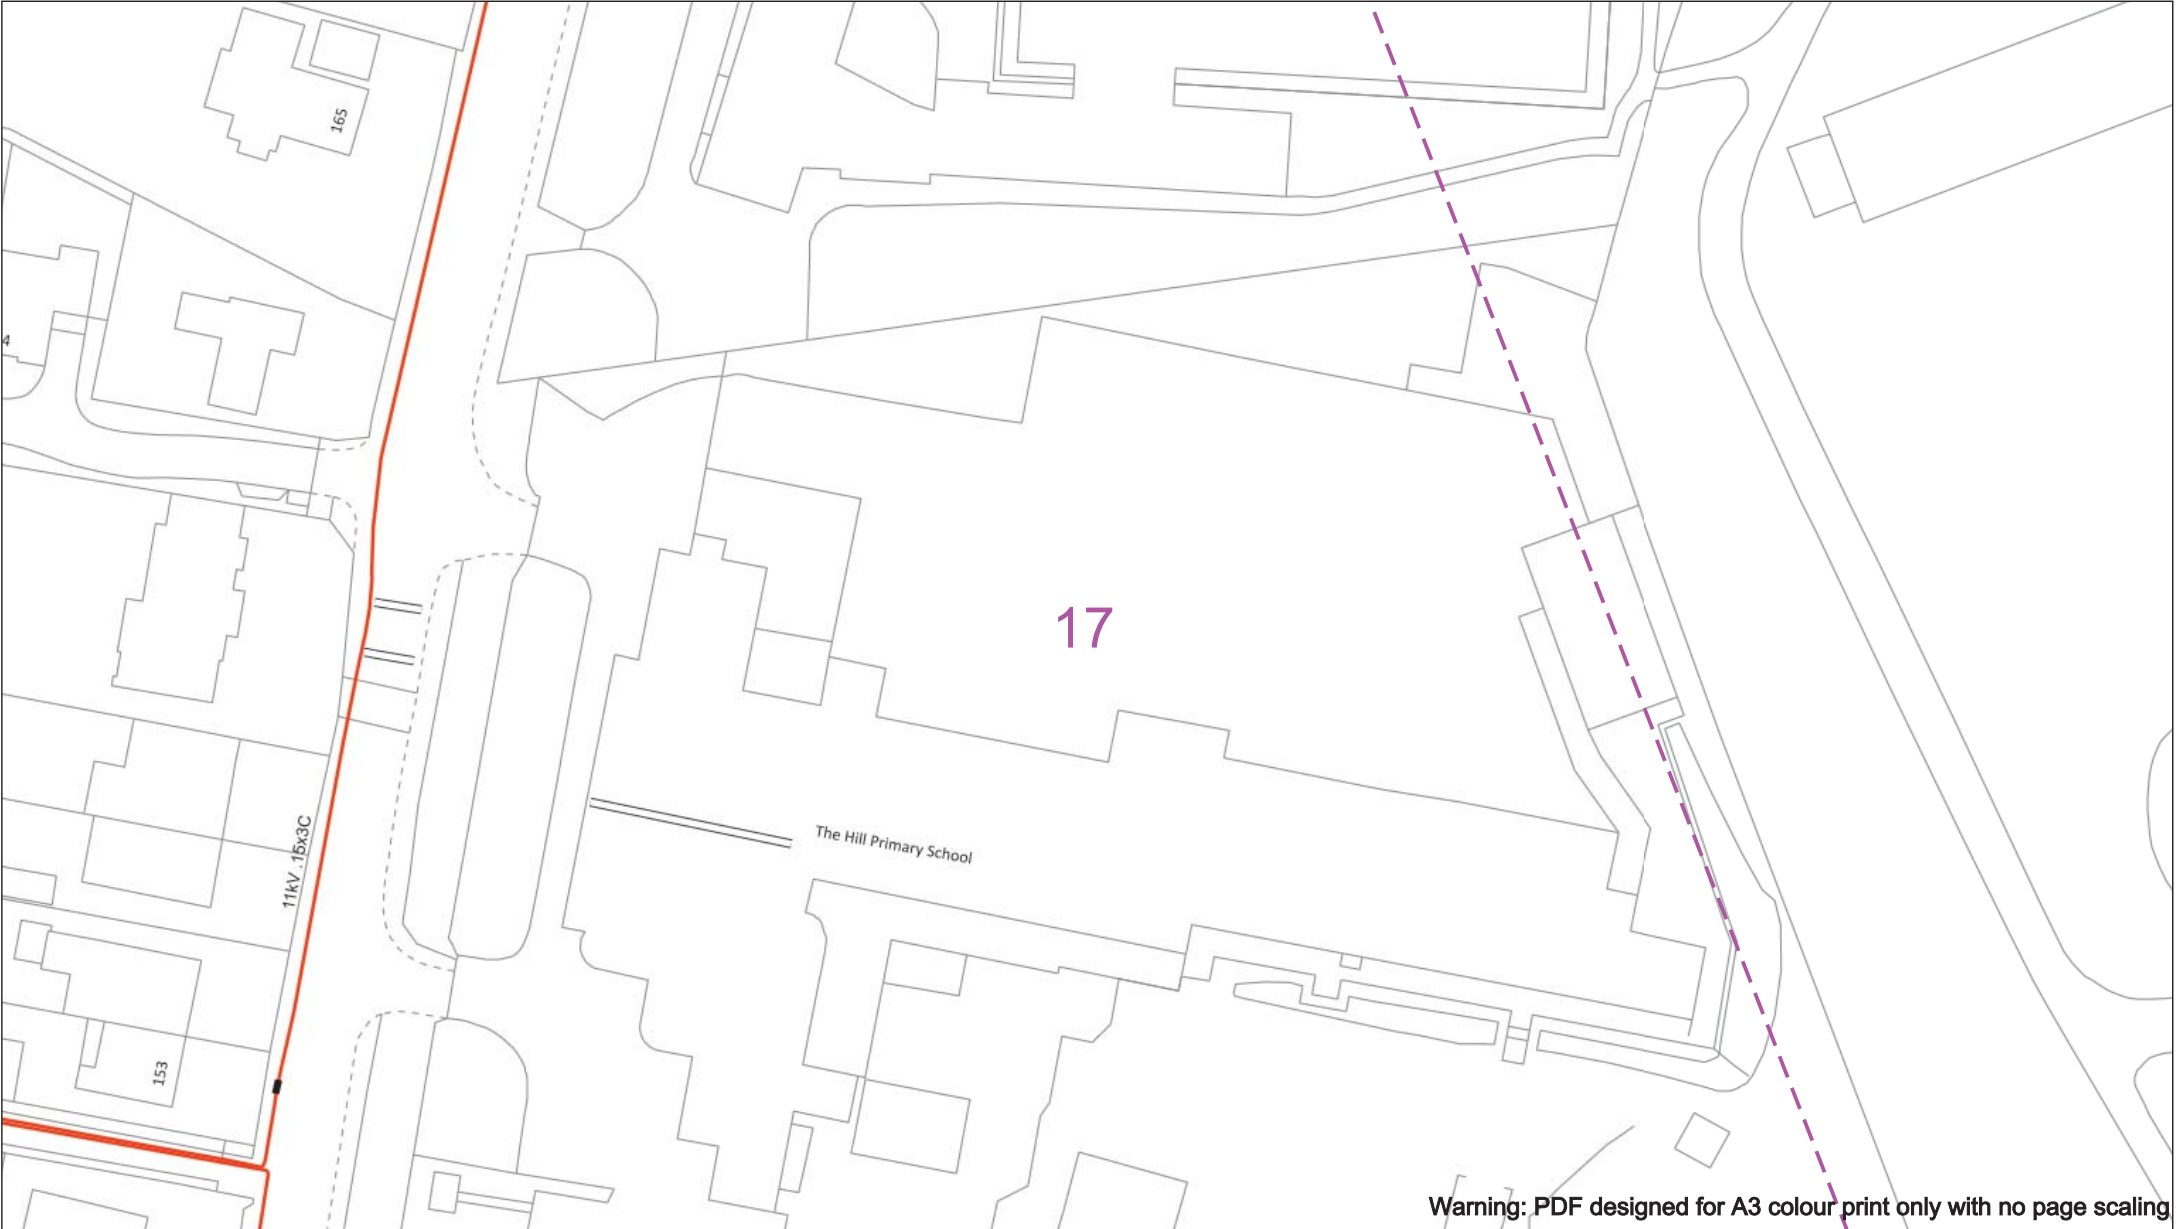

050m

Dig Sites

Area:

Line:

Date Requested: 09/11/2021

Job Reference: 23827726

Site Location: 472556 176139

Requested by: Ms Debbie Wigston

Your Scheme/Reference: 8210940

WARNING

There may have been subsequent alteration to the surface levels. Trial holes must be undertaken to determine position and depths of cables. HS (G) 47 Booklet from the Health and Safety Executive – Avoiding Danger from Buried Cables – should be consulted before commencing excavation work.

WHEN WORKING IN THE VICINITY OF OVERHEAD LINES THE HEALTH AND SAFETY GUIDANCE NOTES GS6 SHOULD BE CONSULTED (AVAILABLE FROM THE HSE WEBSITE)

Voltages (V)				
LV (Low Voltage) and Services	Up to 1,000V			
HV (High Voltage)	Over 1,000V to 11,000V			
EHV (Extra High Voltage)	22,000V to 132,000V			
Transmission	275,000V and 400,000V			

NORMAL DEPTH TO THE TOP OF THE CABLE WHEN LAID				
Services	LV	HV	EHV	
Footpath/Unmade	0.45m	0.45m	0.6m	0.8m
Road Crossing	0.6m	0.6m	0.75m	0.9m
Agricultural	1m	1m	1m	1.1m

Legend

Service Cable

LV Mains

2 – 3.3kV

6.6kV

11kV

22kV

33kV

66kV

132kV

275kV

400kV

Fibre Optic

Pilot Cable

Distribution Structures (Electric)

Pole, Existing Location

Pole Structure, Existing Location - Single

Pole Structure, Existing Location - H

Duct Route

Cross Section Route

Southern Electric Power Distribution plc

Registered Office: No.1 Forbury Place

43 Forbury Road Reading RG1 3JH

Registered in England & Wales No.04094290

If you're unsure & need to seek advice before commencing excavations please contact:

General Enquiries: 0800 048 3516


Subject to revision – Master held by SSEN Asset Data Team:

AssetData@ssen.com

01256 337 294

BASED UPON THE ORDNANCE SURVEY MAP WITH THE SANCTION OF THE CONTROLLER OF H.M. STATIONERY OFFICE CROWN COPYRIGHT RESERVED.

This copy has been made by or with the authority of Scottish and Southern Energy Power Distribution Ltd. Pursuant to section 47 of the Copyright, Designs and Patents Act 1988 ('The Act'). Unless the Act provides a relevant exception to copyright the copy must not be copied without prior permission of the copyright owner. Plans generated by DigSAFE Pro™ software provided by LinesearchbeforeUdig.

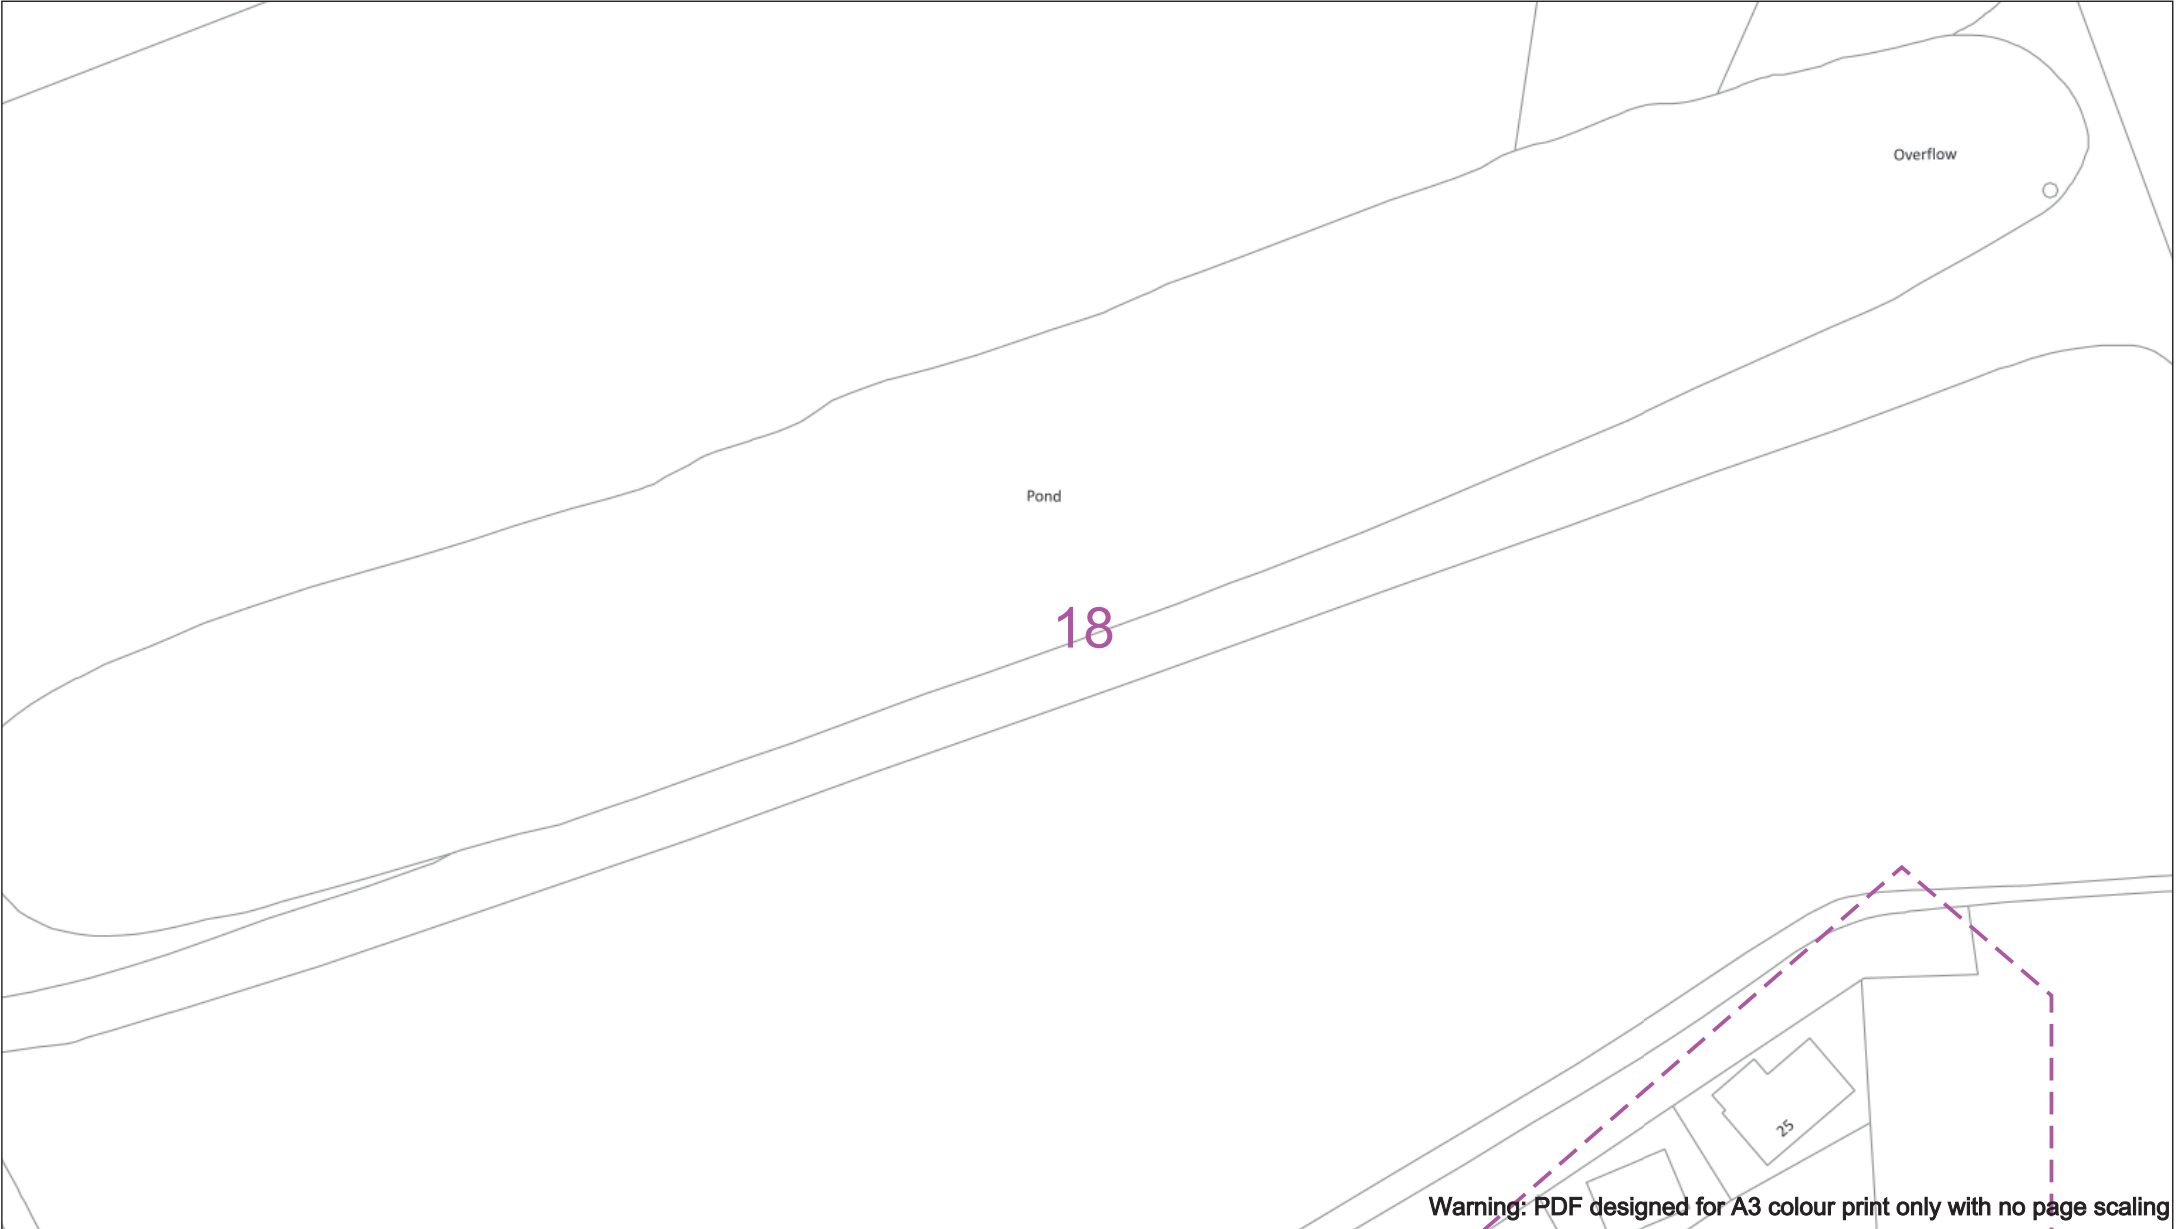

Warning: PDF designed for A3 colour print only with no page scaling

050m

Dig Sites

Area:

Line:

Date Requested: 09/11/2021

Job Reference: 23827726

Site Location: 472556 176139

Requested by: Ms Debbie Wigston

Your Scheme/Reference: 8210940

WARNING

There may have been subsequent alteration to the surface levels. Trial holes must be undertaken to determine position and depths of cables. HS (G) 47 Booklet from the Health and Safety Executive – Avoiding Danger from Buried Cables – should be consulted before commencing excavation work.

WHEN WORKING IN THE VICINITY OF OVERHEAD LINES THE HEALTH AND SAFETY GUIDANCE NOTES GS6 SHOULD BE CONSULTED (AVAILABLE FROM THE HSE WEBSITE)

Voltages (V)

LV (Low Voltage) and Services

Up to 1,000V

HV (High Voltage)

Over 1,000V to 11,000V

EHV (Extra High Voltage)

22,000V to 132,000V

Transmission

275,000V and 400,000V

NORMAL DEPTH TO THE TOP OF THE CABLE WHEN LAID

Services	LV	HV	EHV
Footpath/Unmade	0.45m	0.45m	0.6m
Road Crossing	0.6m	0.6m	0.75m
Agricultural	1m	1m	1.1m

Legend

Service Cable

LV Mains

2 – 3.3kV

6.6kV

11kV

22kV

33kV

66kV

132kV

275kV

400kV

Fibre Optic

Pilot Cable

Distribution Structures (Electric)

Pole, Existing Location

Pole Structure, Existing Location - Single

Pole Structure, Existing Location - H

Duct Route

Cross Section Route

Southern Electric Power Distribution plc

Registered Office: No.1 Forbury Place

43 Forbury Road Reading RG1 3JH

Registered in England & Wales No.04094290

If you're unsure & need to seek advice before commencing excavations please contact:

General Enquiries: 0800 048 3516


Subject to revision – Master held by SSEN Asset Data Team:

Asset.Data@ssen.com

01256 337 294

BASED UPON THE ORDNANCE SURVEY MAP WITH THE SANCTION OF THE CONTROLLER OF H.M STATIONERY OFFICE CROWN COPYRIGHT RESERVED.

This copy has been made by or with the authority of Scottish and Southern Energy Power Distribution Ltd. Pursuant to section 47 of the Copyright, Designs and Patents Act 1988 ('The Act'). Unless the Act provides a relevant exception to copyright the copy must not be copied without prior permission of the copyright owner. Plans generated by DigSAFE Pro™ software provided by LinesearchbeforeUdig.

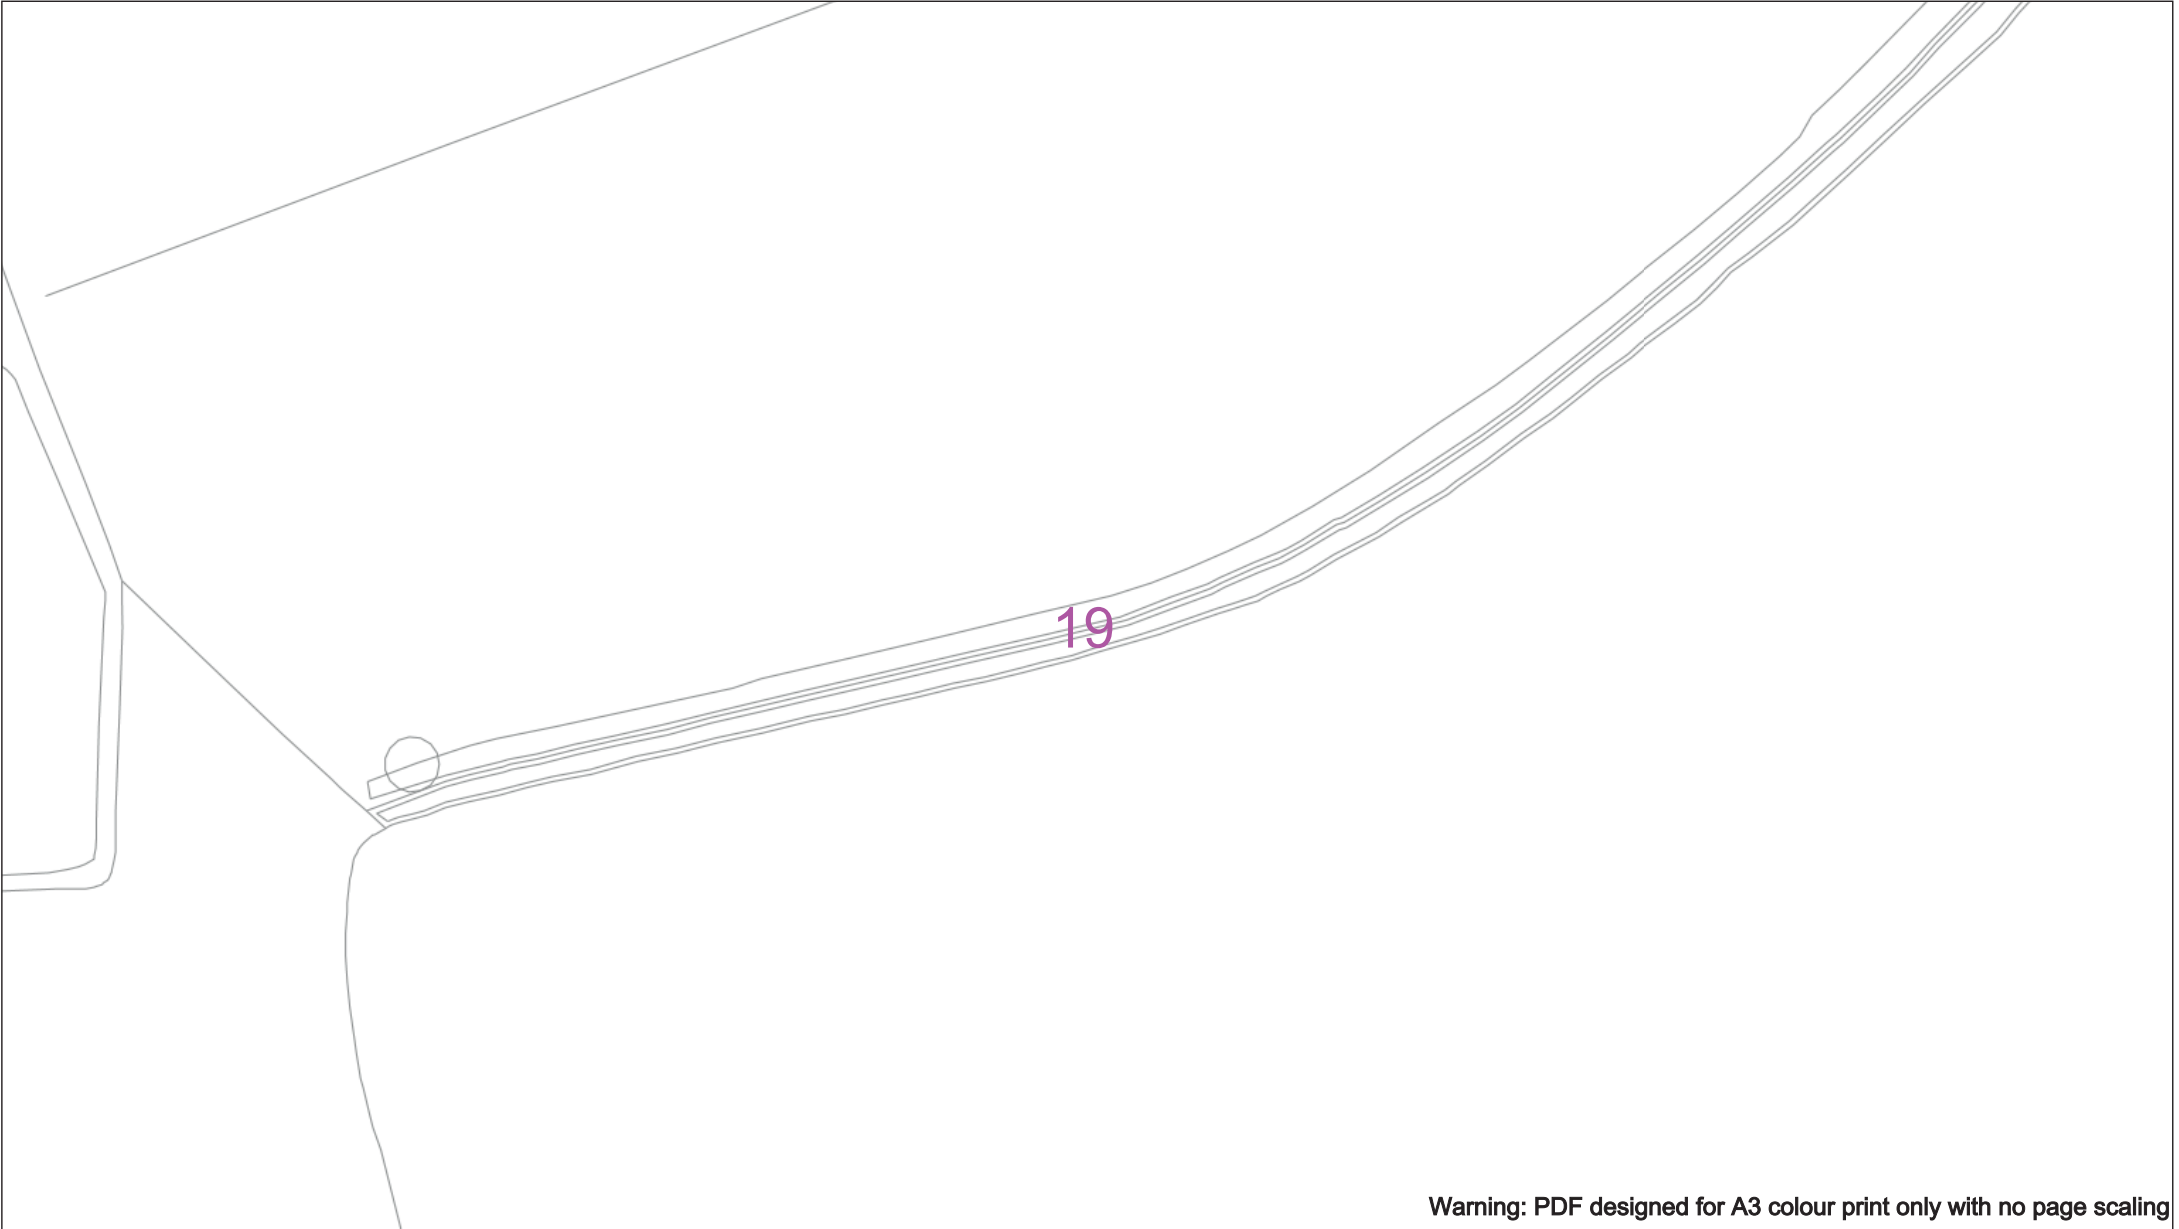

Warning: PDF designed for A3 colour print only with no page scaling

050m

Dig Sites

Area: 

Line: 

Date Requested: 09/11/2021

Job Reference: 23827726

Site Location: 472556 176139

Requested by: Ms Debbie Wigston

Your Scheme/Reference: 8210940

WARNING

There may have been subsequent alteration to the surface levels. Trial holes must be undertaken to determine position and depths of cables. HS (G) 47 Booklet from the Health and Safety Executive – Avoiding Danger from Buried Cables – should be consulted before commencing excavation work.

WHEN WORKING IN THE VICINITY OF OVERHEAD LINES THE HEALTH AND SAFETY GUIDANCE NOTES GS6 SHOULD BE CONSULTED (AVAILABLE FROM THE HSE WEBSITE)

Voltages (V)				
LV (Low Voltage) and Services	Up to 1,000V			
HV (High Voltage)	Over 1,000V to 11,000V			
EHV (Extra High Voltage)	22,000V to 132,000V			
Transmission	275,000V and 400,000V			

NORMAL DEPTH TO THE TOP OF THE CABLE WHEN LAID				
Services	LV	HV	EHV	
Footpath/Unmade	0.45m	0.45m	0.6m	0.8m
Road Crossing	0.6m	0.6m	0.75m	0.9m
Agricultural	1m	1m	1m	1.1m

Legend

 Service Cable

 LV Mains

 2 – 3.3kV

 6.6kV

 11kV

 22kV

 33kV

 66kV

 132kV

 275kV

 400kV

 Fibre Optic

 Pilot Cable

Distribution Structures (Electric)

 Pole, Existing Location

 Pole Structure, Existing Location - Single

 Pole Structure, Existing Location - H

 Duct Route

 Cross Section Route



Southern Electric Power Distribution plc

Registered Office: No.1 Forbury Place

43 Forbury Road Reading RG1 3JH

Registered in England & Wales No.04094290

If you're unsure & need to seek advice before commencing excavations please contact:

General Enquiries: 0800 048 3516


Subject to revision – Master held by SSEN Asset Data Team:

Asset.Data@ssen.com

01256 337 294

BASED UPON THE ORDNANCE SURVEY MAP WITH THE SANCTION OF THE CONTROLLER OF H.M STATIONERY OFFICE CROWN COPYRIGHT RESERVED.

This copy has been made by or with the authority of Scottish and Southern Energy Power Distribution Ltd. Pursuant to section 47 of the Copyright, Designs and Patents Act 1988 ('The Act'). Unless the Act provides a relevant exception to copyright the copy must not be copied without prior permission of the copyright owner. Plans generated by DigSAFE Pro™ software provided by LinesearchbeforeUdig.

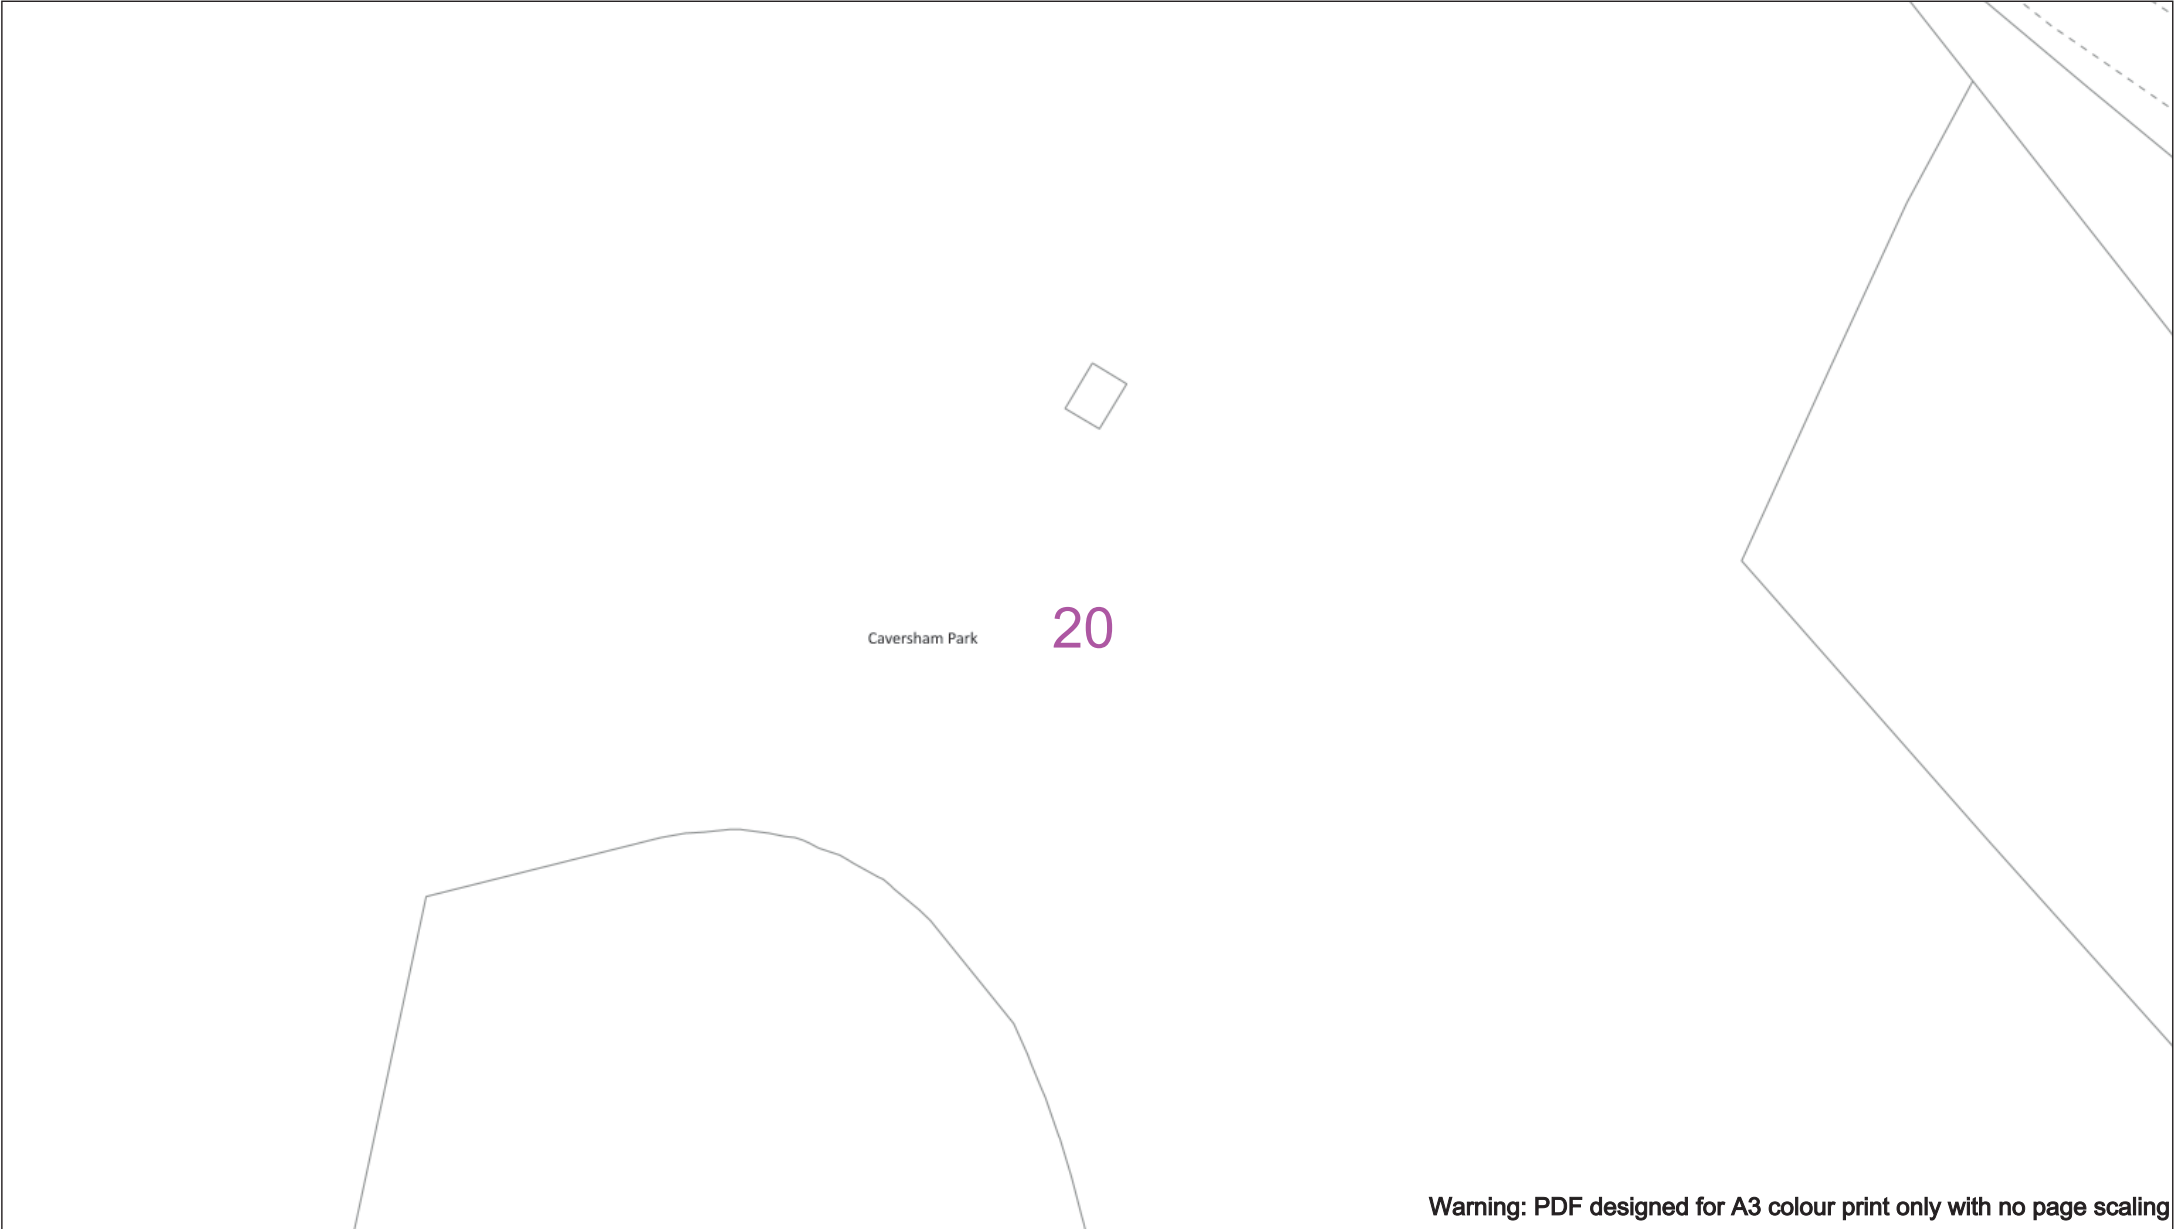

Warning: PDF designed for A3 colour print only with no page scaling

050m

Dig Sites

Area:

Line:

Date Requested: 09/11/2021

Job Reference: 23827726

Site Location: 472556 176139

Requested by: Ms Debbie Wigston

Your Scheme/Reference: 8210940

WARNING

There may have been subsequent alteration to the surface levels. Trial holes must be undertaken to determine position and depths of cables. HS (G) 47 Booklet from the Health and Safety Executive – Avoiding Danger from Buried Cables – should be consulted before commencing excavation work.

WHEN WORKING IN THE VICINITY OF OVERHEAD LINES THE HEALTH AND SAFETY GUIDANCE NOTES GS6 SHOULD BE CONSULTED (AVAILABLE FROM THE HSE WEBSITE)

Voltages (V)

LV (Low Voltage) and Services

Up to 1,000V

HV (High Voltage)

Over 1,000V to 11,000V

EHV (Extra High Voltage)

22,000V to 132,000V

Transmission

275,000V and 400,000V

NORMAL DEPTH TO THE TOP OF THE CABLE WHEN LAID

Services	LV	HV	EHV
Footpath/Unmade	0.45m	0.45m	0.6m
Road Crossing	0.6m	0.6m	0.75m
Agricultural	1m	1m	1.1m

Service Cable

LV Mains

2 – 3.3kV

6.6kV

11kV

22kV

33kV

66kV

132kV

275kV

400kV

Fibre Optic

Pile Cable

Distribution Structures (Electric)

Pole, Existing Location

Pole Structure, Existing Location - Single

Pole Structure, Existing Location - H

Duct Route

Cross Section Route


Southern Electric Power Distribution plc
Registered Office: No.1 Forbury Place
43 Forbury Road Reading RG1 3JH
Registered in England & Wales No.04094290

If you're unsure & need to seek advice before commencing excavations please contact:
General Enquiries: 0800 048 3516

Subject to revision – Master held by SSEN Asset Data Team:
Asset.Data@ssen.com
01256 337 294

BASED UPON THE ORDNANCE SURVEY MAP WITH THE SANCTION OF THE CONTROLLER OF H.M STATIONERY OFFICE CROWN COPYRIGHT RESERVED.

This copy has been made by or with the authority of Scottish and Southern Energy Power Distribution Ltd. Pursuant to section 47 of the Copyright, Designs and Patents Act 1988 ('The Act'). Unless the Act provides a relevant exception to copyright the copy must not be copied without prior permission of the copyright owner. Plans generated by DigSAFE Pro™ software provided by LinesearchbeforeUdig.

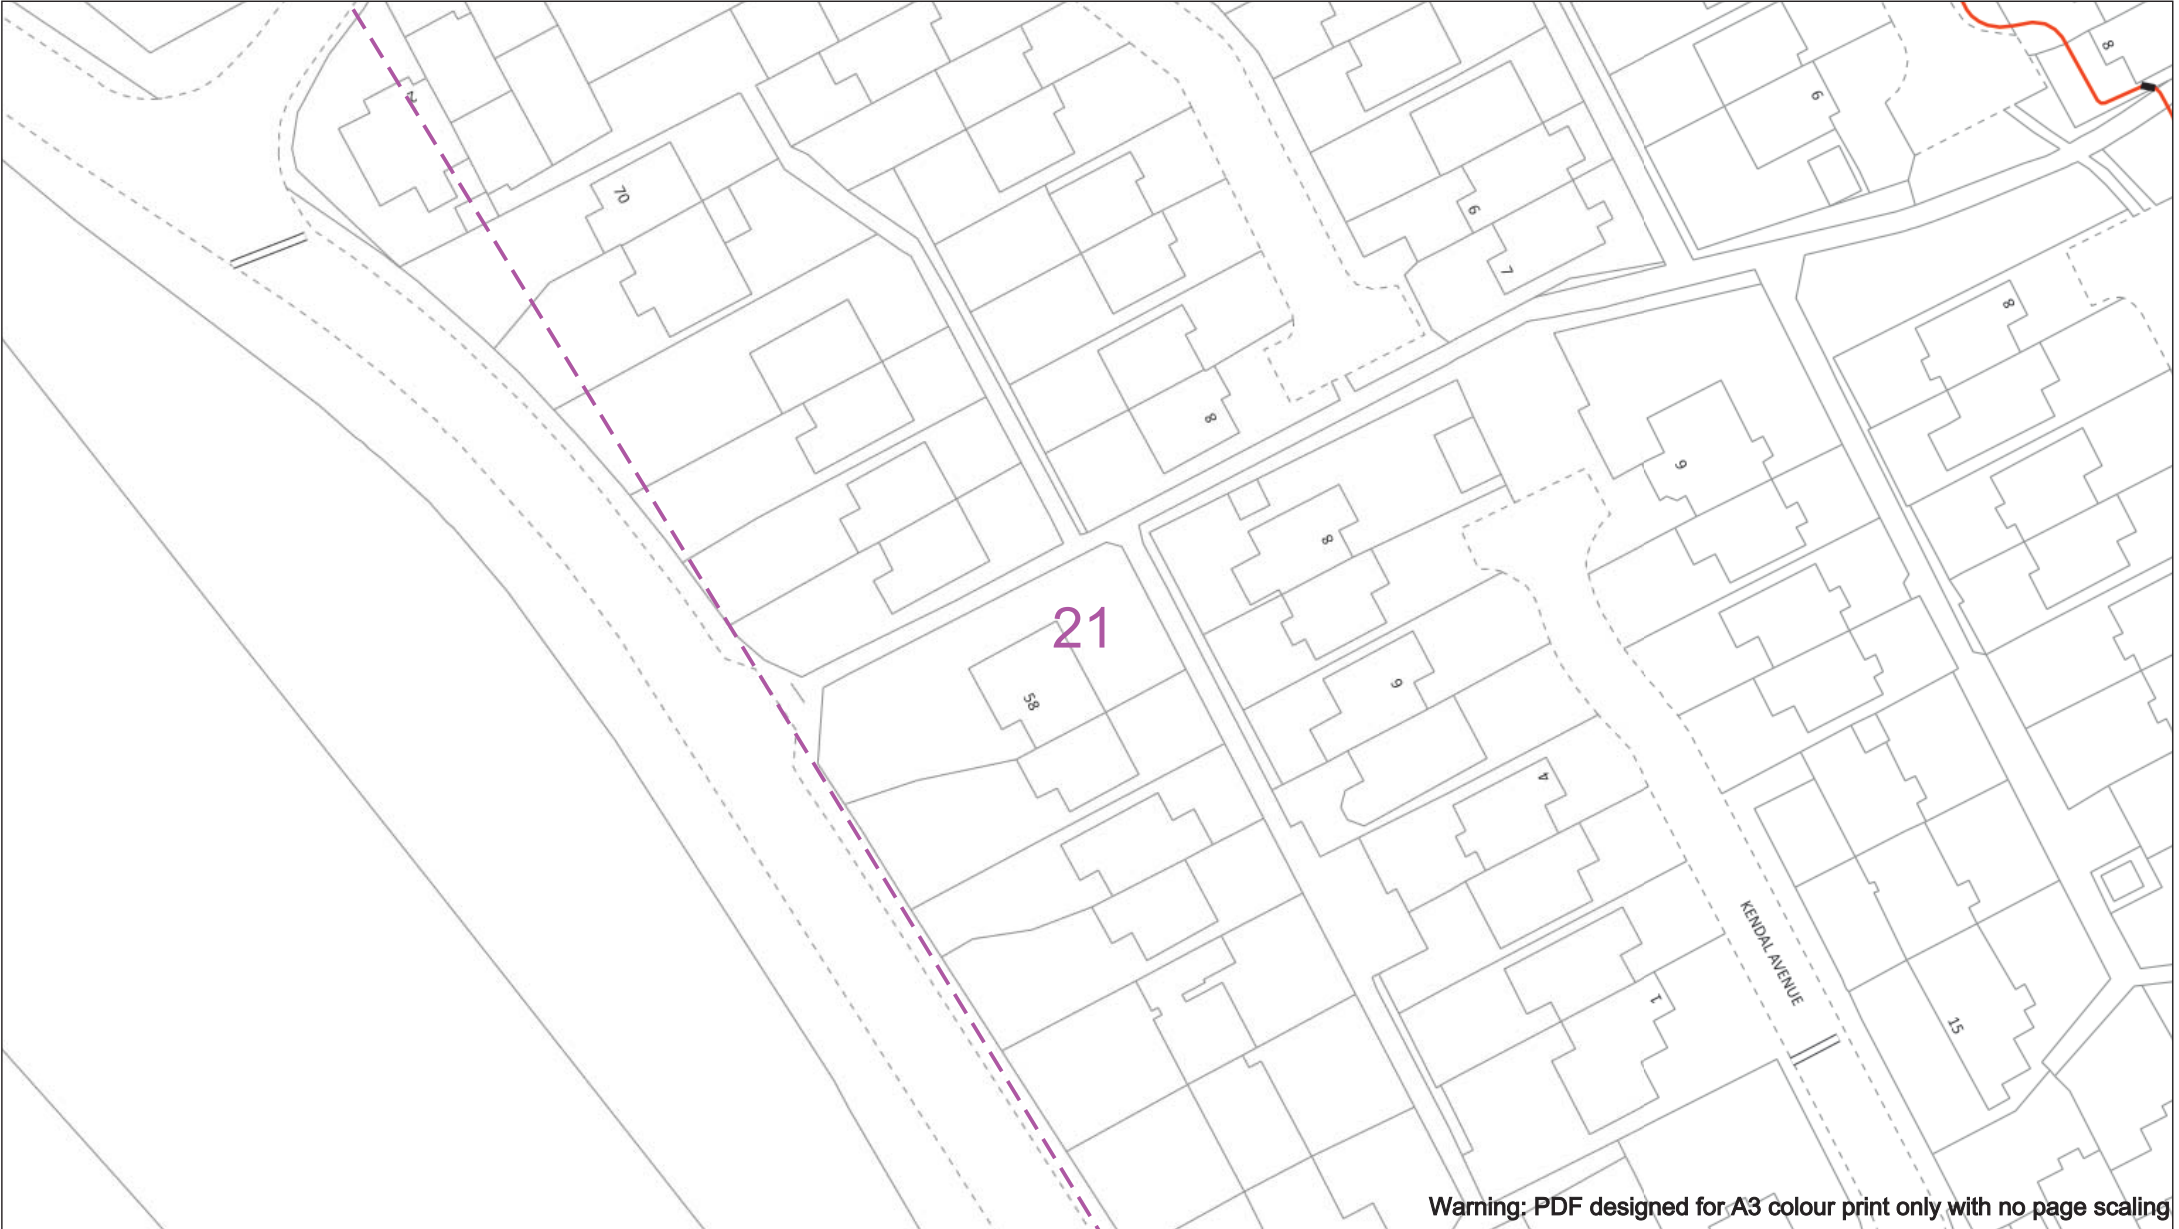

Warning: PDF designed for A3 colour print only with no page scaling

050m

Dig Sites

Area:

Line:

Date Requested: 09/11/2021

Job Reference: 23827726

Site Location: 472556 176139

Requested by: Ms Debbie Wigston

Your Scheme/Reference: 8210940

WARNING

There may have been subsequent alteration to the surface levels. Trial holes must be undertaken to determine position and depths of cables. HS (G) 47 Booklet from the Health and Safety Executive – Avoiding Danger from Buried Cables – should be consulted before commencing excavation work.

WHEN WORKING IN THE VICINITY OF OVERHEAD LINES THE HEALTH AND SAFETY GUIDANCE NOTES GS6 SHOULD BE CONSULTED (AVAILABLE FROM THE HSE WEBSITE)

Voltages (V)

LV (Low Voltage) and Services

Up to 1,000V

HV (High Voltage)

Over 1,000V to 11,000V

EHV (Extra High Voltage)

22,000V to 132,000V

Transmission

275,000V and 400,000V

NORMAL DEPTH TO THE TOP OF THE CABLE WHEN LAID

	LV	HV	EHV
Footpath/Unmade	0.45m	0.45m	0.6m
Road Crossing	0.6m	0.6m	0.75m
Agricultural	1m	1m	1.1m

Legend

Service Cable

LV Mains

2 – 3.3kV

6.6kV

11kV

22kV

33kV

66kV

132kV

275kV

400kV

Fibre Optic

Pilot Cable

Distribution Structures (Electric)

Pole, Existing Location

Pole Structure, Existing Location - Single

Pole Structure, Existing Location - H

Duct Route

Cross Section Route

Southern Electric Power Distribution plc

Registered Office: No.1 Forbury Place

43 Forbury Road Reading RG1 3JH

Registered in England & Wales No.04094290

If you're unsure & need to seek advice before commencing excavations please contact:

General Enquiries: 0800 048 3516


Subject to revision – Master held by SSEN Asset Data Team:

Asset.Data@scn.com

01256 337 294

BASED UPON THE ORDNANCE SURVEY MAP WITH THE SANCTION OF THE CONTROLLER OF H.M STATIONERY OFFICE CROWN COPYRIGHT RESERVED.

This copy has been made by or with the authority of Scottish and Southern Energy Power Distribution Ltd. Pursuant to section 47 of the Copyright, Designs and Patents Act 1988 ('The Act'). Unless the Act provides a relevant exception to copyright the copy must not be copied without prior permission of the copyright owner. Plans generated by DigSAFE Pro™ software provided by LinesearchbeforeUdig.

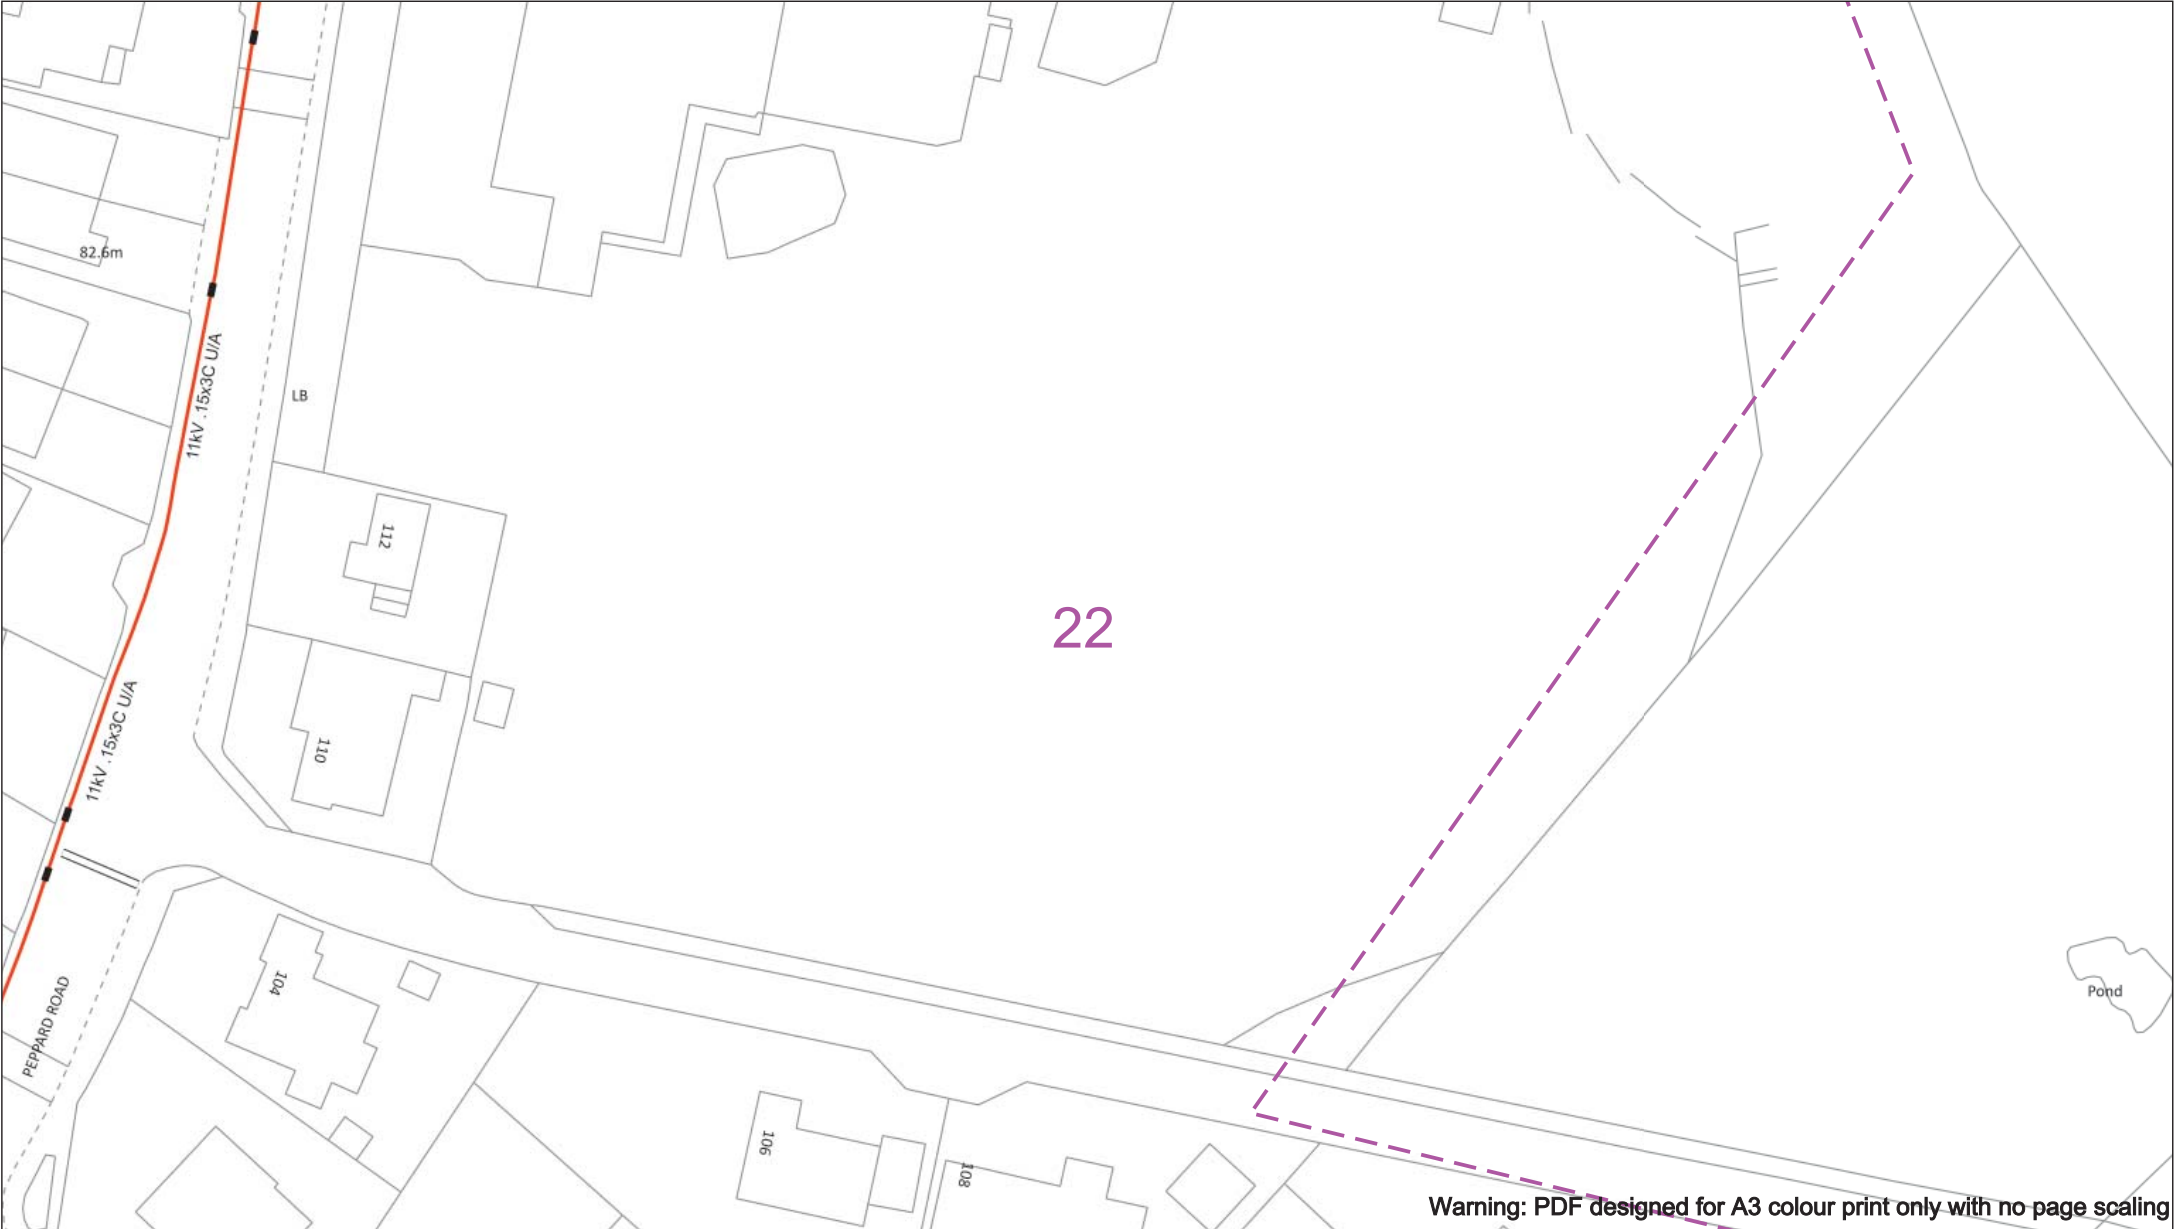

Warning: PDF designed for A3 colour print only with no page scaling

050m

Dig Sites

Area:

Line:

Date Requested: 09/11/2021

Job Reference: 23827726

Site Location: 472556 176139

Requested by: Ms Debbie Wigston

Your Scheme/Reference: 8210940

WARNING

There may have been subsequent alteration to the surface levels. Trial holes must be undertaken to determine position and depths of cables. HS (G) 47 Booklet from the Health and Safety Executive – Avoiding Danger from Buried Cables – should be consulted before commencing excavation work.

WHEN WORKING IN THE VICINITY OF OVERHEAD LINES THE HEALTH AND SAFETY GUIDANCE NOTES GS6 SHOULD BE CONSULTED (AVAILABLE FROM THE HSE WEBSITE)

Voltages (V)				
LV (Low Voltage) and Services	Up to 1,000V			
HV (High Voltage)	Over 1,000V to 11,000V			
EHV (Extra High Voltage)	22,000V to 132,000V			
Transmission	275,000V and 400,000V			

NORMAL DEPTH TO THE TOP OF THE CABLE WHEN LAID				
Services	LV	HV	EHV	
Footpath/Unmade	0.45m	0.45m	0.6m	0.8m
Road Crossing	0.6m	0.6m	0.75m	0.9m
Agricultural	1m	1m	1m	1.1m

Legend

Service Cable

LV Mains

2 – 3.3kV

6.6kV

11kV

22kV

33kV

66kV

132kV

275kV

400kV

Flow Optic

Pole Cable

Distribution Structures (Electric)

Pole, Existing Location

Pole Structure, Existing Location - Single

Pole Structure, Existing Location - H

Duct Route

Cross Section Route


Southern Electric Power Distribution plc
Registered Office: No.1 Forbury Place
43 Forbury Road Reading RG1 3JH
Registered in England & Wales No.04094290

If you're unsure & need to seek advice before commencing excavations please contact:
General Enquiries: 0800 048 3516

Subject to revision – Master held by SSEN Asset Data Team:
Asset.Data@ssen.com
01256 337 294

BASED UPON THE ORDNANCE SURVEY MAP WITH THE SANCTION OF THE CONTROLLER OF H.M. STATIONERY OFFICE CROWN COPYRIGHT RESERVED.

This copy has been made by or with the authority of Scottish and Southern Energy Power Distribution Ltd. Pursuant to section 47 of the Copyright, Designs and Patents Act 1988 ('The Act'). Unless the Act provides a relevant exception to copyright the copy must not be copied without prior permission of the copyright owner. Plans generated by DigSAFE Pro™ software provided by LinesearchbeforeUdig.

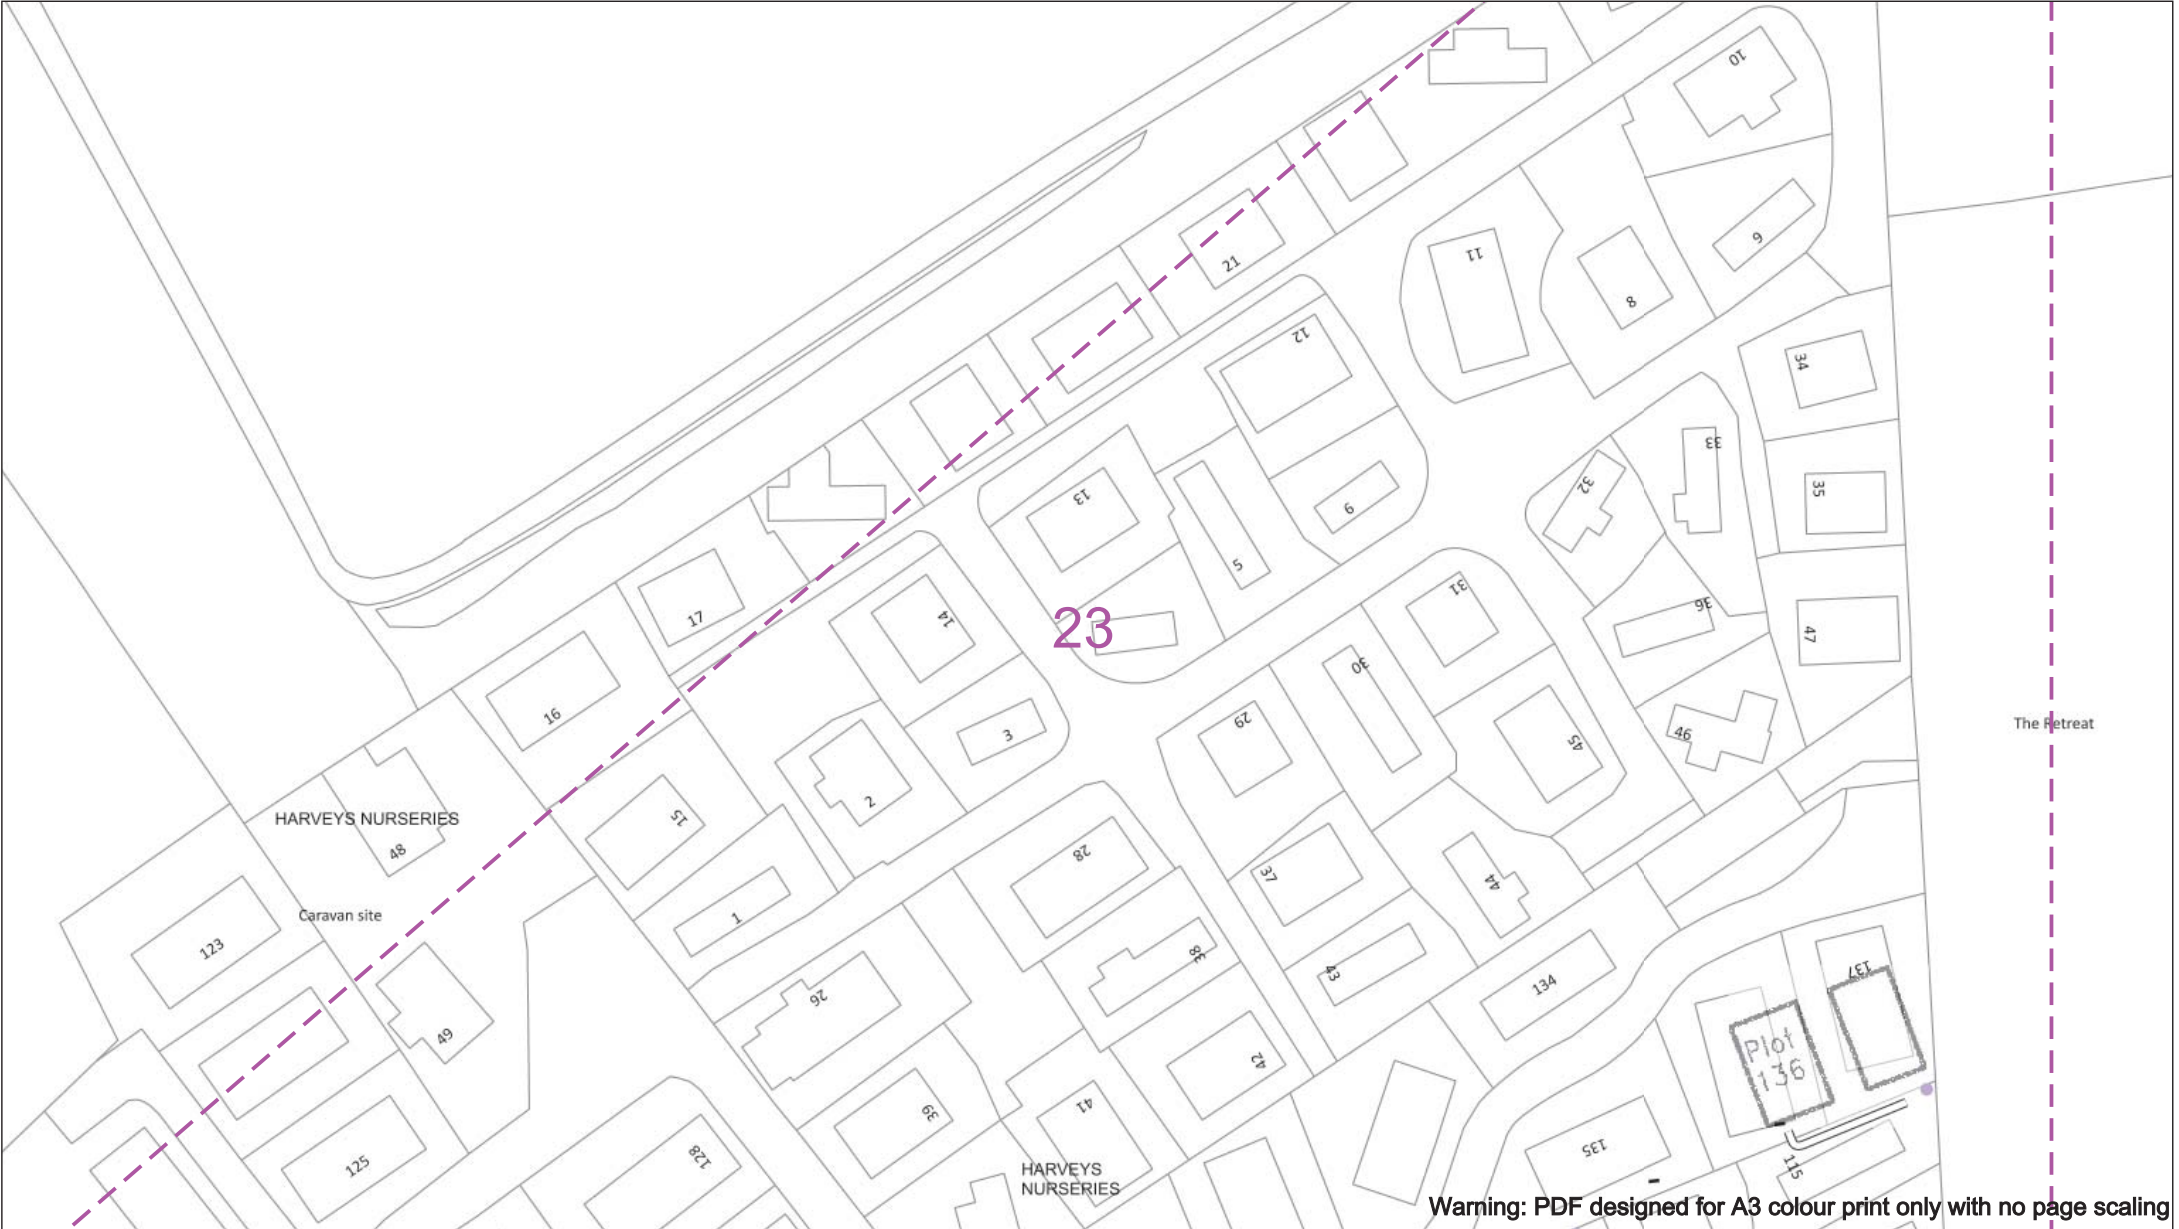

Warning: PDF designed for A3 colour print only with no page scaling

050m

Dig Sites

Area:

Line:

Date Requested: 09/11/2021

Job Reference: 23827726

Site Location: 472556 176139

Requested by: Ms Debbie Wigston

Your Scheme/Reference: 8210940

WARNING

There may have been subsequent alteration to the surface levels. Trial holes must be undertaken to determine position and depths of cables. HS (G) 47 Booklet from the Health and Safety Executive – Avoiding Danger from Buried Cables – should be consulted before commencing excavation work.

WHEN WORKING IN THE VICINITY OF OVERHEAD LINES THE HEALTH AND SAFETY GUIDANCE NOTES GS6 SHOULD BE CONSULTED (AVAILABLE FROM THE HSE WEBSITE)

Voltages (V)

LV (Low Voltage) and Services

Up to 1,000V

HV (High Voltage)

Over 1,000V to 11,000V

EHV (Extra High Voltage)

22,000V to 132,000V

Transmission

275,000V and 400,000V

NORMAL DEPTH TO THE TOP OF THE CABLE WHEN LAID

Services	LV	HV	EHV
Footpath/Unmade	0.45m	0.45m	0.6m
Road Crossing	0.6m	0.6m	0.75m
Agricultural	1m	1m	1.1m

Legend

Service Cable

LV Mains

2 – 3.3kV

6.6kV

11kV

22kV

33kV

66kV

132kV

275kV

400kV

Fibre Optic

Pilot Cable

Distribution Structures (Electric)

Pole, Existing Location

Pole Structure, Existing Location - Single

Pole Structure, Existing Location - H

Duct Route

Cross Section Route

Southern Electric Power Distribution plc

Registered Office: No.1 Forbury Place

43 Forbury Road Reading RG1 3JH

Registered in England & Wales No.04094290

If you're unsure & need to seek advice before commencing excavations please contact:

General Enquiries: 0800 048 3516


Subject to revision – Master held by SSEN Asset Data Team:

Asset.Data@ssen.com

01256 337 294

BASED UPON THE ORDNANCE SURVEY MAP WITH THE SANCTION OF THE CONTROLLER OF H.M STATIONERY OFFICE CROWN COPYRIGHT RESERVED.

This copy has been made by or with the authority of Scottish and Southern Energy Power Distribution Ltd. Pursuant to section 47 of the Copyright, Designs and Patents Act 1988 ('The Act'). Unless the Act provides a relevant exception to copyright the copy must not be copied without prior permission of the copyright owner. Plans generated by DigSAFE Pro™ software provided by LinesearchbeforeUdig.

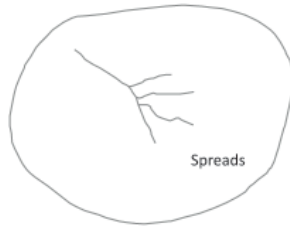

24

Warning: PDF designed for A3 colour print only with no page scaling

0

50m

Dig Sites

Area:

Line:

Date Requested: 09/11/2021

Job Reference: 23827726

Site Location: 472556 176139

Requested by:
Ms Debbie Wigston

Your Scheme/Reference: 8210940

WARNING

There may have been subsequent alteration to the surface levels. Trial holes must be undertaken to determine position and depths of cables. HS (G) 47 Booklet from the Health and Safety Executive – Avoiding Danger from Buried Cables – should be consulted before commencing excavation work.

WHEN WORKING IN THE VICINITY OF OVERHEAD LINES THE HEALTH AND SAFETY GUIDANCE NOTES GS6 SHOULD BE CONSULTED (AVAILABLE FROM THE HSE WEBSITE)

Voltages (V)				
LV (Low Voltage) and Services	Up to 1,000V			
HV (High Voltage)	Over 1,000V to 11,000V			
EHV (Extra High Voltage)	22,000V to 132,000V			
Transmission	275,000V and 400,000V			

NORMAL DEPTH TO THE TOP OF THE CABLE WHEN LAID				
Services	LV	HV	EHV	
Footpath/Unmade	0.45m	0.45m	0.6m	0.8m
Road Crossing	0.6m	0.6m	0.75m	0.9m
Agricultural	1m	1m	1m	1.1m

Legend

Service Cable

LV Mains

2 – 3.3kV

6.6kV

11kV

22kV

33kV

66kV

132kV

275kV

400kV

Fibre Optic

Pilot Cable

Distribution Structures (Electric)

Pole, Existing Location

Pole Structure, Existing Location - Single

Pole Structure, Existing Location - H

Duct Route

Cross Section Route

Scottish & Southern
Electricity Networks

Southern Electric Power Distribution plc

Registered Office: No.1 Forbury Place
43 Forbury Road Reading RG1 3JH
Registered in England & Wales No.04094290

If you're unsure & need to seek advice before commencing excavations please contact:
General Enquiries: 0800 048 3516

Subject to revision – Master held by SSEN Asset Data Team:
Asset.Data@sen.com
01256 337 294

BASED UPON THE ORDNANCE SURVEY MAP WITH THE SANCTION OF THE CONTROLLER OF H.M STATIONERY OFFICE CROWN COPYRIGHT RESERVED.

This copy has been made by or with the authority of Scottish and Southern Energy Power Distribution Ltd. Pursuant to section 47 of the Copyright, Designs and Patents Act 1988 ('The Act'). Unless the Act provides a relevant exception to copyright the copy must not be copied without prior permission of the copyright owner. Plans generated by DigSAFE Pro™ software provided by LinesearchbeforeUdig.

25

Warning: PDF designed for A3 colour print only with no page scaling

0

50m

Dig Sites

Area: 

Line: 

Date Requested: 09/11/2021

Job Reference: 23827726

Site Location: 472556 176139

Requested by:
Ms Debbie Wigston

Your Scheme/Reference: 8210940

WARNING

There may have been subsequent alteration to the surface levels. Trial holes must be undertaken to determine position and depths of cables. HS (G) 47 Booklet from the Health and Safety Executive – Avoiding Danger from Buried Cables – should be consulted before commencing excavation work.

WHEN WORKING IN THE VICINITY OF OVERHEAD LINES THE HEALTH AND SAFETY GUIDANCE NOTES GS6 SHOULD BE CONSULTED (AVAILABLE FROM THE HSE WEBSITE)

Voltages (V)

LV (Low Voltage) and Services

Up to 1,000V

HV (High Voltage)

Over 1,000V to 11,000V

EHV (Extra High Voltage)

22,000V to 132,000V

Transmission

275,000V and 400,000V

NORMAL DEPTH TO THE TOP OF THE CABLE WHEN LAID

Services	LV	HV	EHV
Footpath/Unmade	0.45m	0.45m	0.6m
Road Crossing	0.6m	0.6m	0.75m
Agricultural	1m	1m	1.1m

Legend

 Service Cable

 LV Mains

 2 – 3.3kV

 6.6kV

 11kV

 22kV

 33kV

 66kV

 132kV

 275kV

 400kV

 Fibre Optic

 Pilot Cable

Distribution Structures (Electric)

 Pole, Existing Location

 Pole Structure, Existing Location - Single

 Pole Structure, Existing Location - H

 Duct Route

 Cross Section Route



Southern Electric Power Distribution plc

Registered Office: No.1 Forbury Place

43 Forbury Road Reading RG1 3JH

Registered in England & Wales No.04094290

If you're unsure & need to seek advice before commencing excavations please contact:

General Enquiries: 0800 048 3516


Subject to revision – Master held by SSEN Asset Data Team:

Asset.Data@ssen.com

01256 337 294

BASED UPON THE ORDNANCE SURVEY MAP WITH THE SANCTION OF THE CONTROLLER OF H.M STATIONERY OFFICE CROWN COPYRIGHT RESERVED.

This copy has been made by or with the authority of Scottish and Southern Energy Power Distribution Ltd. Pursuant to section 47 of the Copyright, Designs and Patents Act 1988 ('The Act'). Unless the Act provides a relevant exception to copyright the copy must not be copied without prior permission of the copyright owner. Plans generated by DigSAFE Pro™ software provided by LinesearchbeforeUdig.

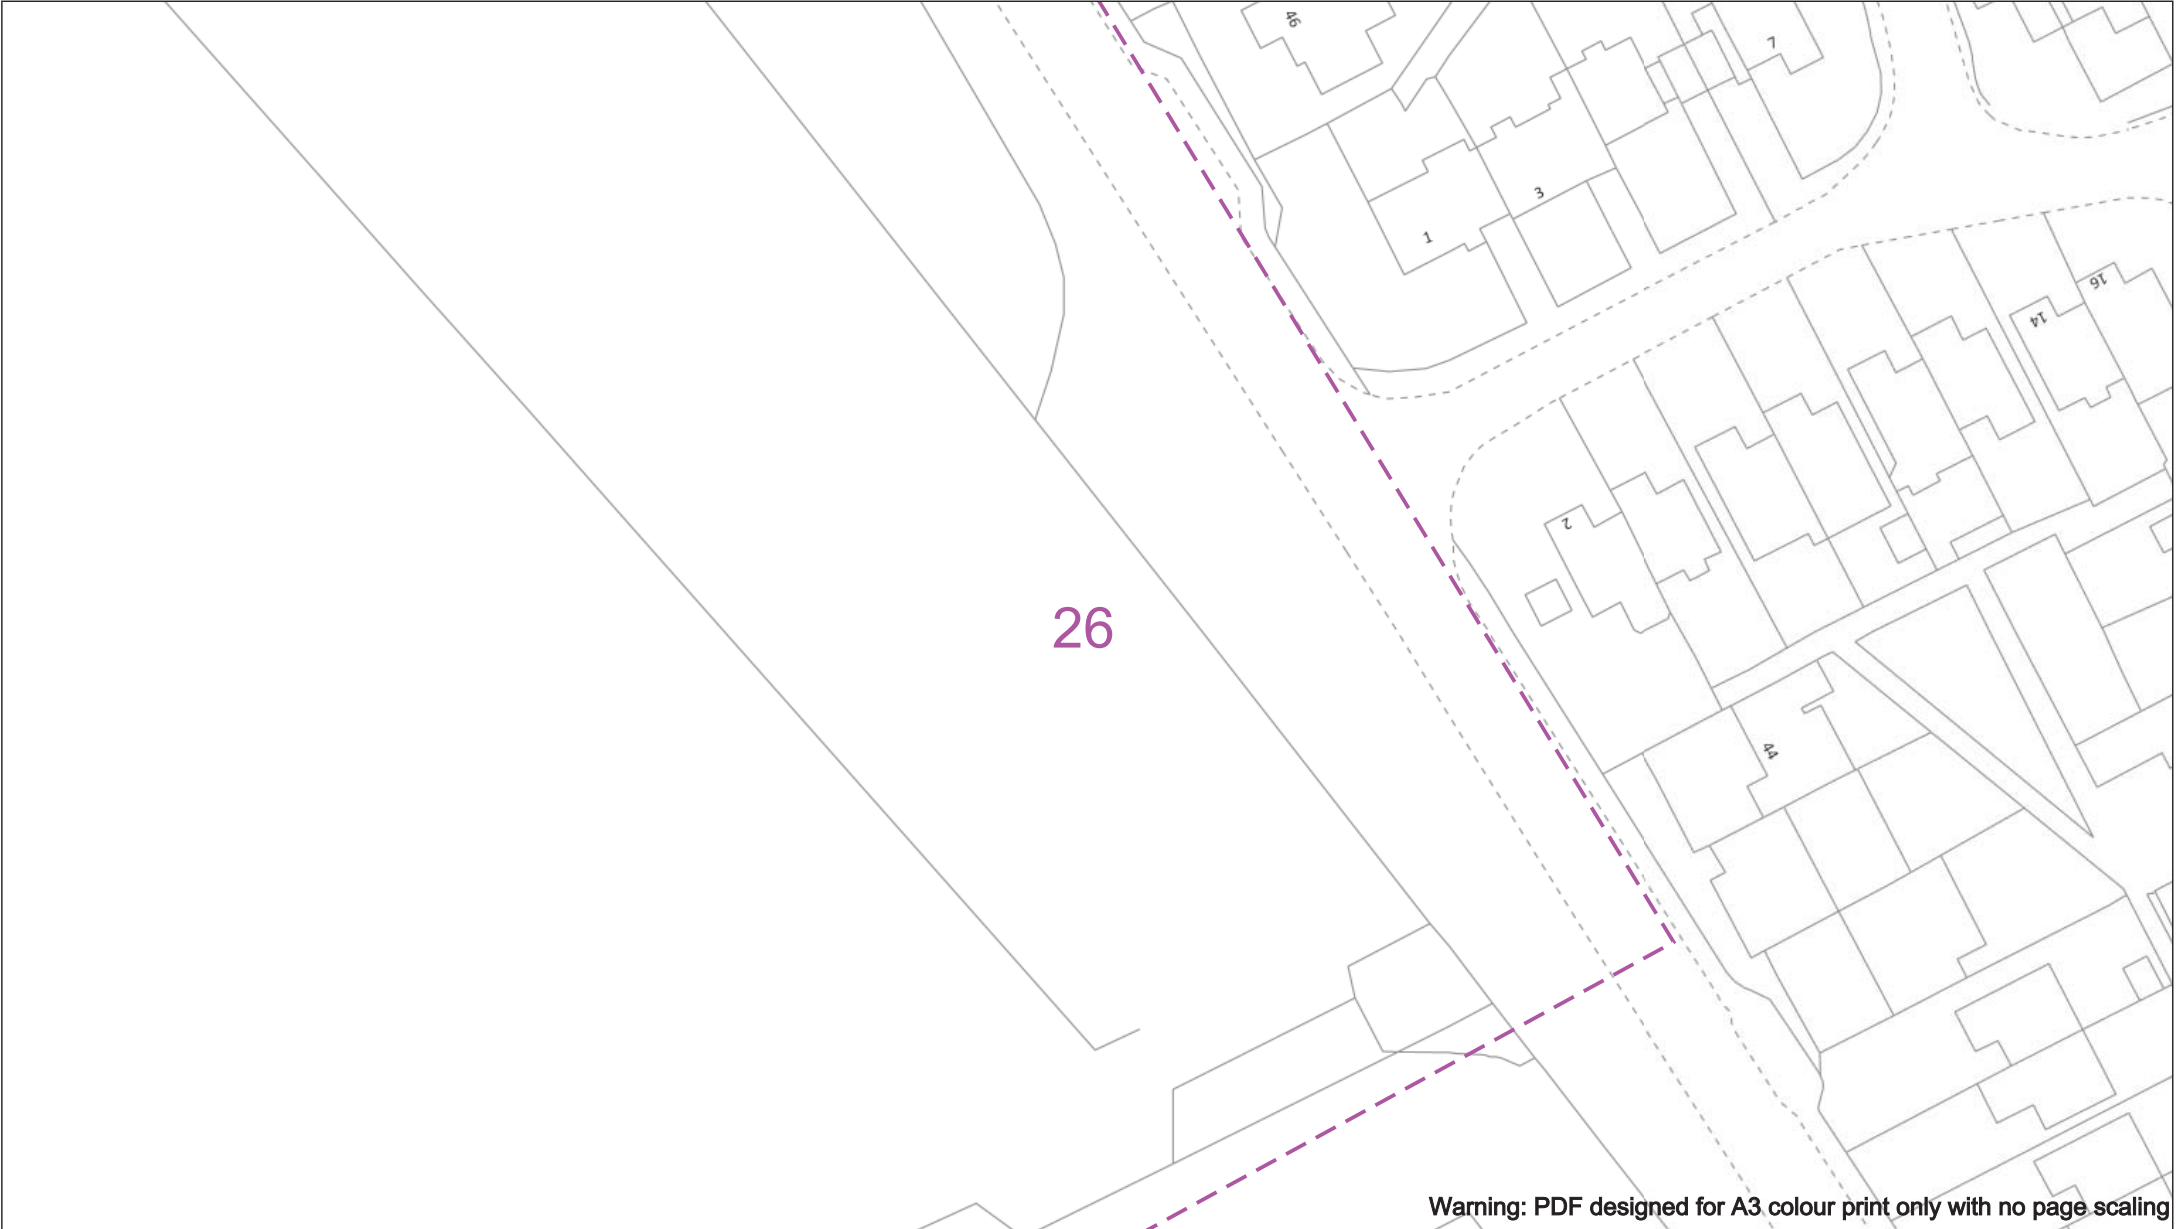

Warning: PDF designed for A3 colour print only with no page scaling

050m

Dig Sites

Area:

Line:

Date Requested: 09/11/2021

Job Reference: 23827726

Site Location: 472556 176139

Requested by: Ms Debbie Wigston

Your Scheme/Reference: 8210940

WARNING

There may have been subsequent alteration to the surface levels. Trial holes must be undertaken to determine position and depths of cables. HS (G) 47 Booklet from the Health and Safety Executive – Avoiding Danger from Buried Cables – should be consulted before commencing excavation work.

WHEN WORKING IN THE VICINITY OF OVERHEAD LINES THE HEALTH AND SAFETY GUIDANCE NOTES GS6 SHOULD BE CONSULTED (AVAILABLE FROM THE HSE WEBSITE)

Voltages (V)				
LV (Low Voltage) and Services	Up to 1,000V			
HV (High Voltage)	Over 1,000V to 11,000V			
EHV (Extra High Voltage)	22,000V to 132,000V			
Transmission	275,000V and 400,000V			

NORMAL DEPTH TO THE TOP OF THE CABLE WHEN LAID				
Services	LV	HV	EHV	
Footpath/Unmade	0.45m	0.45m	0.6m	0.8m
Road Crossing	0.6m	0.6m	0.75m	0.9m
Agricultural	1m	1m	1m	1.1m

Service Cable

LV Mains

2 – 3.3kV

6.6kV

11kV

22kV

33kV

66kV

132kV

275kV

400kV

Power Cable

Pipe Cable

Distribution Structures (Electric)

Pole, Existing Location

Pole Structure, Existing Location - Single

Pole Structure, Existing Location - H

Duct Route

Cross Section Route

Southern Electric Power Distribution plc

Registered Office: No.1 Forbury Place

43 Forbury Road Reading RG1 3JH

Registered in England & Wales No.04094290

If you're unsure & need to seek advice before commencing excavations please contact:

General Enquiries: 0800 048 3516

Subject to revision – Master held by SSEN Asset Data Team:


AssetData@ssen.com

01256 337 294

Scale: 1:500 (When plotted at A3)

BASED UPON THE ORDNANCE SURVEY MAP WITH THE SANCTION OF THE CONTROLLER OF H.M. STATIONERY OFFICE CROWN COPYRIGHT RESERVED.

This copy has been made by or with the authority of Scottish and Southern Energy Power Distribution Ltd. Pursuant to section 47 of the Copyright, Designs and Patents Act 1988 ('The Act'). Unless the Act provides a relevant exception to copyright the copy must not be copied without prior permission of the copyright owner. Plans generated by DigSAFE Pro™ software provided by LinesearchbeforeUdig.

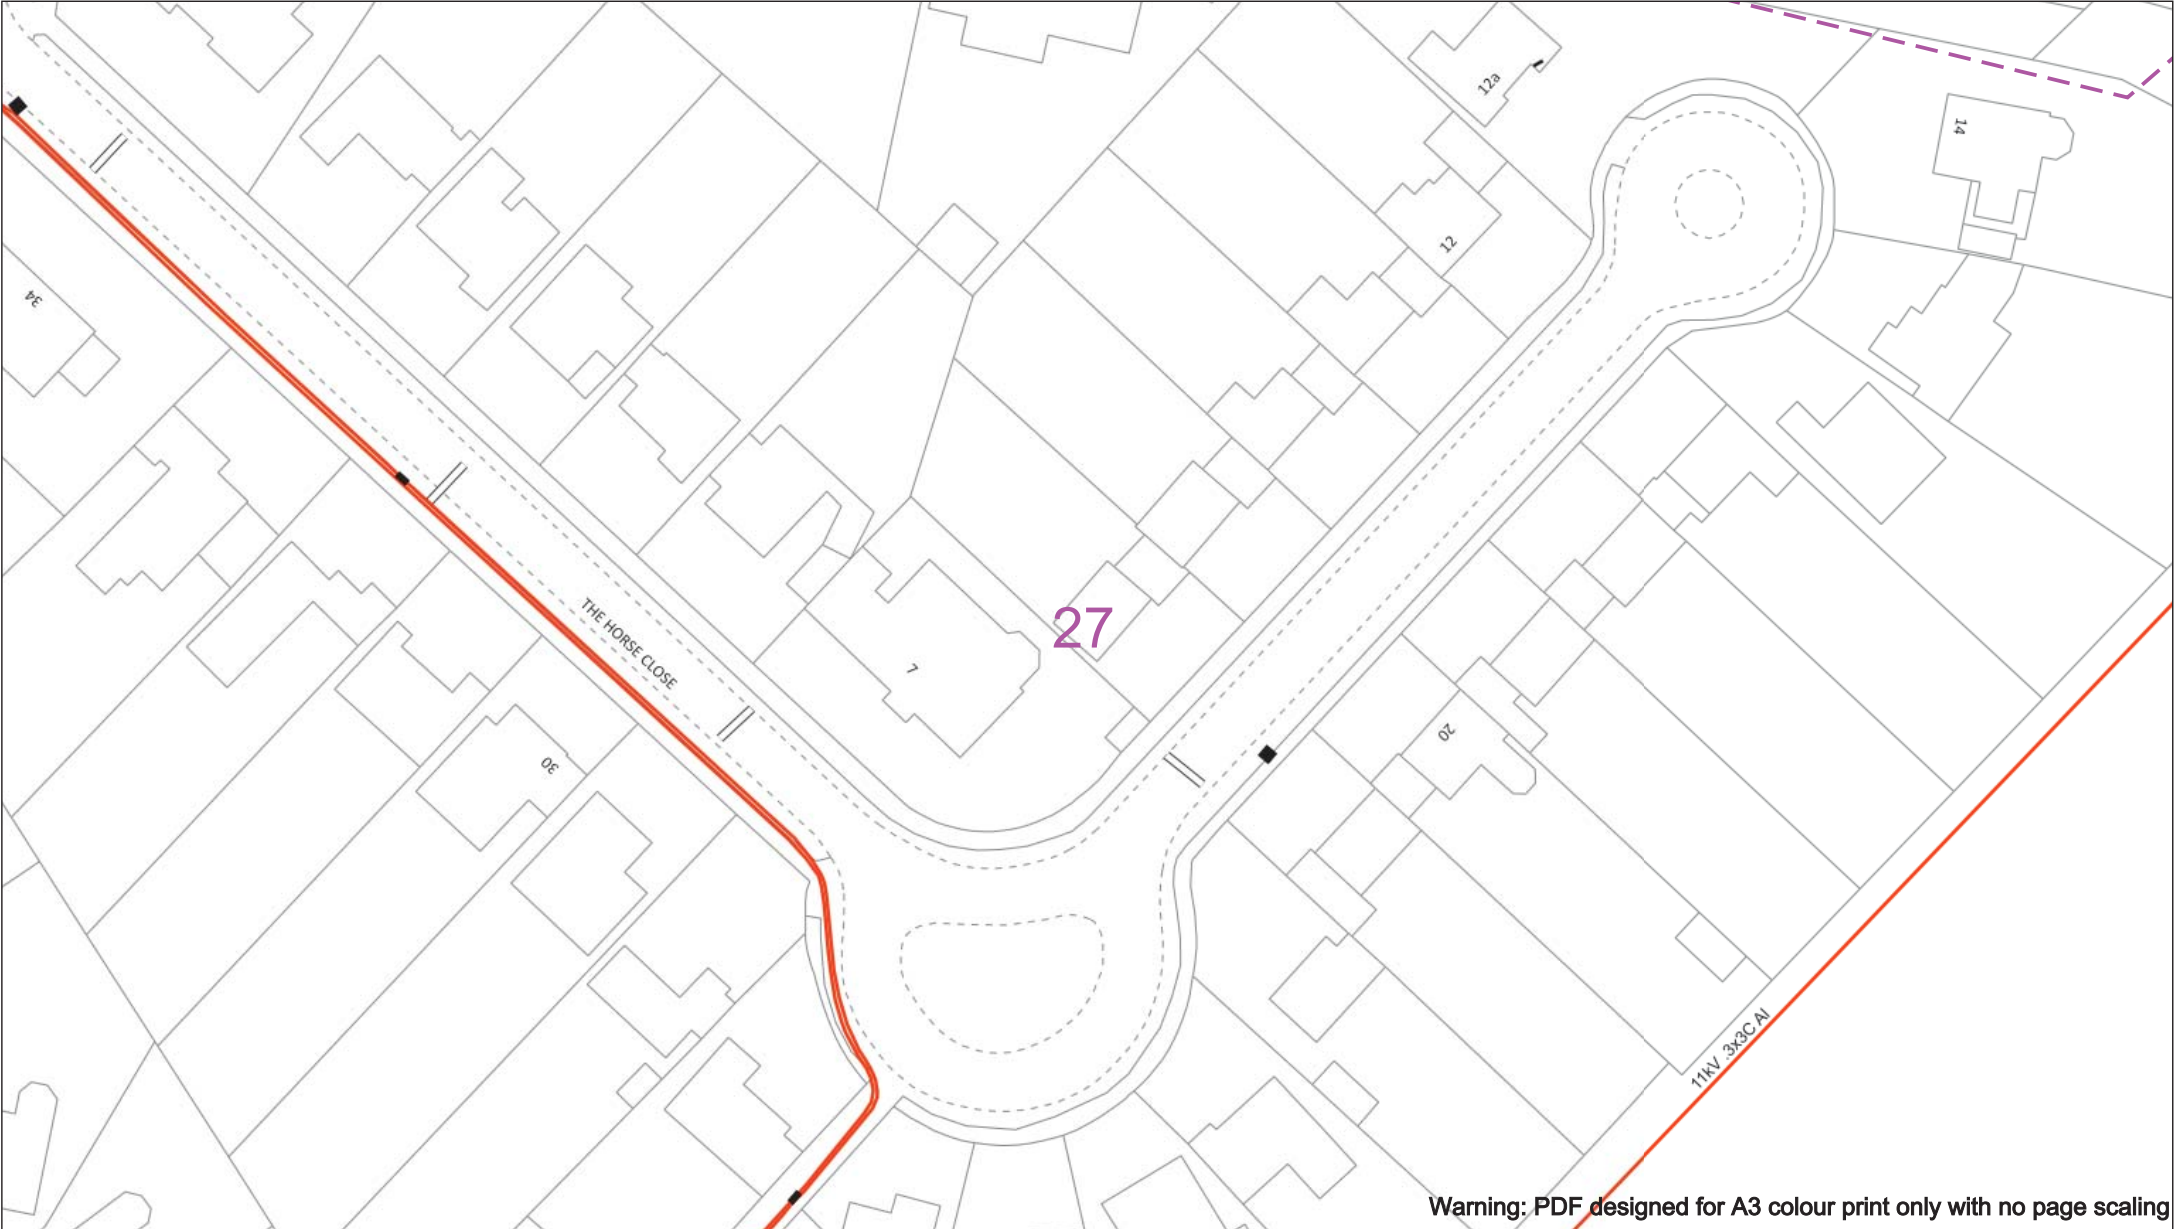

050m

Dig Sites

Area:

Line:

Date Requested: 09/11/2021

Job Reference: 23827726

Site Location: 472556 176139

Requested by: Ms Debbie Wigston

Your Scheme/Reference: 8210940

WARNING

There may have been subsequent alteration to the surface levels. Trial holes must be undertaken to determine position and depths of cables. HS (G) 47 Booklet from the Health and Safety Executive – Avoiding Danger from Buried Cables – should be consulted before commencing excavation work.

WHEN WORKING IN THE VICINITY OF OVERHEAD LINES THE HEALTH AND SAFETY GUIDANCE NOTES GS6 SHOULD BE CONSULTED (AVAILABLE FROM THE HSE WEBSITE)

Voltages (V)				
LV (Low Voltage) and Services	Up to 1,000V			
LV Mains	Over 1,000V to 11,000V			
HV (High Voltage)	22,000V to 132,000V			
EHV (Extra High Voltage)	275,000V and 400,000V			
Transmission	275,000V and 400,000V			

NORMAL DEPTH TO THE TOP OF THE CABLE WHEN LAID				
Services	LV	HV	EHV	
Footpath/Unmade	0.45m	0.45m	0.6m	0.8m
Road Crossing	0.6m	0.6m	0.75m	0.9m
Agricultural	1m	1m	1m	1.1m

Legend

Service Cable

LV Mains

2 – 3.3kV

6.6kV

11kV

22kV

33kV

66kV

132kV

275kV

400kV

Fibre Optic

Pilot Cable

Distribution Structures (Electric)

Pole, Existing Location

Pole Structure, Existing Location - Single

Pole Structure, Existing Location - H

Duct Route

Cross Section Route


Southern Electric Power Distribution plc
Registered Office: No.1 Forbury Place
43 Forbury Road Reading RG1 3JH
Registered in England & Wales No.04094290

If you're unsure & need to seek advice before commencing excavations please contact:
General Enquiries: 0800 048 3516

Subject to revision – Master held by SSEN Asset Data Team:
AssetData@ssen.com
01256 337 294

BASED UPON THE ORDNANCE SURVEY MAP WITH THE SANCTION OF THE CONTROLLER OF H.M STATIONERY OFFICE CROWN COPYRIGHT RESERVED.

This copy has been made by or with the authority of Scottish and Southern Energy Power Distribution Ltd. Pursuant to section 47 of the Copyright, Designs and Patents Act 1988 ('The Act'). Unless the Act provides a relevant exception to copyright the copy must not be copied without prior permission of the copyright owner. Plans generated by DigSAFE Pro™ software provided by LinesearchbeforeUdig.

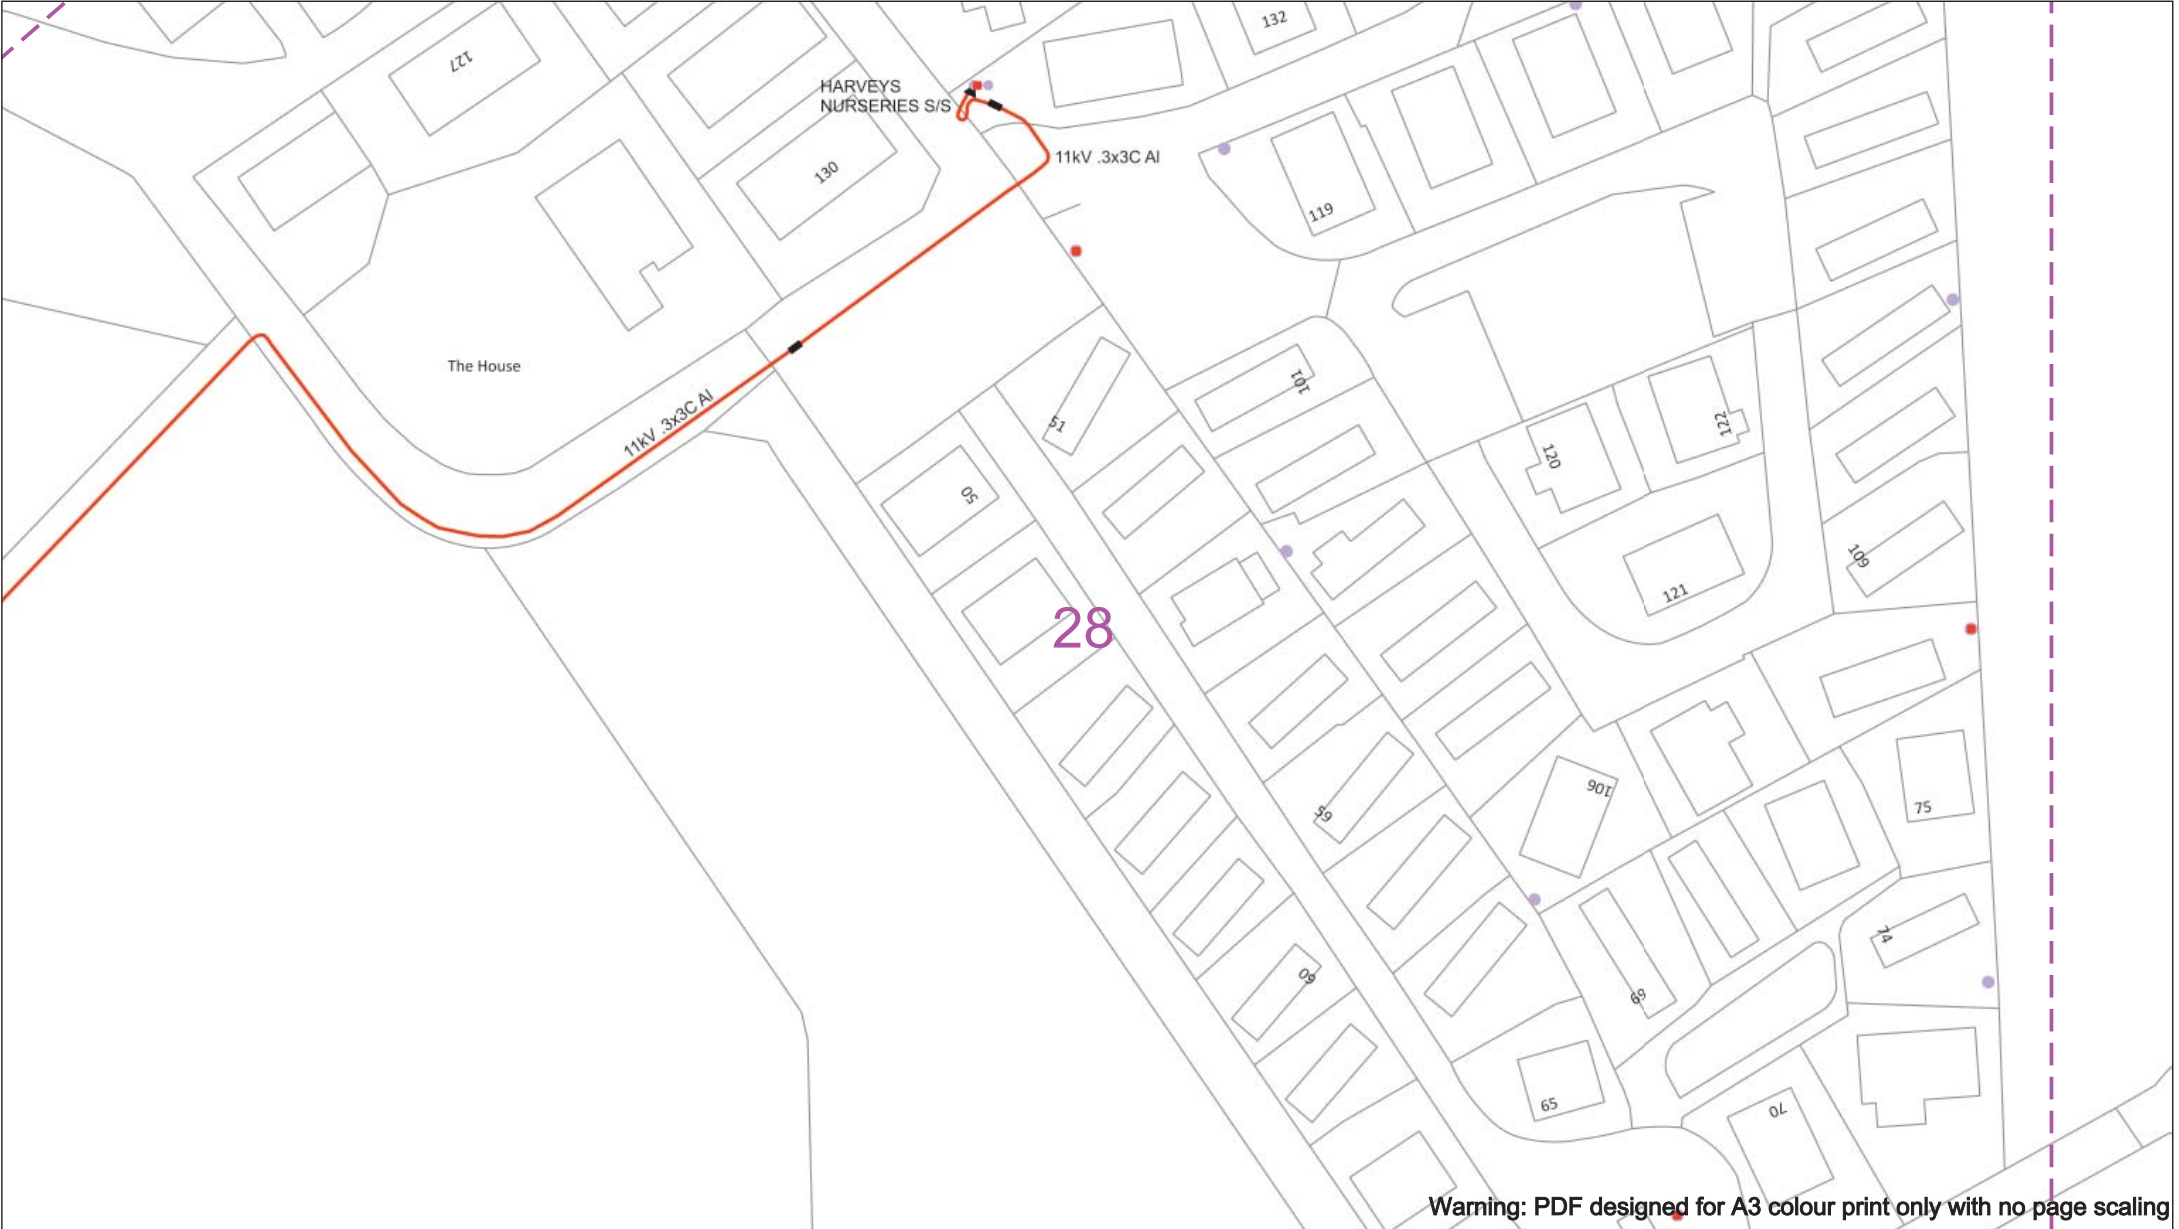

Warning: PDF designed for A3 colour print only with no page scaling

050m

Dig Sites

Area:

Line:

Date Requested: 09/11/2021

Job Reference: 23827726

Site Location: 472556 176139

Requested by: Ms Debbie Wigston

Your Scheme/Reference: 8210940

WARNING

There may have been subsequent alteration to the surface levels. Trial holes must be undertaken to determine position and depths of cables. HS (G) 47 Booklet from the Health and Safety Executive – Avoiding Danger from Buried Cables – should be consulted before commencing excavation work.

WHEN WORKING IN THE VICINITY OF OVERHEAD LINES THE HEALTH AND SAFETY GUIDANCE NOTES GS6 SHOULD BE CONSULTED (AVAILABLE FROM THE HSE WEBSITE)

Voltages (V)

LV (Low Voltage) and Services

Up to 1,000V

Over 1,000V to 11,000V

22,000V to 132,000V

275,000V and 400,000V

NORMAL DEPTH TO THE TOP OF THE CABLE WHEN LAID

Services	LV	HV	HV	EHV
Footpath/Unmade	0.45m	0.45m	0.6m	0.8m
Road Crossing	0.6m	0.6m	0.75m	0.9m
Agricultural	1m	1m	1m	1.1m

Legend

Service Cable

LV Mains

2 – 3.3kV

6.6kV

11kV

22kV

33kV

66kV

132kV

275kV

400kV

Pole Cable

Distribution Structures (Electric)

Pole, Existing Location

Pole Structure, Existing Location - Single

Pole Structure, Existing Location - H

Duct Route

Cross Section Route

Southern Electric Power Distribution plc

Registered Office: No.1 Forbury Place

43 Forbury Road Reading RG1 3JH

Registered in England & Wales No.04094290

If you're unsure & need to seek advice before commencing excavations please contact:

General Enquiries: 0800 048 3516

Subject to revision – Master held by SSEN Asset Data Team:

AssetData@ssen.com

01256 337 294

Scale: 1:500 (When plotted at A3)

BASED UPON THE ORDNANCE SURVEY MAP WITH THE SANCTION OF THE CONTROLLER OF H.M. STATIONERY OFFICE CROWN COPYRIGHT RESERVED.

This copy has been made by or with the authority of Scottish and Southern Energy Power Distribution Ltd. Pursuant to section 47 of the Copyright, Designs and Patents Act 1988 ('The Act'). Unless the Act provides a relevant exception to copyright the copy must not be copied without prior permission of the copyright owner. Plans generated by DigSAFE Pro™ software provided by LinesearchbeforeUdig.

Warning: PDF designed for A3 colour print only with no page scaling

050m

Dig Sites

Area: 

Line: 

Date Requested: 09/11/2021

Job Reference: 23827726

Site Location: 472556 176139

Requested by: Ms Debbie Wigston

Your Scheme/Reference: 8210940

WARNING

There may have been subsequent alteration to the surface levels. Trial holes must be undertaken to determine position and depths of cables. HS (G) 47 Booklet from the Health and Safety Executive – Avoiding Danger from Buried Cables – should be consulted before commencing excavation work.

WHEN WORKING IN THE VICINITY OF OVERHEAD LINES THE HEALTH AND SAFETY GUIDANCE NOTES GS6 SHOULD BE CONSULTED (AVAILABLE FROM THE HSE WEBSITE)

Voltages (V)

LV (Low Voltage) and Services	Up to 1,000V
HV (High Voltage)	Over 1,000V to 11,000V
EHV (Extra High Voltage)	22,000V to 132,000V
Transmission	275,000V and 400,000V

NORMAL DEPTH TO THE TOP OF THE CABLE WHEN LAID

Services	LV	HV	EHV
Footpath/Unmade	0.45m	0.45m	0.6m
Road Crossing	0.6m	0.6m	0.75m
Agricultural	1m	1m	1.1m

Legend

 Service Cable

 LV Mains

 2 – 3.3kV

 6.6kV

 11kV

 22kV

 33kV

 66kV

 132kV

 275kV

 400kV

 Fibre Optic

 Pipe Cable

Distribution Structures (Electric)

 Pole, Existing Location

 Pole Structure, Existing Location - Single

 Pole Structure, Existing Location - H

 Duct Route

 Cross Section Route



Southern Electric Power Distribution plc

Registered Office: No.1 Forbury Place

43 Forbury Road Reading RG1 3JH

Registered in England & Wales No.04094290

If you're unsure & need to seek advice before commencing excavations please contact:

General Enquiries: 0800 048 3516

Subject to revision – Master held by SSEN Asset Data Team:

Asset.Data@ssen.com

01256 337 294

Based upon the Ordnance Survey map with the sanction of the Controller of H.M. Stationery Office Crown Copyright Reserved.

This copy has been made by or with the authority of Scottish and Southern Energy Power Distribution Ltd. Pursuant to section 47 of the Copyright, Designs and Patents Act 1988 ('The Act'). Unless the Act provides a relevant exception to copyright the copy must not be copied without prior permission of the copyright owner. Plans generated by DigSAFE Pro™ software provided by LinesearchbeforeUdig.

30

Warning: PDF designed for A3 colour print only with no page scaling

0 50m

Dig Sites Area: Line:

Date Requested: 09/11/2021
Job Reference: 23827726
Site Location: 472556 176139
Requested by:
Ms Debbie Wigston
Your Scheme/Reference: 8210940

WARNING

There may have been subsequent alteration to the surface levels. Trial holes must be undertaken to determine position and depths of cables. HS (G) 47 Booklet from the Health and Safety Executive – Avoiding Danger from Buried Cables – should be consulted before commencing excavation work.

WHEN WORKING IN THE VICINITY OF OVERHEAD LINES THE HEALTH AND SAFETY GUIDANCE NOTES GS6 SHOULD BE CONSULTED (AVAILABLE FROM THE HSE WEBSITE)

Scale: 1:500 (When plotted at A3)

Voltages (V)				
LV (Low Voltage) and Services	Up to 1,000V			
HV (High Voltage)	Over 1,000V to 11,000V			
EHV (Extra High Voltage)	22,000V to 132,000V			
Transmission	275,000V and 400,000V			

NORMAL DEPTH TO THE TOP OF THE CABLE WHEN LAID				
Services	LV	HV	EHV	
Footpath/Unmade	0.45m	0.45m	0.6m	0.8m
Road Crossing	0.6m	0.6m	0.75m	0.9m
Agricultural	1m	1m	1m	1.1m

Legend	
Service Cable	
LV Mains	
2 – 3.3kV	
6.6kV	
11kV	
22kV	
33kV	
66kV	
132kV	
275kV	
400kV	
Flow Ducts	
Pile Cable	


Distribution Structures (Electric)	
Pole, Existing Location	
Pole Structure, Existing Location - Single	
Pole Structure, Existing Location - H	
Duct Route	
Cross Section Route	



Southern Electric Power Distribution plc
Registered Office: No.1 Forbury Place
43 Forbury Road Reading RG1 3JH
Registered in England & Wales No.04094290

If you're unsure & need to seek advice before commencing excavations please contact:
General Enquiries: 0800 048 3516

Subject to revision – Master held by SSSEN Asset Data Team:
Asset.Data@sen.com
01256 337 294

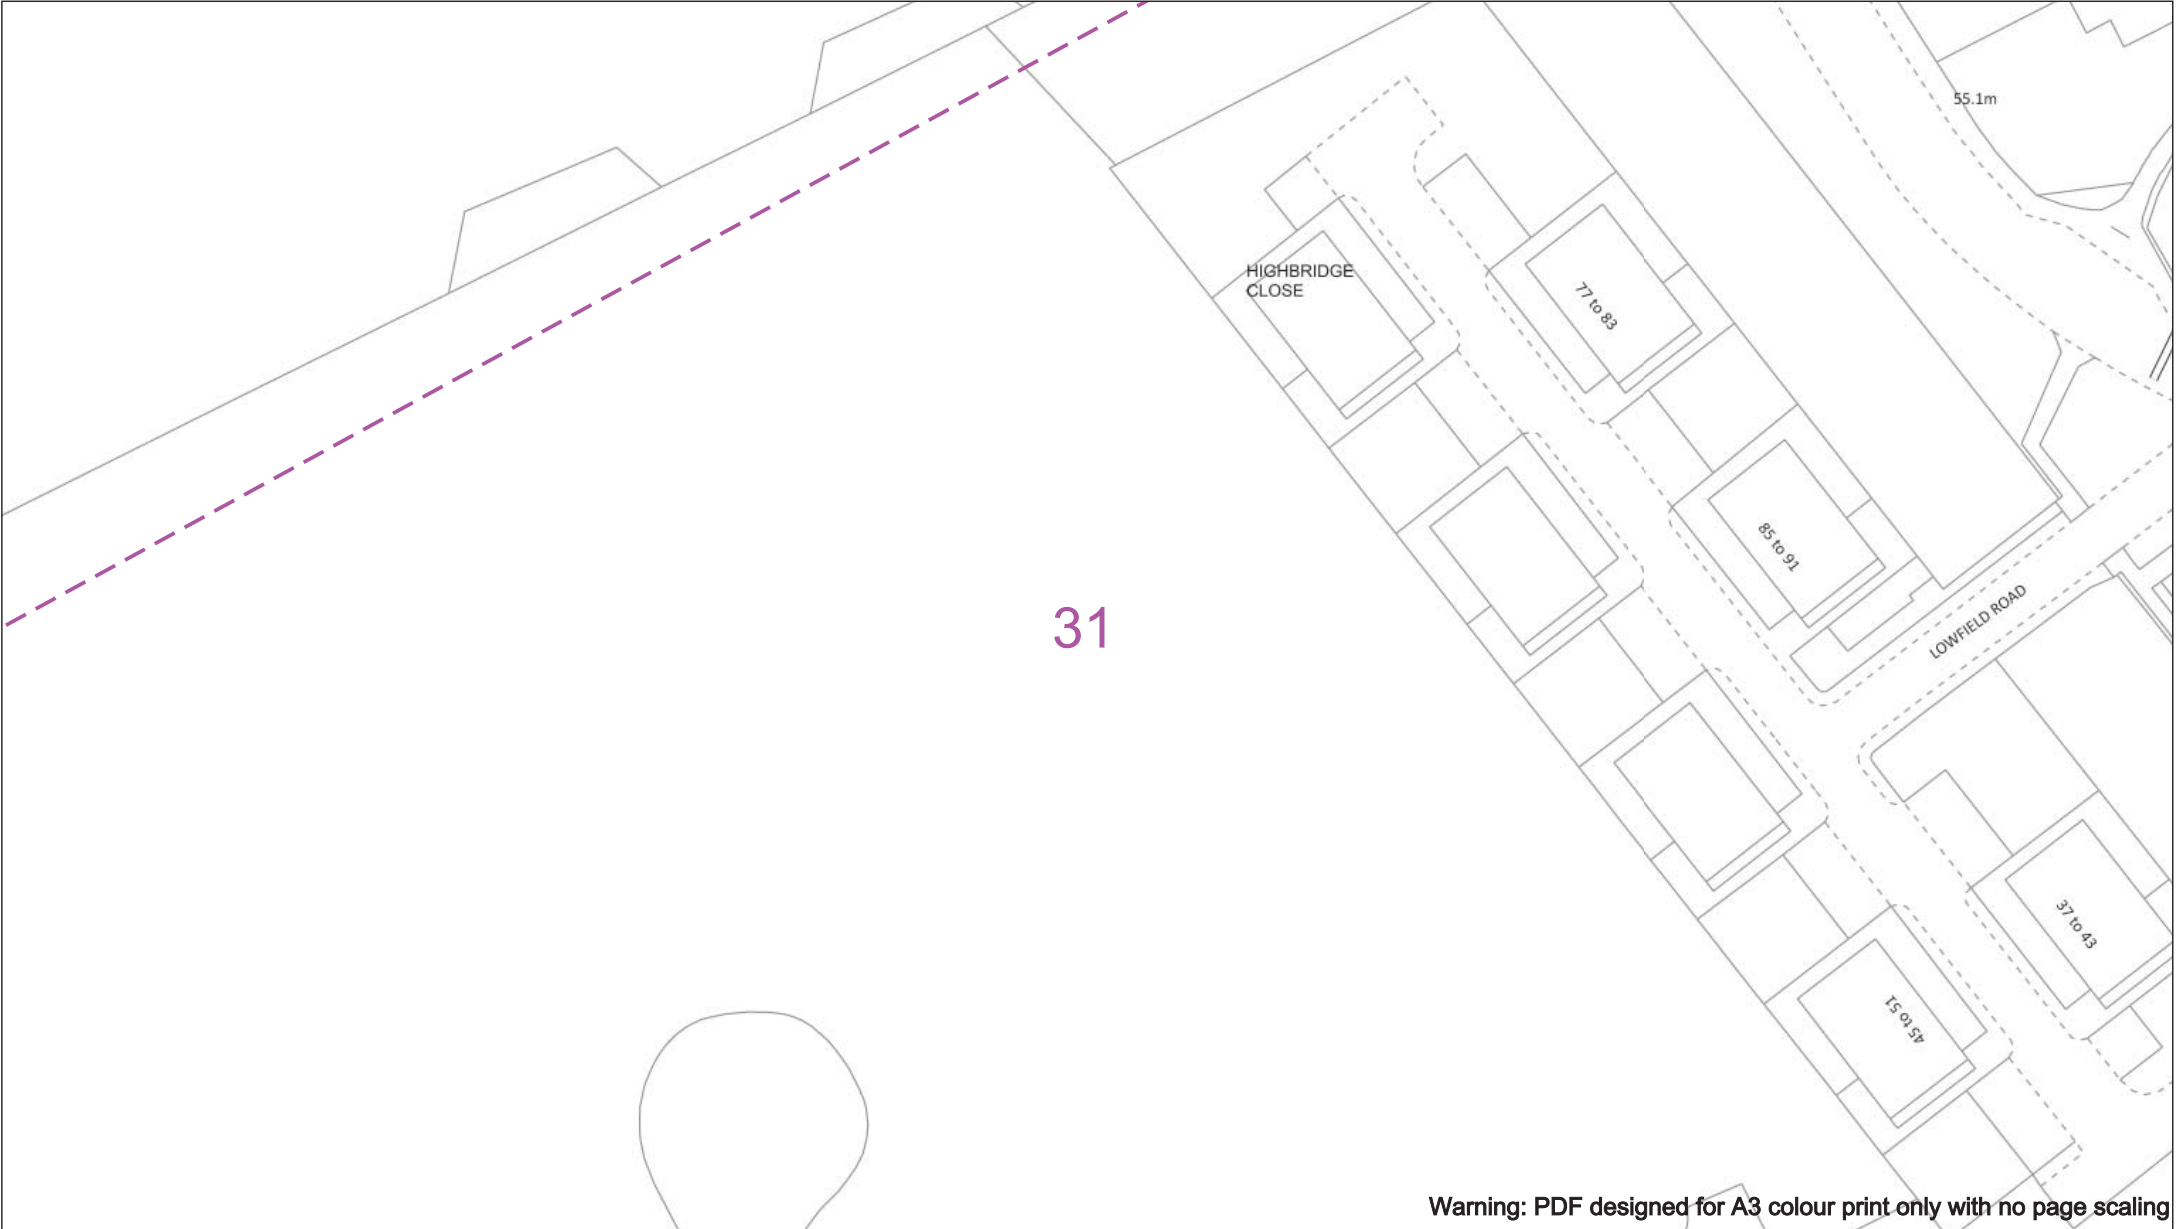

050m

Dig Sites

Area: 

Line: 

Date Requested: 09/11/2021

Job Reference: 23827726

Site Location: 472556 176139

Requested by: Ms Debbie Wigston

Your Scheme/Reference: 8210940

WARNING

There may have been subsequent alteration to the surface levels. Trial holes must be undertaken to determine position and depths of cables. HS (G) 47 Booklet from the Health and Safety Executive – Avoiding Danger from Buried Cables – should be consulted before commencing excavation work.

WHEN WORKING IN THE VICINITY OF OVERHEAD LINES THE HEALTH AND SAFETY GUIDANCE NOTES GS6 SHOULD BE CONSULTED (AVAILABLE FROM THE HSE WEBSITE)

Voltages (V)

LV (Low Voltage) and Services

Up to 1,000V

HV (High Voltage)

Over 1,000V to 11,000V

EHV (Extra High Voltage)

22,000V to 132,000V

Transmission

275,000V and 400,000V

NORMAL DEPTH TO THE TOP OF THE CABLE WHEN LAID

Services	LV	HV	EHV
Footpath/Unmade	0.45m	0.45m	0.6m
Road Crossing	0.6m	0.6m	0.75m
Agricultural	1m	1m	1.1m

Legend

 Service Cable

 LV Mains

 2 – 3.3kV

 6.6kV

 11kV

 22kV

 33kV

 66kV

 132kV

 275kV

 400kV

 Fibre Optic

 Pilot Cable

Distribution Structures (Electric)

 Pole, Existing Location

 Pole Structure, Existing Location - Single

 Pole Structure, Existing Location - H

 Duct Route

 Cross Section Route



Southern Electric Power Distribution plc

Registered Office: No.1 Forbury Place

43 Forbury Road Reading RG1 3JH

Registered in England & Wales No.04094290

If you're unsure & need to seek advice before commencing excavations please contact:

General Enquiries: 0800 048 3516


Subject to revision – Master held by SSEN Asset Data Team:

Asset.Data@ssen.com

01256 337 294

BASED UPON THE ORDNANCE SURVEY MAP WITH THE SANCTION OF THE CONTROLLER OF THE H.M. STATIONERY OFFICE CROWN COPYRIGHT RESERVED.

This copy has been made by or with the authority of Scottish and Southern Energy Power Distribution Ltd. Pursuant to section 47 of the Copyright, Designs and Patents Act 1988 ('The Act'). Unless the Act provides a relevant exception to copyright the copy must not be copied without prior permission of the copyright owner. Plans generated by DigSAFE Pro™ software provided by LinesearchbeforeUdig.

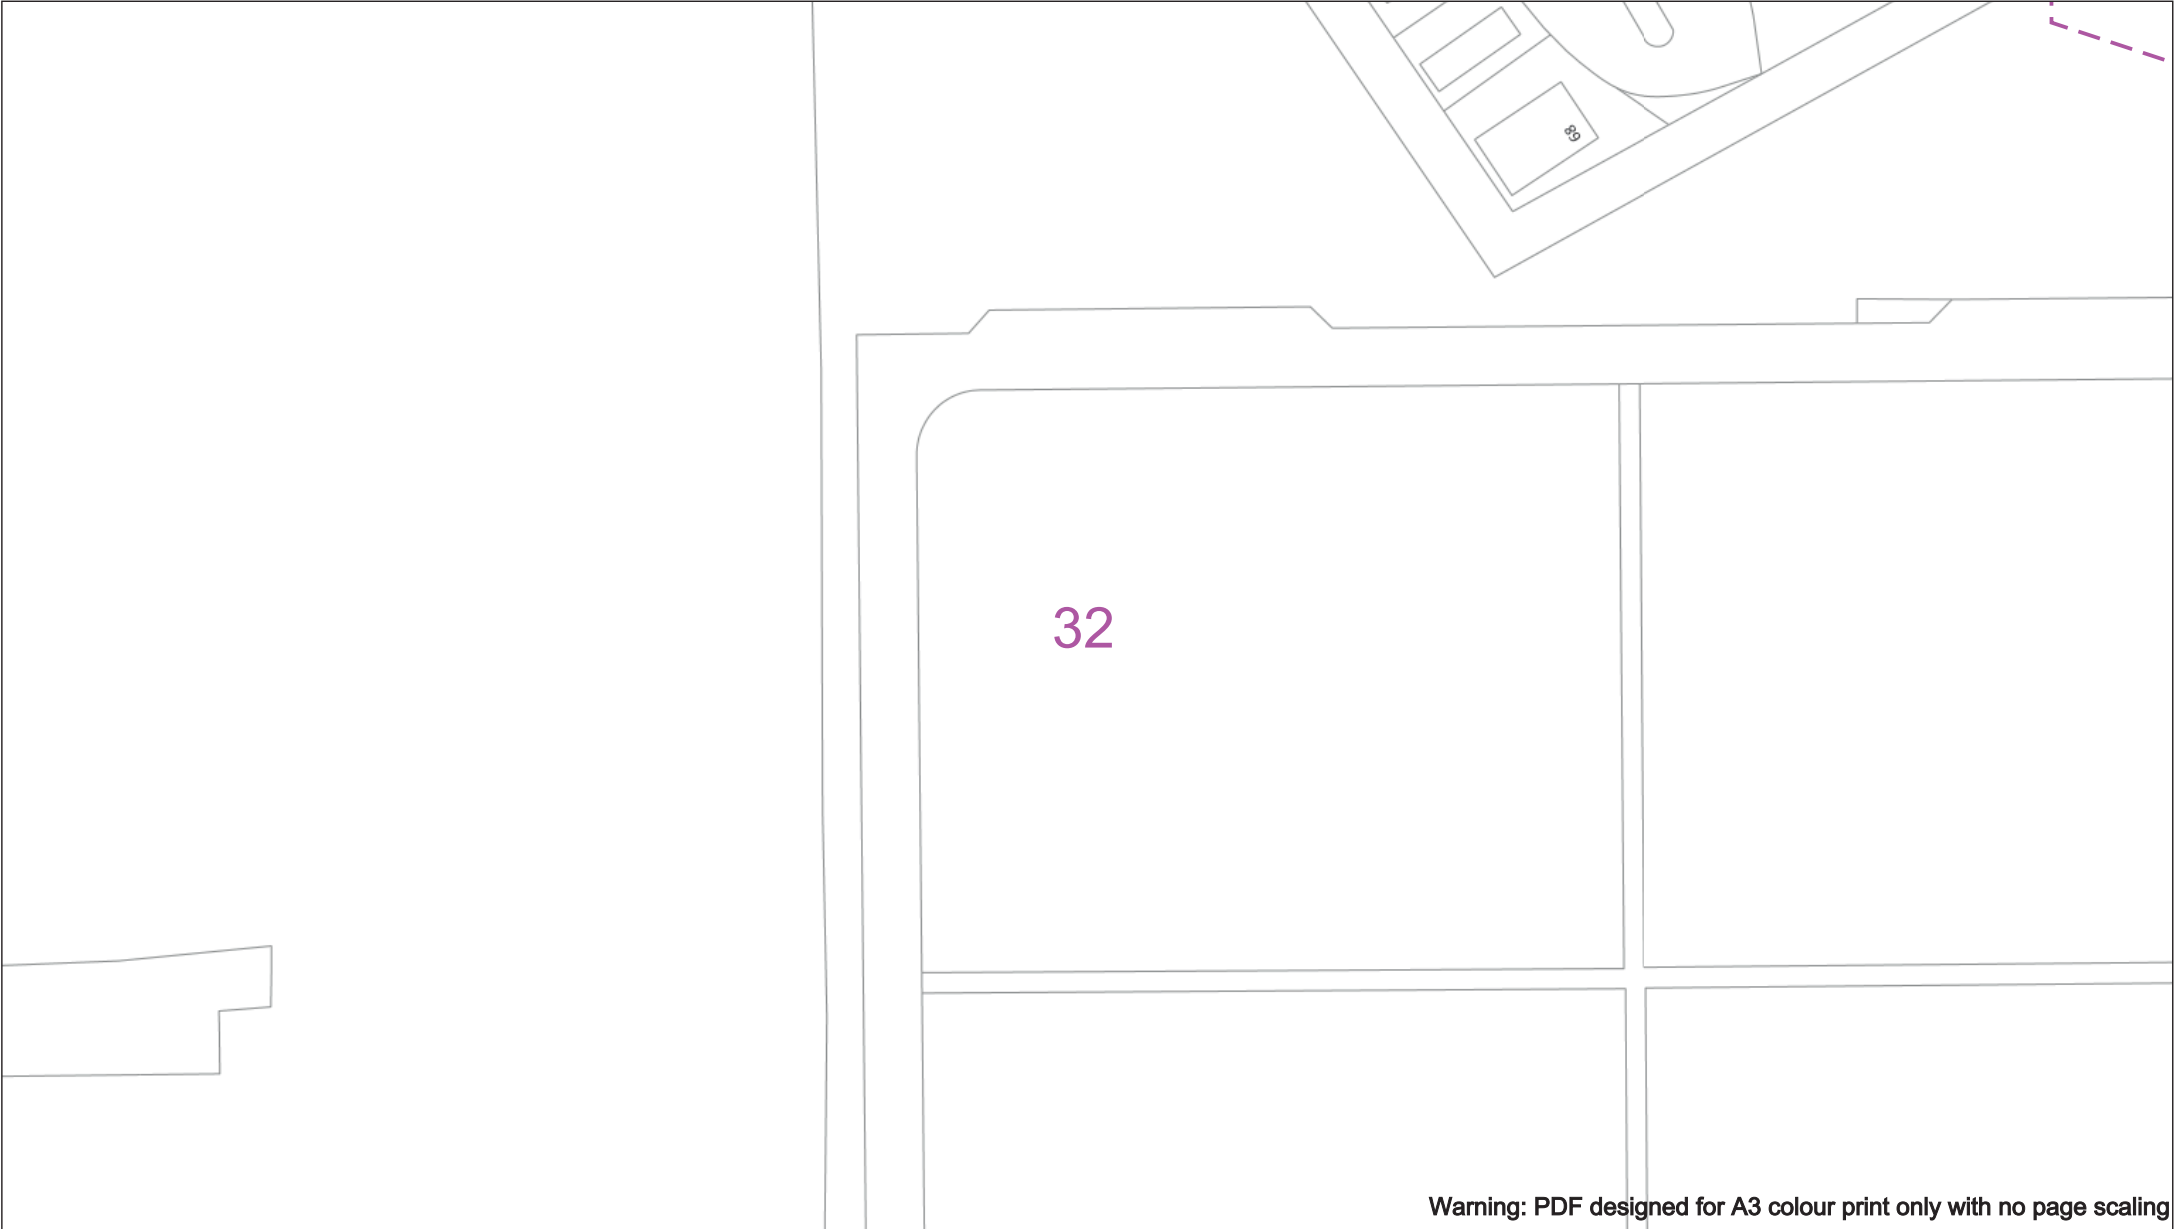

Warning: PDF designed for A3 colour print only with no page scaling

050m

Dig Sites

Area: 

Line: 

Date Requested: 09/11/2021

Job Reference: 23827726

Site Location: 472556 176139

Requested by: Ms Debbie Wigston

Your Scheme/Reference: 8210940

WARNING

There may have been subsequent alteration to the surface levels. Trial holes must be undertaken to determine position and depths of cables. HS (G) 47 Booklet from the Health and Safety Executive – Avoiding Danger from Buried Cables – should be consulted before commencing excavation work.

WHEN WORKING IN THE VICINITY OF OVERHEAD LINES THE HEALTH AND SAFETY GUIDANCE NOTES GS6 SHOULD BE CONSULTED (AVAILABLE FROM THE HSE WEBSITE)

Voltages (V)				
LV (Low Voltage) and Services	Up to 1,000V			
HV (High Voltage)	Over 1,000V to 11,000V			
EHV (Extra High Voltage)	22,000V to 132,000V			
Transmission	275,000V and 400,000V			

NORMAL DEPTH TO THE TOP OF THE CABLE WHEN LAID				
Services	LV	HV	EHV	
Footpath/Unmade	0.45m	0.45m	0.6m	0.8m
Road Crossing	0.6m	0.6m	0.75m	0.9m
Agricultural	1m	1m	1m	1.1m

Legend

 Service Cable

 LV Mains

 2 – 3.3kV

 6.6kV

 11kV

 22kV

 33kV

 66kV

 132kV

 275kV

 400kV

 Fibre Optic

 Pilot Cable

Distribution Structures (Electric)

 Pole, Existing Location

 Pole Structure, Existing Location - Single

 Pole Structure, Existing Location - H

 Duct Route

 Cross Section Route



Southern Electric Power Distribution plc

Registered Office: No.1 Forbury Place

43 Forbury Road Reading RG1 3JH

Registered in England & Wales No.04094290

If you're unsure & need to seek advice before commencing excavations please contact:

General Enquiries: 0800 048 3516

Subject to revision – Master held by SSEN Asset Data Team:

Asset.Data@ssen.com

01256 337 294

BASED UPON THE ORDNANCE SURVEY MAP WITH THE SANCTION OF THE CONTROLLER OF H.M STATIONERY OFFICE CROWN COPYRIGHT RESERVED.

This copy has been made by or with the authority of Scottish and Southern Energy Power Distribution Ltd. Pursuant to section 47 of the Copyright, Designs and Patents Act 1988 ('The Act'). Unless the Act provides a relevant exception to copyright the copy must not be copied without prior permission of the copyright owner. Plans generated by DigSAFE Pro™ software provided by LinesearchbeforeUdig.



Warning: PDF designed for A3 colour print only with no page scaling

050m

Dig Sites

Area:

Line:

Date Requested: 09/11/2021

Job Reference: 23827726

Site Location: 472556 176139

Requested by: Ms Debbie Wigston

Your Scheme/Reference: 8210940

WARNING

There may have been subsequent alteration to the surface levels. Trial holes must be undertaken to determine position and depths of cables. HS (G) 47 Booklet from the Health and Safety Executive – Avoiding Danger from Buried Cables – should be consulted before commencing excavation work.

WHEN WORKING IN THE VICINITY OF OVERHEAD LINES THE HEALTH AND SAFETY GUIDANCE NOTES GS6 SHOULD BE CONSULTED (AVAILABLE FROM THE HSE WEBSITE)

Voltages (V)

LV (Low Voltage) and Services Up to 1,000V

HV (High Voltage) Over 1,000V to 11,000V

EHV (Extra High Voltage) 22,000V to 132,000V

Transmission 275,000V and 400,000V

NORMAL DEPTH TO THE TOP OF THE CABLE WHEN LAID

Services	LV	HV	EHV
Footpath/Unmade	0.45m	0.45m	0.6m
Road Crossing	0.6m	0.6m	0.75m
Agricultural	1m	1m	1.1m

Legend

Service Cable

LV Mains

2-33kV

6.6kV

11kV

22kV

33kV

66kV

132kV

275kV

400kV

Fibre Optic

Pilot Cable

Distribution Structures (Electric)

Pole, Existing Location

Pole Structure, Existing Location - Single

Pole Structure, Existing Location - H

Duct Route

Cross Section Route


Southern Electric Power Distribution plc
Registered Office: No.1 Forbury Place
43 Forbury Road Reading RG1 3JH
Registered in England & Wales No.04094290

If you're unsure & need to seek advice before commencing excavations please contact:
General Enquiries: 0800 048 3516

Subject to revision – Master held by SSEN Asset Data Team:
Asset.Data@ssen.com
01256 337 294

BASED UPON THE ORDNANCE SURVEY MAP WITH THE SANCTION OF THE CONTROLLER OF H.M. STATIONERY OFFICE CROWN COPYRIGHT RESERVED.

This copy has been made by or with the authority of Scottish and Southern Energy Power Distribution Ltd. Pursuant to section 47 of the Copyright, Designs and Patents Act 1988 ('The Act'). Unless the Act provides a relevant exception to copyright the copy must not be copied without prior permission of the copyright owner. Plans generated by DigSAFE Pro™ software provided by LinesearchbeforeUdig.

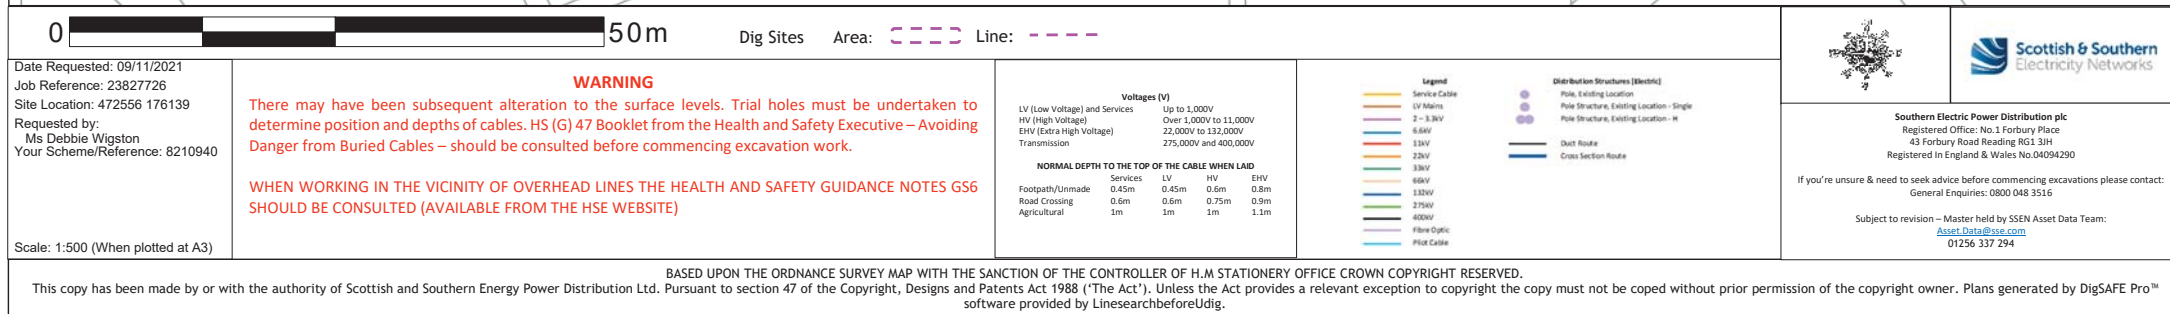

Appendix G

Service Records – Virgin Media and BT Openreach (Telecom)



York Place
Elizabeth House
Queen Street
Leeds
LS1 2TW

Virgin Media
Field Services
Units 1-12
Broad Lane
Mayfair Business Park
Bradford
Yorkshire
BD4 8PW

Tel: 0870 888 3116 Opt 2

Plant Enquiry Ref: VM.1161944
Letter Date 09.03.2020
Your Ref: YP1315771
Date: 10.03.2020

Dear Sir/Madam,

Enquiry Location: Caversham Park Peppard Road, Caversham, RG4 8TZ

Thank you for your enquiry regarding work at the above location.

I enclose a copy of our above referenced drawing, marked to show the approximate position of plant owned and operated by Virgin Media.

You will be aware that you have a duty to ensure that no damage results to this equipment as a result of your proposed works. Please note that this apparatus may contain Fibre Optic, Coaxial and/or 240v Power Cables and as such, special care must be taken when excavating this area.

Should you require Virgin Media apparatus to be diverted we must agree a specification of works and provide a detailed estimate of costs. The costs are £720 (Business) or £240 (Residential) Inc VAT and the charge applies to each individual scheme requested. Both the estimate and specification will be sent to you within 25 working days of when the payment was received.

This initial payment will cover the following: -

- Detailed site visit by an experienced planning engineer. (Up to 10 hours planning time)
- Detailed specification of works.
- Detailed breakdown of costs.

Payment is required in advance for the estimated cost of detailed design work and the charge applies whether or not your works proceed. Please supply us with your payment and a copy of your plans or drawings and quote 'Our Ref' as above.

The address to send the cheque is:

Diversiory Works, Virgin Media, 1 Dove Wynd, Strathclyde Business Park Bellshill ML4 3AL

Or if you prefer to talk, please call the Diversiory Team on: 0800 408 0088 Option 1

Should your request be in relation to a Residential New Development, Virgin Media would like the opportunity to assist with your diversionary quote and serve your site free of charge, offering your customers the fastest widely available broadband speeds on the market up to 500Mbps.

For Commercial New Developments our team can also be reached through the below link, ensuring future businesses to your site are connected to our fibre network.


Simply head over to www.virginmedia.com/developer to fill in the enquiry form, and a member of our New Developments team will be in touch within 48 hours.

You will also find useful information about additional benefits to you and your site, plus a handy 'developers guide' can be downloaded with detailed installation requirements.

Or if you prefer to talk, please call the Diversiory Team on: 0800 408 0088 Option 2

Yours faithfully

National Plant Enquiries Team,

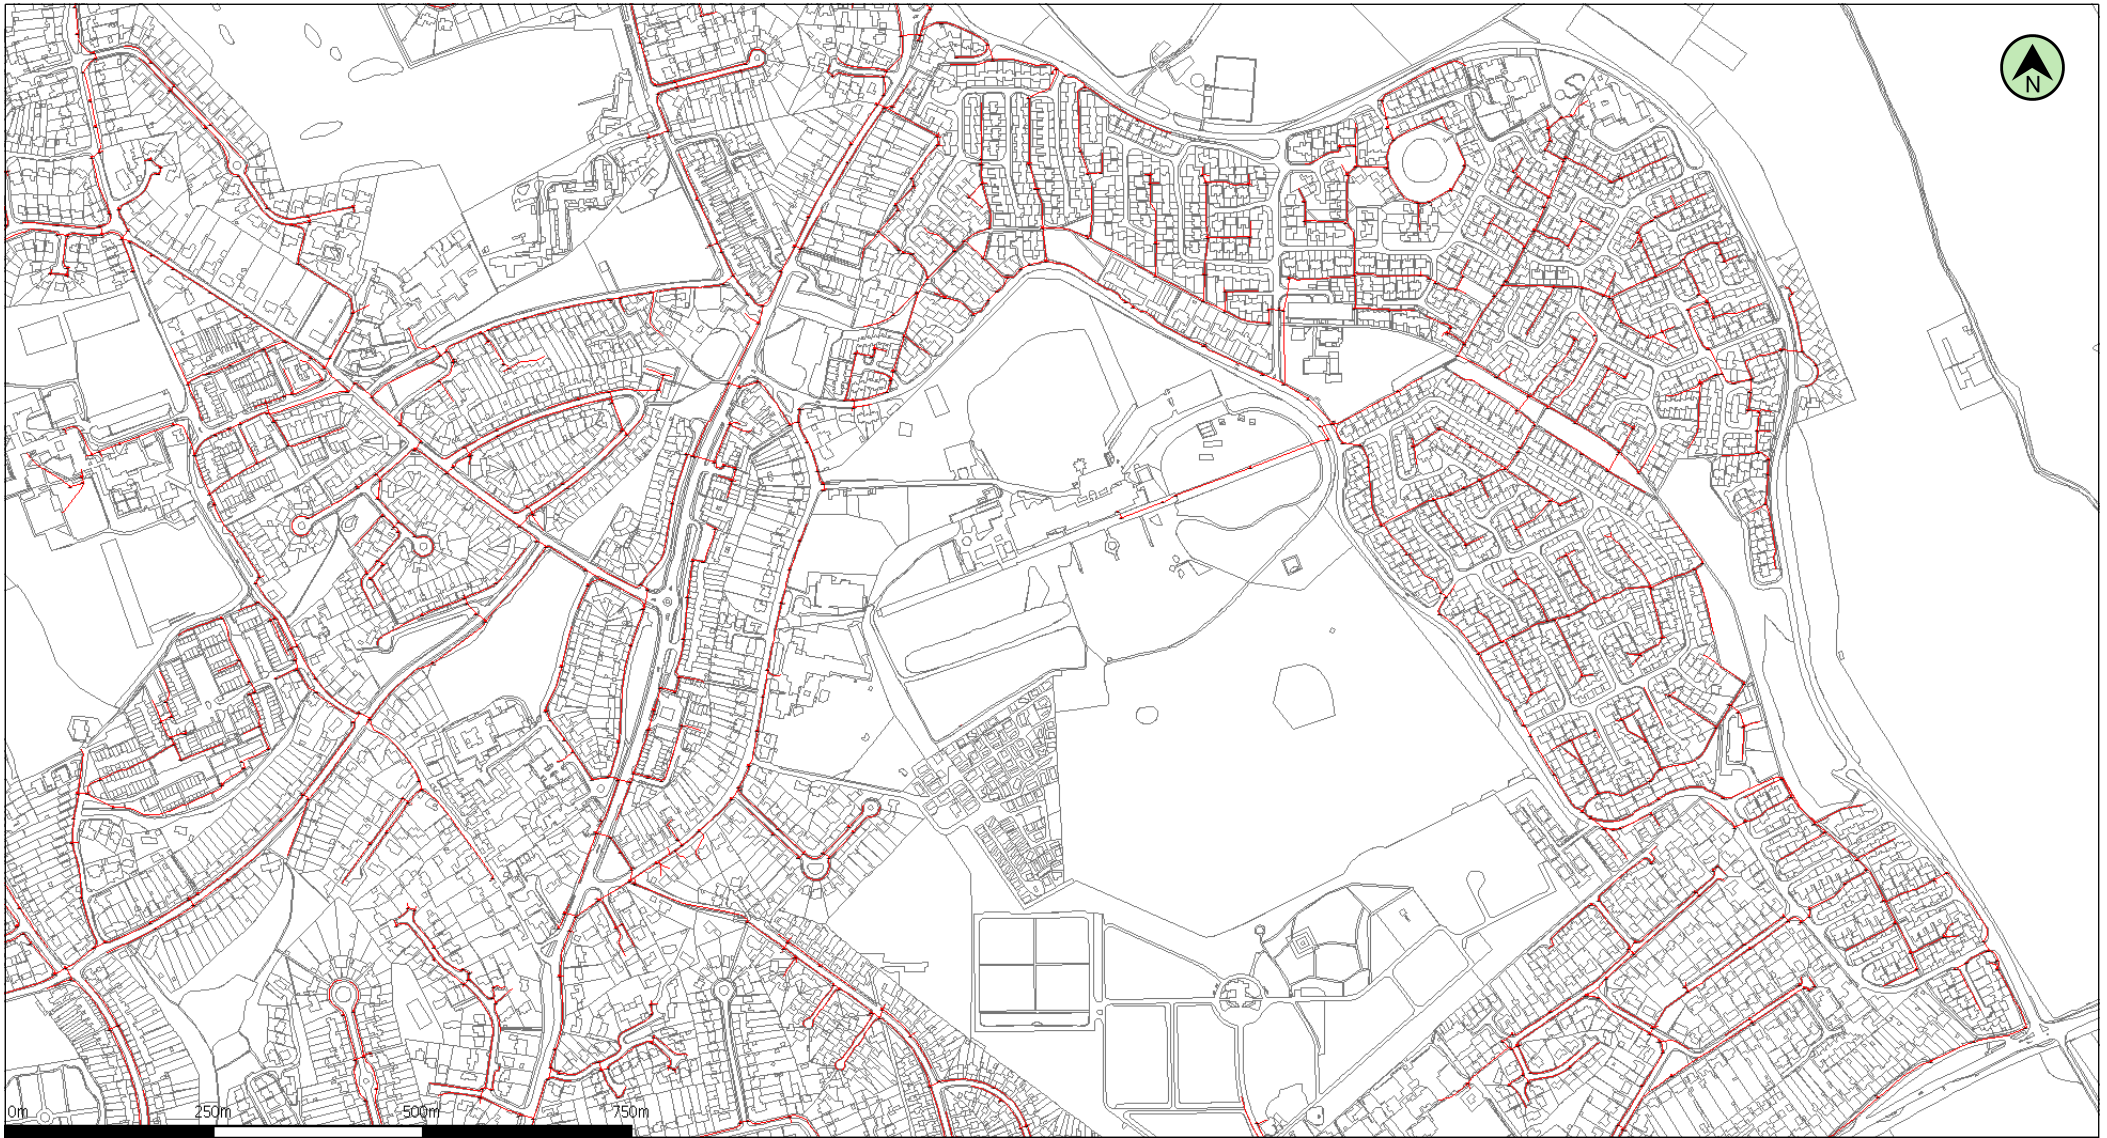

(c) Crown copyright and database rights 2020 Ordnance Survey 100019209 Date: 10/03/20 Scale: 1:9045 Map Centre: 472429,176208 Data updated: 02/03/20 Telecoms Plan A4

Important Information - please read The purpose of this plan is to identify Virgin Media apparatus. We have tried to make it as accurate as possible but we cannot warrant its accuracy. In addition, we caution that within Virgin Media apparatus there may be instances where mains voltage power cables have been placed inside green, rather than black ducting. Further details can be found using the "Affected Postcodes.pdf", which can be downloaded from this website. Therefore, you must not rely solely on this plan if you are carrying out any excavation or other works in the vicinity of Virgin Media apparatus. The actual position of any underground service must be verified by cable detection equipment, etc. and established on site before any mechanical plant is used. Accordingly, unless it is due to the negligence of Virgin Media, its employees or agents, Virgin Media will not have any liability for any omissions or inaccuracies in the plan or for any loss or damage caused or arising from the use of and/or any reliance on this plan. This plan is produced by Virgin Media Limited (c) Crown copyright and database rights 2020 Ordnance Survey 100019209.

Duct, Trench



Chamber



Cabinet



stephy.jaison@virginmedia.co.uk

VM.1161944

