


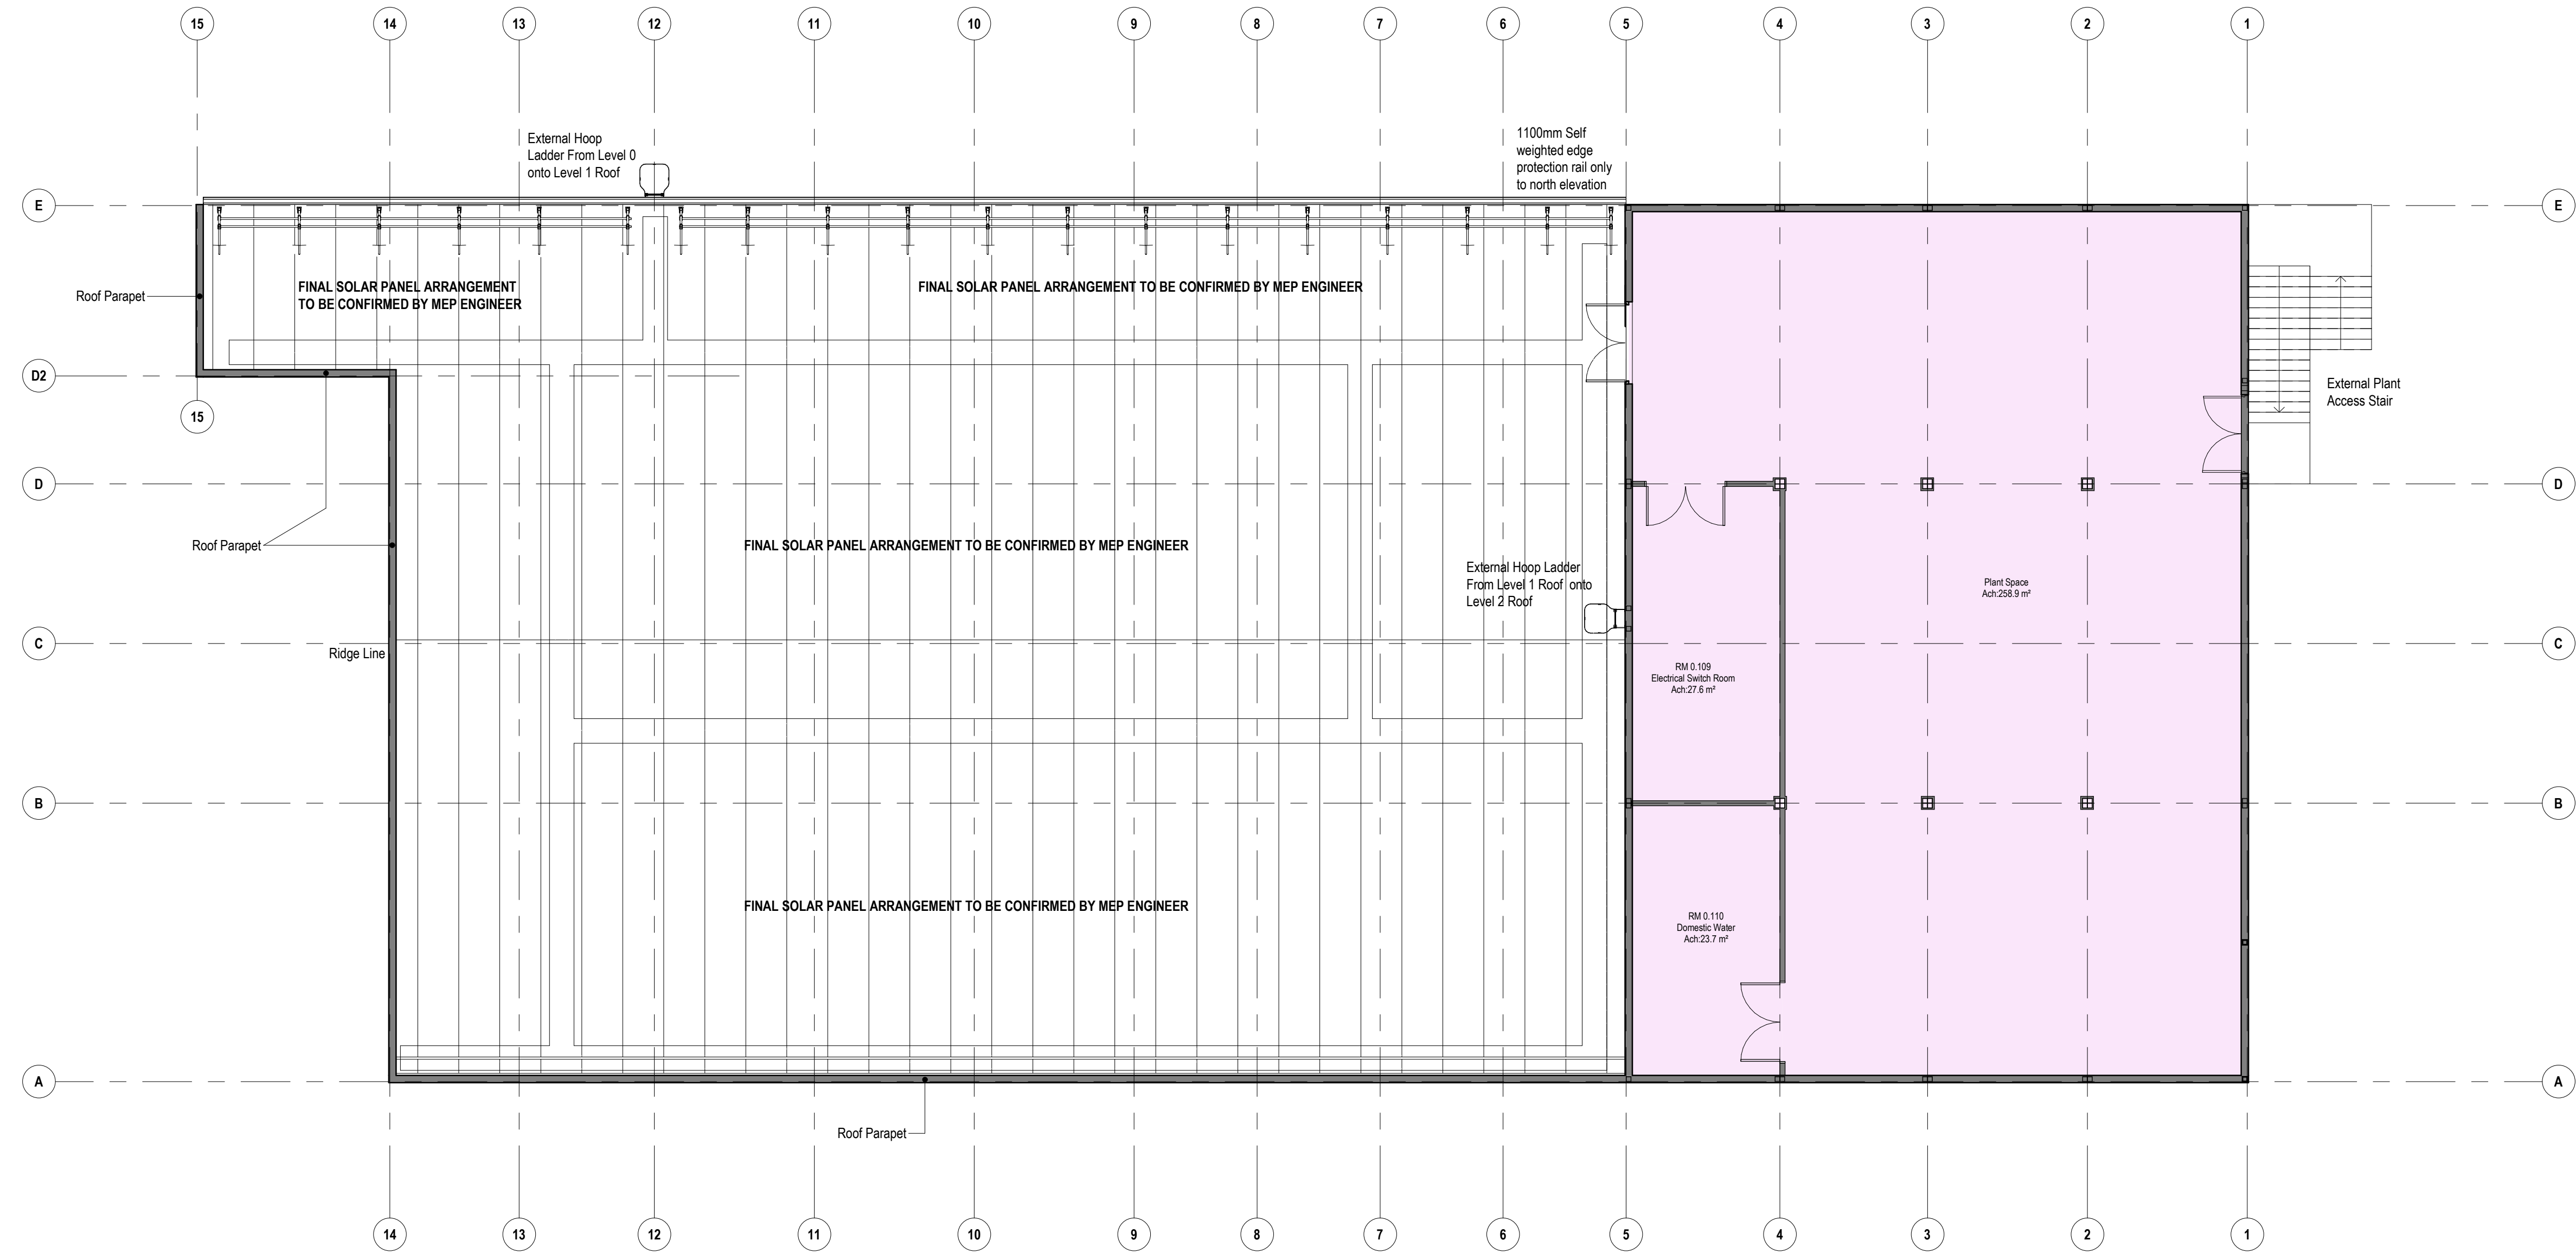

Planning - First Floor Plant Level GA Layout
1 : 100

Notes:

- This drawing is copyright.
- Do not scale dimensions from this drawing.
- This drawing is to be read in conjunction with all other relevant drawings.
- All discrepancies on this drawing are to be reported to the architect.
- Do not modify any element of this drawing.
- Use drawing only for purpose(s) issued.
- This drawing may contain colour.

Scale Bar

0 1m 3m 5m

Scale: 1:100

North Point

Key Plan

Hazard	HAZ-xx To warn of significant hazards or information that is unusual To be read in conjunction with all other consultant's information Refer to CDM Schedule XXXX-IBH-WB-XX-SH-A-200-XXXX
---------------	---

The following external model files are included within this drawing:

P01	18/06/2024	Planning Issue	MJS	AG
Rev	Date	Revision Notes	Drawn	Review
Logos				
Royal Berkshire NHS Foundation Trust				
T: +44(0)161 6940123 E: info@mbcontracts.co.uk W: www.mtx.co.uk				
		Intelligence Buildings Infrastructure		
www.ibigroup.com				
Project				
Royal Berkshire Hospital - Integrated Care Service - Elective Recovery RBH-ICS ER				
Drawing Title				
Planning - First Floor Plant Level GA Layout				
Job Number	Date	Security Classification	Drawn By	
146891	18.06.2024		MJS	
Scale@A1	Purpose	Reviewed By		
1 : 100	PLANNING	AG		
Drawing Number				Revision
RBHU-AUK-XX-01-PL-A-200201				P01