


Appendix A Drawings

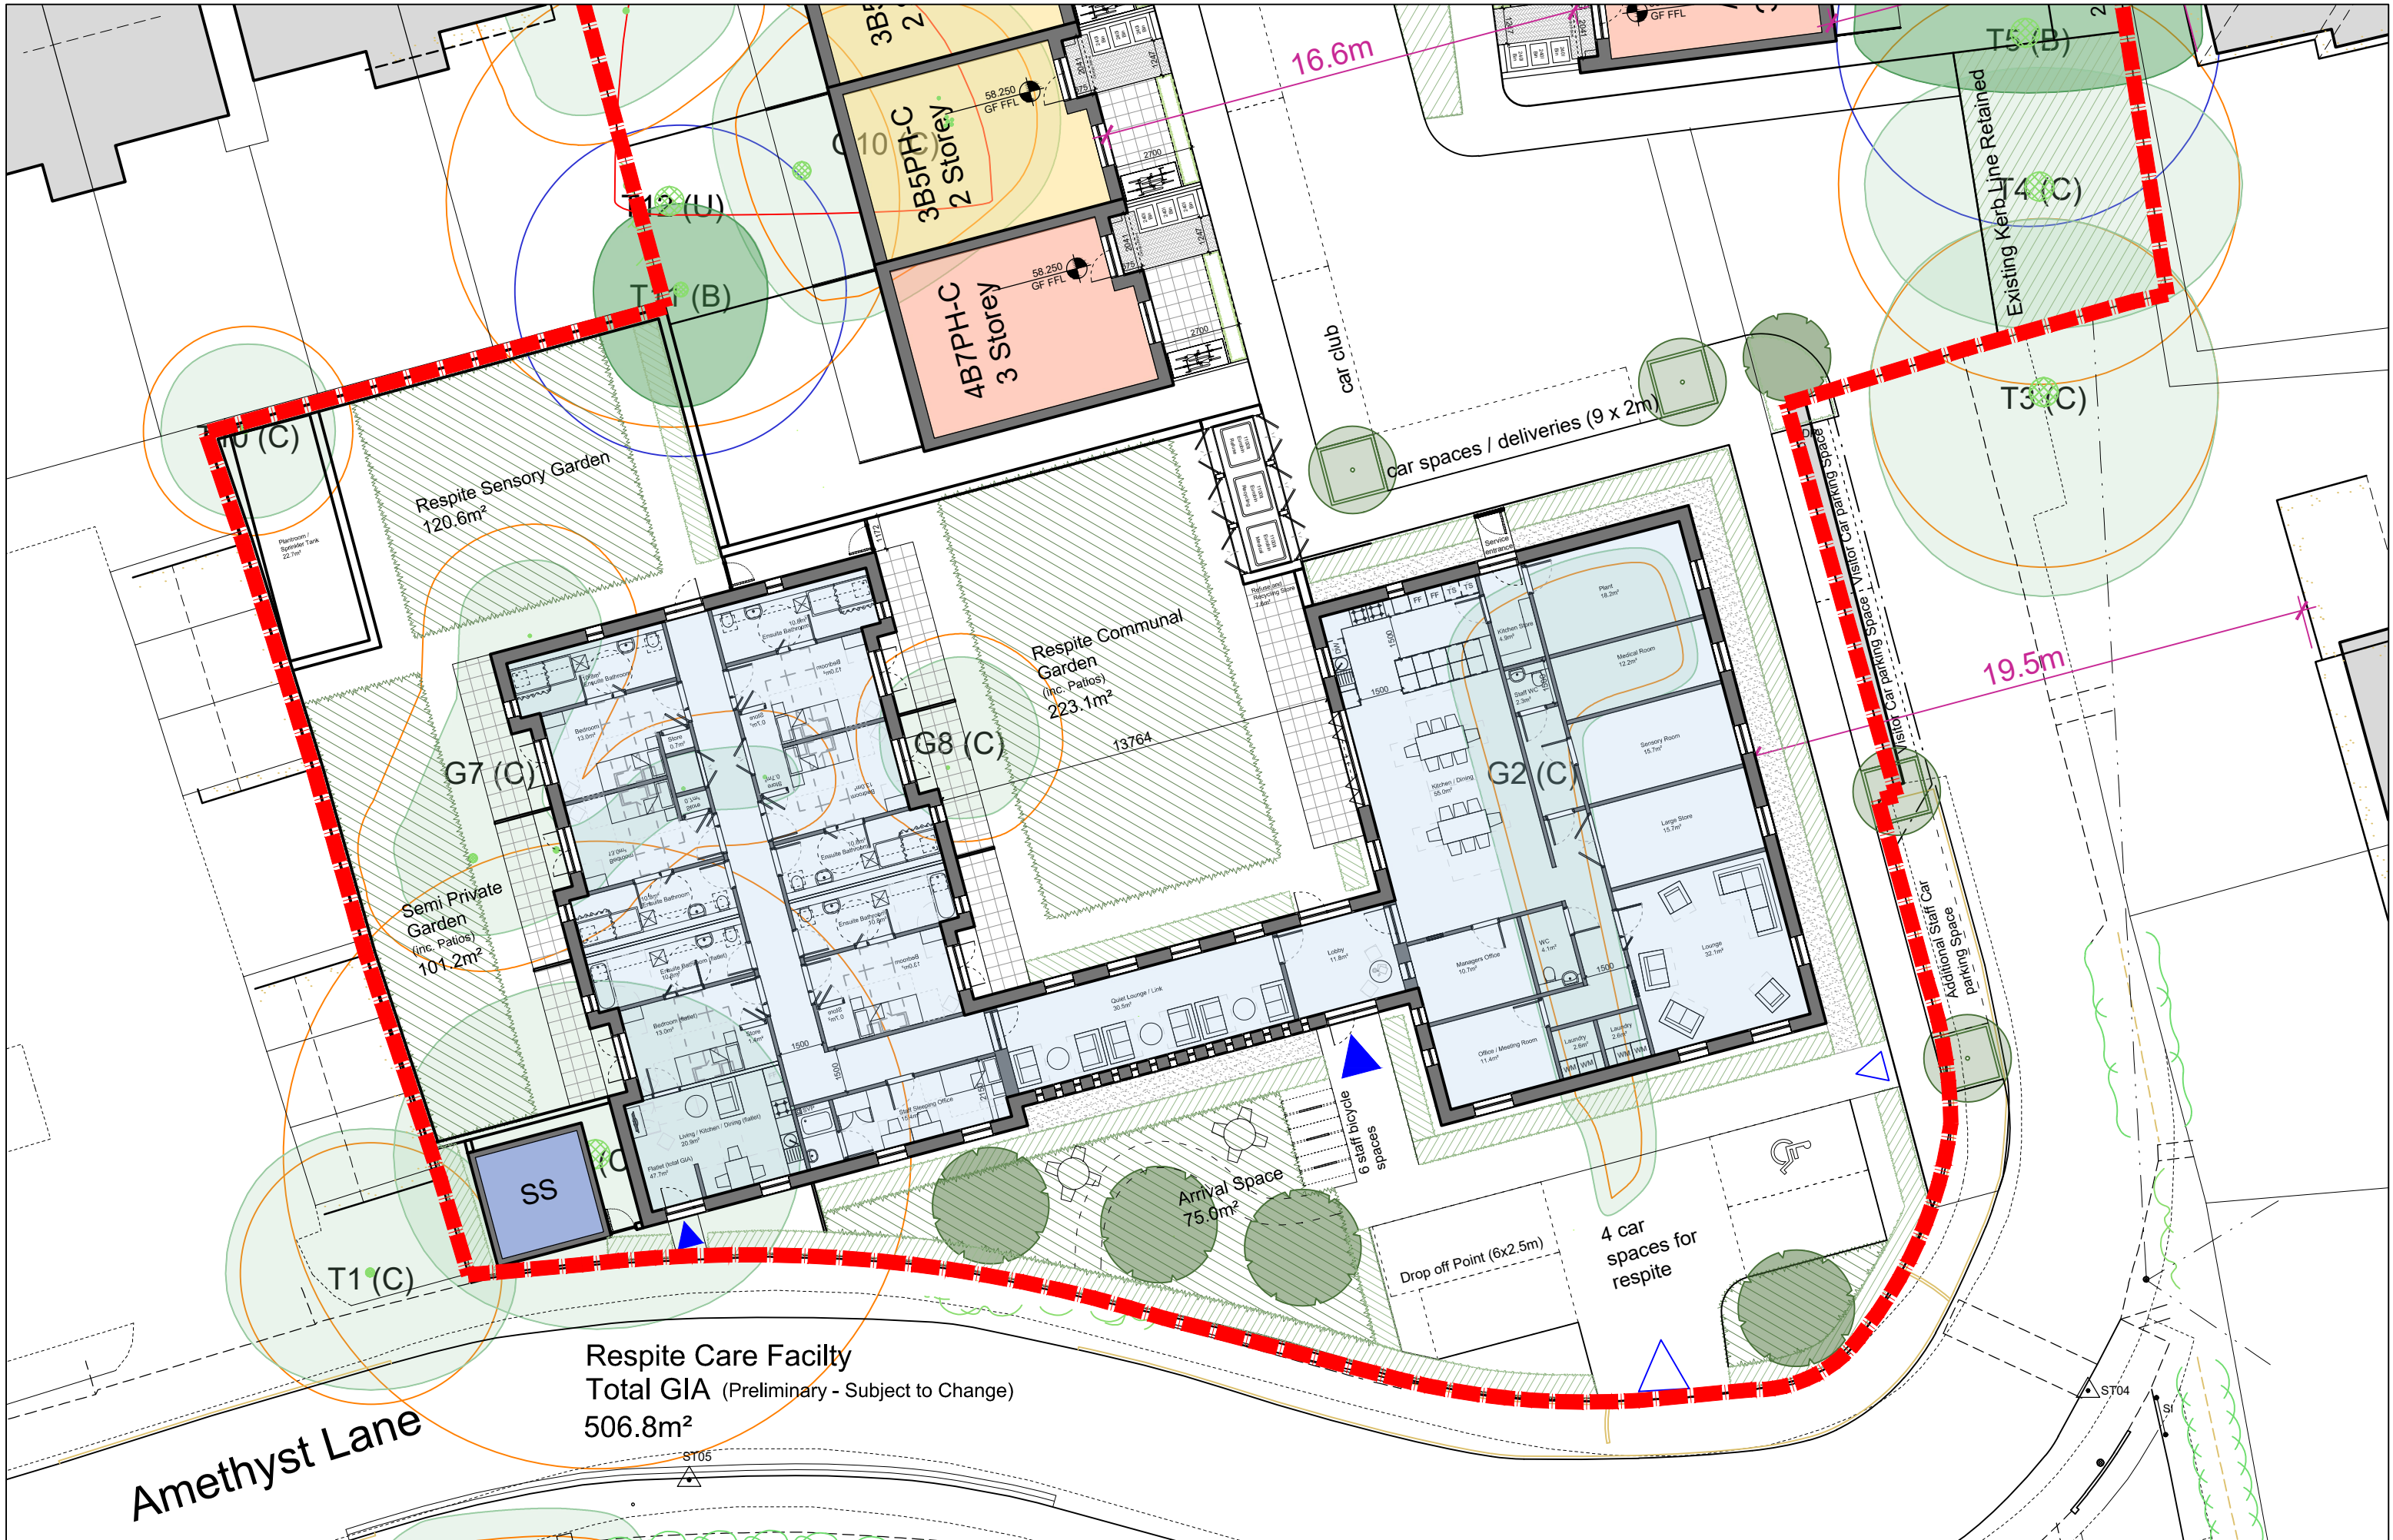



AC	Assumed Connection	DS	Depth To Silt	RE	
AG	Above Ground	DTB	Depth To Base	SA	
AK	Assumed Route	DTW	Depth To Water	SB	
AL	Base Level	DTS	Depth To Surface	SC	
BL	Base Level	ED	External Backdrop	TF	
CB	Concrete Bending	EQI	End Of Trace	UT	
CBC	Circular Brick Chamber	ESD	Internal Backdrop	UT	
CC	Circular Concrete Chamber	IL	Invert Level	UT	
CL	Cover Level	OH	Overhead	UT	
CPC	Circular Plastic Chamber	PD	Pearl Depth Response	UT	
CL	Cover Level	PD	Pearl Depth Response	UT	
CU	Camera Under Water	RB	Real Bend	UT	

PAS 128: 2014 QUALITY LEVEL GUIDE

Q-LEVEL	DESCRIPTION	ACC.	Q-LEVEL	DESCRIPTION
Q1-D	Service positions taken from records.	Disproved	Q1-B2	Horizontal & vertical location using only one geophysical technique.
Q1-C	Visual evidence of service existence but undetectable by geophysical technology.	Disproved	Q1-B1	Horizontal & vertical location using multiple geophysical techniques.
Q1-B4	Undetectable service present shown as an assumed route. (CPR)	Not a source of risk	Q1-A	Horizontal & vertical position verification by open excavation, manholes and/or inspection chambers.
Q1-B3	Horizontal location by one geophysical technique but with some or poor depth information.			

DETECTION METHOD IN ACCORDANCE WITH PAS 128: 2014 SURVEY TYPE B

DRAINAGE SURVEY

All accessible Manholes and Inspection chambers have had their respective covers lifted with pipe sizes, inverts, chamber sizes/types and service data recorded from ground level. All connections from DPs, Gullies, Drains, VPs, RE's and manholes have been proven wherever possible using audible connections (AC) and/or sonde instrumentation where applicable. Where these methods have proved unsuccessful then assumed (AR) straight line connections will be shown.

CCTV DRAINAGE SURVEY

All accessible Manholes and Inspection chambers have had their respective covers lifted with pipe sizes, inverts, chamber sizes/type and service data recorded from ground level. Pipework has been traced, accessed and collected for post processing. Drainage layout, including manhole covers not located by topographical survey, may be taken from CCTV chainage and will be shown as indicative only.

Electricity

Elec cables will have been predominantly located using EML methodology with electronically derived depths shown. GPR techniques will be employed to achieve greater quality levels as required.

British Telecoms

BT cables will have been predominantly located using EML methodology with electronically derived depths shown. GPR techniques will be employed to achieve greater quality levels as required. Due to current laws and legislation protecting all BT apparatus, cabling can only be located remotely. We therefore compare all our telecom findings against record information to produce the final service layout. In some instances, where high amount of cable ducts are present, we may only be able to identify a linear centre peak signal rather than identifying all the individual duct positions. For further information regarding Telecoms apparatus, please contact Openreach directly.

Cable TV & Communications

Cable TV and/or Com cables will have been predominantly located using EML methodology with electronically derived depths shown. GPR techniques will be employed to achieve greater quality levels as required.

Fibre Optic

FO cables will have been predominantly located using GPR methodology. This is due to the materials used within fibre optic cabling. In some rare instances, tracer cabling or conductible non fibre optic cabling will be present within some or all ducting. When this is the case, both EML and GPR methodology will be combined to identify service network and achieve greater quality levels.

Lighting, Traffic Signal & Security Cables

LC, TS and/or Sec cables will have been predominantly located using EML methodology with electronically derived depths shown. GPR techniques will be employed to achieve greater quality levels as required.

Gas & Water Inc. Fuel Pipes and Hot Water Pipes

GM/GS and/or VMWS pipe work will have been attempted and located using both EML & GPR methodology with electronically derived depths shown for the former and depths to crown levels shown for the latter. When the Gas/Water pipe work is constructed using conductible materials, then we are able to employ multiple geophysical techniques to identify service network and achieve greater quality levels. When a non conductible material is used, GPR methodology will be employed to locate and plot the final service layout.

Ground Penetrating Radar

GPR methodology is used to identify and locate all non metallic, non conductible piping and cabling. We also employ GPR to obtain a greater accuracy levels on EML located services. The GPR has a greater success rate on pipe or service diameter upward of Ø63mm, Ø63mm, as size increments increase, so does the chance of detection. The GPR can produce varying results and as such, wouldn't be used as an independent utility surveying instrument.

Unidentified Traces

All UTs will have been predominantly located using EML methodology with electronically derived depths shown. GPR techniques will be employed to achieve greater quality levels as required. Every effort has been made to identify the service but in this instance, is not achievable. We recommend excavation work to determine identity and depth where applicable.

Scarring (Q1-C)

Scarring has been identified on site with a potential of an undetectable service present.

Assumed Routes & Taken from Records (Q1-B4/D)

Assumed routes (AR) are shown if there is evidence that a service exists but we are unable to trace it whilst on site. The surveyor will attempt to locate various (service evidence) etc. around site area to successfully determine an assumed route between these points. If there is little evidence on site but they believe a service is still present, then a common sense approach to an assumed route shall be employed.

Taken from records (TFR) are service routes that are taken from STAT record plans or previous survey information and overlaid onto our drawings.

SURVEY RECOMMENDATIONS


The areas of dense vegetation to be cleared to allow access if any of these areas are deemed critical or of high importance.

To undertake a CCTV drainage survey of the entire site area to establish a more comprehensive drainage network, and asset condition of the pipework.

The sewers with high levels of silt or blockages to be jetted to extend the CCTV drainage survey, if any of these areas are deemed critical or of high importance.

We recommend full statutory record information be obtained to confirm site findings and to position undetectable which may be present.

Due to the geophysical nature of subsurface technology, we always recommend excavation works to be carried out within critical areas for verification and to eliminate the possibility of undetectable services present.

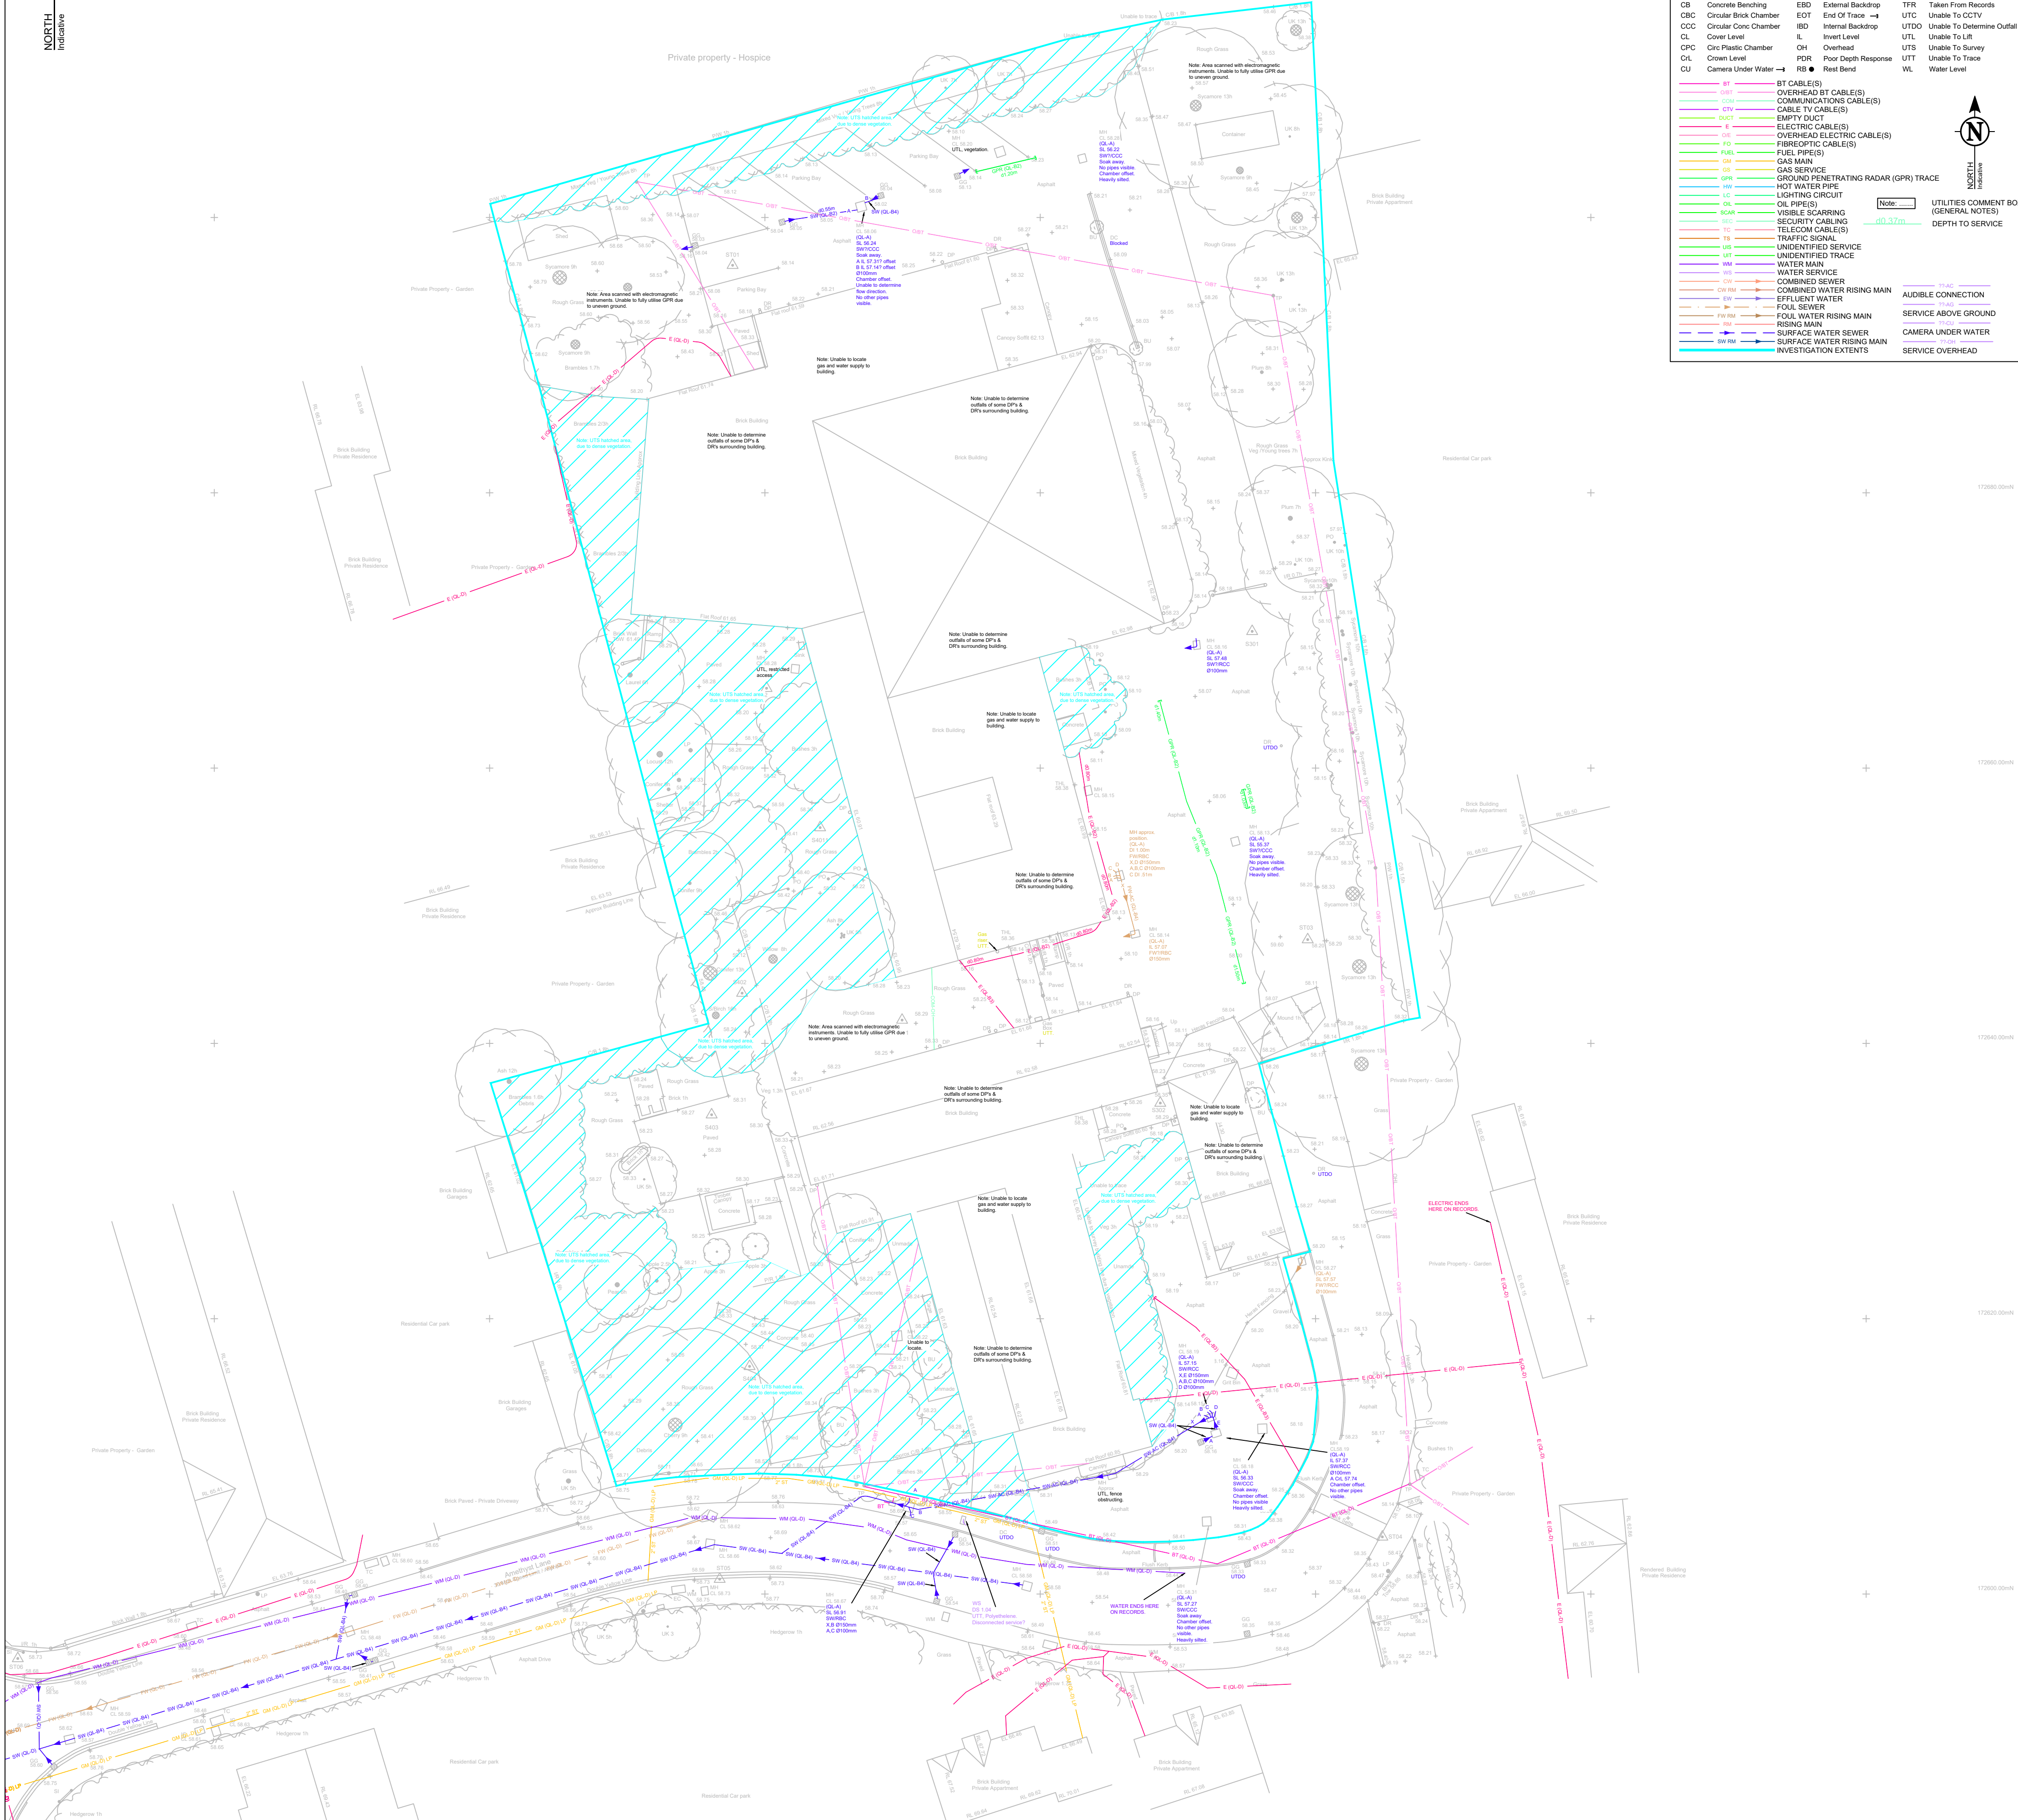

UTILITIES & UNDERGROUND INVESTIGATIONS

ABBREVIATIONS & SYMBOLS

1D SC 1 Duct & Cables	DCI	Depth To Crown	RBC	Rectangular Brick Chamber	
Ø	Diameter	DI	Depth To Invert	RCC	Rectangular Concrete Chamber
AC	Audible Connection	DS	Depth To Silt	RE	Rodding Eye
AG	Above Ground	DTB	Depth To Base	SA	Survey Abandoned
AR	Assumed Route	DTW	Depth To Water	SL	Silt Level
BL	Base Level	DTS	Depth To Surcharge	SuL	Surcharge Level
CB	Concrete Batching	EBD	External Backdrop	TFR	Taken From Records
CBC	Circular Brick Chamber	EDT	End Of Trace →	UTC	Unable To CCTV
CCC	Circular Concrete Chamber	IBD	Internal Backdrop	UTDO	Unable To Determine Outfall
CL	Cover Level	IL	Invert Level	UTL	Unable To Lift
CPC	Circ Plastic Chamber	OH	Overhead	UTS	Unable To Survey
CU	Crown Level	POR	Poor Depth Response	UTT	Unable To Trace
Camera Under Water →	RB	Rest Bend	WL	Water Level	

BT CABLES)

OVERHEAD BT CABLES)

COMMUNICATING CABLES)

CABLE TV CABLES)

EMPTY DUCT)

ELECTRIC CABLES)

OVERHEAD ELECTRIC CABLES)

FIBROPTIC CABLES)

FUEL PIPE(S)

QAS MAIN)

GAS SERVICE)

GROUND EXTRINSIC RADAR (GPR) TRACE)

HOT WATER PIPE)

LIGHTING CIRCUIT)

OL PIPE(S)

VISUAL SCANNING)

TELEPHONE CABLEING)

TELECOM CABLE(S)

TRAPIC SIGNAL)

UNIDENTIFIED SERVICE)

UNIDENTIFIED TRACE)

WATER MAIN)

WATER SERVICE)

COMBINED WATER RISING MAIN)

EFFLUENT LINE)

FOUL SEWER)

QAS WATER RISING MAIN)

ROILING SEWER)

SURFACE WATER RISING MAIN)

SURFACE WATER SEWER)

INVESTIGATION EXTER

UTL

UTS

UTDO

UTL

UTS

UTDO

UTL

 
UTS

UTDO

UTL

UTS</

BT CABLE(S)
OVERHEAD BT CABLE(S)
CABLE TV CABLE(S)
EMPTY DUCT
ELECTRIC CABLE(S)
OVERHEAD ELECTRIC CABLE(S)
FIBRE OPTIC CABLE(S)
FUEL PIPES
GAS MAIN
GAS SERVICE
GROUND PENETRATING RADAR (GPR) TRACE
HOT WATER PIPE
LIGHTING CIRCUIT
OIL PIPE(S)
VISIBLE SCARRING
SECURITY CABLE(S)
TELECOM CABLE(S)
TRAFFIC SIGNAL
UNIDENTIFIED SERVICE
UNIDENTIFIED TRACE
WATER MAIN
WATER SERVICE
COMBINED SEWER
COMBINED WATER RISING MAIN
EFFLUENT WATER
FOUL SEWER
FOUL WATER RISING MAIN
RISING MAIN
SURFACE WATER SEWER
SURFACE WATER RISING MAIN
INVESTIGATION EXTENTS



UTILITIES & UNDERGROUND INVESTIGATIONS

DRAWING NOTES

All below ground details shown have been identified from above ground without excavation. Survey Solution use electro-magnetic and/or ground penetrating radar (GPR) methods to investigate for underground utilities, services and features. Results using these methods are not infallible and we recommend trial excavations are carried out to confirm any identifications, positions and depths.

Any areas on the drawing where services or features have not been shown are not necessarily clear of services or features but are an indication that no items have been identified during our investigations. All reasonable care and normal good practice should still be employed during design and construction processes.

Certain types of services such as plastic or concrete pipes, some conduit and ducting where direct access can not be achieved for tracing may not be shown and alternative locating methods should be used.

Survey Solutions has used all reasonable care to research available service records but the completeness or use of the service records supplied to or by Survey Solutions cannot be guaranteed. Therefore Survey Solutions cannot be held responsible for any features annotated as 'taken from records' (TFR).

Depths obtained using electro-magnetic or GPR are effected by ground conditions and should be treated as indicative only. Electro-magnetic depths to utilities and services are generally taken to the centre of a feature. GPR depths to the top of a feature and drainage depth shown to inverts, unless otherwise indicated.

Drainage pipe sizes will be obtained without entering the chamber and therefore should be treated as approximate. Pipe dimensions which have not been obtained visually will be taken from records when available.

All services, drainage and utilities routes are assumed straight between access points, unless otherwise stated. The numbers of cables in runs will not be shown unless specifically requested. All services are below ground unless indicated.

Services, utilities and features may not have been surveyed if obstructed or not reasonably visible or accessible at the time of survey.

Survey Solutions accept no responsibility for the completeness or accuracy of either the topographical survey or base mapping on this project.

All critical dimensions and measurements should be checked and verified with any errors or discrepancies notified to Survey Solutions immediately. The accuracy of the digital data is the same as the plotting scale implies. All dimensions are in metres unless otherwise stated.

The contractor must check and verify all site and building dimensions, levels, utilities and drainage details and connections prior to commencing work.

© Land Survey Solutions Limited hold the copyright to all the information contained within this document and their written consent must be obtained before copying or using the data other than for the purpose it was originally supplied.

Do not scale from this drawing.

GENERAL SYNOPSIS

This survey has been carried out in accordance with PAS 128: 2014 & our version of the Royal Institution of Chartered Surveyors (RICS) specification for Measured Surveys of Land, Buildings and Utilities. Our survey extents have been agreed and confirmed with formal acceptance of 43954BWUG from Gleds Management Services Ltd. If you have any queries regarding the final services layout, please may we ask you to carefully read all the information within this title block in its entirety before continuing to do so.

TOPOGRAPHICAL/DWG DRAWING INFORMATION

TOPOGRAPHICAL SURVEY DATE 19/08/2022

SURVEY TYPE	DESCRIPTION	EFFECT ON SURVEY RESULTS
TOPO	Survey Solutions	None
OUTDATED		
OS		
NTS		

GENERAL SITE CONDITIONS

ADDITIONAL INFORMATION	EFFECT ON SURVEY RESULTS

DESKTOP UTILITY RECORDS (PAS 128: 2014 SURVEY TYPE D)

PREREQUISITE FOR PAS 128: 2014 SURVEY TYPE B

COMMISSIONED: NO

UTILITY	AVAILABILITY	UTILITY COMPANY PROVIDER
SEWER	NO	N/A
WATER MAIN	NO	N/A
GAS MAIN	NO	PUBLIC
TELECOM	NO	N/A
CABLE TV	NO	N/A
ELECTRICITY	NO	N/A
OIL PIPES	NO	N/A
OTHER	NO	N/A

A	UTILITY RECORDS ADDED.	RJB	JAB	GSB	31/10/2022
REV	DESCRIPTION	DRAWN	CHECKED	APPR	SURVEY DATE

SURVEY SOLUTIONS

LAND SURVEYING
BUILDING SURVEYING
UNDERGROUND SURVEYING
SITE ENGINEERING
MONITORING

0845 040 5969
survey-solutions.co.uk

IPSWICH BEDFORD COVENTRY GLASGOW LONDON MANCHESTER NORMICH NOTTINGHAM YEOVIL

PROJECT TITLE AMETHYST LANE, READING, BERKSHIRE, RG30 2EZ.					
DRAWING DETAIL UTILITIES AND DRAINAGE SURVEY. SHEET 1 OF 2					
CLIENT GLEEDS MANAGEMENT SERVICES LTD	SCALE 1:250				
SURVEYOR RJB	SURVEY DATE SURVDATE	CHECKED BY AJM	APPROVED BY GSB	DWG STATUS FINAL	
DRAWING NUMBER 43954BWUG-01	REVISION A		ISSUE DATE 26/09/2022		

