

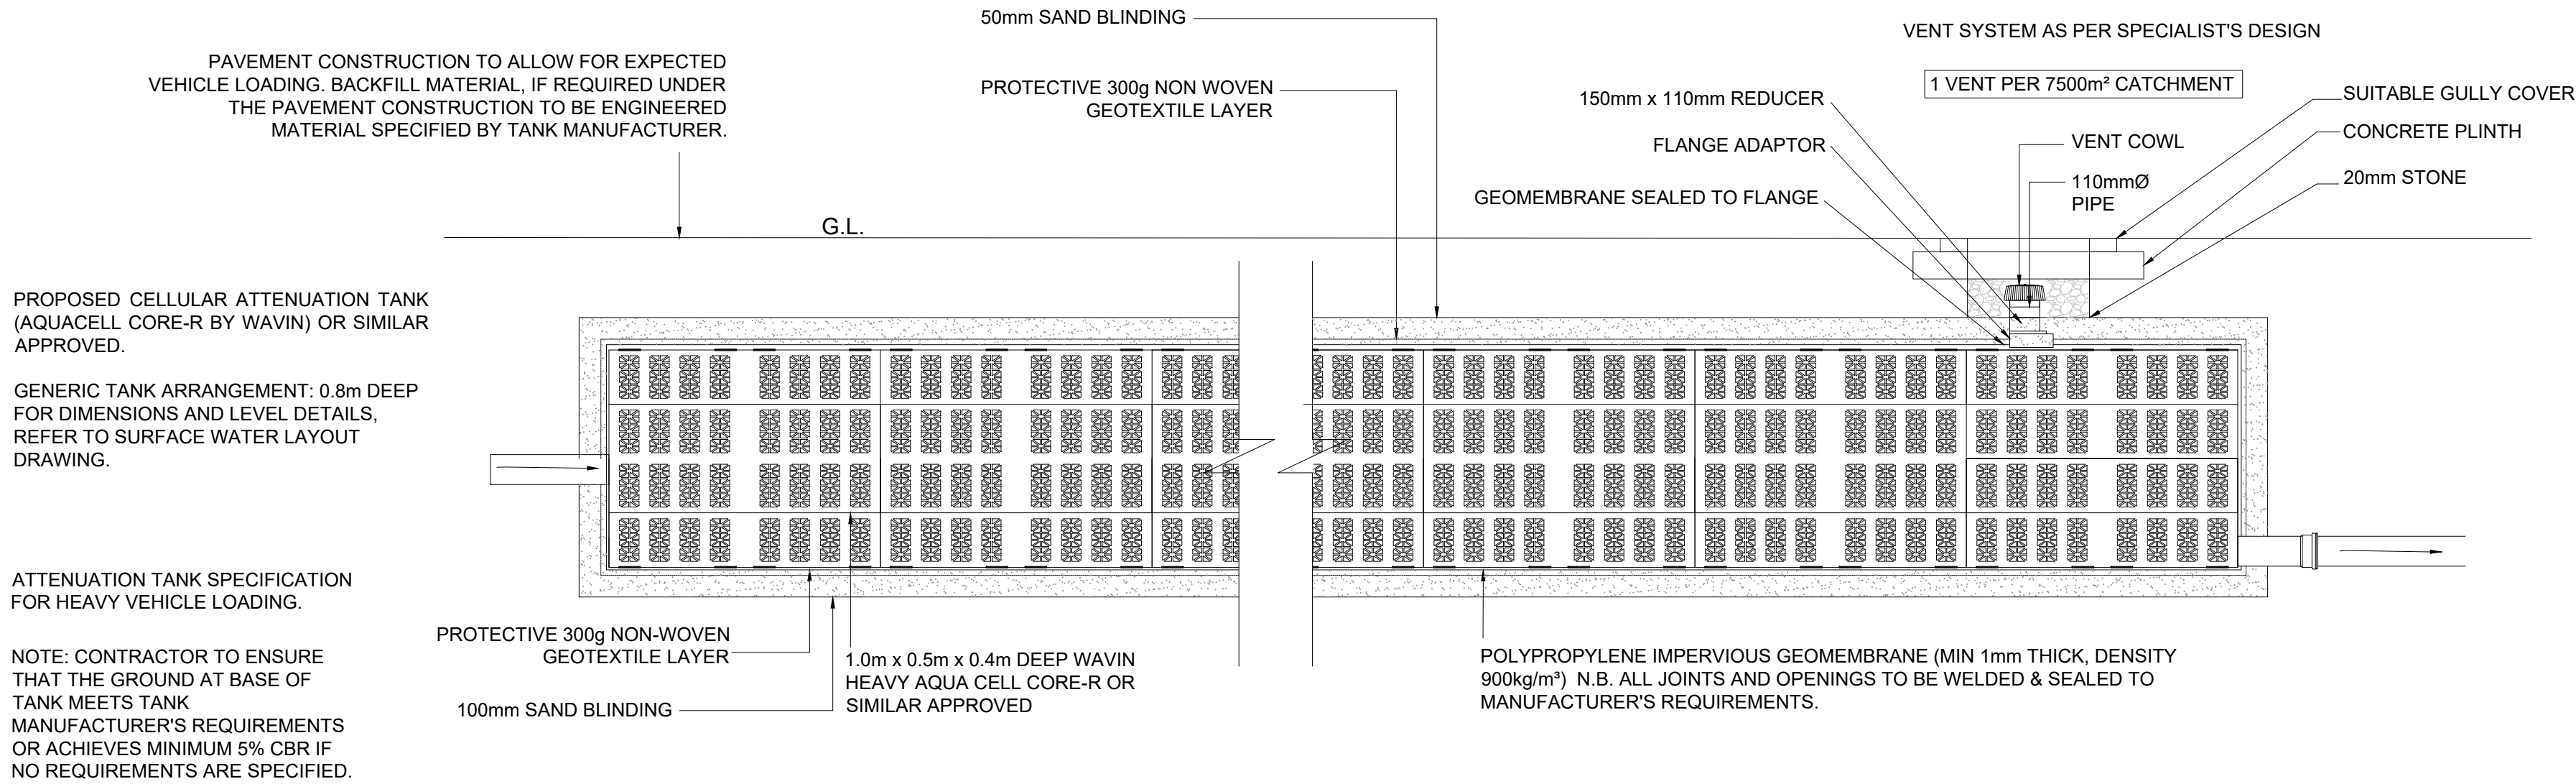
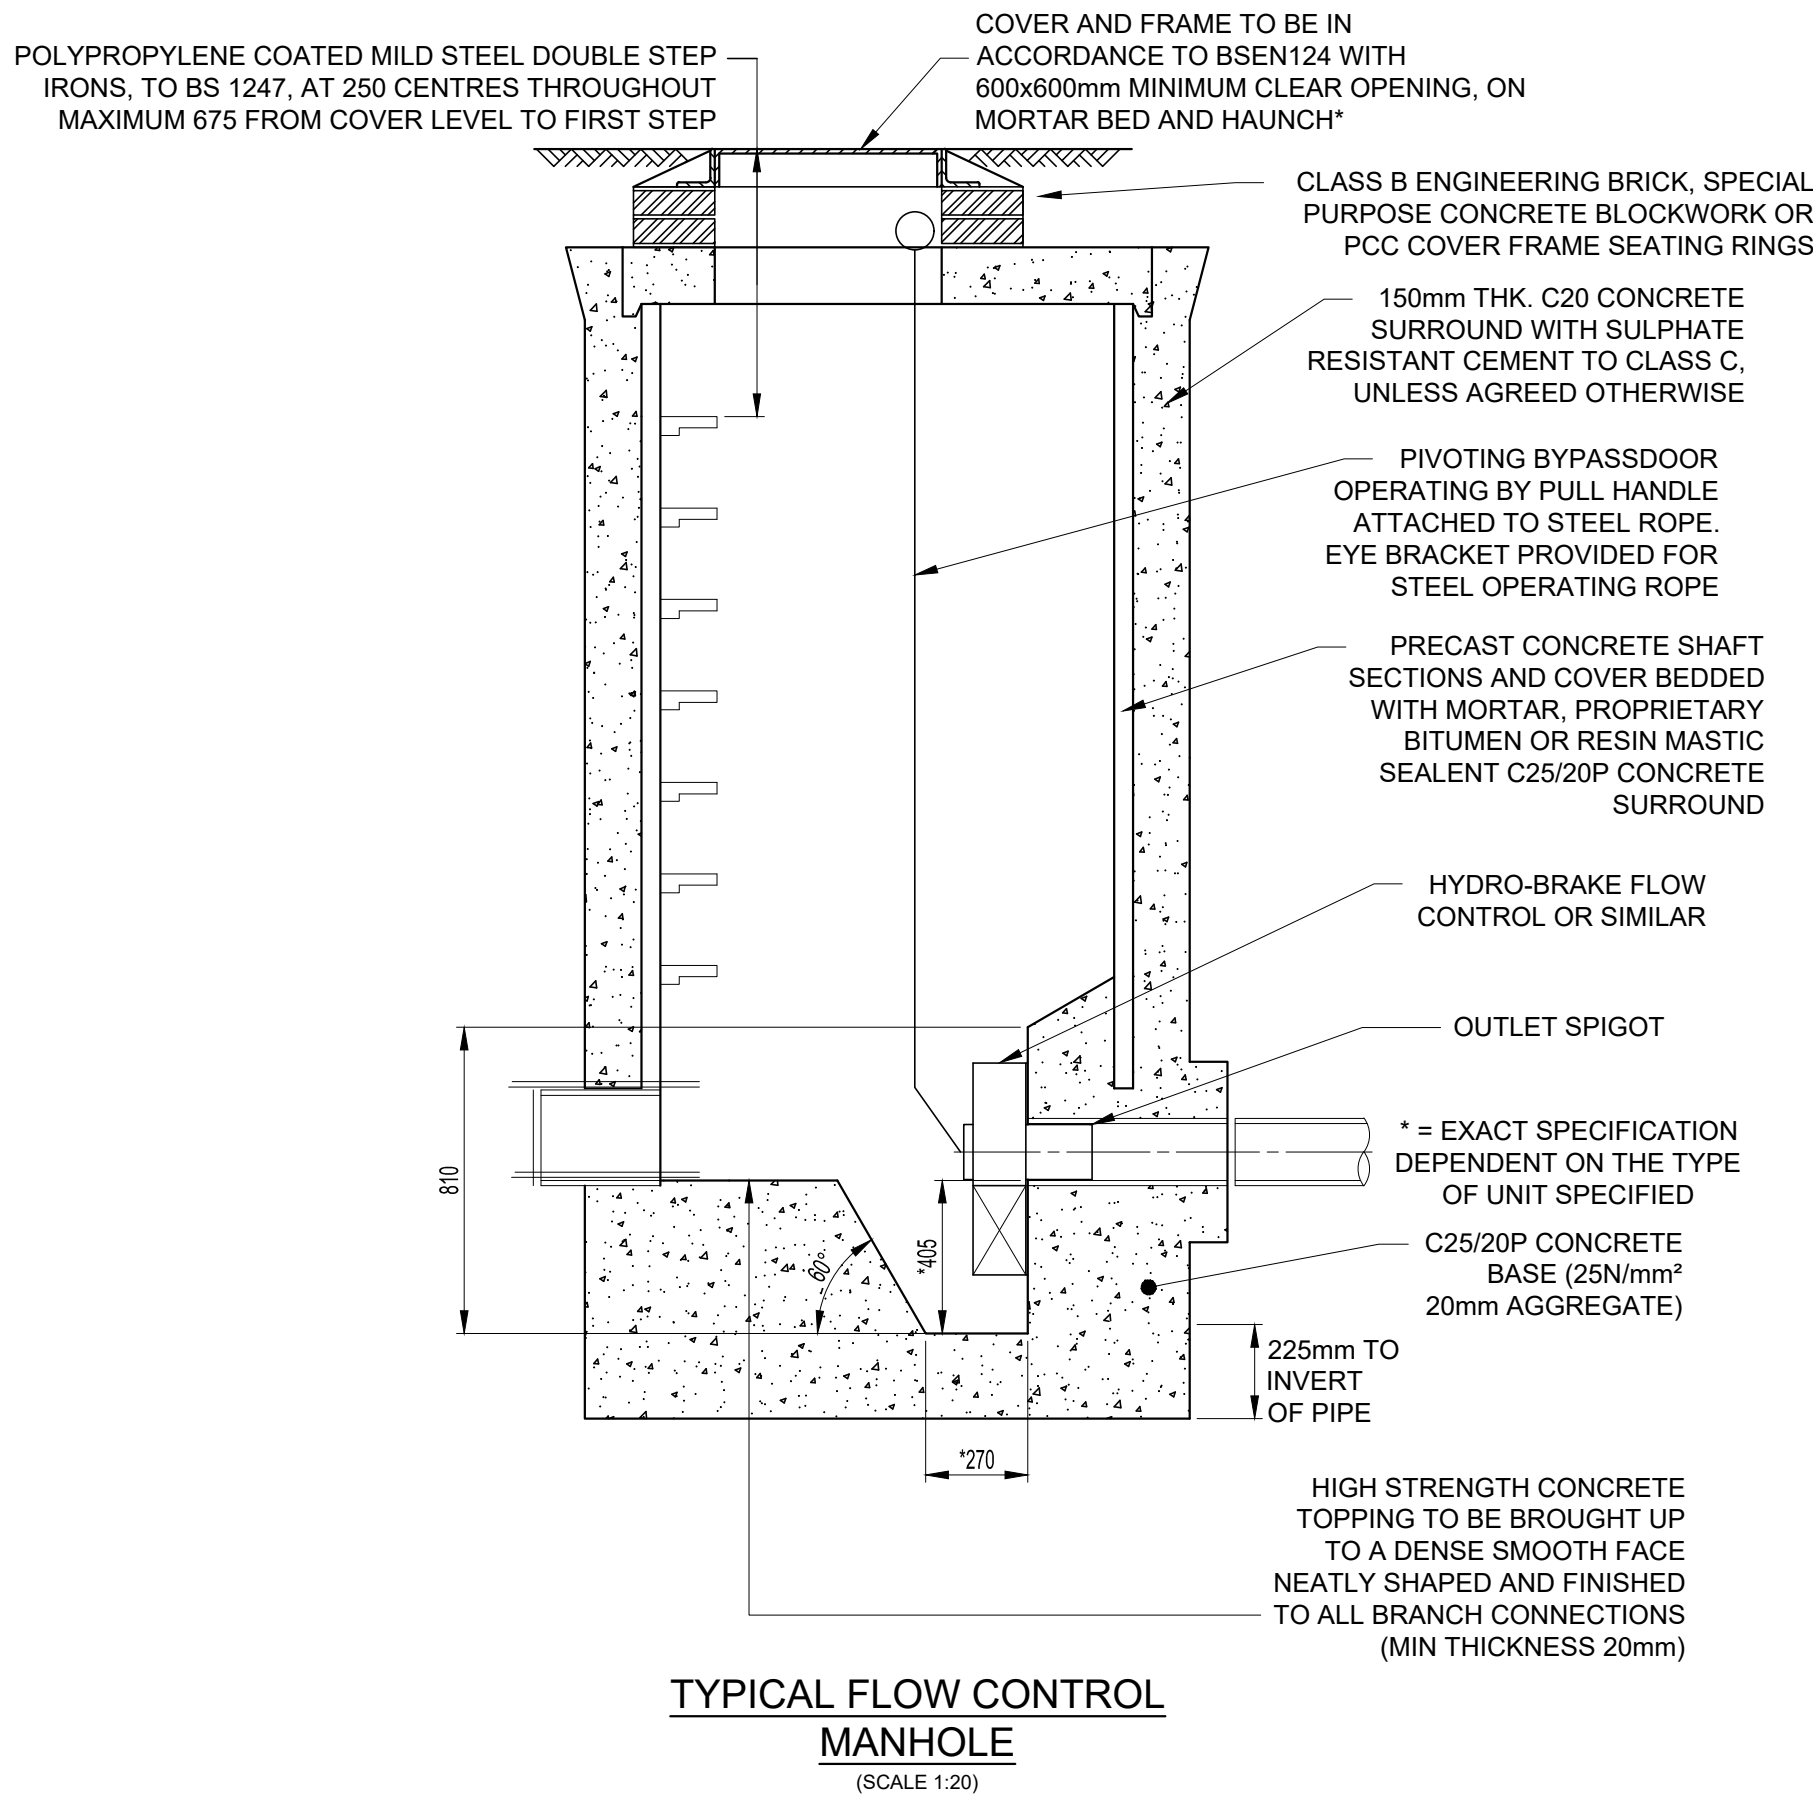
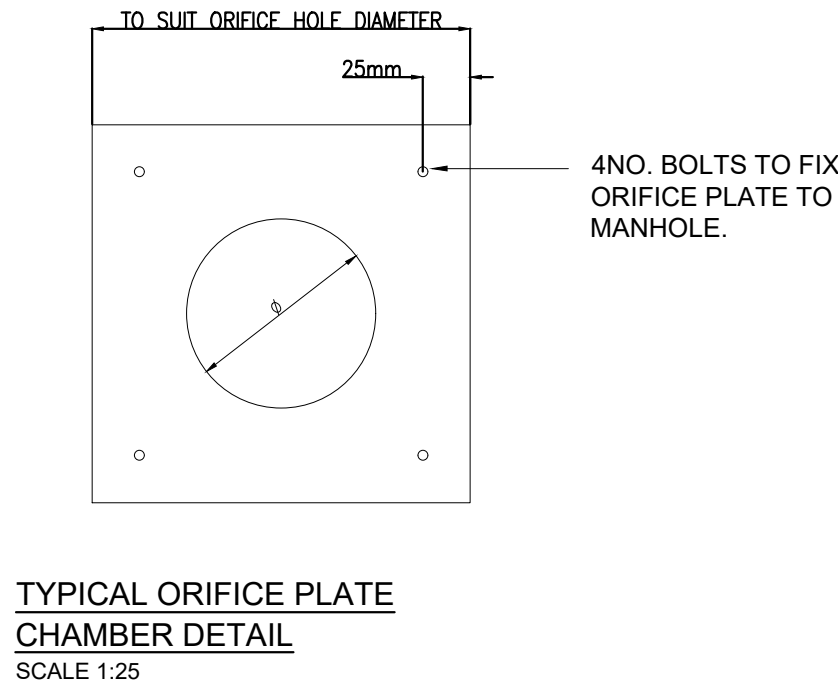


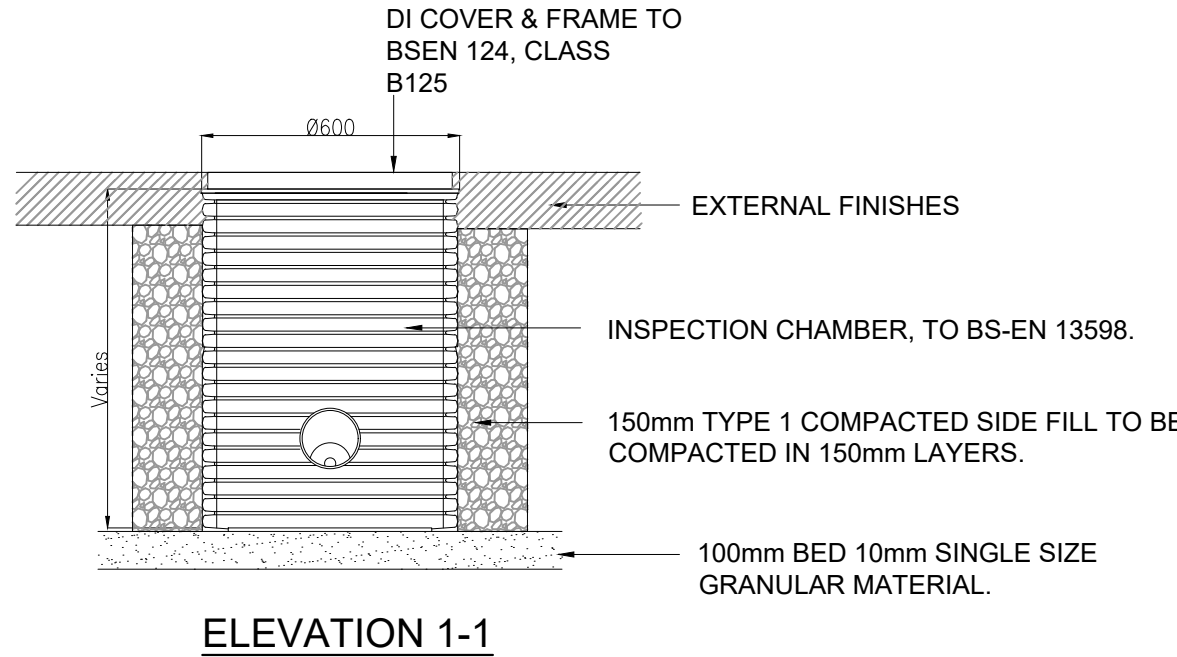


TYPICAL CELLULAR STORAGE TANK
(TYPICAL DETAIL ONLY - REFER TO MANUFACTURER'S PRODUCT SPECIFICATION)
SCALE 1:20

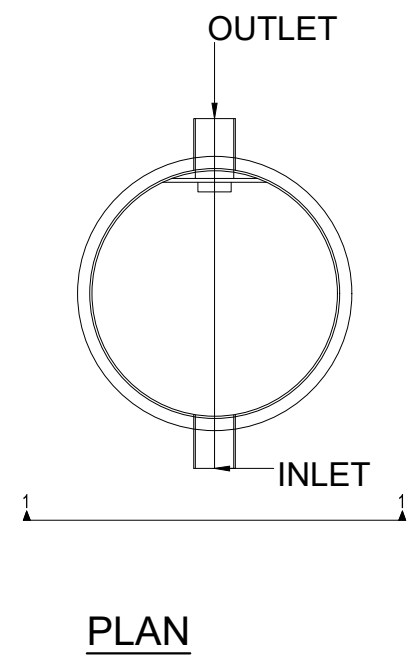

Notes

- Do not scale this drawing. All dimensions must be checked/ verified on site. If in doubt ask.
- This drawing is to be read in conjunction with all relevant architects, engineers and specialists drawings and specifications.
- All dimensions in millimetres unless noted otherwise. All levels in metres unless noted otherwise.
- Any discrepancies noted on site are to be reported to the engineer immediately.

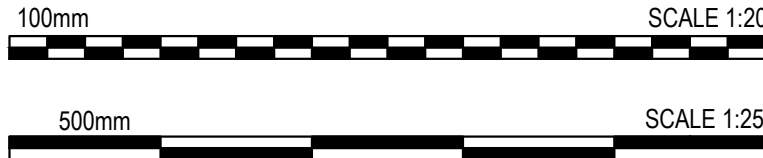

Design Notes

- Refer to 600353-HEX-XX-XX-DR-C-9200-9203 for Surface and Foul Water Drainage Layout.

C01	17/11/22	CONSTRUCTION ISSUE.
P03	12/08/22	DRAFT CONSTRUCTION ISSUE.
P02	22/07/22	AMENDED AS CLOUDED
P01	10/05/22	CONTRACTORS PROPOSALS SUBMISSION
REV	DATE	DESCRIPTION

CLIENT


**Department
for Education**

CONTRACTOR



CONSULTANT



PROJECT

RIVER ACADEMY, READING

DRAWING TITLE

DRAINAGE CONSTRUCTION DETAILS
SHEET 2 OF 2

DRAWING PURPOSE

DRAFT CONSTRUCTION ISSUE

DRAWN BY	DATE	CHK'D BY	SCALE	MEDIA
RV	10.05.22	RV	As Shown	A1
PROJECT - ORIGINATOR - ZONE - LEVEL - TYPE - ROLE - NUMBER				REVISION

FS0949-HEX-XX-XX-DR-C-9205 C01