



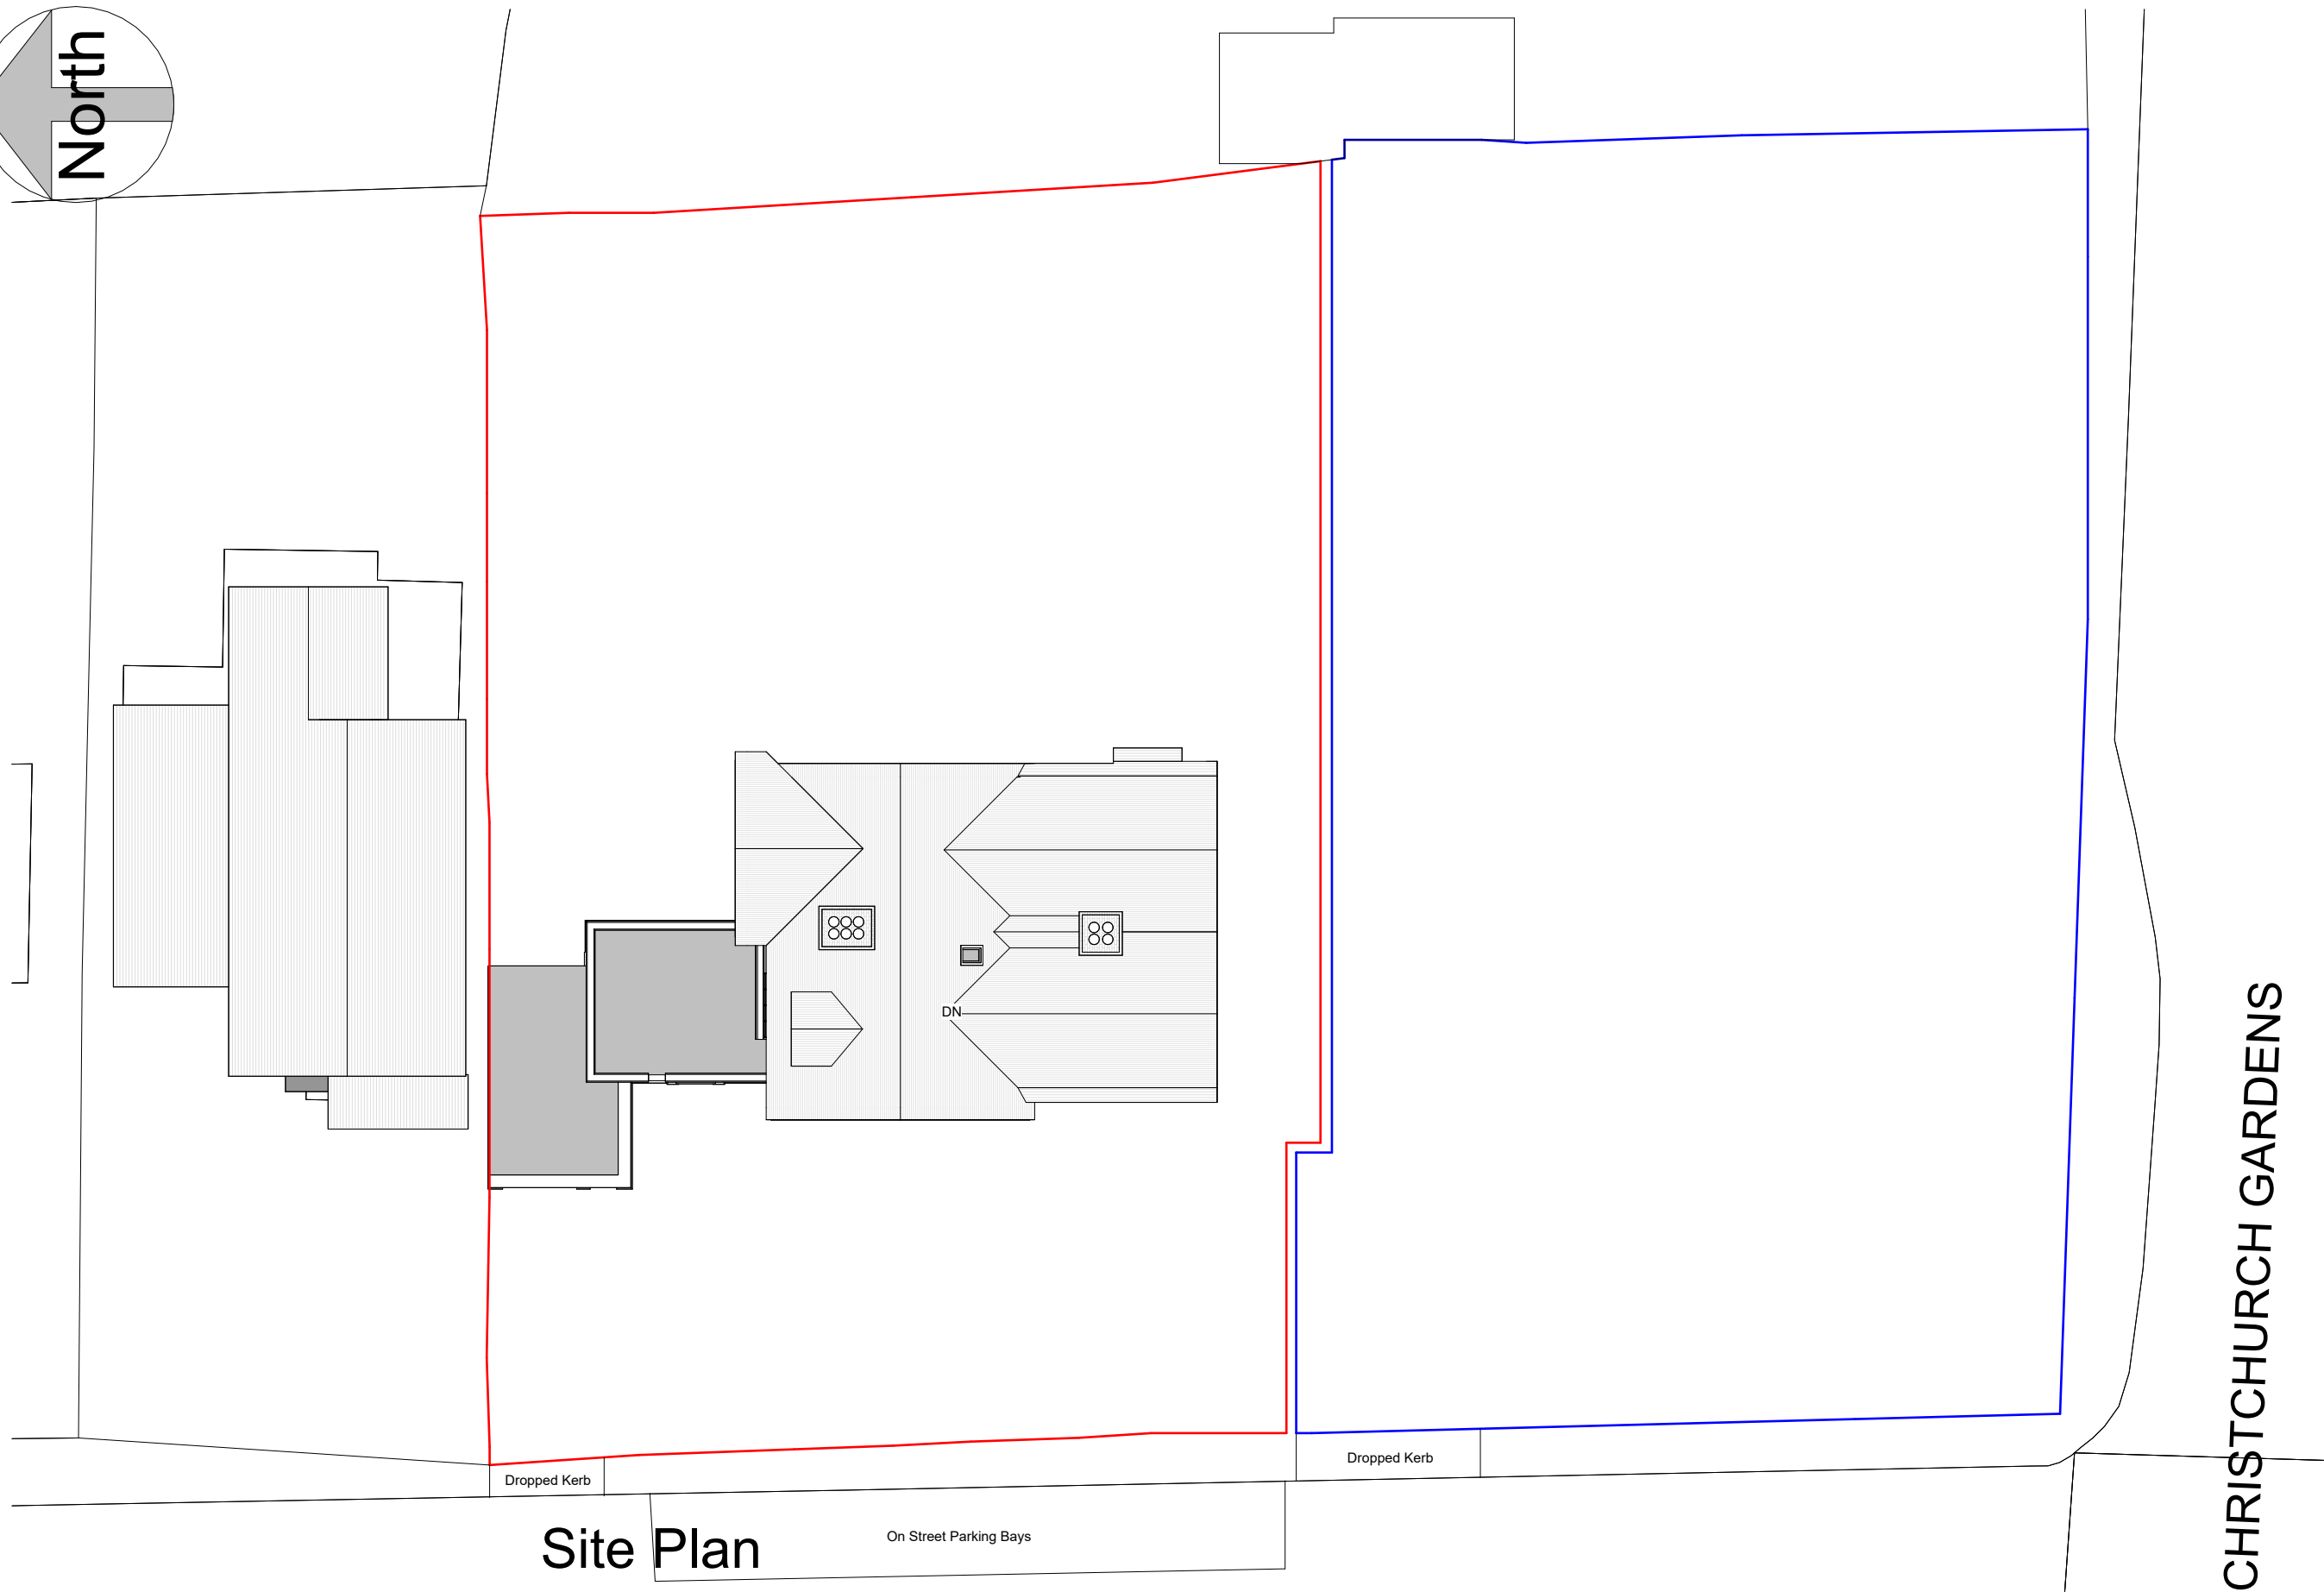

CHRISTCHURCH GARDENS

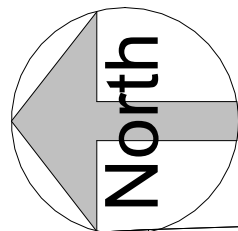

FLUENT
ARCHITECTURAL DESIGN SERVICES
TEL: 0800 043 8838
E-MAIL: INFO@FLUENT-ADS.CO.UK
WEB: FLUENT-ADS.CO.UK

11 Glebe Road, Reading

Existing Site Plan

Scale @ A3
1 : 200

Date
15.05.24

Drawn by
NM

Drawing number
P.M.2.100

Project number
2296

Rev
B

Key:

Existing Proposed SVP Boundary line

Existing drainage Proposed drainage Overhead

0 4 8 12 16 20

GRAPHIC SCALE: 1:200

No.	Description	Date
A	First draft	15.10.24
B	Client's comments (1)	04.11.24