


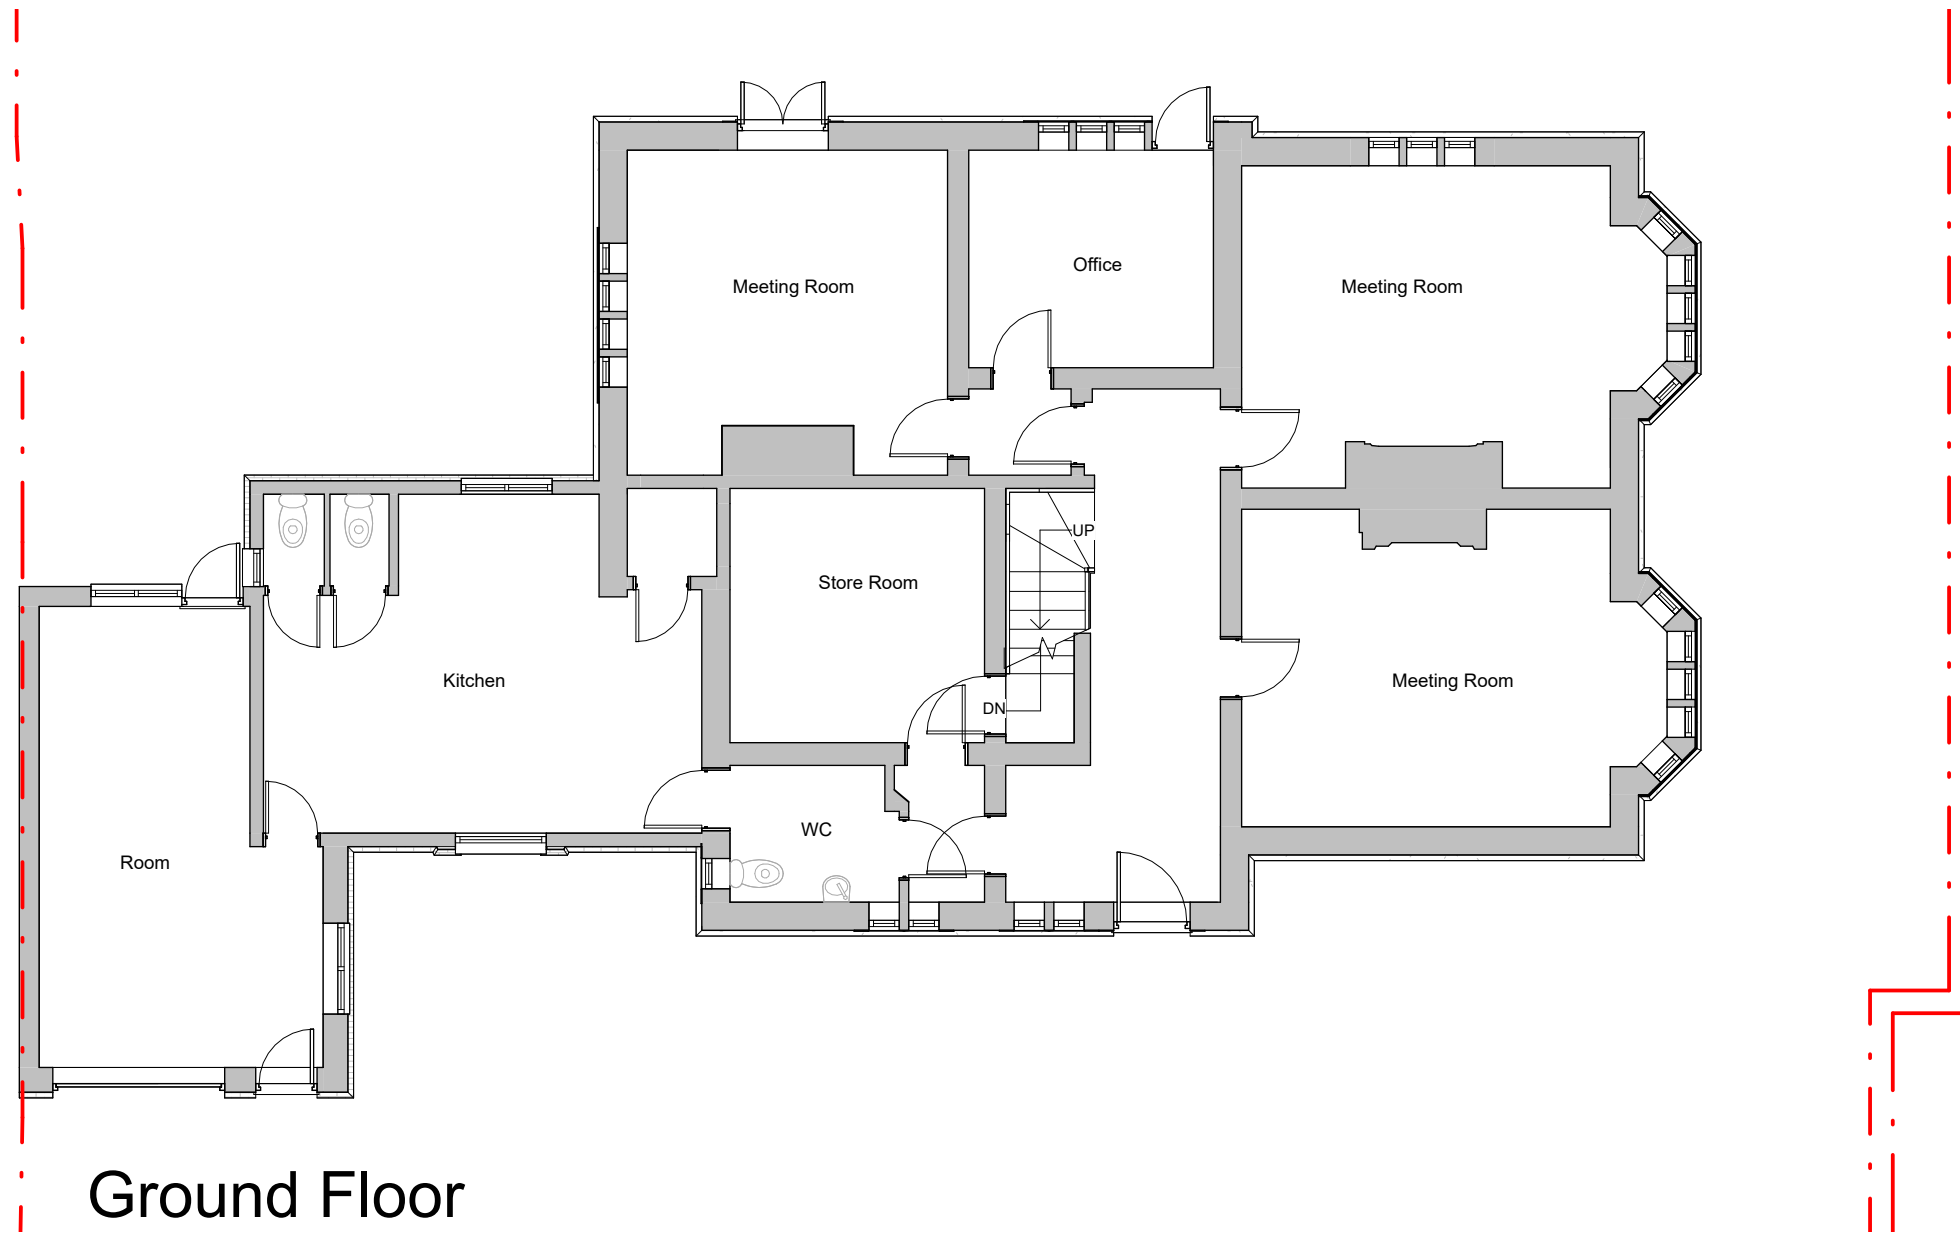

FLUENT
ARCHITECTURAL DESIGN SERVICES
TEL: 0800 043 8838
E-MAIL: INFO@FLUENT-ADS.CO.UK
WEB: FLUENT-ADS.CO.UK

11 Glebe Road, Reading

Existing Ground Floor Plan

Scale @ A3
1 : 100

Date
15.05.24

Drawn by
NM

 
Drawing number
P.M.2.200

Project number
2296

Rev
B

Key:

Existing Proposed SVP Boundary line
Existing drainage Proposed drainage Overhead



No.	Description	Date
A	First draft	15.10.24
B	Client's comments (1)	04.11.24