


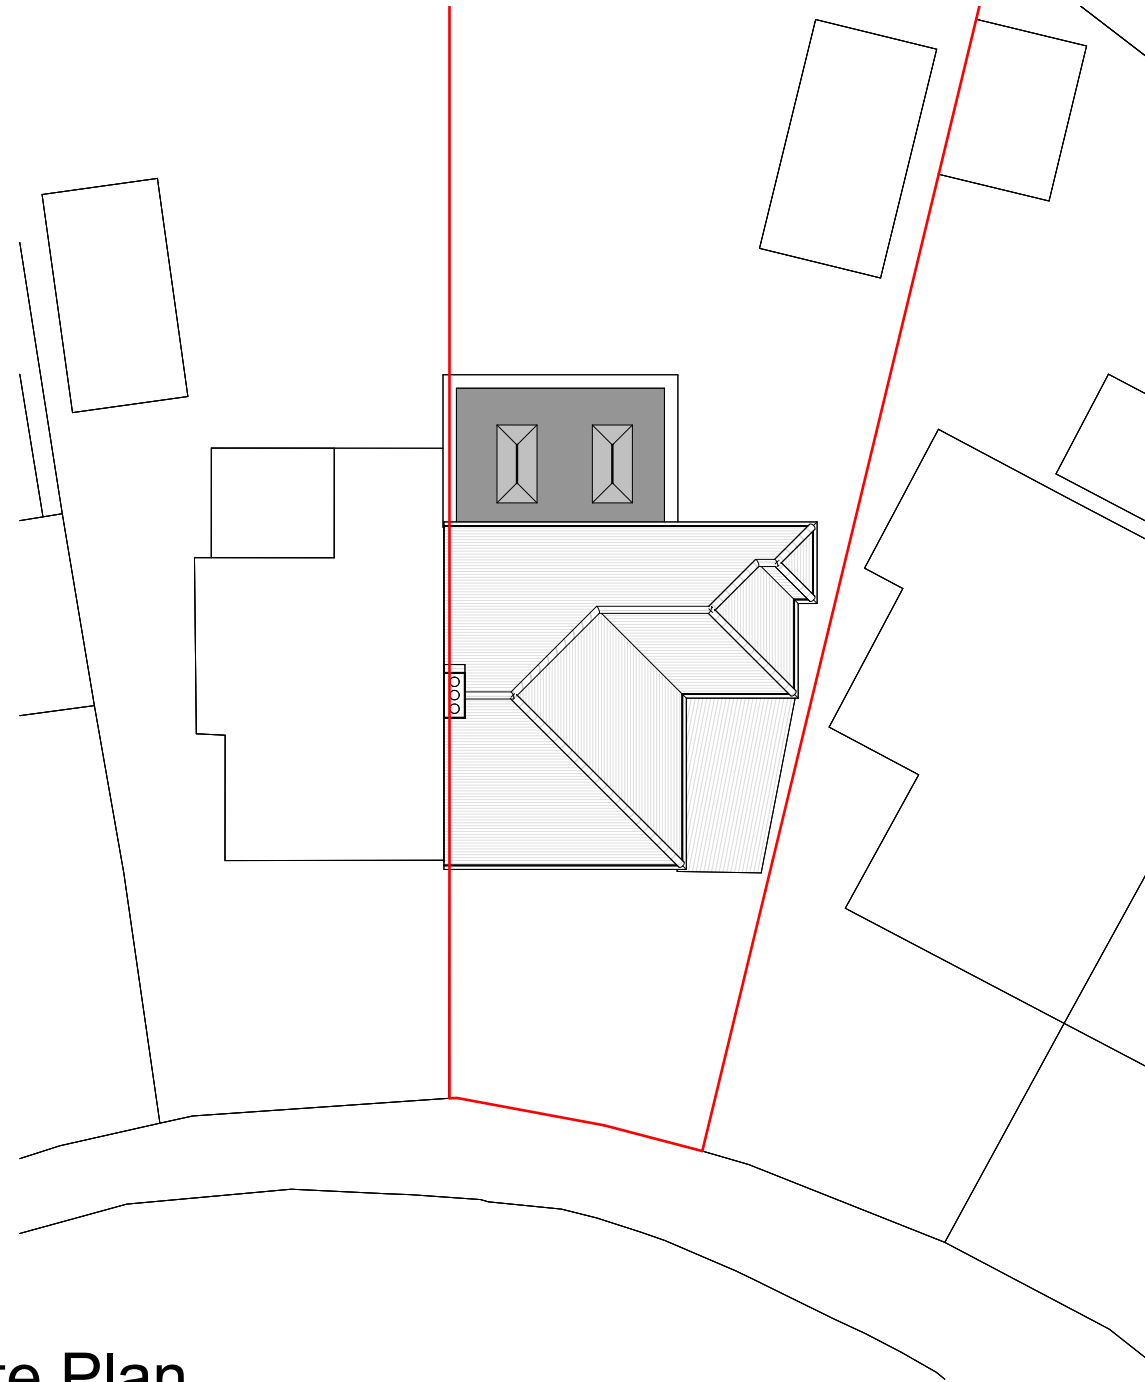


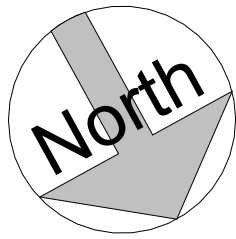

Site Plan

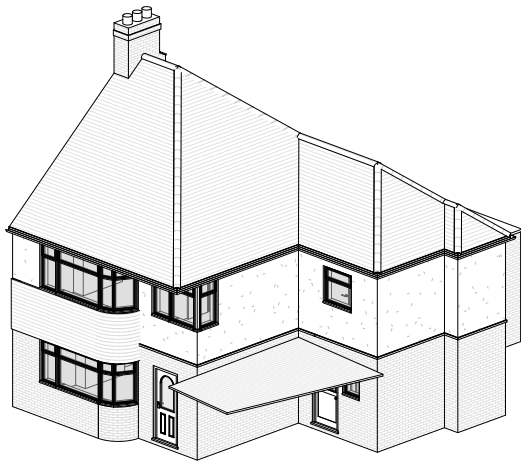

3D View 1

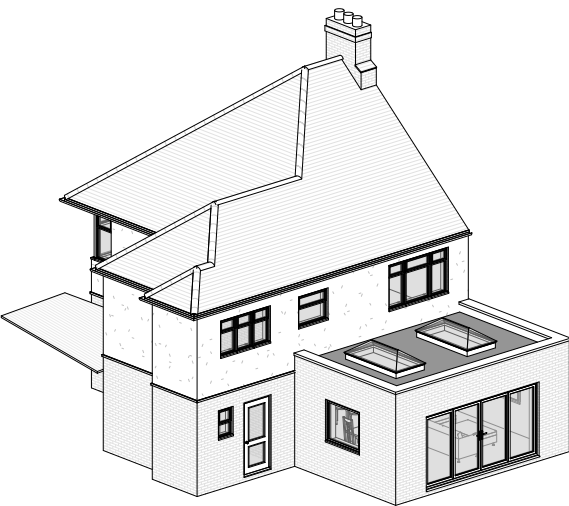

3D View 2

 FLUENT ARCHITECTURAL DESIGN SERVICES TEL: 0800 043 8838 E-MAIL: INFO@FLUENT-ADS.CO.UK WEB: FLUENT-ADS.CO.UK	11 Mayfield Drive. Reading RG4 5JP	Scale @ A3 1 : 200	Drawing number P.M.400	Key: Existing Proposed SVP Existing drainage Proposed drainage Overhead Boundary line 0 4 8 12 16 20 GRAPHIC SCALE: 1:200	No.	Description	Date
		Date 28.08.2024	Project number 2251			First draft	29.08.24
	Proposed Site Plan and 3D Views	Drawn by MV	Rev C		A	Client's comments (1)	19.11.24
					B	Client's comments (2)	19.12.24
					C	Client's comments (3)	02.01.25