




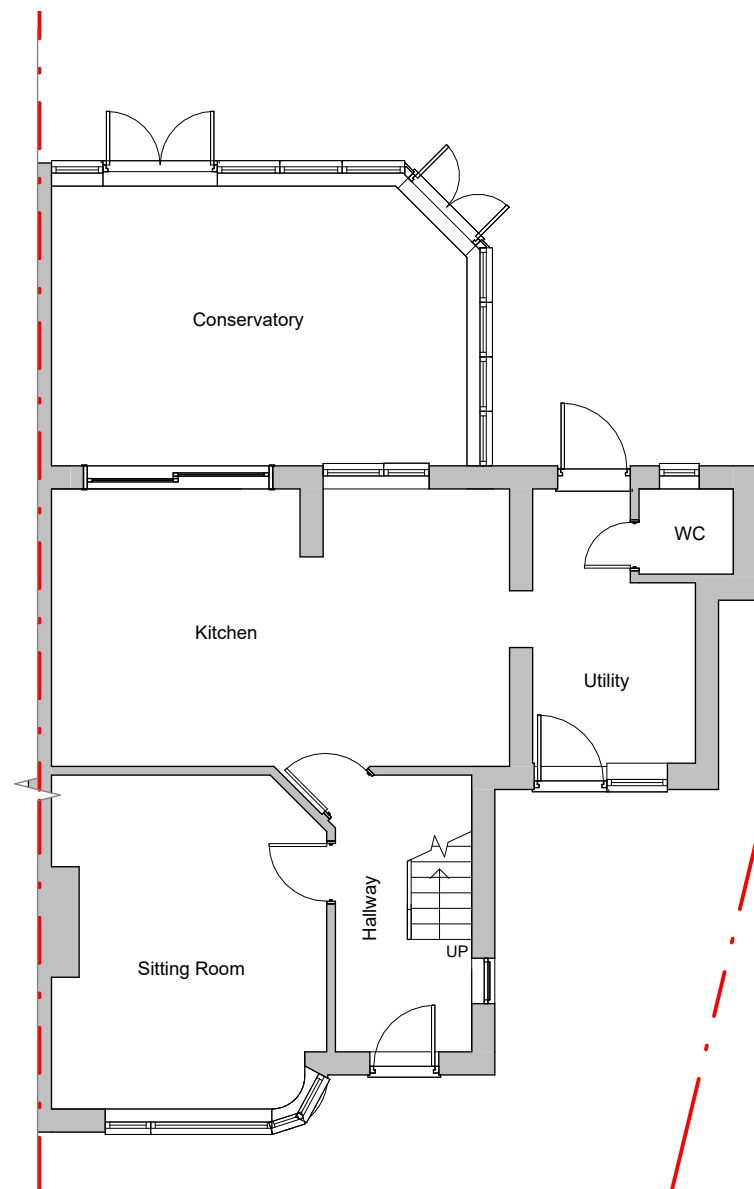

Ground Floor

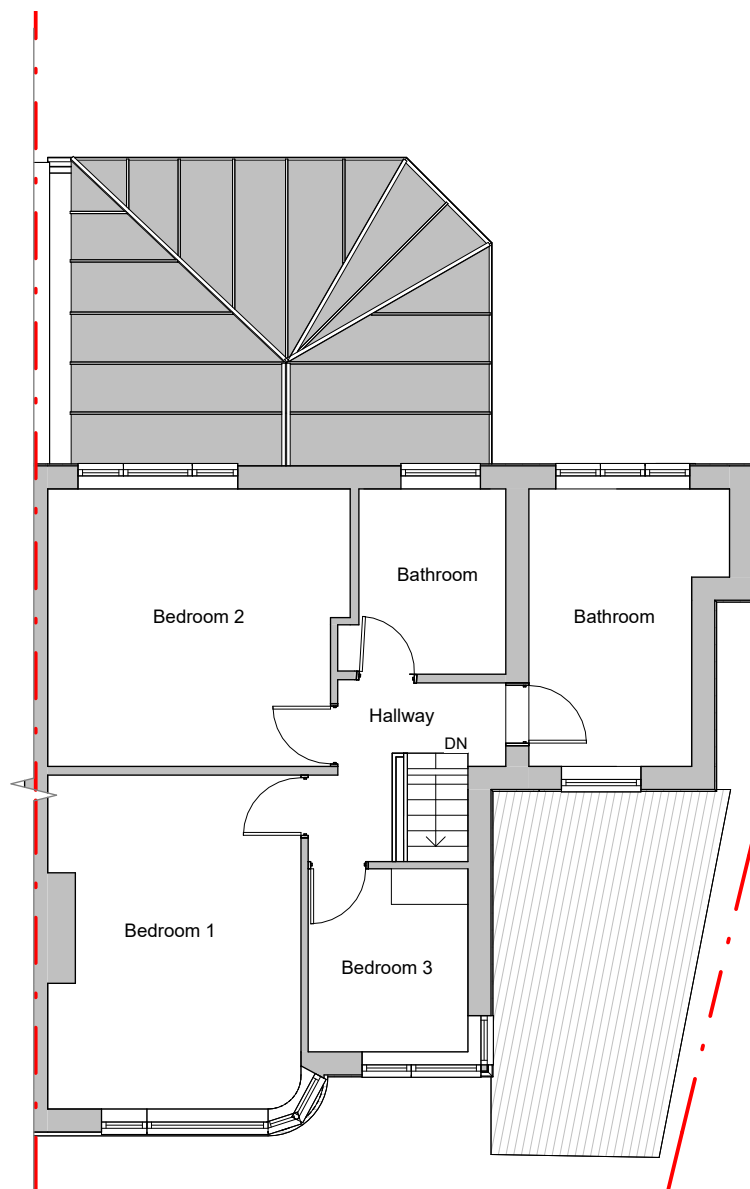

First Floor

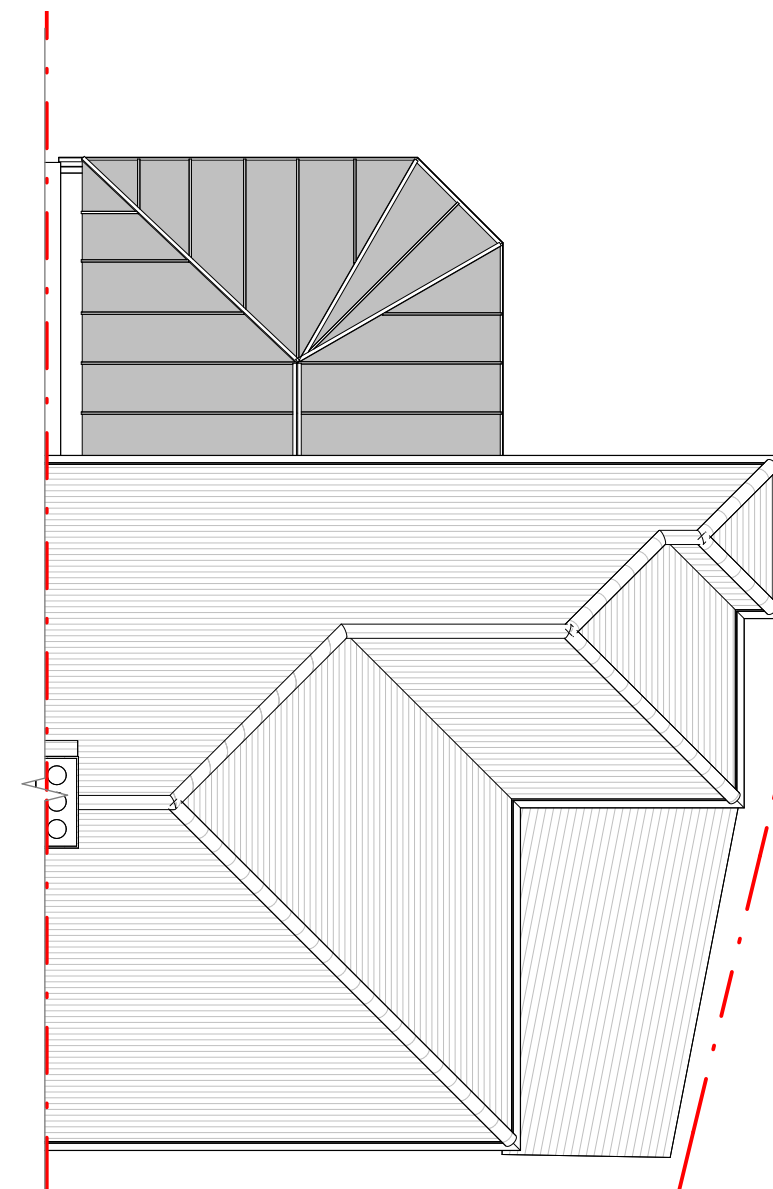

Roof Plan



FLUENT
ARCHITECTURAL DESIGN SERVICES
TEL: 0800 043 8838
E-MAIL: INFO@FLUENT-ADS.CO.UK
WEB: FLUENT-ADS.CO.UK

11 Mayfield Drive. Reading RG4 5JP

Existing Floor Plans

Scale @ A3
1 : 100

Date
28.08.2024

Drawn by
MV

Drawing number
P.M.200

Project number
2251

Rev

Key:

Existing Proposed SVP Boundary line
Existing drainage Proposed drainage Overhead

0 1 2 3 4 5 10
GRAPHIC SCALE: 1:100

No.	Description	Date
	First draft	29.08.24