


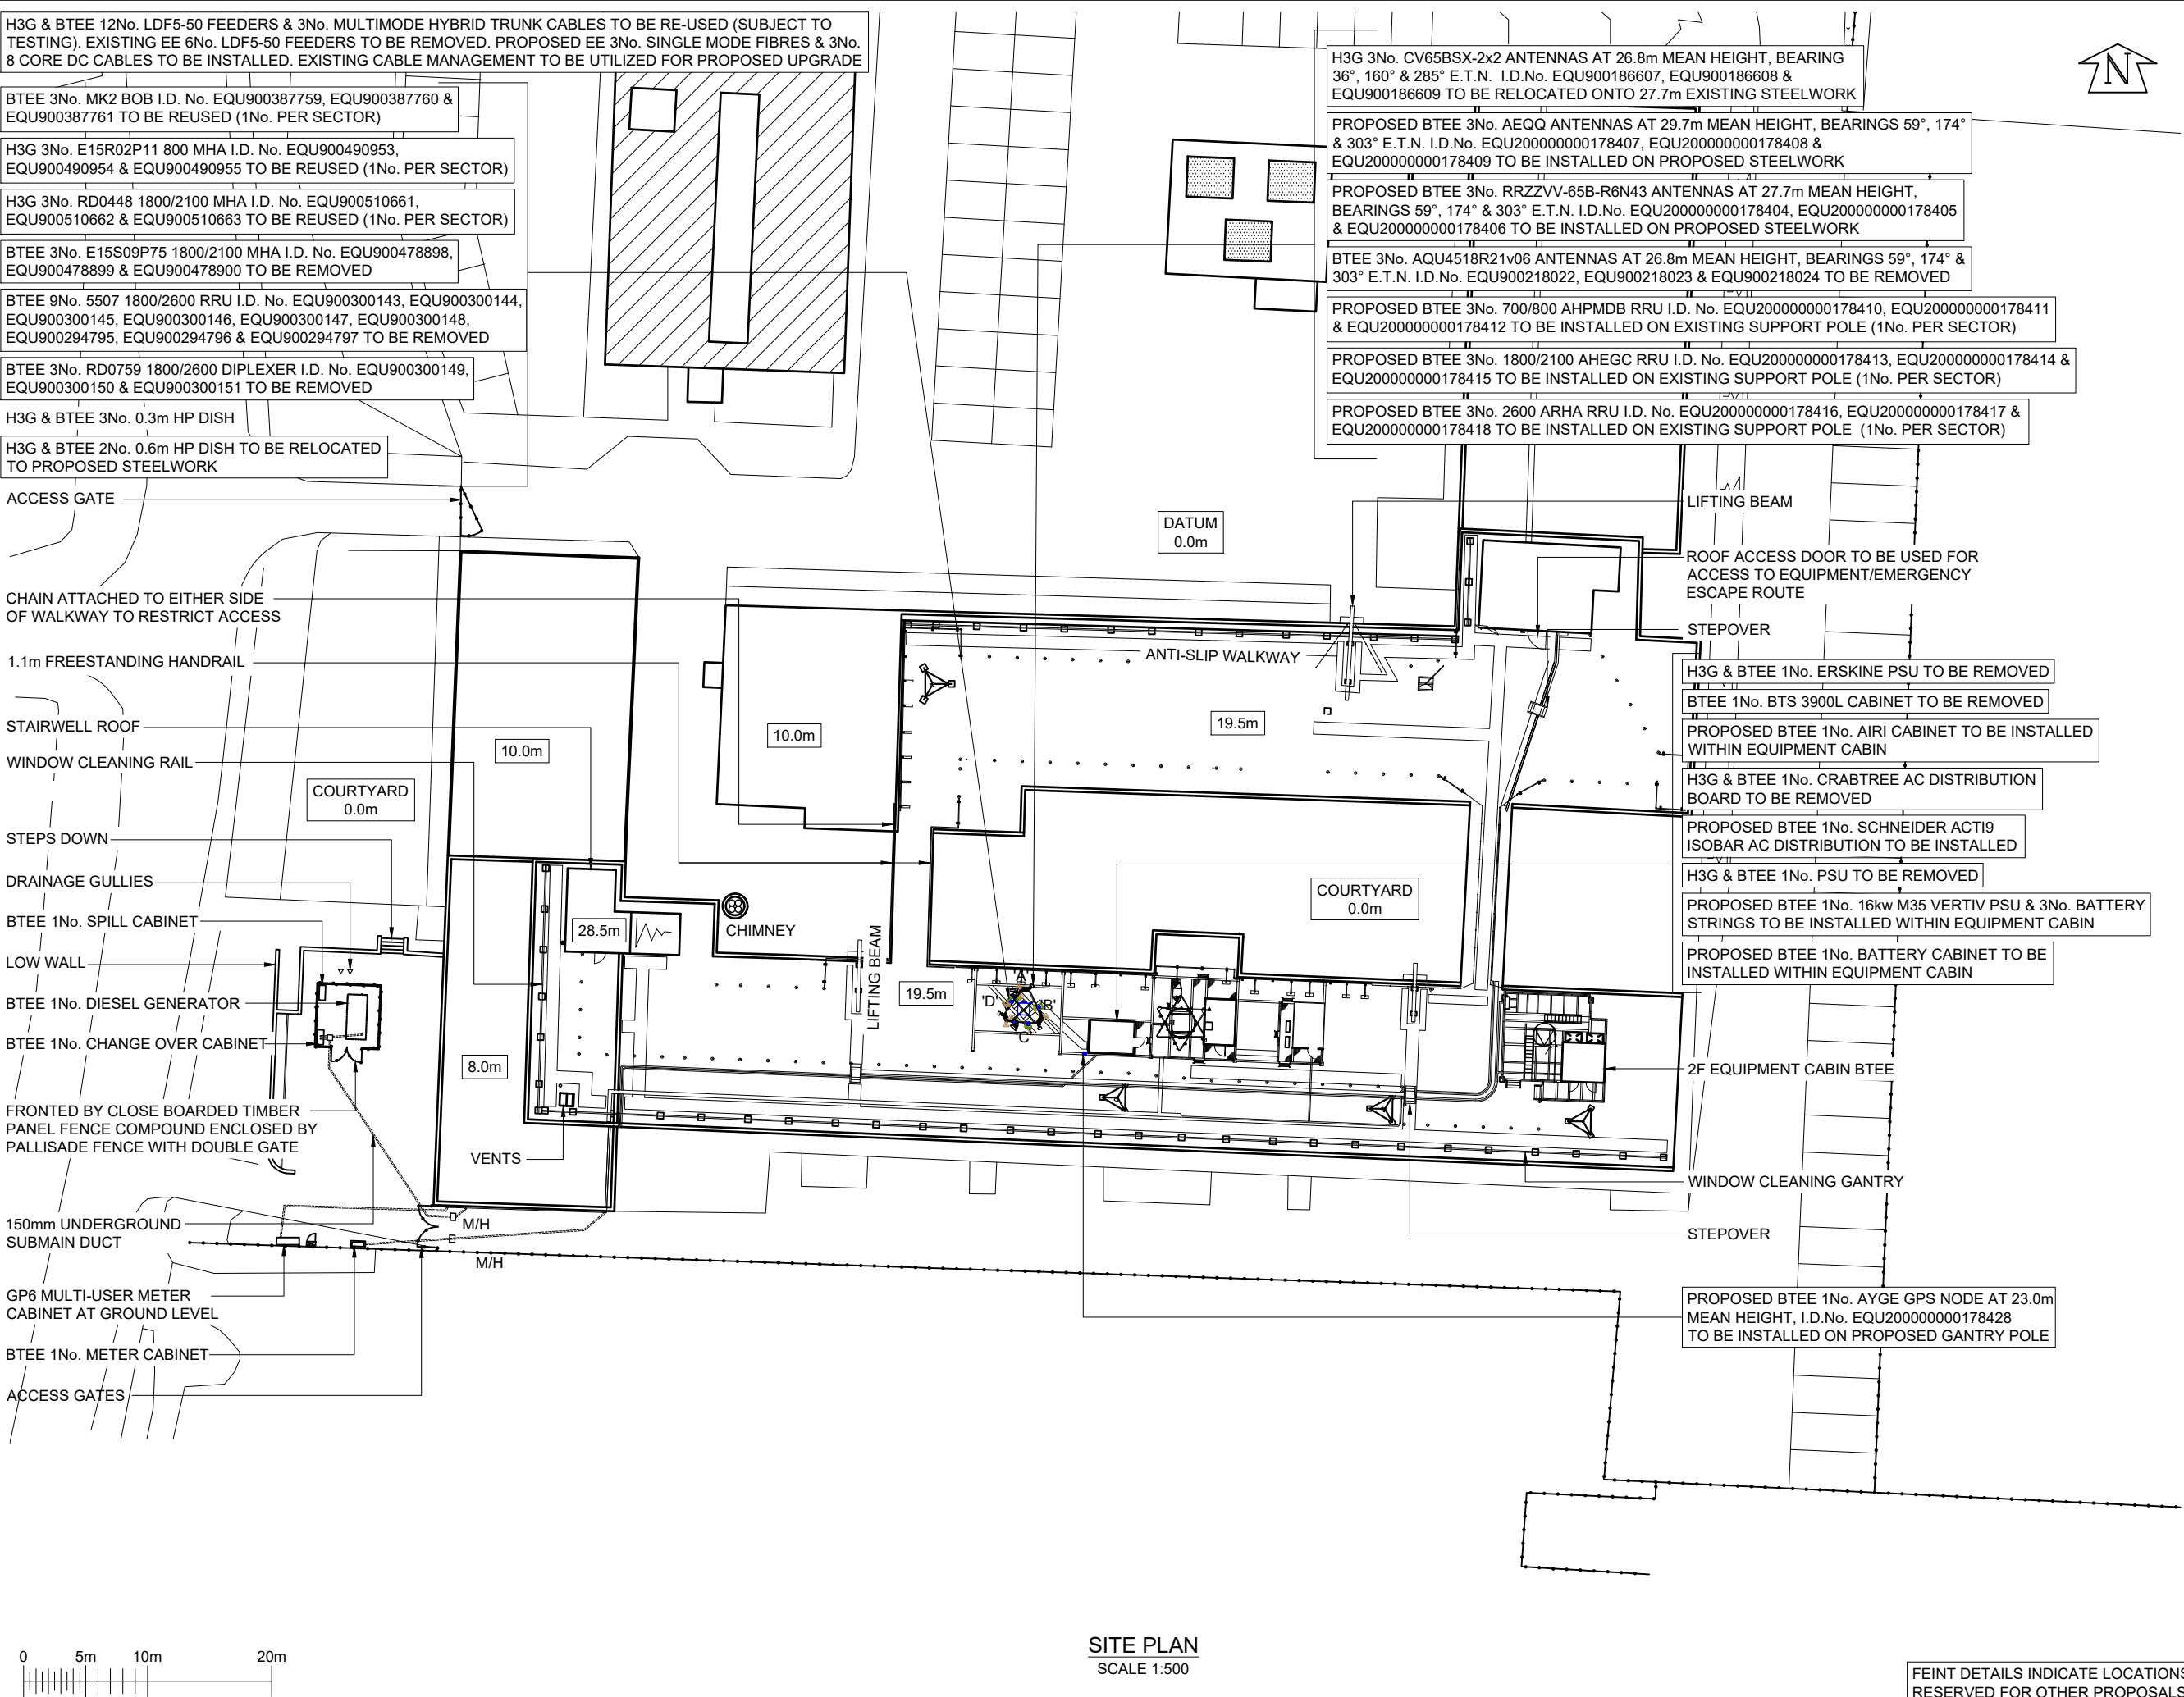

SITE PLAN
SCALE 1:500

FEINT DETAILS INDICATE LOCATIONS RESERVED FOR OTHER PROPOSALS WHICH MAY BE THE SUBJECT OF SEPARATE APPLICATIONS

©2020 Cellnex
All rights reserved. No part of this publication may be reproduced, stored in a retrieval system or transmitted in any form or by any means (Electronic, Mechanical, Photocopying, Recording or otherwise), without the prior written consent of the Company.

NOTES

PROJECT No.

COM-0025454

CELL No.

91335

BT SKYLINE No.

RG0019

43	COM-0025454 PLANNING ISSUE	28/01/25	HFC	HFC
42	COM0020305 PROJECT REMOVAL	13/03/24	MCD	MCD
41		28/03/23	GBC	GBC
40	COM0020305 PLANNING	02/11/22	BEA	BEA
39	COM-0018969 PLANNING	10/06/22	NOV	NOV
ISS	REVISION	DATE	DRN	APP

cellnex

driving telecom connectivity

Crawley Court, Winchester, Hampshire, SO21 2QA
Tel. 01962 823434, Fax. 01962 822378

SITE No

167371

READING ZSC

BASINGSTOKE ROAD

READING

BERKSHIRE

RG2 0EW

NGR

SU 72100 71920

OS GRID

472100 171920

TITLE

SITE PLAN

PROPOSED

BTEE LTD

SCALE

1:500

DRAWN	IM	01/06/11
APPROVED	HFC	28/01/25

DRG No.

Sheet 1 of 1

Rev

167371-02-110-MD043

43

 


©2020 Cellnex
All rights reserved. No part of this publication may be reproduced, stored in a retrieval system or transmitted in any form or by any means (Electronic, Mechanical, Photocopying, Recording or otherwise), without the prior written consent of the Company.

NOTES



EQUIPMENT PLAN
SCALE 1:25



FEINT DETAILS INDICATE LOCATIONS
RESERVED FOR OTHER PROPOSALS
WHICH MAY BE THE SUBJECT OF
SEPARATE APPLICATIONS

PROJECT No.		COM-0025454			
CELL No.		91335			
BT SKYLINE No.					
RG0019					
43	COM-0025454 PLANNING ISSUE	28/01/25	HFC	HFC	
42	COM0020305 PROJECT REMOVAL	13/03/24	MCD	MCD	
41		28/03/23	GBC	GBC	
40	COM0020305 PLANNING	02/11/22	BEA	BEA	
39	COM-0018969 PLANNING	10/06/22	NOV	NOV	
ISS	REVISION	DATE	DRN	APP	
 Crawley Court, Winchester, Hampshire, SO21 2QA Tel. 01962 823434, Fax. 01962 822378					
SITE No 167371 READING ZSC BASINGSTOKE ROAD READING BERKSHIRE RG2 0EW					
NGR		SU 72100 71920			
OS GRID		472100 171920			
TITLE EQUIPMENT PLAN PROPOSED BTEE LTD					
SCALE 1:25					
DRAWN		IM	01/06/11		
APPROVED		HFC	28/01/25		
DRG No.		Sheet 1 of 1		Rev	
167371-02-111-MD043		43			

H3G & BTEE 12No. LDF5-50 FEEDERS & 3No. MULTIMODE HYBRID TRUNK CABLES TO BE RE-USED (SUBJECT TO TESTING). EXISTING EE 6No. LDF5-50 FEEDERS TO BE REMOVED. PROPOSED EE 3No. SINGLE MODE FIBRES & 3No. 8 CORE DC CABLES TO BE INSTALLED. EXISTING CABLE MANAGEMENT TO BE UTILIZED FOR PROPOSED UPGRADE

H3G 3No. CV65BSX-2x2 ANTENNAS AT 26.8m MEAN HEIGHT, BEARING 36°, 160° & 285° E.T.N. I.D.No. EQU900186607, EQU900186608 & EQU900186609 TO BE RELOCATED TO 27.7m ON EXISTING STEELWORK

PROPOSED BTEE 3No. AEQQ ANTENNAS AT 29.7m MEAN HEIGHT, BEARINGS 59°, 174° & 303° E.T.N. I.D.No. EQU200000000178407, EQU200000000178408 & EQU200000000178409 TO BE INSTALLED ON PROPOSED STEELWORK

PROPOSED BTEE 3No. RRZZVV-65B-R6N43 ANTENNAS AT 27.7m MEAN HEIGHT, BEARINGS 59°, 174° & 303° E.T.N. I.D.No. EQU200000000178404, EQU200000000178405 & EQU200000000178406 TO BE INSTALLED ON PROPOSED STEELWORK

BTEE 3No. AQU4518R21v06 ANTENNAS AT 26.8m MEAN HEIGHT, BEARINGS 59°, 174° & 303° E.T.N. I.D.No. EQU900218022, EQU900218023 & EQU900218024 TO BE REMOVED

PROPOSED BTEE 3No. 700/800 AHPMDB RRU I.D. No. EQU200000000178410, EQU200000000178411 & EQU200000000178412 TO BE INSTALLED ON EXISTING SUPPORT POLE (1No. PER SECTOR)

PROPOSED BTEE 3No. 1800/2100 AHEGC RRU I.D. No. EQU200000000178413, EQU200000000178414 & EQU200000000178415 TO BE INSTALLED ON EXISTING SUPPORT POLE (1No. PER SECTOR)

PROPOSED BTEE 3No. 2600 ARHA RRU I.D. No. EQU200000000178416, EQU200000000178417 & EQU200000000178418 TO BE INSTALLED ON EXISTING SUPPORT POLE (1No. PER SECTOR)

BTEE 3No. MK2 BOB I.D. No. EQU900387759, EQU900387760 & EQU900387761 TO BE REUSED (1No. PER SECTOR)

H3G 3No. E15R02P11 800 MHA I.D. No. EQU900490953, EQU900490954 & EQU900490955 TO BE REUSED (1No. PER SECTOR)

H3G 3No. RD0448 1800/2100 MHA I.D. No. EQU900510661, EQU900510662 & EQU900510663 TO BE REUSED (1No. PER SECTOR)

BTEE 3No. E15S09P75 1800/2100 MHA I.D. No. EQU900478898, EQU900478899 & EQU900478900 TO BE REMOVED

BTEE 9No. 5507 1800/2600 RRU I.D. No. EQU900300143, EQU900300144, EQU900300145, EQU900300146, EQU900300147, EQU900300148, EQU900294795, EQU900294796 & EQU900294797 TO BE REMOVED

BTEE 3No. RD0759 1800/2600 DIPLEXER I.D. No. EQU900300149, EQU900300150 & EQU900300151 TO BE REMOVED

H3G & BTEE 3No. 0.3m HP DISH

H3G & BTEE 2No. 0.6m HP DISH TO BE RELOCATED TO PROPOSED STEELWORK

19.5m

10.0m

GL 0.0m

29.7m

27.7m

23.0m

29.7m

SOUTH ELEVATION
SCALE 1:500

PROPOSED BTEE 1No. AYGE GPS NODE AT 23.0m MEAN HEIGHT, I.D.No. EQU200000000178428 TO BE INSTALLED ON PROPOSED GANTRY POLE

H3G & BTEE 1No. ERSKINE PSU TO BE REMOVED

BTEE 1No. BTS 3900L CABINET TO BE REMOVED

PROPOSED BTEE 1No. AIRI CABINET TO BE INSTALLED WITHIN EQUIPMENT CABIN

H3G & BTEE 1No. CRABTREE AC DISTRIBUTION BOARD TO BE REMOVED

PROPOSED BTEE 1No. SCHNEIDER ACTI9 ISOBAR AC DISTRIBUTION TO BE INSTALLED

H3G & BTEE 1No. PSU TO BE REMOVED

PROPOSED BTEE 1No. 16kw M35 VERTIV PSU & 3No. BATTERY STRINGS TO BE INSTALLED WITHIN EQUIPMENT CABIN

PROPOSED BTEE 1No. BATTERY CABINET TO BE INSTALLED WITHIN EQUIPMENT CABIN

CABIN BTEE

NOTES

PROJECT No. COM-0025454

CELL No. 91335

BT SKYLINE No.
RG0019

43	COM-0025454 PLANNING ISSUE	28/01/25	HFC	HFC
42	COM0020305 PROJECT REMOVAL	13/03/24	MCD	MCD
41		28/03/23	GBC	GBC
40	COM0020305 PLANNING	02/11/22	BEA	BEA
39	COM-0018969 PLANNING	10/06/22	NOV	NOV
ISS	REVISION	DATE	DRN	APP



Crawley Court, Winchester, Hampshire, SO21 2QA
Tel. 01962 823434, Fax. 01962 822378

SITE No 167371
READING ZSC
BASINGSTOKE ROAD
READING
BERKSHIRE
RG2 0EW

NGR SU 72100 71920

OS GRID 472100 171920

TITLE
SOUTH ELEVATION
PROPOSED
BTEE LTD

SCALE 1:500

DRAWN IM 01/06/11

APPROVED HFC 28/01/25

DRG No. Sheet 1 of 2 Rev
167371-02-160-MD043 43

FEINT DETAILS INDICATE LOCATIONS
RESERVED FOR OTHER PROPOSALS
WHICH MAY BE THE SUBJECT OF
SEPARATE APPLICATIONS

H3G & BTEE 12No. LDF5-50 FEEDERS & 3No. MULTIMODE HYBRID TRUNK CABLES TO BE RE-USED (SUBJECT TO TESTING). EXISTING EE 6No. LDF5-50 FEEDERS TO BE REMOVED. PROPOSED EE 3No. SINGLE MODE FIBRES & 3No. 8 CORE DC CABLES TO BE INSTALLED. EXISTING CABLE MANAGEMENT TO BE UTILIZED FOR PROPOSED UPGRADE

PROPOSED BTEE 1No. AYGE GPS NODE AT 23.0m MEAN HEIGHT, I.D.No. EQU200000000178428 TO BE INSTALLED ON PROPOSED GANTRY POLE

H3G & BTEE 1No. ERSKINE PSU TO BE REMOVED

BTEE 1No. BTS 3900L CABINET TO BE REMOVED

PROPOSED BTEE 1No. AIRI CABINET TO BE INSTALLED WITHIN EQUIPMENT CABIN

H3G & BTEE 1No. CRABTREE AC DISTRIBUTION BOARD TO BE REMOVED

PROPOSED BTEE 1No. SCHNEIDER ACTI9 ISOBAR AC DISTRIBUTION TO BE INSTALLED

H3G & BTEE 1No. PSU TO BE REMOVED

PROPOSED BTEE 1No. 16kw M35 VERTIV PSU & 3No. BATTERY STRINGS TO BE INSTALLED WITHIN EQUIPMENT CABIN


PROPOSED BTEE 1No. BATTERY CABINET TO BE INSTALLED WITHIN EQUIPMENT CABIN

CABIN BTEE

19.5m

10.0m

GL 0.0m

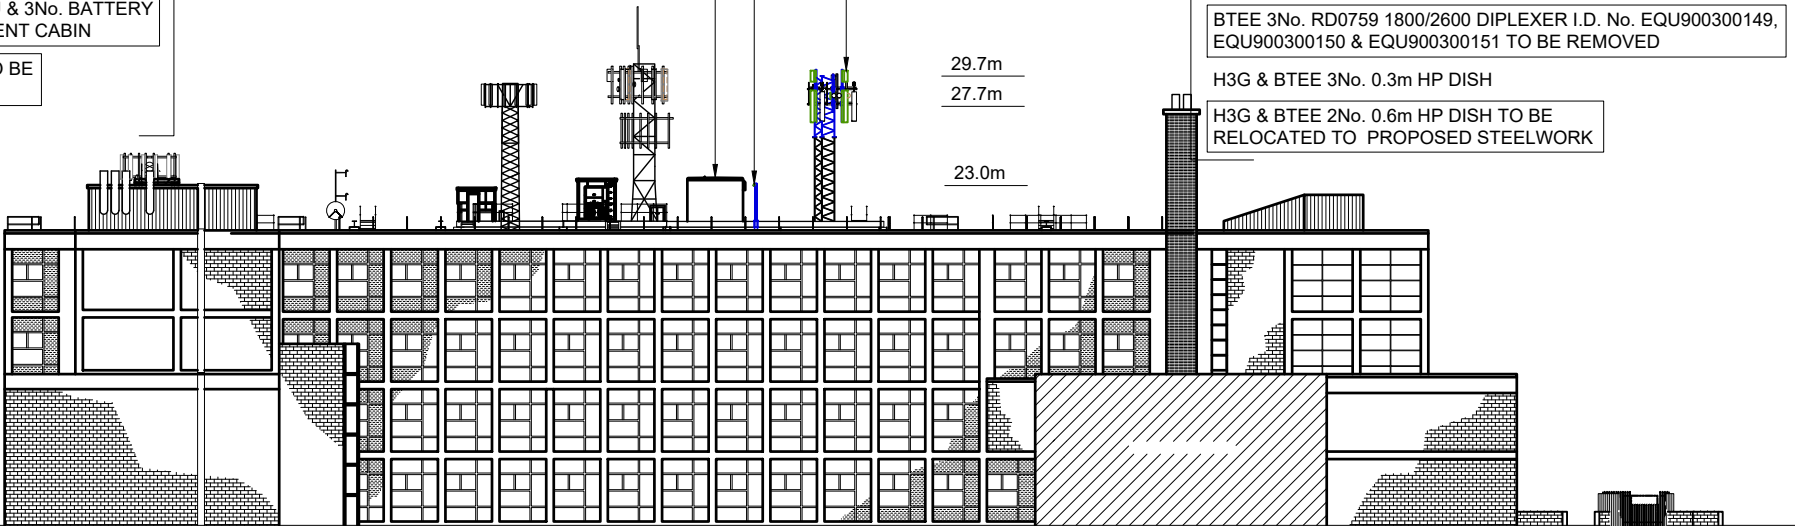

NORTH ELEVATION
SCALE 1:500



H3G 3No. CV65BSX-2x2 ANTENNAS AT 26.8m MEAN HEIGHT, BEARING 36°, 160° & 285° E.T.N. I.D.No. EQU900186607, EQU900186608 & EQU900186609 TO BE RELOCATED TO 27.7m ON EXISTING STEELWORK

PROPOSED BTEE 3No. AEQQ ANTENNAS AT 29.7m MEAN HEIGHT, BEARINGS 59°, 174° & 303° E.T.N. I.D.No. EQU200000000178407, EQU200000000178408 & EQU200000000178409 TO BE INSTALLED ON PROPOSED STEELWORK

PROPOSED BTEE 3No. RRZZVV-65B-R6N43 ANTENNAS AT 27.7m MEAN HEIGHT, BEARINGS 59°, 174° & 303° E.T.N. I.D.No. EQU200000000178404, EQU200000000178405 & EQU200000000178406 TO BE INSTALLED ON PROPOSED STEELWORK

BTEE 3No. AQU4518R21v06 ANTENNAS AT 26.8m MEAN HEIGHT, BEARINGS 59°, 174° & 303° E.T.N. I.D.No. EQU900218022, EQU900218023 & EQU900218024 TO BE REMOVED

PROPOSED BTEE 3No. 700/800 AHPMDB RRU I.D. No. EQU200000000178410, EQU200000000178411 & EQU200000000178412 TO BE INSTALLED ON EXISTING SUPPORT POLE (1No. PER SECTOR)

PROPOSED BTEE 3No. 1800/2100 AHEGC RRU I.D. No. EQU200000000178413, EQU200000000178414 & EQU200000000178415 TO BE INSTALLED ON EXISTING SUPPORT POLE (1No. PER SECTOR)

PROPOSED BTEE 3No. 2600 ARHA RRU I.D. No. EQU200000000178416, EQU200000000178417 & EQU200000000178418 TO BE INSTALLED ON EXISTING SUPPORT POLE (1No. PER SECTOR)

BTEE 3No. MK2 BOB I.D. No. EQU900387759, EQU900387760 & EQU900387761 TO BE REUSED (1No. PER SECTOR)

H3G 3No. E15R02P11 800 MHA I.D. No. EQU900490953, EQU900490954 & EQU900490955 TO BE REUSED (1No. PER SECTOR)

H3G 3No. RD0448 1800/2100 MHA I.D. No. EQU900510661, EQU900510662 & EQU900510663 TO BE REUSED (1No. PER SECTOR)

BTEE 3No. E15S09P75 1800/2100 MHA I.D. No. EQU900478898, EQU900478899 & EQU900478900 TO BE REMOVED

BTEE 9No. 5507 1800/2600 RRU I.D. No. EQU900300143, EQU900300144, EQU900300145, EQU900300146, EQU900300147, EQU900300148, EQU900294795, EQU900294796 & EQU900294797 TO BE REMOVED

BTEE 3No. RD0759 1800/2600 DIPLEXER I.D. No. EQU900300149, EQU900300150 & EQU900300151 TO BE REMOVED

H3G & BTEE 3No. 0.3m HP DISH

H3G & BTEE 2No. 0.6m HP DISH TO BE RELOCATED TO PROPOSED STEELWORK

NOTES

PROJECT No. COM-0025454

CELL No. 91335

BT SKYLINE No. RG0019

43	COM-0025454 PLANNING ISSUE	28/01/25	HFC	HFC
42	COM0020305 PROJECT REMOVAL	13/03/24	MCD	MCD
41		28/03/23	GBC	GBC
40	COM0020305 PLANNING	02/11/22	BEA	BEA
39	COM-0018969 PLANNING	10/06/22	NOV	NOV
ISS	REVISION	DATE	DRN	APP



Crawley Court, Winchester, Hampshire, SO21 2QA
Tel. 01962 823434, Fax. 01962 822378

SITE No 167371
READING ZSC
BASINGSTOKE ROAD
READING
BERKSHIRE
RG2 0EW

NGR SU 72100 71920

OS GRID 472100 171920

TITLE
NORTH ELEVATION
PROPOSED
BTEE LTD

SCALE 1:500

DRAWN IM 01/06/11

APPROVED HFC 28/01/25

DRG No. Sheet 2 of 2 Rev
167371-02-160-MD043 43

FEINT DETAILS INDICATE LOCATIONS
RESERVED FOR OTHER PROPOSALS
WHICH MAY BE THE SUBJECT OF
SEPARATE APPLICATIONS