




EV DRAWING LEGEND


- EXISTING KERB
- PROPOSED KERB
- PROPOSED DROPPED KERB
- DEMOLISHED
- EXISTING LINE WORK
- PROPOSED LINE WORKS
- PROPOSED EV BOLLARD - RAL 5015
- EXISTING FLOOD LIGHT
- PROPOSED FLOOD LIGHT
- EXISTING FENCE LINE
- PROPOSED FENCE LINE

EV INFRASTRUCTURE LEGEND

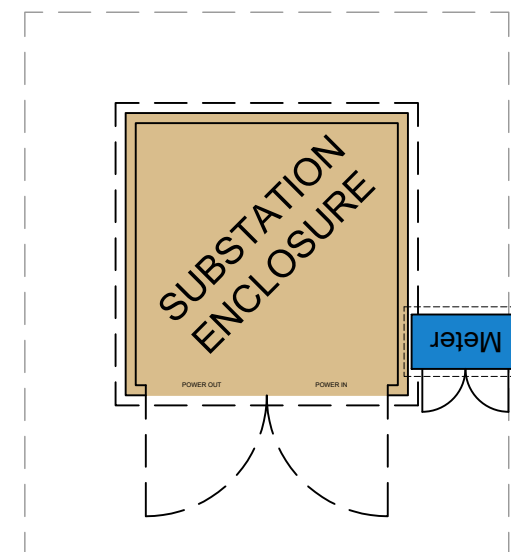


DENOTES DNO HV/LV SUBSTATION
Typical GRP Enclosure 2.8m x 2.8m
All to service provider standard details
TO ICP DETAILS


DENOTES ENVICO TYPE O
METERING CABINET
1065mm x 540mm x 1273mm H
GRP Housing set 300mm clear
from GRP Enclosure

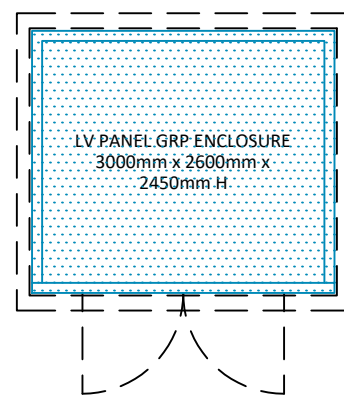

DENOTES BESPOKE LV PANEL GRP
ENCLOSURE
TO BE SPECIFIED BY ELECTRICIAN
Unit Size 3000mm x 2600mm x
2450mm H GRP unit allowed for
currently

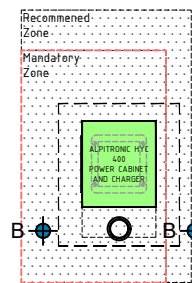

DENOTES CHARGING POST
ALPITRONICS HYC 400

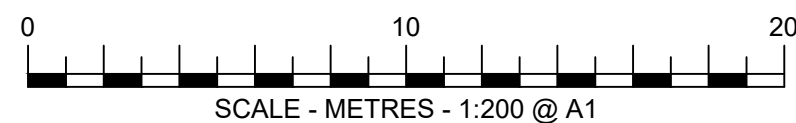

DRAWING NOTES

COPYRIGHT ©
This drawing and the details herein are the copyright of MBH Design Studio Ltd. and must not be reproduced, altered or passed to any third party without prior written consent.
This drawing has been produced for the project listed below, is submitted in support of this application application to the Local Planning Authority and is not intended for use by any other person or for any other purpose.
Every effort has been made to ensure the accuracy of these drawings, however MBH Design Studio Ltd. accept no responsibility for any discrepancies arising from the reuse of survey information and preliminary drawings commissioned by the Applicant from others.

**SCHEME BASED ON
TECHNICS SURVEY DATED
OCTOBER 2024**

REV	DATE	DESCRIPTION	DRAWN/CHECKED
REVISION NOTES			

PLANNING



MBH Design Studio Ltd.
Rosemount House, Rosemount Avenue, West Byfleet, Surrey, KT14 6LB
www.mbhstd.com t: 01932 352 727 f: 01932 351 545

CLIENT



PROJECT

FS2359 READING ROSE KILN WAY MORRISONS
ROSE KILN LANE
READING
RG2 0HB

DRAWING TITLE

PROPOSED SITE PLAN

DRAWN BY KL	DATE 15.10.2024	SCALE 1:200	PAPER SIZE A1
CHECKED BY RRB	DRAWING NUMBER 14313-2359-21	REV.	