
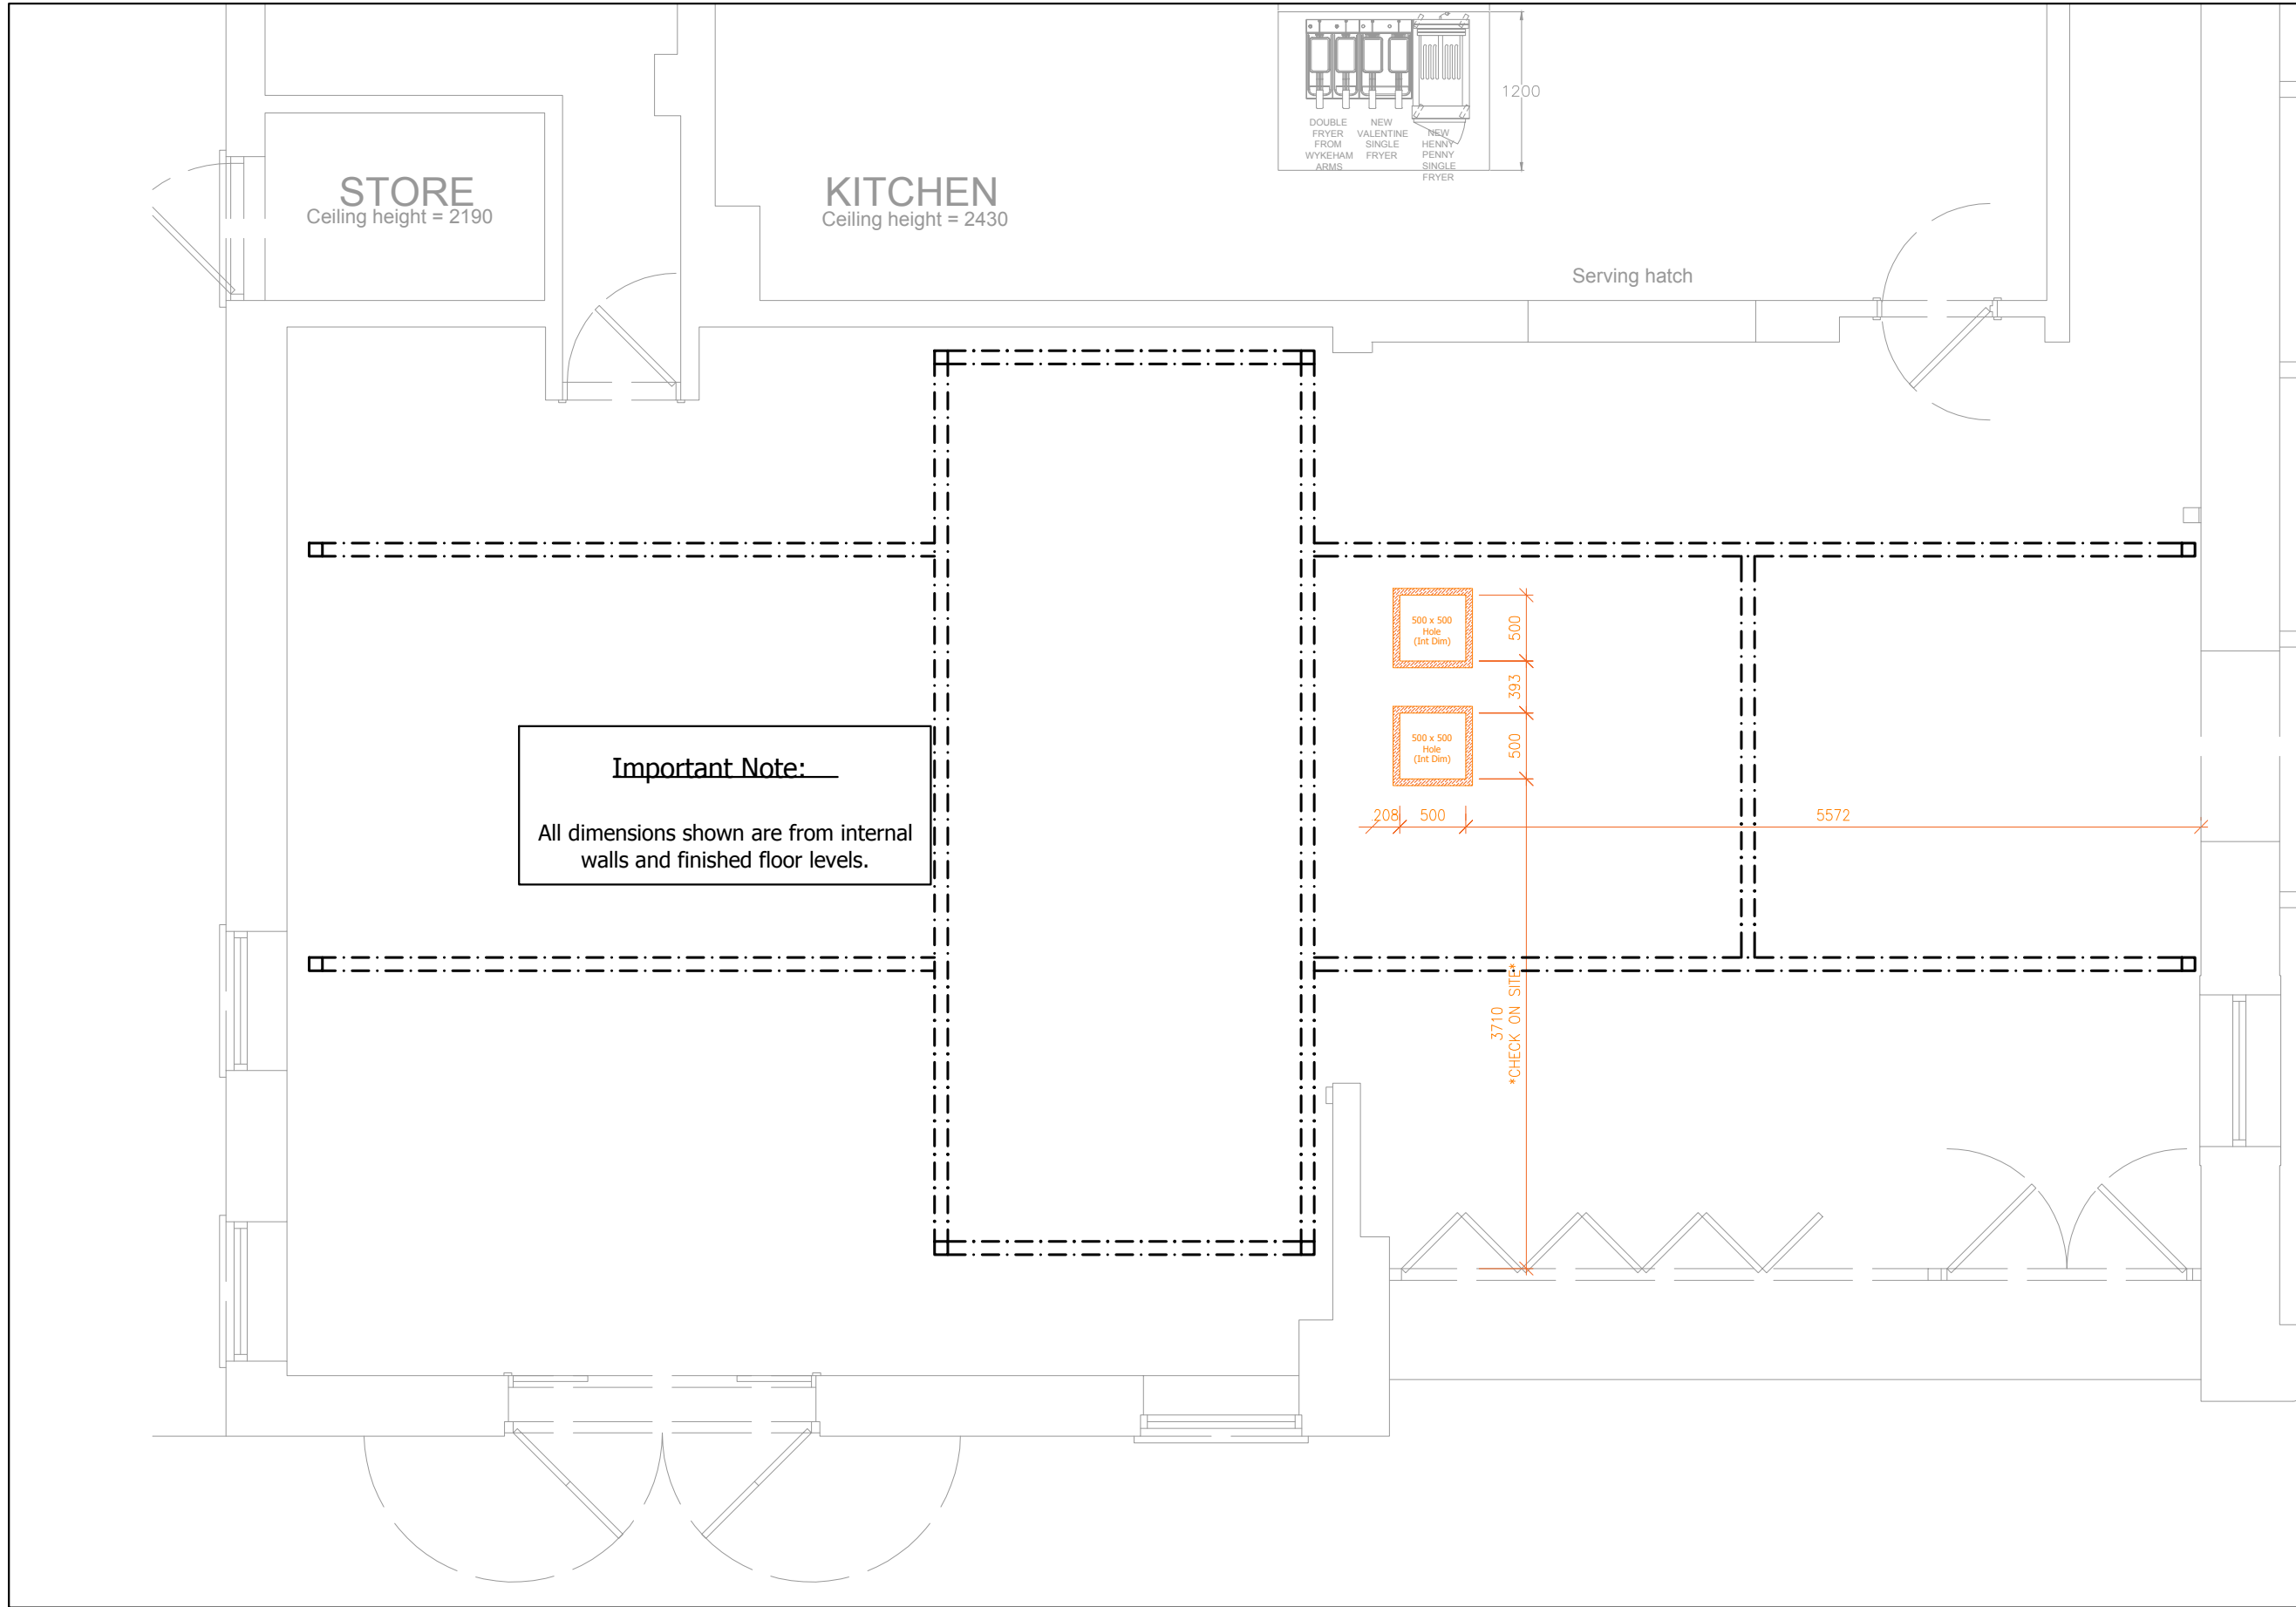
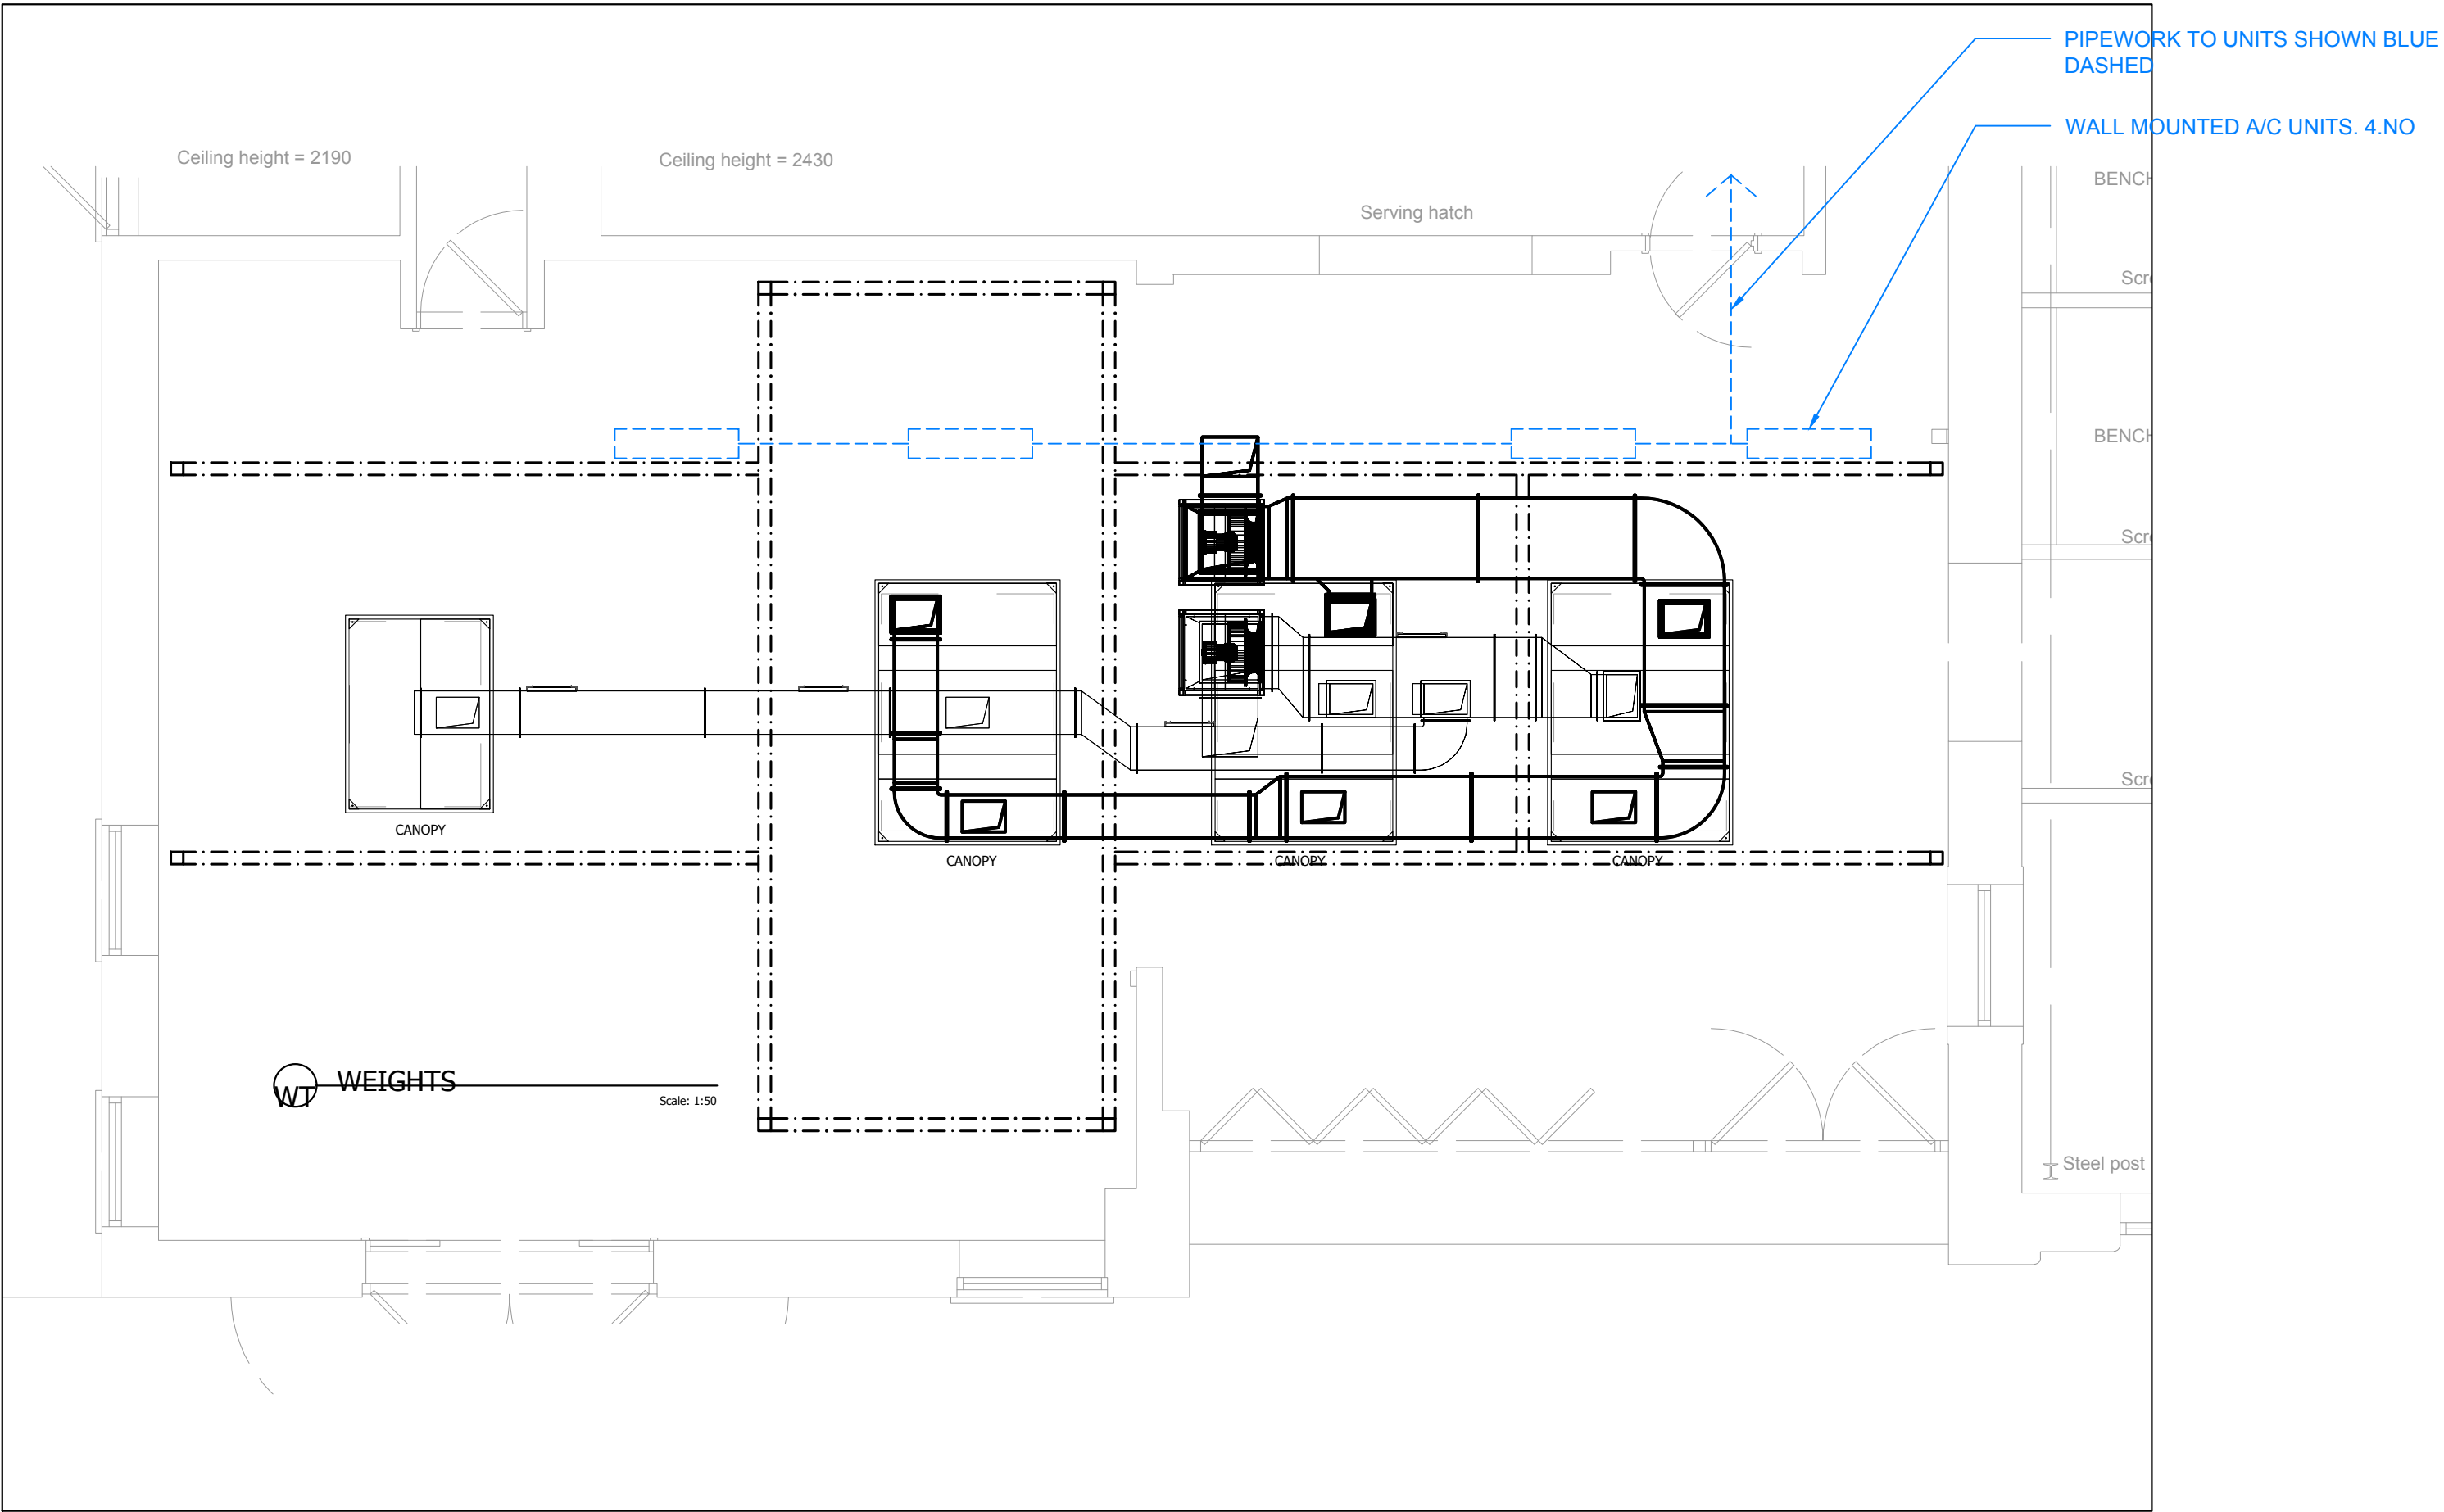


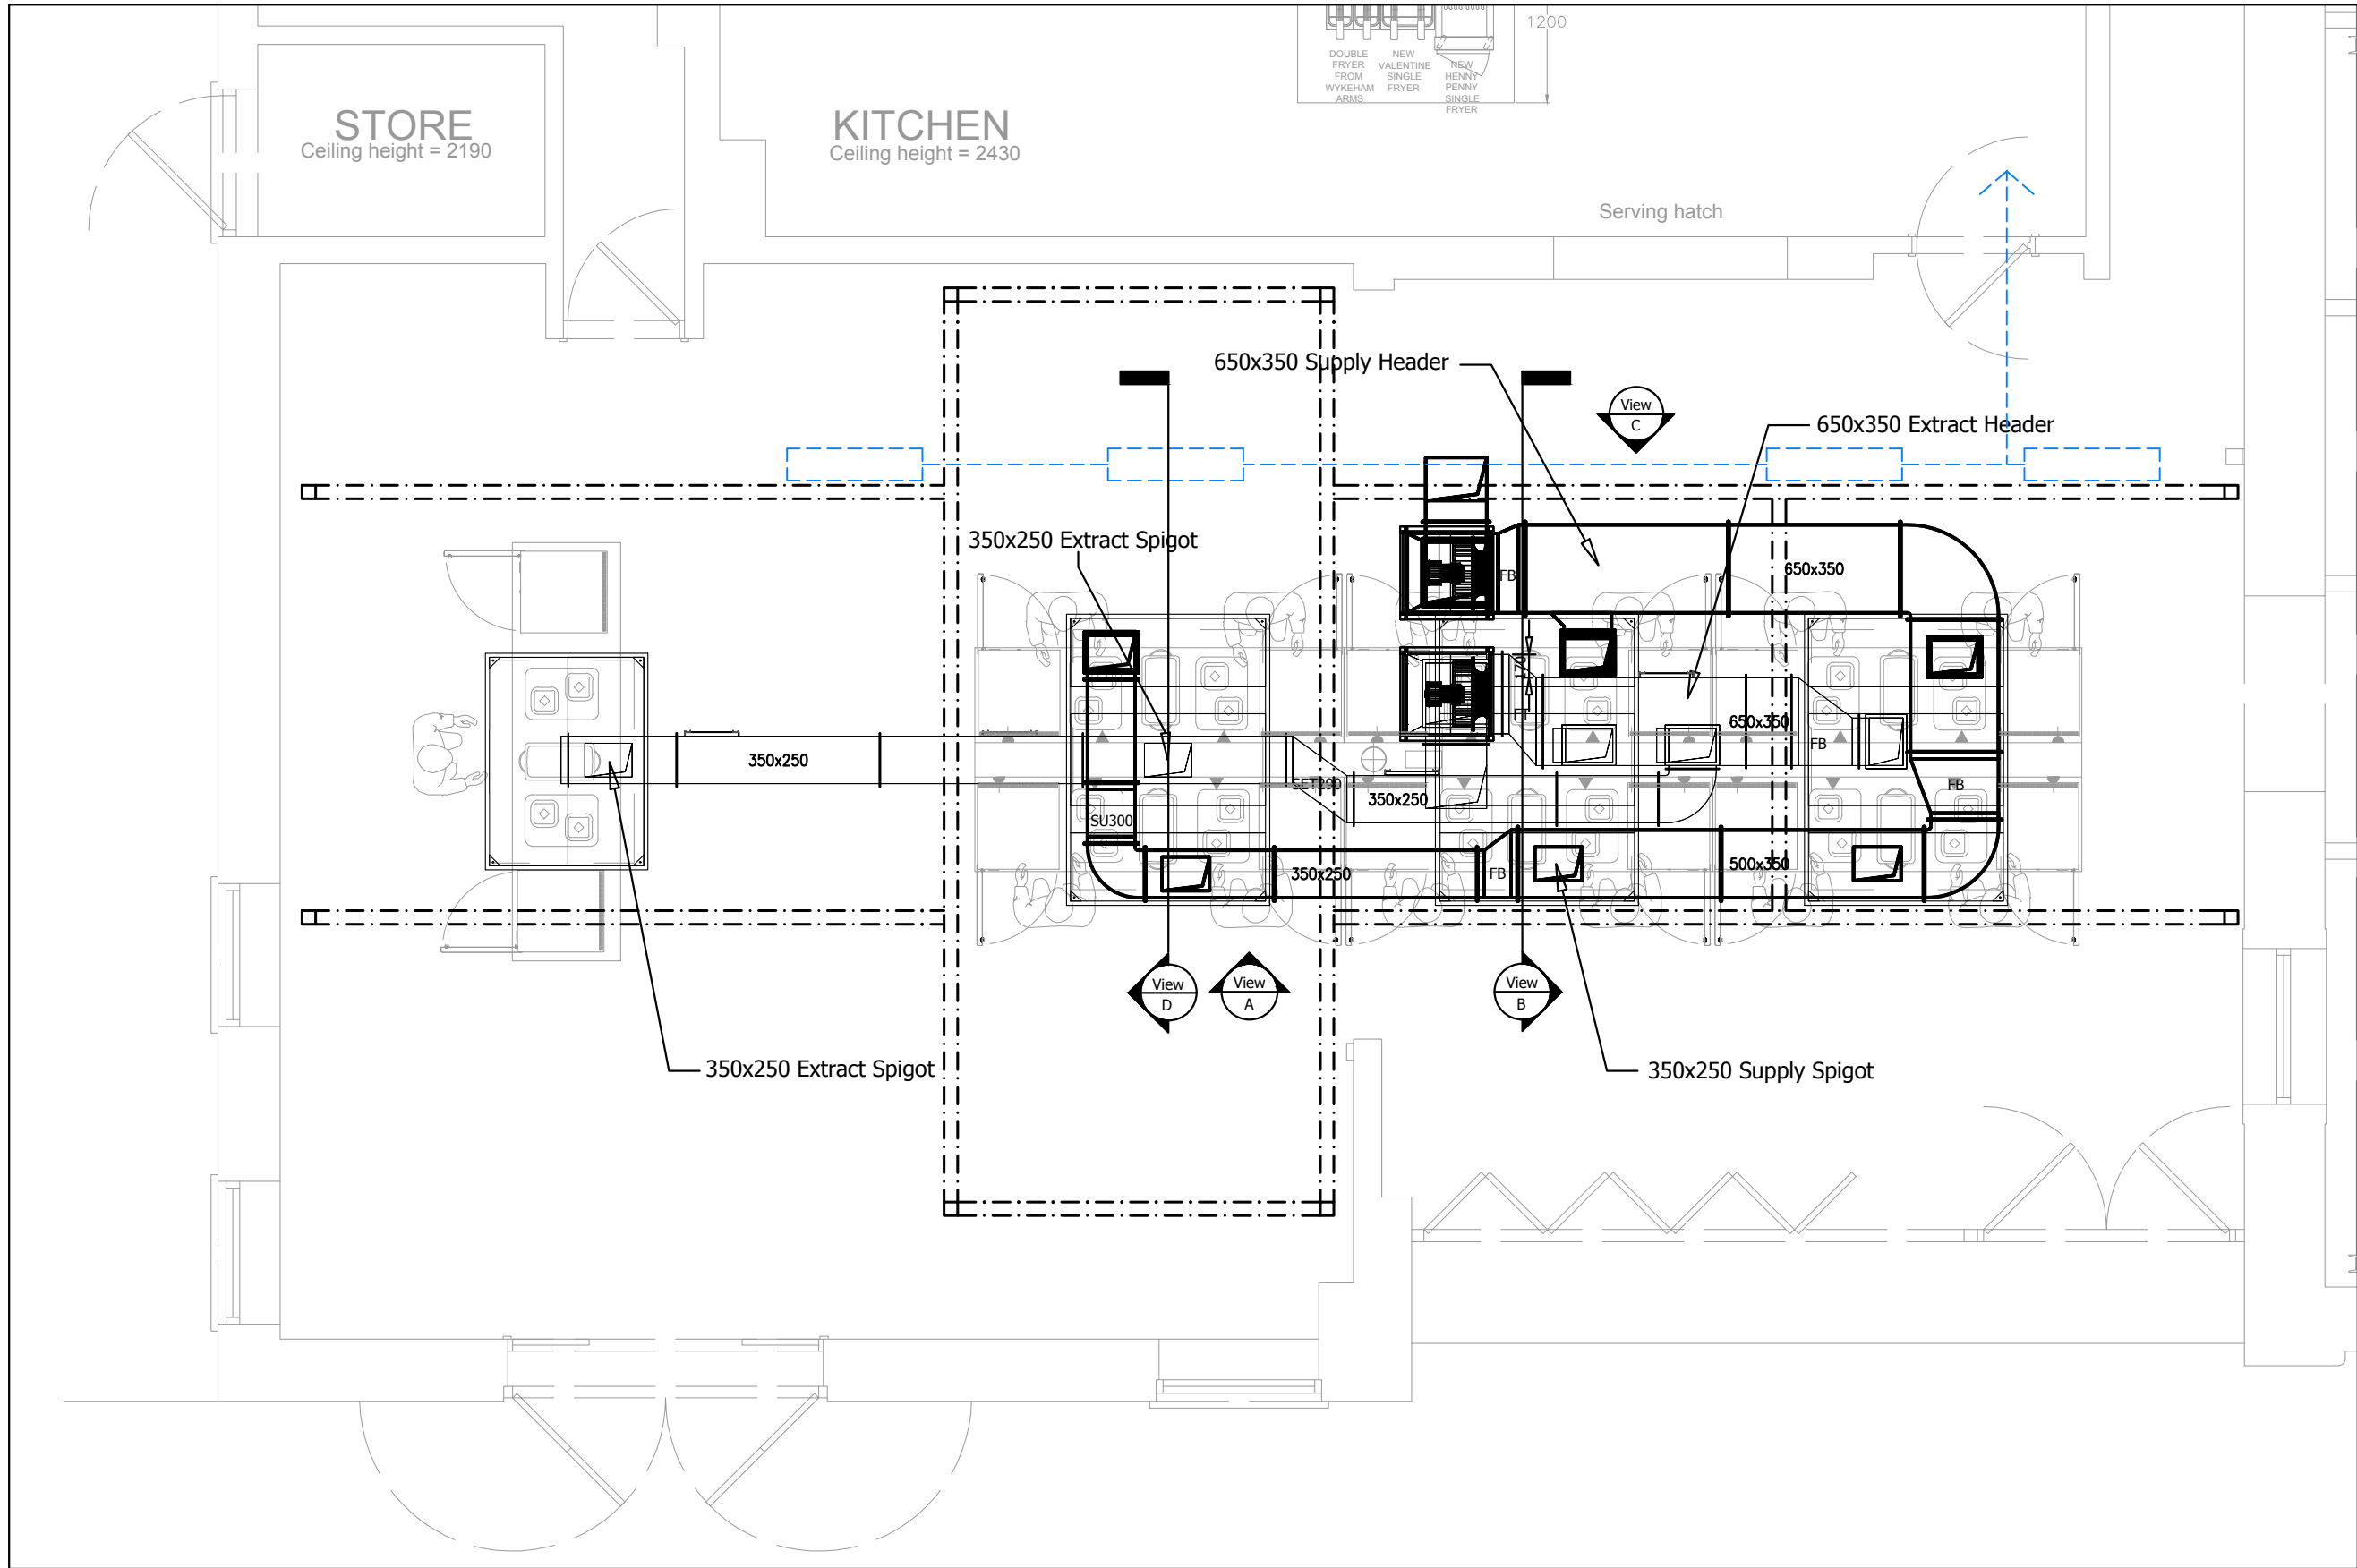

01 Proposed HVAC layout
SCALE - 1:50 @ A1

WESTWOOD STUDIOS Ltd
97 Dale Avenue,
Hassocks,
West Sussex,
BN6 8LR.
t: 07957421434
ben@westwoodstudios.co.uk

A	Planning Issue	15.04.25
-	Planning Issue	07.01.25
Rev	Description	Date
Do not scale from drawings. All discrepancies to be reported to the Client immediately. All dimensions to be verified by contractor on site prior to any works commencing.		
Client Name : Fuller, Smith & Turner		
Project Address The Narrowboat		
: Blakes Quay		
Reading RG1 3EQ		
Description : Proposed Air Handling System Layout		
Scale : 1:50@ A1		
CONSTRUCTION		
Dwg No.		Rev No.
024-101-02-04		A