


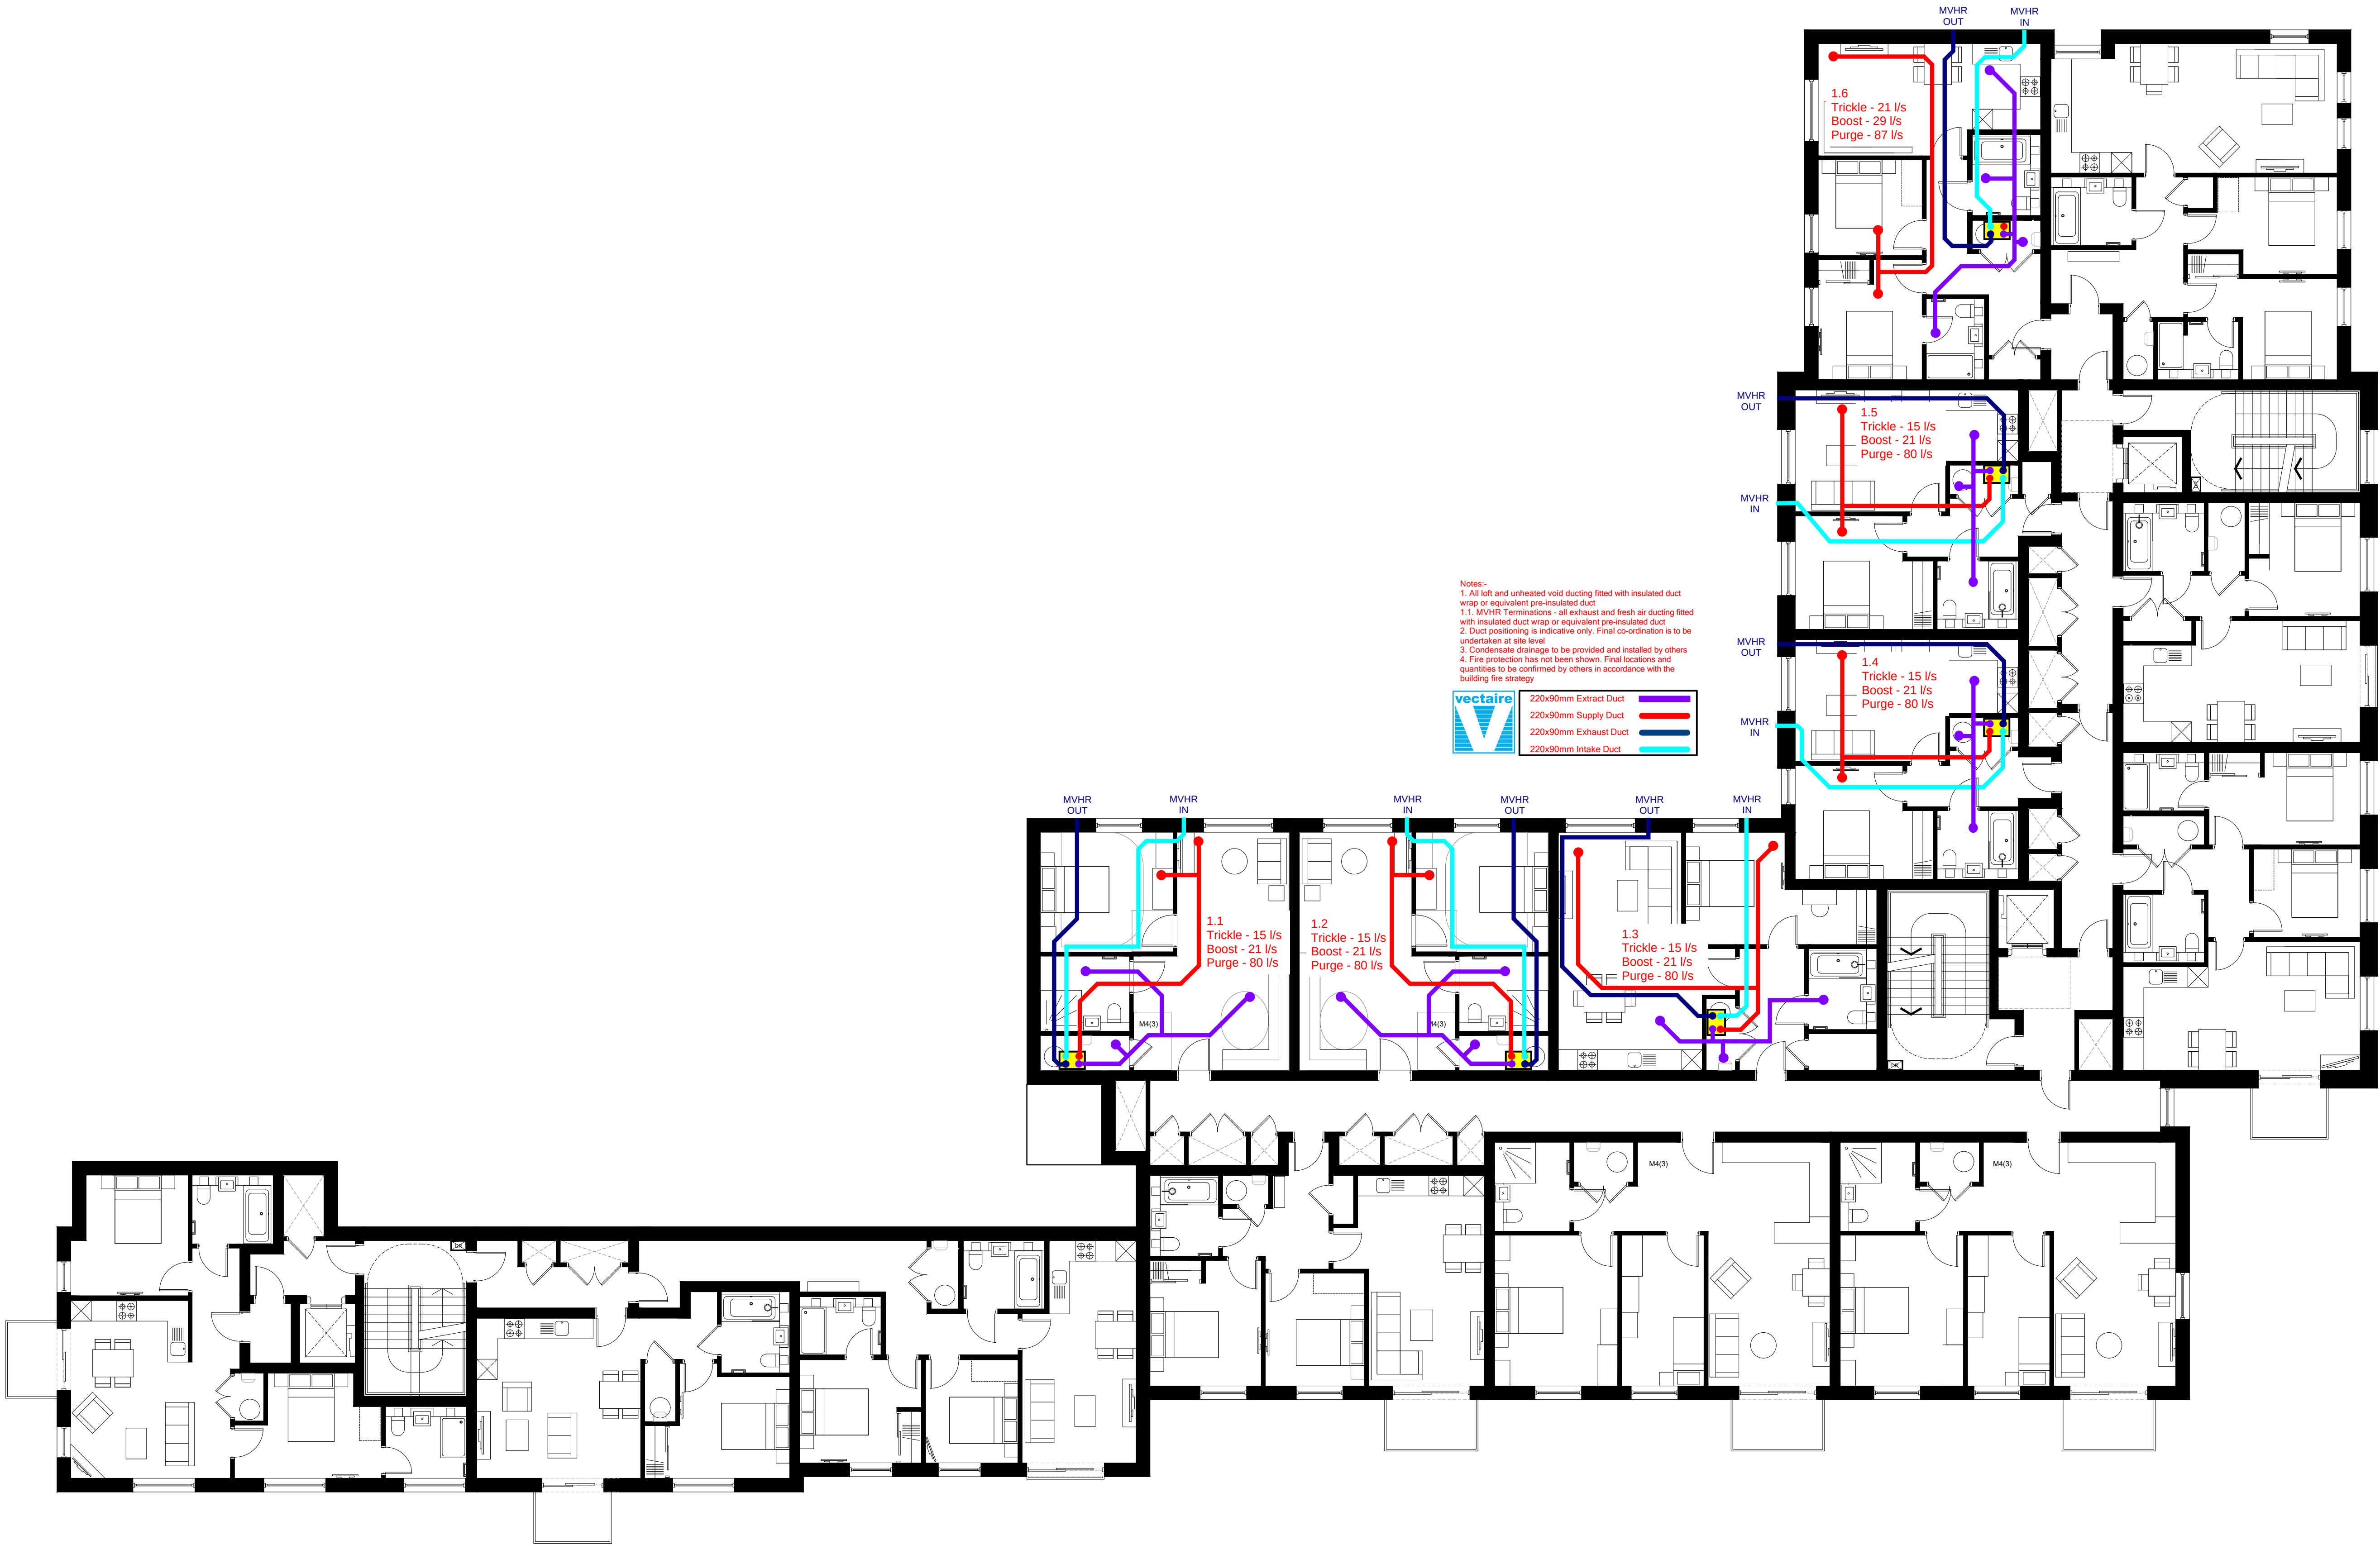

First Floor Plan



revision	date	prepared	description

Berkeley
Designed for life

Berkeley House
Farnham Lane
Farnham Royal
SL2 3RQ


T: 01753 784400
F: 01753 646855
www.berkeleygroup.co.uk

project
Vastern Road
Reading

drawing
Block B and C - MVHR Proposal
First Floor Plan

date	scale @ a1	drawn
October 2019	1:100	ISB

drawing number	revision
448.PL.BC.V.101	C

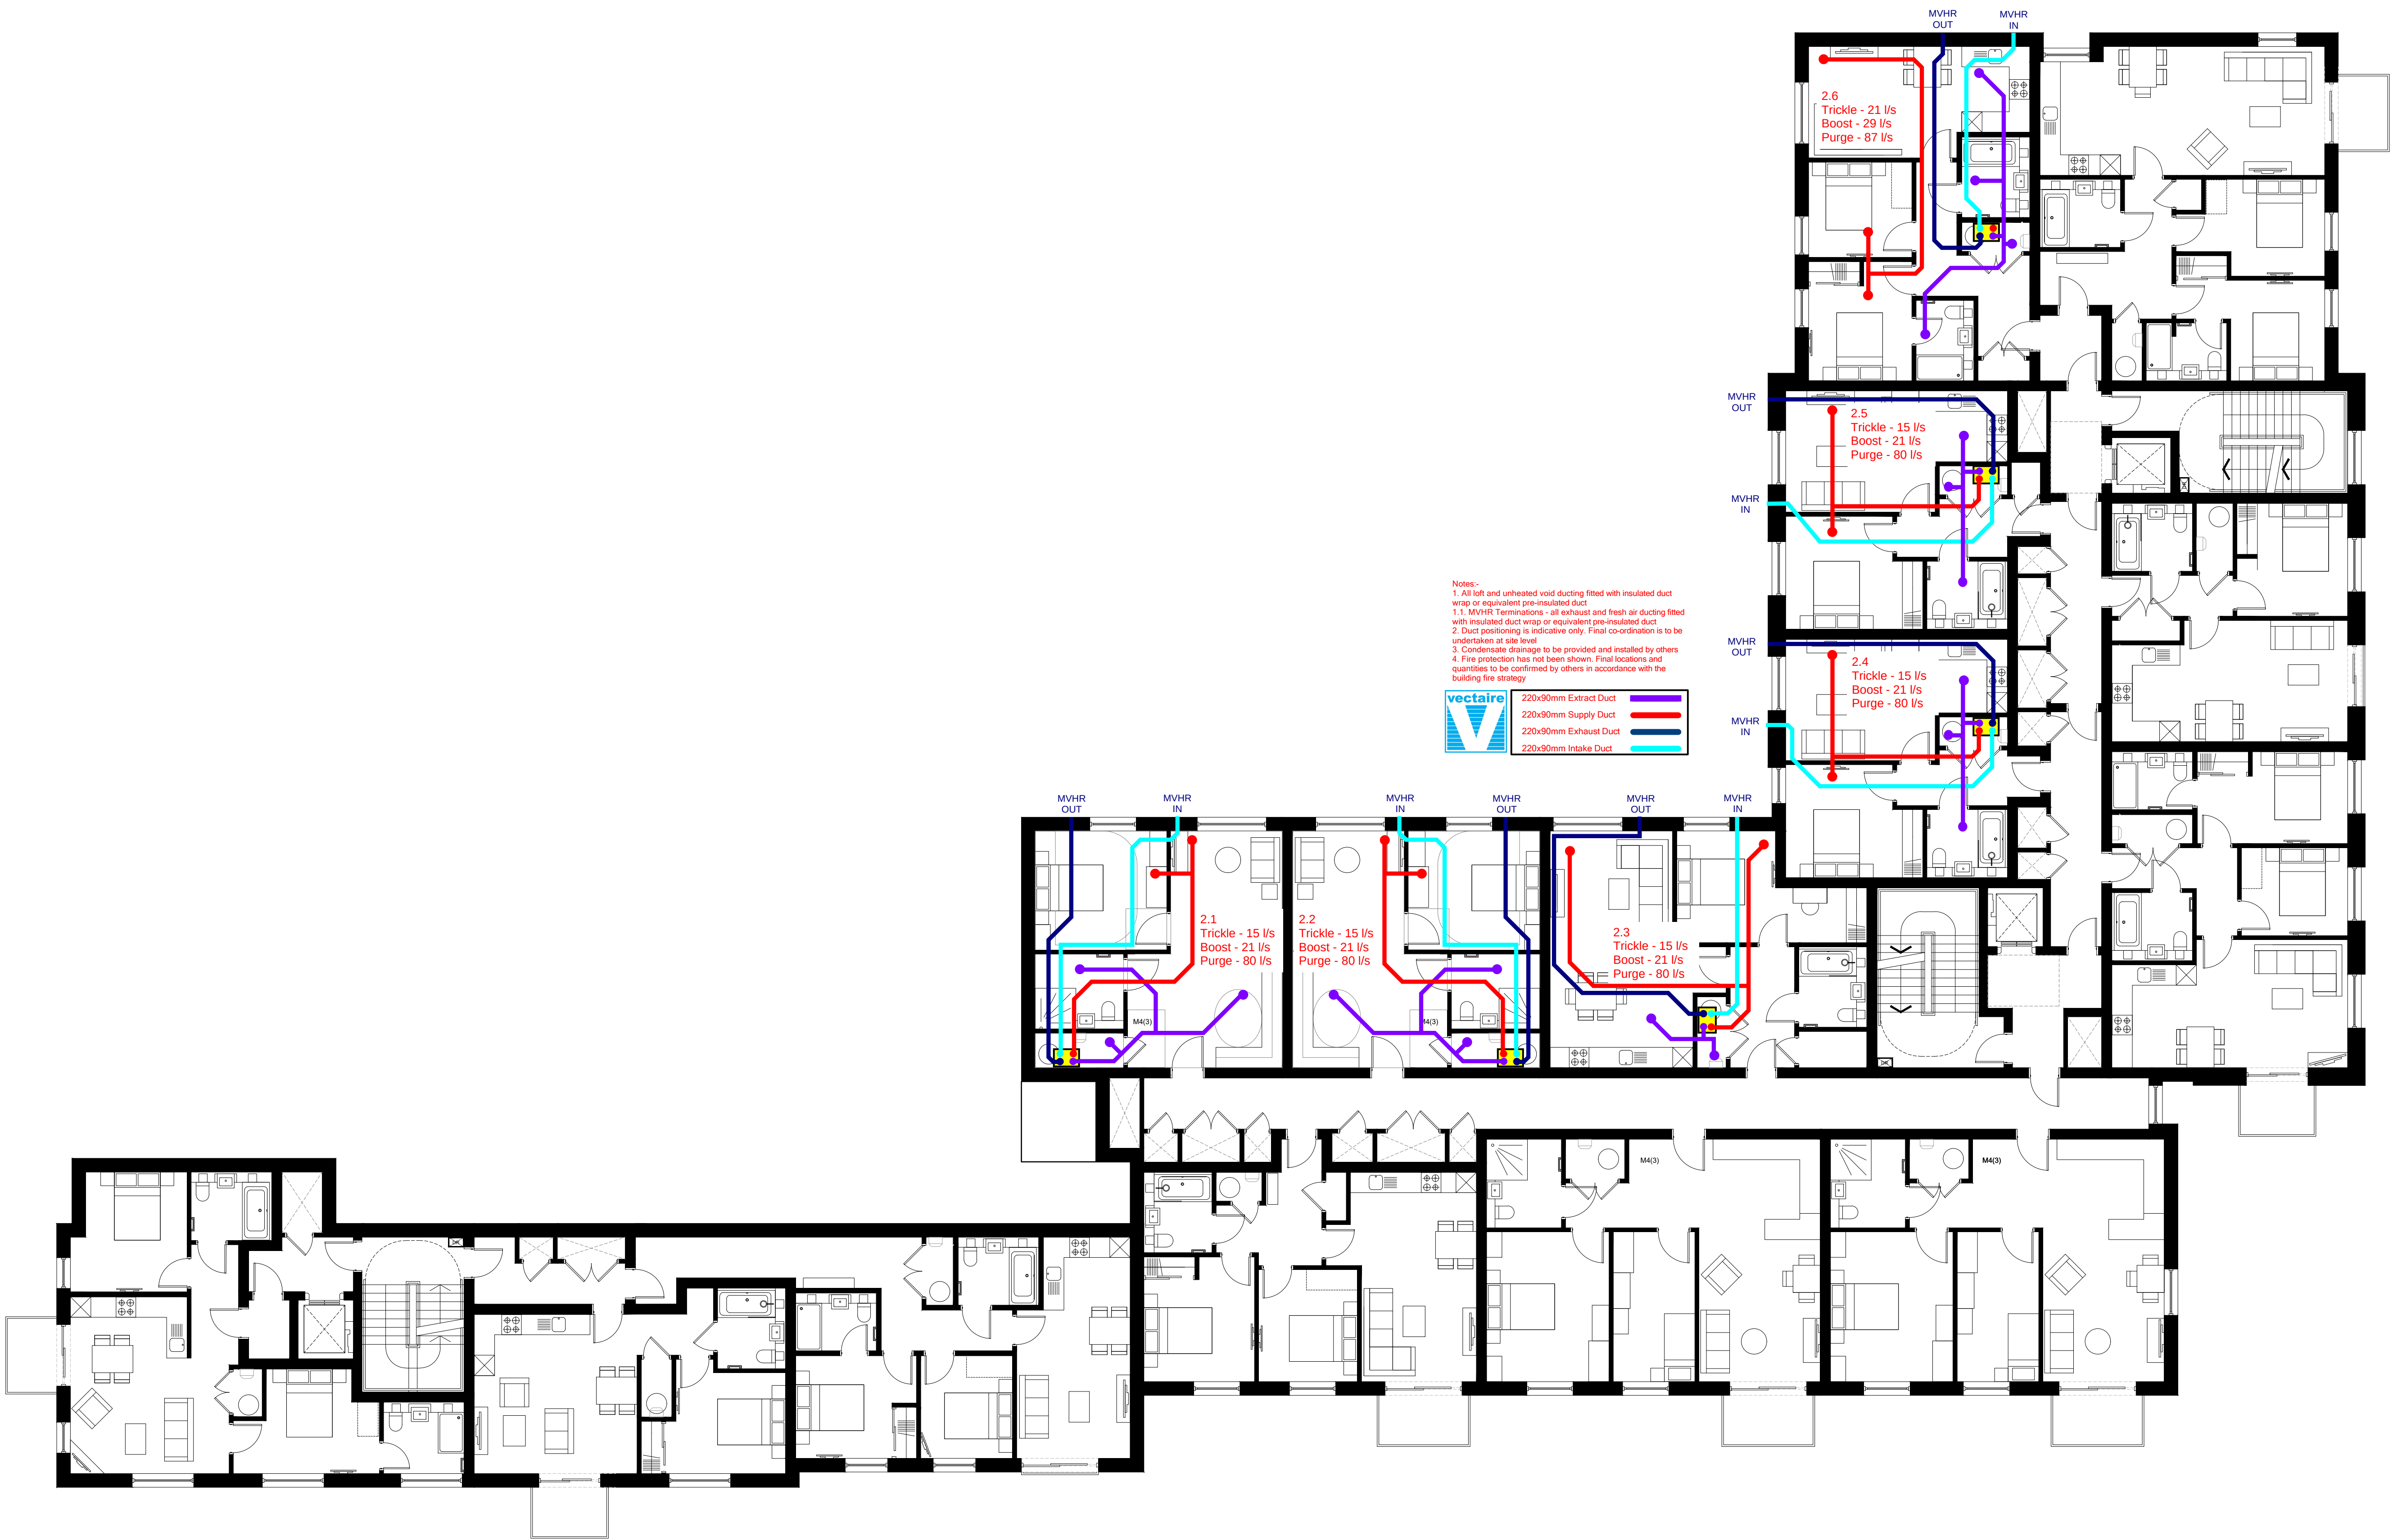

Second Floor Plan



revision
date
description

Berkeley
Designed for life

Berkeley House
Farnham Lane
Farnham Royal
SL2 3RQ

T: 01753 784400
F: 01753 648555
www.berkeleygroup.co.uk

project
Vastern Road
Reading

drawing
Block B and C - MVHR Proposal
Second Floor Plan


date
October 2019

scale @ a1
1:100

drawn
ISB

drawing number
448.PL.BC.V.102

revision
C

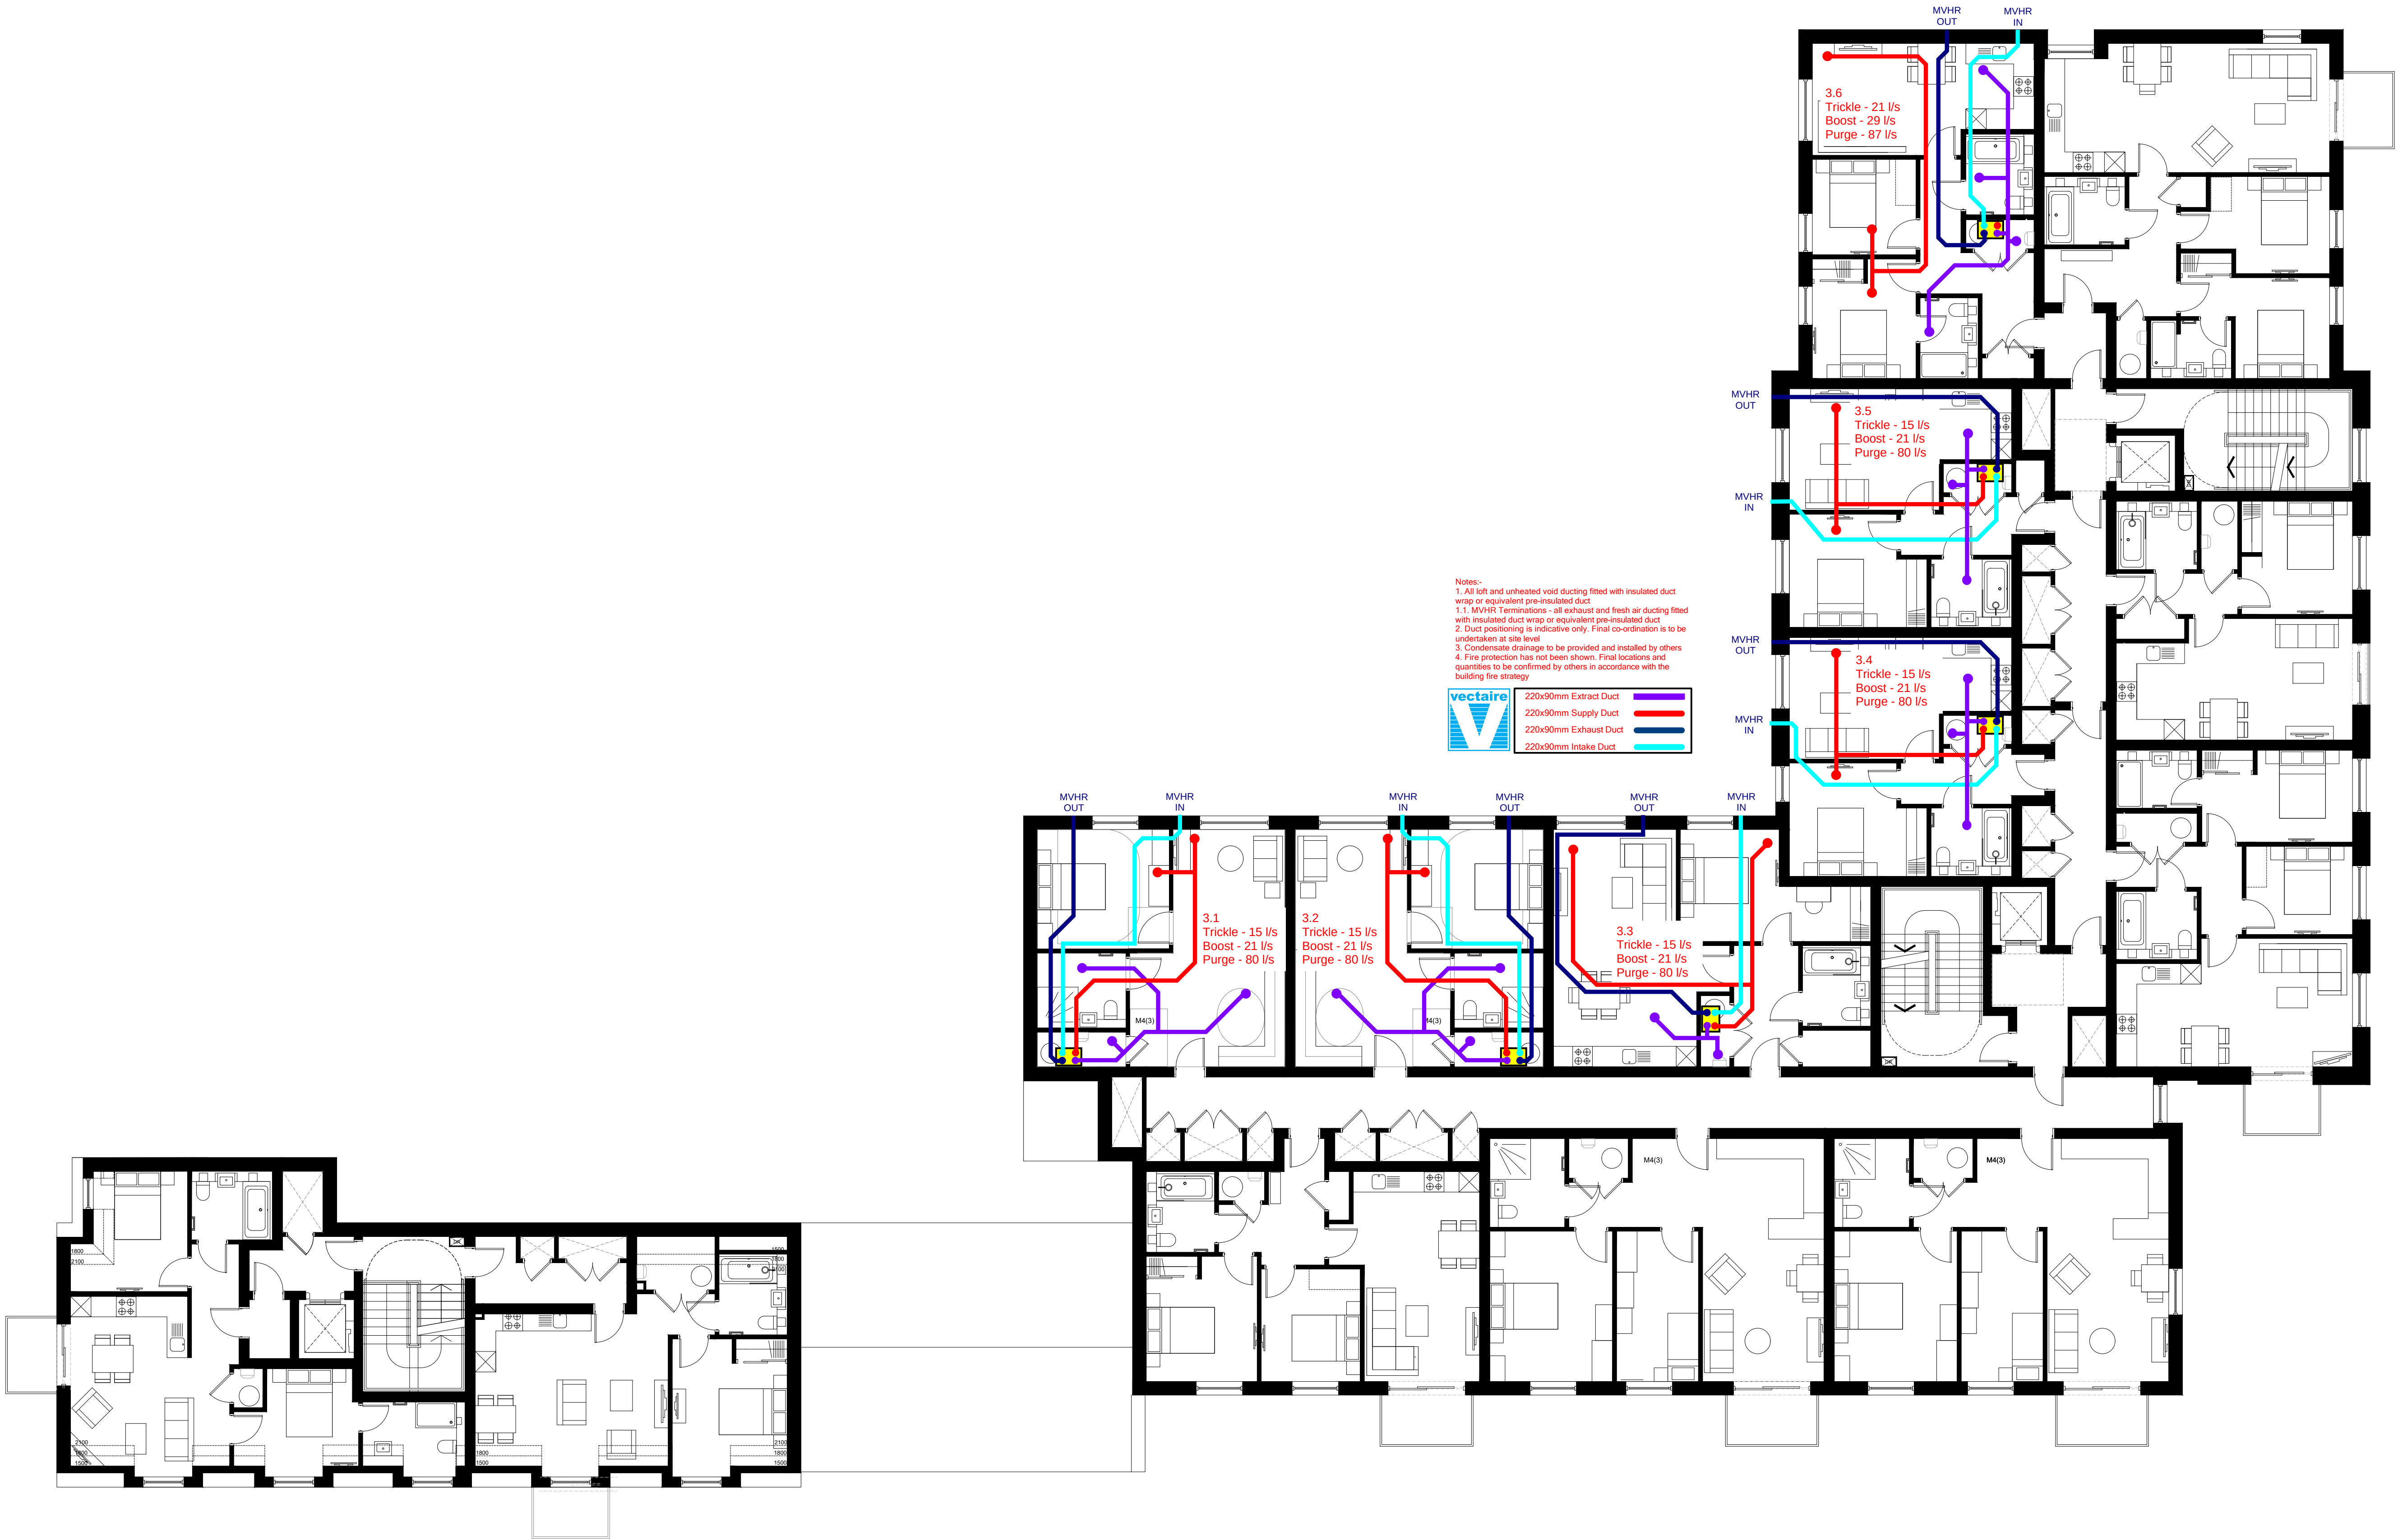

Third Floor Plan



revision
date
prepared
description

Berkeley
Designed for life

Berkeley House
Farnham Lane
Farnham Royal
SL2 3RQ

T: 01753 784400
F: 01753 646855
www.berkeleygroup.co.uk

project
Vastern Road
Reading

drawing
Block B and C - MVHR Proposal
Third Floor Plan



date
October 2019

scale @ a1
1:100

drawn
ISB

drawing number
448.PL.BC.V.103

revision
C

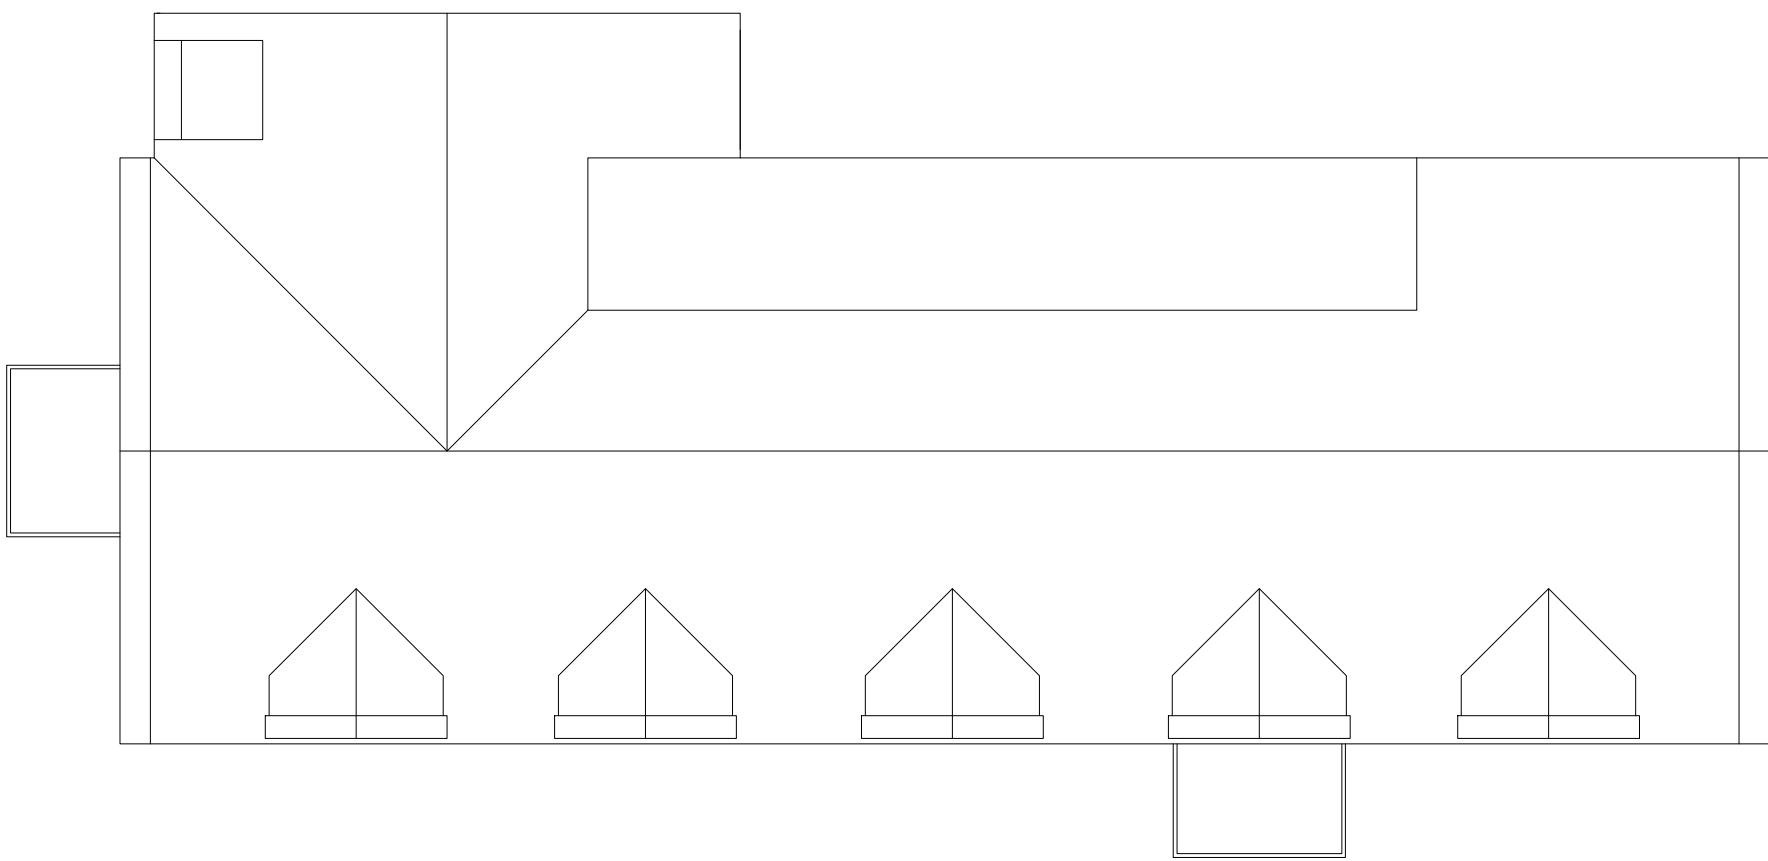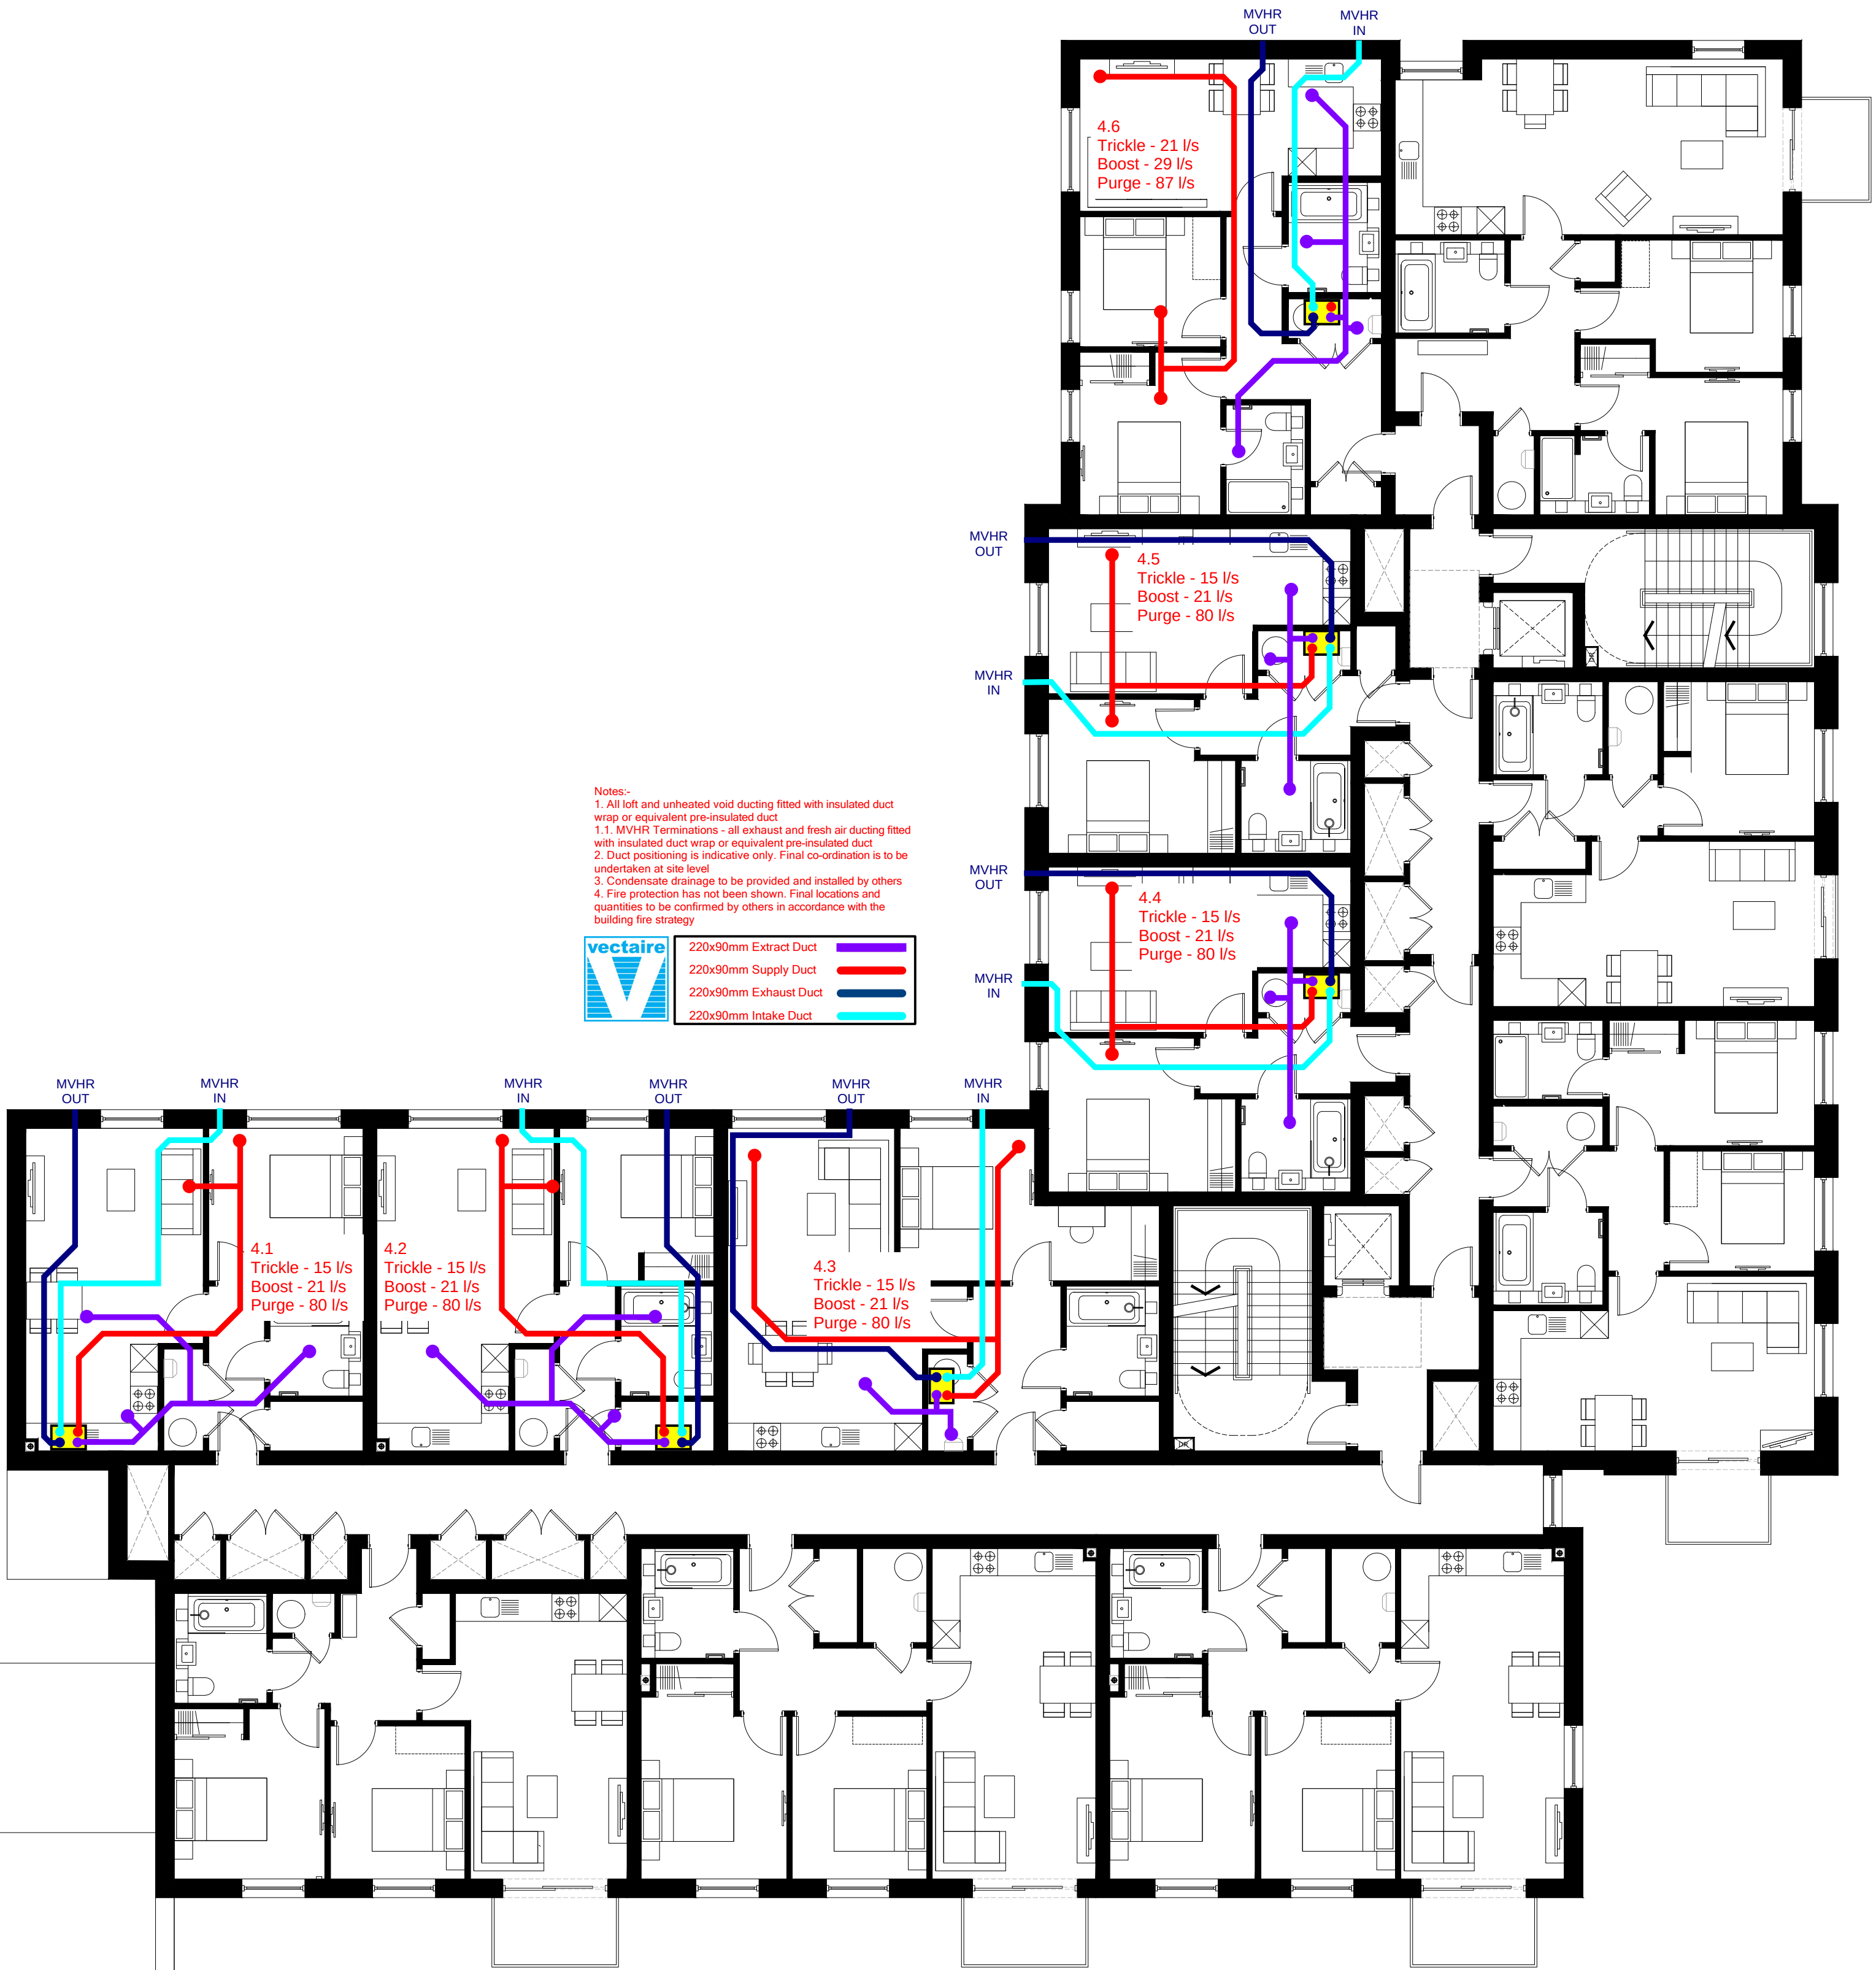

Fourth Floor Plan



revision	date	prepared	description
----------	------	----------	-------------

Berkeley
Designed for life

Berkeley House
Farnham Lane
Farnham Royal
SL2 3RQ


T: 01753 784400
F: 01753 646855
www.berkeleygroup.co.uk

project
Vastern Road
Reading

drawing
Block B and C - MVHR Proposal
Fourth Floor Plan

date	scale @ a1	drawn
October 2019	1:100	ISB

drawing number	revision
448.PL.BC.V.104	C

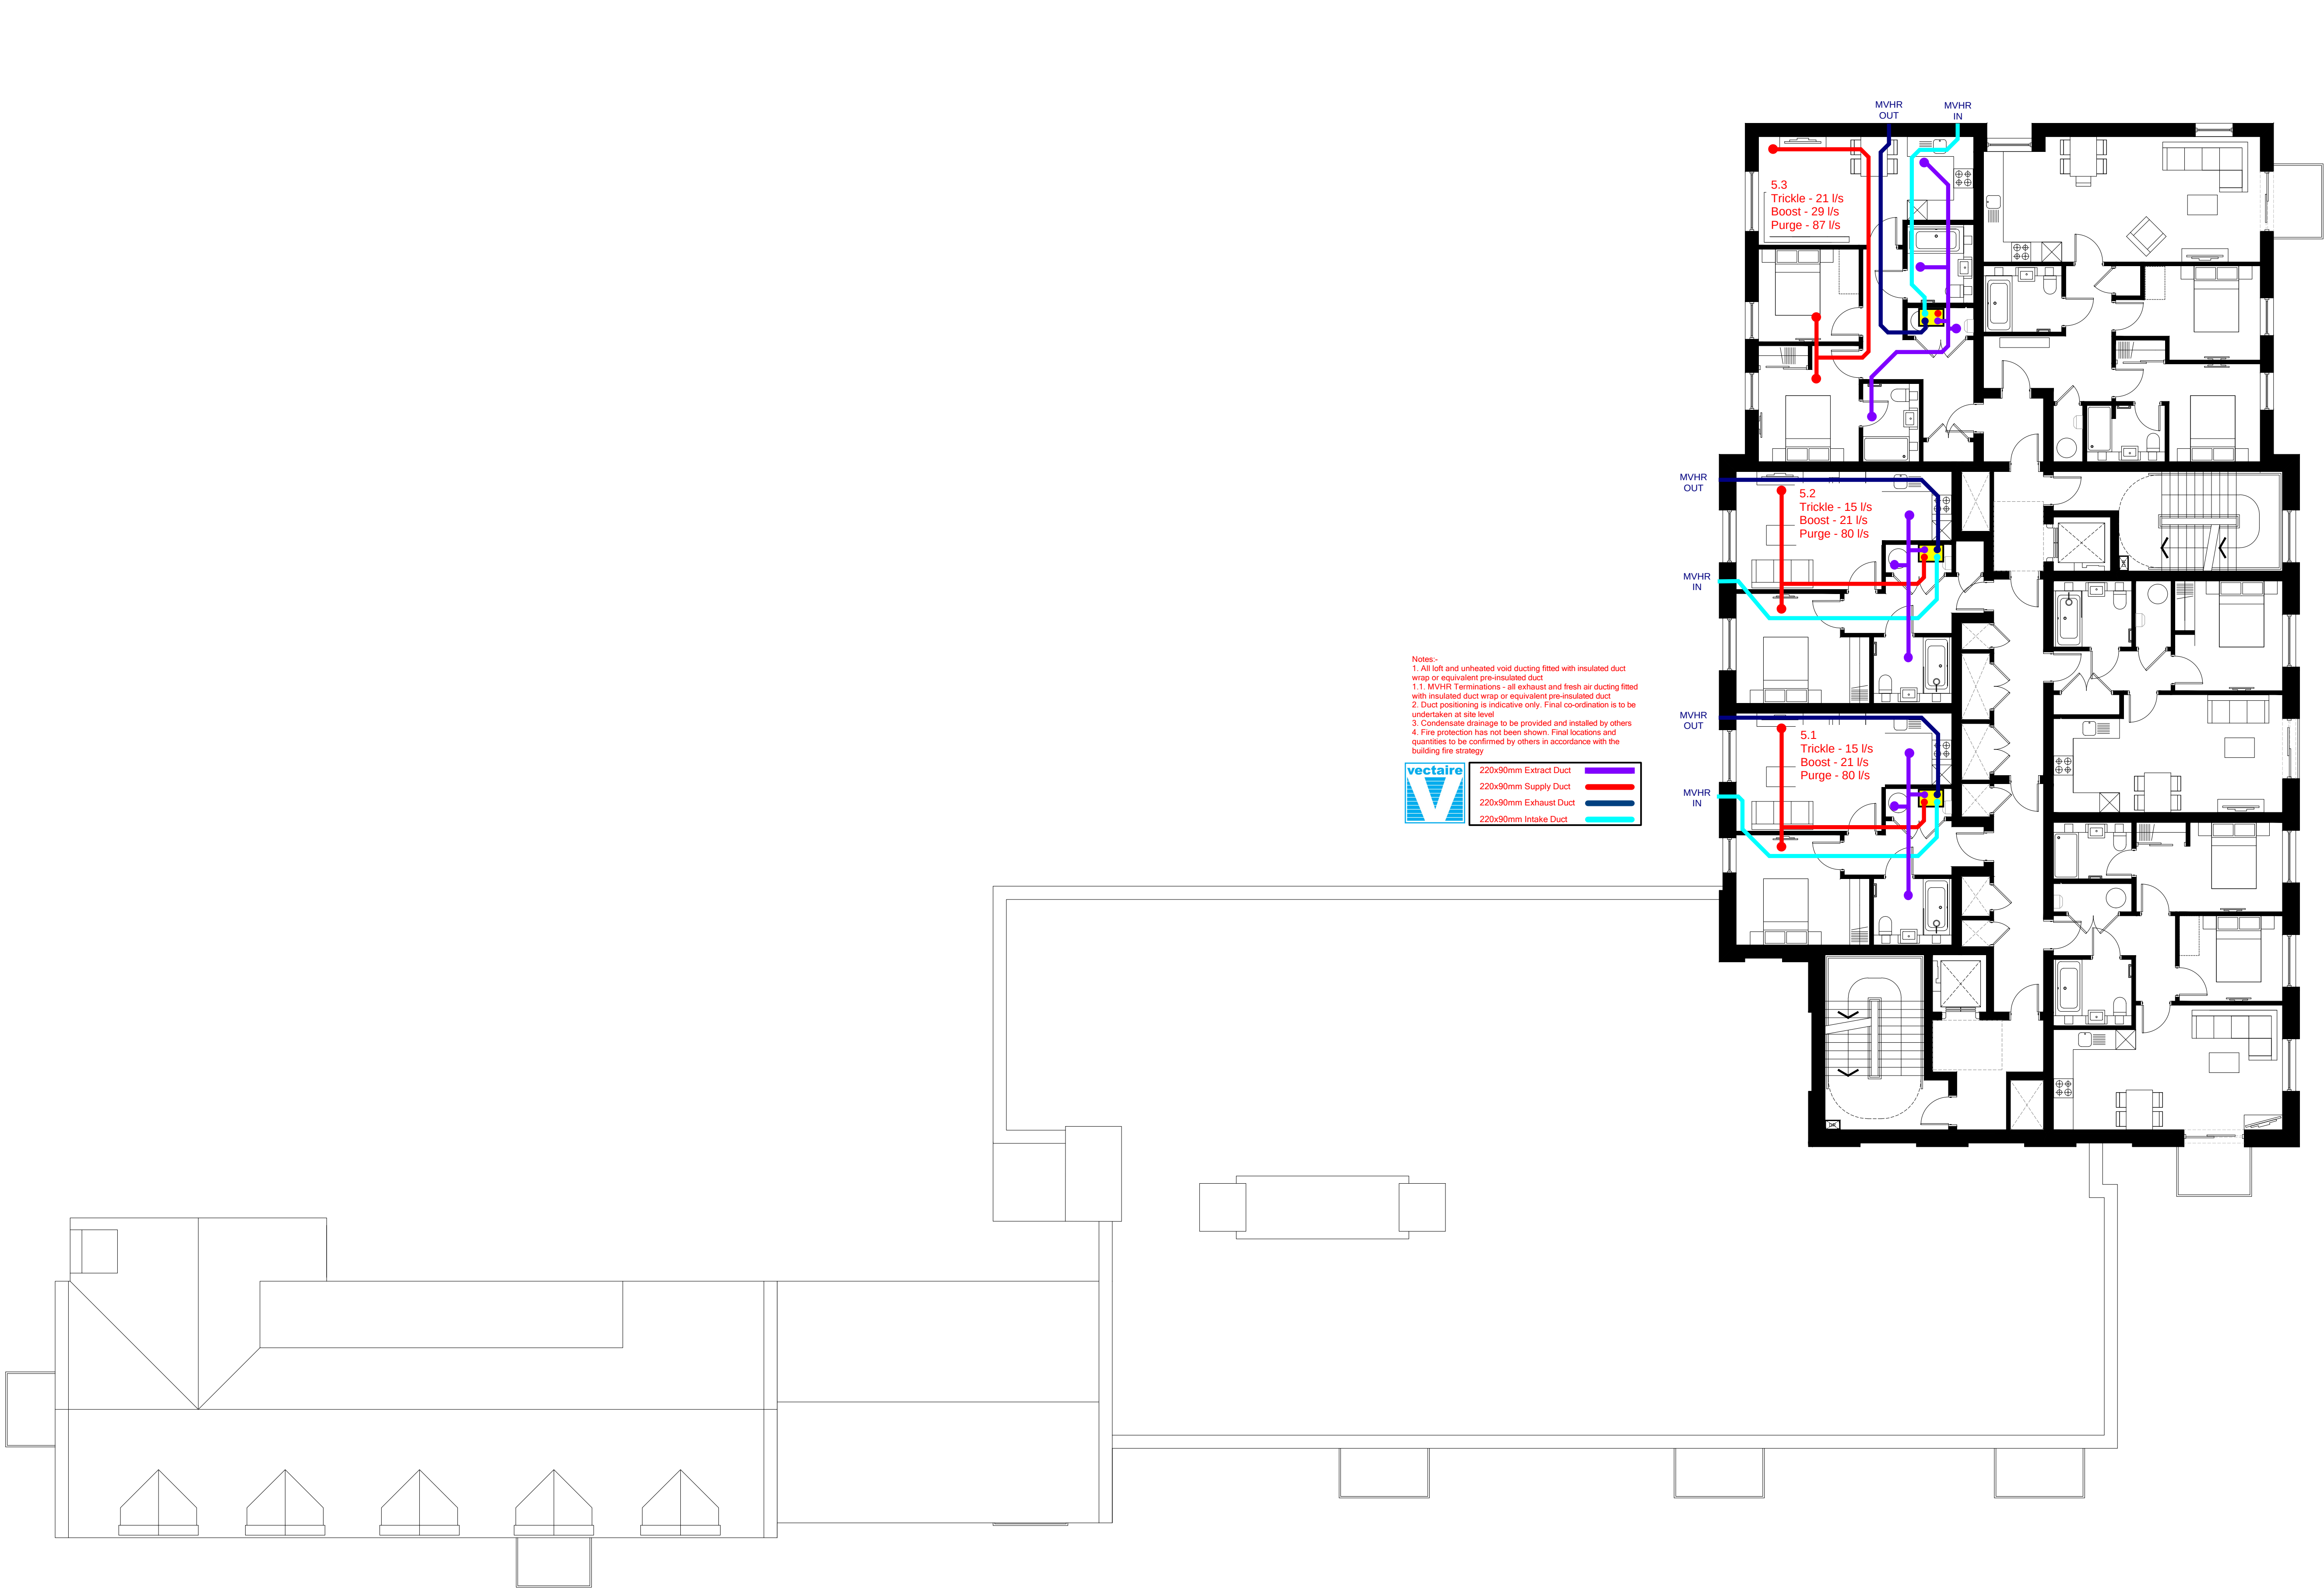

Fifth Floor Plan

key plan


notes

- Notes:-
- 1. All loft and unheated void ducting fitted with insulated duct wrap or equivalent pre-insulated duct
 - 1.1. MVHR Terminations - all exhaust and fresh air ducting fitted with insulated duct wrap or equivalent pre-insulated duct
 - 2. Duct positioning is indicative only. Final co-ordination is to be undertaken at site level
 - 3. Condensate drainage to be provided and installed by others
 - 4. Fire protection has not been shown. Final locations and quantities to be confirmed by others in accordance with the building fire strategy


	220x90mm Extract Duct	
	220x90mm Supply Duct	
	220x90mm Exhaust Duct	
	220x90mm Intake Duct	


revision	date	prepared	description
Berkeley House Farnham Lane Farnham Royal SL2 3RQ		T: 01753 784400 F: 01753 646855 www.berkeleygroup.co.uk	
project Vastern Road Reading			
drawing Block B and C - MVHR Proposal Fifth Floor Plan			
date	scale @ a1	drawn	
October 2019	1:100	ISB	
drawing number	revision		
448.PL.BC.V.105	C		




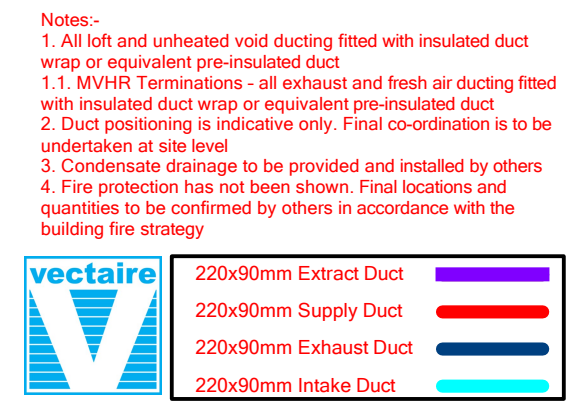

drawing number 448.PL.BC.V.106 revision C

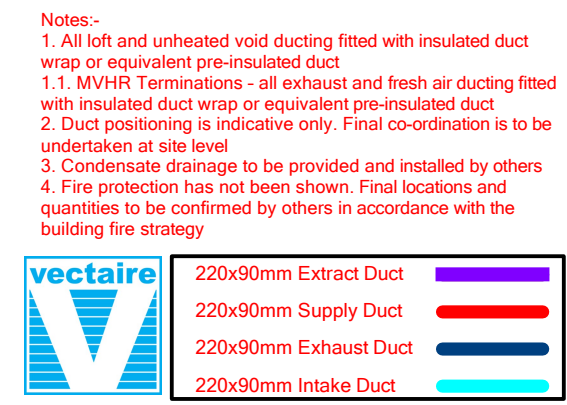

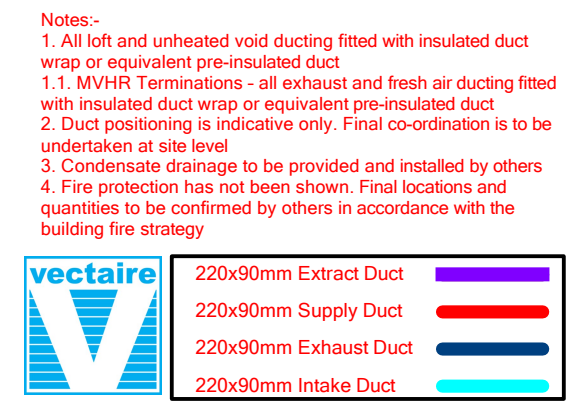

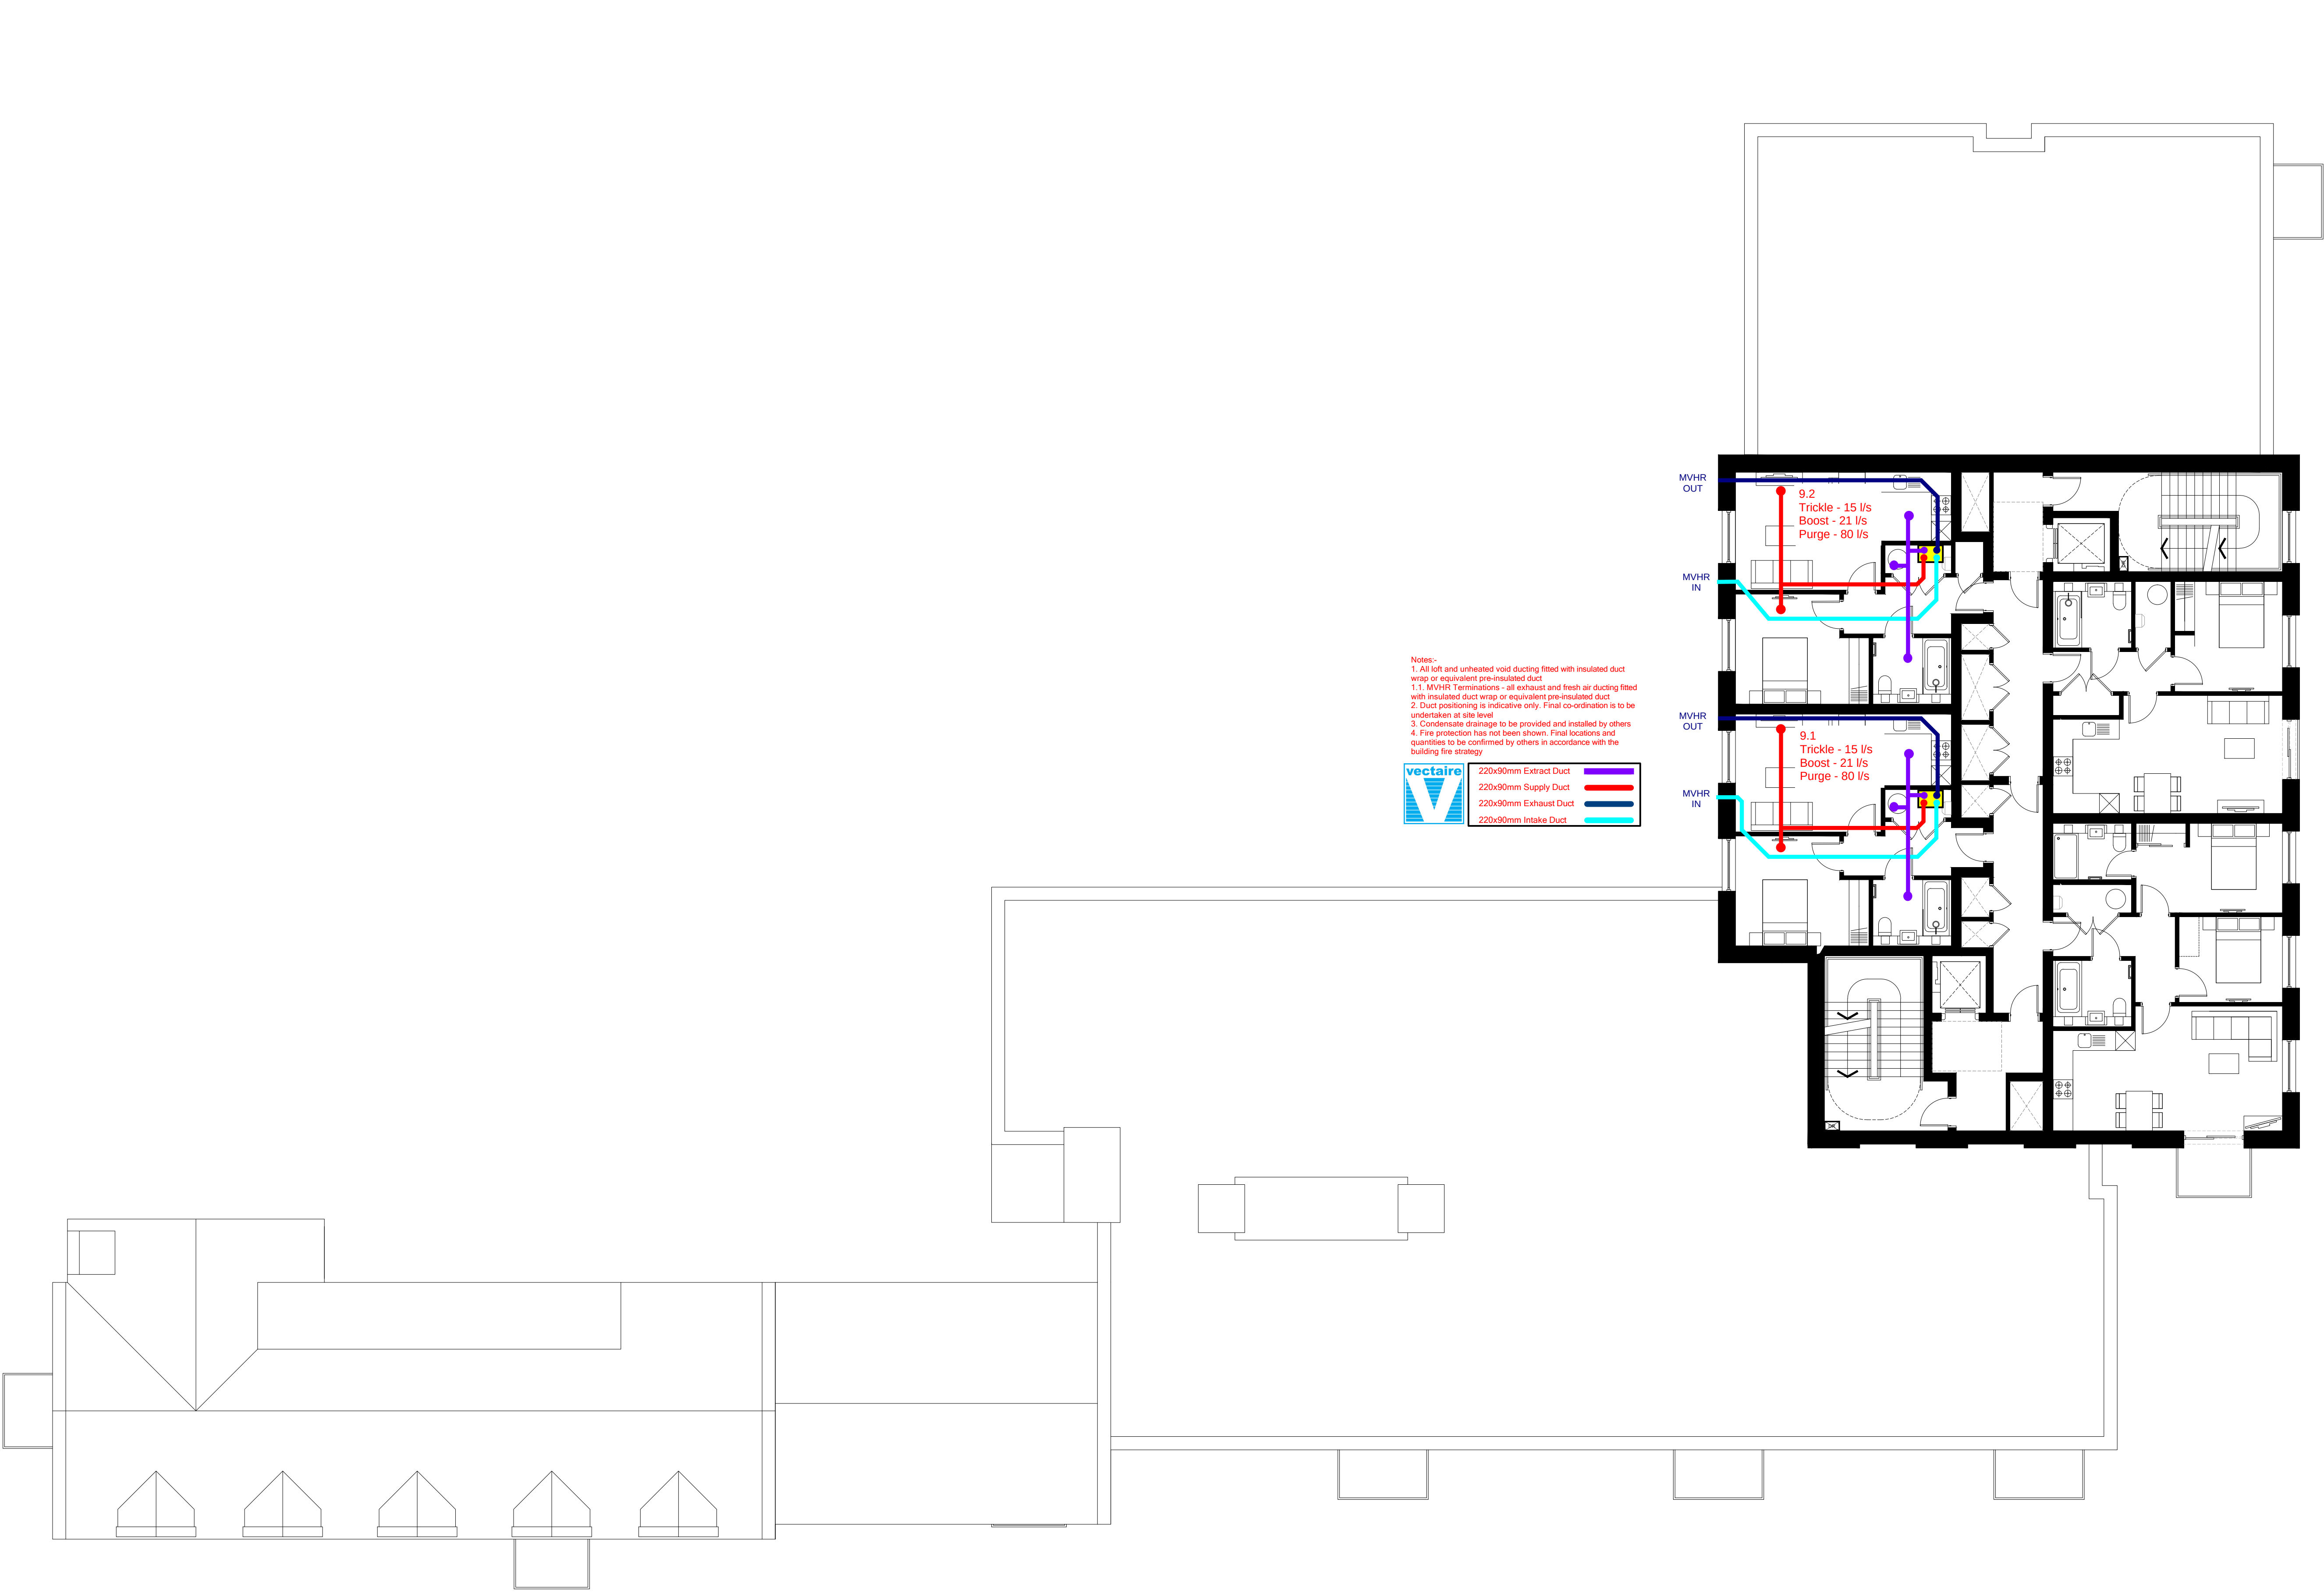


Ninth Floor Plan




key plan

notes

revision	date	prepared	description
Berkeley Designed for life			
Berkeley House Farnham Lane Farnham Royal SL2 3RQ		T: 01753 784400 F: 01753 646855 www.berkeleygroup.co.uk	
project Vastern Road Reading			
drawing Block B and C - MVHR Proposal Ninth Floor Plan			
date	scale @ a1	drawn	revision
October 2019	1:100	ISB	
drawing number 448.PL.BC.V.109			revision C

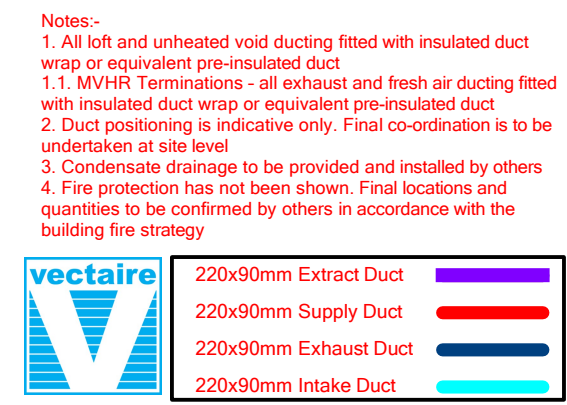

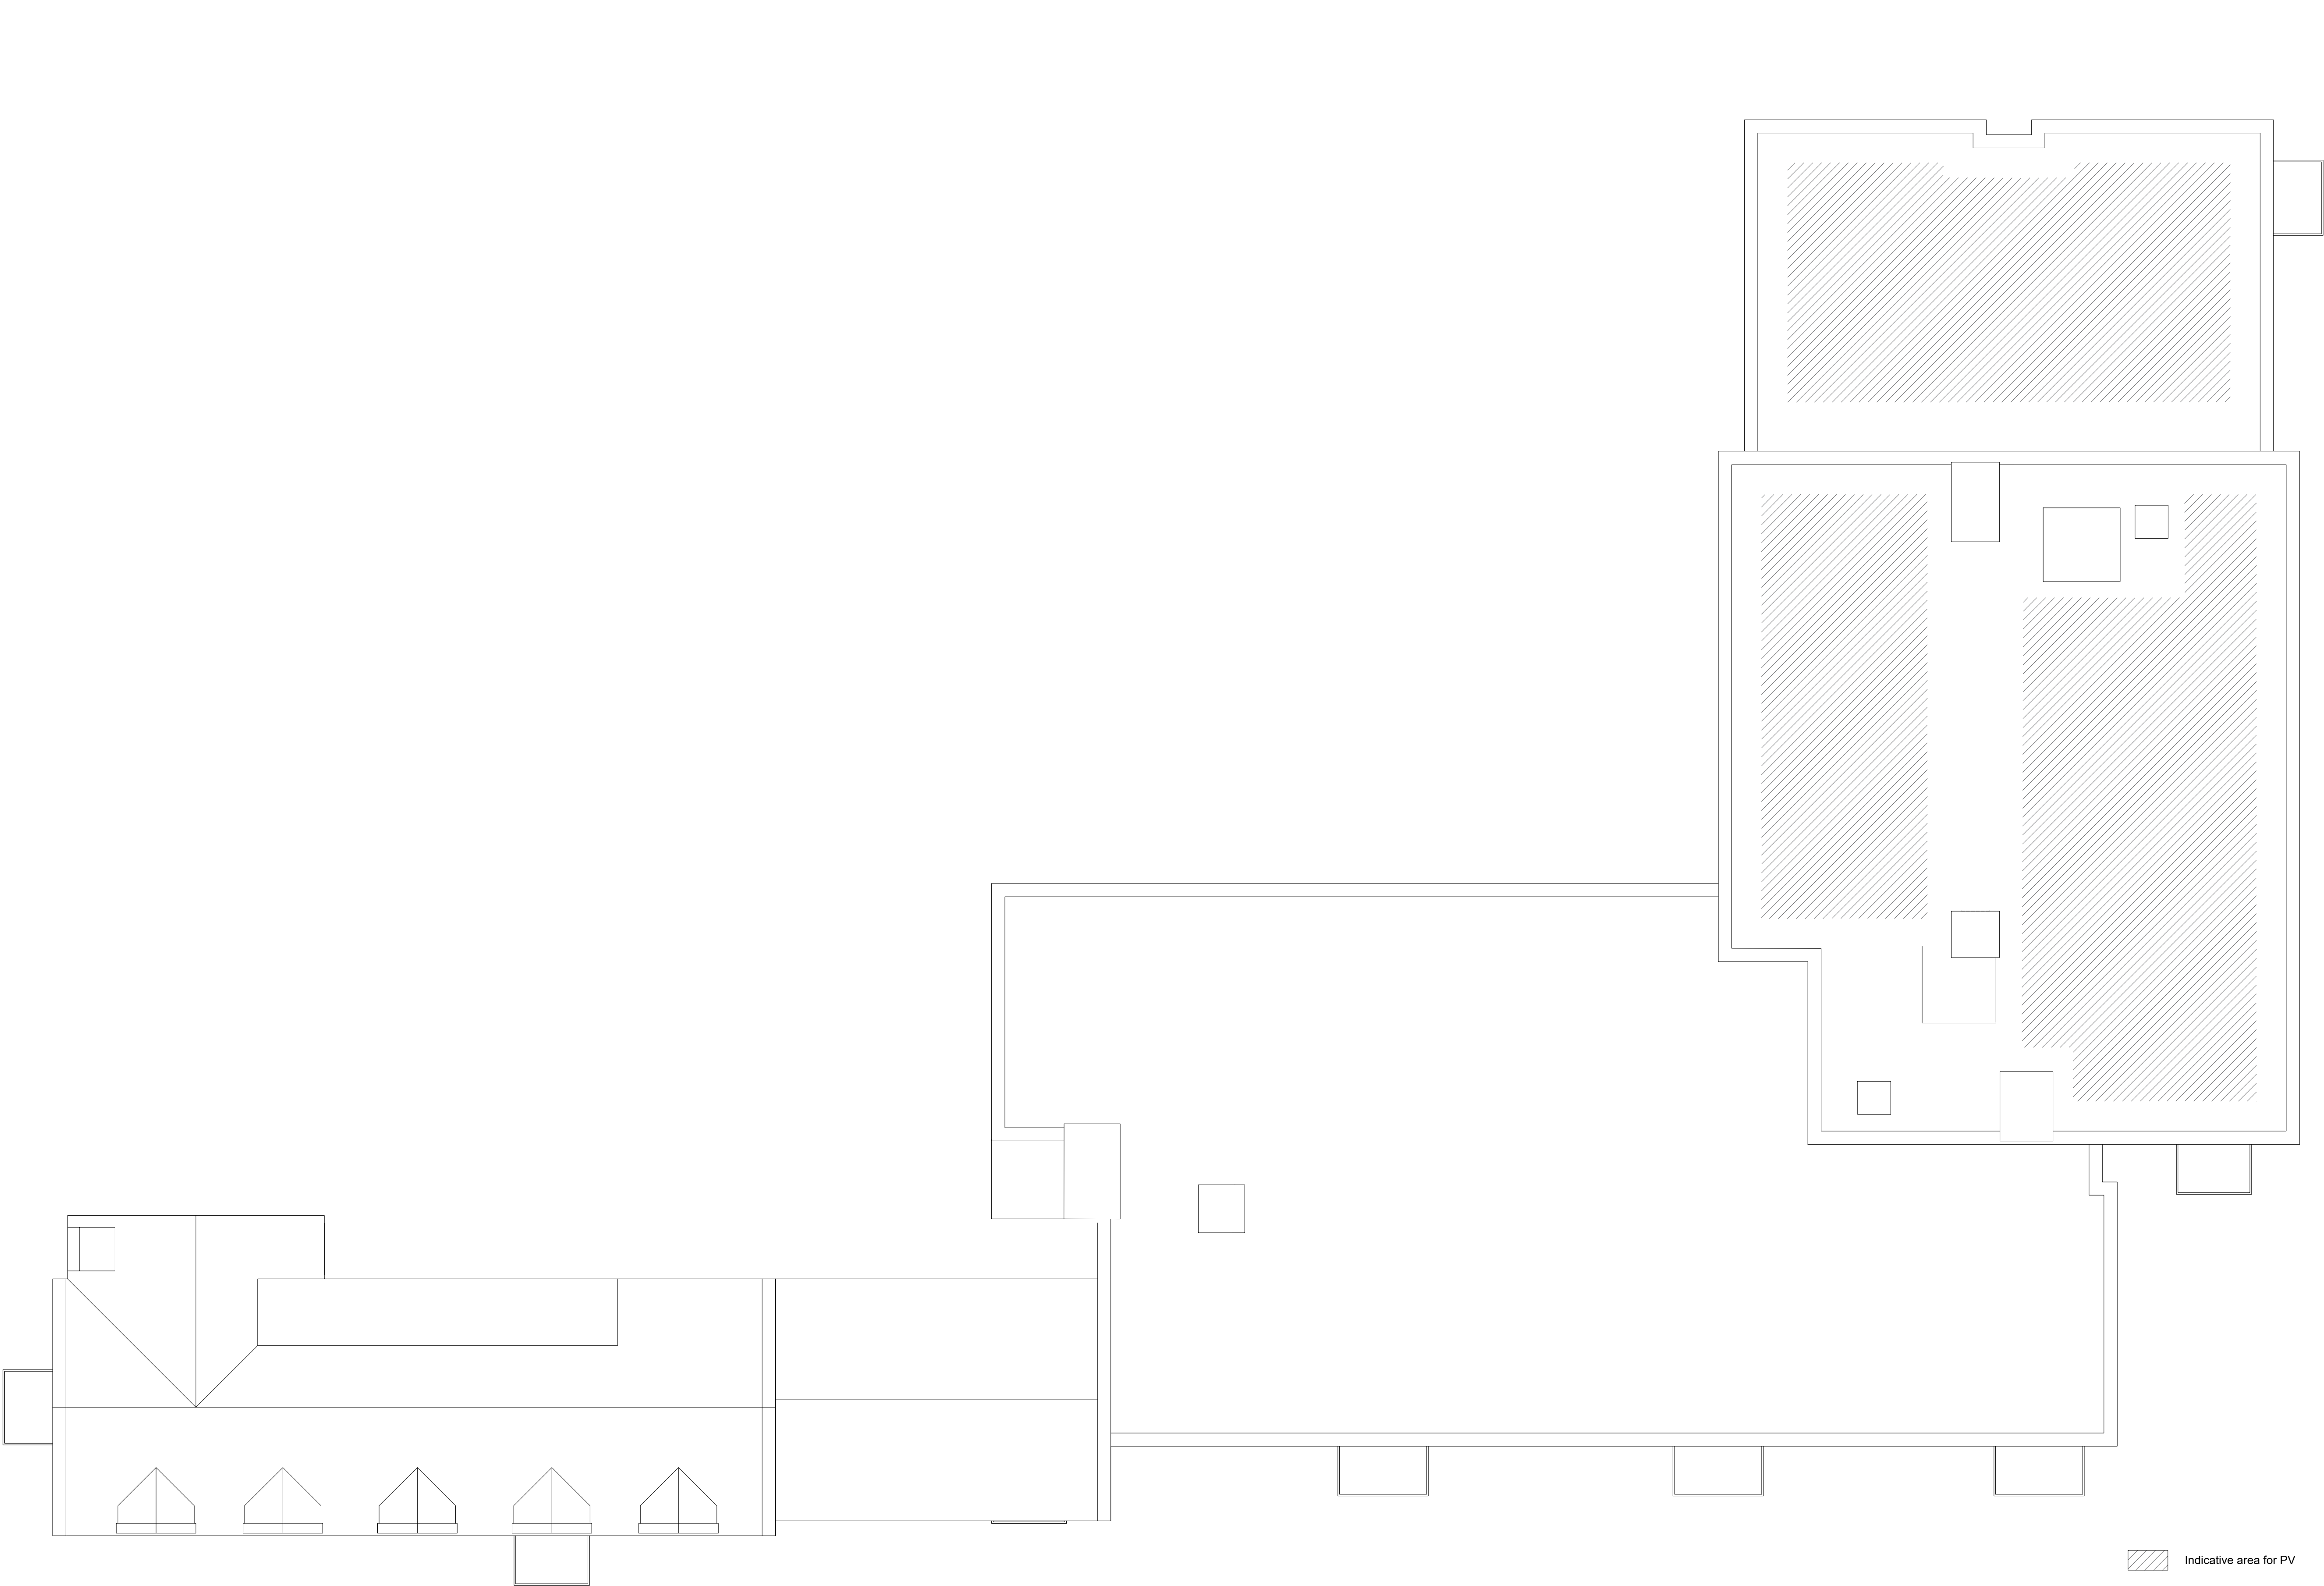

Roof Plan



Indicative area for PV

key plan

notes

revision	date	prepared	description
----------	------	----------	-------------

Berkeley
Designed for life

Berkeley House
Farnham Lane
Farnham Royal
SL2 3RQ

T: 01753 784400
F: 01753 646855
www.berkeleygroup.co.uk

project Vastern Road Reading			
drawing Block B and C Roof Plan			
date November 2021	scale @ a1 1:100	drawn EE	revision
drawing number 448.PL.BC.V.111			revision C