


FILE LOCATION PATH: P:\PROJECTS\HOT13113 300 BROOK DRIVE\04 BIM\CIVIL\DRAWINGS\3113-CIV-XX-XX-D-C-30004_PROPOSED SW DRAINAGE FOR PLANNING.DWG

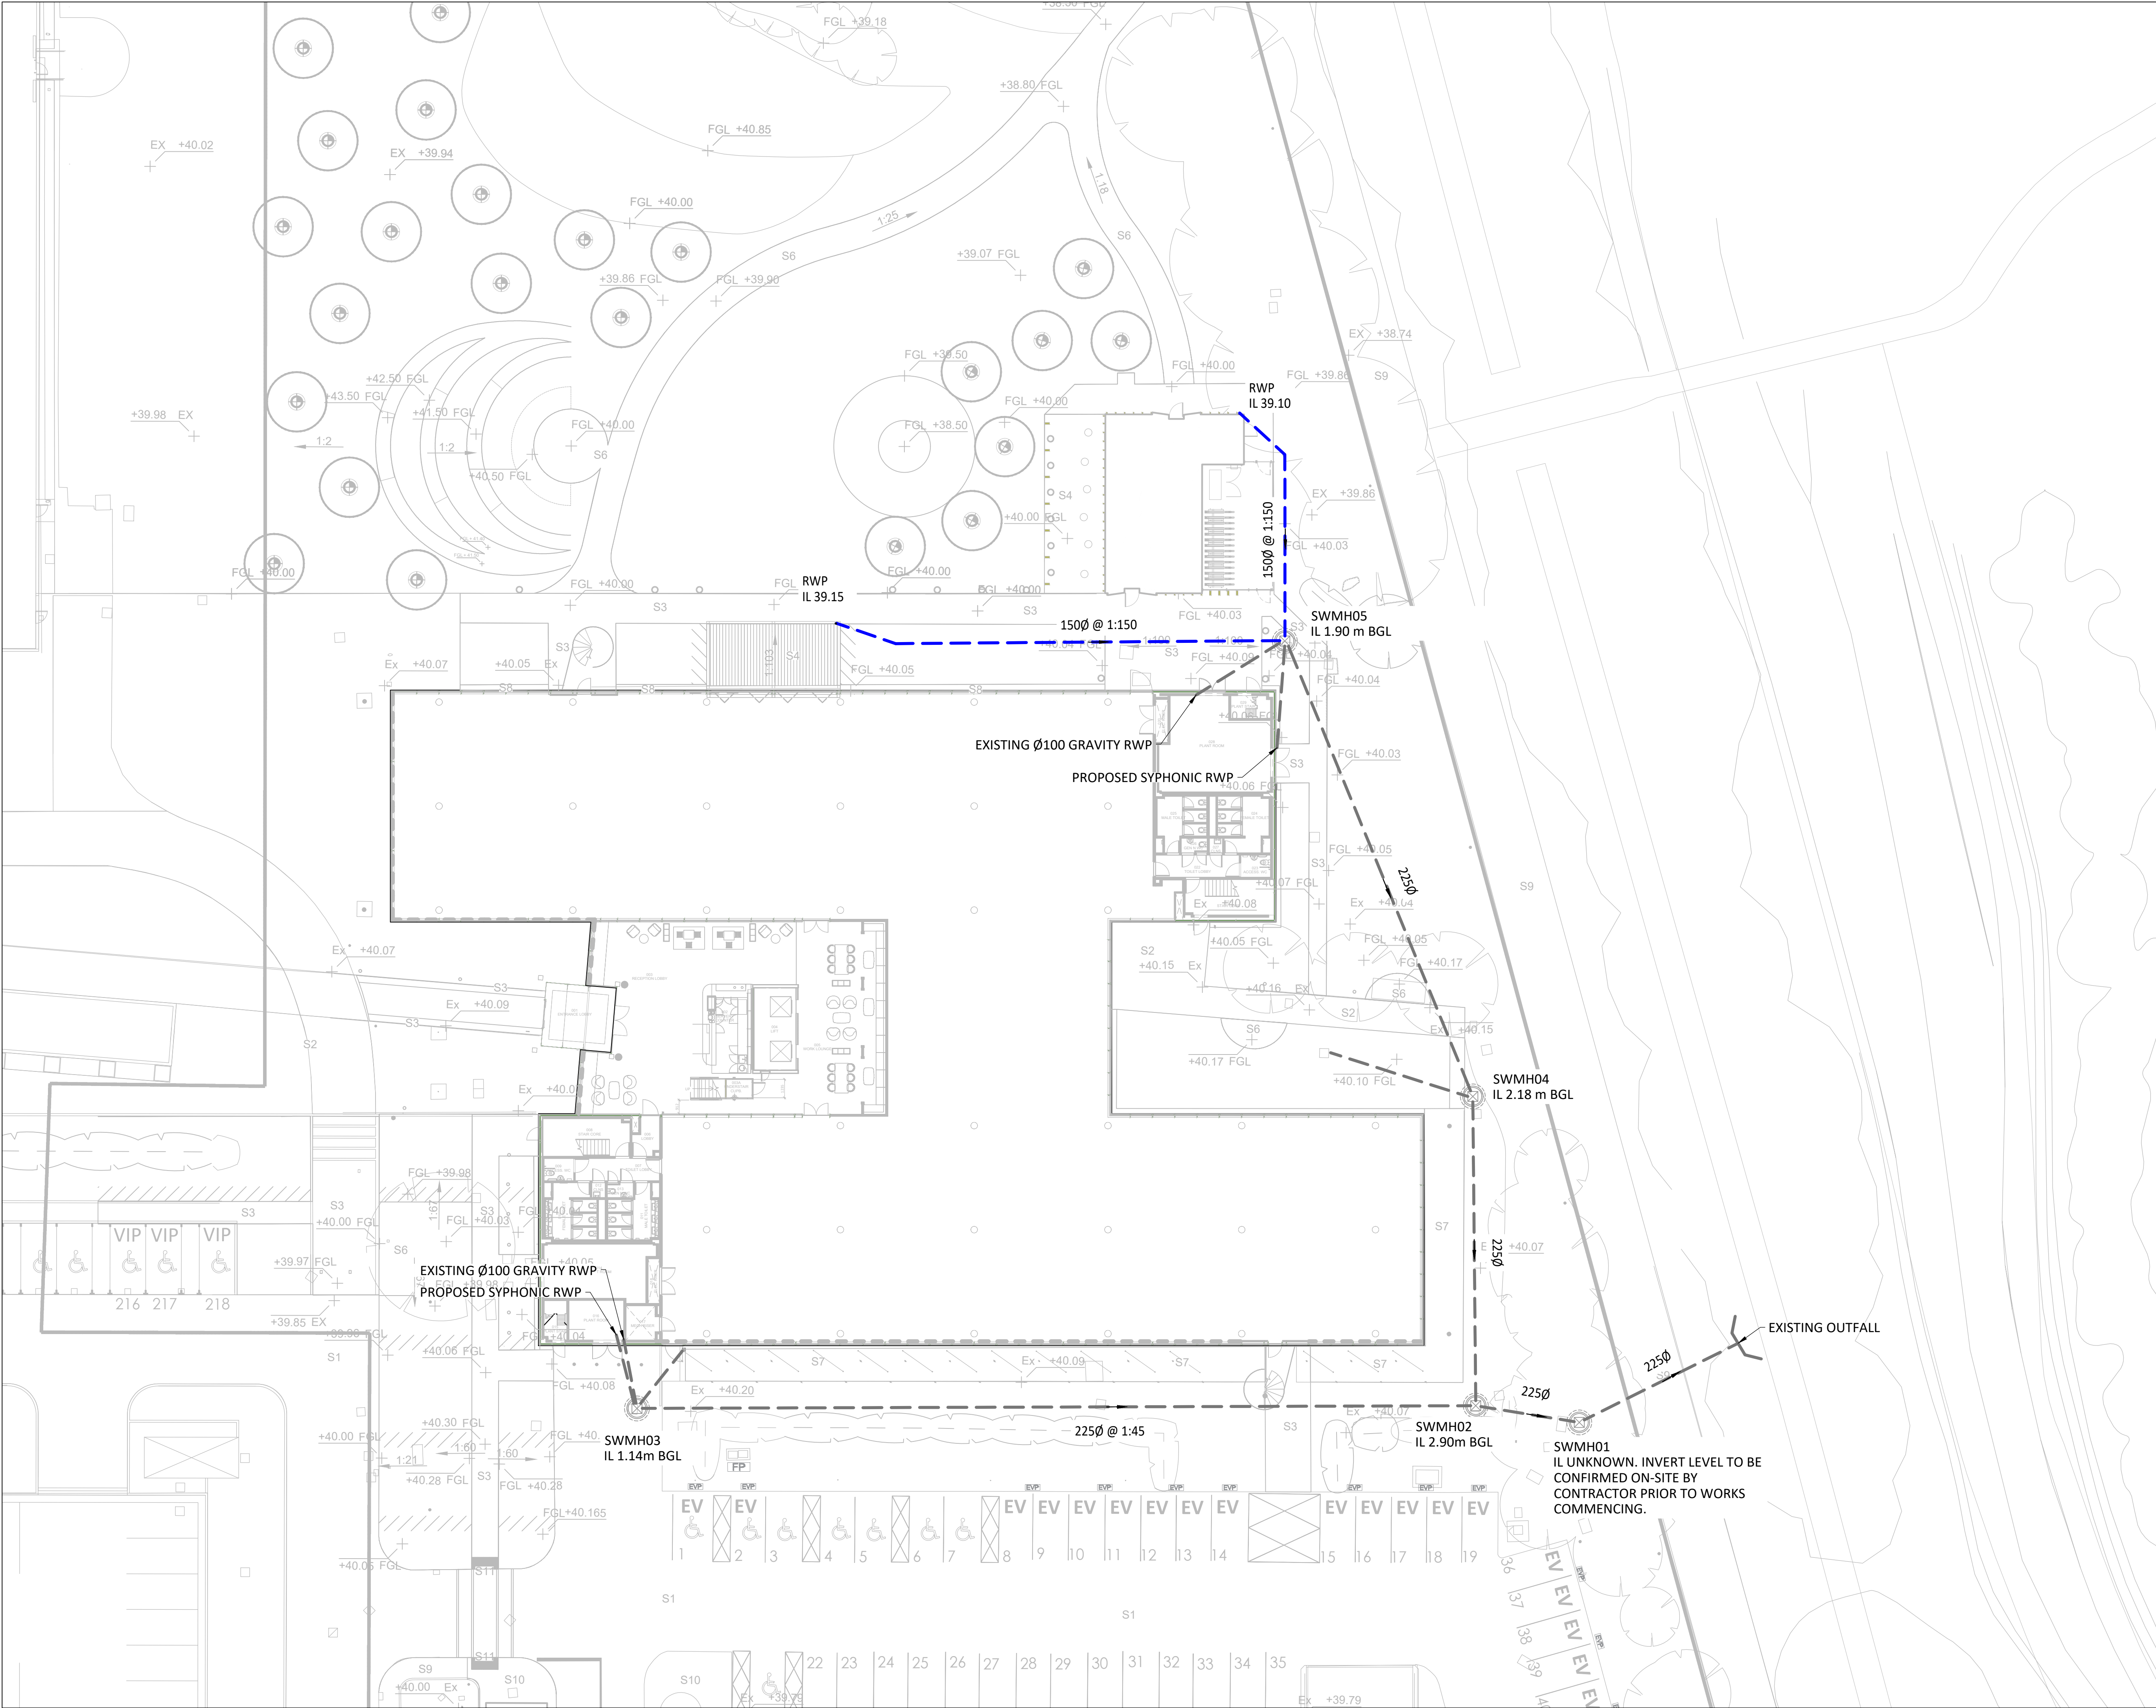

- STANDARD NOTES
- THIS DRAWING IS TO BE READ IN CONJUNCTION WITH ALL RELEVANT ARCHITECTS AND ENGINEER'S DRAWINGS AND THE SPECIFICATIONS.
 - THIS DRAWING SHOULD NOT BE SCALED.
 - ALL DIMENSIONS ARE TO BE VERIFIED BY THE CONTRACTOR ON SITE.
 - ALL DISCREPANCIES SHOULD BE REPORTED TO C.A./E.A. PRIOR TO THE COMMENCEMENT OF WORKS.

- © CIVIC ENGINEERS LIMITED
- DRAWING NOTES
- DESIGN IS BASED ON:
 - PLACE DESIGN LANDSCAPE GENERAL ARRANGEMENT DRAWING 1004-PL-001 DATED 29.10.2024
 - JPD TECHNICAL SERVICE LTS DRAINAGE SURVEY DATED 30.04.2024
 - MURPHY GEOSPATIAL CCTV REPORT DATED 27.10.2023
 - CONNECTION TO THE PUBLIC SEWER WILL REQUIRE APPROVAL FROM THAMES WATER. IT IS THE RESPONSIBILITY OF THE CONTRACTOR TO ENSURE THE APPROVAL IS IN PLACE PRIOR TO COMMENCING WORK.
 - CONTRACTOR TO CONFIRM EXISTING INVERT LEVELS PRIOR TO COMMENCEMENT OF CONSTRUCTION.
 - THE PROPOSED DESIGN IS FOR NO FLOODING DURING THE 1 IN 100 YEAR EVENT + 40% CLIMATE CHANGE ALLOWANCE.

KEY

- EXISTING SURFACE WATER DRAIN
- PROPOSED SURFACE WATER DRAIN
- EXISTING SURFACE WATER INSPECTION CHAMBER

17.07.25

P01

ISSUED FOR INFORMATION

SS

RW

DATE

REV

DESCRIPTION

DRAWN

CHKD

CIVIC

ENGINEERS

civicingengineers.com

PROJECT

300 BROOK DRIVE

TITLE

PROPOSED SURFACE WATER DRAINAGE LAYOUT FOR PLANNING

DRAWING STATUS

TENDER

STATUS CODE

-

CE PROJECT No.

3113

SCALE @ A1

1:200

DATE CREATED

JUL 25

DRAWN

SS

CHECKED

RW

DRAWING No.

3113-CIV-XX-XX-D-C-30005

REV

P01