


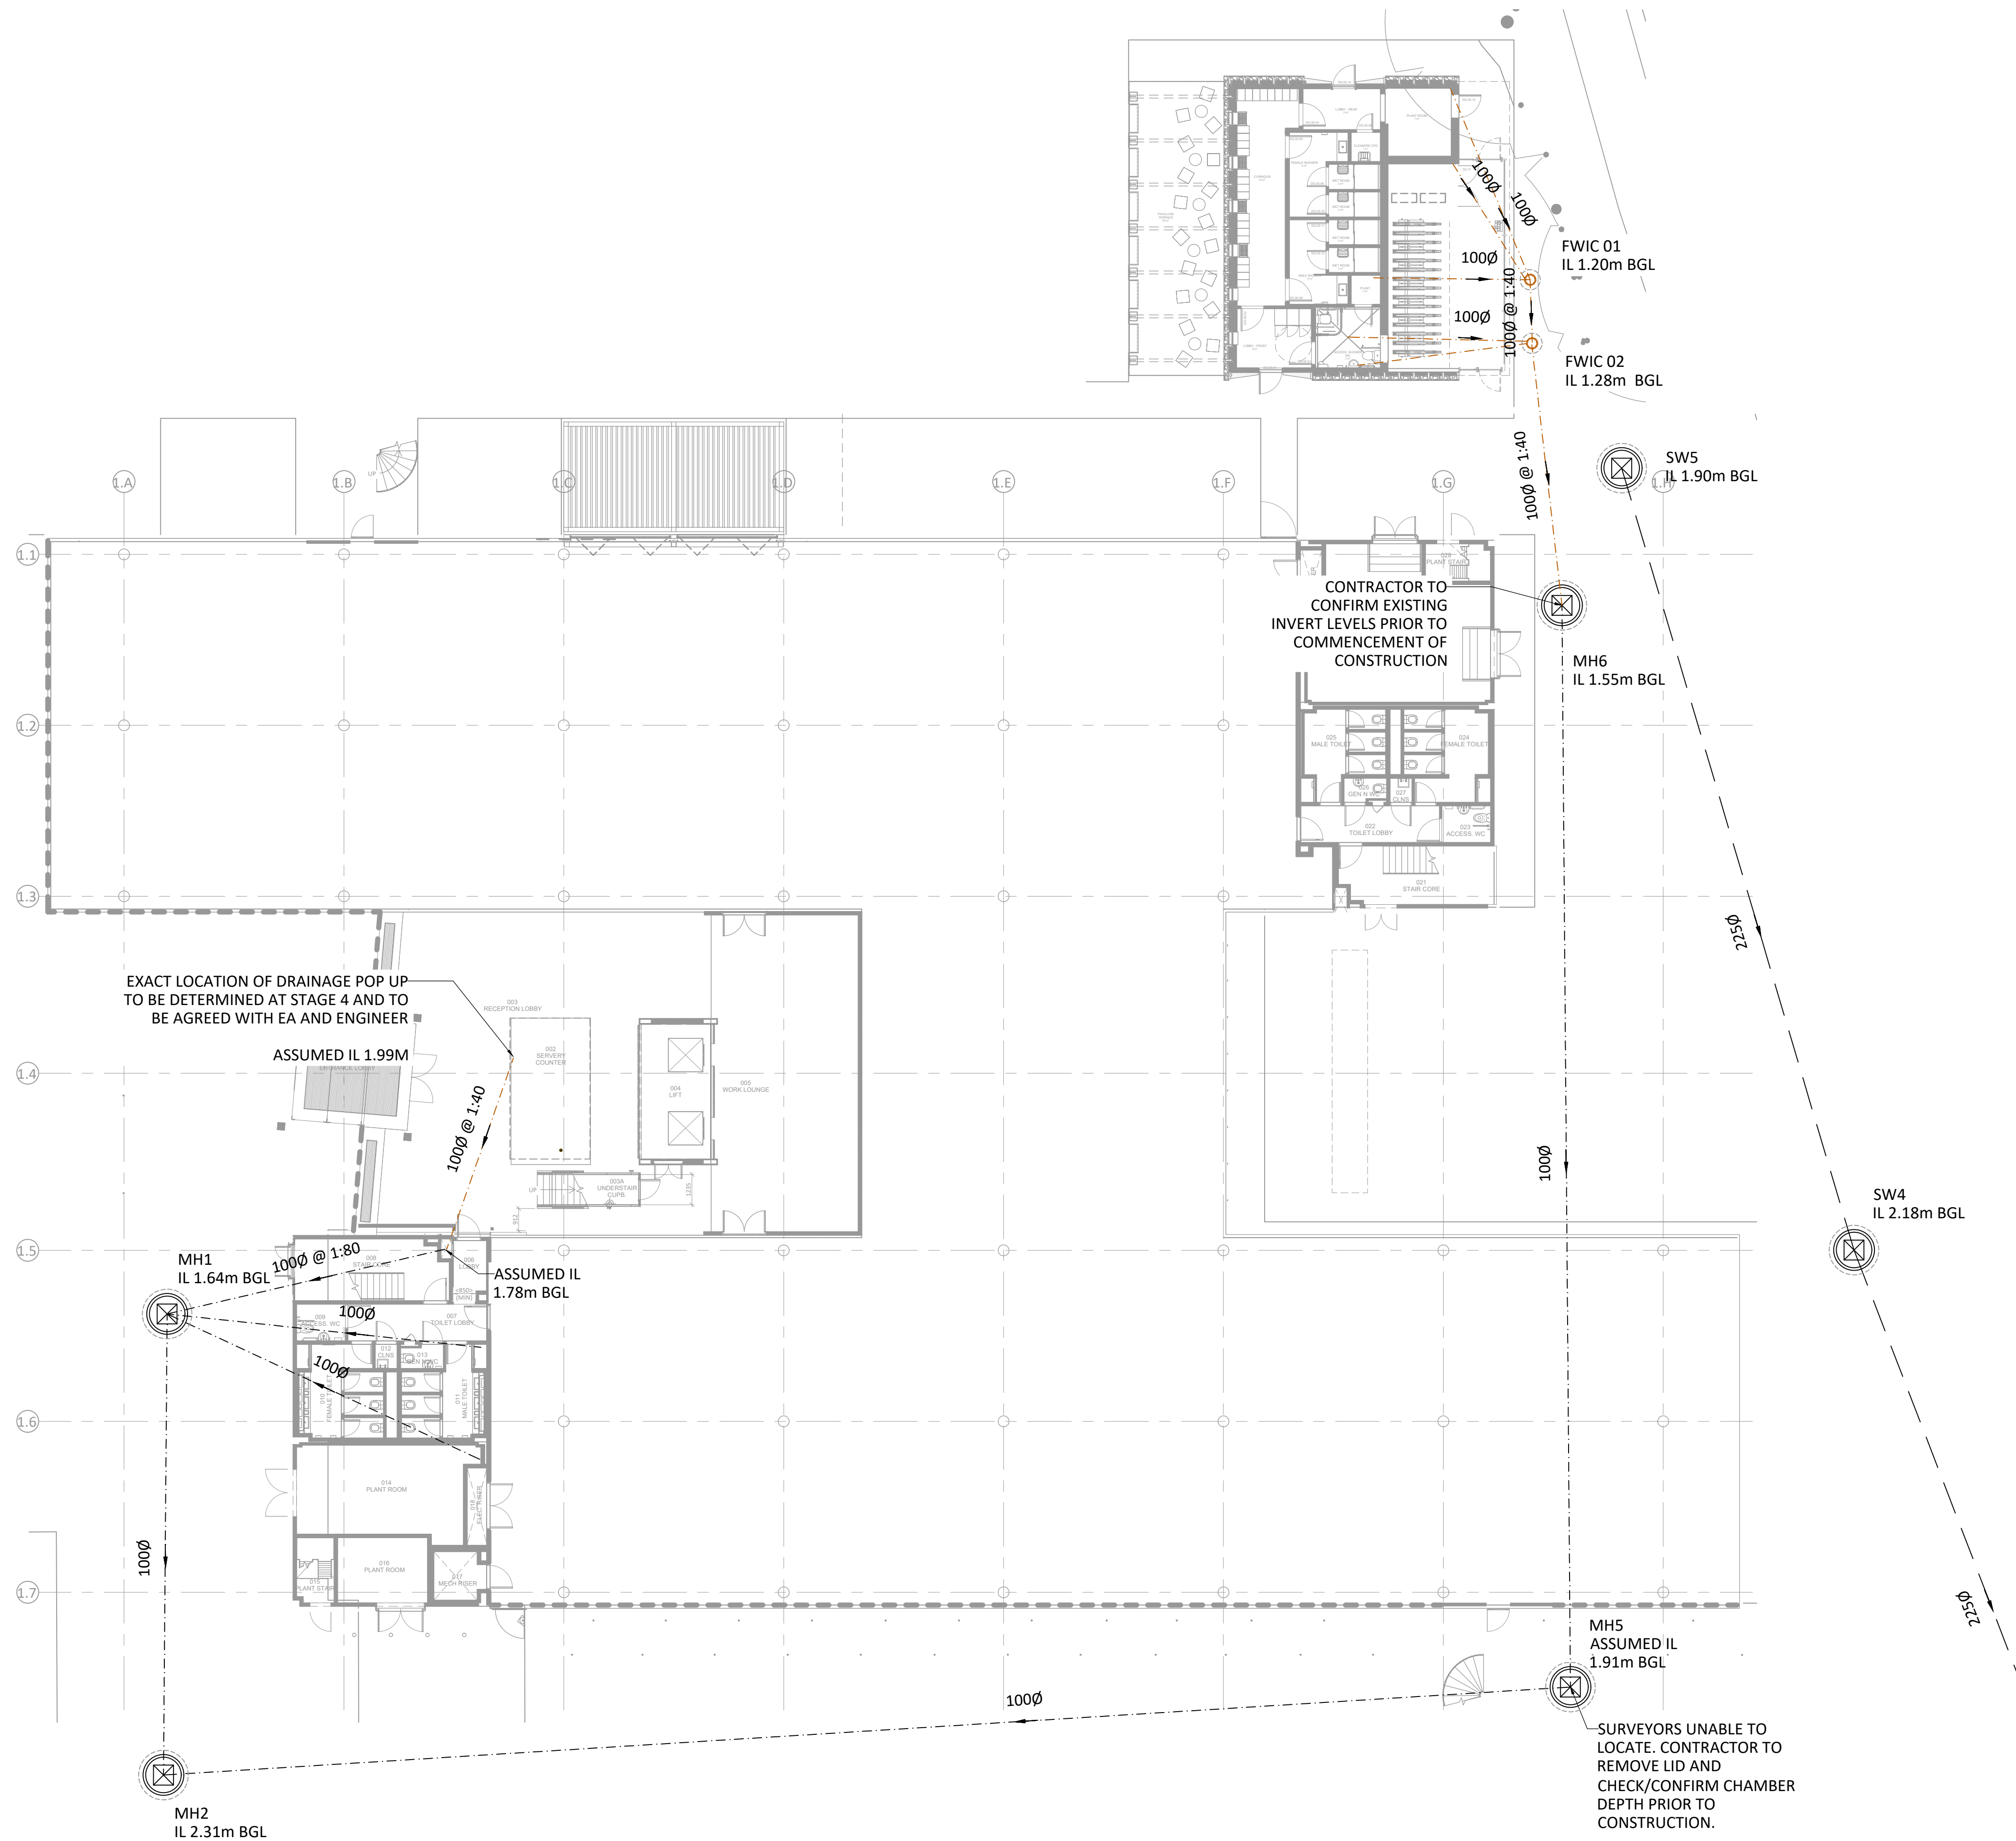

STANDARD NOTES

1. THIS DRAWING IS TO BE READ IN CONJUNCTION WITH ALL RELEVANT ARCHITECT'S AND ENGINEER'S DRAWINGS AND THE SPECIFICATIONS.
2. THIS DRAWING SHOULD NOT BE SCALED.
3. ALL DIMENSIONS ARE TO BE VERIFIED BY THE CONTRACTOR ON SITE.
4. ALL DISCREPANCIES SHOULD BE REPORTED TO C.A./E.A. PRIOR TO THE COMMENCEMENT OF WORKS.

© CIVIC ENGINEERS LIMITED

DRAWING NOTES

- 1: TO BE READ IN CONJUNCTION WITH BELOW
GROUND DRAINAGE DETAIL DRAWING
3113-CIV-XX-XX-D-C-31001 - 31002.
- 2: DESIGN IS BASED ON MURPHY GEOSPATIAL
CCTV REPORT DATED 27/10/2023.
- 3: CONNECTION TO THE PUBLIC SEWER WILL
REQUIRE APPROVAL FROM THAMES WATER.
IT IS THE RESPONSIBILITY OF THE
CONTRACTOR TO ENSURE THE APPROVAL IS
IN PLACE PRIOR TO COMMENCING WORK.

KEY:

- EXISTING FOUL WATER SEWER
- EXISTING SURFACE WATER SEWER
- PROPOSED FOUL WATER SEWER
-  PROPOSED FOUL WATER INSPECTION CHAMBER

04.03.25	P03	ISSUED FOR TENDER	SS	RWI
12.08.24	P02	DESIGN UPDATE	SS	RWI
27.03.24	P01	ISSUED FOR INFORMATION	SS	RWI
DATE	REV	DESCRIPTION	DRAWN	CHKD



MANCHESTER Carver's Warehouse, 77 Dale Street, Manchester, M1 2HG. Tel: 0161 228 6757
LONDON Reeds Wharf, 33 Mill Street, London SE1 2AX. Tel: 020 7253 2977
LEEDS 1 Saw Mill Street, Water Lane, Leeds, LS11 5WE. Tel: 0113 2025 130
GLASGOW 35 Virginia Street, Glasgow, G1 1TN. Tel: 0141 370 1829

www.civiceengineers.com

PROJECT

PROPOSED DRAINAGE LAYOUT

DRAWING STATUS				STATUS CODE	
TENDER				-	
CE PROJECT No.	SCALE @ A1	DATE CREATED	DRAWN	CHECKED	
3113	1:150	MAR 24	SS	RWi	
DRAWING No.				REV	
3113-CIV-XX-XX-D-C-30002				P03	