


0.24	+0.20	+0.20	+0.24	+0.26	+0.36	+0.23	+0.18	+0.18	0.00
------	-------	-------	-------	-------	-------	-------	-------	-------	------

Article Name: KHA 9 C/EW 19 W 840 AN-96 (with 14049720 spill shield)
Item Number: 06063896
Fitting: 1x 06063896 | 840
Luminous Flux: 1357lm
Maintenance Factor: 0.90
Connected Load: 19W
Quantity: 1no. LUMINAIRE

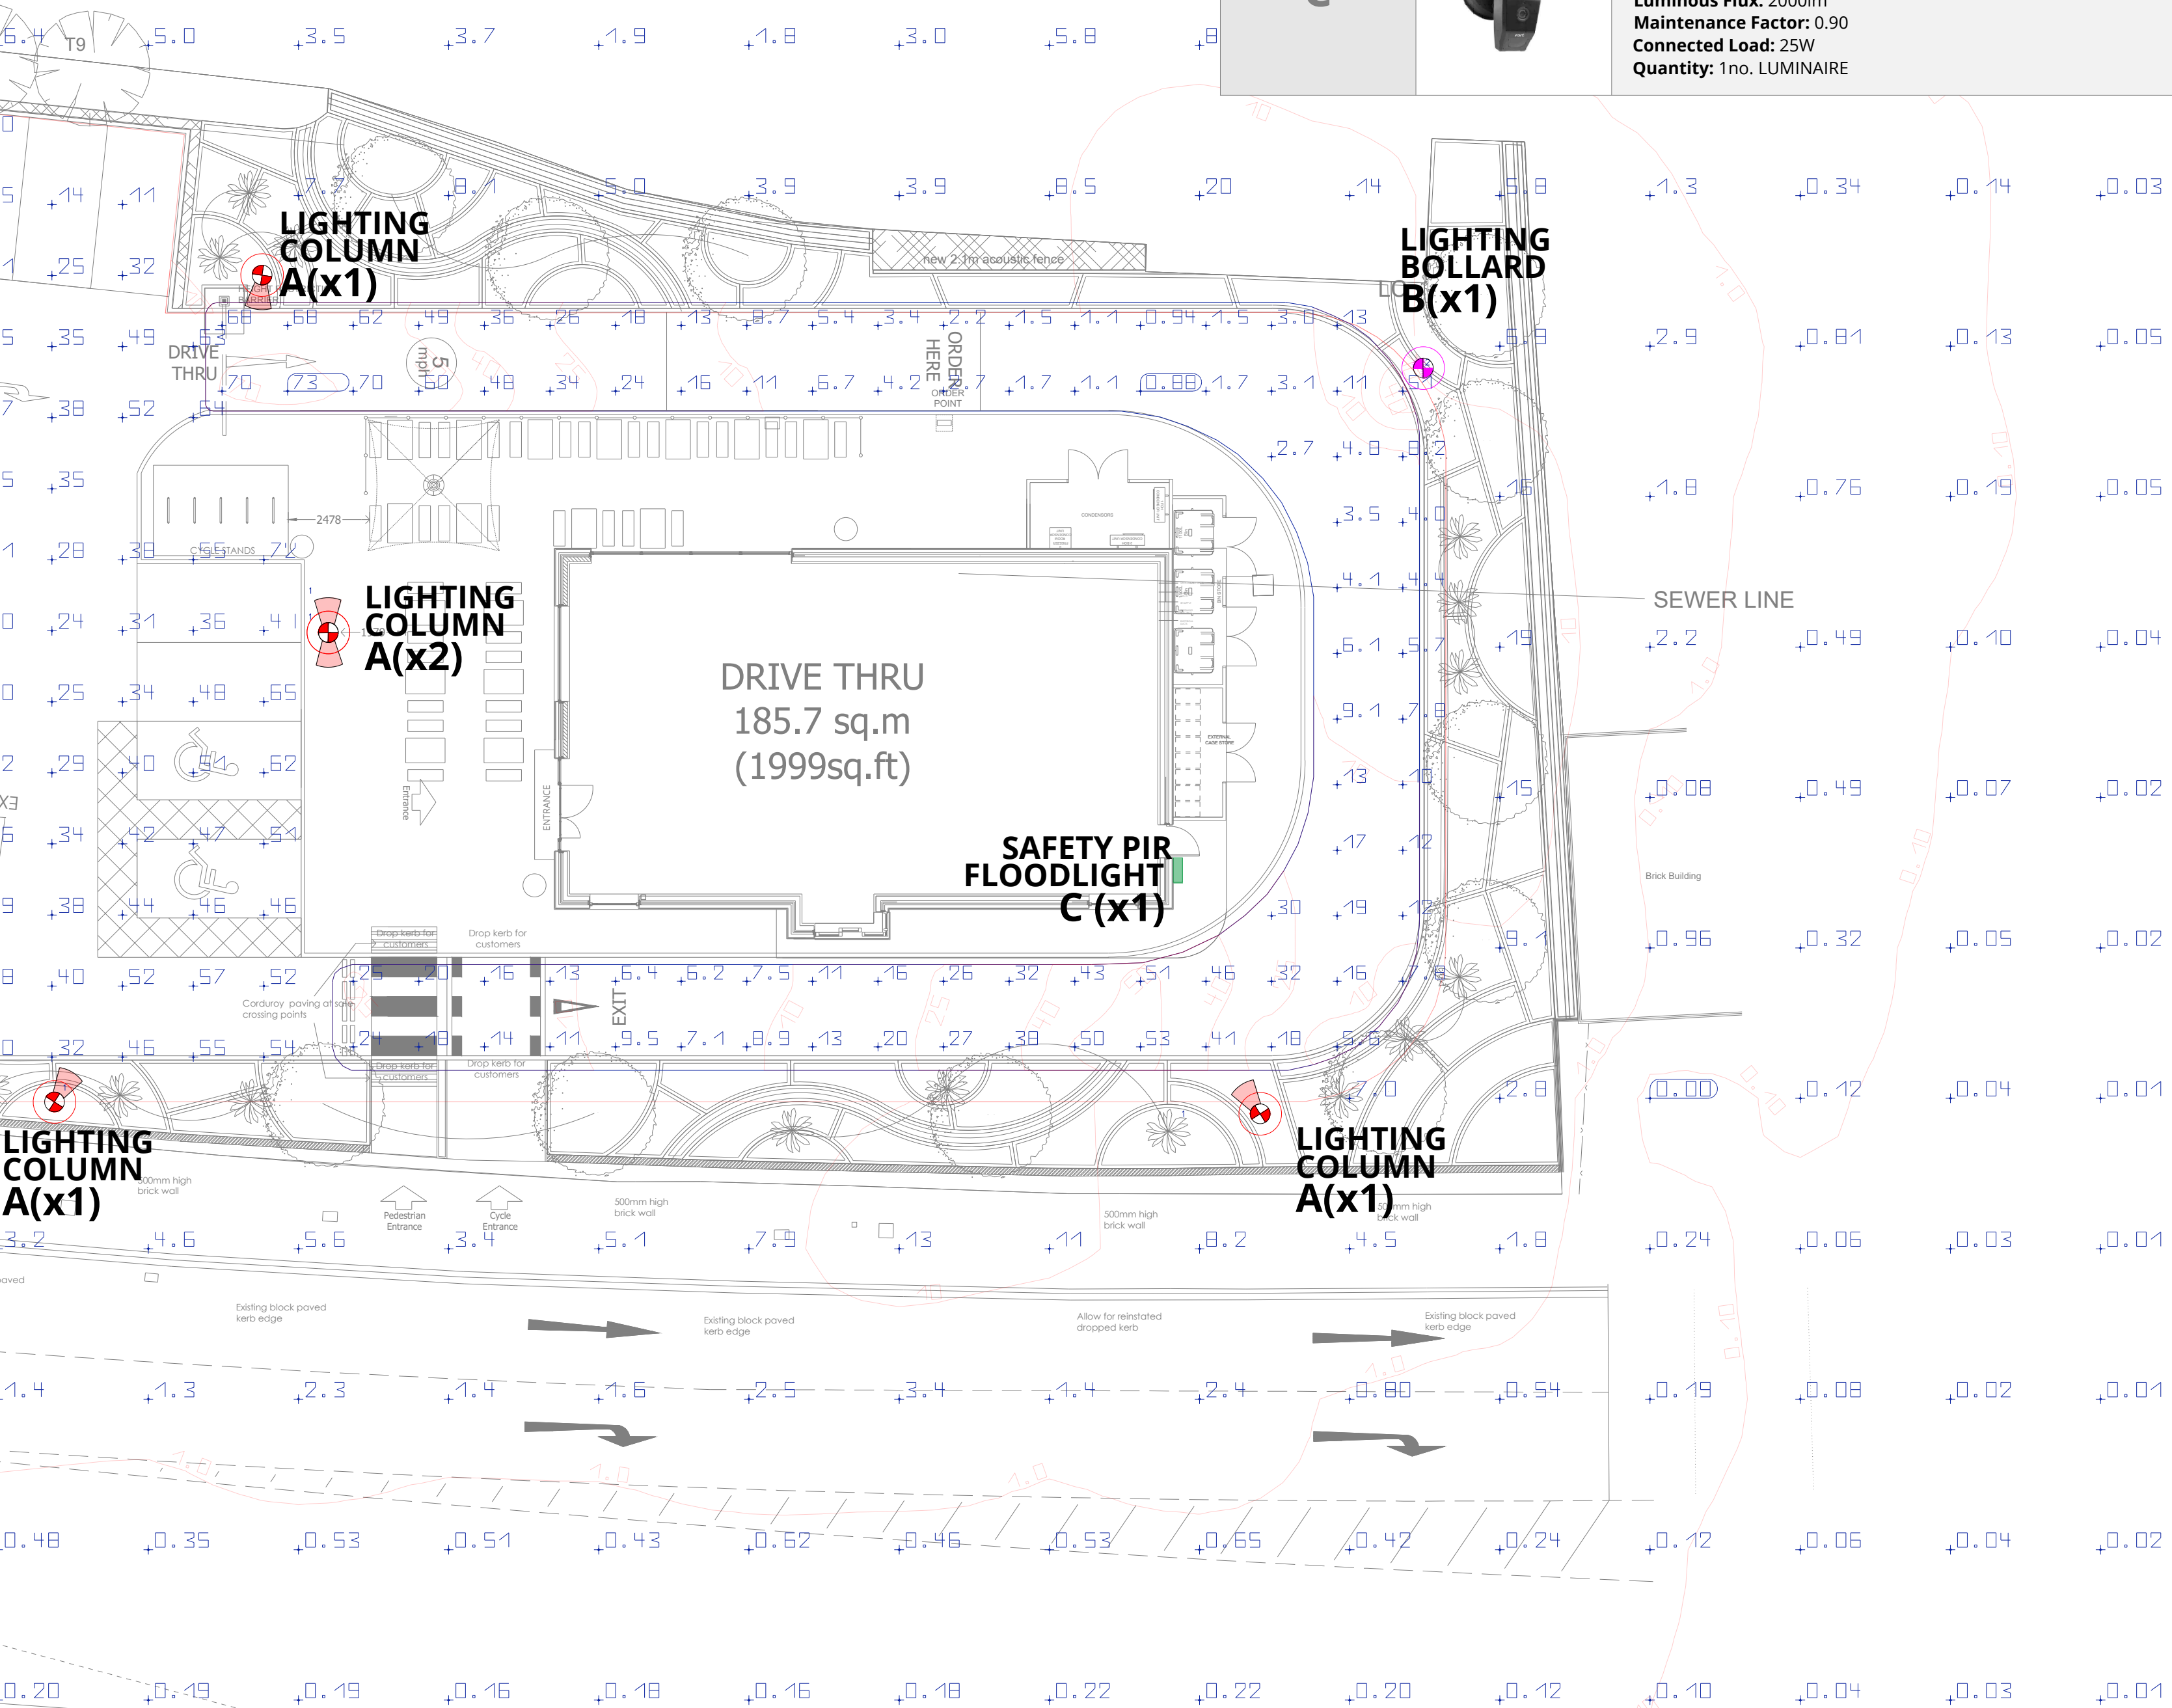

REV	DATE	DRAWN BY	REVISION DESCRIPTION
W	14.02.2024	CP	2136-23W PROPOSED SITE PLAN

UNIT 11 TINWELL BUSINESS PARK, STEADFOLD LANE, TINWELL, STAMFORD PE9 3UN
www.concept-mep.co.uk | info@concept-mep.co.uk | +44 (0) 1780 917167

DRAWN BY SAWA	DATE 25/01/2023	SCALE 1:150	SHEET SIZE A1
CHECKED BY A/JK	DATE 25/01/2023	DRAWING STATUS PRELIMINARY	

PROJECT / DRAWING NUMBER **020-09-E-01** REVISION **P12**

COLLABORATE - INNOVATE - MODERATE