


Do Not Scale.
Use figured dimensions only.

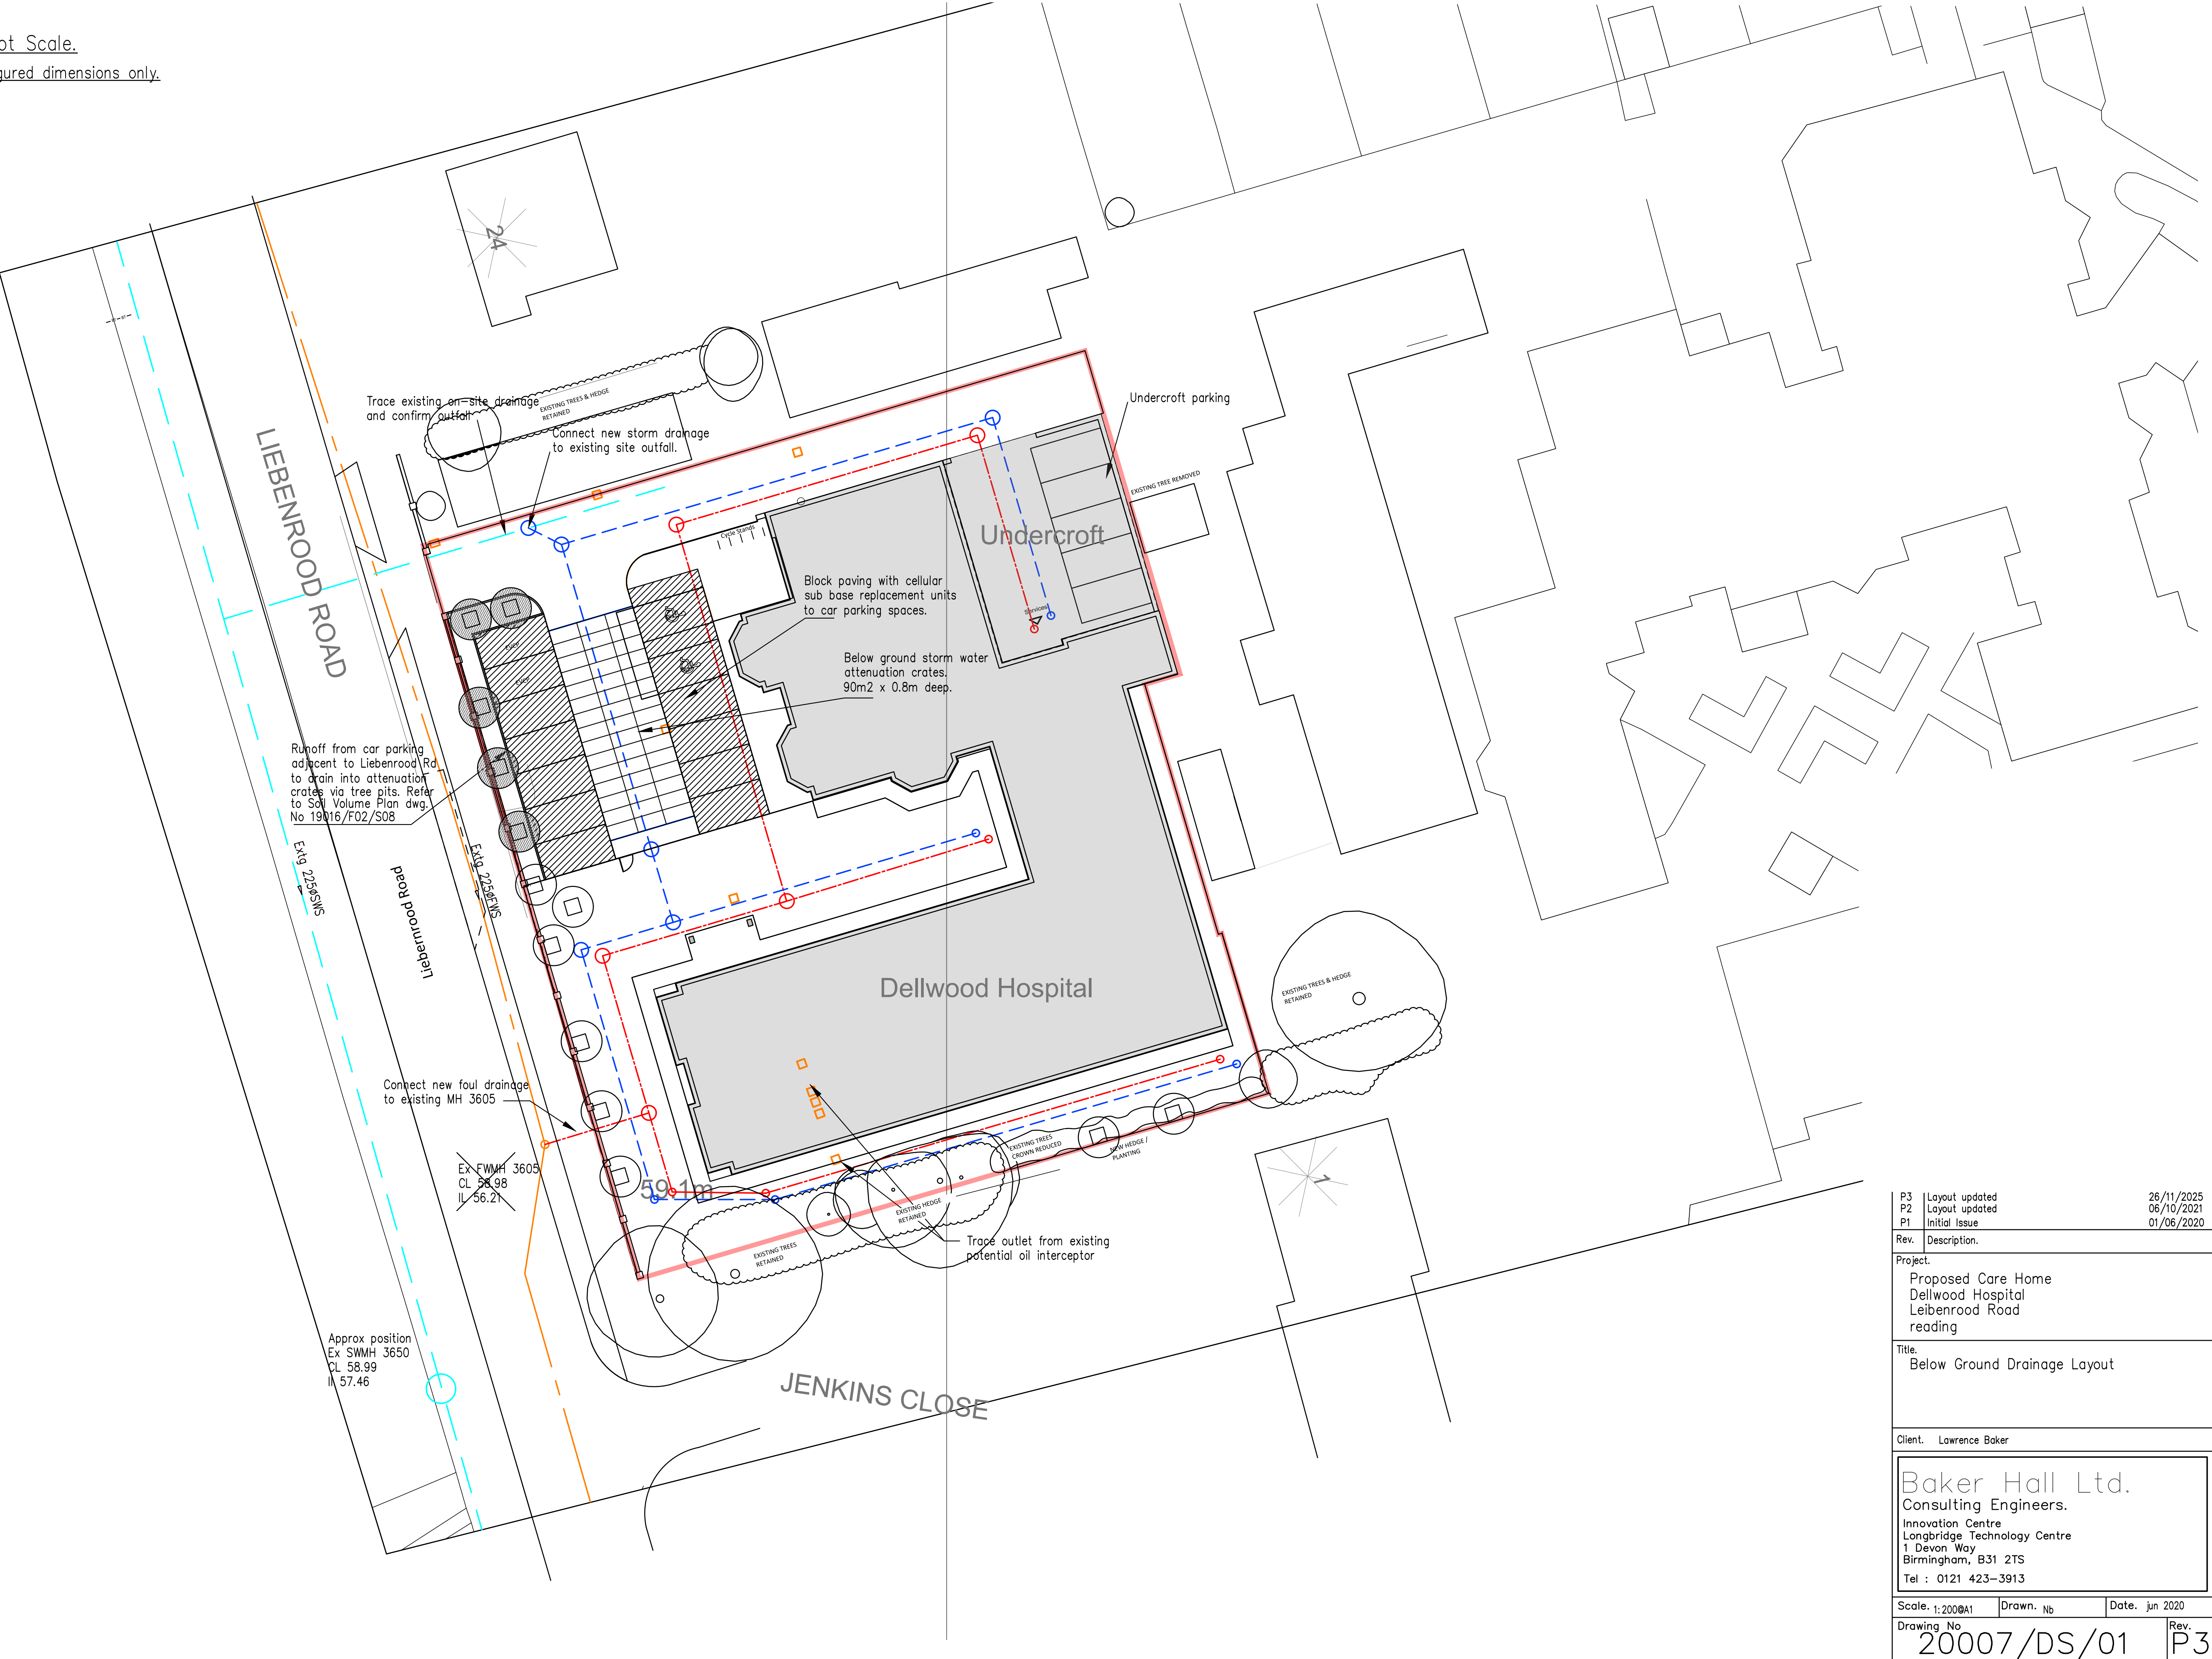

P3	Layout updated	26/11/2025
P2	Layout updated	06/10/2021
P1	Initial Issue	01/06/2020
Rev.	Description.	
Project.		
Proposed Care Home Dellwood Hospital Leibenrood Road reading		
Title.		
Below Ground Drainage Layout		
Client. Lawrence Baker		
Baker Hall Ltd. Consulting Engineers. Innovation Centre Longbridge Technology Centre 1 Devon Way Birmingham, B31 2TS Tel : 0121 423-3913		
Scale. 1:200	Drawn. Nb	Date. jun 2020
Drawing No		Rev.
20007/DS/01		P3