


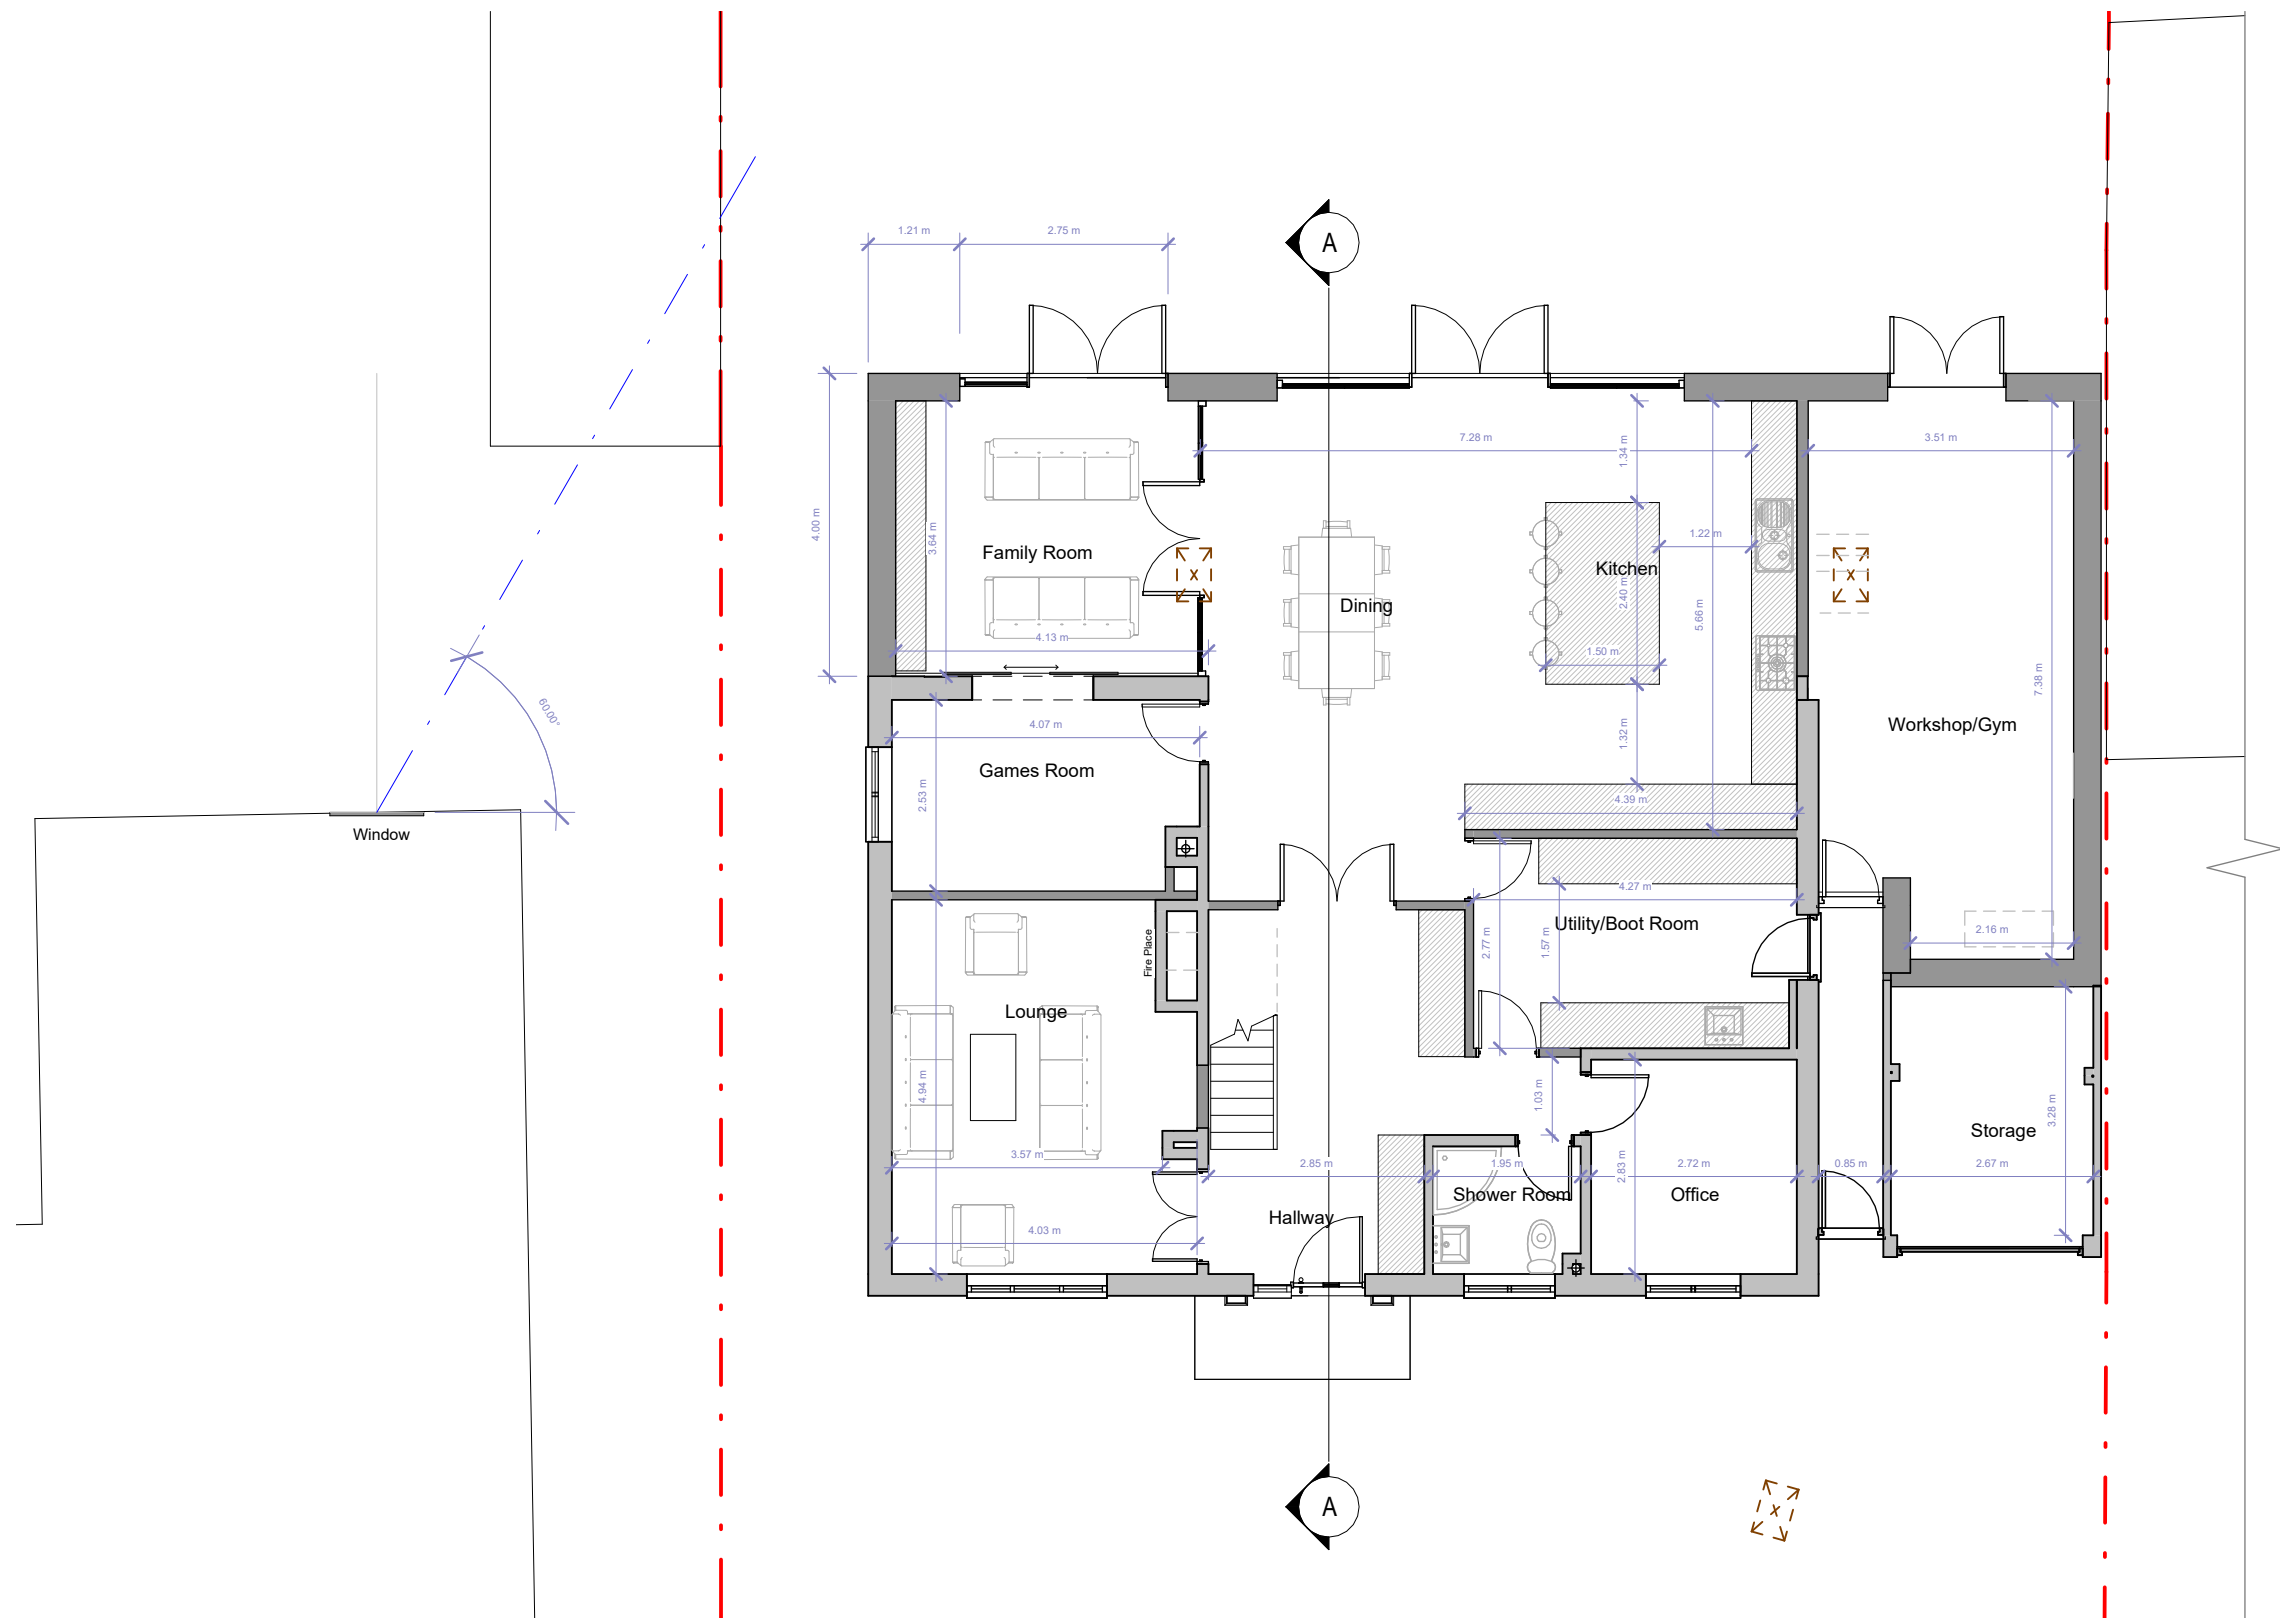

Ground Floor



FLUENT
ARCHITECTURAL DESIGN SERVICES
TEL: 0800 043 8838
E-MAIL: INFO@FLUENT-ADS.CO.UK
WEB: FLUENT-ADS.CO.UK

Twigmoor House Upper Warren Avenue
Reading

Proposed Floor Plans

Scale @ A3
1 : 100

Date
31.07.2025

Drawn by
SZ

 
Drawing number
P.M.500

Project number
2397

Rev
E

Key:

Existing Proposed SVP Boundary line
Existing drainage Proposed drainage Overhead



No.	Description	Date
0	First Draft	
A	Client's comments (2)	10.09.25
B	Drawing amended	17.10.25
C	Drawing amended	21.10.25
D	Drawing amended	26.11.25
E	Revision 9	17.12.25