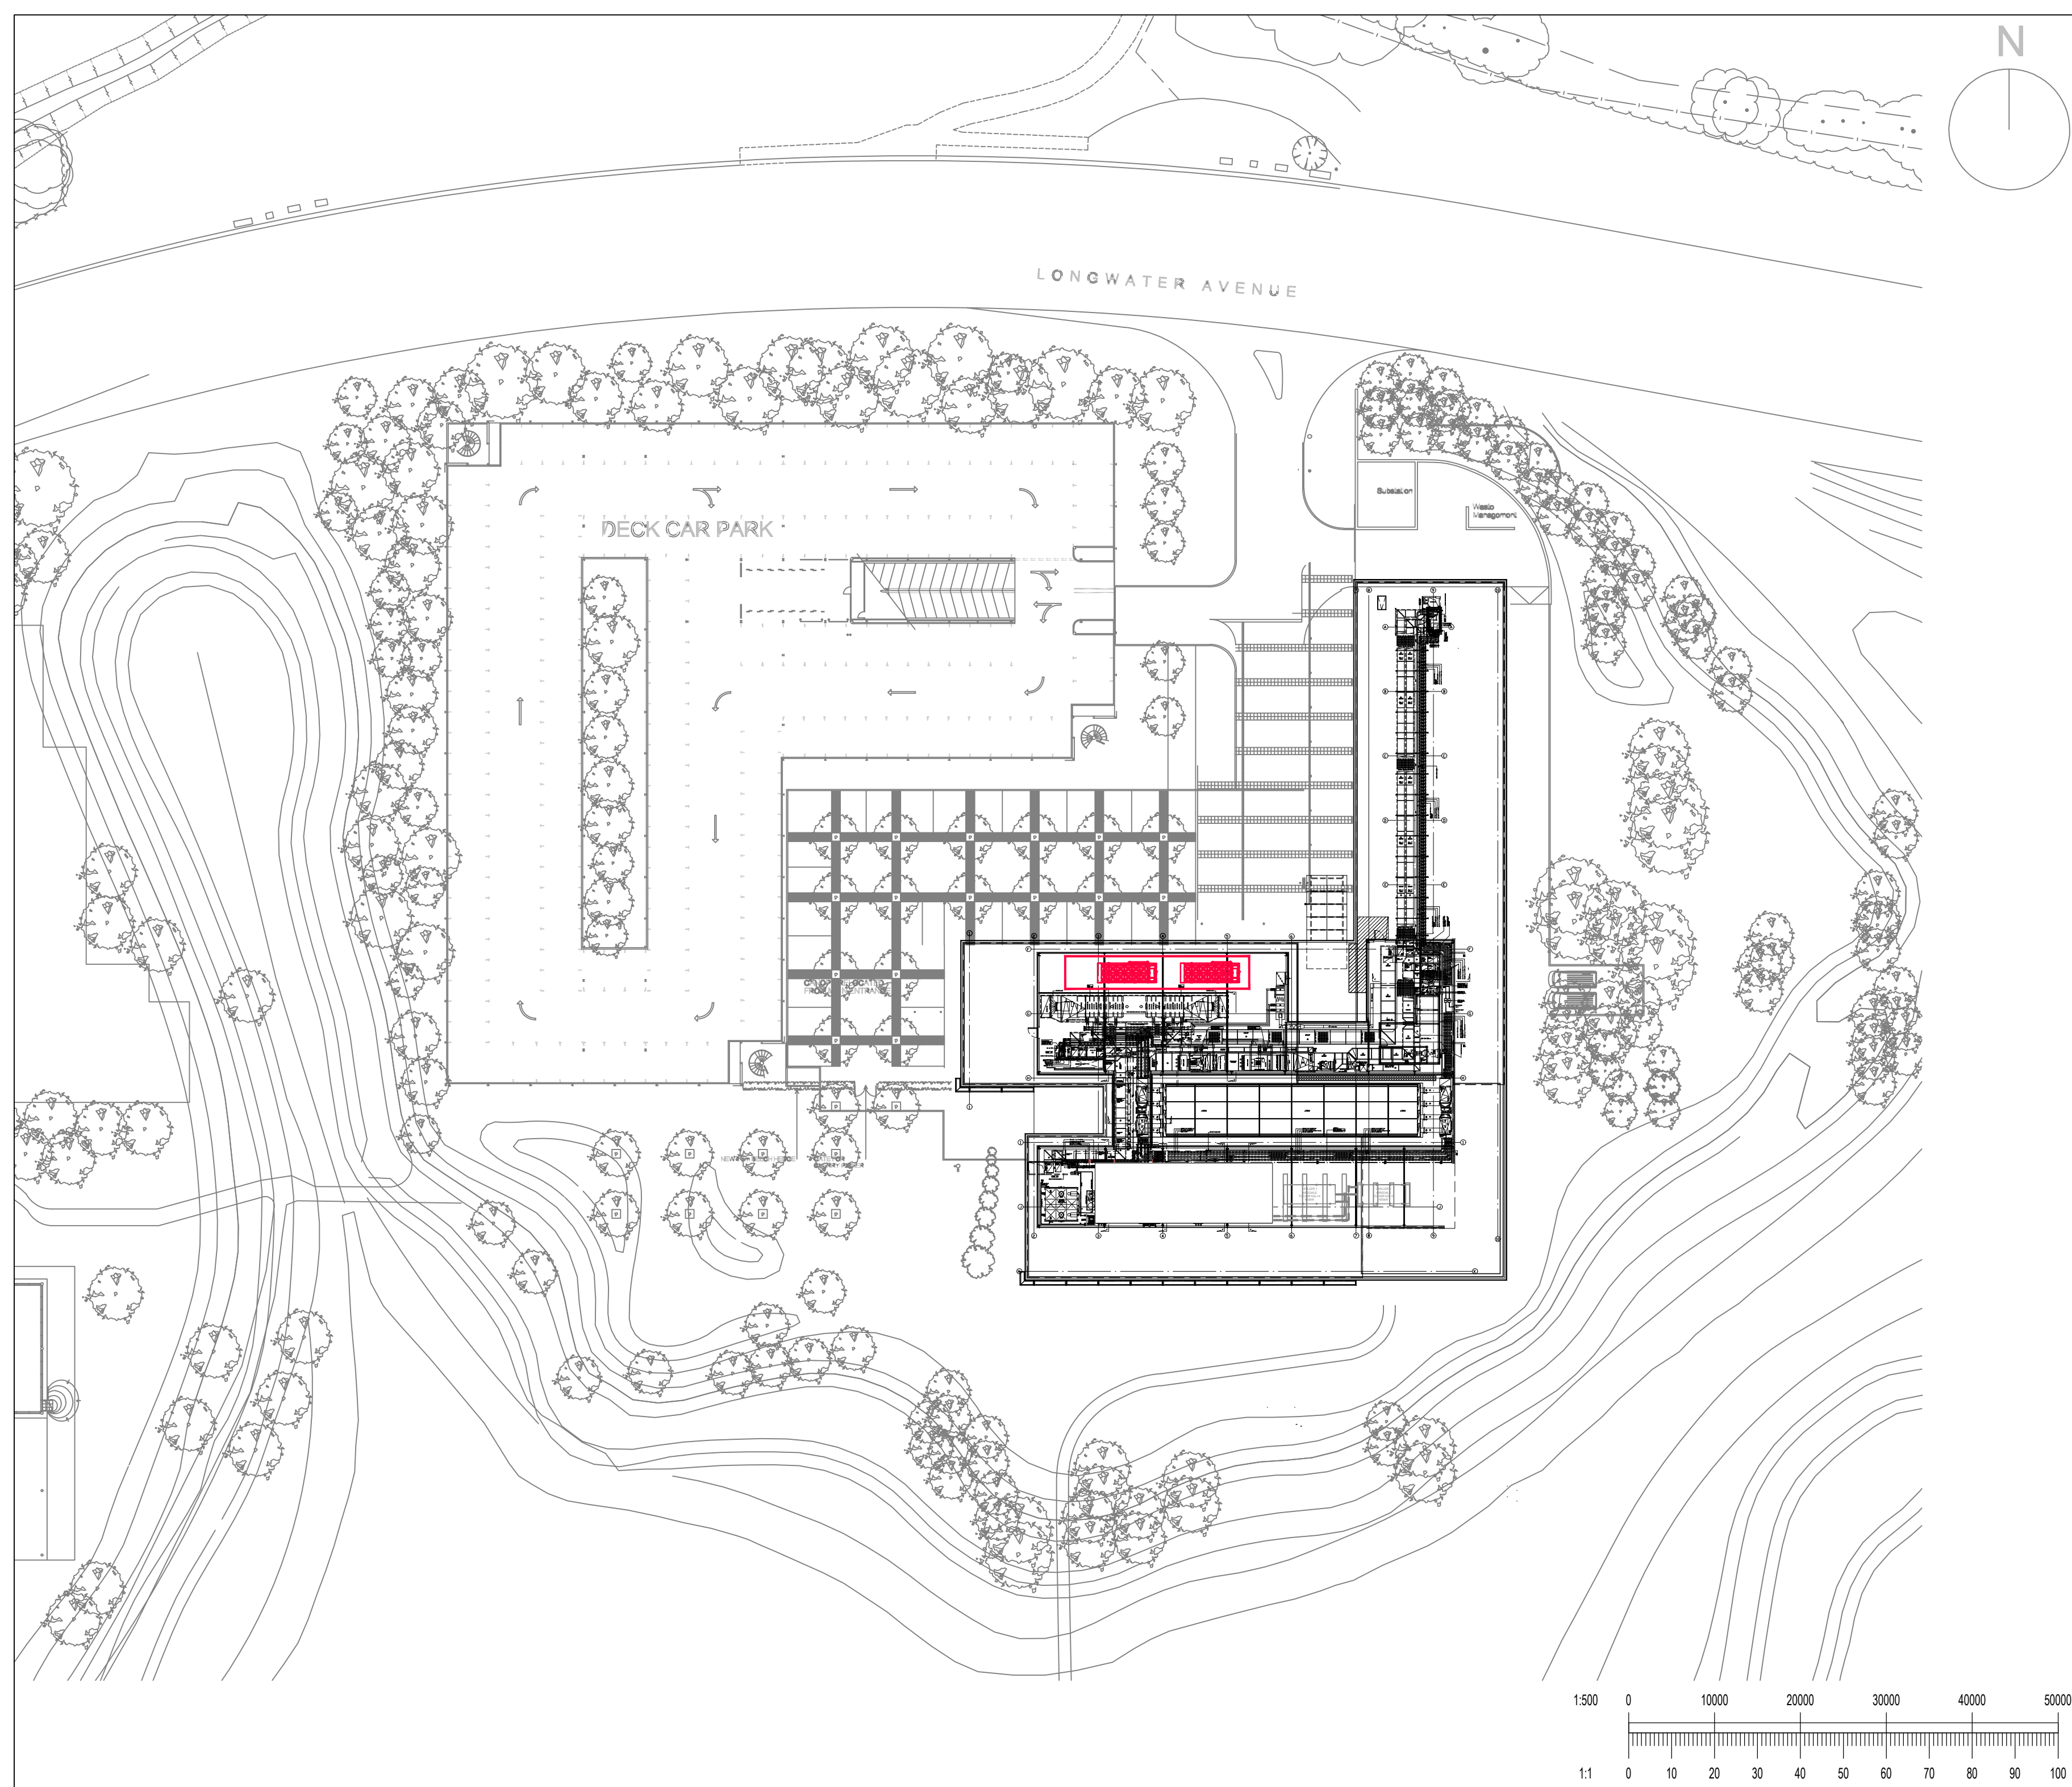


- A. THIS DRAWING IS TO BE READ IN CONJUNCTION WITH ALL RELEVANT ARCHITECTS, STRUCTURAL ENGINEERS AND FURNESS GREEN PARTNERSHIP DRAWINGS AND SPECIFICATION.
B. THE CONTRACTOR SHALL BE RESPONSIBLE FOR THE COORDINATION OF ALL WORK WITH ALL OTHER TRADES.
C. ANY INFORMATION SHOWN ON THIS DRAWING RELATING TO FIRE AND LIFE SAFETY SYSTEMS IS INDICATIVE AND TO BE DEVELOPED AS PART OF THE RELEVANT SPECIALIST CONTRACTORS DETAIL DESIGN.

GENERAL NOTES

Rev	Description	Date
04	ASHP PLANT INDICATED	JAN. '26
03	RED LINE AMENDED TO ALIGN WITH ARCHITECTS LAYOUT	JAN. '26
02	AMENDED TO SUIT PLANNING CONSULTANTS COMMENTS	JAN. '26
01	FURTHER PLANNING UPDATES	DEC. '25
00	ISSUED FOR PLANNING	DEC. '25

Issue Status

PLANNING

Client

MAPLETREE (UK) MANAGEMENT LTD

FURNESS GREEN PARTNERSHIP

BUILDING SERVICES & ENVIRONMENTAL ENGINEERING CONSULTANTS
71 LEONARD STREET (FIRST FLOOR), LONDON, EC2A 4QS
020 3589 3898 www.furnessgreen.com info@furnessgreen.com



Project

100 LONG WATER AVENUE
GREEN PARK - DECARBONISATION

Title

PROPOSED SITE PLAN

Drawn K.C.	Checked G.B.	Date DEC. '25	Scale 1:500@A2
Job No 1136	Dwg No 50-SA-201	Rev 04	